

TULUKSAK, ALASKA

2010-11 WASTEWATER SYSTEM IMPROVEMENTS PHASE I & II



- COMMUNITY HONEYBUCKET DUMPSITE IMPROVEMENTS
- WASTEWATER TREATMENT AND DISPOSAL AREA
- COMMUNITY LIFT STATION
- GRAVITY SEWER AND FORCEMAIN PIPING


Prepared for the Tuluksak Native Community

In Cooperation with the State of Alaska
Department of Environmental Conservation
Village Safe Water Program

ISSUED FOR CONSTRUCTION - REVISED JAN. 2011

SHEET INDEX

No.	Title
G1.1	COVER SHEET
G1.2	GENERAL NOTES, DESIGN CRITERIA AND LEGEND
G1.3	2010 AND 2011 IMPROVEMENT - SHEET INDEX
G1.4	2010 AND 2011 IMPROVEMENT - SHEET INDEX
G1.4	SITE CONTROL
G2.0	HORIZONTAL AND VERTICAL CONTROL
G3.0	TEST HOLE SITE LOCATION MAP
G3.1	TEST HOLE BORING LOGS
G3.2	TEST HOLE BORING LOGS
G3.3	TEST HOLE BORING LOGS
G3.4	TEST HOLE BORING LOGS
G3.5	TEST HOLE BORING LOGS
G3.6	TEST HOLE BORING LOGS
G3.7	TEST HOLE BORING LOGS
G3.8	TEST HOLE BORING LOGS
G3.9	TEST HOLE BORING LOGS
C1.1	S1 GRAVITY SEWER PLAN AND PROFILE
C1.2	S1 GRAVITY SEWER PLAN AND PROFILE
C1.3	S2 GRAVITY SEWER PLAN AND PROFILE
C1.4	S2 GRAVITY SEWER PLAN AND PROFILE
C2.1	FM1 FORCEMAIN PLAN AND PROFILE
C2.2	FM1 FORCEMAIN PLAN AND PROFILE
C2.3	FM1 FORCEMAIN PLAN AND PROFILE
C2.4	FM1 FORCEMAIN PLAN AND PROFILE
C2.5	FM1 FORCEMAIN PLAN AND PROFILE
C2.6	FM1 FORCEMAIN PLAN AND PROFILE
C2.7	FM1 FORCEMAIN PLAN AND PROFILE
C2.8	FM1 FORCEMAIN PLAN AND PROFILE
C2.9	FM2 FORCEMAIN PLAN AND PROFILE
C2.10	FM2 CONNECTION TO SCHOOL UTILITIES
C3.1	LIFT STATION #1 SITE PLAN AND PUMP CURVE
C3.2	LIFT STATION DETAILS
C3.3	LIFT STATION PIPING PLAN AND DETAILS
C3.4	BUILDING SECTION AND DETAILS
C3.5	LIFT STATION LADDER DETAILS
C3.6	LIFT STATION HOIST AND PIPE SUPPORT DETAILS
C4.0	LAGOON SITE PLAN AND DESIGN CRITERIA
C4.1	LAGOON PLAN AND PROFILE
C4.2	LAGOON INLET STRUCTURE DETAILS
C4.3	CELL TRANSFER STRUCTURE AND OVERFLOW CHANNELS
C4.4	TYPICAL CONTROL STRUCTURE DETAILS
C4.5	LAGOON CLOSEOUT
C4.6	SEWER SERVICE PLAN
C5.1	ARCTIC PIPE DETAILS
C5.2	SEWER MAIN AND MANHOLE DETAILS
C5.3	TRENCH AND SEWER CONNECTION DETAILS
C5.4	SEWER SERVICE LINE DETAILS
C5.5	ARCTIC BOX DETAILS
C5.6	ARCTIC BOX DETAILS
M1-1	LIFT STATION MECHANICAL PLAN
M1-2	HYDRONIC PIPING SCHEMATIC
M1-3	POWER PLANT MECHANICAL PLAN
E1.1	ELECTRICAL LEGEND & SCHEDULE
E2.1	ELECTRICAL SITE PLAN
E3.1	ELECTRICAL NEC CLASSIFIED BOUNDARY PLANS
E4.1	ELECTRICAL CELL TRANSFER MANHOLE PLANS
E4.2	ELECTRICAL POWER PLANT PLANS
E5.1	ELECTRICAL LIFT STATION PLANS
E5.2	ELECTRICAL LIFT STATION PLANS
E6.1	ELECTRICAL LIFT STATION DIAGRAMS & PANEL SCHEDULE
E6.2	ELECTRICAL LIFT STATION CONTROLS
E6.3	ELECTRICAL POWER PLANT CONTROLS AND DIAGRAMS
E6.4	ELECTRICAL POWER PLANT CONTROLS AND DIAGRAMS

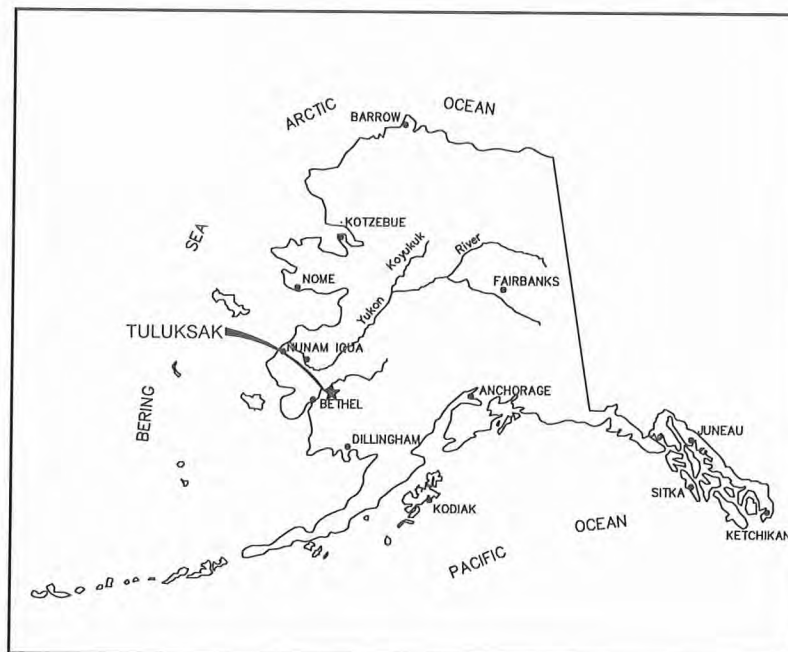

LOCATION MAP

CE₂
ENGINEERS, INC.
PO BOX 222346 ANCHORAGE, AK 99523 PH: 907-349-1010 FAX: 907-349-1015



RECORD DRAWING CERTIFICATE

THESE DRAWINGS REFLECT RECORDED
INFORMATION OBTAINED DURING
CONSTRUCTION.
INFORMATION PROVIDED HEREIN IS
ACCURATE TO THE BEST OF MY
KNOWLEDGE.

NAME

DATE

SCOPE OF THE PROJECT

THIS PLAN SET COVERS PHASE I & II OF THE TULUKSAK WASTEWATER SYSTEM IMPROVEMENTS PROJECT, WHICH, WHEN FULLY IMPLEMENTED, WILL PROVIDE PIPED GRAVITY SEWER, HONEYBUCKET DISPOSAL AND FORCEMAIN SERVICE TO THE ENTIRE COMMUNITY OF TULUKSAK, ALASKA.

PHASE I OF THE PROJECT WILL INCLUDE THE FOLLOWING COMPONENTS:

1. NEW COMMUNITY WASTEWATER TREATMENT AND DISPOSAL AREA.
2. NEW COMMUNITY HONEYBUCKET DUMPSITE AND CLOSE-OUT OF EXISTING.

PHASE II OF THE PROJECT WILL INCLUDE THE FOLLOWING COMPONENTS:

1. NEW COMMUNITY PRIMARY LIFT STATION WITH 3,740 LF OF SEWER FORCEMAIN TO TREATMENT AREA INCLUDING HYDRONIC HEAT TRACE AND WASTE HEAT RECOVERY FROM THE TNC POWER PLANT.
2. 1,350 LF OF BURIED GRAVITY SEWER MAIN PIPING FROM THE COMMUNITY CORE SERVICE AREA TO THE NEW LIFT STATION.
3. 500 LF OF SEWER FORCEMAIN PIPING CONNECTING THE NEW LIFT STATION TO THE EXISTING SCHOOL SEWER FORCEMAIN.
4. 5 EACH SEWER SERVICE LINES TO WASHETERIA FACILITY, CLINIC, CONSTRUCTION CAMP, COMMUNITY CENTER AND STORE.

Project Number (Consultant) _____

VSW Project Manager _____

Construction Foreman _____

Final Design (Date) _____

ADEC Approval (Date) _____

Construction Period (From) _____ (To) _____

As-Builts (Date) _____

G:\ACAD\TULUKSAK\TLT0901 2008 Waste water disposal area\G1.1 GENERAL NOTES LEGEND & DESIGN CRITERIA.dwg, 1/11/2011 12:45:28 PM, Flash, LANIER MP C2050_LD520C PCL 6BLK WHIT.pcl3

GENERAL NOTES

A. GENERAL:

- THE PROJECT SUPERINTENDENT SHALL MAINTAIN A CLEAN SET OF "AS BUILT" RECORD DRAWINGS SHOWING THE LOCATIONS AND SWING TIES TO ALL APPURTENANCES. ALL ELEVATIONS SHALL BE MARKED ASB (AS-BUILT) WITH THE CORRECT VALUE INSERTED. DRAWINGS SHALL BE KEPT CURRENT IN RED PENCIL ON A DAILY BASIS IN A NEAT, LEGIBLE FASHION. COPIES OF THE AS-BUILT DRAWINGS SHALL BE SUBMITTED TO THE TULUKSAK NATIVE COMMUNITY AND VSW UPON COMPLETION OF CONSTRUCTION.
- THE BASIS OF BEARINGS FOR HORIZONTAL CONTROL IS SHOWN ON SHEET G2.0.
- THE BASIS OF VERTICAL CONTROL IS SHOWN ON SHEET G2.0.
- EXISTING UTILITIES ARE SHOWN IN APPROXIMATE LOCATIONS TO THE BEST KNOWLEDGE OF THE ENGINEER AT THE TIME OF DESIGN. RECORDS MAY NOT BE COMPLETELY ACCURATE. THE PROJECT SUPERINTENDENT SHALL VERIFY HORIZONTAL AND VERTICAL LOCATIONS OF UTILITIES WITHIN EACH CONSTRUCTION REACH PRIOR TO BEGINNING WORK.
- THE RECOMMENDED FINISHED FLOOR ELEVATION OF STRUCTURES IS 2.0 FEET ABOVE THE CORPS OF ENGINEERS 100-YEAR FLOOD ELEVATION. FOR THIS PROJECT THE 100-YEAR FLOOD STAGE IS ELEV. 30.3 FEET AND MINIMUM FINISHED FLOOR ELEVATION IS 32.3 FEET.

B. ARCTIC PIPE:

- CARRIER PIPE:
FORCEMAINS SHALL BE 4" AND 6" HDPE, SDR 11. GRAVITY MAINS SHALL BE 8" HDPE, SDR 17. ALL HDPE PIPING SHALL BE LISTED BY THE PPI WITH A DESIGNATION OF PE3408 AND A CELL CLASSIFICATION OF 345434C OR BETTER AS PER ASTM D3350.
- INSULATION:
ARCTIC PIPE INSULATION SHALL BE CLOSED CELL (ASTM D2341 CELL CLASSIFICATION 550674970034) URETHANE FOAM WITH A MAXIMUM K FACTOR OF 0.155 BTU-IN/HR-SF-DEG F. THE INSULATION CORE DENSITY SHALL BE BETWEEN 3.0 AND 4.0 LBS/CF. VOIDS GREATER THAN 0.05 CUBIC INCHES BEYOND 24 INCHES OF EITHER END OF THE PIPE SECTION WILL BE CAUSE FOR REJECTION OF THE PIPE. SEE TECHNICAL SPECIFICATION FOR FURTHER REQUIREMENTS.
- OUTER JACKET MATERIAL:
THE OUTER JACKET MATERIAL FOR ALL ARCTIC PIPE AND FITTINGS SHALL BE 16 GAUGE HELICAL CORRUGATED ALUMINUM PIPE WITH SEAMS THAT WILL WITHSTAND A HYDROSTATIC PRESSURE OF 5 FEET OF WATER WITH NO LEAKAGE.
- HYDRONIC HEAT TRACE:
HYDRONIC HEAT TRACE (WHERE SPECIFIED) SHALL BE A MINIMUM OF 2" DIA. HDPE, SDR 11 AND LISTED BY THE PPI WITH A DESIGNATION OF PE3408 AND A CELL CLASSIFICATION OF 345434C OR BETTER AS PER ASTM D3350.

C. CLEARING AND GRUBBING:

- THE CONSTRUCTION CREW SHALL REMOVE ALL TREES, BRUSH, VEGETATIVE MAT, AND OTHER OBJECTIONABLE MATERIAL WITHIN THE ROAD FOOTPRINT. WHERE DIKE FILL IS TO BE PLACED OVER SOFT, SATURATED TUNDRA, THE GROUND SURFACE MAY BE PREPARED BY CUTTING BRUSH AND TREES WITHIN THE DIKE FOOTPRINT AND GRUBBING AN 8-FOOT WIDE KEYWAY ALONG THE CENTER OF THE DIKE.
- ALL GRUBBED MATERIAL SHALL BE DISPOSED OF IN THE DESIGNATED SPOILS DEPOSITION AREA OR THE BORROW AREA EAST OF THE LAGOON AND WITHIN THE PROJECT PROPERTY. A PORTION OF THE GRUBBED ORGANIC TOPSOIL SHALL BE STOCKPILED AND LATER USED TO COVER AND REVEGETATE THE DIKE SIDESLOPES, BORROW AREA, AND OTHER AREAS DISTURBED BY CONSTRUCTION.

D. EARTHWORK:

- SIDE WALLS OF EXCAVATIONS SHALL BE SLOPED OR SUFFICIENTLY BRACED IN CONFORMANCE WITH SECTION 05.160 OF THE STATE OF ALASKA DEPARTMENT OF LABOR STANDARDS AND THE LATEST FEDERAL OSHA EXCAVATION AND TRENCHING STANDARDS. IF IT IS NECESSARY TO LEAVE AN OPEN EXCAVATION UNATTENDED, THE OPEN EXCAVATION SHALL BE ADEQUATELY SIGNED AND BARRICADED TO WARN RESIDENTS OF THE HAZARD.
- COMPACTION OF STRUCTURAL FOUNDATIONS, PIPE ZONE MATERIALS, EMBANKMENTS AND ROADWAYS SHALL BE ACCOMPLISHED USING A MINIMUM OF THREE (3) PASSES WITH A 15,000 POUND VIBRATORY DRUM COMPACTOR. EMBANKMENT FILL SHALL BE COMPACTED IN MAXIMUM 8"-INCH LIFTS PRIOR TO SUBSEQUENT PLACEMENT OF FILL .SUPERINTENDENT SHALL COORDINATE AN INITIAL EFFORT INSPECTION WITH THE ENGINEER AND VSW TO VERIFY THE ACTUAL COMPACTIVE EFFORT REQUIRED. IF LIGHTER EQUIPMENT IS SUBSTITUTED THE LIFT DEPTH AND NUMBER OF PASSES SHALL BE ADJUSTED TO OBTAIN THE SAME COMPACTIVE EFFORT .
-
- WHERE EXCAVATIONS ENCOUNTER GROUNDWATER, DEWATERING SHALL BE IMPLEMENTED AND TEMPORARY SHORING MAY BE REQUIRED TO STABILIZE THE WALLS WHILE EXCESS WATER IS ALLOWED TO DRAIN OR PUMPED OUT OF THE EXCAVATION.

E. PIPELINE TESTING:

- GENERAL:
ALL TESTING SHALL BE IN CONFORMANCE WITH THE FOLLOWING REQUIREMENTS:
ALL TESTS SHALL BE WITNESSED BY A REPRESENTATIVE DESIGNATED BY THE COMMUNITY. UPON SUCCESSFUL COMPLETION OF A TEST THE RESULTS OF THE TEST SHALL BE DOCUMENTED ON A TEST FORM AND ACKNOWLEDGED BY SIGNATURE OF THE COMMUNITY'S REPRESENTATIVE WITNESSING THE TEST AND BY THE PROJECT SUPERINTENDENT. THE SUPERINTENDENTS RED LINED AS-BUILT DRAWINGS SHALL ALSO NOTE THE TIME AND DATE OF THE TEST, AS WELL AS THE NAME OF THE COMMUNITY'S WITNESS, FOR EACH PIPE SEGMENT TESTED.
- FORCEMAIN TESTING:
PERFORM HYDROSTATIC TESTING OF ALL FORCEMAIN PIPING. FILL THE LINES WITH POTABLE WATER AND REMOVE AIR POCKETS PRIOR TO STARTING THE TEST. PRESSURIZE TO 100 PSI AND LEAVE FOR A MINIMUM OF 1 HOUR. AFTER THIS INITIAL PERIOD, ADD WATER TO BRING THE PRESSURE UP TO 100 PSI AND BEGIN A ONE HOUR TEST. THERE SHALL BE NO LOSS IN PRESSURE DURING THE 1 HOUR TEST FOR THE PIPING TO BE ACCEPTED.
- GRAVITY SEWER MAIN TESTING:
THE CONSTRUCTION CREW SHALL CLEAN AND FLUSH ALL SANITARY SEWER MAINS PRIOR TO VISUAL INSPECTION (LAMPING) AND PRESSURE TESTING.
EACH REACH OF SEWER MAIN SHALL BE LAMPED, MANHOLE TO MANHOLE, WITH A HIGH INTENSITY LIGHT AND LARGE MIRROR. SEGMENTS NOT LAMPING TO 7/8 OF A FULL MOON SHALL BE REALIGNED AND/OR REGRADED AS NECESSARY TO MEET THE 7/8 MOON REQUIREMENT.
ALL SEGMENTS OF COMPLETED SEWER MAIN AND OUTFALL SHALL BE PRESSURE TESTED FROM MANHOLE TO MANHOLE OR TERMINUS TO TERMINUS WITH AIR AT THE END OF CONSTRUCTION (PRIOR TO CONNECTING SEWER SERVICE LINES). AIR SHALL BE SLOWLY SUPPLIED TO THE PLUGGED PIPE INSTALLATION UNTIL THE INTERNAL AIR PRESSURE REACHES 4.0 POUNDS PER SQUARE INCH (PSI) GREATER THAN THE AVERAGE BACK PRESSURE OF ANY GROUNDWATER THAT MAY SUBMERGE THE PIPE. AT LEAST TWO (2) MINUTES SHALL BE ALLOWED FOR TEMPERATURE STABILIZATION BEFORE PROCEEDING WITH THE TEST. AT THE END OF THE STABILIZATION PERIOD THE AIR PRESSURE SHALL BE ADJUSTED TO THE TEST PRESSURE AND THE 10 MINUTE TEST PERIOD SHALL BEGIN. THE MAXIMUM ALLOWABLE PRESSURE DROP FOR ANY SEWER MAIN SEGMENT DURING THE 10 MINUTE TEST PERIOD SHALL BE 2.7 PSI.
- SEWER MANHOLE TESTING :

F. REVEGETATION SPECIFICATION:

- THE ENTIRE AREA DISTURBED BY CONSTRUCTION SHALL BE REVEGETATED AS QUICKLY AS GOOD CONSTRUCTION PRACTICE ALLOWS. AREAS TO BE REVEGETATED SHALL FIRST BE COVERED WITH A MINIMUM 6-INCH LAYER OF FRIABLE, LOOSELY PLACED TOPSOIL, FREE OF DEBRIS. THE FOLLOWING SEED MIXTURE AND FERTILIZER APPLICATION RATES SHALL BE APPLIED:

SEED	NAME/TYPE	RATE	METHOD
Red Fescue	Arctic Red	14 lbs/acre	Broadcast
Bering Hairgrass	Norcoast	16 lbs/acre	Broadcast
Rye Grass	Annual	2 lbs/acre	Broadcast
FERTILIZER	20-20-20	180 lbs/acre	Broadcast
- EROSION CONTROL FABRIC:
USE BIODEGRADABLE JUTE MESH WITH A LIFE OF 1-2 YEARS. INSTALL ON SLOPES AFTER SEEDING AND ANCHOR SECURELY WITH GROUND STAPLES.

G. HONEY BUCKET DUMPSITE CLOSURE

- THE DUMPSITE CLOSURE WILL OCCUR ONCE THE NEW LAGOON IS OPERATIONAL.

PROJECT DESCRIPTION

THIS PROJECT CONSTRUCTS A TWO-CELL FACULTATIVE PERCOLATION LAGOON, A LIFT STATION, AND A SEWAGE FORCE MAIN BETWEEN THE LAGOON AND LIFT STATION.

THE LAGOON SYSTEM WILL PROVIDE WASTEWATER TREATMENT OF DOMESTIC WASTEWATER. TREATMENT INVOLVES A COMBINATION OF PROCESSES THAT REMOVE SOLIDS, BIODEGRADABLE ORGANICS, AND PATHOGENS FROM THE WATER PRIOR TO ITS RELEASE INTO THE PERCOLATION CELL.

THE FIRST CELL WILL RECEIVE RAW WASTEWATER VIA A 3,740± FT. FORCE MAIN FROM A LIFT STATION LOCATED WITHIN THE VILLAGE. CELL 1 IS DESIGNED TO PROVIDE A QUIESCENT ZONE FOR DIGESTION OF ORGANIC MATTER AND BIODEGRADABLE CONTAMINANTS BY BOTH AEROBIC AND ANAEROBIC MICROBES AND STORAGE FOR NON-DIGESTABLE SOLIDS. A MAX. LOADING RATE OF 38#/ACRE-DAY. CELL 1 IS HYDRAULICALLY CONNECTED TO CELL 2 WITH AN INTERCONNECTING DUAL PIPE CONTROL STRUCTURE DESIGNED TO MAINTAIN A LIQUID DEPTH OF NO MORE THAN 7.0 FEET IN CELL 1. CELL 2 IS DESIGNED TO PERCOLATE WITH A MAXIMUM HYDRAULIC APPLICATION RATE OF 0.9 GAL/SF-DAY.

WORK SUMMARY

CONSTRUCT A DUAL-CELL, LINED WASTEWATER TREATMENT LAGOON AND ASSOCIATED HYDRAULIC CONTROL FEATURES.

INSTALL APPROXIMATELY 5,091 LF OF FORCEMAIN AND GRAVITY SEWER MAIN FROM THE CORE PART OF THE COMMUNITY TO THE PROPOSED FACULTATIVE LAGOON SITE.

INSTALL A CENTRAL COMMUNITY LIFT STATION AND HONEYBUCKET DUMPING FACILITY.

INSTALL A HYDRONIC HEAT TRACE AND WASTE HEAT RECOVER SYSTEM TO PROVIDE FREEZE PROTECTION OF THE LAGOON FORCEMAIN AND HONEYBUCKET DUMPING STATION.

CONSTRUCTION SCHEDULE

MOST OF THE THE LAGOON SITE SOILS ARE COMPOSED PRIMARILY OF ORGANIC SILT OVERBURDEN AND FINE SAND. A SUCCESSFUL PROJECT WILL REQUIRE CAREFUL PLANNING TO SEQUENCE THE WORK IN A MANNER THAT BEST UTILIZES LOCAL SOILS AND SOIL CONDITIONS. THE ANTICIPATED CONSTRUCTION SEQUENCING/SCHEDULING IS AS FOLLOWS.

SUMMER 2010. AFTER SPRING HIGH WATER, BEGIN CONSTRUCTION OF LAGOON DIKES, LEVEL CONTROL STRUCTURES AND APPURTENANCES. SHAPE ACCESS ROADS AND DIKES TO PREPARE FOR LAGOON LINER.

2011 CONSTRUCTION SEASON. INSTALL GRAVITY AND FORCE MAINS AND HEAT RECOVERY SYSTEM. CONSTRUCT LIFT STATION, CONSTRUCT FENCE AND INSTALL SIGNAGE. PROVIDE STARTUP SERVICES. RE-VEGETATE ALL DISTURBED AREAS. CONNECT TO THE EXISTING WASHETERIA AND SCHOOL WASTEWATER DISPOSAL SYSTEMS AND COMMISSION NEW SYSTEM COMPONENTS.

SYSTEM STARTUP

LIFT STATION STARTUP

AFTER INSTALLATION OF ALL NEW LIFT STATION EQUIPMENT, THE PROJECT SUPERINTENDENT SHALL START AND FIELD TEST EACH PUMP UNIT TO DEMONSTRATE ITS ABILITY TO PUMP WITHOUT EXCESSIVE VIBRATION, MOTOR OVERLOADING OR OVERHEATING. EACH PUMP SHALL BE OPERATED FOR A SUFFICIENT PERIOD OF TIME TO PERMIT THOROUGH OBSERVATION OF ALL PUMP COMPONENTS. THE PROJECT SUPERINTENDENT SHALL VERIFY THE PROPER SEQUENCING AND OPERATION OF ALL CONTROLS.

AFTER THE LIFT STATION INSTALLATION IS COMPLETE BUT PRIOR TO DRAWING WASTEWATER INTO THE WET WELL, THE SUPERINTENDENT SHALL DETERMINE THE DISCHARGE RATE OF EACH OF THE SUBMERSIBLE WASTEWATER PUMPS, INDEPENDENTLY AND IN TANDEM. THESE MEASUREMENTS SHALL BE RECORDED ON THE RECORD DRAWINGS FOR FUTURE REFERENCE.

THE DISCHARGE PUMPING RATE SHALL BE DETERMINED BY MEASURING DRAWDOWN OF POTABLE WATER PLACED IN THE WET WELL. ALL LIFT STATION TESTING SHALL BE PERFORMED WITH POTABLE WATER.

LAGOON STARTUP

SAMPLING WELLS SHOULD BE USED TO DETERMINE THE INITIAL NITRATE LEVELS PRIOR TO USE OF THE LAGOON SYSTEM.

STORM WATER MANAGEMENT PLAN


CONSTRUCTION SHALL BE PLANNED AND EXECUTED TO EXPEDITIOUSLY COMPLETE THE PROJECT WHILE MAINTAINING THE CONSTRUCTION SITE IN A MANNER THAT REDUCES THE POTENTIAL FOR CONTAMINATED STORM RUNOFF. SPECIFIC STEPS ARE TO INCLUDE THE FOLLOWING:

- PRIOR TO CONSTRUCTION DEVELOP A STORMWATER POLLUTION PREVENTION PLAN (SWPPP), WHICH UTILIZES THE BEST MANAGEMENT PRACTICES (BMPs) AND IS IN COMPLIANCE WITH THE NATIONAL POLLUTANT DISCHARGE ELIMINATION SYSTEM (NPDES) AND THE ALASKA CONSTRUCTION GENERAL PERMIT NO. AKR10000. THIS PLAN MUST BE APPROVED BY THE STATE OF ALASKA ADEC.
- FILE A NOTICE OF INTENT (NOI) WITH THE EPA A MINIMUM OF 7-DAYS PRIOR TO THE START OF CONSTRUCTION.
- CONSTRUCTOR SHALL BE VIGILANT WITH IMPLEMENTATION OF THE PLAN.

LEGEND

EXISTING		PROPOSED		DESCRIPTION
PLAN VIEW	PROFILE VIEW	PLAN VIEW	PROFILE VIEW	
				GROUND SURFACE
				DRAINAGE/WATER FEATURE
				SEWER FORCE MAIN, LIFT STATION , REDUCER, AND DOUBLE WYE CLEANOUT
				SEWER SERVICE LINE
				CULVERT
				BURIED ELECTRICAL LINE
				BURIED FUEL OIL LINE
				BURIED TELEPHONE LINE
				OVERHEAD ELECTRIC
				EASEMENT
				UTILITY POLE
				FENCE
				ROADS AND TRAVELED WAYS
				CONTOUR LINE
				R.O.W. (RIGHT- OF- WAY)
				SHORELINE
				TREES AND /OR BRUSH
				STRUCTURE
				GROUND PROFILE
				DIRECTION OF DRAINAGE
				PROPERTY LINE
				SECTION LINE
				BLM BRASS CAPPED MONUMENT
				BENCHMARK
				SPOT ELEVATION
				REBAR - ABILITY SURVEY POINT NO.
				YELLOW PLASTIC CAP (REBAR)
				TRACT NUMBER
				LOT NUMBER
				HEAT TRACE POWER SUPPLY

SECTION AND DETAIL DESIGNATIONS

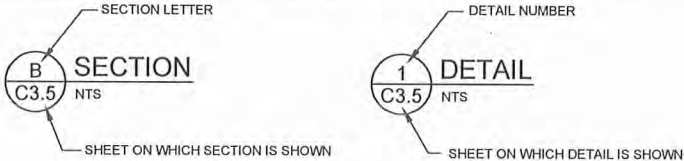

MATERIAL QUANTITIES

ITEM	ESTIMATED QUANTITY
LAGOON OVERBURDEN	7,500 CU. YDS.
LAGOON CUT/FILL VOLUME	40,000 CU. YDS.
6" ARCTIC FORCEMAIN	3,740 L.F.
4" ARCTIC FORCEMAIN	511 L.F.
8" ARCTIC SEWER MAIN	1,351 L.F.
FORCEMAIN CLEAN OUT ASSEMBLY	8 EACH

ABBREVIATIONS

A.P.	ANGLE POINT (HORIZONTAL)
CMP	CORRUGATED METAL PIPE
C.O.E.	CORPS OF ENGINEERS
CULV.	CULVERT
FF	FINISHED FLOOR ELEVATION
G.B.	GRADE BREAK (VERTICAL)
G.V.	GATE VALVE
HDPE	HIGH DENSITY POLYETHYLENE PIPE
INV.	INVERT
IPS	IRON PIPE SIZE (INDUSTRY STANDARD OUTSIDE PIPE DIAMETER)
LF	LINEAR FEET
MFR	MANUFACTURER
MH	MANHOLE
SDR	SIDE DIMENSION RATIO
SHT.	SHEET
SS	STAINLESS STEEL
STA.	STATION
TOJ	TOP OF PIPE JACKET
V.B.	VALVE BOX
WS	WATER SURFACE

RECORD DRAWING CERTIFICATE
THESE DRAWINGS REFLECT RECORDED INFORMATION OBTAINED DURING CONSTRUCTION. INFORMATION PROVIDED HEREIN IS ACCURATE TO THE BEST OF MY KNOWLEDGE.

SCALE:
AS SHOWN
1" = 100'-0"
IF NOT ONE INCH ON SCALE, ACCORDINGLY



2010-11 WASTEWATER SYSTEM IMPROVEMENTS
GENERAL NOTES, DESIGN CRITERIA AND LEGEND
TULUKSAK, ALASKA




REVISION	BY	DATE

Project No.	Date	Designed	Drawn	Approved
	JUNE 2009	LAP	DDR	LAP

Sheet No.
G1.1

G:\ACAD\TULUKSAK\T\T0901 2008 Waste water disposal area\G1.2 - G1.3 SHEET INDEX.dwg, 1/11/2011 1:22:11 PM, cmerz, LANIER MP C2050_LDS20C PCL 6.pc3

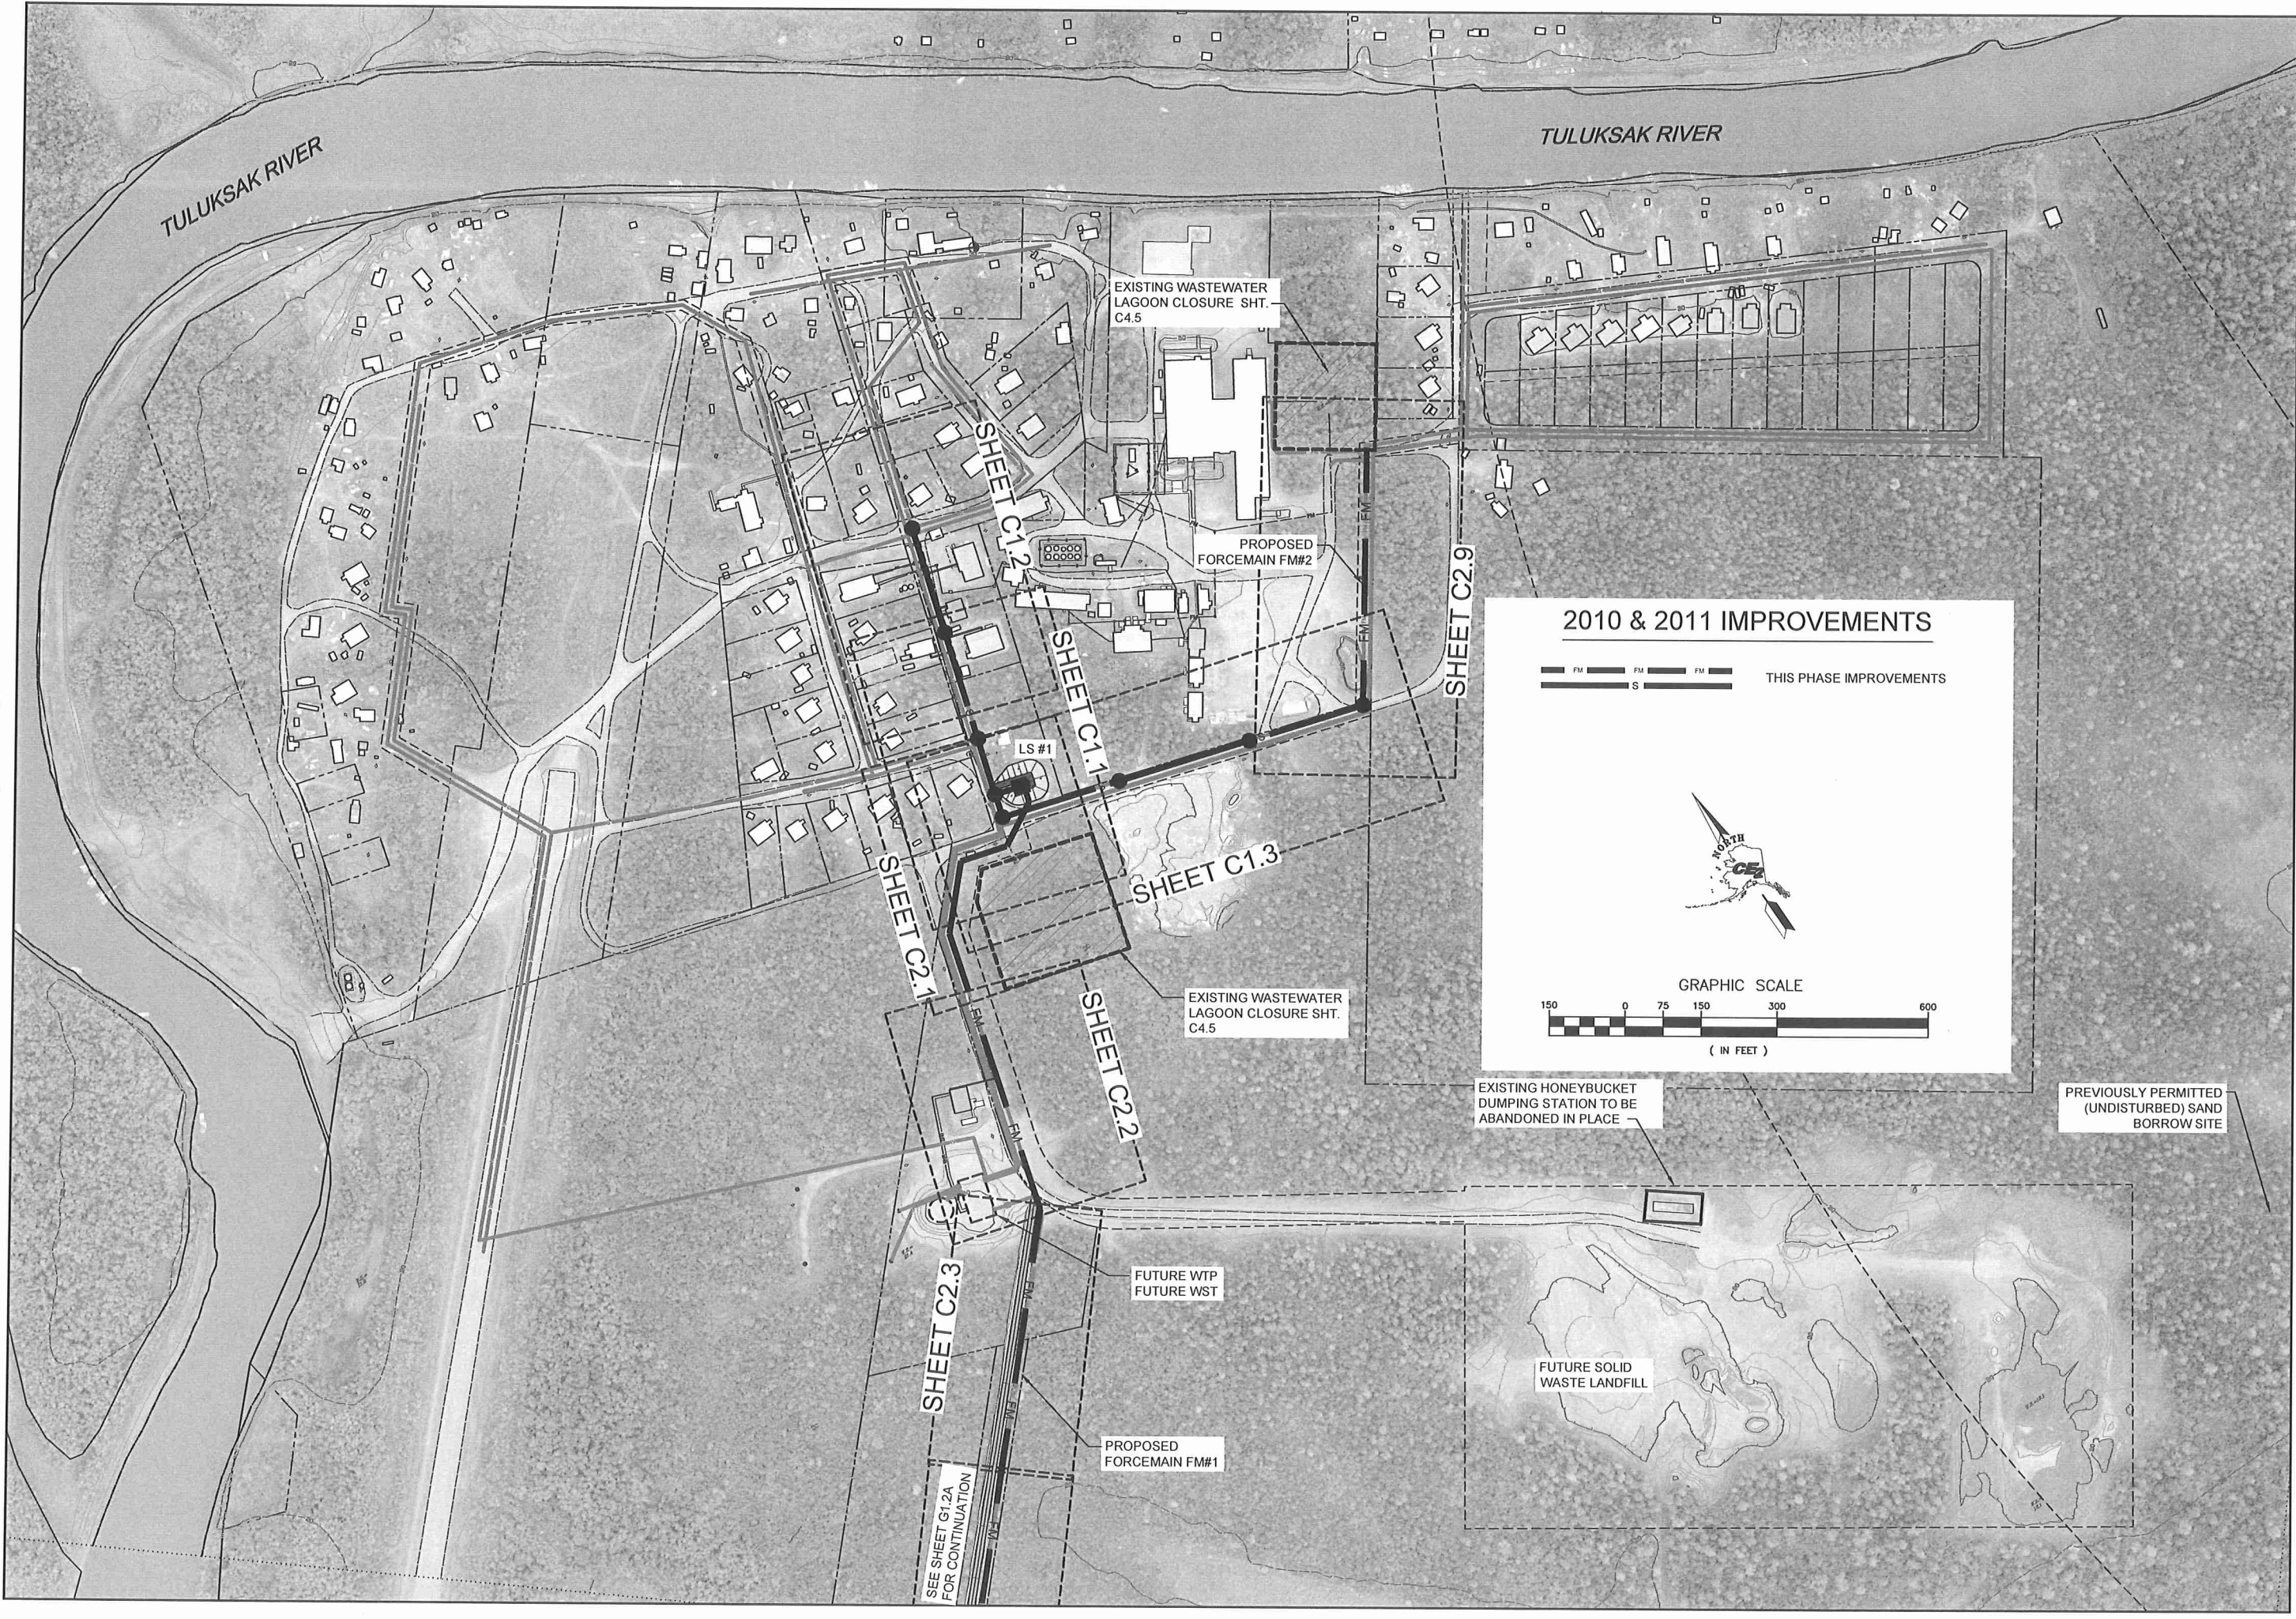

RECORD DRAWING CERTIFICATE
THESE DRAWINGS REFLECT RECORDED
INFORMATION OBTAINED DURING
CONSTRUCTION. INFORMATION PROVIDED
HEREIN IS ACCURATE TO THE BEST OF MY
KNOWLEDGE.

SCALE:
AS SHOWN
BASE LINE INCH ON
ORIGINAL DRAWING
1" = 100'
IF NOT ONE INCH ON
SCALE ACCORDINGLY

2010-11 WASTEWATER
SYSTEM IMPROVEMENTS

2010 AND 2011
IMPROVEMENTS
SHEET INDEX
TULUKSAK, ALASKA

REVISION	BY	DATE

Project No.	Date	Designed	Drawn	Approved
	JUNE 2009	LAP	CM/LAW	LAP

Sheet No. G1.2

G:\ACAD\TULUKSAK\TLT0901 2008 Waste water disposal area\G1.2 - G1.3 SHEET INDEX.dwg, 1/11/2011 12:51:36 PM, Flash, LANIER MP C2050_LD520C PCL 6BLK WHIT.pcl



Project No. _____
Date JUNE 2009
Designed LAP
Drawn CM/LAW
Approved LAP

Sheet No. **G1.3**

REVISION	BY	DATE

CE2
ENGINEERS, INC.
PO BOX 22346 ANCHORAGE, AK 99523 PH: 907-346-1010 FAX: 907-346-1015

**2010-11 WASTEWATER
SYSTEM IMPROVEMENTS**

**2010 AND 2011
IMPROVEMENTS
SHEET INDEX**
TULUKSAK, ALASKA


STATE OF ALASKA
49TH
NO. CE 9692
11/11/11

ALL SAFE WATER

RECORD DRAWING CERTIFICATE
THESE DRAWINGS REFLECT RECORDED
INFORMATION OBTAINED DURING
CONSTRUCTION. INFORMATION PROVIDED
HEREIN IS ACCURATE TO THE BEST OF MY
KNOWLEDGE.

SCALE:
AS SHOWN
BAR IS ONE INCH ON
ORIGINAL DRAWING
0 1"
IF NOT ONE INCH ON
SCALE, ACCORDINGLY

NAME _____
DATE _____

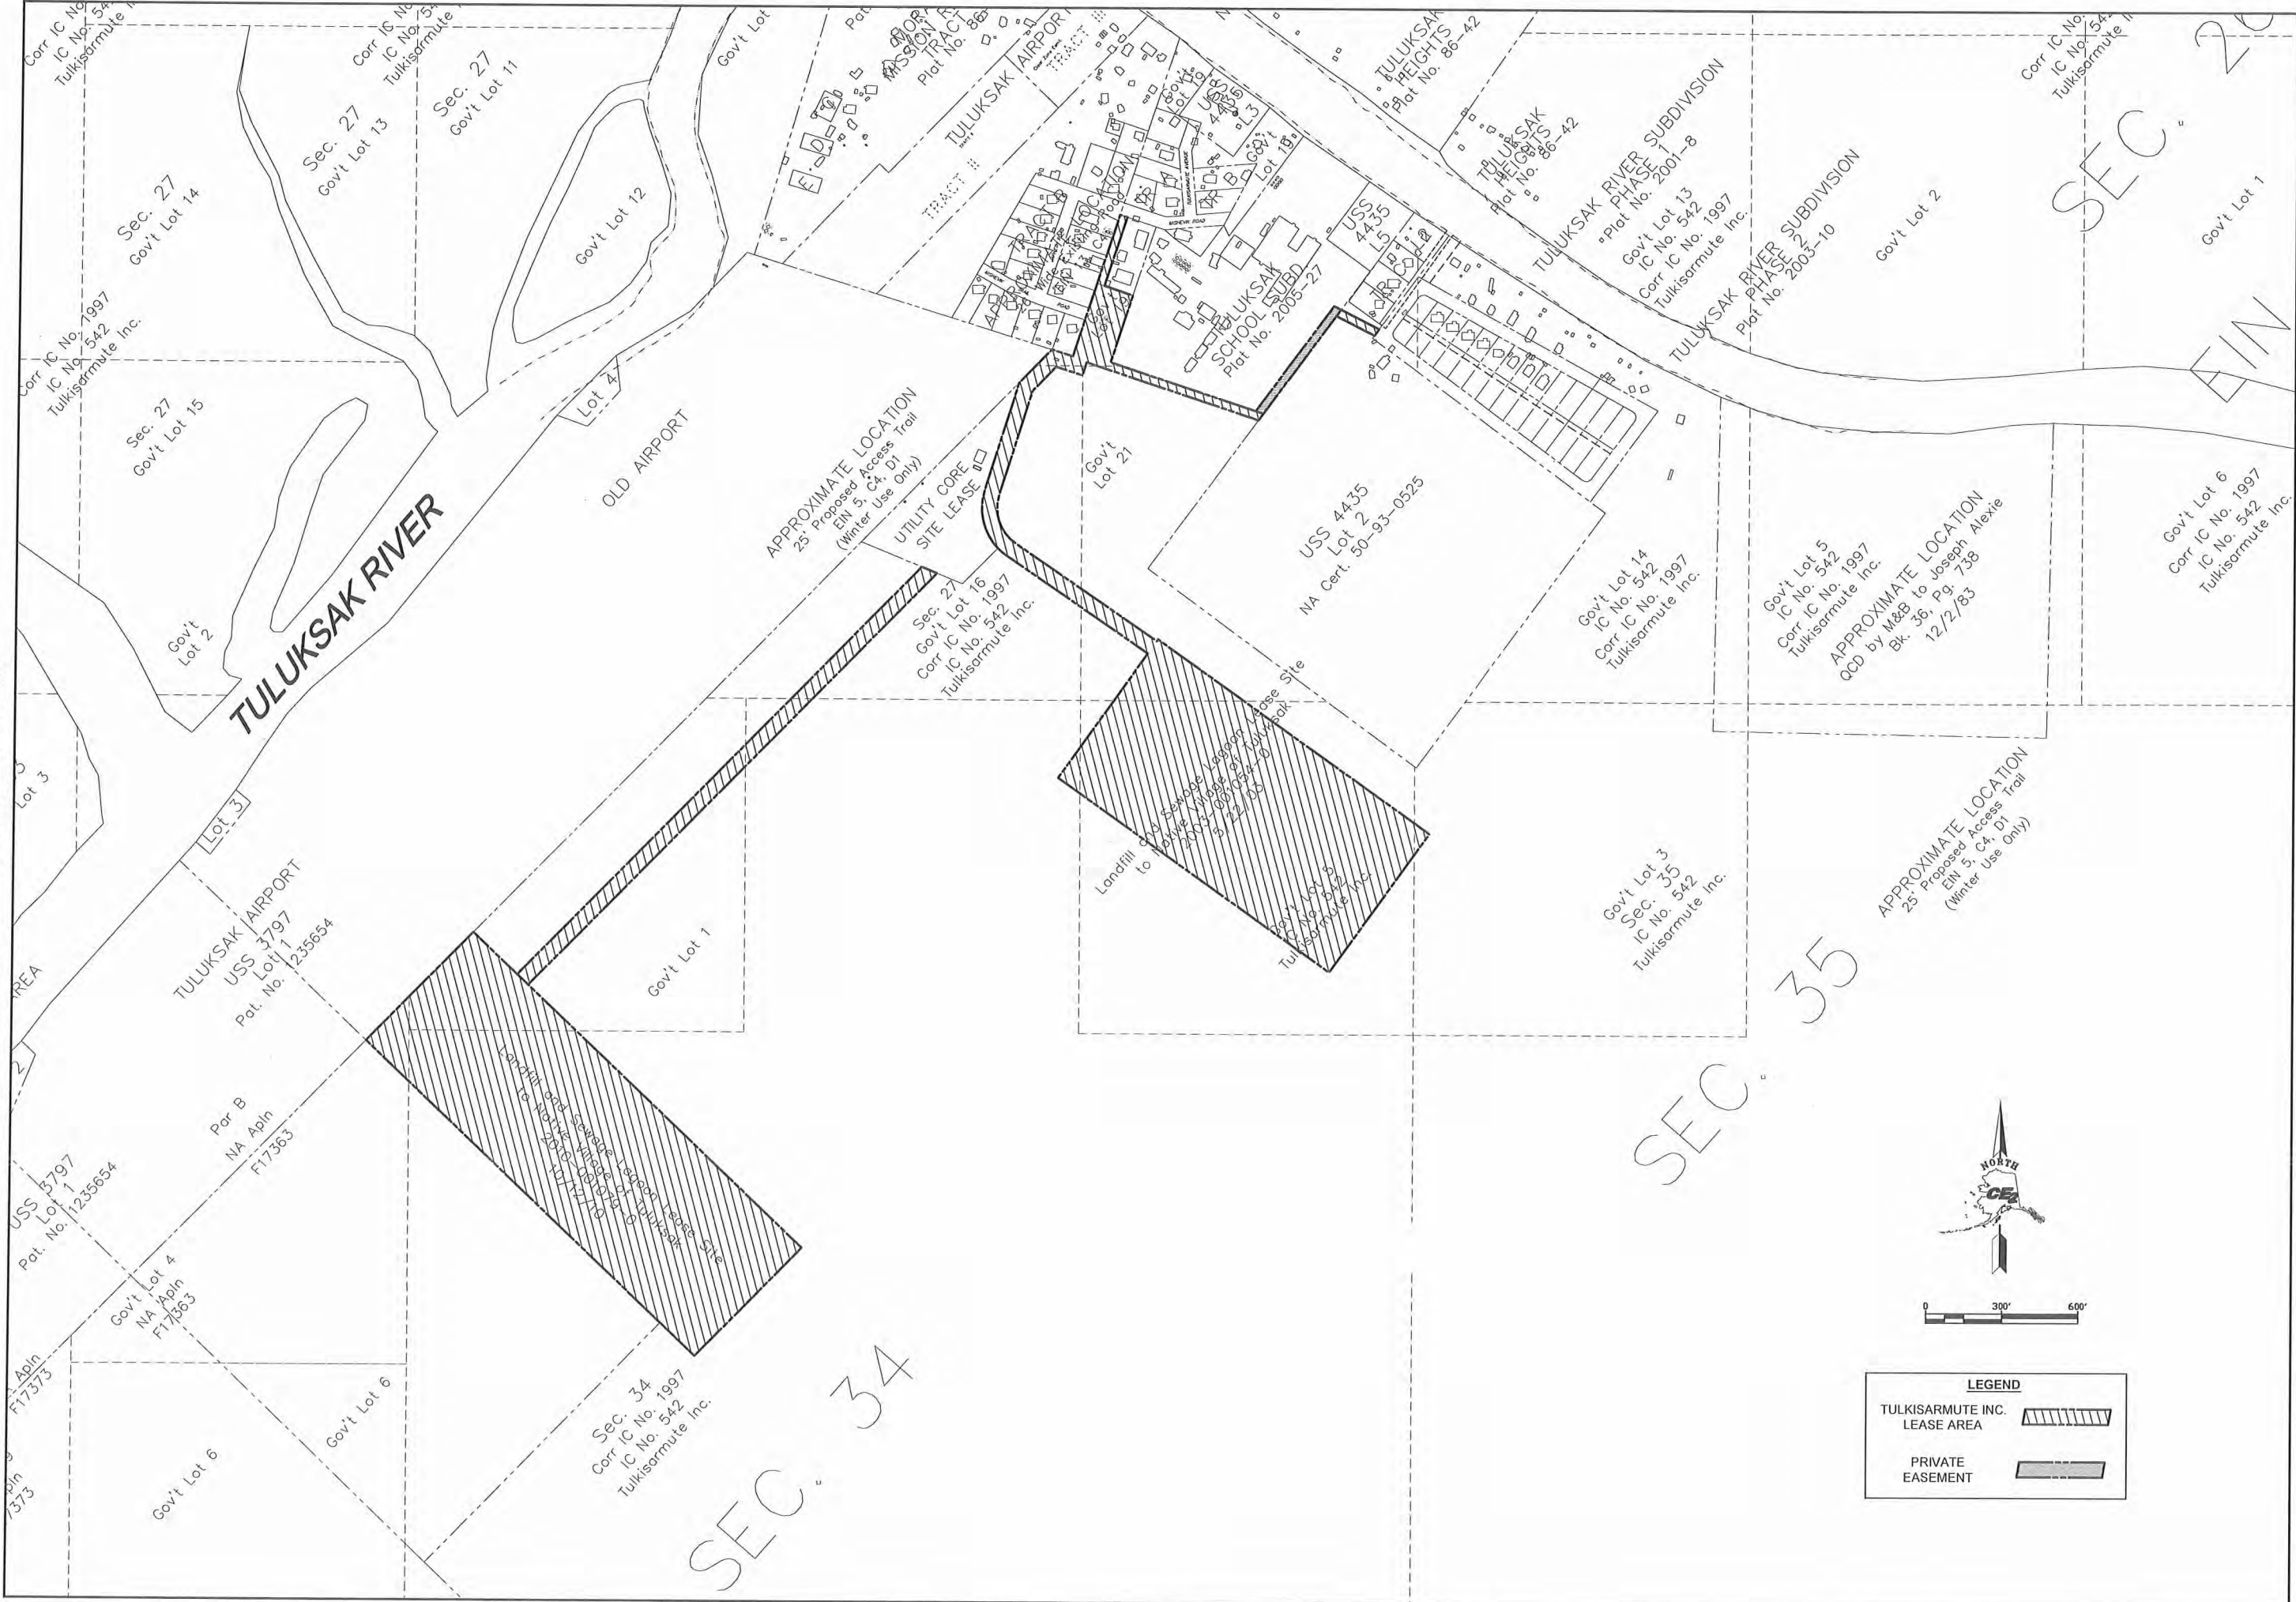

LEGEND

TULKISARMUTE INC. LEASE AREA

PRIVATE EASEMENT

REVISION	BY	DATE

Project No.	JUNE 2009
Date	LAP
Designed	LAP
Drawn	CMLAW
Approved	LAP

Sheet No. G1.4

2010-11 WASTEWATER SYSTEM IMPROVEMENTS

SITE CONTROL

TULUKSAK, ALASKA



SCALE: AS SHOWN

1" = 300'

THIS DRAWING IS NOT TO BE USED FOR ANY OTHER PURPOSES WITHOUT THE WRITTEN CONSENT OF THE ENGINEER.

RECORD DRAWING CERTIFICATE

THESE DRAWINGS REFLECT RECORDED INFORMATION OBTAINED DURING CONSTRUCTION. INFORMATION PROVIDED HEREIN IS ACCURATE TO THE BEST OF MY KNOWLEDGE.

NAME _____ DATE _____

G:\ACAD\TULUKSAK\T10901 2008 Waste water disposal area\G2.0 SURVEY CONTROL.dwg, 1/11/2011 12:57:36 PM, Flash, LANIER MP C2050_LD520C PCL 6BLK WHIT.pcl

PROJECT CONTROL (GROUND) COORDINATE TABLE

Number	Northing	Easting	Elevation	Raw Desc
3000	2594495.041	1824290.109	23.63	BASE BLM BRASS CAP COR. 2, USS 875, (1960)
3001	2595445.568	1824701.089	27.22	BLM BRASS CAP LOT 3, CDR. 2 USS 4435 (1991)
3002	2594547.493	1823027.080	23.04	2" ALUMINUM CAP -1+975-75H, LT-L36714 (1997)
3003	2590693.676	1818857.680	27.93	BLM BRASS CAP LOT 1, CDR. 4 USS 3797 (1960 & 1991)
3006	2589887.670	1819682.122	26.52	BLM BRASS CAP LOT 1, CDR. 3 USS 3797 (1960 & 1991)
3012	2594343.462	1824099.100	20.20	RED PLASTIC CAP (HCLINTOCK)
3015	2594298.755	1826560.781	27.97	SET SPIKE
3016	2593887.953	1826402.475	23.55	BLM BRASS CAP COR 3, LOT 2 USS 4435 (1991)
3017	2594573.011	1825472.629	25.39	BLM BRASS CAP COR 2, LOT 2 USS 4435 (1991) BURIED 0.7'
3018	2594649.098	1825500.544	28.29	POWER POLE SPIKE TBM
3019	2594846.307	1825673.705	27.78	BLM BRASS CAP COR 1, LOT 2 USS 4435 (1991)
3020	2594836.263	1825461.451		BLM BRASS CAP COR 1, LOT 5, COR 6, LOT 1 USS 4435 (1991)
3021	2594714.793	1825377.604	26.49	N" REBAR
3022	2594785.016	1825159.676	24.62	BLM BRASS CAP COR 4, LOT 1, COR 4, LOT 4 USS 4435 (1991)
3025	2595271.081	1824545.942	24.86	N" REBAR
3028	2596151.080	1823704.447	22.24	RED PLASTIC CAP (DOWL), 6" ABOVE GROUND
3030	2594829.251	1823518.867	24.65	RED PLASTIC CAP (DOWL) BURIED, 1'
3031	2594817.777	1823506.447	24.03	5/8" REBAR (BENT SHOT BASE) -CL-2+125
3033	2594521.291	1824207.672	24.42	BLM BRASS CAP COR 2, LOT 1 USS 3797 (1960)
3051	2595171.821	1824112.749	24.23	1.5" ALUMINUM CAP (IN ROAD)
3052	2595455.559	1824925.012	30.23	ARMORY-TBM-SPK AT CORP OF ENG. HIGH WATER MARK (SIGN)
3053	2595541.654	1824656.014	29.63	POWER POLE SPIKE TBM
3054	2595254.918	1824730.236	26.21	SET SPIKE IN ROAD

LEGEND

3015 TYPICAL CONTROL POINT IDENTIFIER

3015 TYPICAL CONTROL POINT IDENTIFIER WITH CONVENTIONAL DIFFERENTIAL ELEVATION

SURVEY NOTES

THIS SURVEY WAS PERFORMED WITH TRIMBLE MODEL 4700 RECEIVERS AND TRIMBLE GEOMATICS OFFICE VERSION 1.5 PROCESSING SOFTWARE. THE HORIZONTAL POSITIONS WERE DETERMINED WITH REAL TIME KINETIC METHODS BASED UPON POINT NUMBER 3000, THE BASE STATION POINT. SEE LOCAL PROJECT COORDINATE TABLE FOR POINT 3000 LOCAL PROJECT COORDINATES. POINT 3000 ALSO HAD "NAD 83 AK STATE PLANE ZONE 7 COORDINATES OF N=2594539.283 USFT., E=1824246.230 USFT., OR N=790817.158 M., E=556031.363 M., DETERMINED BY POST PROCESSING 3 STATIC SESSIONS WITH 5 OTHER CORRS STATIONS.

THIS SURVEY'S COORDINATES ARE US SURVEY FEET BASED ON ALASKA DOT&PF PROJECT AKSAS 51795, TULUKSAK AIRPORT, 1997 SURVEY CONTROL, SUBMITTED BY STANLEY E. PONSNESS, LS#6714. THIS SURVEY WAS CALIBRATED OR LOCALIZED TO SAID SURVEY BY A LEAST SQUARES BEST FIT USING SIX OF THE FORMER SURVEY CONTROL POINTS SPREAD AROUND THIS PROJECT. ALL SIX POINTS OF THIS SURVEY FIT WITHIN 0.1 USFT OF THE FORMER SURVEY PUBLISHED VALUES. THIS SURVEY THEREFORE MAINTAINS THE FORMER SURVEY HORIZONTAL GROUND DISTANCES AND LOCAL PLANE BEARINGS AS ORIENTED TO THE MEAN NAD 83 GEODETIC BEARING OF N 34°00'42"E BETWEEN MONUMENTS SET TO DEFINE THE CENTERLINE OF A PLANNED FUTURE RUNWAY CENTERLINE. SAID BEARINGS WERE REPORTED TO BE DETERMINED FROM GPS SURVEY METHODS ORIGINATING AT NGS B ORDER GPS STATION "CABIN" LOCATED NEAR BETHEL.

VERTICAL DATUM IS NAVD88 BASED UPON THIS SURVEY'S AFOREMENTIONED POST PROCESSING. THE ELIPSOIDAL HEIGHT OF POINT NO. 3000 WAS DETERMINED TO BE 67.010 USFT, AND THE ORTHOMETRIC HEIGHT (ABOVE GEOID OR APPROXIMATE MEAN SEA LEVEL) WAS HELD AS 23.634 USFT. CONVENTIONAL DIFFERENTIAL LEVEL LOOPS WERE USED TO CONTROL THE VERTICAL POSITIONING, USING THE ELEVATION OF 23.634 USFT OF POINT NO. 3000 AS THE BASIS OF ELEVATION.

US ARMY CORP. OF ENGINEERS FLOOD WATER GAUGE ELEVATION 0.0 IS ELEVATION 28.33 (THIS SURVEY) AS DETERMINED AT THE GAUGE SIGN ON THE CLASSROOM BUILDING IN FRONT OF THE HIGH SCHOOL. THE FLOOD WATER GAUGE SIGN LISTS THE HIGH WATER MARK AT 3.9 FEET AND THE RECOMMENDED BUILDING ELEVATION AT 5.9 FEET.

TBM 7 EL=30.40'
HIGHEST PART OF 30"x30" CONC.
WIND SOCK BASE (TIPPED OVER)

TBM 6 EL=29.81'
SPIKE IN SOUTH SIDE OF
POWER POLE W/ TRANSFORMER

TBM 4 EL=29.63'
6" SPIKE IN NORTH SIDE OF POWER POLE

TBM 8 EL=26.30'
6" SPIKE, 1" ABOVE GROUND IN SOUTH SIDE OF POWER POLE
C.O.E. HIGH WATER MARK ON SAME POLE, EL=30.24'

TBM 13 EL=29.22'
SPIKE IN SE SIDE OF POWER POLE (#B52),
1" ABOVE GROUND

TBM 14 EL=29.99'
SPIKE IN SOUTH SIDE OF POWER POLE (#B7U),
2' ABOVE GROUND

TBM 15 EL=28.43'
SPIKE IN SOUTH SIDE OF POWER POLE

TBM FINISH FLOOR
TULUKSAK NATIVE STORE
EL=28.74'

TBM SPIKE EL=25.43'
NORTH SIDE OF POWER POLE
1" ABOVE GROUND

TBM 9 EL=26.30'
SPIKE IN WEST SIDE OF POWER POLE
1" ABOVE GROUND

REQUIRE EASEMENT

USS 4435
LOT 2

LONG TERM LEASE FROM
TULUKSAMUIT CORP
19--

DATE 10-20-03

SCALE 1"=300'

SHEET 1 OF 1

JOB No. 3698

DRAWING: 3698TULUKSAK

TULUKSAK
SURVEY CONTROL DIAGRAM

ABILITY SURVEYS

GARY D. NELSON, P.L.S.

(907)235-8440

152 DEHEL AVE., HOMER, ALASKA

RECORD DRAWING CERTIFICATE

THESE DRAWINGS REFLECT RECORDED
INFORMATION OBTAINED DURING
CONSTRUCTION. INFORMATION PROVIDED
HEREIN IS ACCURATE TO THE BEST OF MY
KNOWLEDGE.

NAME

DATE

SCALE:

AS SHOWN

1"

IF NOT ONE INCH ON
THIS SHEET ADJUST
SCALE ACCORDINGLY



2010-11 WASTEWATER
SYSTEM IMPROVEMENTS

HORIZONTAL AND
VERTICAL CONTROL

TULUKSAK, ALASKA

CE2
ENGINEERS, INC.

PO BOX 22346 ANCHORAGE, AK 99520 PH: 907-549-1000 FAX: 907-549-1015


REVISION	BY	DATE

Project No.	JUNE 2009
Date	LAP
Designed	ABILITY
Drawn	LAP
Approved	LAP

Sheet No.

G2.0

G:\ACAD\TULUKSAK\TLT0901 2008 Waste water disposal area\G3.0 TO G3.5.dwg, 1/11/2011 1:25:46 PM, Flash, HP LaserJet 5100 Series PCL6.pc3

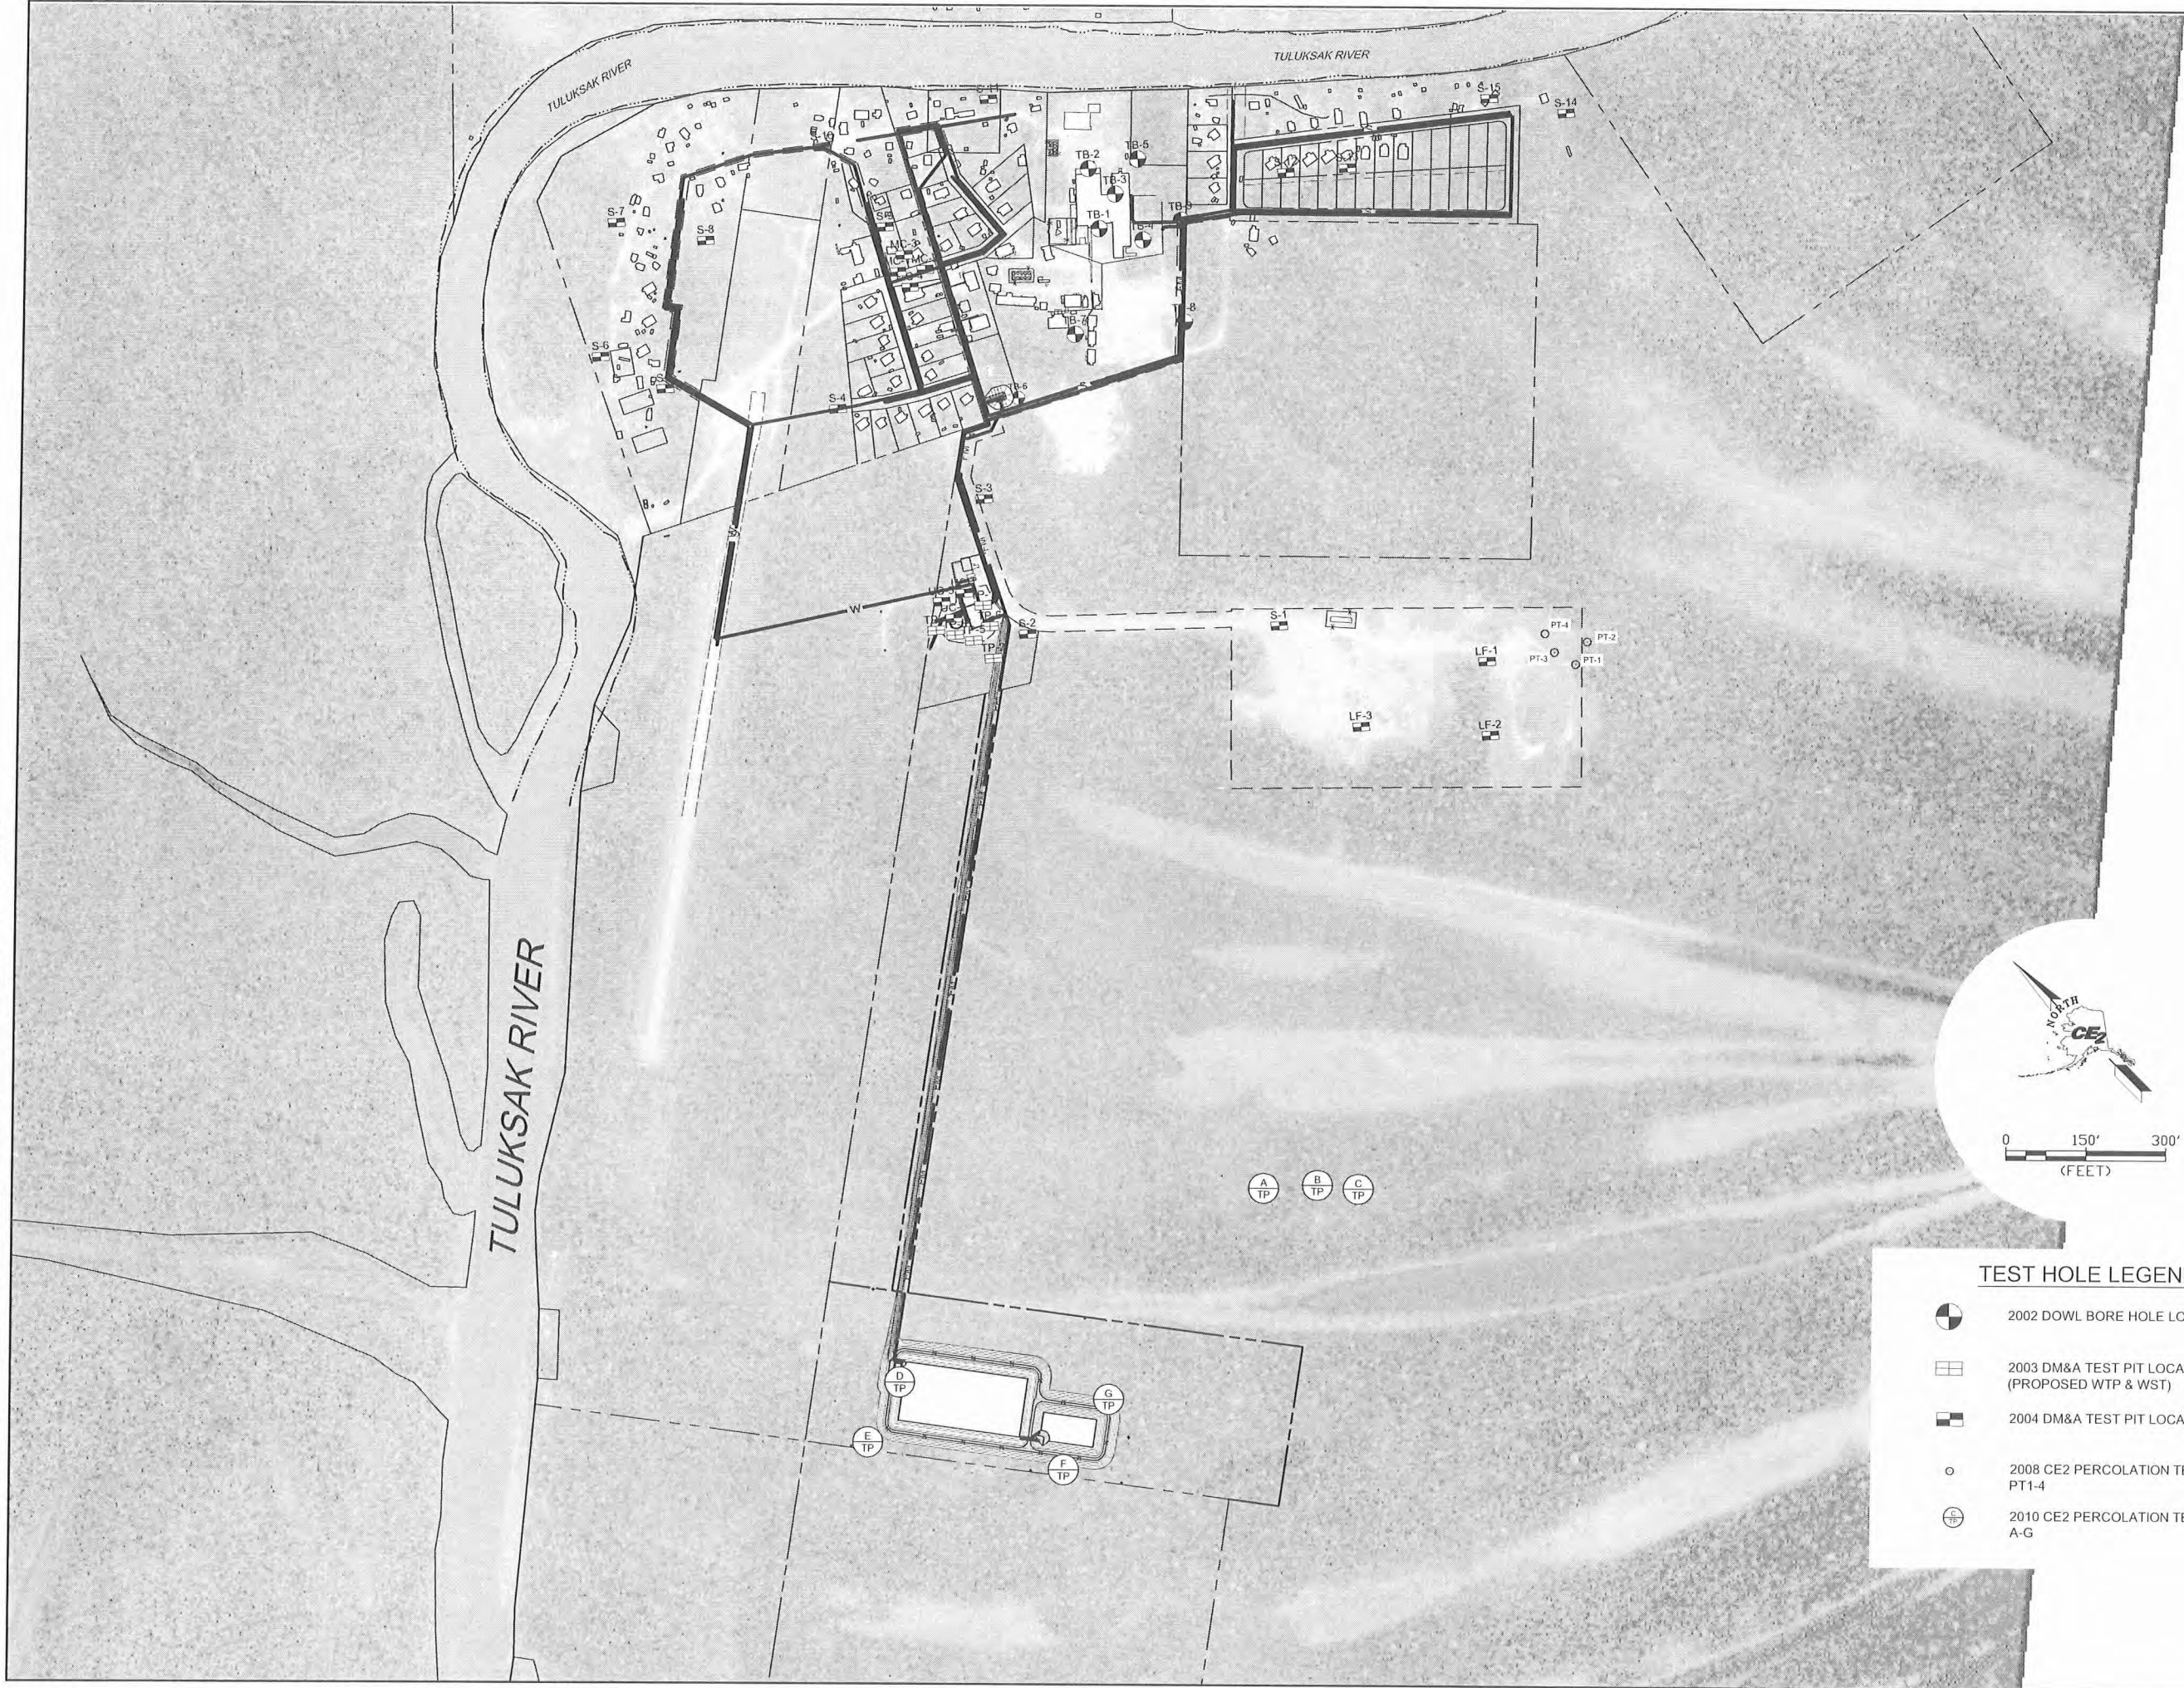

TEST HOLE LEGEND

- 2002 DOWL BORE HOLE LOCATION - 1-10
- 2003 DM&A TEST PIT LOCATION - TP1-TP-5 (PROPOSED WTP & WST)
- 2004 DM&A TEST PIT LOCATION- UC1-3
- 2008 CE2 PERCOLATION TEST HOLES PT1-4
- 2010 CE2 PERCOLATION TEST HOLES A-G

RECORD DRAWING CERTIFICATE
THESE DRAWINGS REFLECT RECORDED
INFORMATION OBTAINED DURING
CONSTRUCTION. INFORMATION PROVIDED
HEREIN IS ACCURATE TO THE BEST OF MY
KNOWLEDGE.

SCALE:
AS SHOWN
1" = 100'
IF NOT SHOWN ON
THIS SHEET, AS SHOWN
ON THE PREVIOUS SHEET



2010-11 WASTEWATER
SYSTEM IMPROVEMENTS
TEST HOLE SITE
LOCATION MAP
TULUKSAK, ALASKA







CE2
ENGINEERS, INC.
PO BOX 322846 ANCHORAGE, AK 99523 PH 907-345-1010 FAX 907-345-1015

REVISION	BY	DATE

Project No. _____
Date JUNE 2009
Designed LAP
Drawn CM
Approved LAP

Sheet No. G3.0

G:\ACAD\TULUKSAK\TLT0901 2008 Waste water disposal area\G3.0 TO G3.5.dwg, 1/11/2011 1:02:29 PM, Flash, LANIER MP C2050_LDS20C PCL 6BLK WHIT.pcl

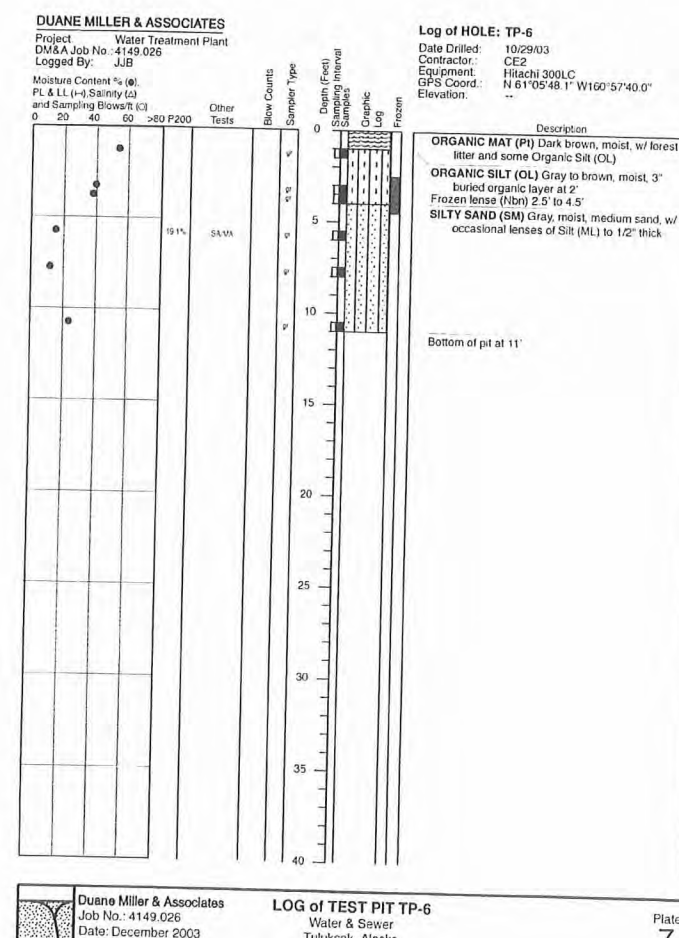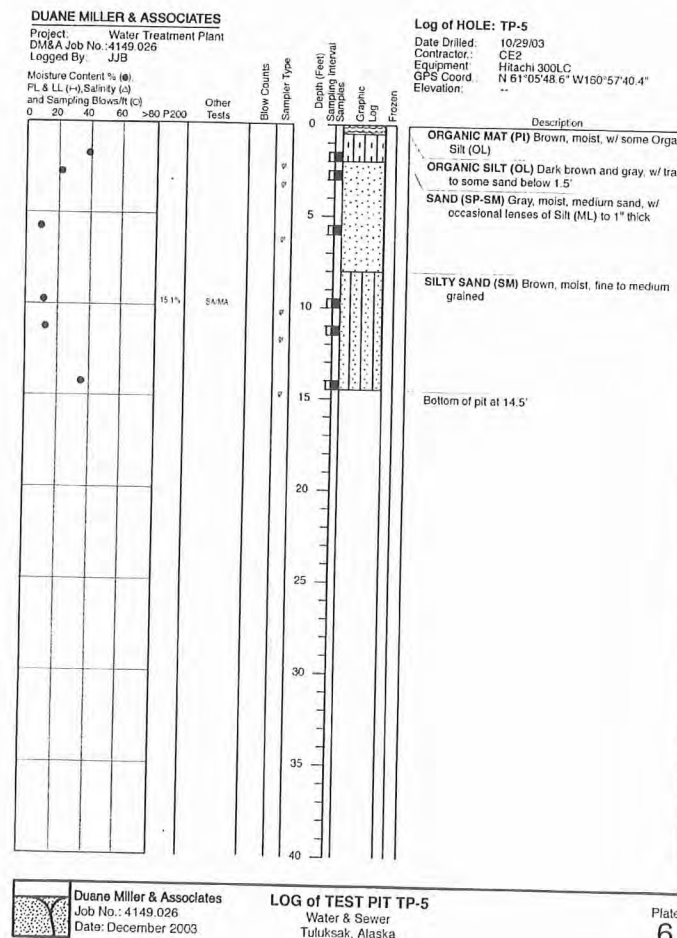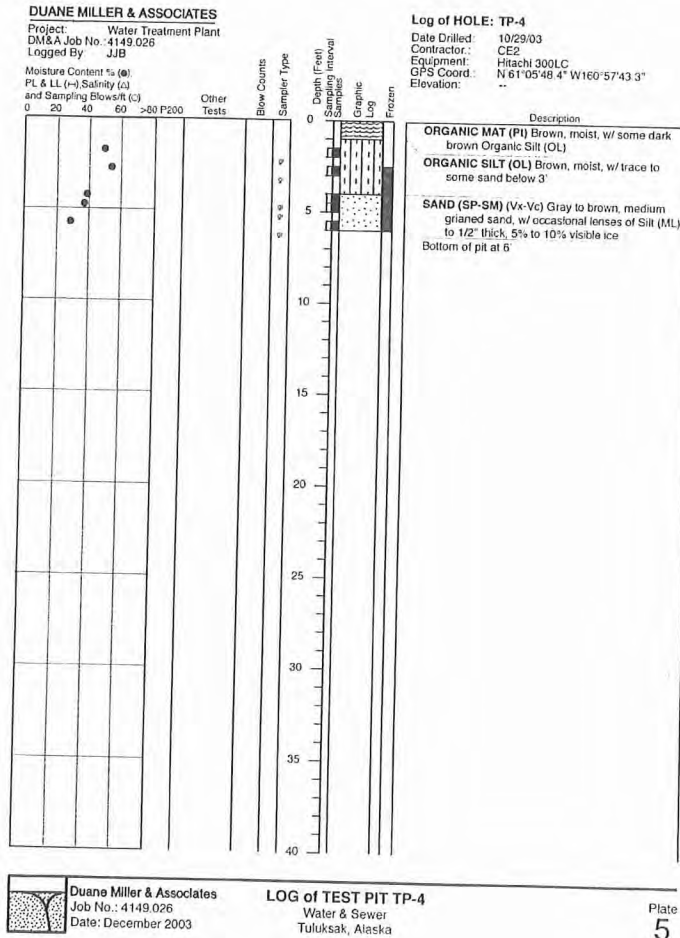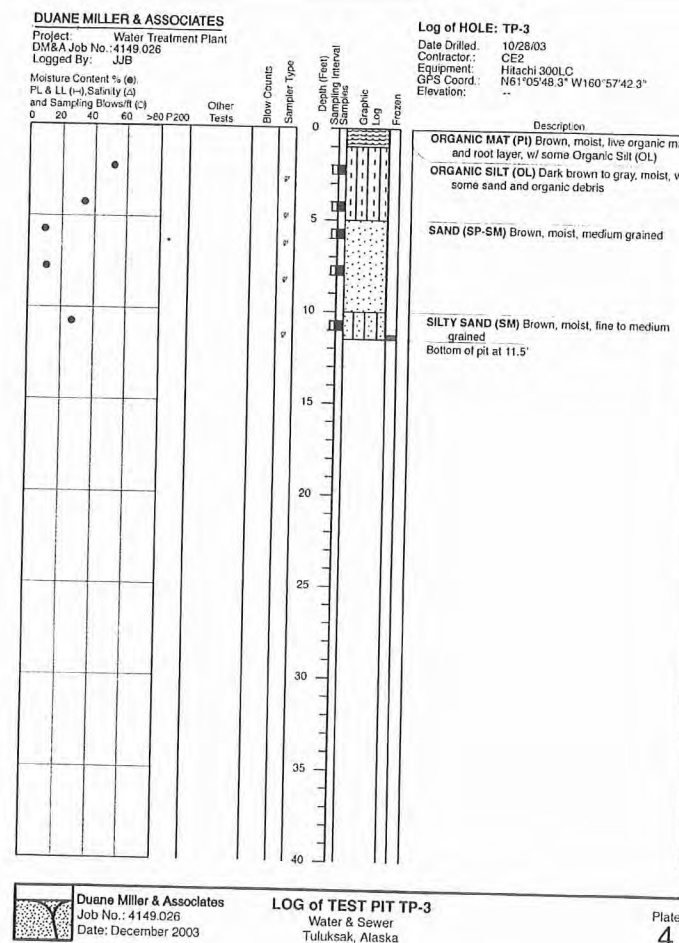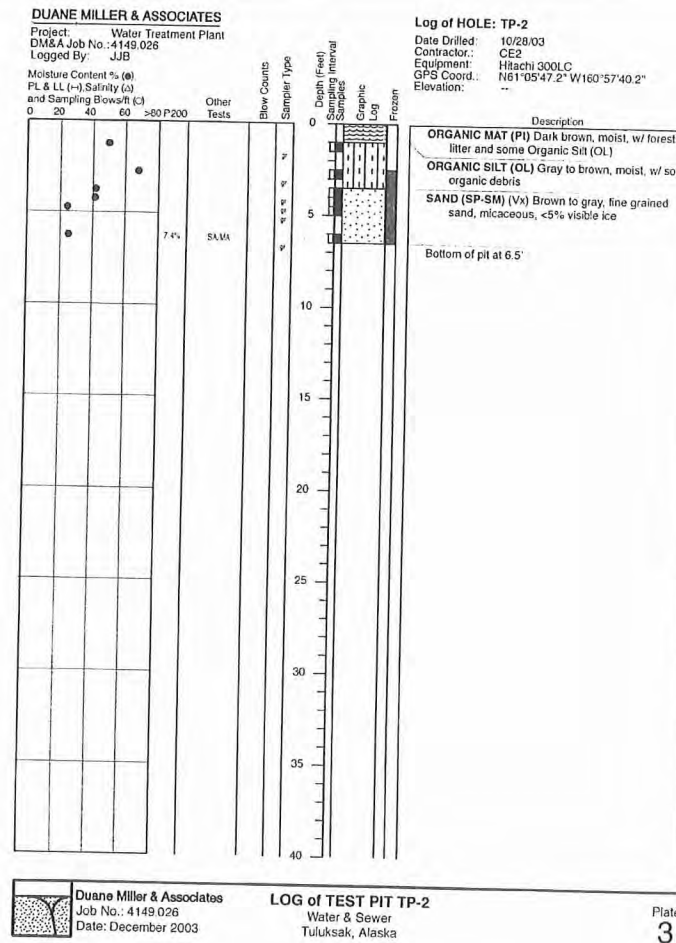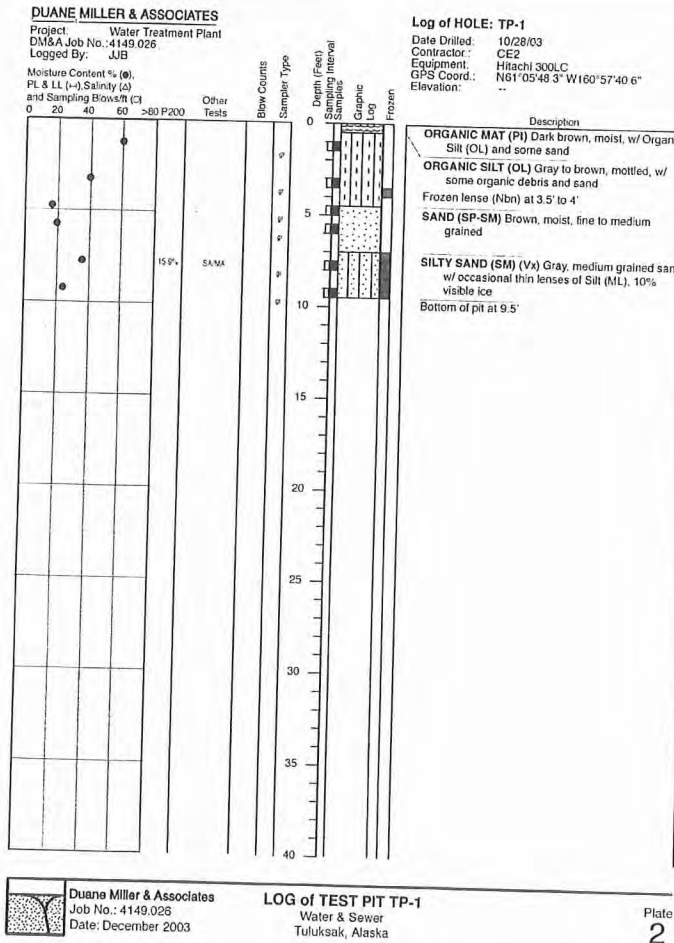

RECORD DRAWING CERTIFICATE

THESE DRAWINGS REFLECT RECORDED INFORMATION OBTAINED DURING CONSTRUCTION. INFORMATION PROVIDED HEREIN IS ACCURATE TO THE BEST OF MY KNOWLEDGE.

SCALE: 1" = 10' (SEE SCALE BAR)

DATE: 11/11/11

2010-11 WASTEWATER SYSTEM IMPROVEMENTS

TEST HOLE BORING LOGS

TULUKSAK, ALASKA

CE2 ENGINEERS, INC.

PO BOX 22946 ANCHORAGE, AK 99523 PH: 907-346-0001 FAX: 907-346-0015

Project No. JUNE 2009

Date: JUNE 2009







Designed: LAP

Drawn: CM

Approved: LAP

Sheet No. G3.1

G:\ACAD\TULUKSAK\TLT0901 2008 Waste water disposal area\G3.0 TO G3.5.dwg, 1/11/2011 1:02:43 PM, Flash, LANIER MP C2050_LD520C PCL 6BLK WHIT.pcl

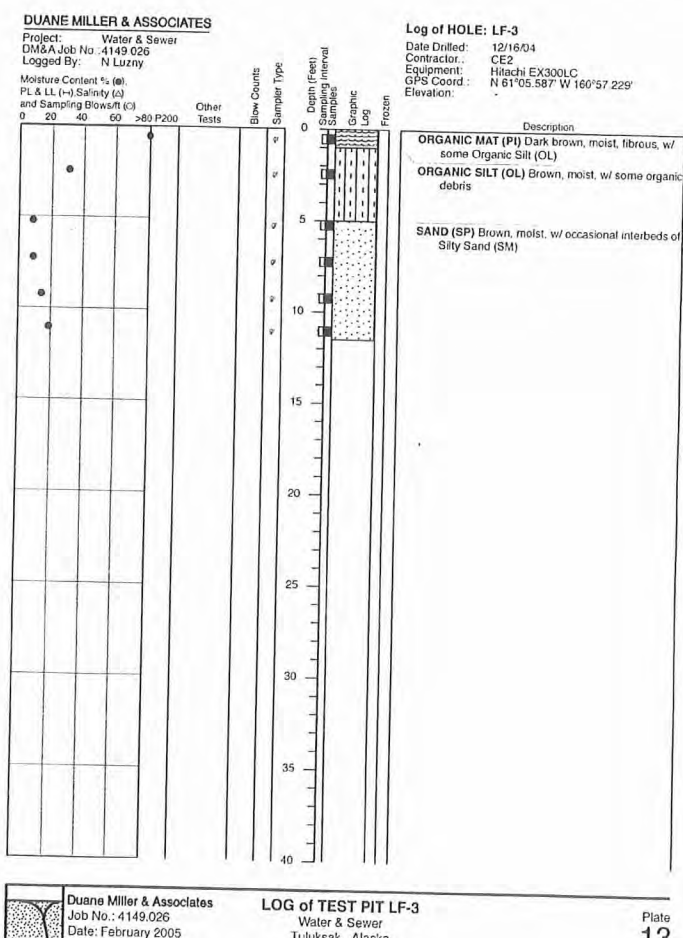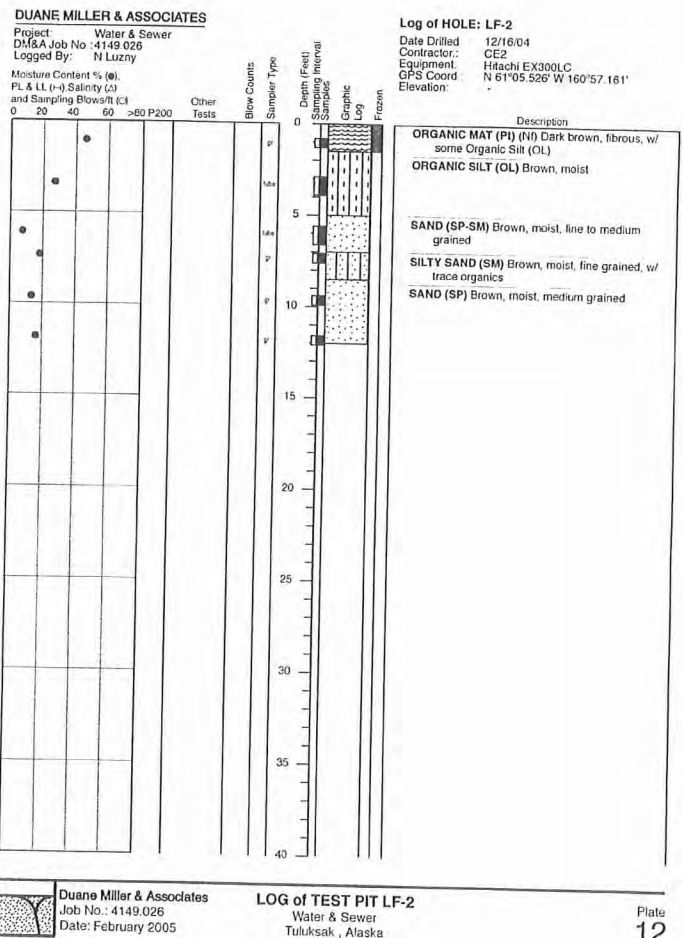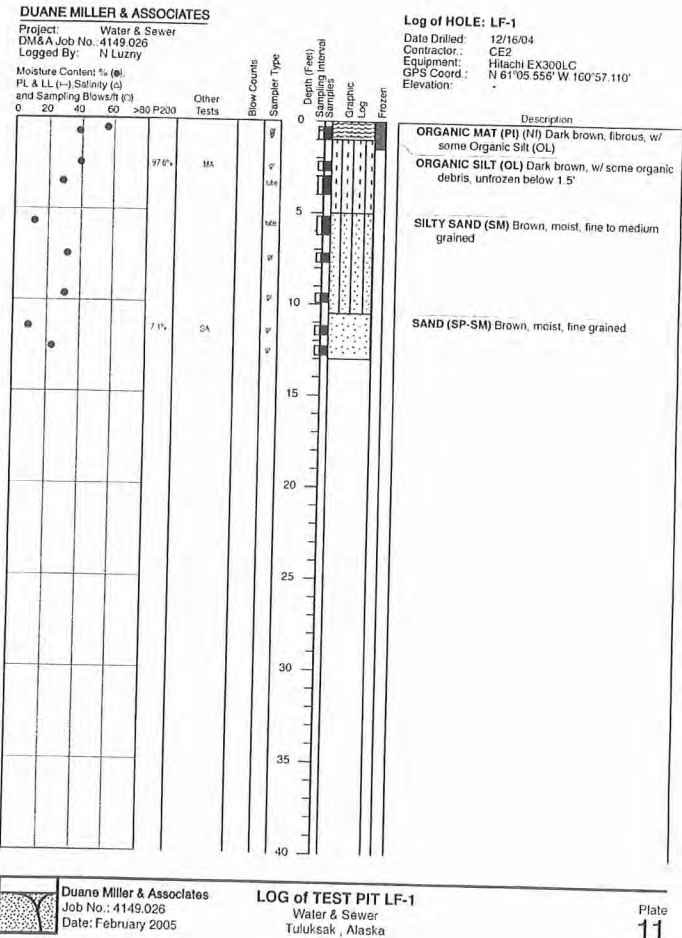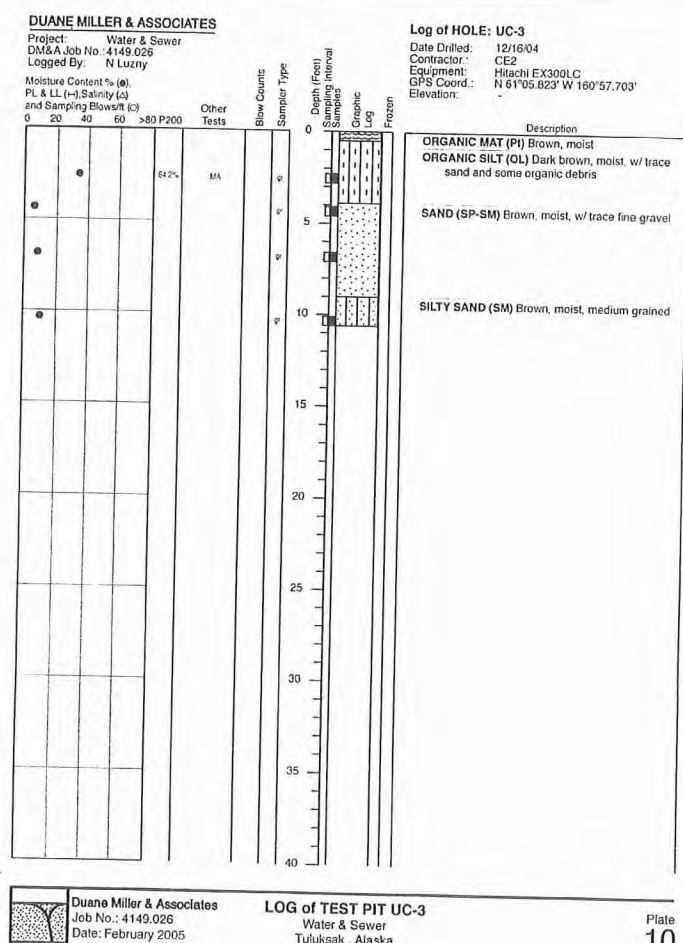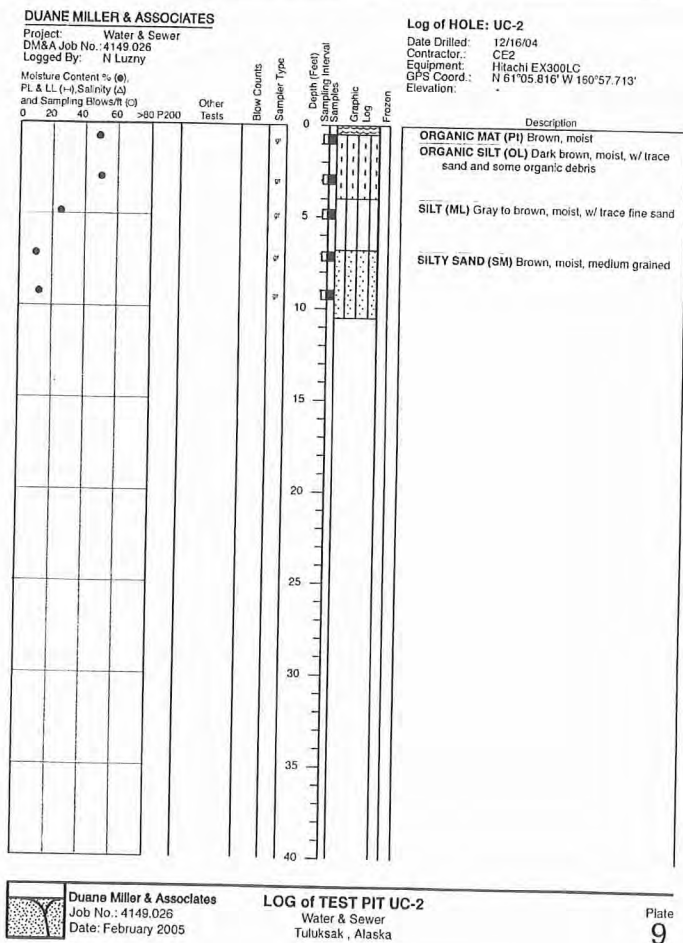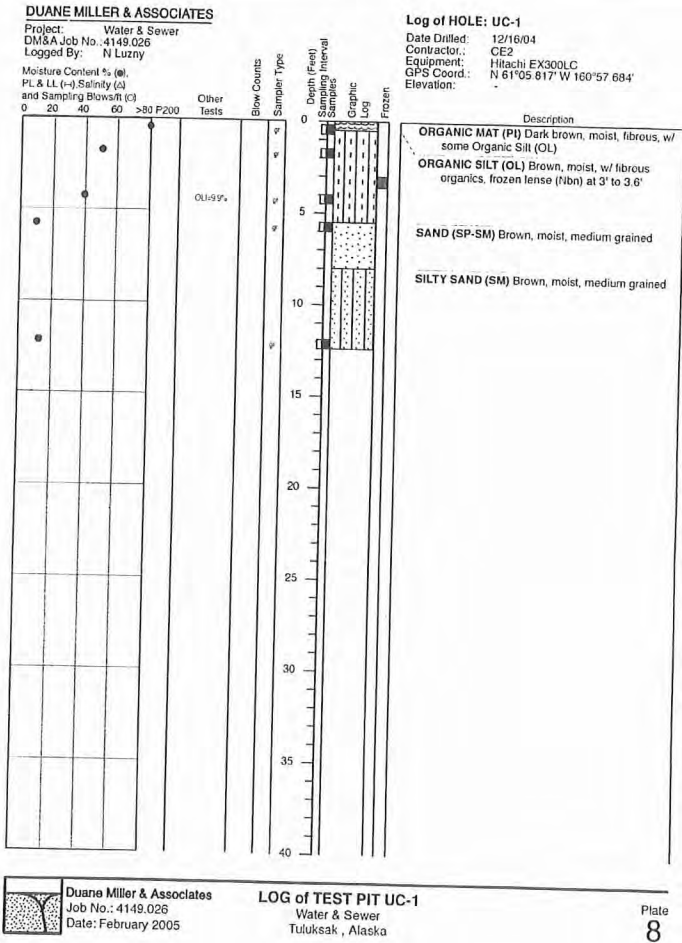

RECORD DRAWING CERTIFICATE

THESE DRAWINGS REFLECT RECORDED INFORMATION OBTAINED DURING CONSTRUCTION. INFORMATION PROVIDED HEREIN IS ACCURATE TO THE BEST OF MY KNOWLEDGE.


NAME _____

DATE _____

SCALE:

1" = 1'

IF NOT ONE INCH ON THIS SHEET, ADJUST SCALES ACCORDINGLY

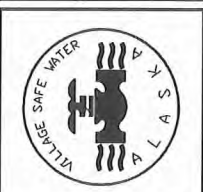

2010-11 WASTEWATER SYSTEM IMPROVEMENTS

TEST HOLE BORING LOGS

TULUKSAK, ALASKA




REVISION	BY	DATE


Project No.	Date	Designed	LAP	Drawn	CM	Approved	LAP
	JUNE 2009						

Sheet No. G3.2


G:\ACAD\TULUKSAK\TLT0901 2008 Waste water disposal area\G3.0 TO G3.5.dwg, 1/11/2011 1:03:10 PM, Flash, LANIER MP C2050_LD520C PCL 6BLK WHIT, pc3

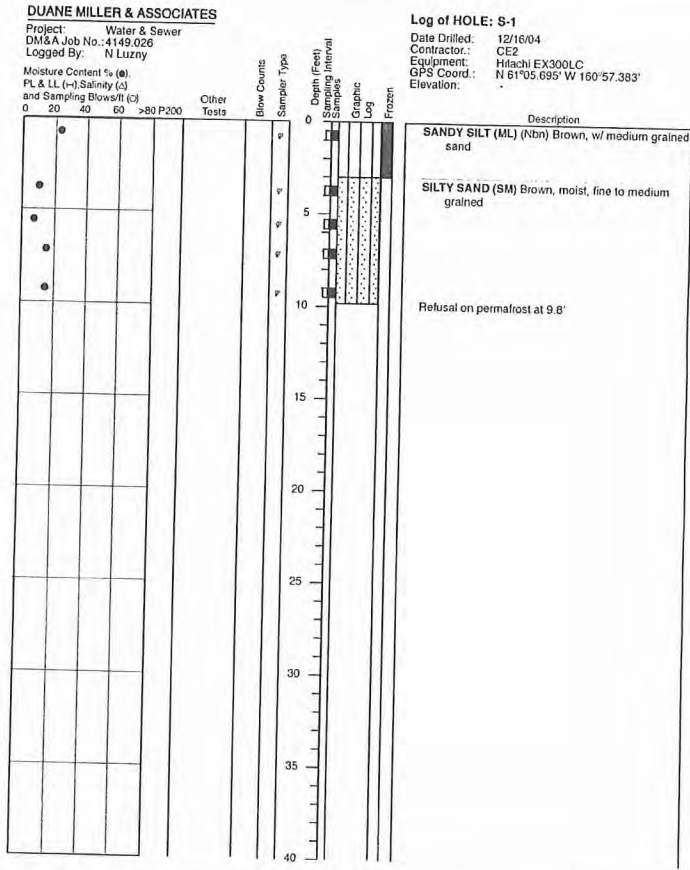


LOG of TEST PIT S-1
Water & Sewer
Tuluksak, Alaska
Plate 14

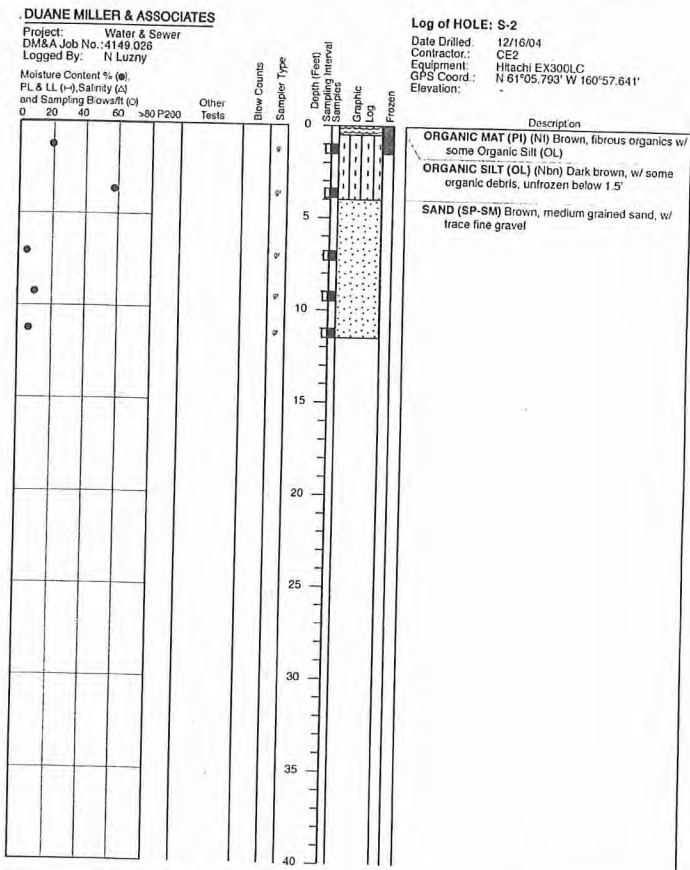


LOG of TEST PIT S-2
Water & Sewer
Tuluksak, Alaska
Plate 15

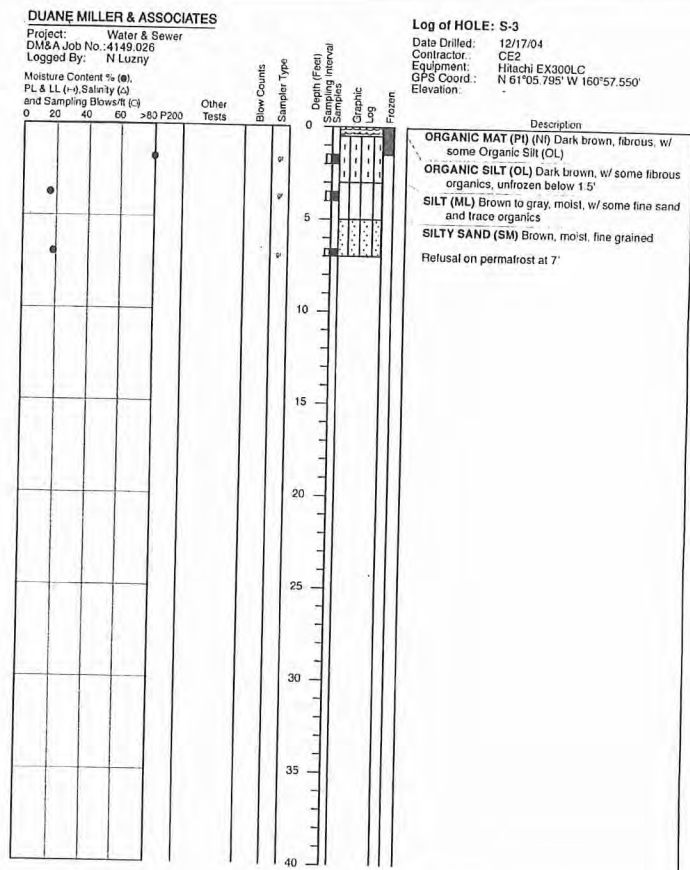


LOG of TEST PIT S-3
Water & Sewer
Tuluksak, Alaska
Plate 16

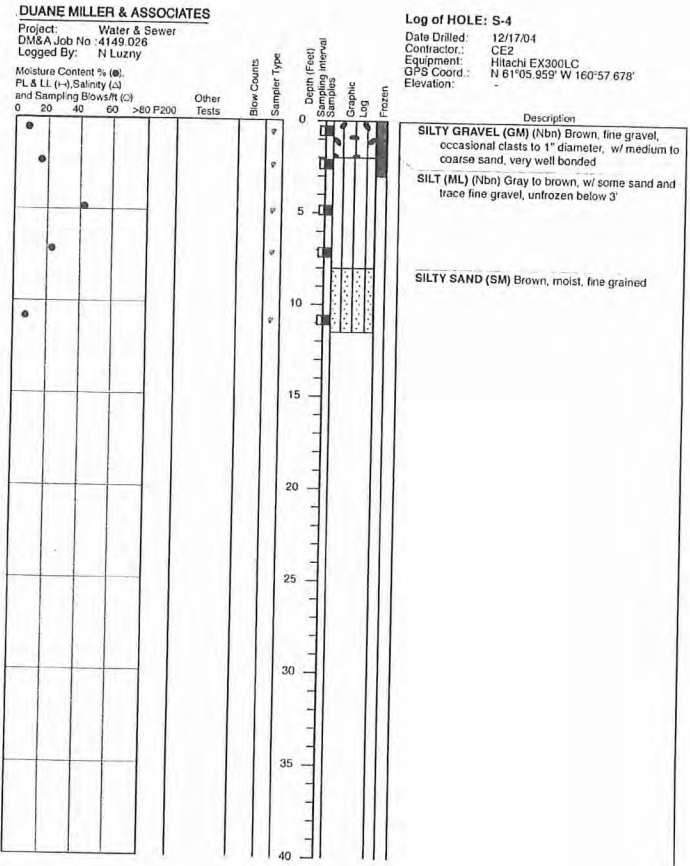

LOG of TEST PIT S-4
Water & Sewer
Tuluksak, Alaska
Plate 17

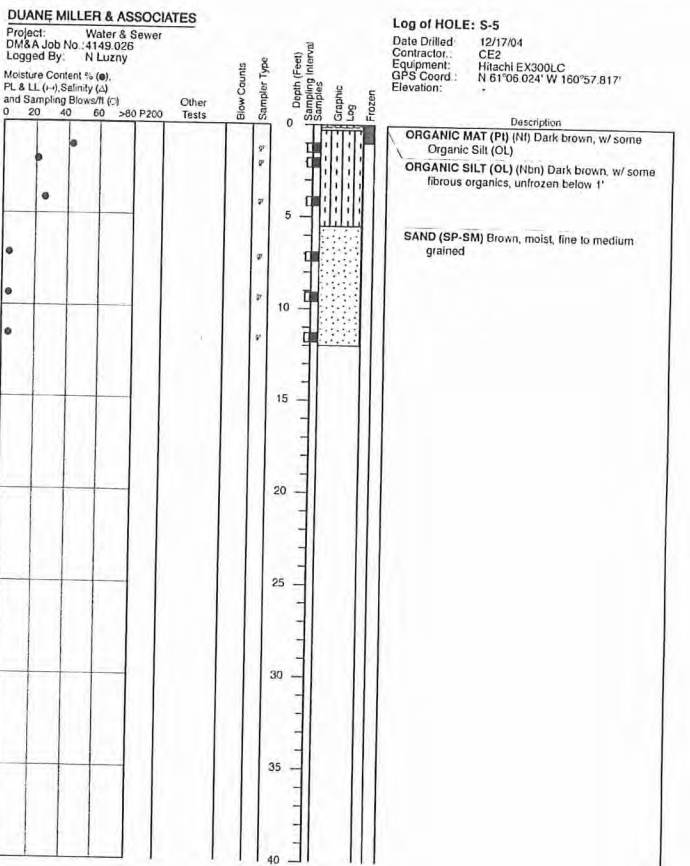

LOG of TEST PIT S-5
Water & Sewer
Tuluksak, Alaska
Plate 18

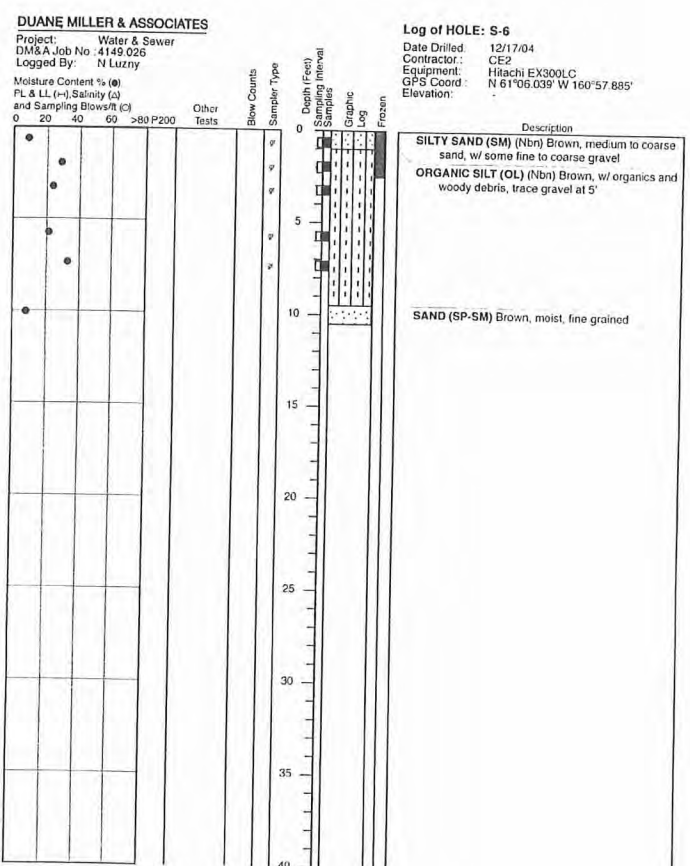

LOG of TEST PIT S-6
Water & Sewer
Tuluksak, Alaska
Plate 19


RECORD DRAWING CERTIFICATE
THESE DRAWINGS REFLECT RECORDED INFORMATION OBTAINED DURING CONSTRUCTION. INFORMATION PROVIDED HEREIN IS ACCURATE TO THE BEST OF MY KNOWLEDGE.

NAME _____ DATE _____

SCALE: 1" = 10'

BAR IS ONE INCH ON ORIGINAL DRAWING

IF ANY ONE INCH ON THIS SHEET, ADJUST SCALES ACCORDINGLY

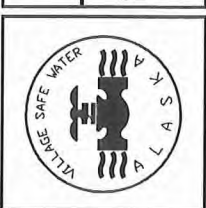

2010-11 WASTEWATER SYSTEM IMPROVEMENTS

TEST HOLE BORING LOGS







TULUKSAK, ALASKA

CE2 ENGINEERS, INC.
PO BOX 22946 ANCHORAGE, AK 99523 PH 907-345-0101 FAX 907-345-1015

REVISION	BY	DATE

Project No.	JUNE 2009
Date	LAP
Designed	CM
Drawn	LAP
Approved	

Sheet No. G3.3

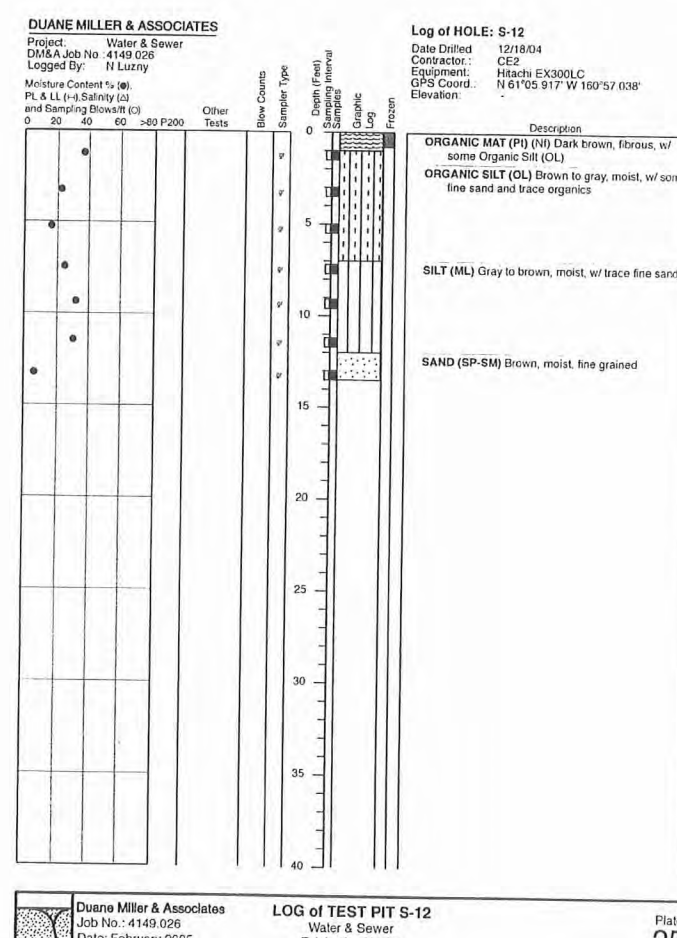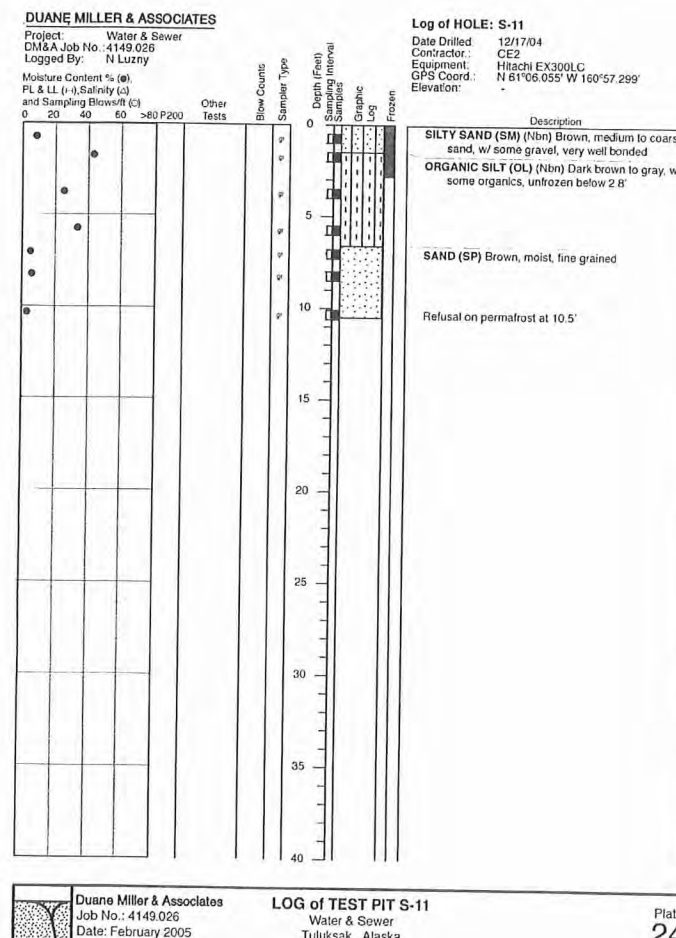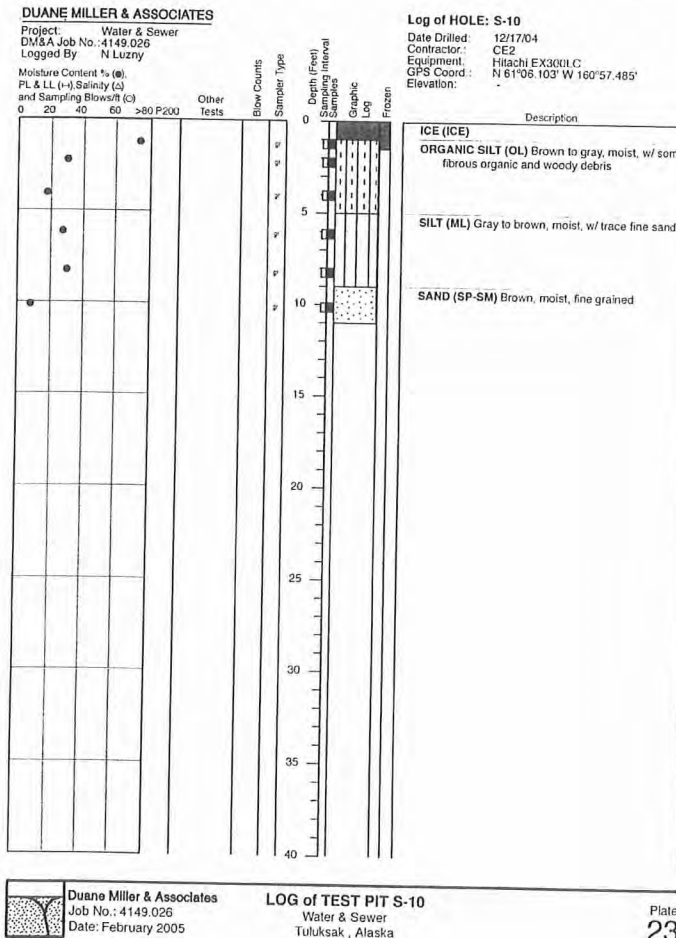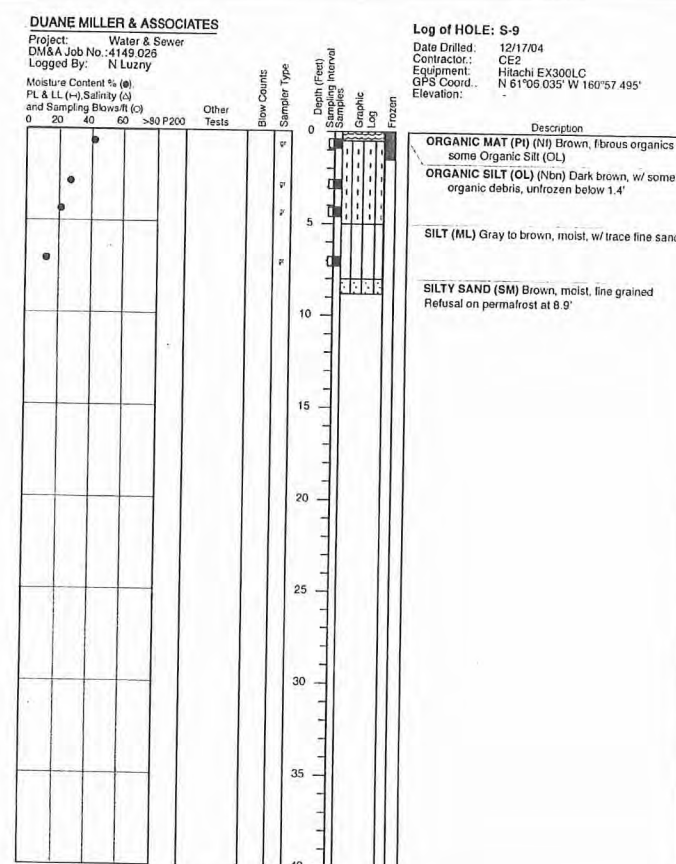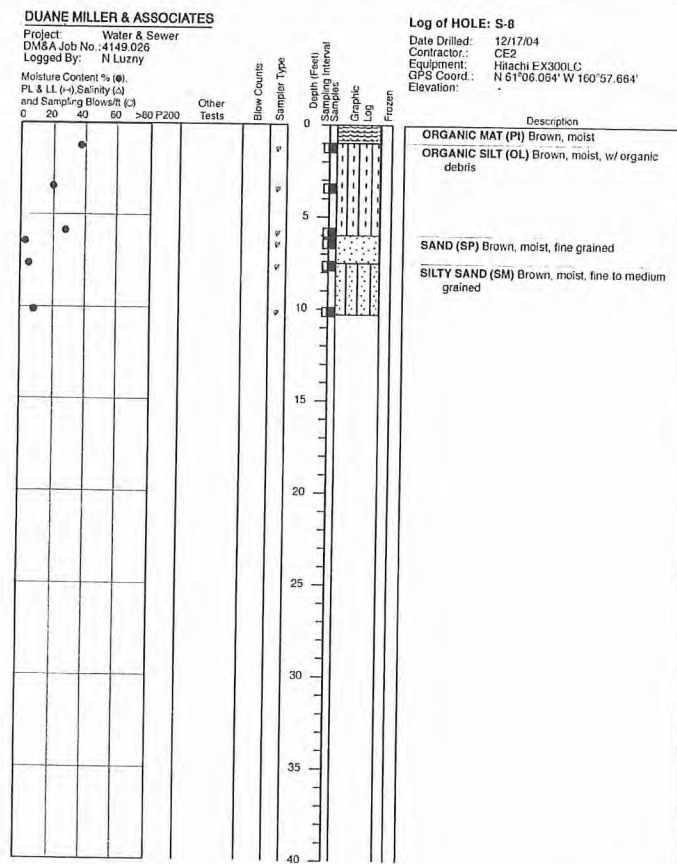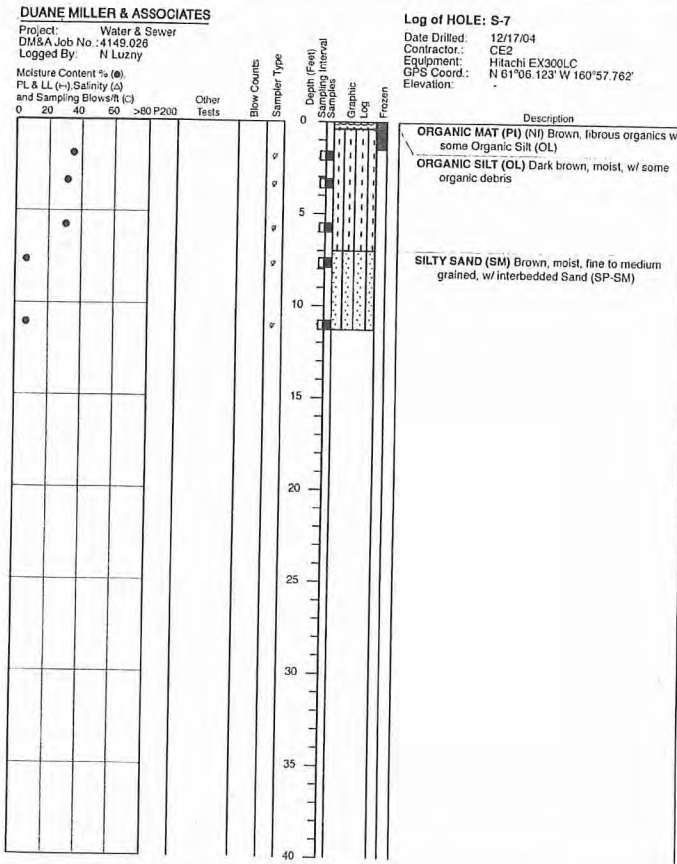

RECORD DRAWING CERTIFICATE
THESE DRAWINGS REFLECT RECORDED INFORMATION OBTAINED DURING CONSTRUCTION. INFORMATION PROVIDED HEREIN IS ACCURATE TO THE BEST OF MY KNOWLEDGE.

SCALE: 1" = 10' IF NOT ONE INCH ON THE SHEET, ADJUST SCALES ACCORDINGLY




2010-11 WASTEWATER SYSTEM IMPROVEMENTS
TEST HOLE BORING LOGS
TULUKSAK, ALASKA

CE2 ENGINEERS, INC.
PO BOX 22806 ANCHORAGE, AK 99523 PH: 907-546-9000 FAX: 907-546-9015

Project No. _____ Date: JUNE 2009
Designed: LAP
Drawn: CM
Approved: LAP

Sheet No. G3.4

NAME _____ DATE _____

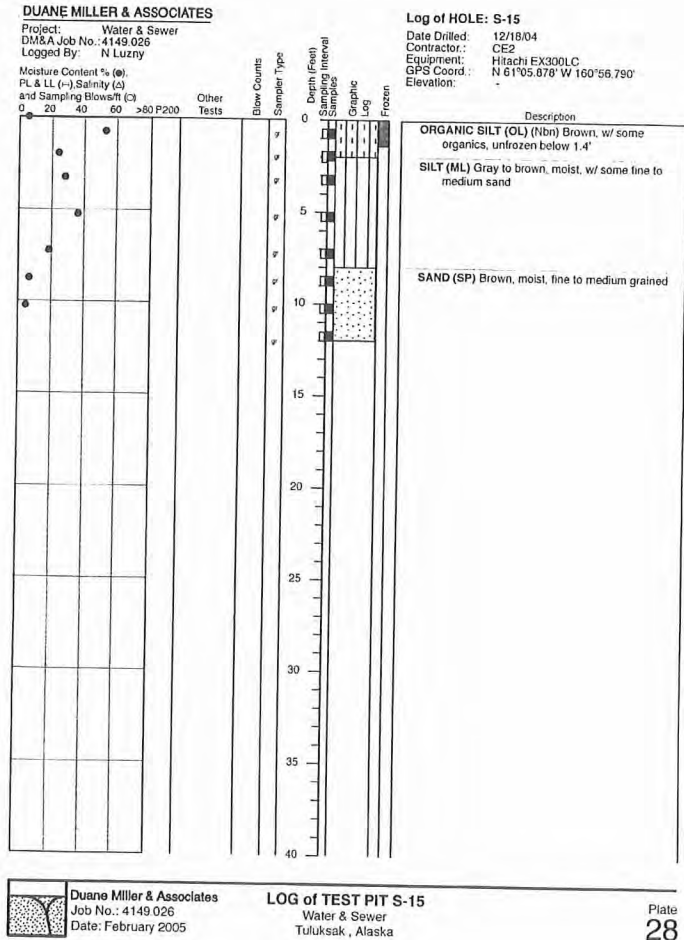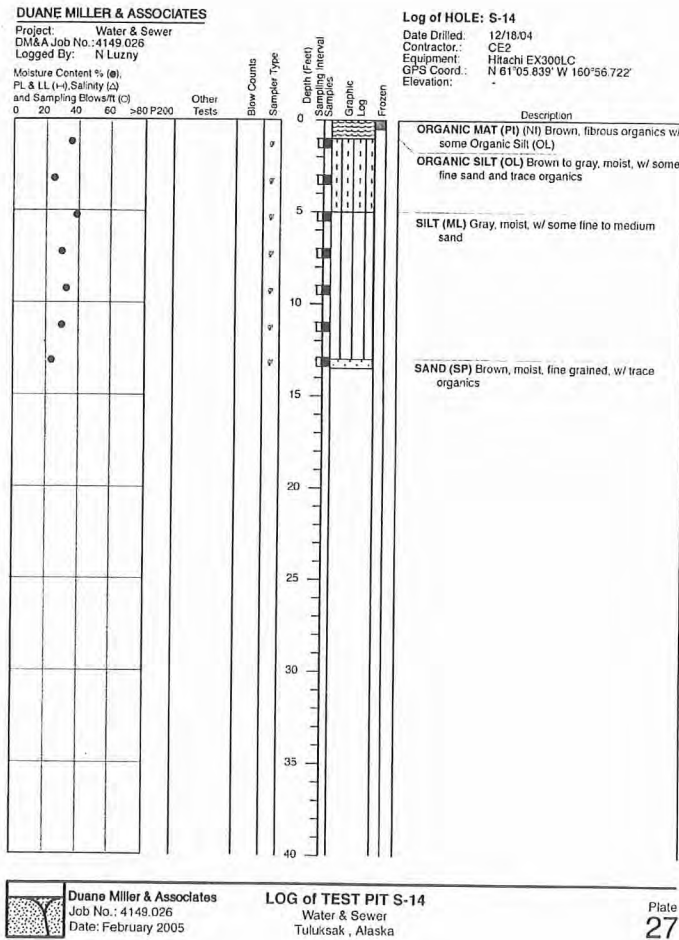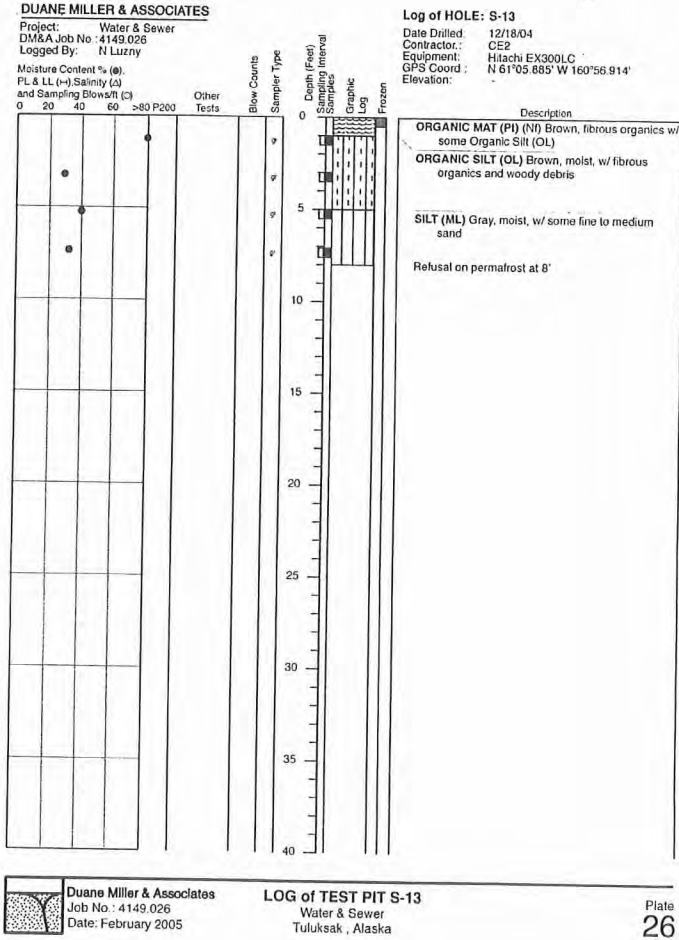

REVISION	BY	DATE

Project No.	
Date	JUNE 2009
Designed	LAP
Drawn	CM
Approved	LAP

Sheet No.
G3.5










2010-11 WASTEWATER
SYSTEM IMPROVEMENTS
TEST HOLE
BORING LOGS
TULUKSAK, ALASKA



SCALE:
BAR SCALE INCHES
ORIGINAL DRAWING
1" = 10' (NOT ONE INCH FOR ALL SCALES ACCORDINGLY)

RECORD DRAWING CERTIFICATE
THESE DRAWINGS REFLECT RECORDED INFORMATION OBTAINED DURING CONSTRUCTION. INFORMATION PROVIDED HEREIN IS ACCURATE TO THE BEST OF MY KNOWLEDGE.
NAME
DATE

G:\ACAD\TULUKSAK\TLT0901 2008 Waste water disposal area\G3.6 TO G3.10.dwg, 4/11/2011 1:05:10 PM, Flash, LANIER MP C2050_LD520C PCL 6BLK WHIT pc3

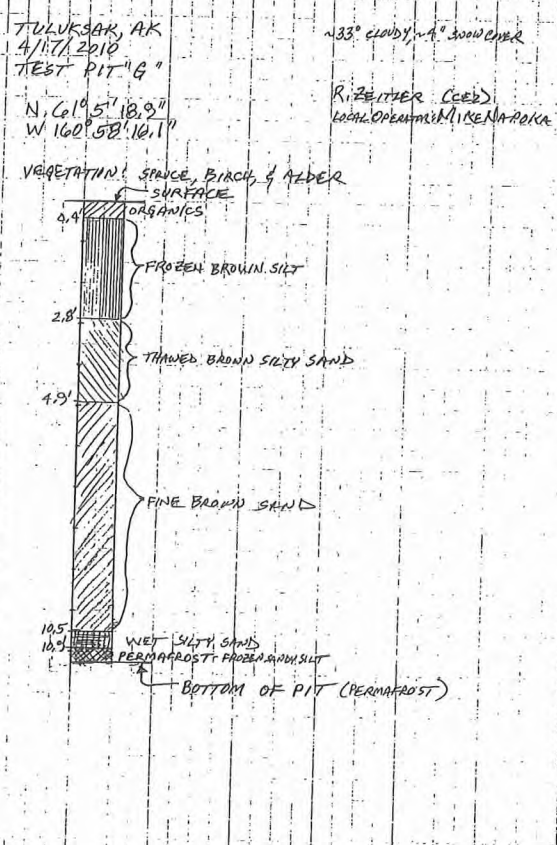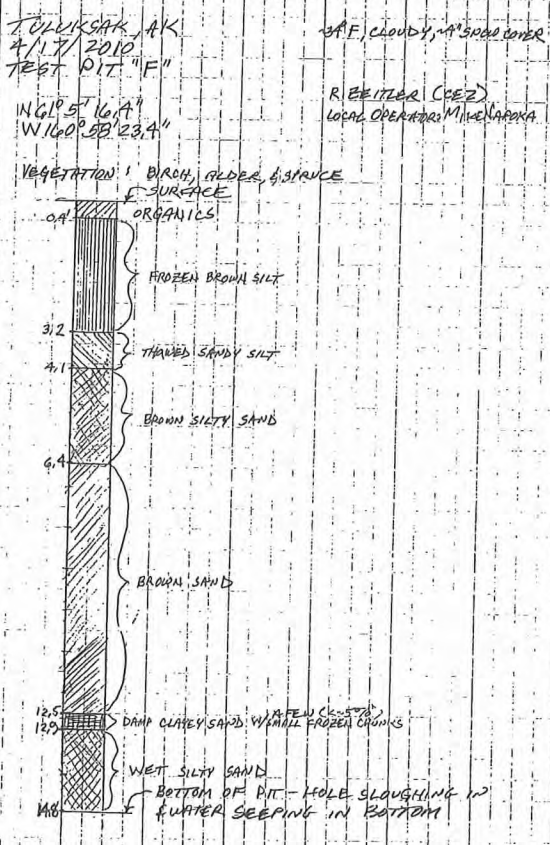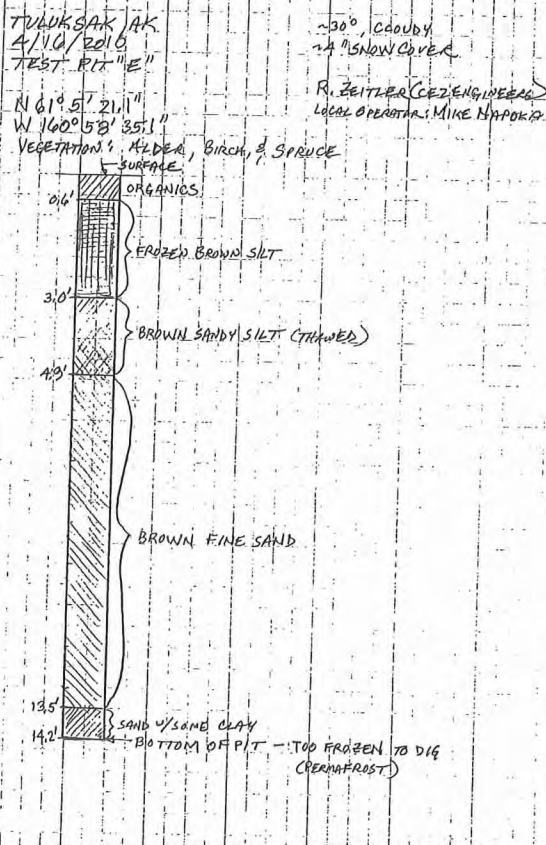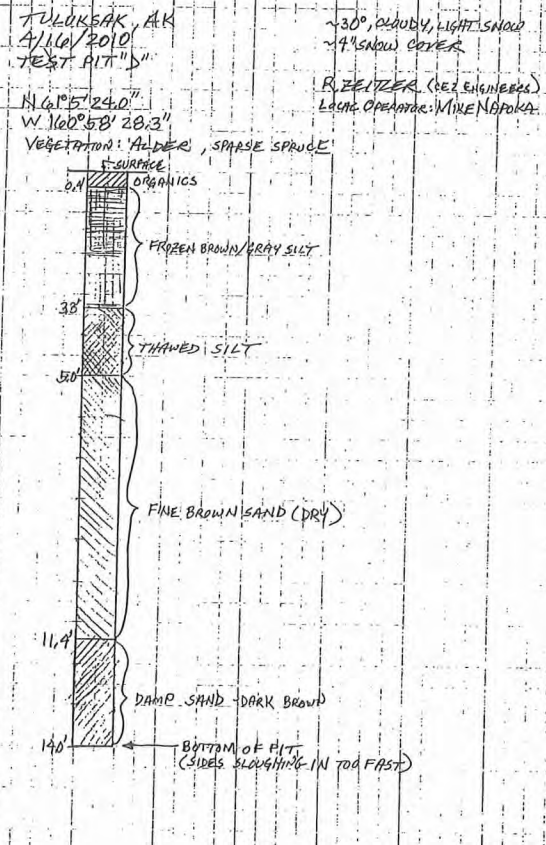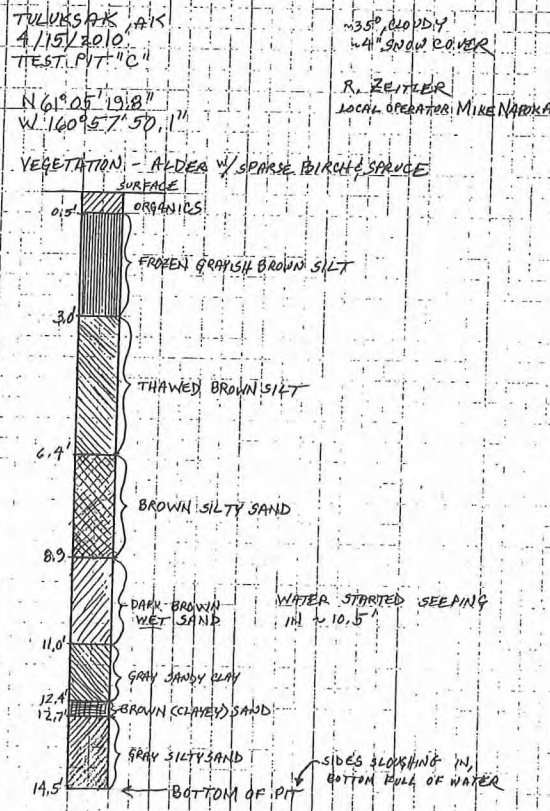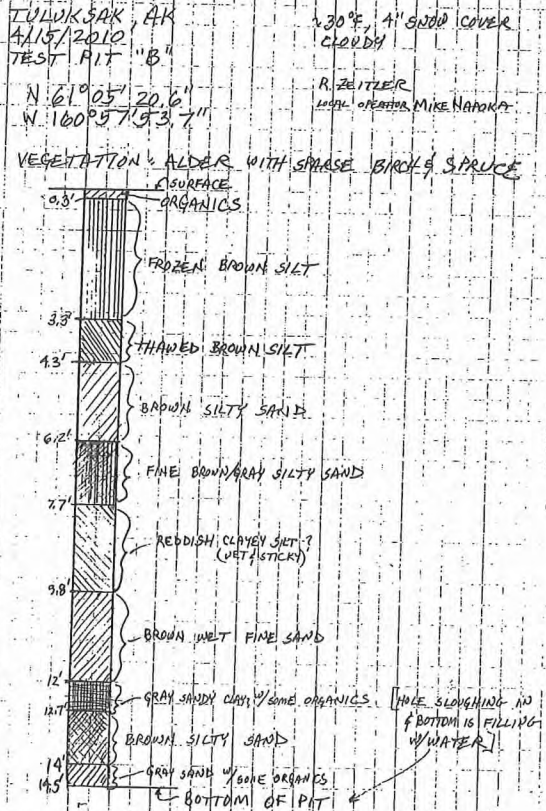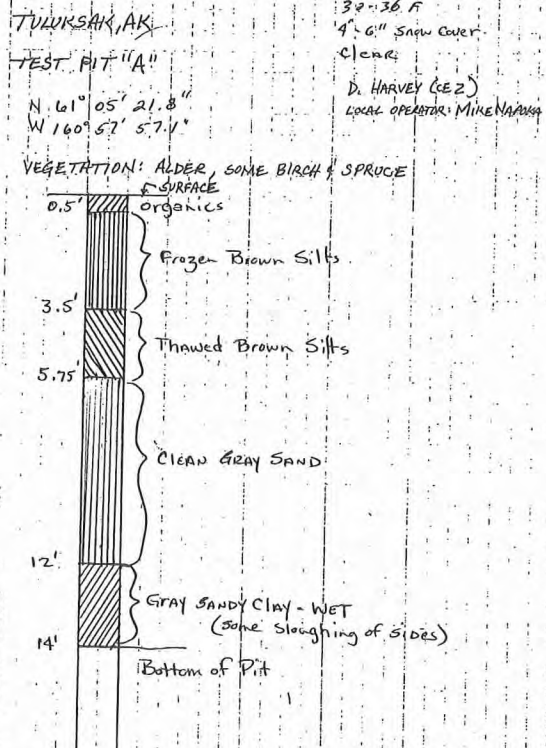

RECORD DRAWING CERTIFICATE

THESE DRAWINGS REFLECT RECORDED INFORMATION OBTAINED DURING CONSTRUCTION. INFORMATION PROVIDED HEREIN IS ACCURATE TO THE BEST OF MY KNOWLEDGE.

NAME _____ DATE _____

SCALE:

1" = 10'

IF NOT ONE INCH ON THIS SHEET, ADJUST SCALES ACCORDINGLY

WASTE WATER

SAFE WATER

WASTE WATER

STATE OF ALASKA

49th

Professional Engineer

NO. 0000000000

EXPIRATION DATE 12/31/2011

REGISTERED PROFESSIONAL

2010-11 WASTEWATER SYSTEM IMPROVEMENTS

TEST HOLE BORING LOGS

TULUKSAK, ALASKA







CE2

ENGINEERS, INC.

PO BOX 222046 ANCHORAGE, AK 99523 PH 907-546-1010 FAX 907-546-0105

Project No.	Date	Designed	Drawn	Approved
	JUNE 2009	LAP	CM	LAP

Sheet No. G3.6

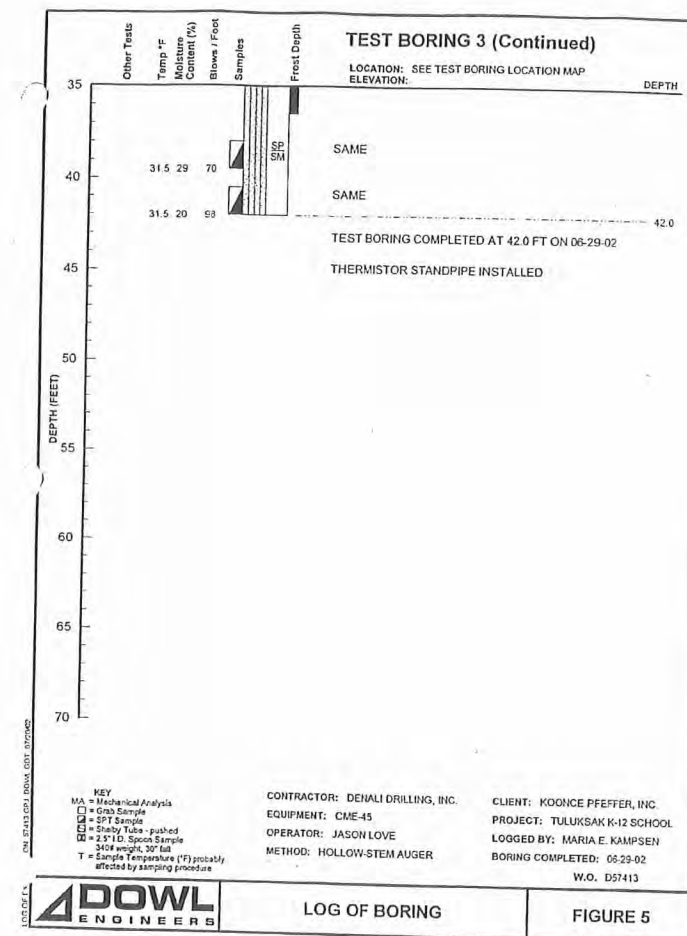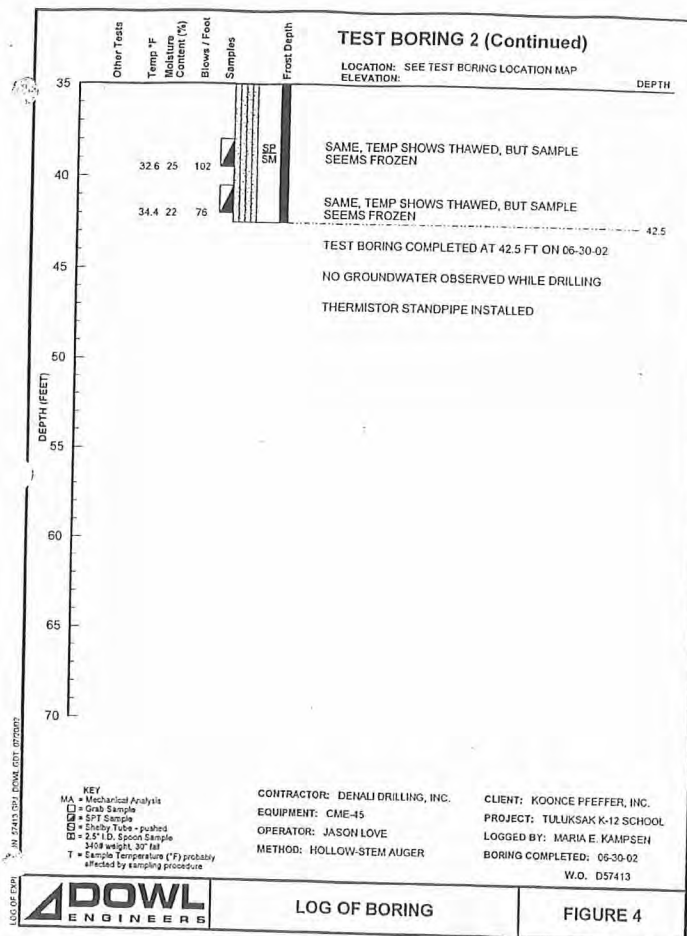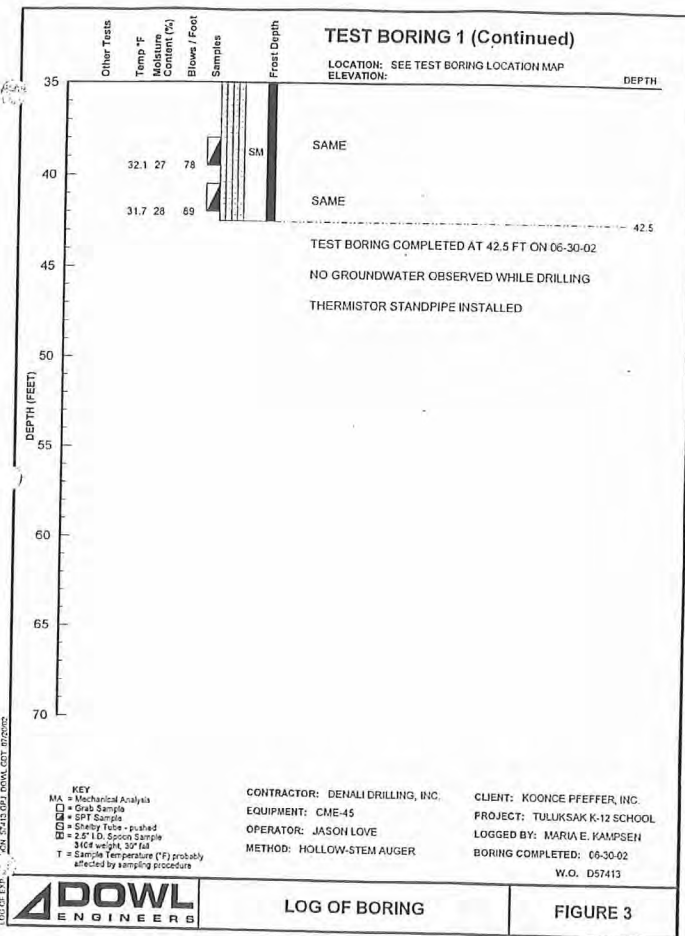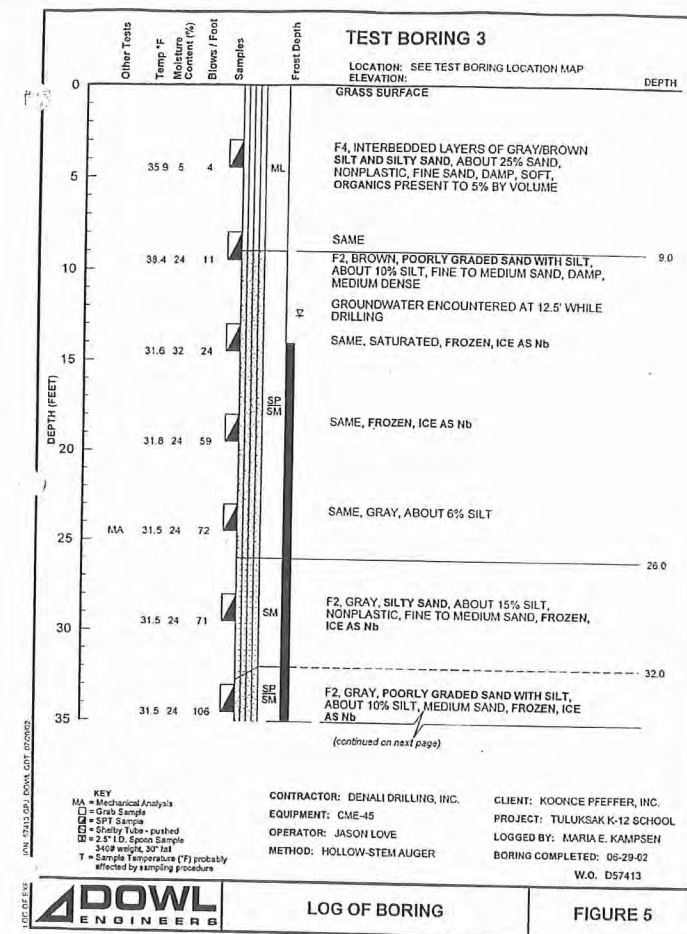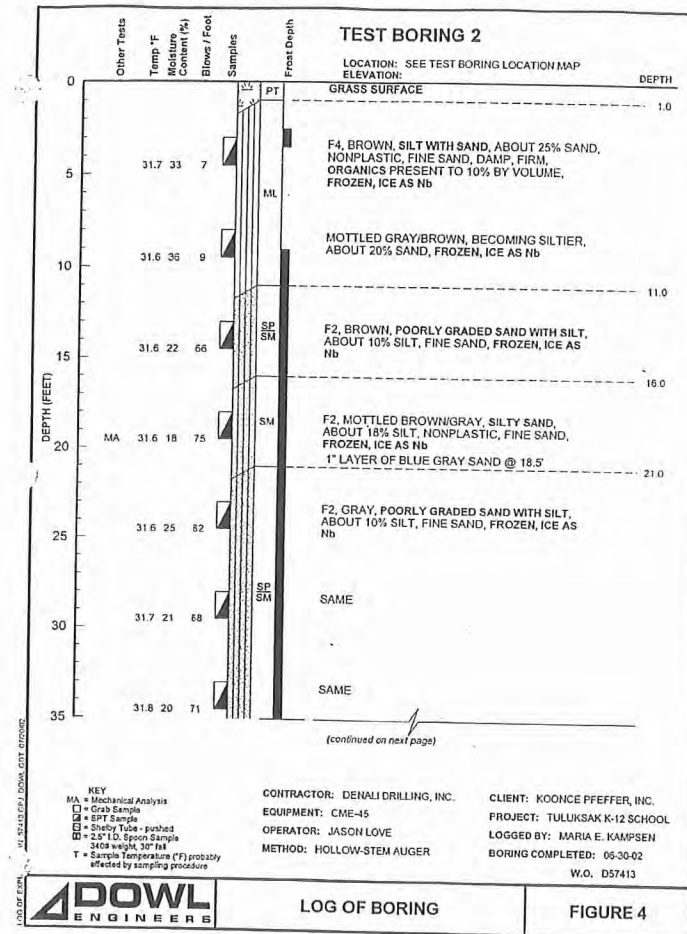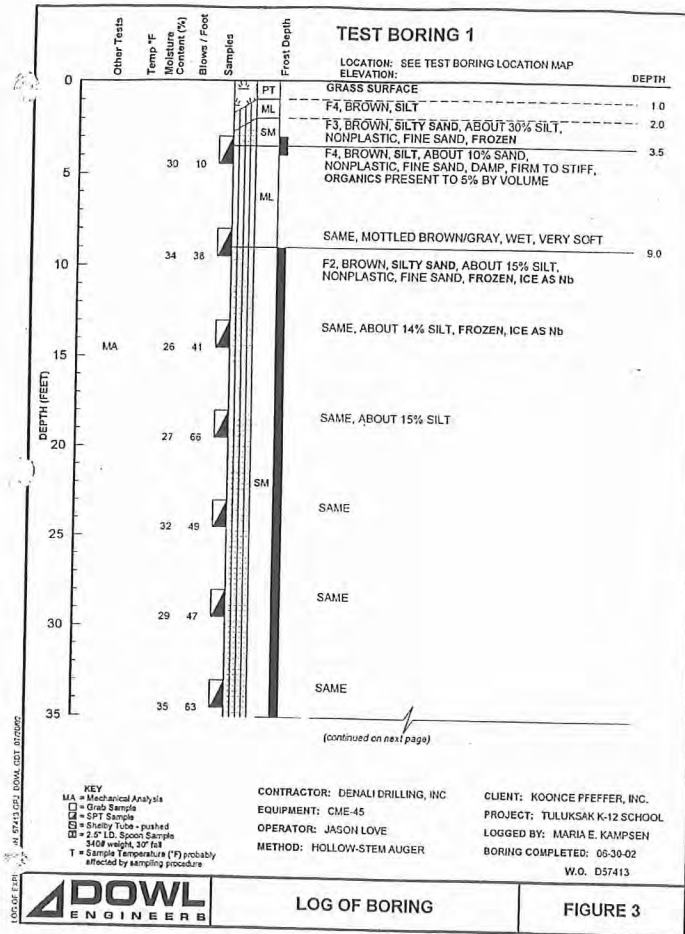

RECORD DRAWING CERTIFICATE
THESE DRAWINGS REFLECT RECORDED INFORMATION OBTAINED DURING CONSTRUCTION. INFORMATION PROVIDED HEREIN IS ACCURATE TO THE BEST OF MY KNOWLEDGE.

SCALE: 1" = 10' (NOT ONE INCH ON ORIGINAL DRAWING)
IF NOT ONE INCH ON THIS SHEET, ADJUST SCALES ACCORDINGLY

NAME _____ DATE _____

2010-11 WASTEWATER SYSTEM IMPROVEMENTS
TEST HOLE BORING LOGS
TULUKSAK, ALASKA







CME2 ENGINEERS, INC.
PO BOX 222046 ANCHORAGE, AK 99523 PH 907-546-0010 FAX 907-546-0015

REVISION	BY	DATE

Project No.	Date	Designed	LAP	Drawn	CM	Approved	LAP
	JUNE 2009						

Sheet No. **G3.7**

G:\ACAD\TULUKSAK\T0901 2008 Waste water disposal area\G3.6 TO G3.10.dwg, 1/11/2011 1:05:33 PM, Flash, LANIER MP C2050_LD520C PCL 6BLK WHIT .pc3

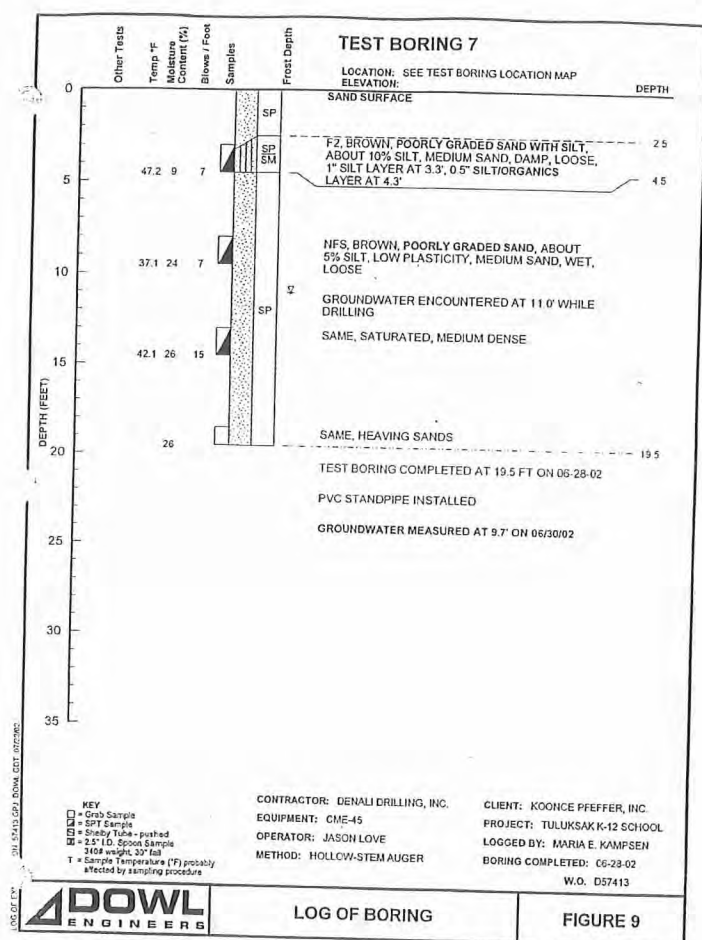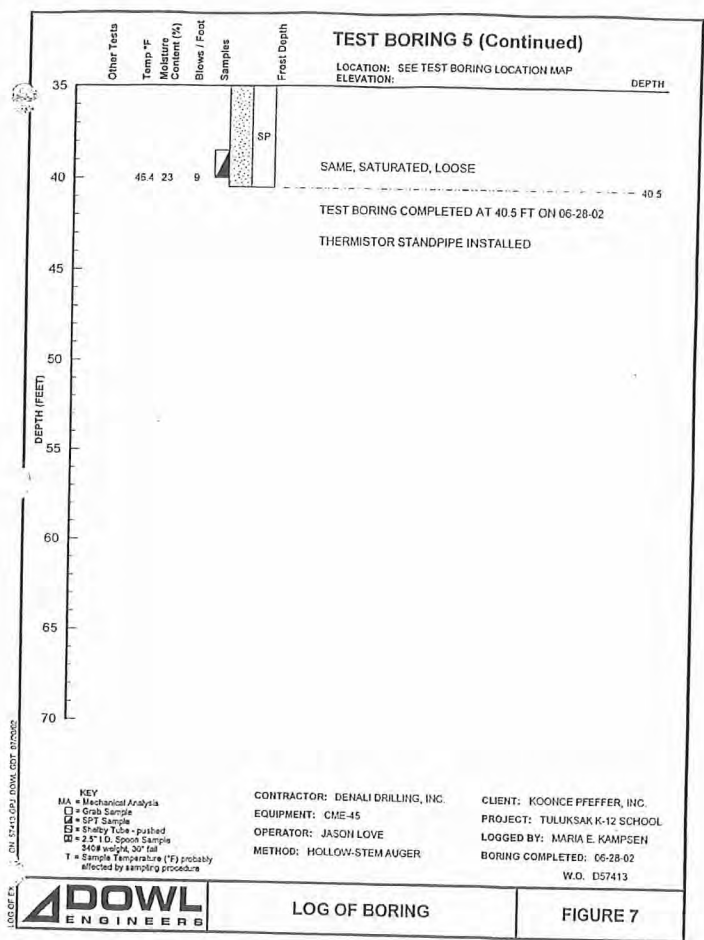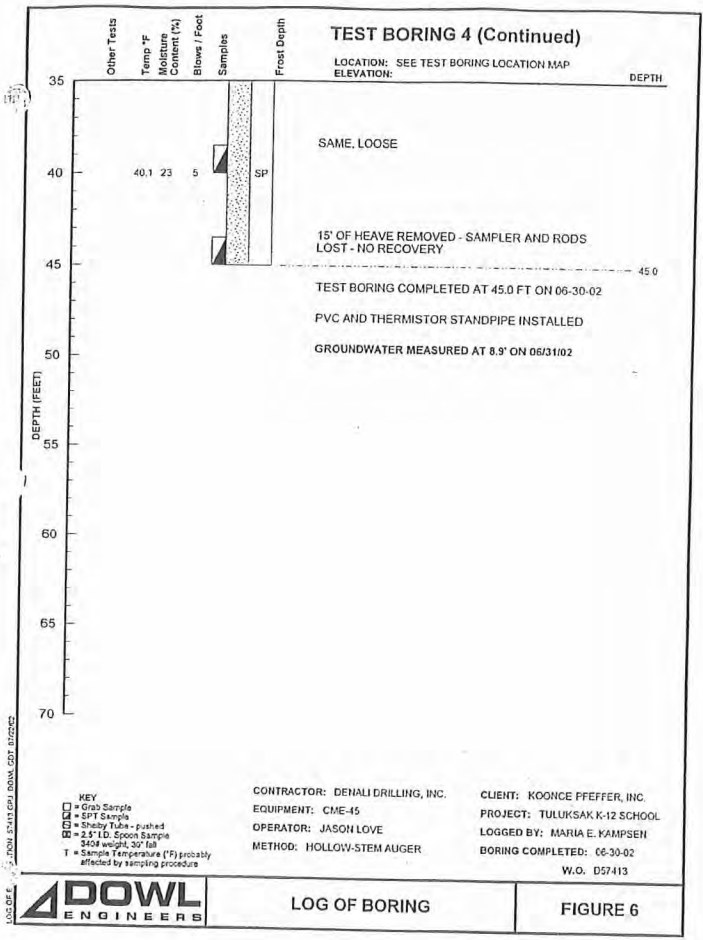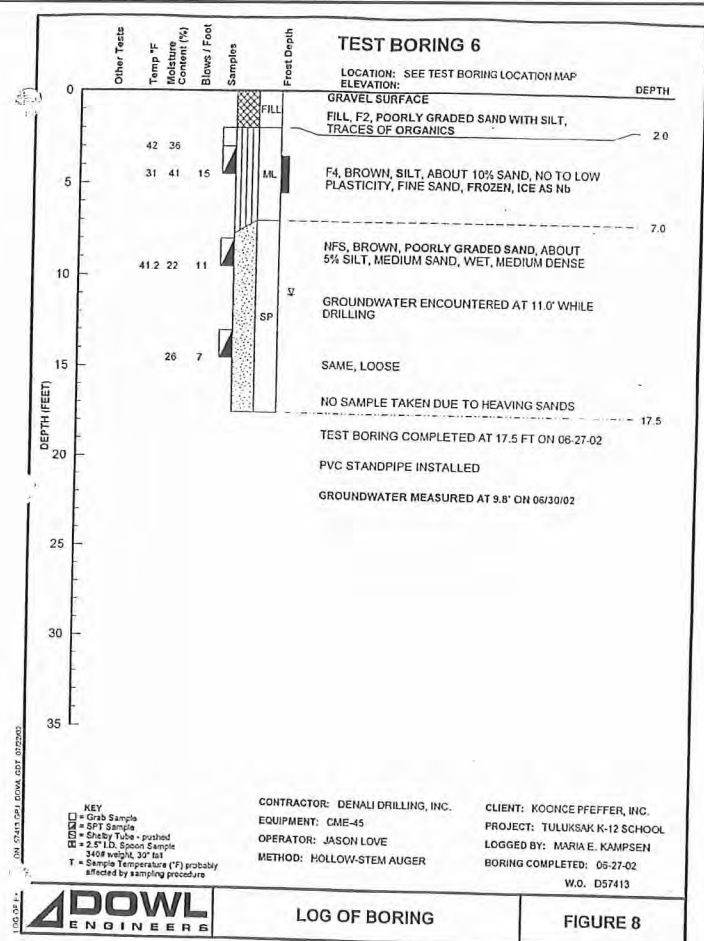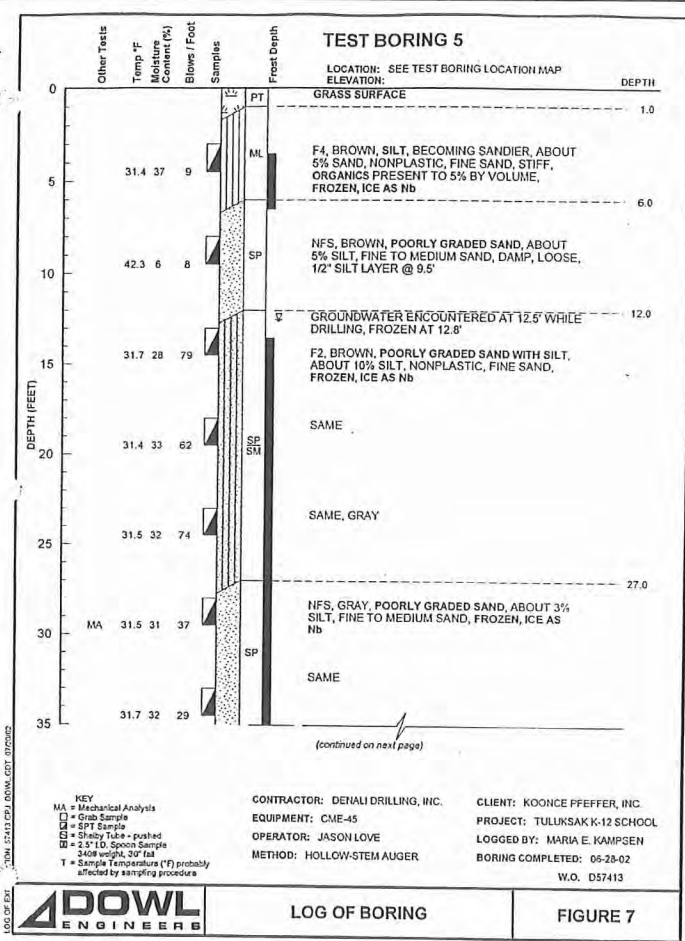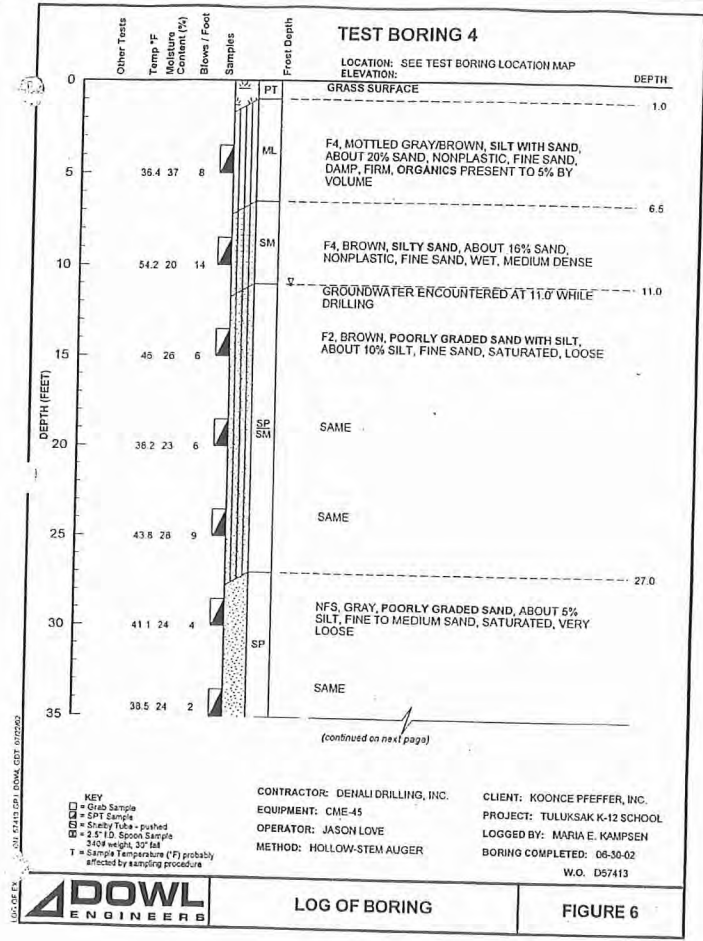

RECORD DRAWING CERTIFICATE

THESE DRAWINGS REFLECT RECORDED INFORMATION OBTAINED DURING CONSTRUCTION. INFORMATION PROVIDED HEREIN IS ACCURATE TO THE BEST OF MY KNOWLEDGE.

SCALE: 1" = 10'-0"

DATE: _____

NAME: _____

2010-11 WASTEWATER SYSTEM IMPROVEMENTS

TEST HOLE BORING LOGS

TULUKSAK, ALASKA

CME2 ENGINEERS, INC.




PO BOX 223946 ANCHORAGE, AK 99523 PH 907-346-0101 FAX 907-346-0105

REVISION	BY	DATE

Project No.	Date	Designed	LAP
		Drawn	CM
		Approved	LAP

Sheet No.

G3.8

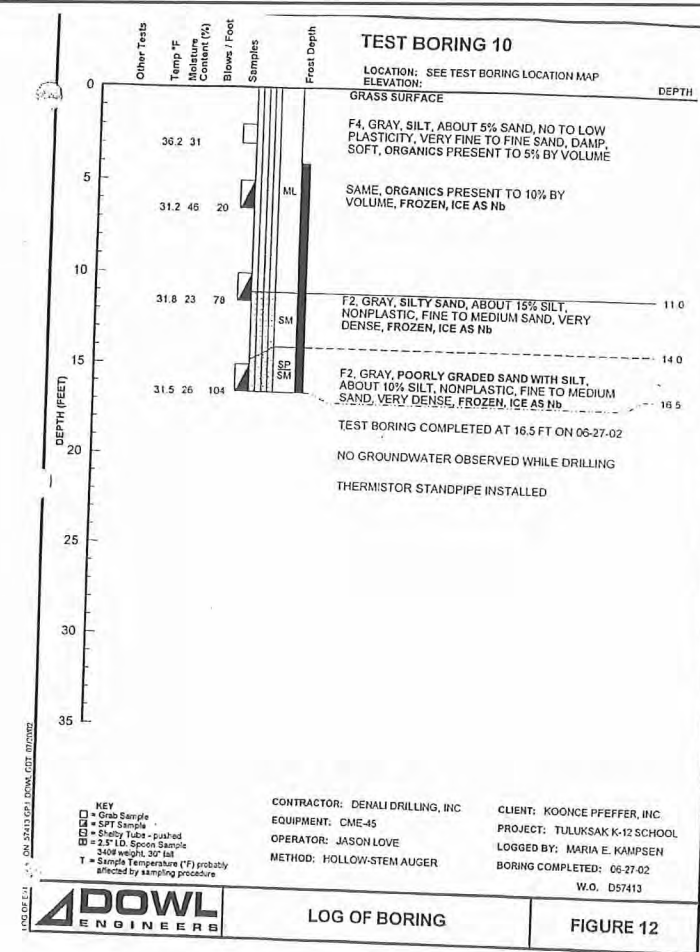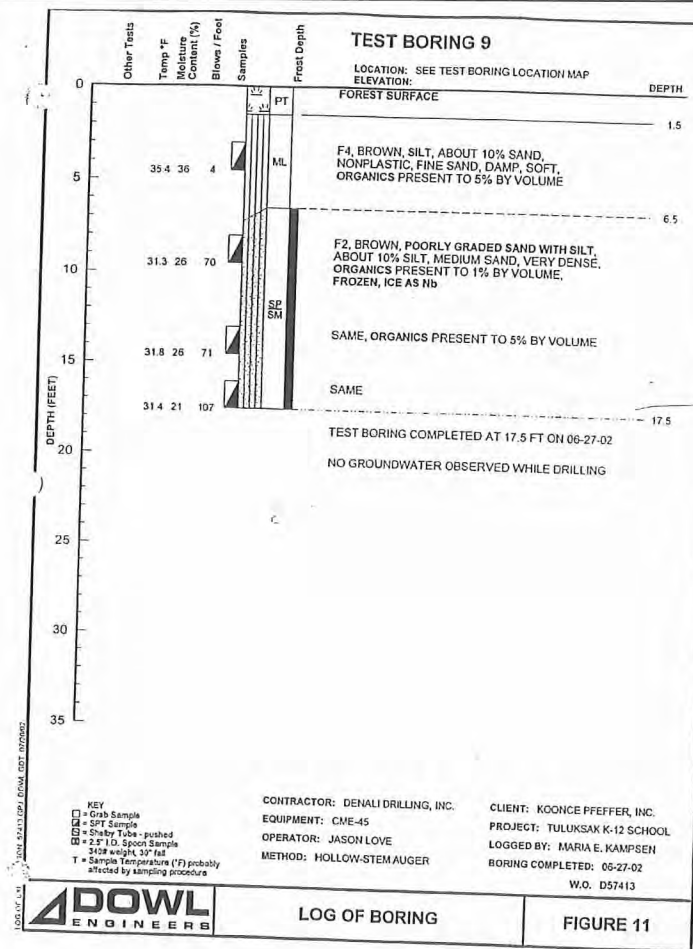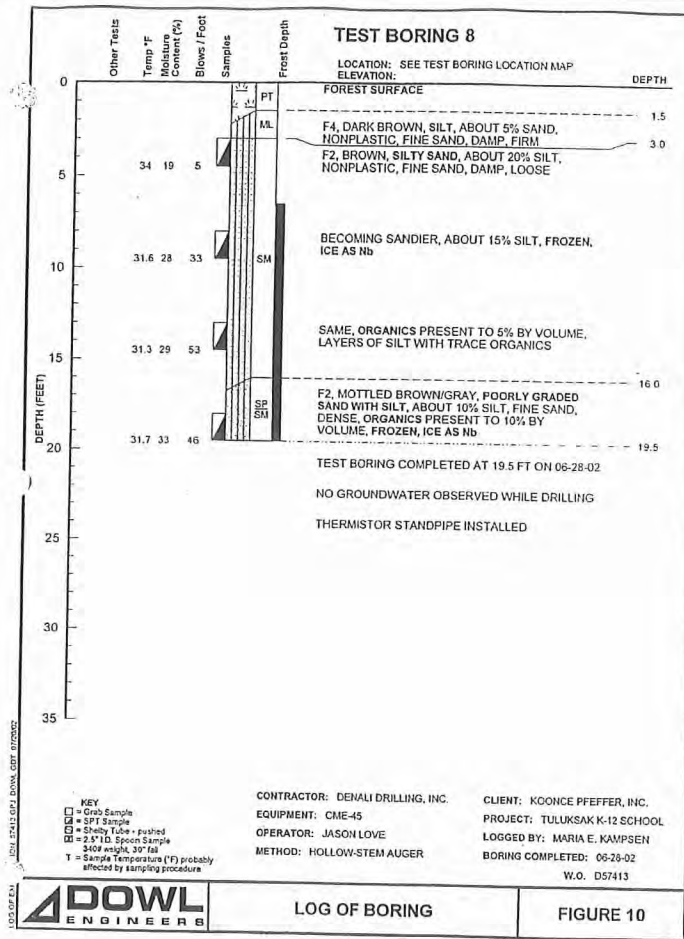

PT-1

SOIL PROFILE/PERCOLATION TEST DATA FORM

Property Location: Tuluksak Wastewater Lagoon Site - Percolation/Storage Cell

Test Pit Number and Location: Test Pit No. 1, N 61°05'31.3", W 160°57'13.9", excavated and monitoring tube set 10/20/2007

Elevations: Existing Ground 18.93'
Bottom/Top of Sand 13.25'
3/6/08 No water noted in test hole to Elev. 7' (12' below existing ground)

Soil Profile: Depth (inches) 0 - 12"
12" - 68"
68" -
Soil Texture Organic Overburden (Pt), fibrous
Organic silt (OL) and Silty Sand (SM) Mixture, dry
Poorly graded clean fine sand (SP)

No groundwater encountered

Time	Time Interval (Minutes)	End of Period Measurement (Feet)	Start of Period Measurement (Feet)	Drop in Water Level (Feet)	Percolation Rate (Hrs/Feet)	Remarks
6:48			6.30			Start soaking period.
7:04	0:16	6.37	6.37	0.07	3.48	Start percolation test. Water level 12" above bottom of hole.
7:19	0:15	6.62	6.30	0.25	1:00	
7:34	0:15	6.50	6.32	0.20	1:15	
7:49	0:15	6.54	6.22	0.22	1:08	
8:04	0:15	6.46	6.40	0.24	1:02	
8:20	0:16	6.63	6.37	0.23	1:09	
8:35	0:15	6.61	6.41	0.24	1:02	
8:50	0:15	6.63	6.38	0.22	1:08	
9:05	0:15	6.62		0.24	1:02	End of Test.

Percolation rate = 5.2 minutes per inch

Date of test March 6, 2008 Percolation test by: Lloyd Persson, P.E.

** 6/10/08 Water Elev. measured above sand at 14.59' (seasonal high groundwater).

PT-2

SOIL PROFILE/PERCOLATION TEST DATA FORM

Property Location: Tuluksak Wastewater Lagoon Site - Percolation/Storage Cell

Test Pit Number and Location: Test Pit No. 2, N 61°05'31.7", W 160°57'12.2", excavated and monitoring tube set 10/20/2007

Elevations: Existing Ground 22.41'
Bottom/Top of Sand 15.95'
3/6/08 No water noted in test hole to Elev. 10.4' (12' below existing ground)

Soil Profile: Depth (inches) 0 - 12"
12" - 82"
82" -
Soil Texture Organic Overburden (Pt), fibrous
Organic silt (OL) and Silty Sand (SM) Mixture, dry
Poorly graded clean fine sand (SP)

No groundwater encountered

Time	Time Interval (Minutes)	End of Period Measurement (Feet)	Start of Period Measurement (Feet)	Drop in Water Level (Feet)	Percolation Rate (Hrs/Feet)	Remarks
6:55			6.05			Start soaking period.
7:10	0:15	6.30	5.70	0.25	1:00	Start percolation test. Water level 12" above bottom of hole.
7:25	0:15	5.85	5.85	0.15	1:40	
7:43	0:18	6.05	6.05	0.20	1:30	
7:58	0:15	6.18	5.95	0.13	1:53	
8:13	0:15	6.07	6.07	0.12	2:05	
8:28	0:15	6.20	6.10	0.13	1:55	
8:43	0:15	6.21	5.92	0.11	2:16	
8:58	0:15	6.06		0.14	1:47	End of Test.

Percolation rate = 10 minutes per inch

Date of test March 6, 2008 Percolation test by: Lloyd Persson, P.E.

PT-3

SOIL PROFILE/PERCOLATION TEST DATA FORM

Property Location: Tuluksak Wastewater Lagoon Site - Percolation/Storage Cell

Test Pit Number and Location: Test Pit No. 3, N 61°05'32.2", W 160°57'14.7", excavated and monitoring tube set 10/20/2007

Elevations: Existing Ground 21.81'
Bottom/Top of Sand 14.95'
3/6/08 No water noted in test hole to Elev. 7'-8" (Excavated to 11' below existing ground and found no water.)

Soil Profile: Depth (inches) 0 - 12"
12" - 64"
64" -
Soil Texture Organic Overburden (Pt), fibrous
Organic silt (OL) and Silty Sand (SM) Mixture, dry
Poorly graded clean fine sand (SP)

No groundwater encountered

Time	Time Interval (Minutes)	End of Period Measurement (Feet)	Start of Period Measurement (Feet)	Drop in Water Level (Feet)	Percolation Rate (Hrs/Feet)	Remarks
7:01			6.65			Start soaking period.
7:16	0:15	7.65	6.65	1.00	0:15	Start percolation test. Water level 12" above bottom of hole.
7:31	0:15	7.70	6.50	1.05	0:14	
7:46	0:15	7.55	6.58	1.05	0:14	
8:01	0:15	7.52	6.62	0.94	0:15	
8:16	0:15	7.50	6.55	0.88	0:17	
8:31	0:15	7.43	6.60	0.88	0:17	
8:46	0:15	7.33	6.55	0.73	0:20	
9:01	0:15	7.36		0.81	0:18	End of Test.

Percolation rate = 1.5 minutes per inch

Date of test March 6, 2008 Percolation test by: Lloyd Persson, P.E.

** 6/10/08 Water Elev. measured above sand at 14.95' (seasonal high groundwater).

RECORD DRAWING CERTIFICATE

THESE DRAWINGS REFLECT RECORDED INFORMATION OBTAINED DURING CONSTRUCTION. INFORMATION PROVIDED HEREIN IS ACCURATE TO THE BEST OF MY KNOWLEDGE.

SCALE: 1" = 10' (AS SHOWN ON THIS SHEET, ADJUST SCALES ACCORDINGLY)

DATE _____ NAME _____

ILLUSTRATION: WATER

49 TH

2010-11 WASTEWATER SYSTEM IMPROVEMENTS

TEST HOLE BORING LOGS

TULUKSAK, ALASKA

CME2 ENGINEERS, INC.

PO BOX 22394 ANCHORAGE, AK 99523 PH: 907-949-0010 FAX: 907-949-0015

REVISION BY DATE

Project No. _____ Date JUNE 2009 Designed LAP Drawn CM Approved LAP

Sheet No. **G3.9**

G:\ACAD\TULUKSAK\T10901 2008 Waste water disposal area\C1.1 thru C1.4 and C2.9.dwg, 1/11/2011 1:11:26 PM, Flash, LANIER MP C2050_LD520C PCL 6BLK WHIT.p3



RECORD DRAWING CERTIFICATE
THESE DRAWINGS REFLECT RECORDED
INFORMATION OBTAINED DURING
CONSTRUCTION. INFORMATION PROVIDED
HEREIN IS ACCURATE TO THE BEST OF MY
KNOWLEDGE.

SCALE:
PLAN: 1"=20'
PROF: 1"=5'
SHEET: 1"=10'
ORIGINAL DRAWING
IF NOT ONE INCH ON
SHEET, SCALE ACCORDINGLY

2010-11 WASTEWATER
SYSTEM IMPROVEMENTS
S1 GRAVITY SEWER
PLAN AND PROFILE
TULUKSAK, ALASKA

Project No.	BY	DATE



REVISION	BY	DATE

Date	JUNE 2009
Designed	LAP
Drawn	LAW
Approved	LAP

Sheet No.
C1.1


NAME
DATE

G:\ACAD\TULUKSAK\TLT0901 2008 Waste water disposal area\C1.1 thru C1.4 and C2.9.dwg, 1/11/2011 1:10:17 PM, Fish, LANIER MP C2050_LD520C PCL 6BLK WHIT,pc3

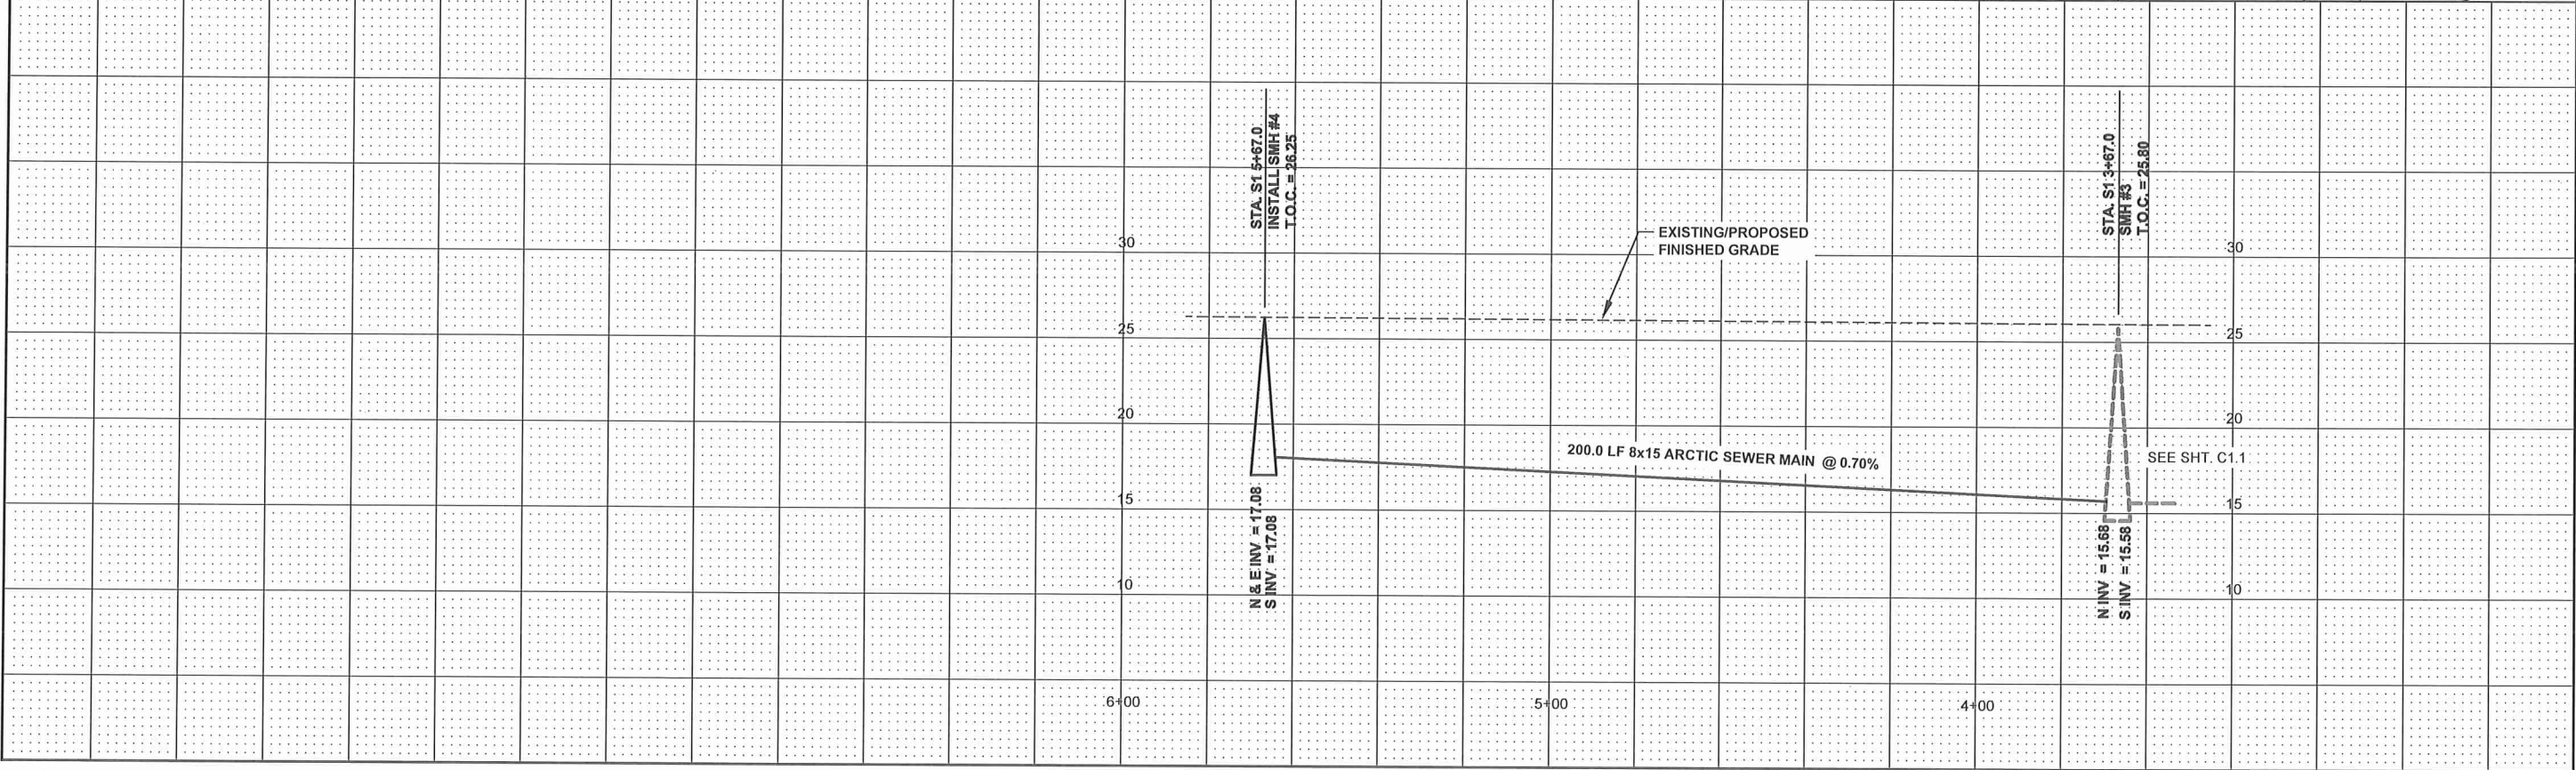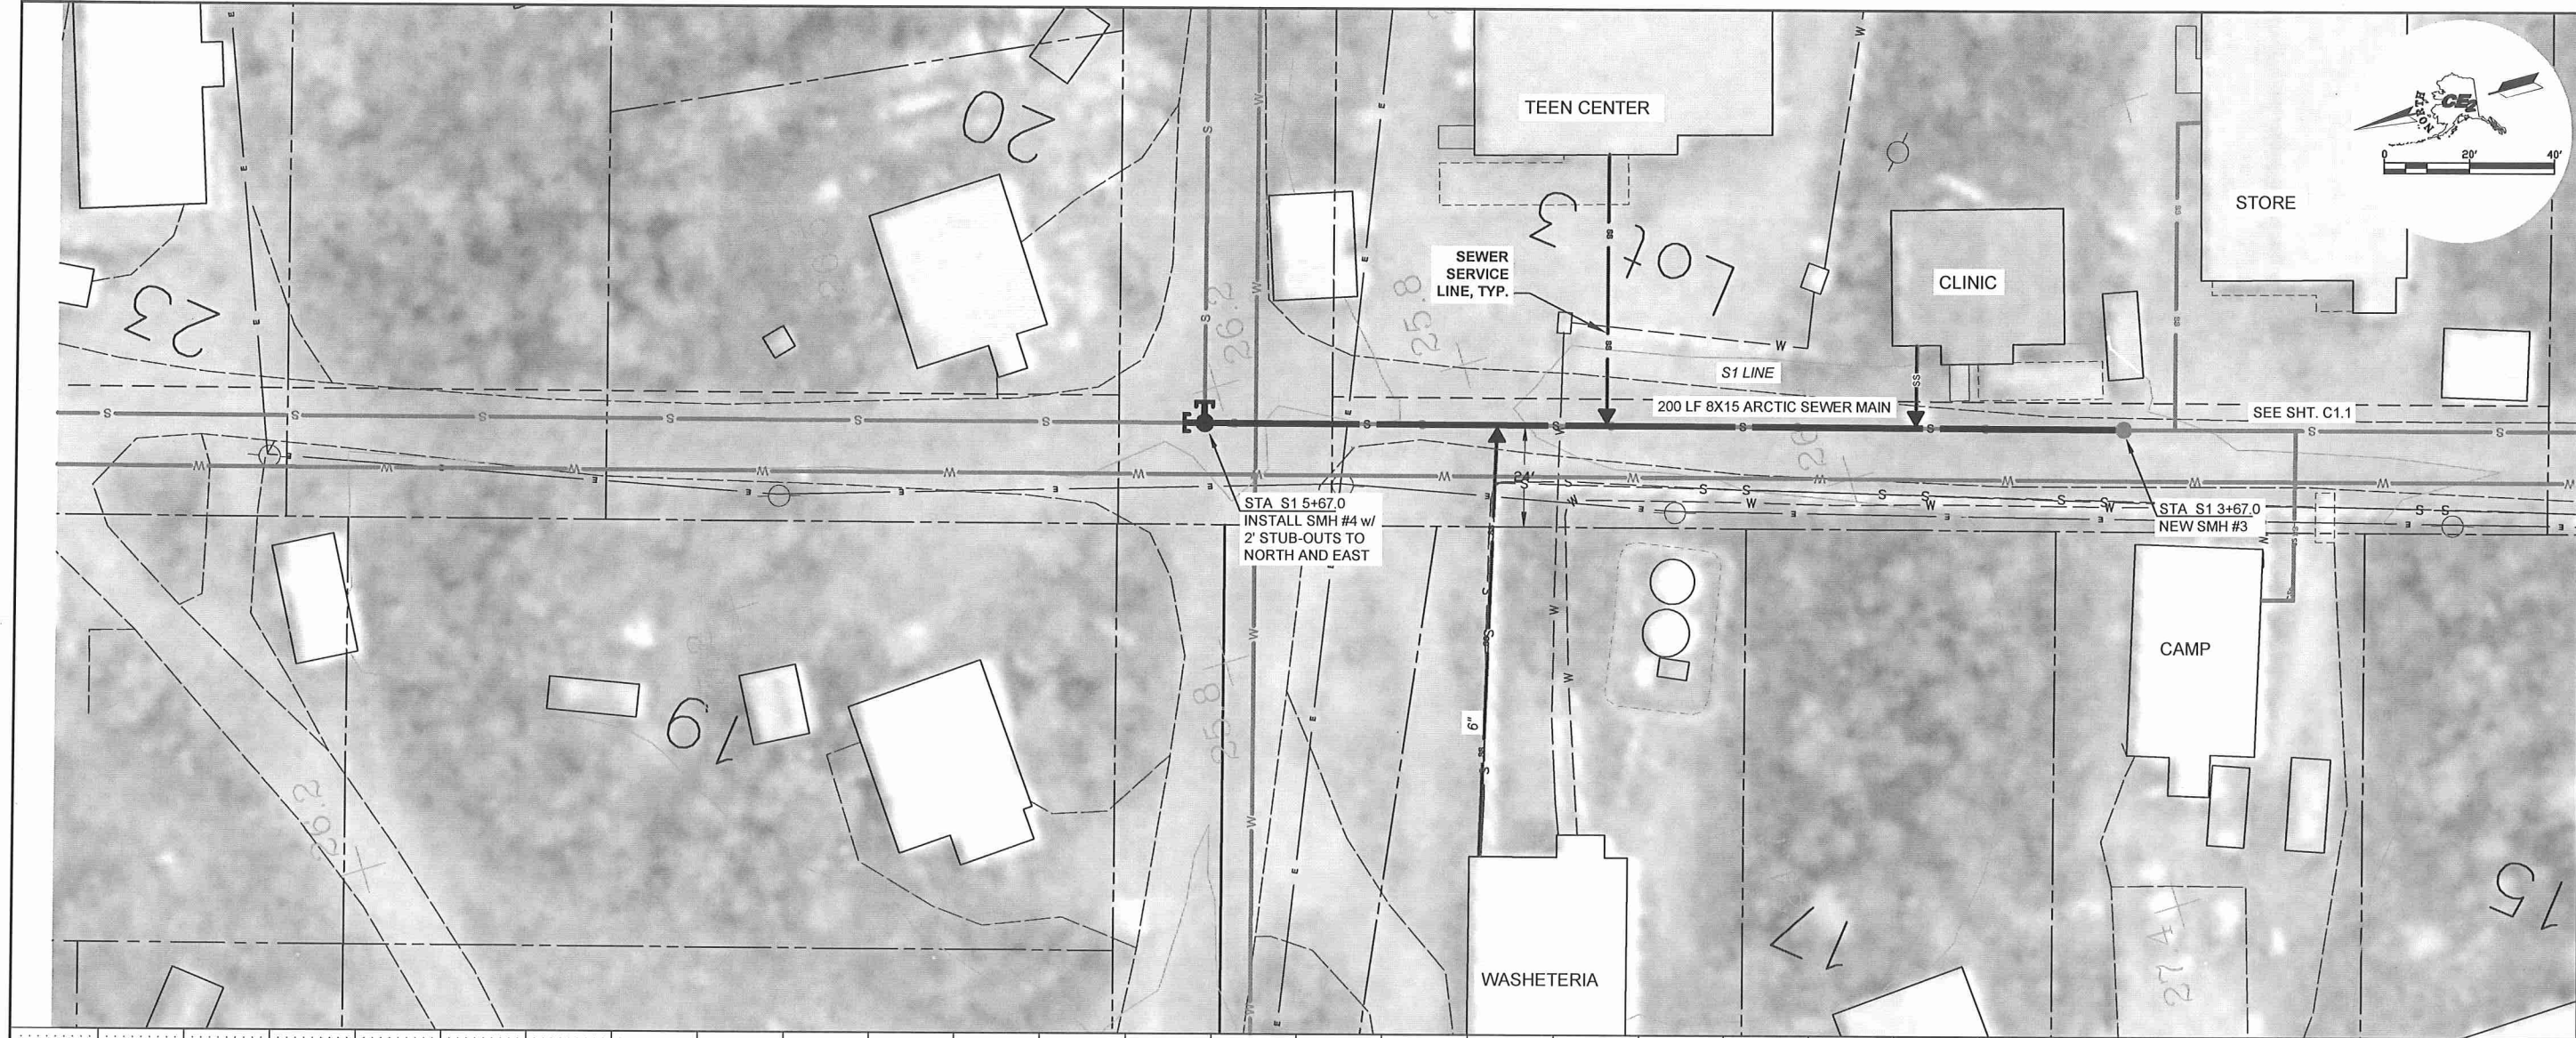

RECORD DRAWING CERTIFICATE
THESE DRAWINGS REFLECT RECORDED
INFORMATION OBTAINED DURING
CONSTRUCTION. INFORMATION PROVIDED
HEREIN IS ACCURATE TO THE BEST OF MY
KNOWLEDGE.

SCALE:
PLAN 1"=20'
PROF (V): 1"=5'
BASE & ONE INCH ON
ORIGINAL DRAWING
IF NOT ONE INCH ON
SCALE ACCORDINGLY

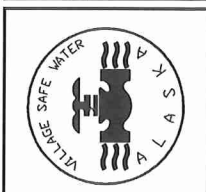


2010-11 WASTEWATER
SYSTEM IMPROVEMENTS
S1 GRAVITY SEWER
PLAN AND PROFILE
TULUKSAK, ALASKA



REVISION	BY	DATE

Project No.	Date	Designed	Drawn	Approved
	JUNE 2009	LAP	LAW	LAP
Sheet No.	C1.2			

G:\ACAD\TULUKSAK\T\T0901 2008 Waste water disposal area\C1.1 thru C1.4 and C2.9.dwg, 1/11/2011 1:09:21 PM, Flash, LANIER MP C2050_LD520C PCL 68LK WHIT,pc3

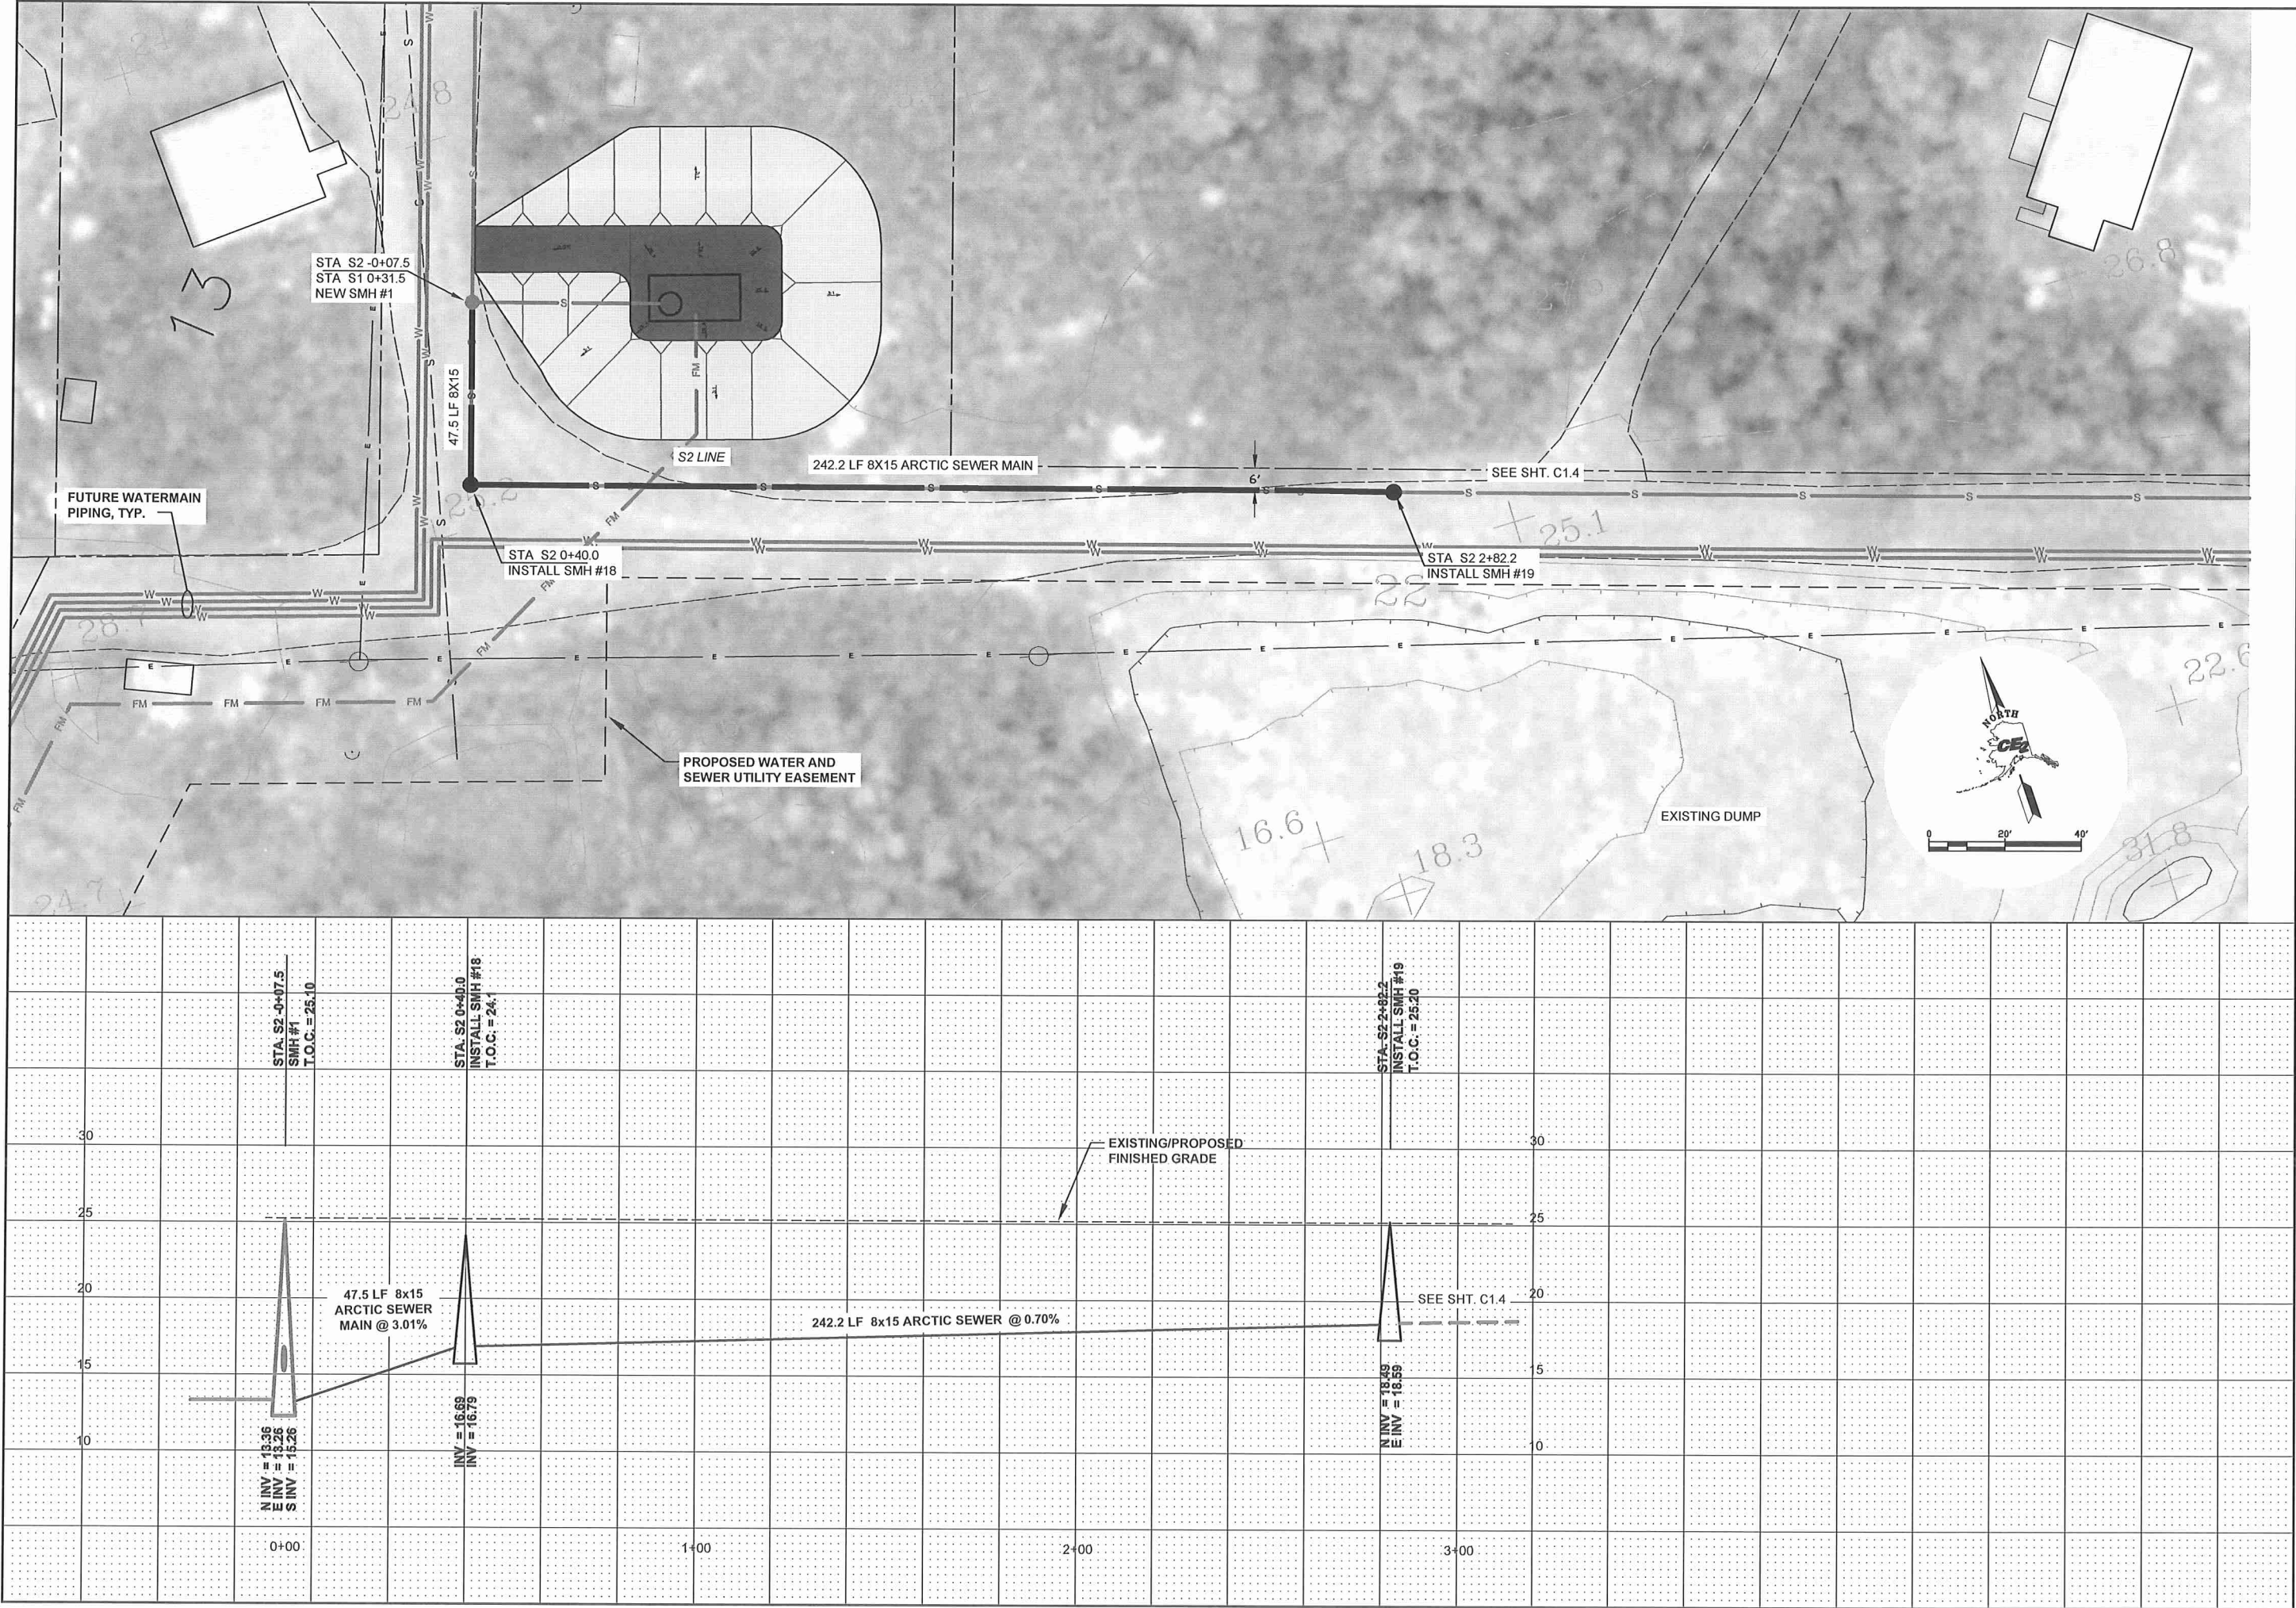

RECORD DRAWING CERTIFICATE
THESE DRAWINGS REFLECT RECORDED
INFORMATION OBTAINED DURING
CONSTRUCTION. INFORMATION PROVIDED
HEREIN IS ACCURATE TO THE BEST OF MY
KNOWLEDGE.

SCALE:
PLANT: 1"=20'
PROF: 1"=5'
BAR IS ONE INCH ON
ORIGINAL DRAWING
IF NOT ONE INCH ON
THIS SHEET, ADJUST
SCALES ACCORDINGLY



2010-11 WASTEWATER
SYSTEM IMPROVEMENTS
S2 GRAVITY SEWER
PLAN AND PROFILE
TULUKSAK, ALASKA



REVISION	BY	DATE

Project No.	JUNE 2009
Date	LAP
Designed	LAW
Drawn	LAP
Approved	LAP

Sheet No. C1.3

G:\ACAD\TULUKSAK\TLT0901 2008 Waste water disposal area\C1.1 thru C1.4 and C2.9.dwg, 1/11/2011 1:08:23 PM, Flash, LANIER MP C2050_LD520C PCL 6BLK WHIT, pc3



RECORD DRAWING CERTIFICATE

THESE DRAWINGS REFLECT RECORDED INFORMATION OBTAINED DURING CONSTRUCTION. INFORMATION PROVIDED HEREIN IS ACCURATE TO THE BEST OF MY KNOWLEDGE.

SCALE: PLAN: 1"=20' PROF: (H): 1"=20' (V): 1"=5' BAR IS ONE INCH ON ORIGINAL DRAWING

1" 0 1" IF ANY CASE, FOR THIS SHEET, ADJUST SCALES ACCORDINGLY

2010-11 WASTEWATER SYSTEM IMPROVEMENTS

S2 GRAVITY SEWER PLAN AND PROFILE

TULUKSAK, ALASKA

PROJECT No. _____ DATE _____

DESIGNED BY _____ LAP _____

DRAWN BY _____ LAW _____

APPROVED BY _____ LAP _____

SHEET No. C1.4

CE2 ENGINEERS, INC.



PO BOX 22346 ANCHORAGE, AK 99523 PH: 907-549-1001 FAX: 907-549-1015

G:\ACAD\TULUKSAK\TLT0901 2008 Waste water disposal area\C2.1_C2.8 ROAD AND FORCEMAIN P&P.dwg, 1/11/2011 1:22:38 PM, Flash, LANIER MP C2050_LD520C PCL 68LK WHIT.pcl3

SEQUENCE OF CONSTRUCTION

1. CLEAR CUT ALL BRUSH AND TREES WITHIN THE PROPOSED UTILITY PIPING AREA, LAGOON AND BORROW PIT AREAS AS REQUIRED OR DIRECTED BY THE ENGINEER. LIMB ALL TREES WITH A TRUNK DIAMETER LARGER THAN 4 INCHES, CUT TRUNK INTO 8 FT LENGTHS AND STACK THE LENGTHS PERIODICALLY AT THE EDGE OF THE RIGHT OF WAY FOR HAUL OFF BY THOSE NEEDING FIREWOOD. DISPOSE OF REMAINING CLEAR CUT DEBRIS AT AN APPROVED LOCATION.
2. GRUB ALL AREAS BENEATH THE FOOTPRINT OF THE PROPOSED ACCESS ROAD CONSTRUCTION. IN ADDITION, GRUB THE BORROW SITE(S) AND AN ACCESS CORRIDOR BETWEEN THE BORROW SOURCE AND THE WORK AS DIRECTED BY THE ENGINEER. GRUBBING SHALL REMOVE ALL ORGANIC MATERIALS DOWN TO IN-SITU SANDY SOILS (AVERAGE ORGANIC DEPTH 1.5'). GRUBBING SHALL BE HAULED OFF TO AN APPROVED LOCATION. TOPSOIL SHALL BE STOCKPILED IN THE BORROW SITE OR ALONG THE EDGE OF THE RIGHT OF WAY FOR LATER USE IN RE-VEGETATION.
3. INSTALL LIFT STATION AND FORCEMAIN AS SHOWN ON THE PLANS. USE IN-SITU SANDS FOR TRENCH BACKFILL TO THE GREATEST EXTENT POSSIBLE.
4. OPEN THE BORROW PIT AS DIRECTED BY THE ENGINEER.
5. COVER THE FORCEMAIN WITH A MINIMUM OF 3 FEET OF TRENCH BACKFILL AND EMBANKMENT FILL BEFORE ALLOWING FULL DUMP TRUCKS TO HAUL OVER THE PIPELINE.

MATCHLINE 4+00.0
SEE SHEET C2.2

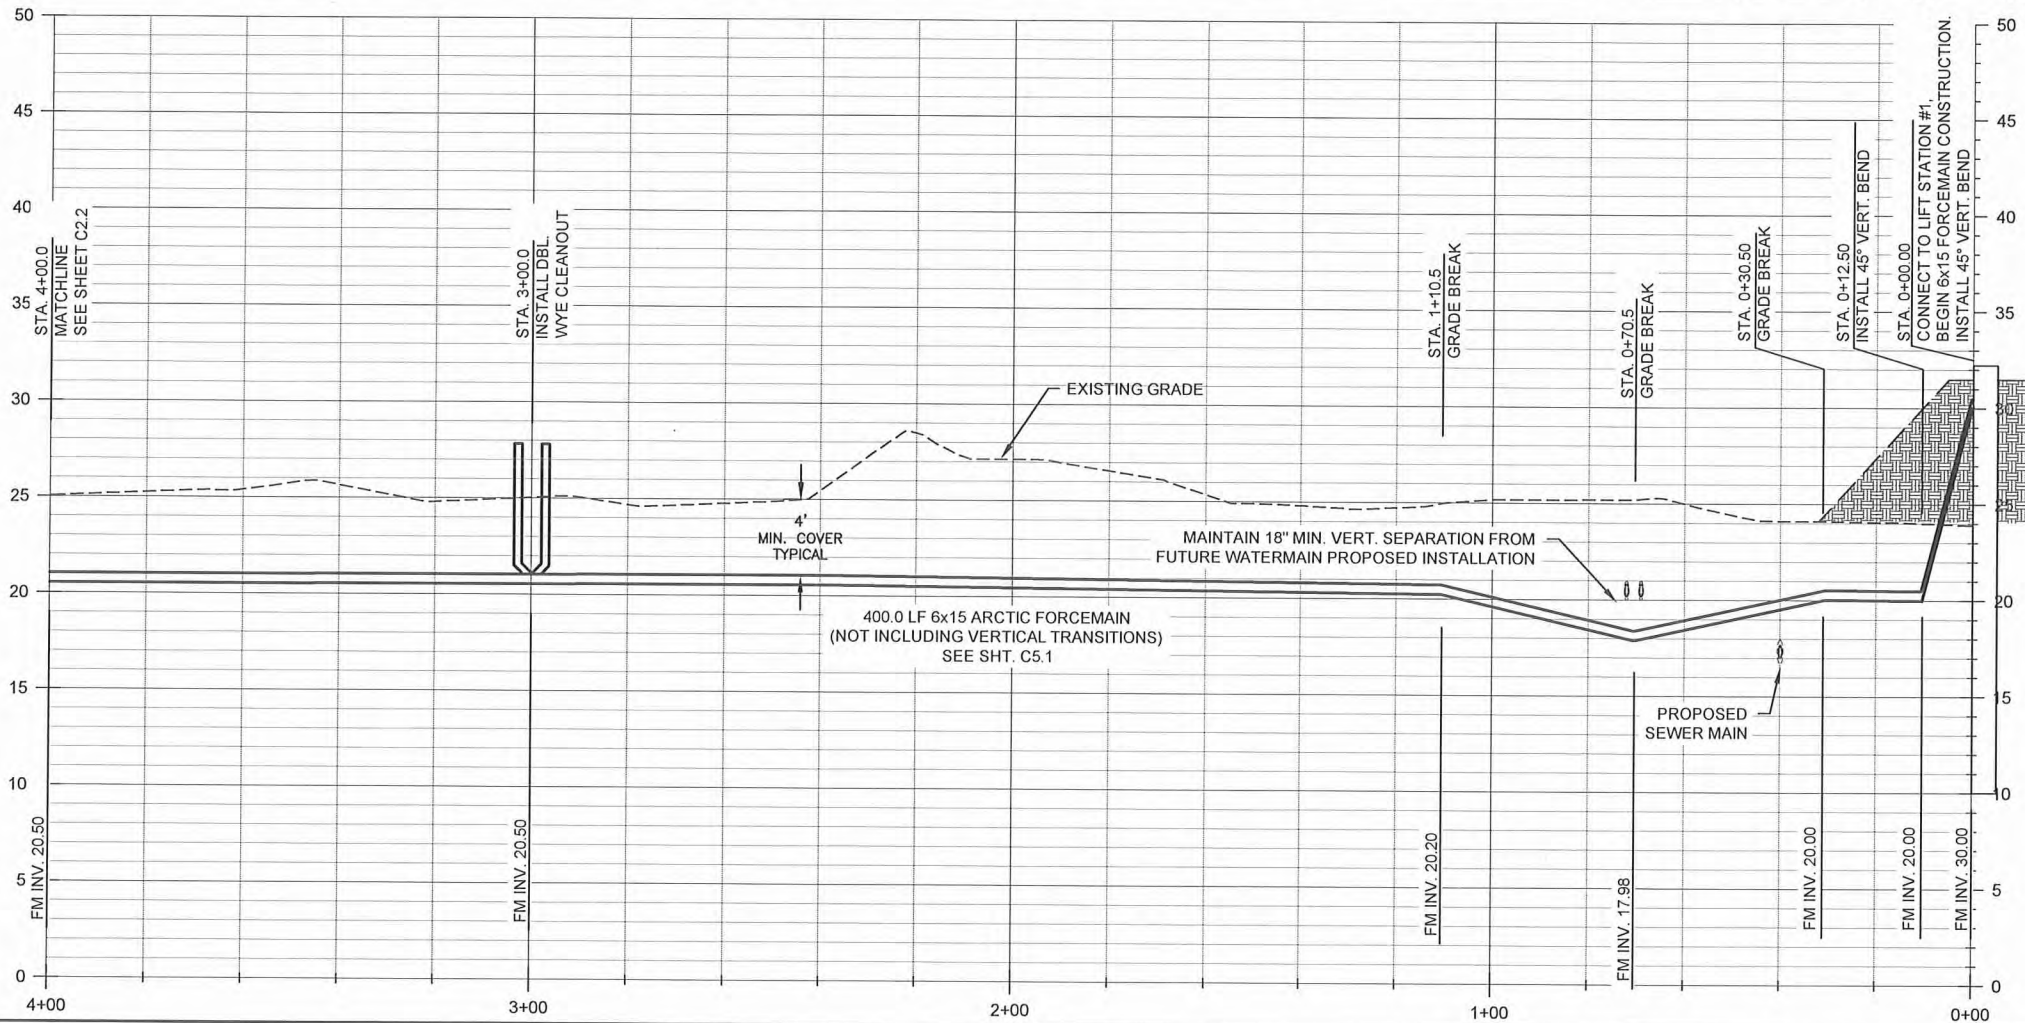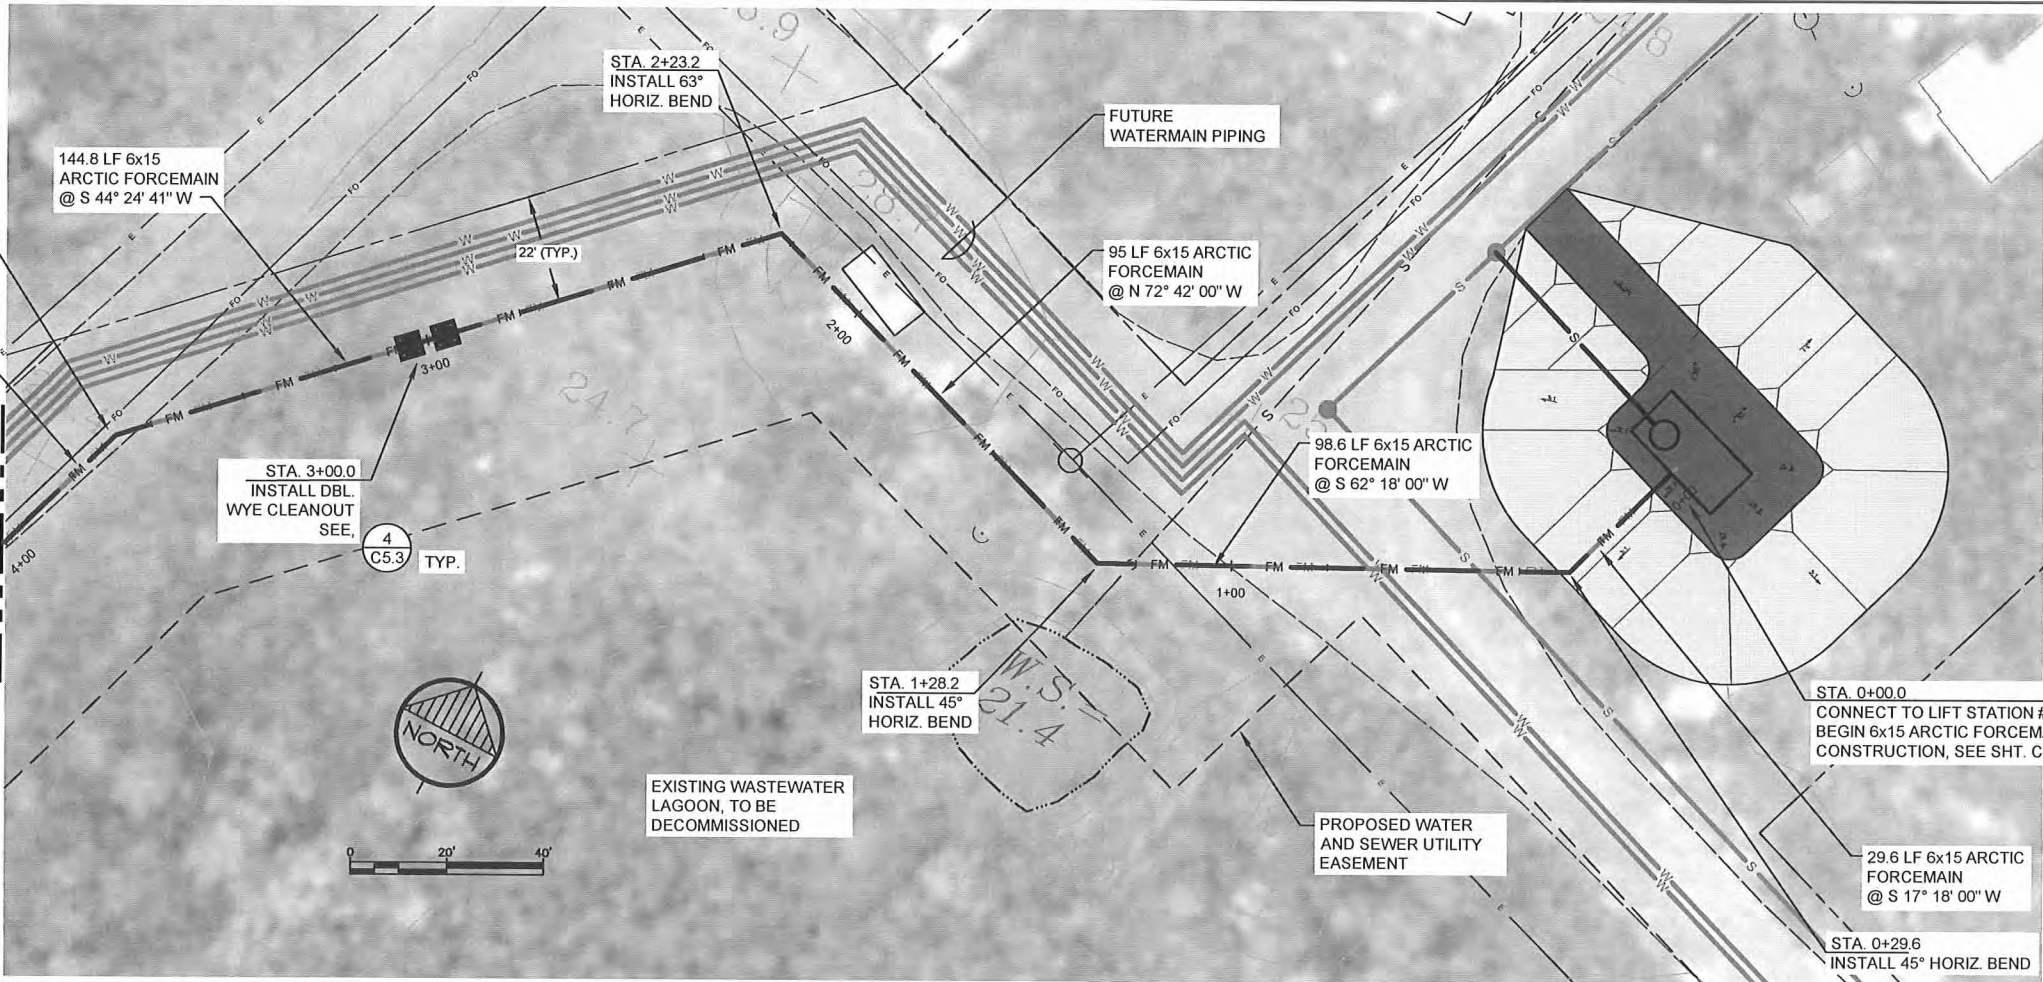

RECORD DRAWING CERTIFICATE

THESE DRAWINGS REFLECT RECORDED INFORMATION OBTAINED DURING CONSTRUCTION. INFORMATION PROVIDED HEREIN IS ACCURATE TO THE BEST OF MY KNOWLEDGE.

SCALE: AS SHOWN

DATE: _____

NAME: _____

2010-11 WASTEWATER SYSTEM IMPROVEMENTS

FM1 FORCE MAIN PLAN AND PROFILE

TULUKSAK, ALASKA

CE2 ENGINEERS, INC.



PO BOX 22046 ANCHORAGE, AK 99523 PH: 907-349-1010 FAX: 907-349-1015

REVISION	BY	DATE
LAGOON RELOCATION	CM	8/10


Project No.	Date	Designed	Drawn	Approved
	JUNE 2009	LAP	CM	LAP

Sheet No. C2.1

G:\ACAD\TULUKSAK\TLT0901 2008 Waste water disposal area\C2.1_C2.8 ROAD AND FORCEMAIN P&P.dwg, 1/11/2011 1:12:56 PM, Flash, LANIER NP C2050_LD520C PCL 6BLK WHIT.pcl

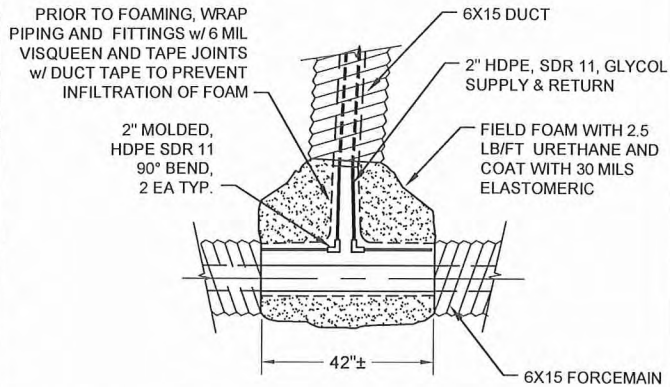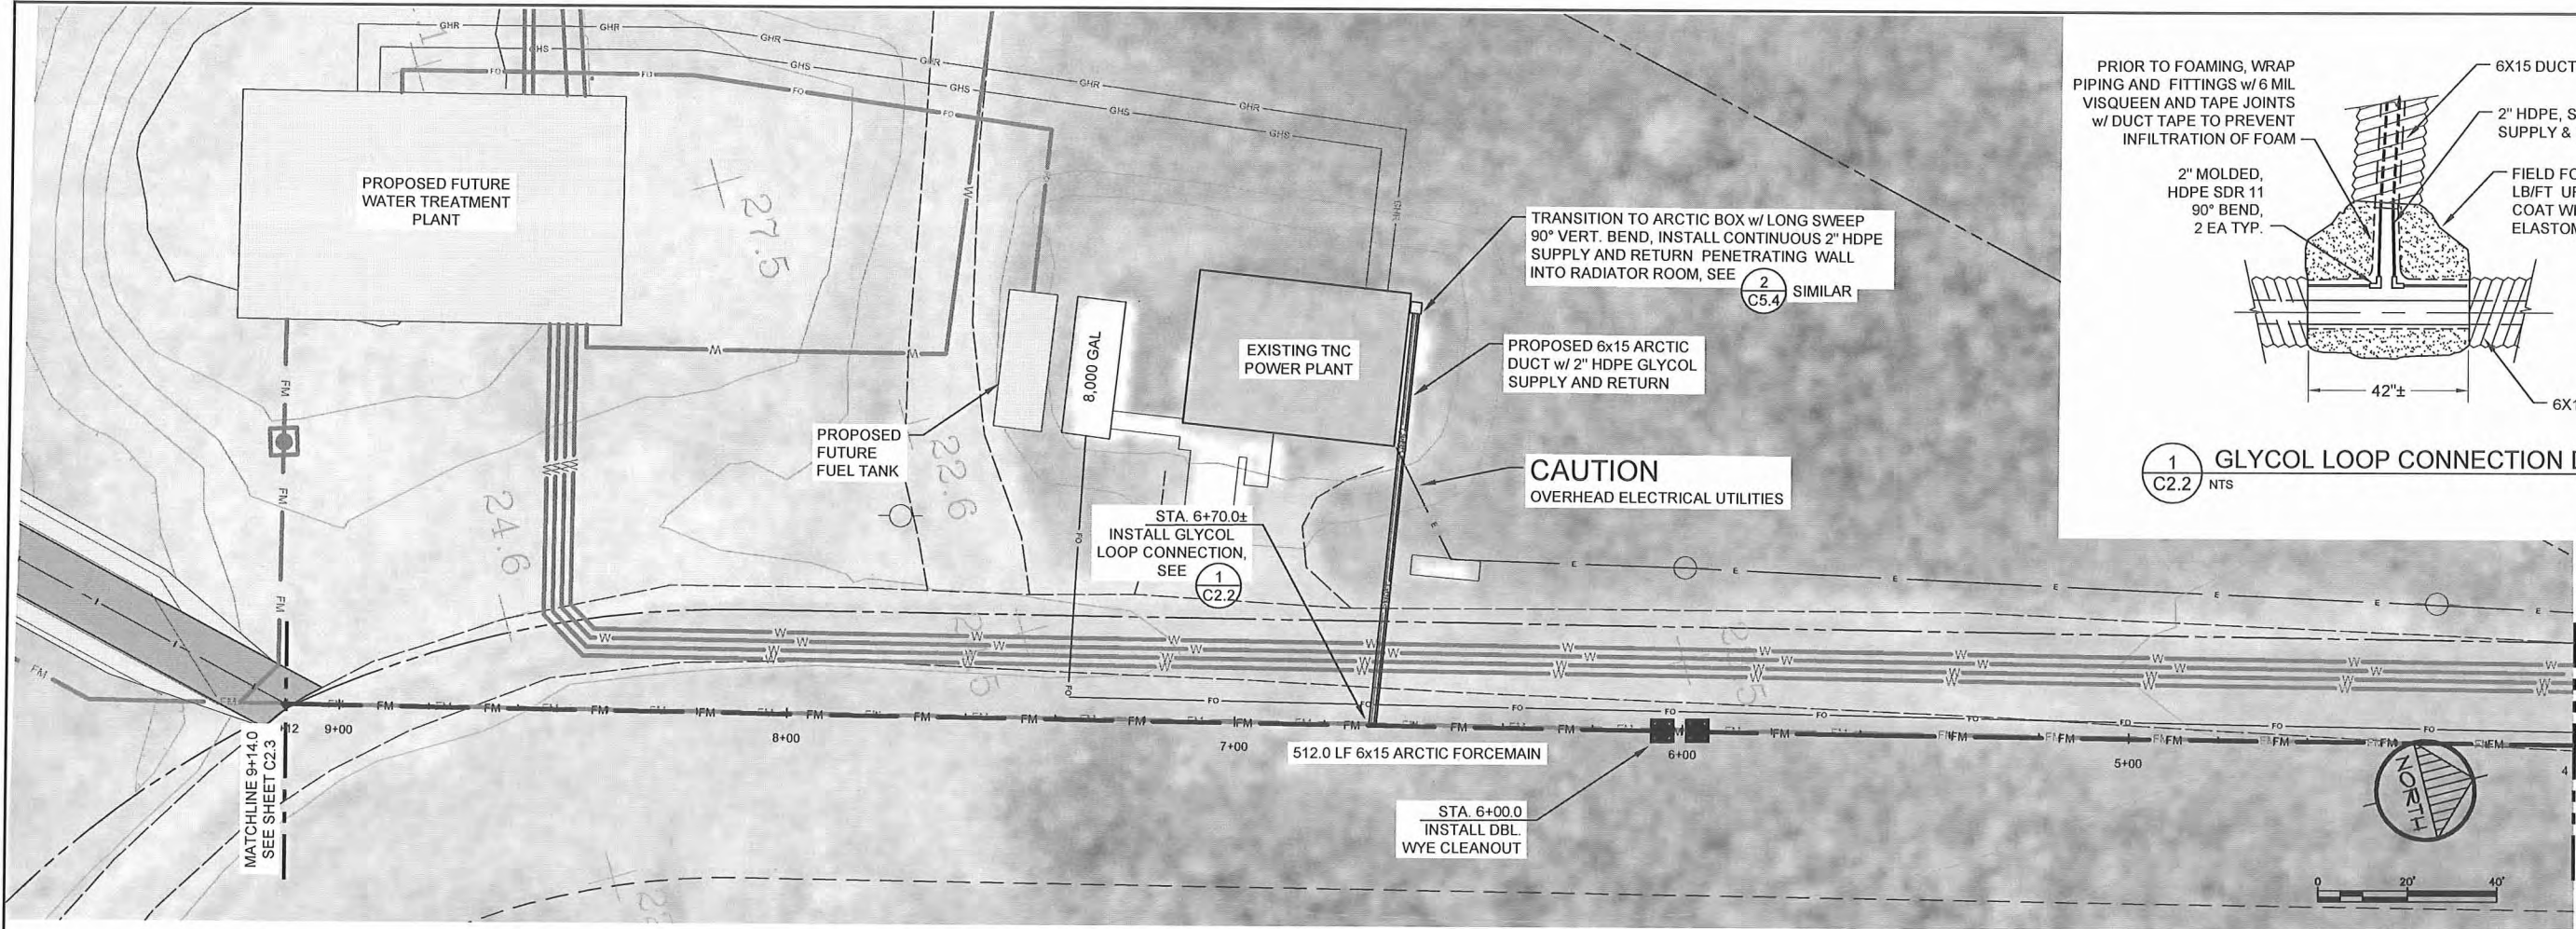

1
C2.2
NTS
GLYCOL LOOP CONNECTION DETAIL

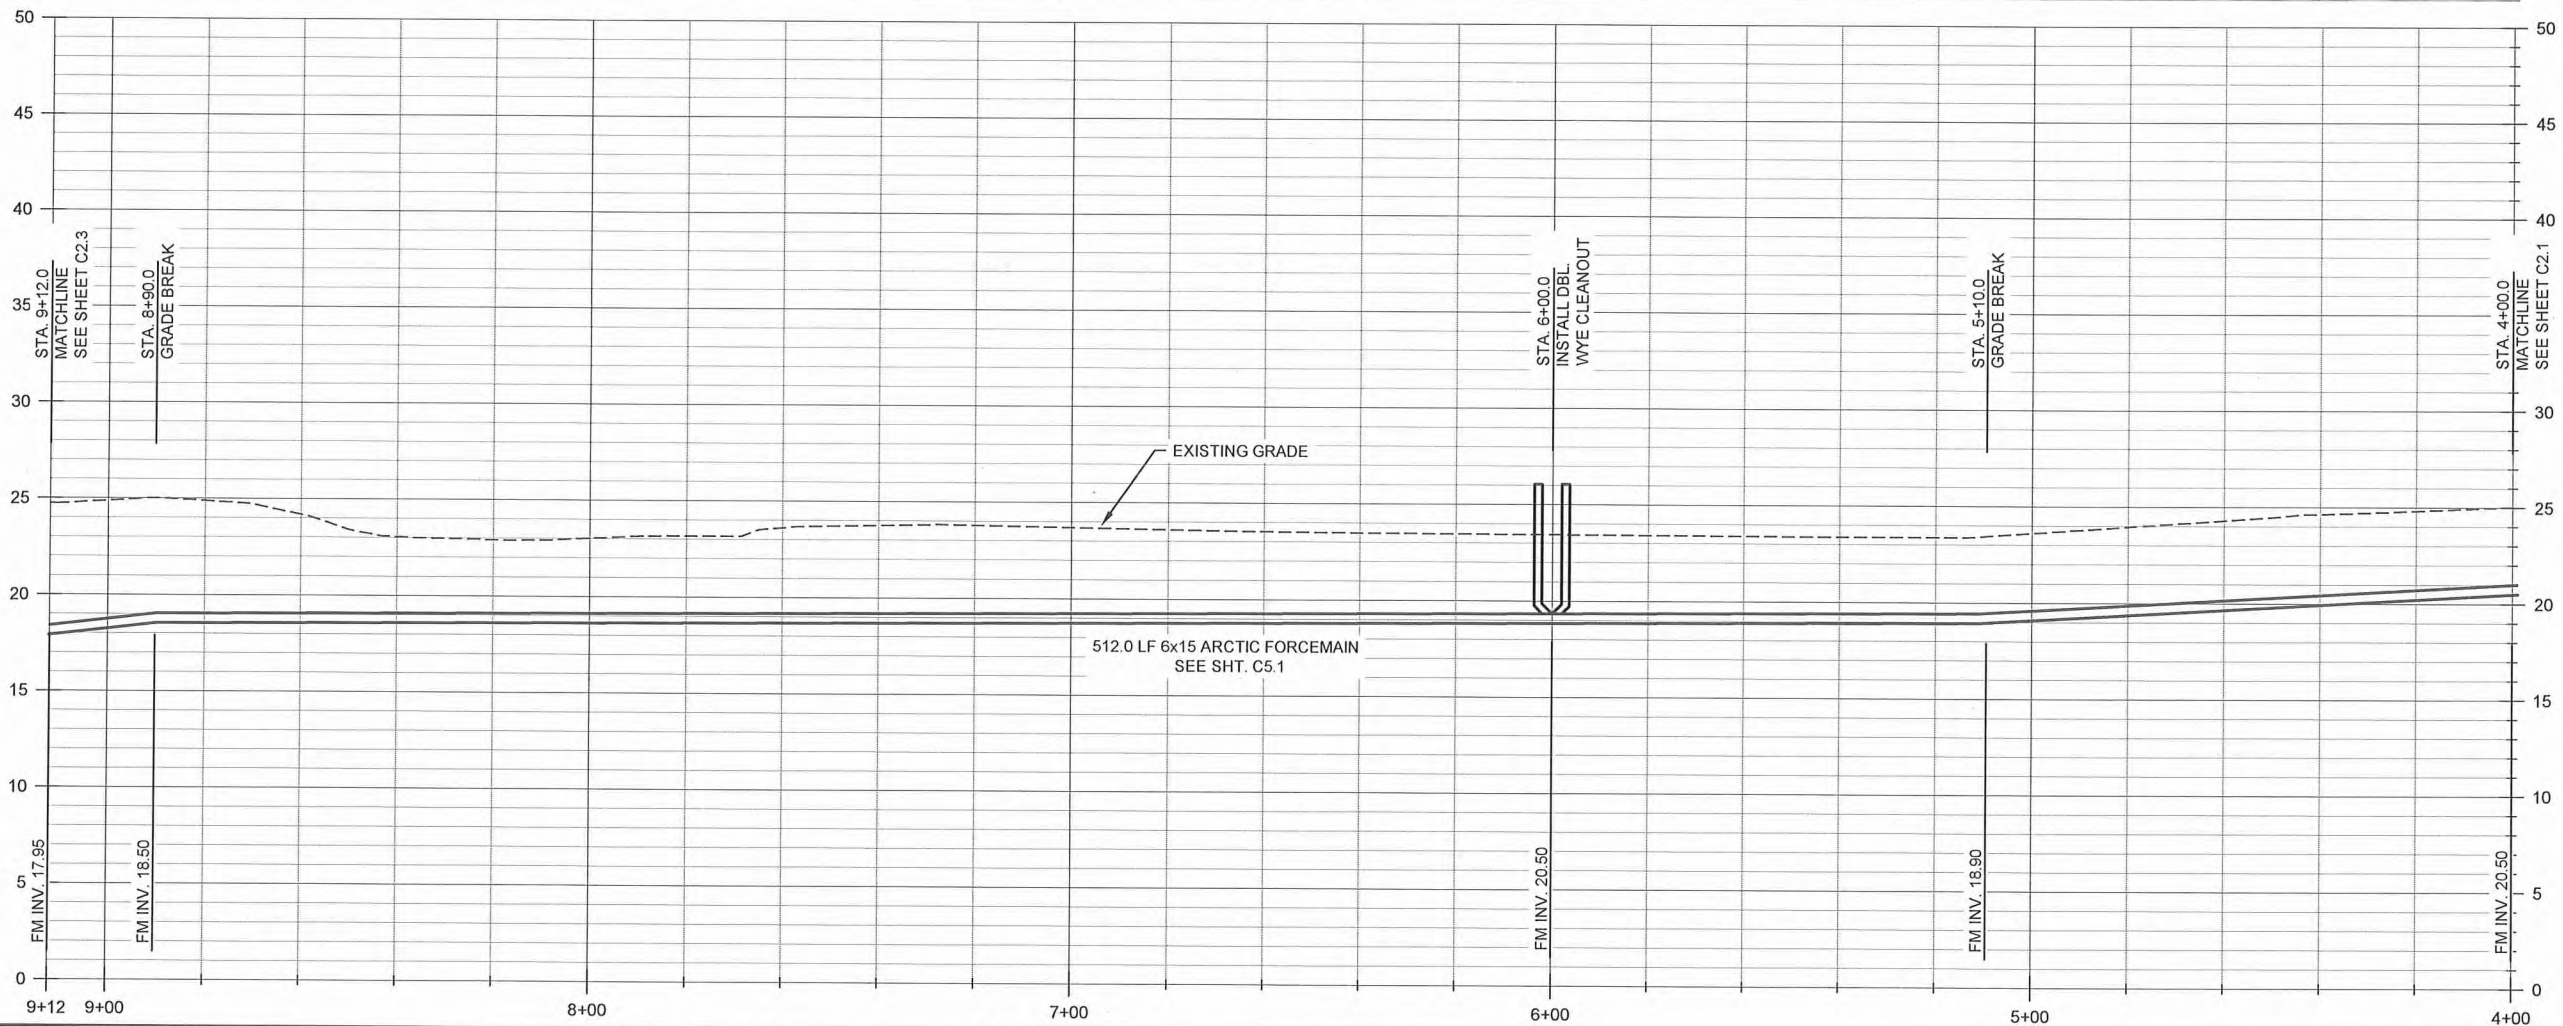

RECORD DRAWING CERTIFICATE
THESE DRAWINGS REFLECT RECORDED
INFORMATION OBTAINED DURING
CONSTRUCTION. INFORMATION PROVIDED
HEREIN IS ACCURATE TO THE BEST OF MY
KNOWLEDGE.

SCALE:
AS SHOWN
1" = 40'
IF NOT ONE INCH ON
SCALE ACCORDINGLY






2010-11 WASTEWATER
SYSTEM IMPROVEMENTS
FM1 FORCE MAIN
PLAN AND PROFILE
TULUKSAK, ALASKA

CE2
ENGINEERS, INC.
PO BOX 22346 ANCHORAGE, AK 99523 PH: 907-946-1001 FAX: 907-946-1015

REVISION	BY	DATE
LAGOON RELOCATION	CM	8/10

Project No.	JUNE 2009
Date	LAP
Designed	CM
Drawn	LAP
Approved	LAP

Sheet No.
C2.2

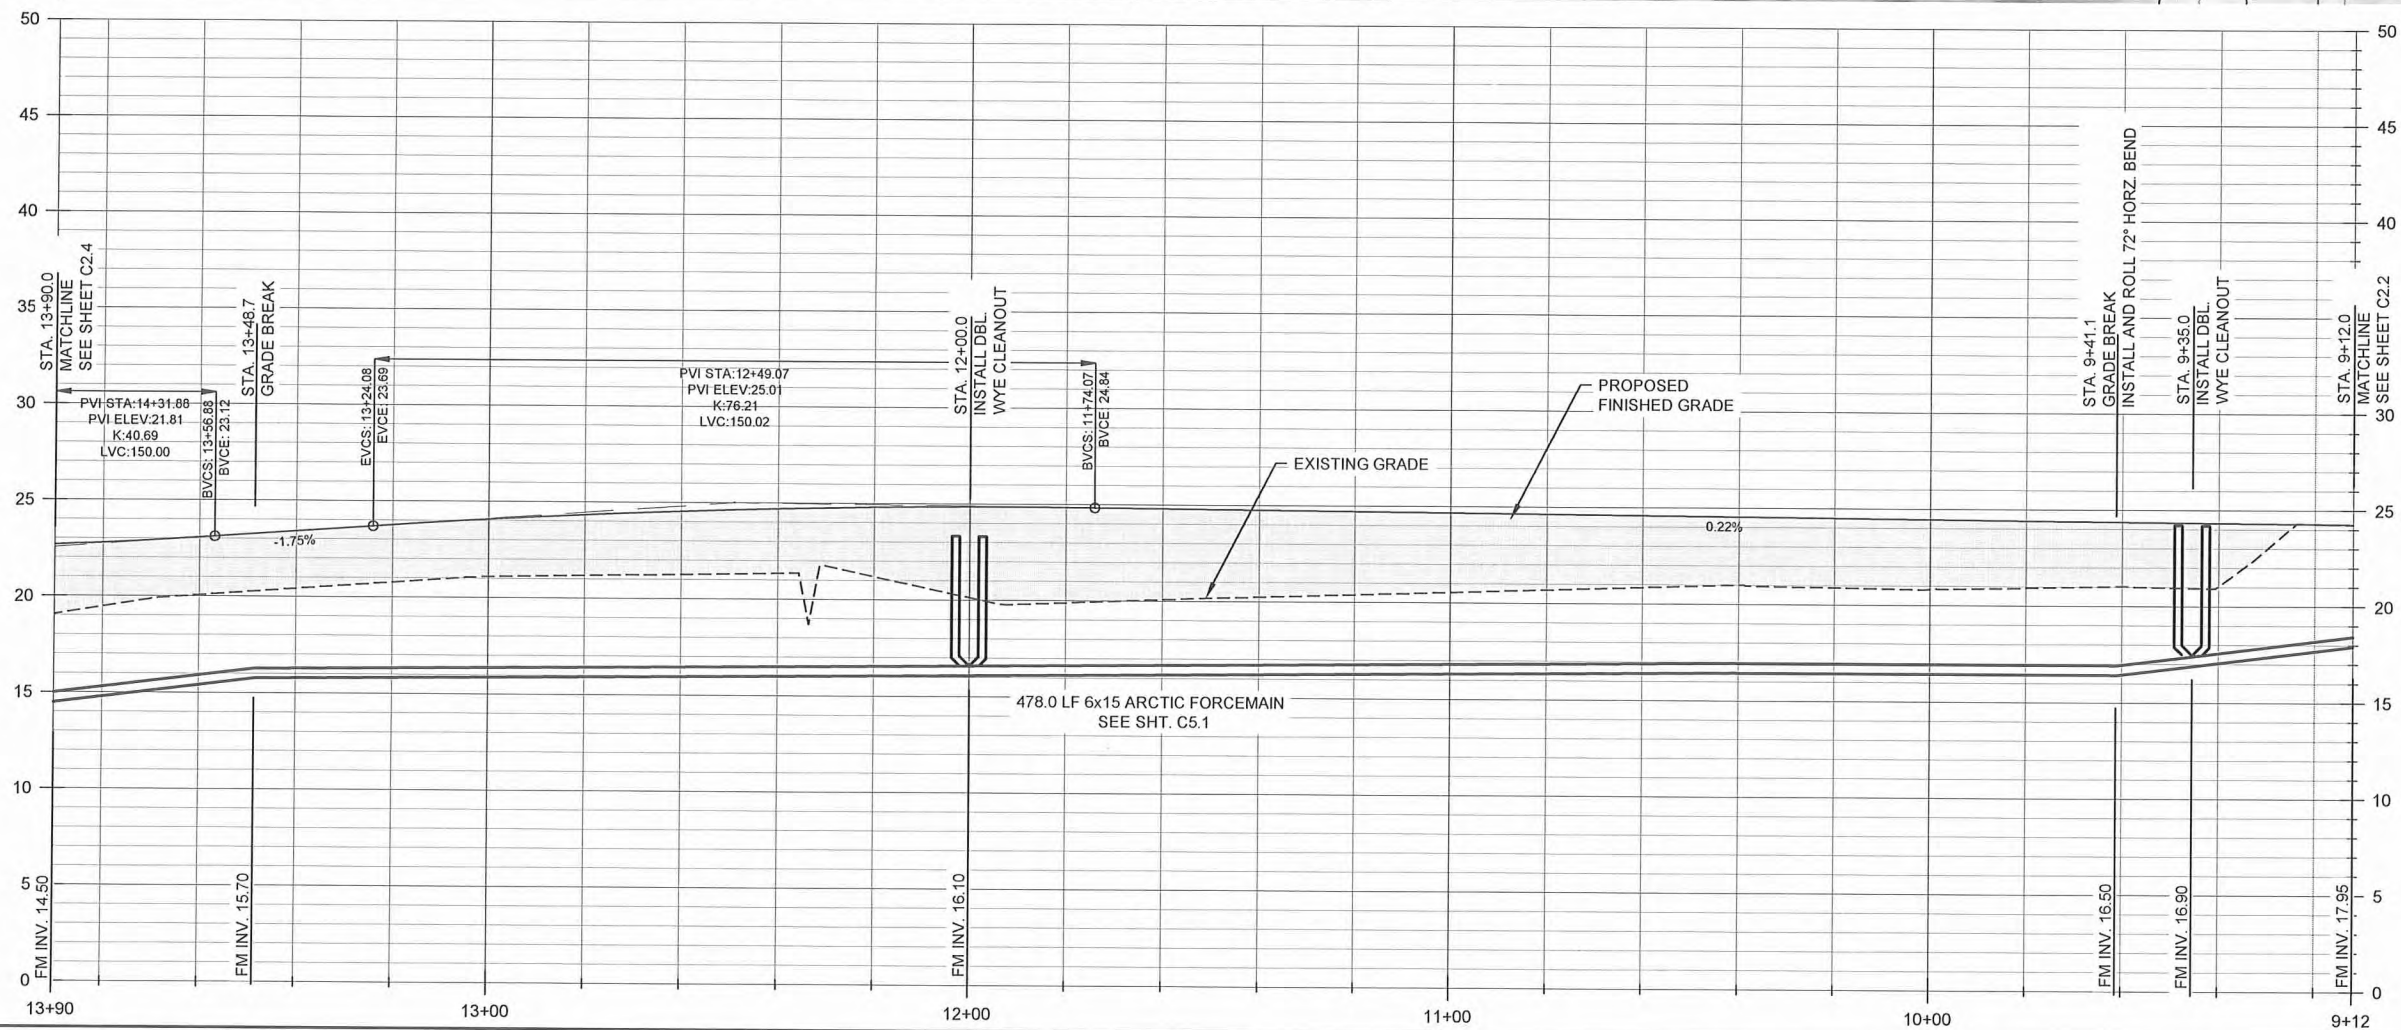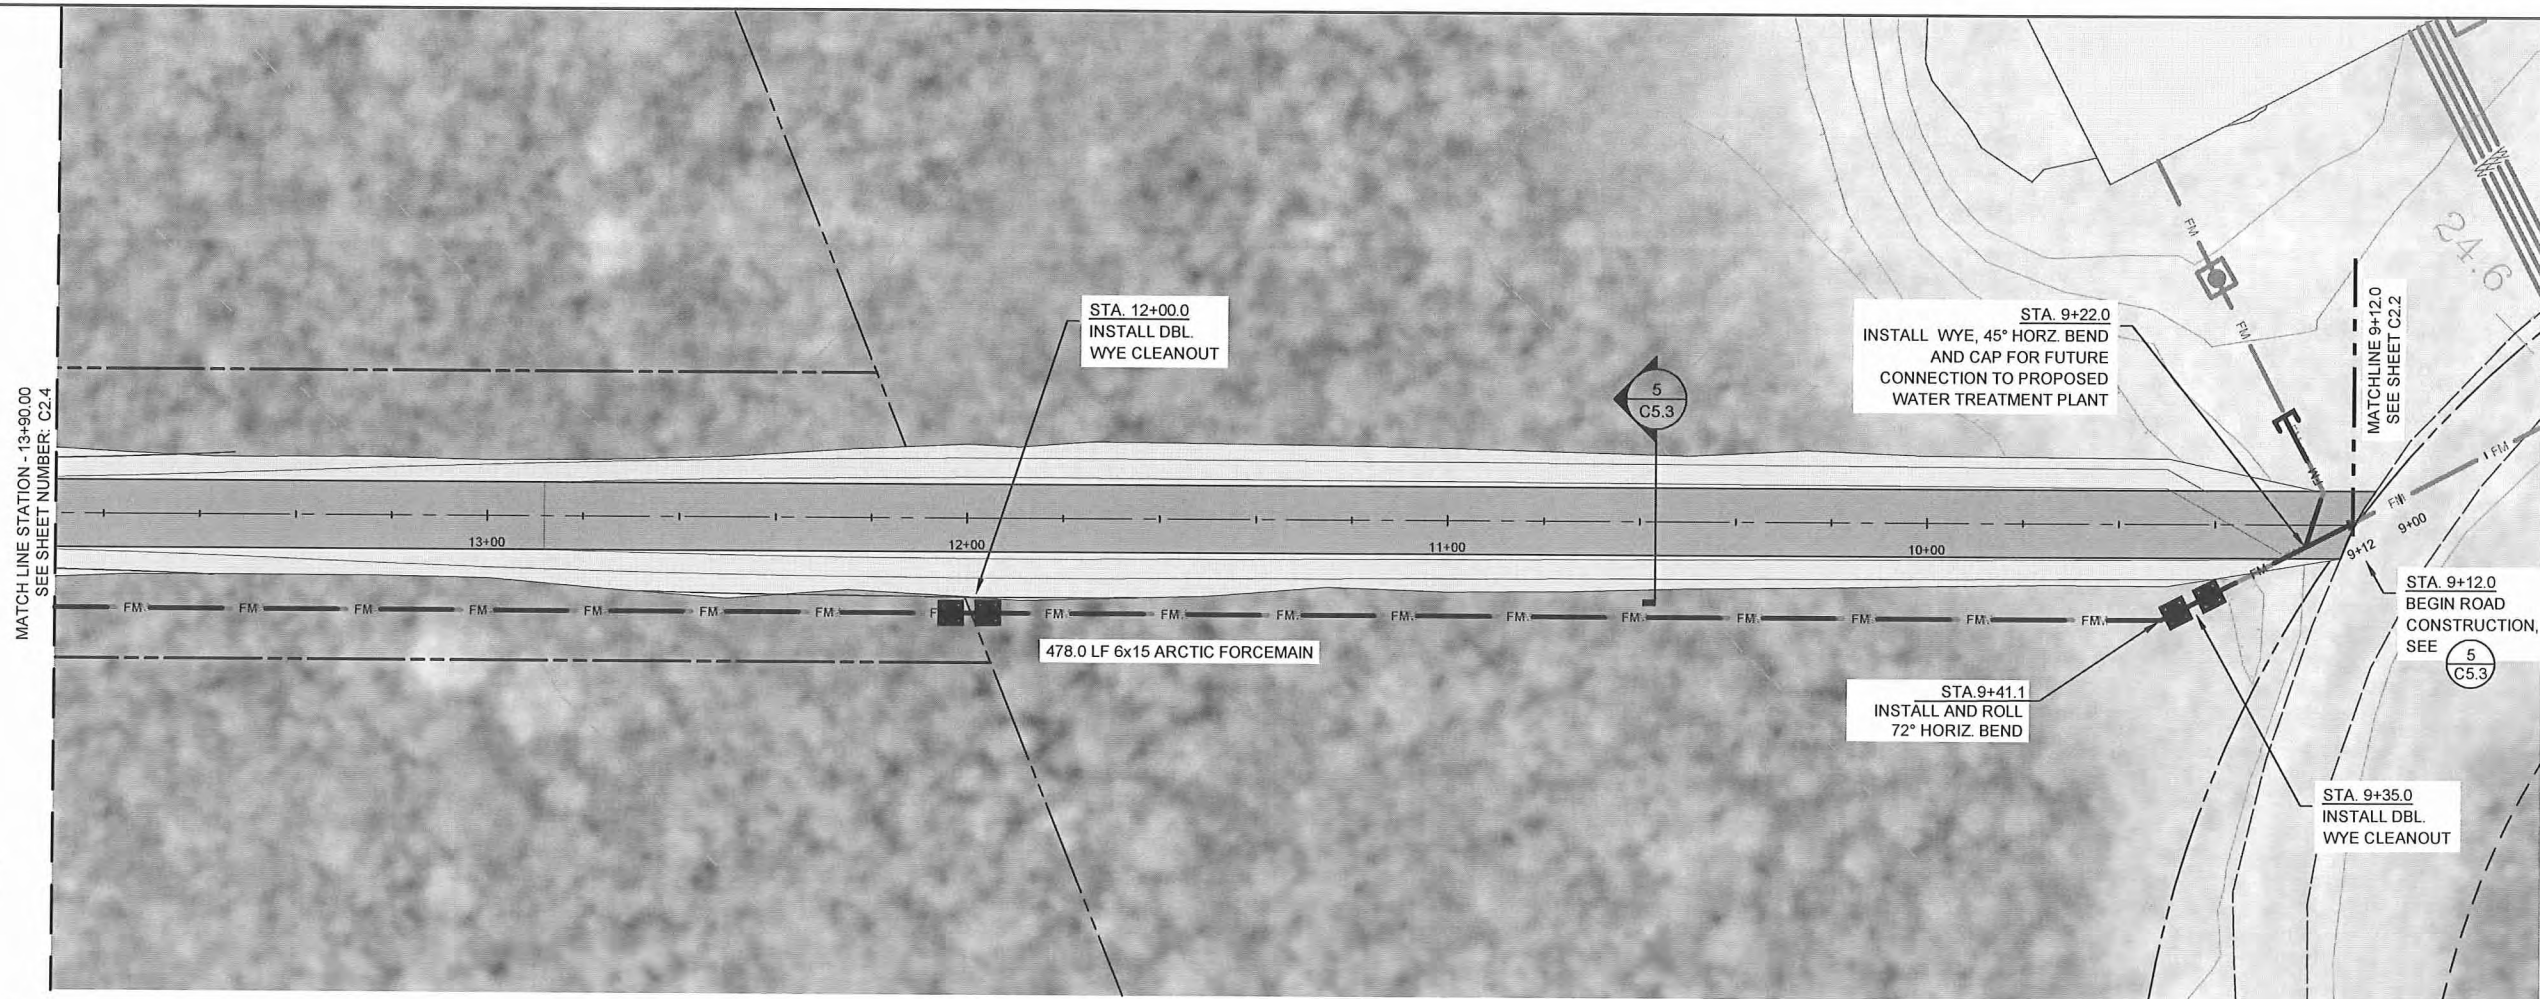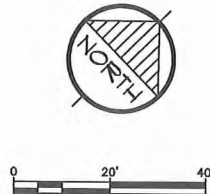

RECORD DRAWING CERTIFICATE
THESE DRAWINGS REFLECT RECORDED
INFORMATION OBTAINED DURING
CONSTRUCTION. INFORMATION PROVIDED
HEREIN IS ACCURATE TO THE BEST OF MY
KNOWLEDGE.

SCALE:
AS SHOWN
1" = 100'
IF NOT ONE INCH ON
THIS SHEET, ADJUST
SCALE ACCORDINGLY

STATE OF ALASKA
49 TH
Lloyd A. Peterson
No. CE 9922
REGISTERED PROFESSIONAL ENGINEER



2010-11 WASTEWATER
SYSTEM IMPROVEMENTS
ROAD AND
FM1 FORCE MAIN
PLAN AND PROFILE
TULUKSAK, ALASKA

CE2
ENGINEERS, INC.
PO BOX 22066 ANCHORAGE, AK 99522 PH: 907-546-1000 FAX: 907-546-1016

REVISION	BY	DATE
LAGOON RELOCATION	CM	8/10

Project No.	Date	Designed	Drawn	Approved
	JUNE 2009	LAP	CM	LAP

Sheet No. C2.3

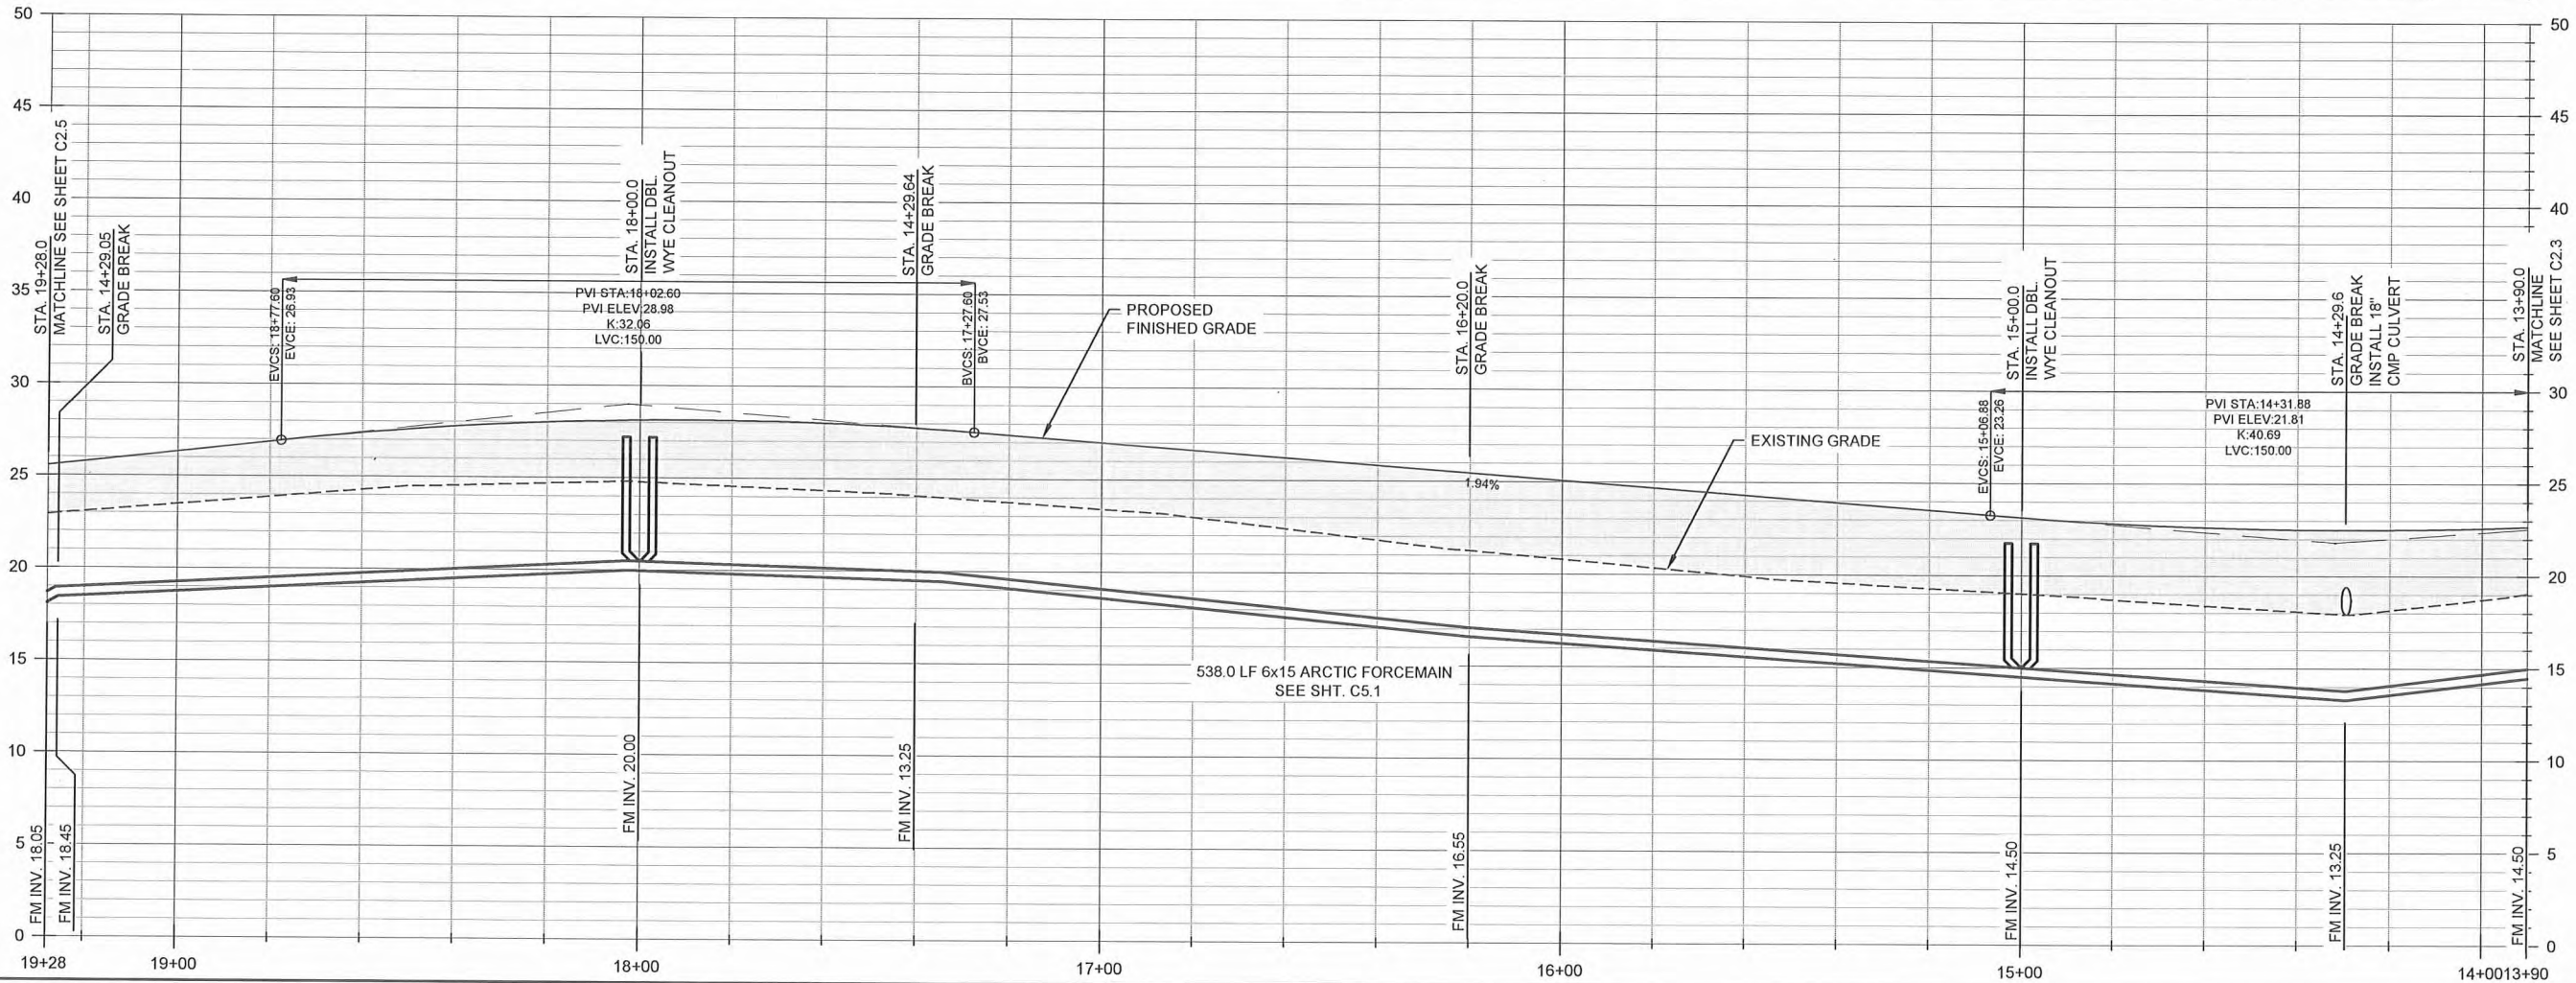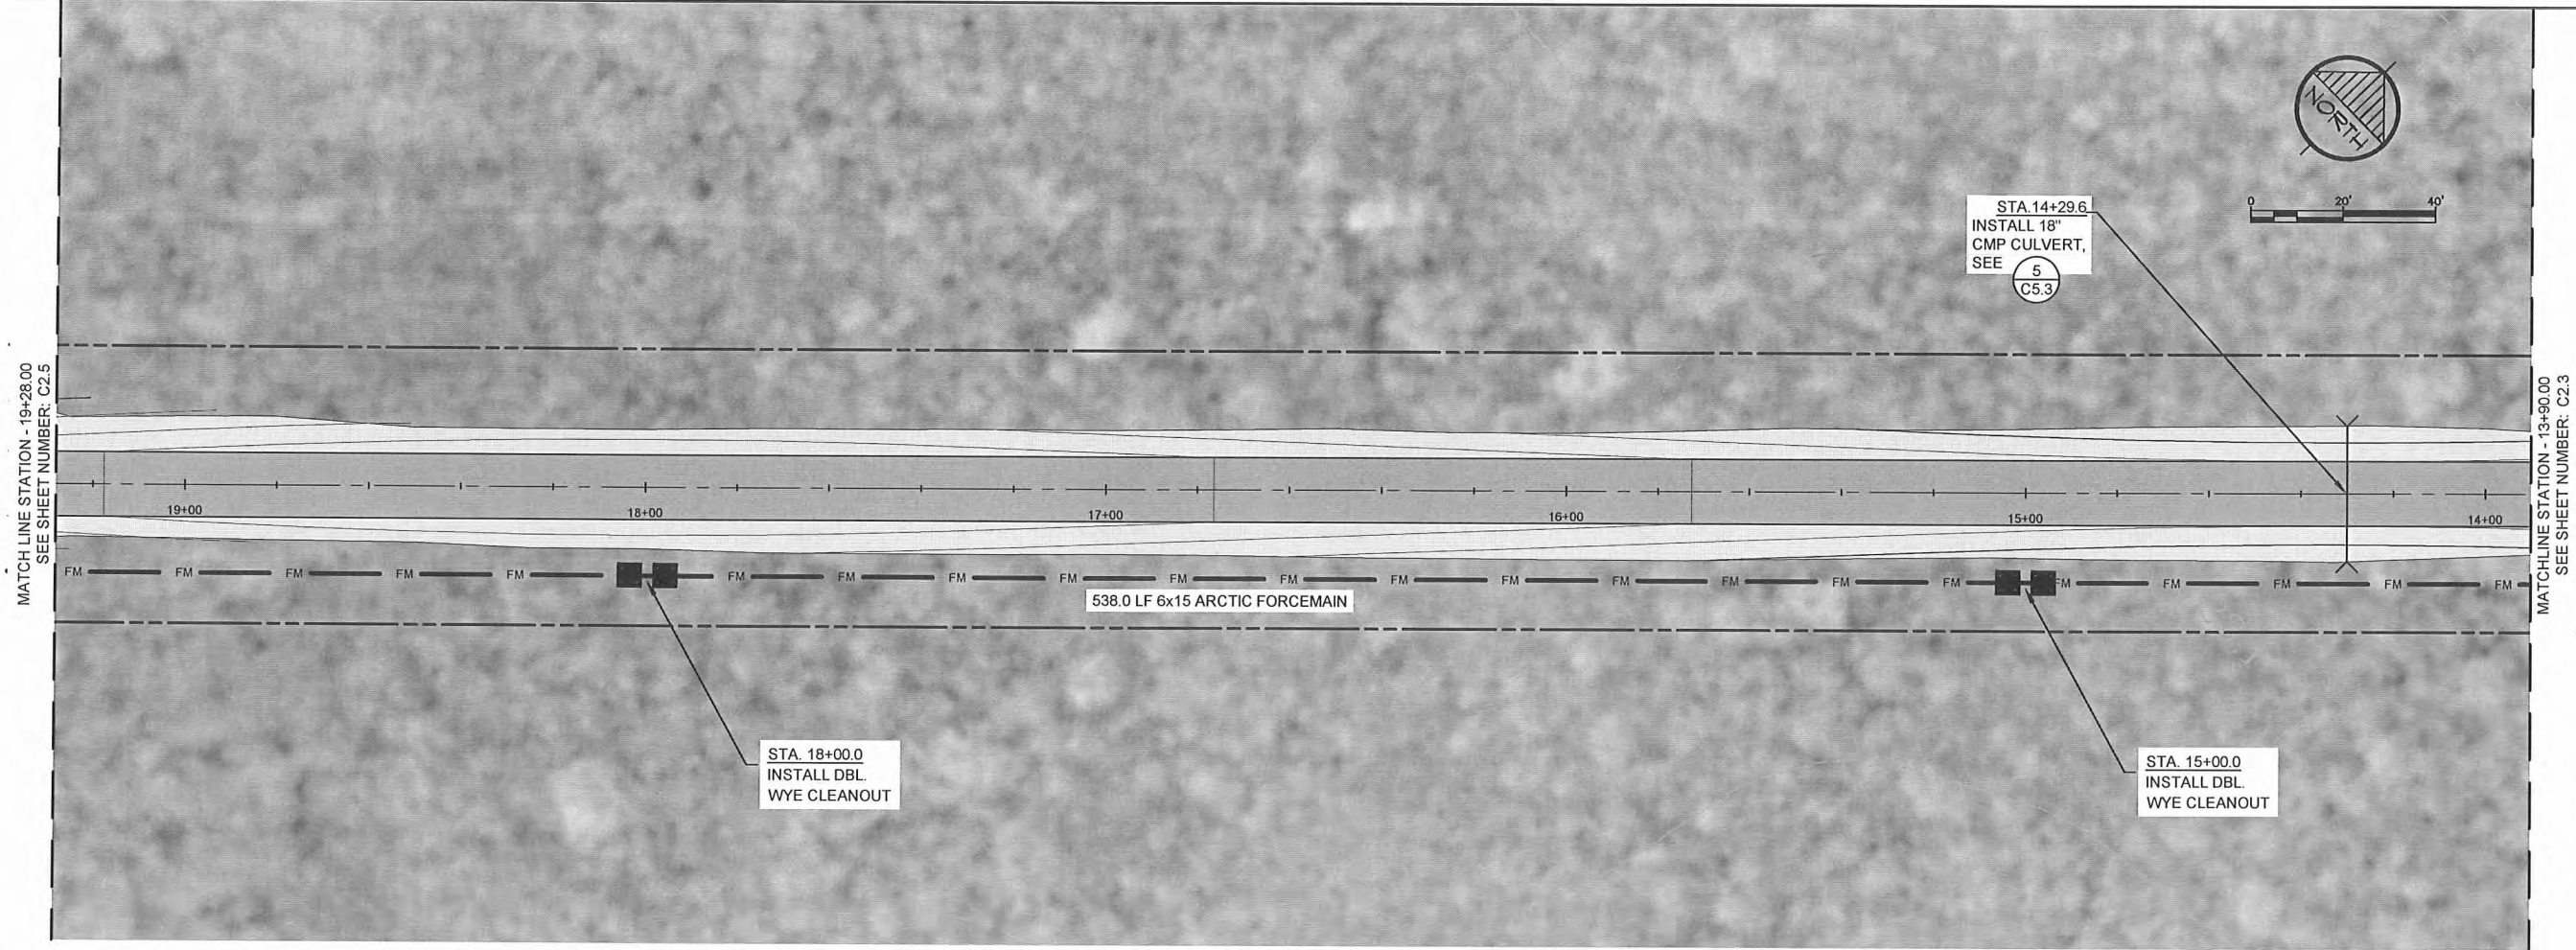

Project No.	BY	DATE
_____	_____	8/10
Date	DESIGNED	LAP
JUNE 2009	_____	_____
Drawn	CM	_____
Approved	LAP	_____

Sheet No.
C2.4

CE2
ENGINEERS, INC.

PO BOX 223946 ANCHORAGE, AK 99523 PH 907-946-1010 FAX 907-946-1015

2010-11 WASTEWATER
SYSTEM IMPROVEMENTS

ROAD AND
FM1 FORCE MAIN
PLAN AND PROFILE

TULUKSAK, ALASKA



SCALE:
AS SHOWN

BAR IS ONE INCH ON
ORIGINAL DRAWING

1"

0 1"

IF NOT ONE INCH ON
THIS SHEET, ADJUST
SCALE ACCORDINGLY

RECORD DRAWING CERTIFICATE

THESE DRAWINGS REFLECT RECORDED
INFORMATION OBTAINED DURING
CONSTRUCTION. INFORMATION PROVIDED
HEREIN IS ACCURATE TO THE BEST OF MY
KNOWLEDGE.

NAME _____

DATE _____

G:\ACAD\TULUKSAK\TLT0901 2008 Waste water disposal area\C2.1_C2.8 ROAD AND FORCEMAIN P&P.dwg, 1/11/2011 1:16:28 PM, Flash, LANIER MP C2050_LD520C PCL 6BLK WHIT.pcl3



RECORD DRAWING CERTIFICATE
THESE DRAWINGS REFLECT RECORDED
INFORMATION OBTAINED DURING
CONSTRUCTION. INFORMATION PROVIDED
HEREIN IS ACCURATE TO THE BEST OF MY
KNOWLEDGE.

SCALE:
AS SHOWN
1" = 40'
IF NOT ONE INCH ON
SCALE ACCORDINGLY

DATE
NAME

2010-11 WASTEWATER
SYSTEM IMPROVEMENTS

ROAD AND
FM1 FORCE MAIN
PLAN AND PROFILE

TULUKSAK, ALASKA

CE2
ENGINEERS, INC.

PO BOX 22396 ANCHORAGE, AK 99523 PH: 907-549-1010 FAX: 907-549-1015

REVISION	BY	DATE
LAGOON RELOCATION	CM	8/10

Project
No. _____
Date
JUNE 2009
Designed
LAP
Drawn
CM
Approved
LAP

Sheet No.
C2.5




RECORD DRAWING CERTIFICATE
THESE DRAWINGS REFLECT RECORDED
INFORMATION OBTAINED DURING
CONSTRUCTION. INFORMATION PROVIDED
HEREIN IS ACCURATE TO THE BEST OF MY
KNOWLEDGE.

SCALE:
AS SHOWN
1" = 40'
THIS SHEET ADJUSTS
SCALE ACCORDINGLY



2010-11 WASTEWATER
SYSTEM IMPROVEMENTS
ROAD AND
FM1 FORCE MAIN
PLAN AND PROFILE
TULUKSAK, ALASKA

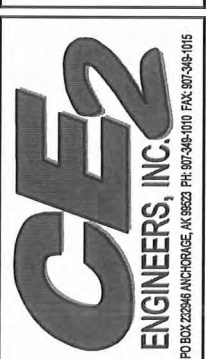


REVISION	BY	DATE
LAGOON RELOCATION	CM	8/10

Project No.	JUNE 2009
Date	
Designed	LAP
Drawn	CM
Approved	LAP

Sheet No. C2.6

G:\ACAD\TULUKSAK\TLT0901 2008 Waste water disposal area\C2.1_C2.8 ROAD AND FORCEMAIN P&P.dwg, 1/11/2011 1:18:13 PM, Flash, LANIER MP C2050_LD520C PCL 6BLK WHIT.pcl3

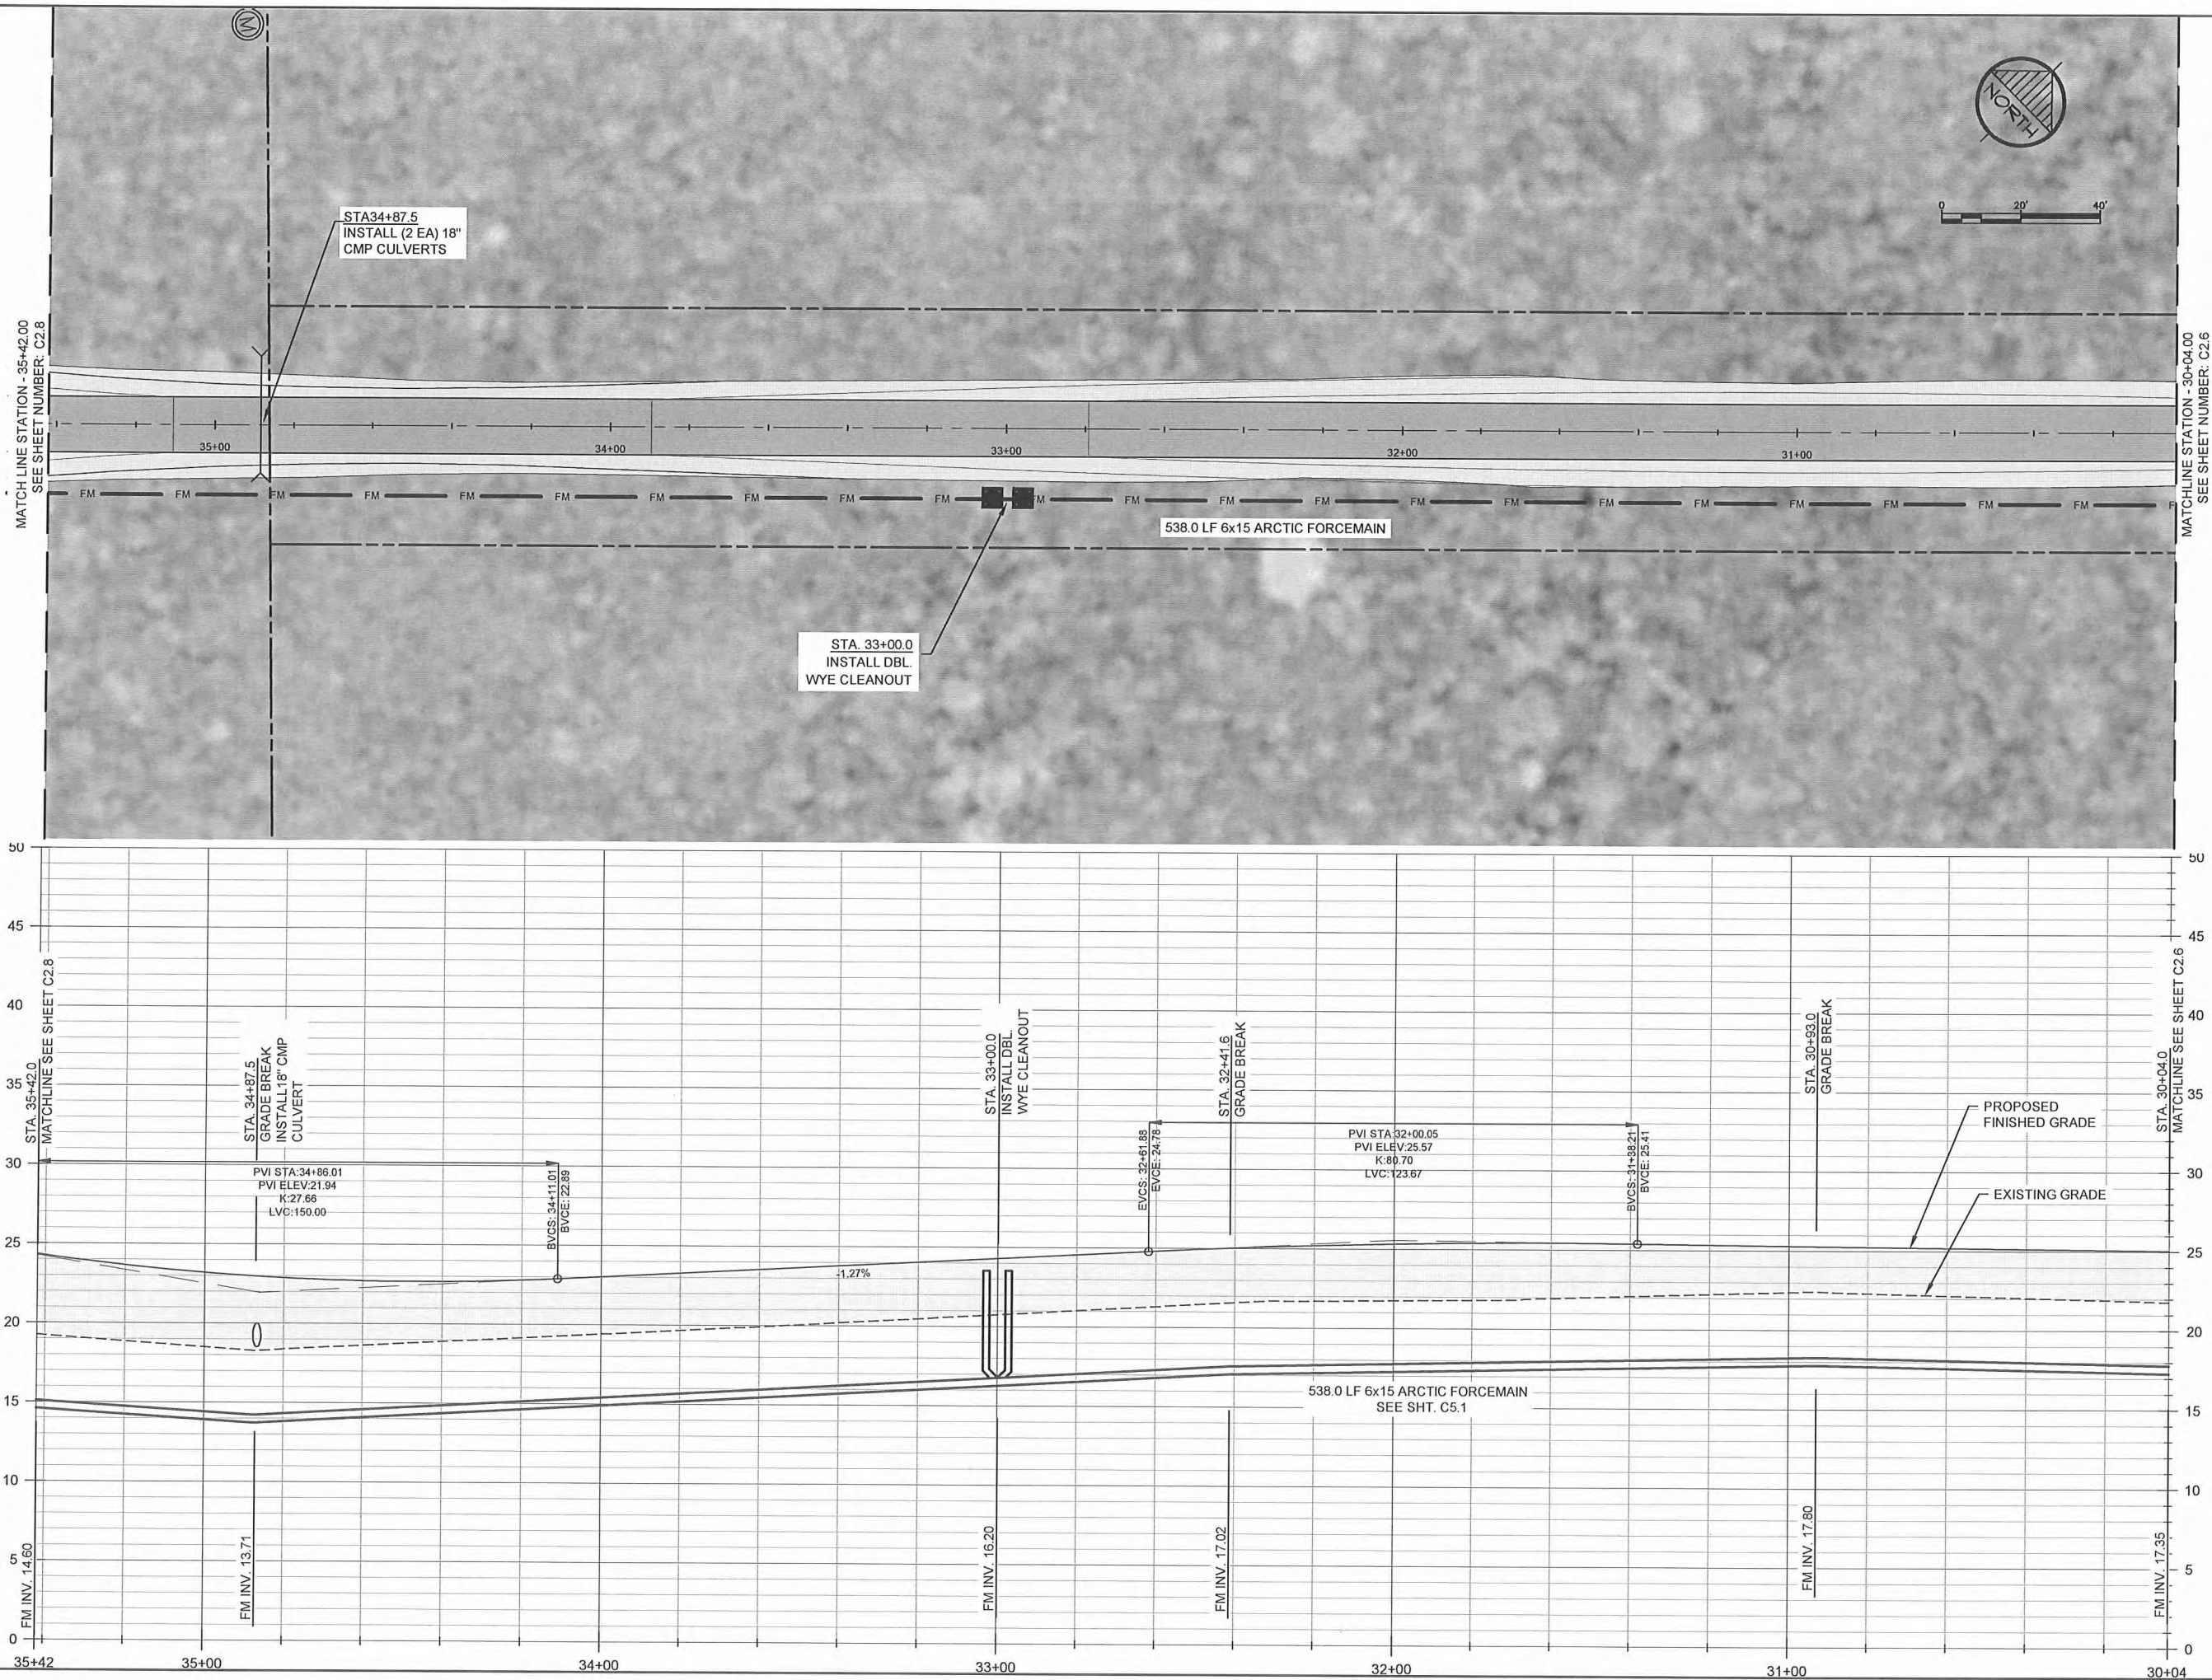

RECORD DRAWING CERTIFICATE
THESE DRAWINGS REFLECT RECORDED
INFORMATION OBTAINED DURING
CONSTRUCTION. INFORMATION PROVIDED
HEREIN IS ACCURATE TO THE BEST OF MY
KNOWLEDGE.

SCALE:
AS SHOWN
1" = 40'
1" = 20'

2010-11 WASTEWATER
SYSTEM IMPROVEMENTS

ROAD AND
FM1 FORCE MAIN
PLAN AND PROFILE
TULUKSAK, ALASKA



CE2
ENGINEERS, INC.
PO BOX 22949 ANCHORAGE AK 99523 PH: 907-349-1010 FAX: 907-349-1015

REVISION	BY	DATE
LAGOON RELOCATION	CM	8/10

Project No. _____	BY _____	DATE _____
Date _____	DESIGNED _____	LAP _____
Drawn _____	CM _____	
Approved _____	LAP _____	

Sheet No. **C2.7**

NAME _____ DATE _____

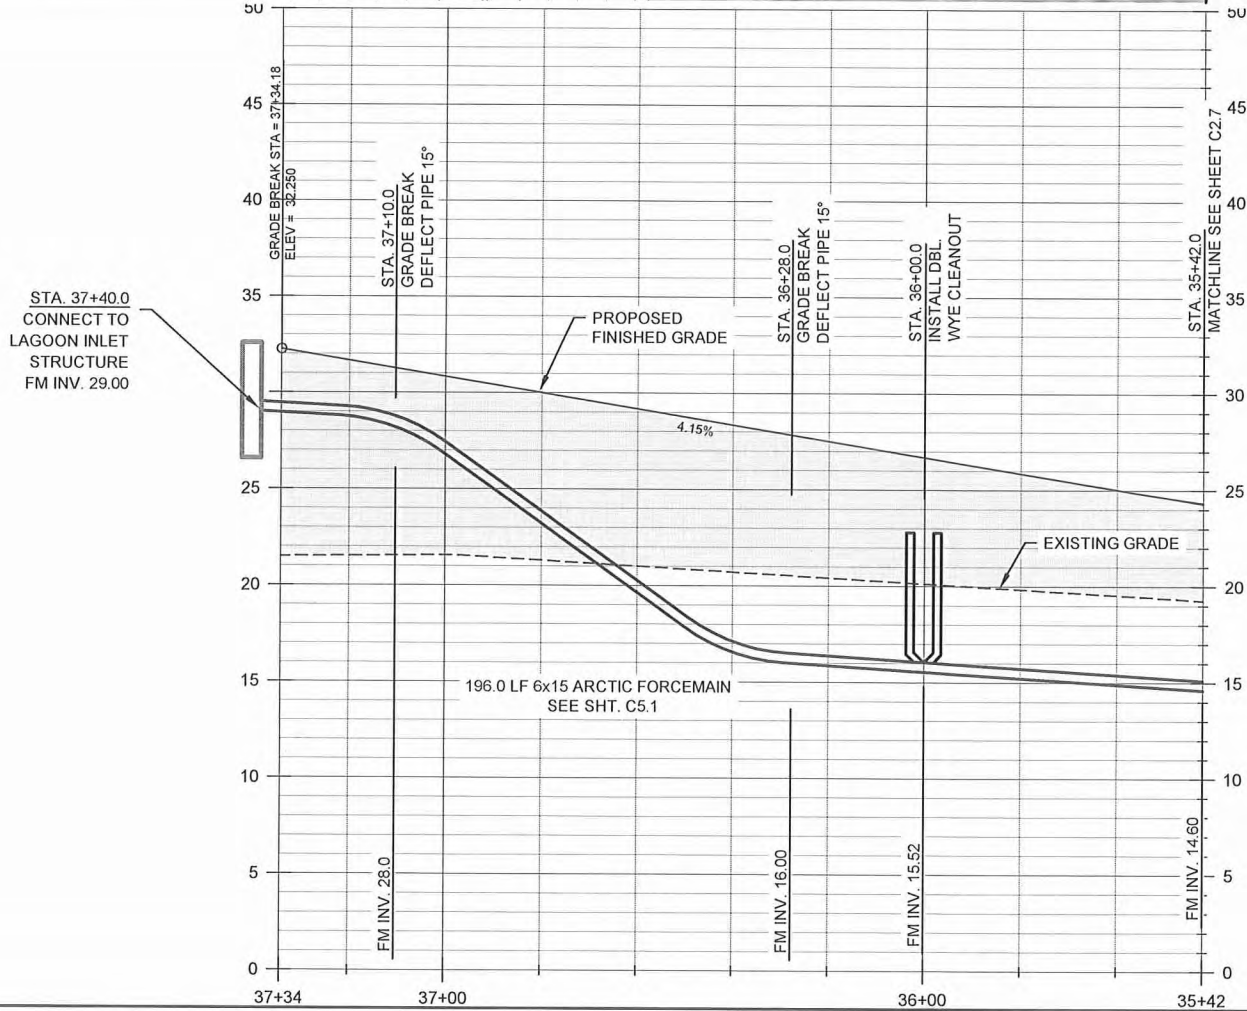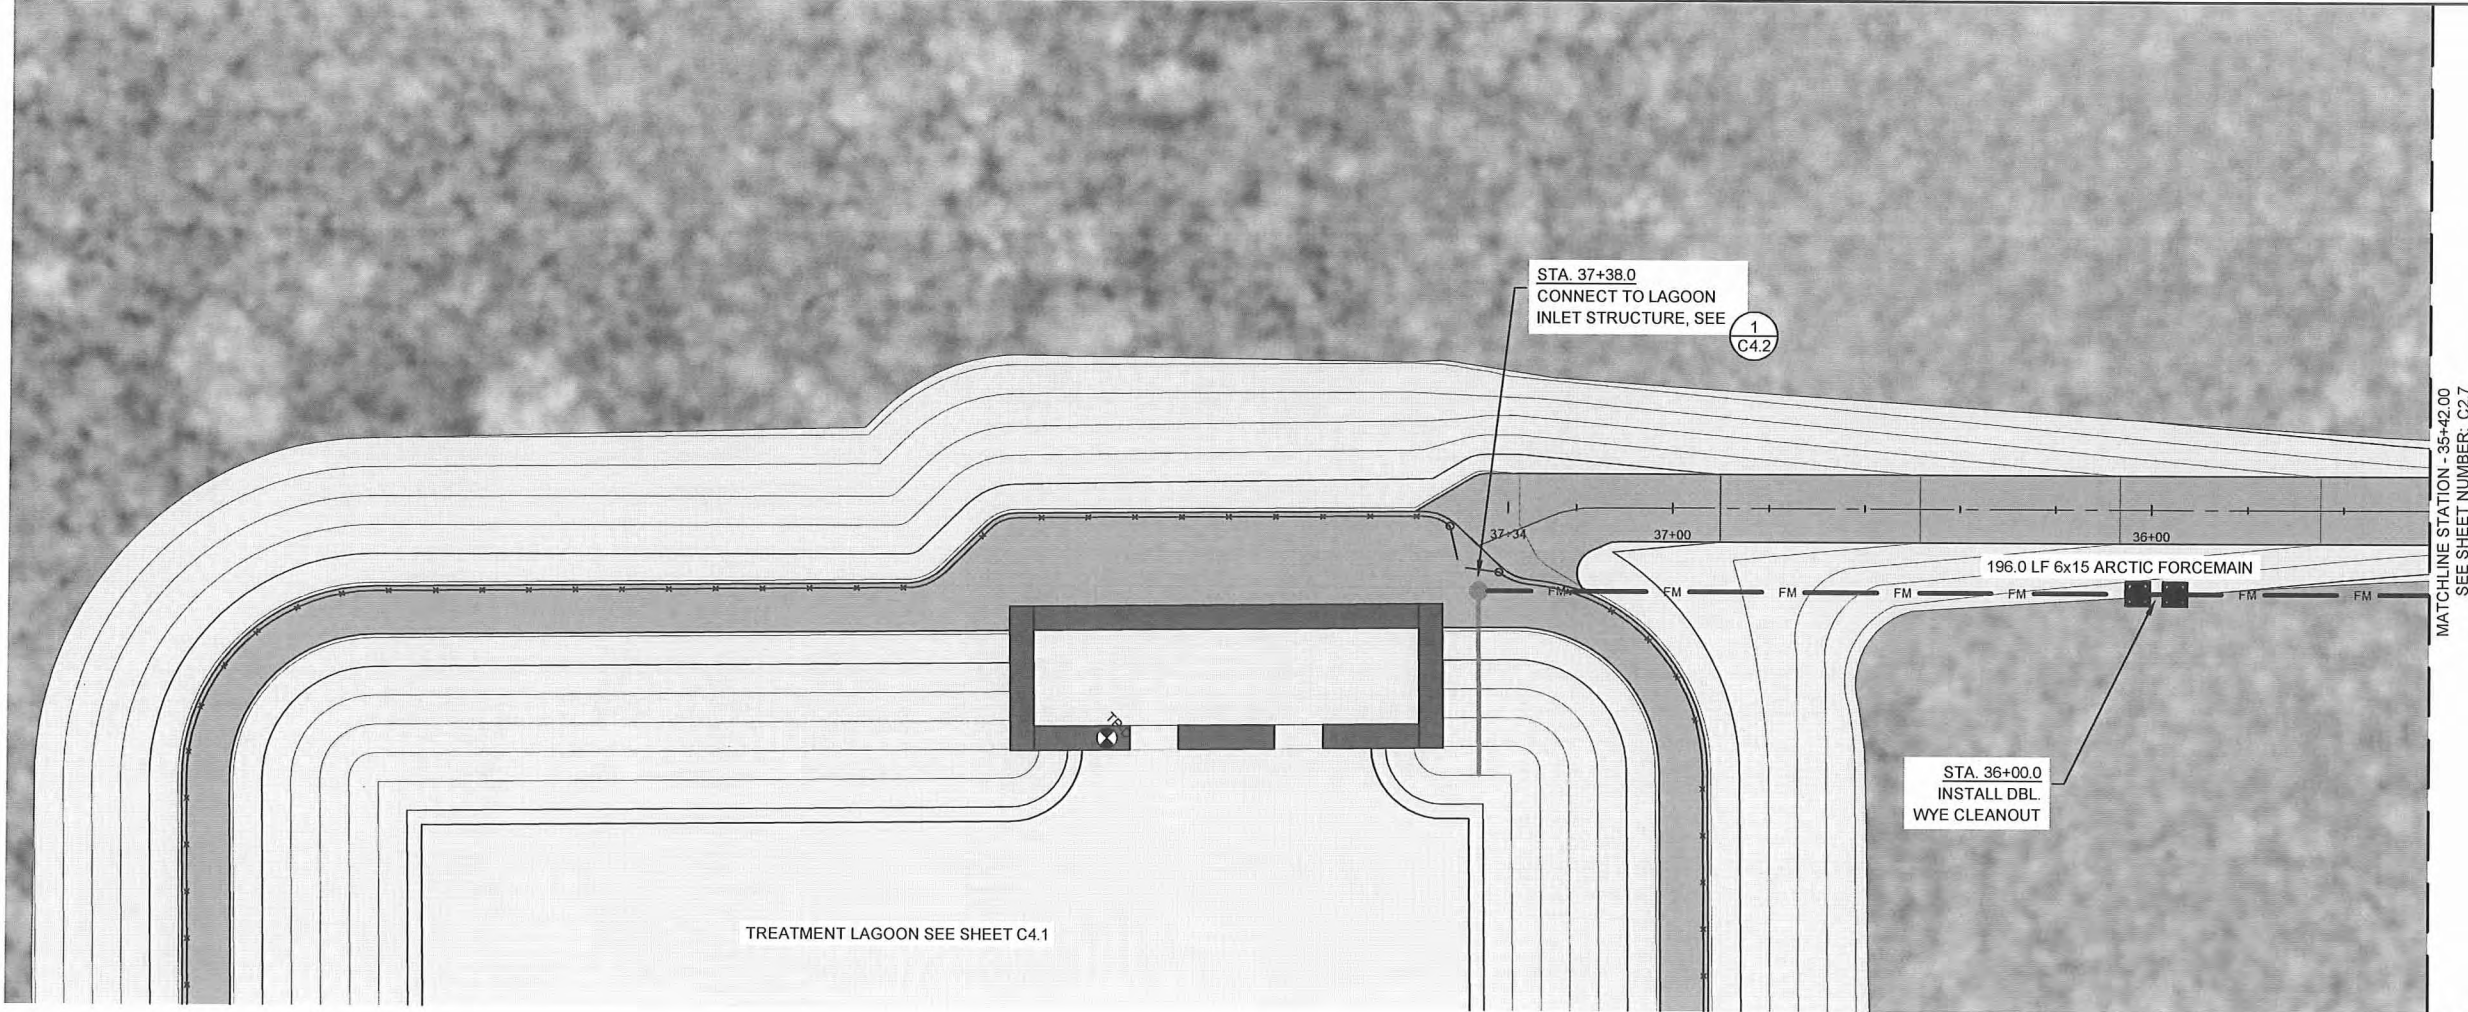

RECORD DRAWING CERTIFICATE
THESE DRAWINGS REFLECT RECORDED
INFORMATION OBTAINED DURING
CONSTRUCTION. INFORMATION PROVIDED
HEREIN IS ACCURATE TO THE BEST OF MY
KNOWLEDGE.

SCALE:
AS SHOWN
1" = 40'
IF ANY SCALE IS NOT
THIS SHEET, ADJUST
SCALES ACCORDINGLY



2010-11 WASTEWATER
SYSTEM IMPROVEMENTS
ROAD AND
FM1 FORCE MAIN
PLAN AND PROFILE
TULUKSAK, ALASKA





REVISION	BY	DATE
LAGOON RELOCATION	CM	8/10

Project No.	JUNE 2009
Date	LAP
Designed	CM
Drawn	LAP
Approved	


Sheet No.
C2.8

G:\ACAD\TULUKSAK\TLT0901 2008 Waste water disposal area\C1.1 thru C1.4 and C2.9.dwg, 1/11/2011 1:06:51 PM, Flash, LANIER MP C2050_LD520C PCL 6BLK WHIT, pc3

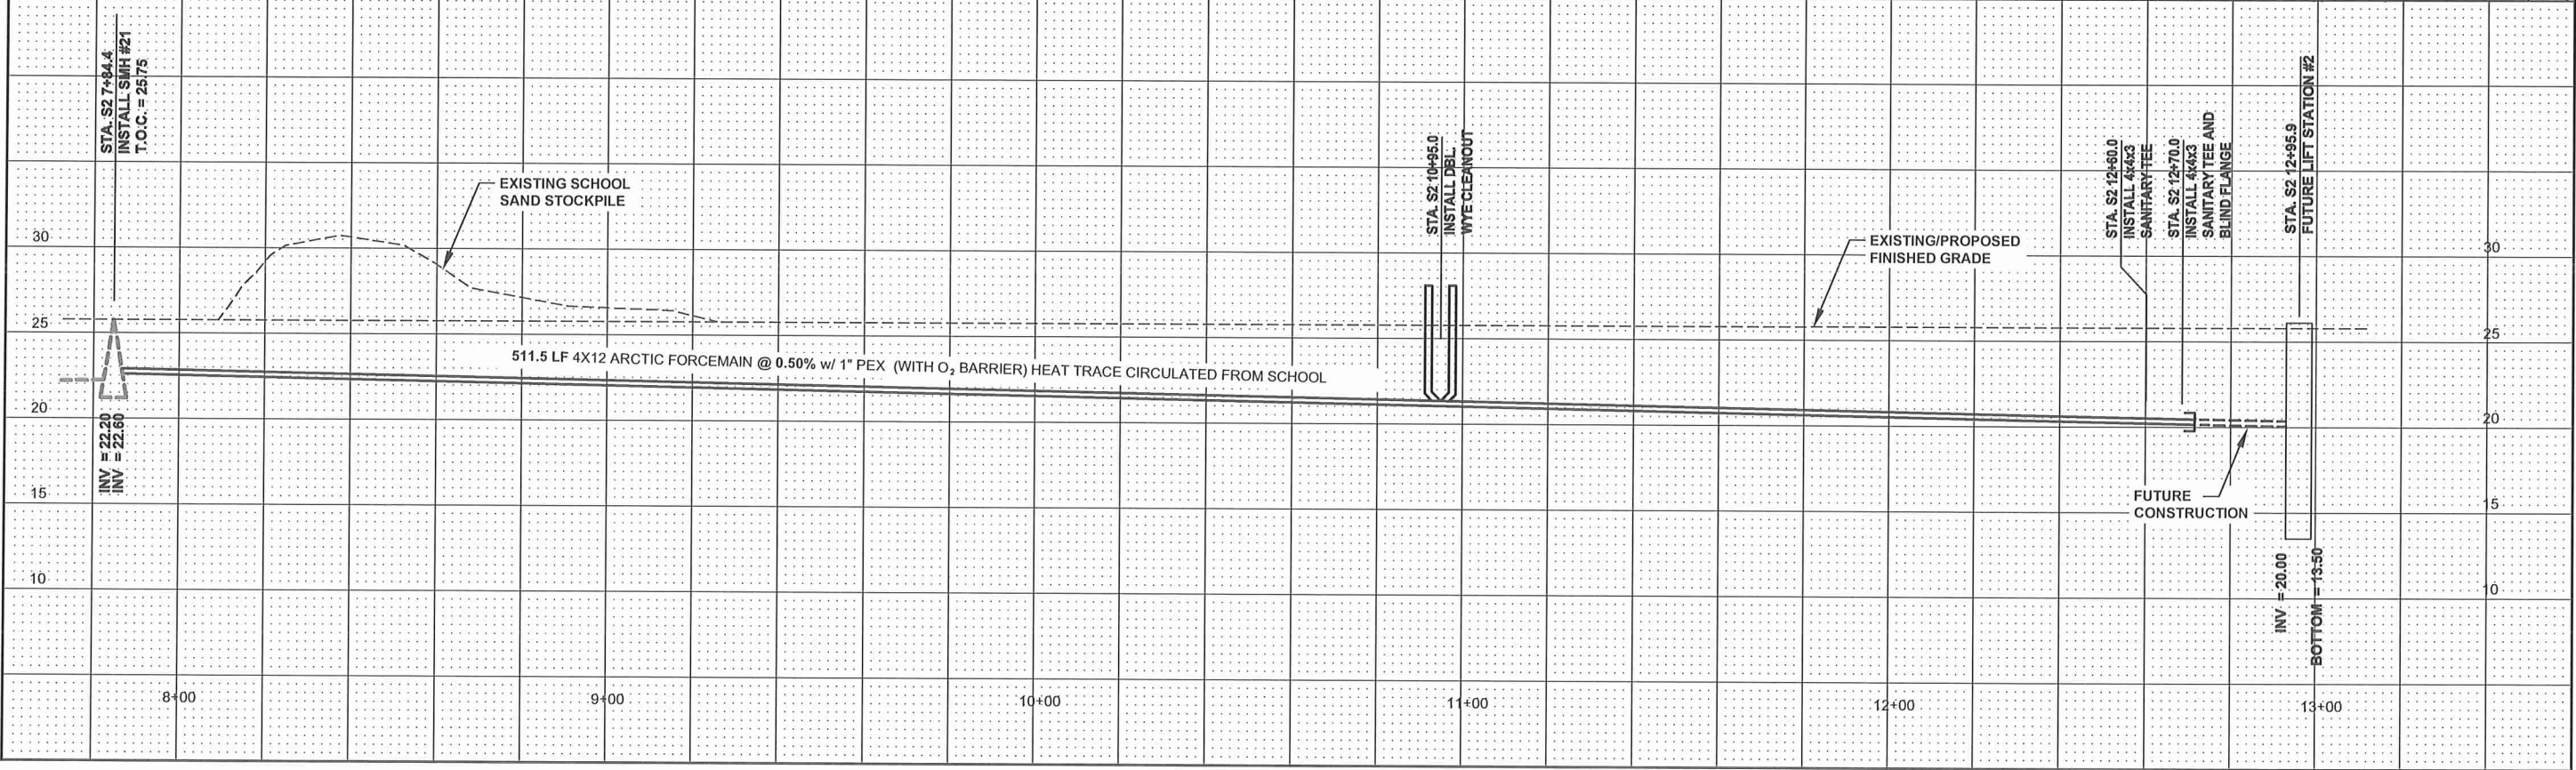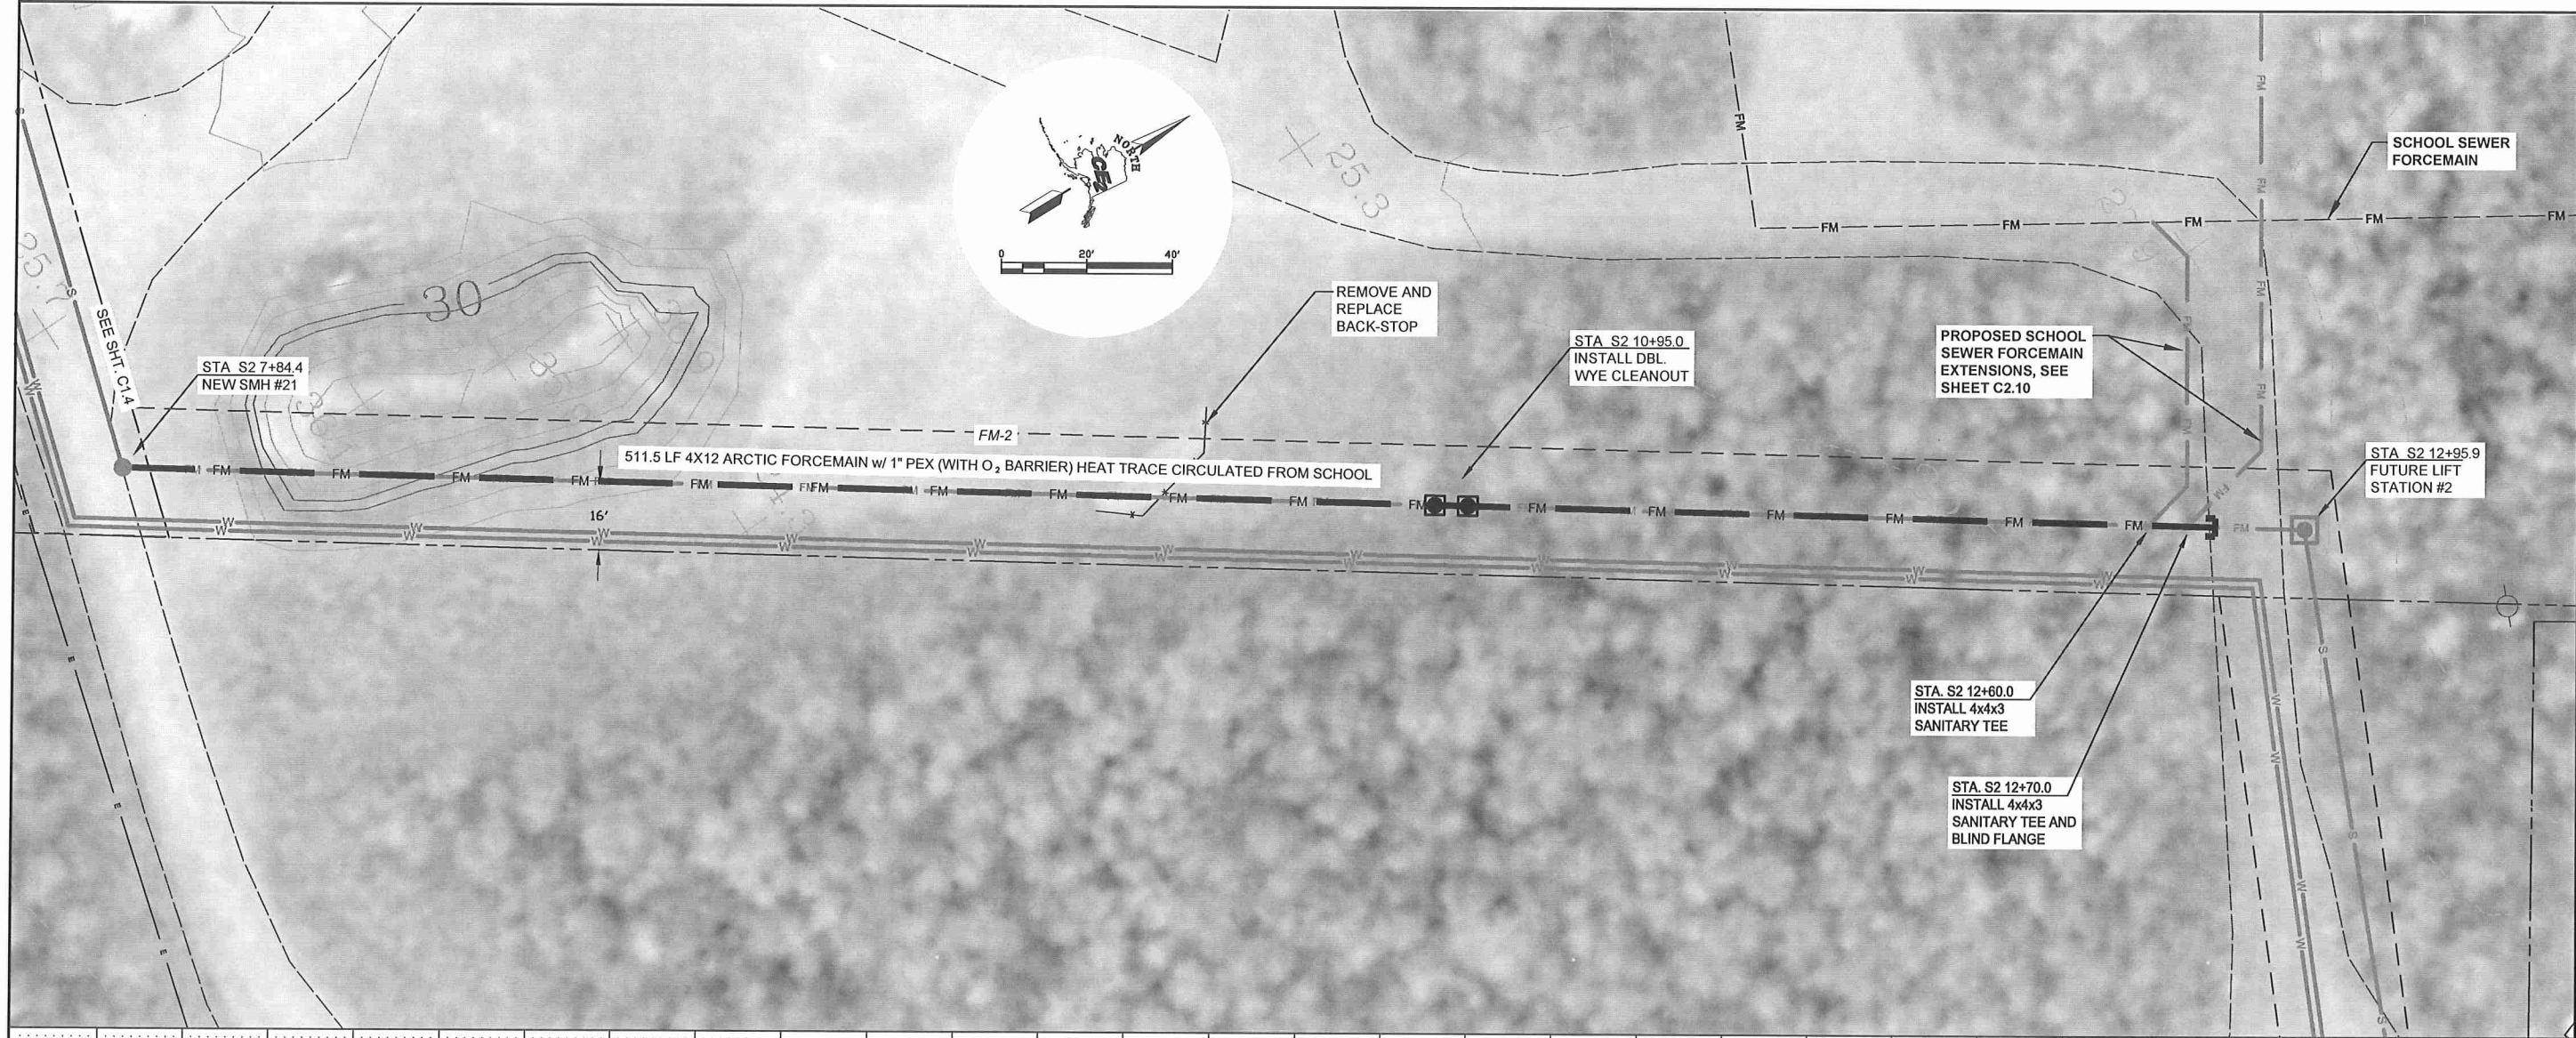

RECORD DRAWING CERTIFICATE
THESE DRAWINGS REFLECT RECORDED INFORMATION OBTAINED DURING CONSTRUCTION. INFORMATION PROVIDED HEREIN IS ACCURATE TO THE BEST OF MY KNOWLEDGE.

SCALE:
PLAN: 1"=20'
PROF: (H): 1"=20'
PROF: (V): 1"=5'
BAR IS ONE INCH ON ORIGINAL DRAWING
IF NOT ONE INCH ON THIS SHEET, ADJUST SCALES ACCORDINGLY

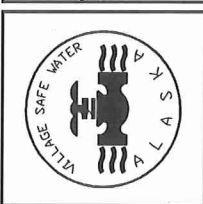

2010-11 WASTEWATER SYSTEM IMPROVEMENTS
FM2 FORCEMAIN PLAN AND PROFILE
TULUKSAK, ALASKA




REVISION	BY	DATE
LAGOON RELOCATION	CM	8/10

Project No.	June 2009
Date	LAP
Designed	LAW
Drawn	LAP
Approved	LAP

Sheet No. C2.9

G:\ACAD\TULUKSAK\TLT0901 2008 Waste water disposal area\C2.10 SCHOOL UTILITIES.dwg, 1/11/2011 1:27:13 PM, Flash, LANIER MP C2050_LD520C PCL 6BLK WHIT.pcl

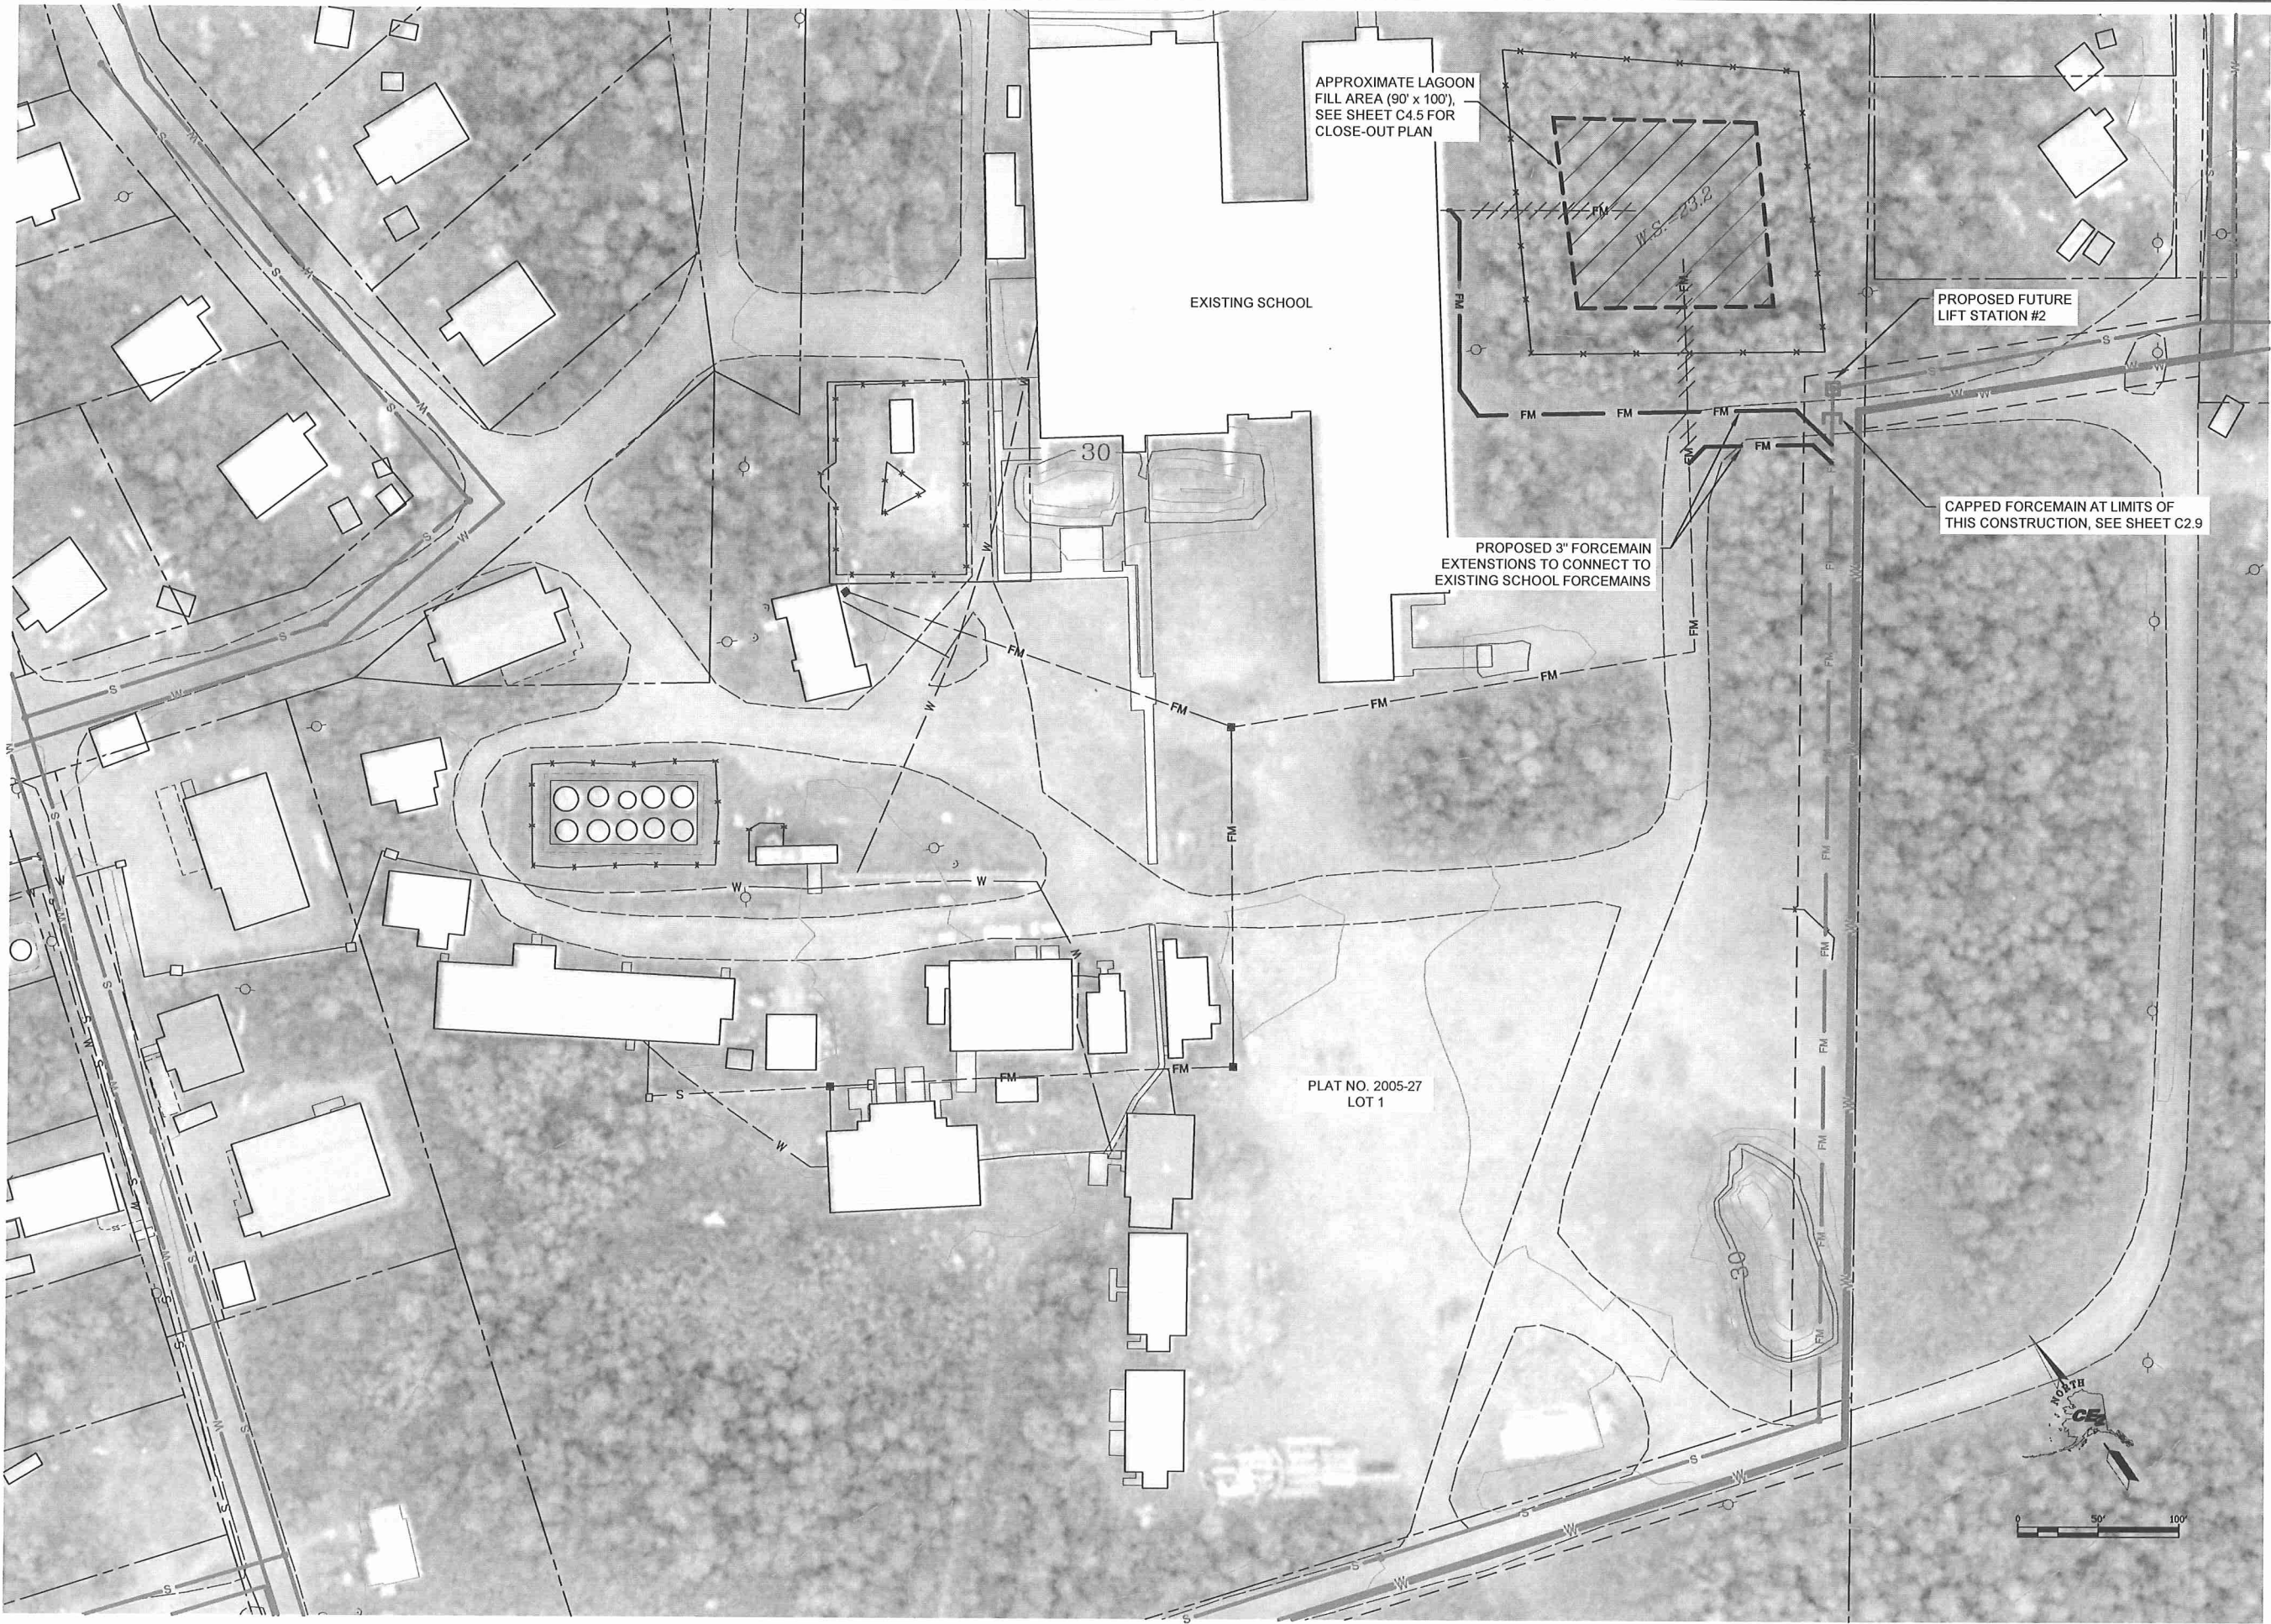

1 CONNECTION TO SCHOOL UTILITIES
C2.10

RECORD DRAWING CERTIFICATE
THESE DRAWINGS REFLECT RECORDED
INFORMATION OBTAINED DURING
CONSTRUCTION. INFORMATION PROVIDED
HEREIN IS ACCURATE TO THE BEST OF MY
KNOWLEDGE.

SCALE:
AS SHOWN
1" = 100'
IF NOT ONE INCH ON
SCALE ACCORDINGLY

ALLIANCE WATER
TULAKSAK, ALASKA

STATE OF ALASKA
49TH
PROFESSIONAL ENGINEER
NO. CE 9622
1/1/11

2010-11 WASTEWATER
SYSTEM IMPROVEMENTS
CONNECTION TO
SCHOOL UTILITIES
TULUKSAK, ALASKA



CFE2
ENGINEERS, INC.
PO BOX 22346 ANCHORAGE, AK 99523 PH: 907-349-1010 FAX: 907-349-1015

REVISION	BY	DATE

Project No. _____	Date <u>SEPT 2010</u>	Designed <u>LAP</u>	Drawn <u>CM</u>	Approved <u>LAP</u>
-------------------	-----------------------	---------------------	-----------------	---------------------

Sheet No. **C2.10**

G:\ACAD\TULUKSAK\TLT0901 2008 Waste water disposal area\C3.1 LIFT STATION SITE PLAN.dwg, 1/11/2011 1:30:13 PM, Flash, LANIER MP C2050_L0520C PCL 6BLK WHIT.p3

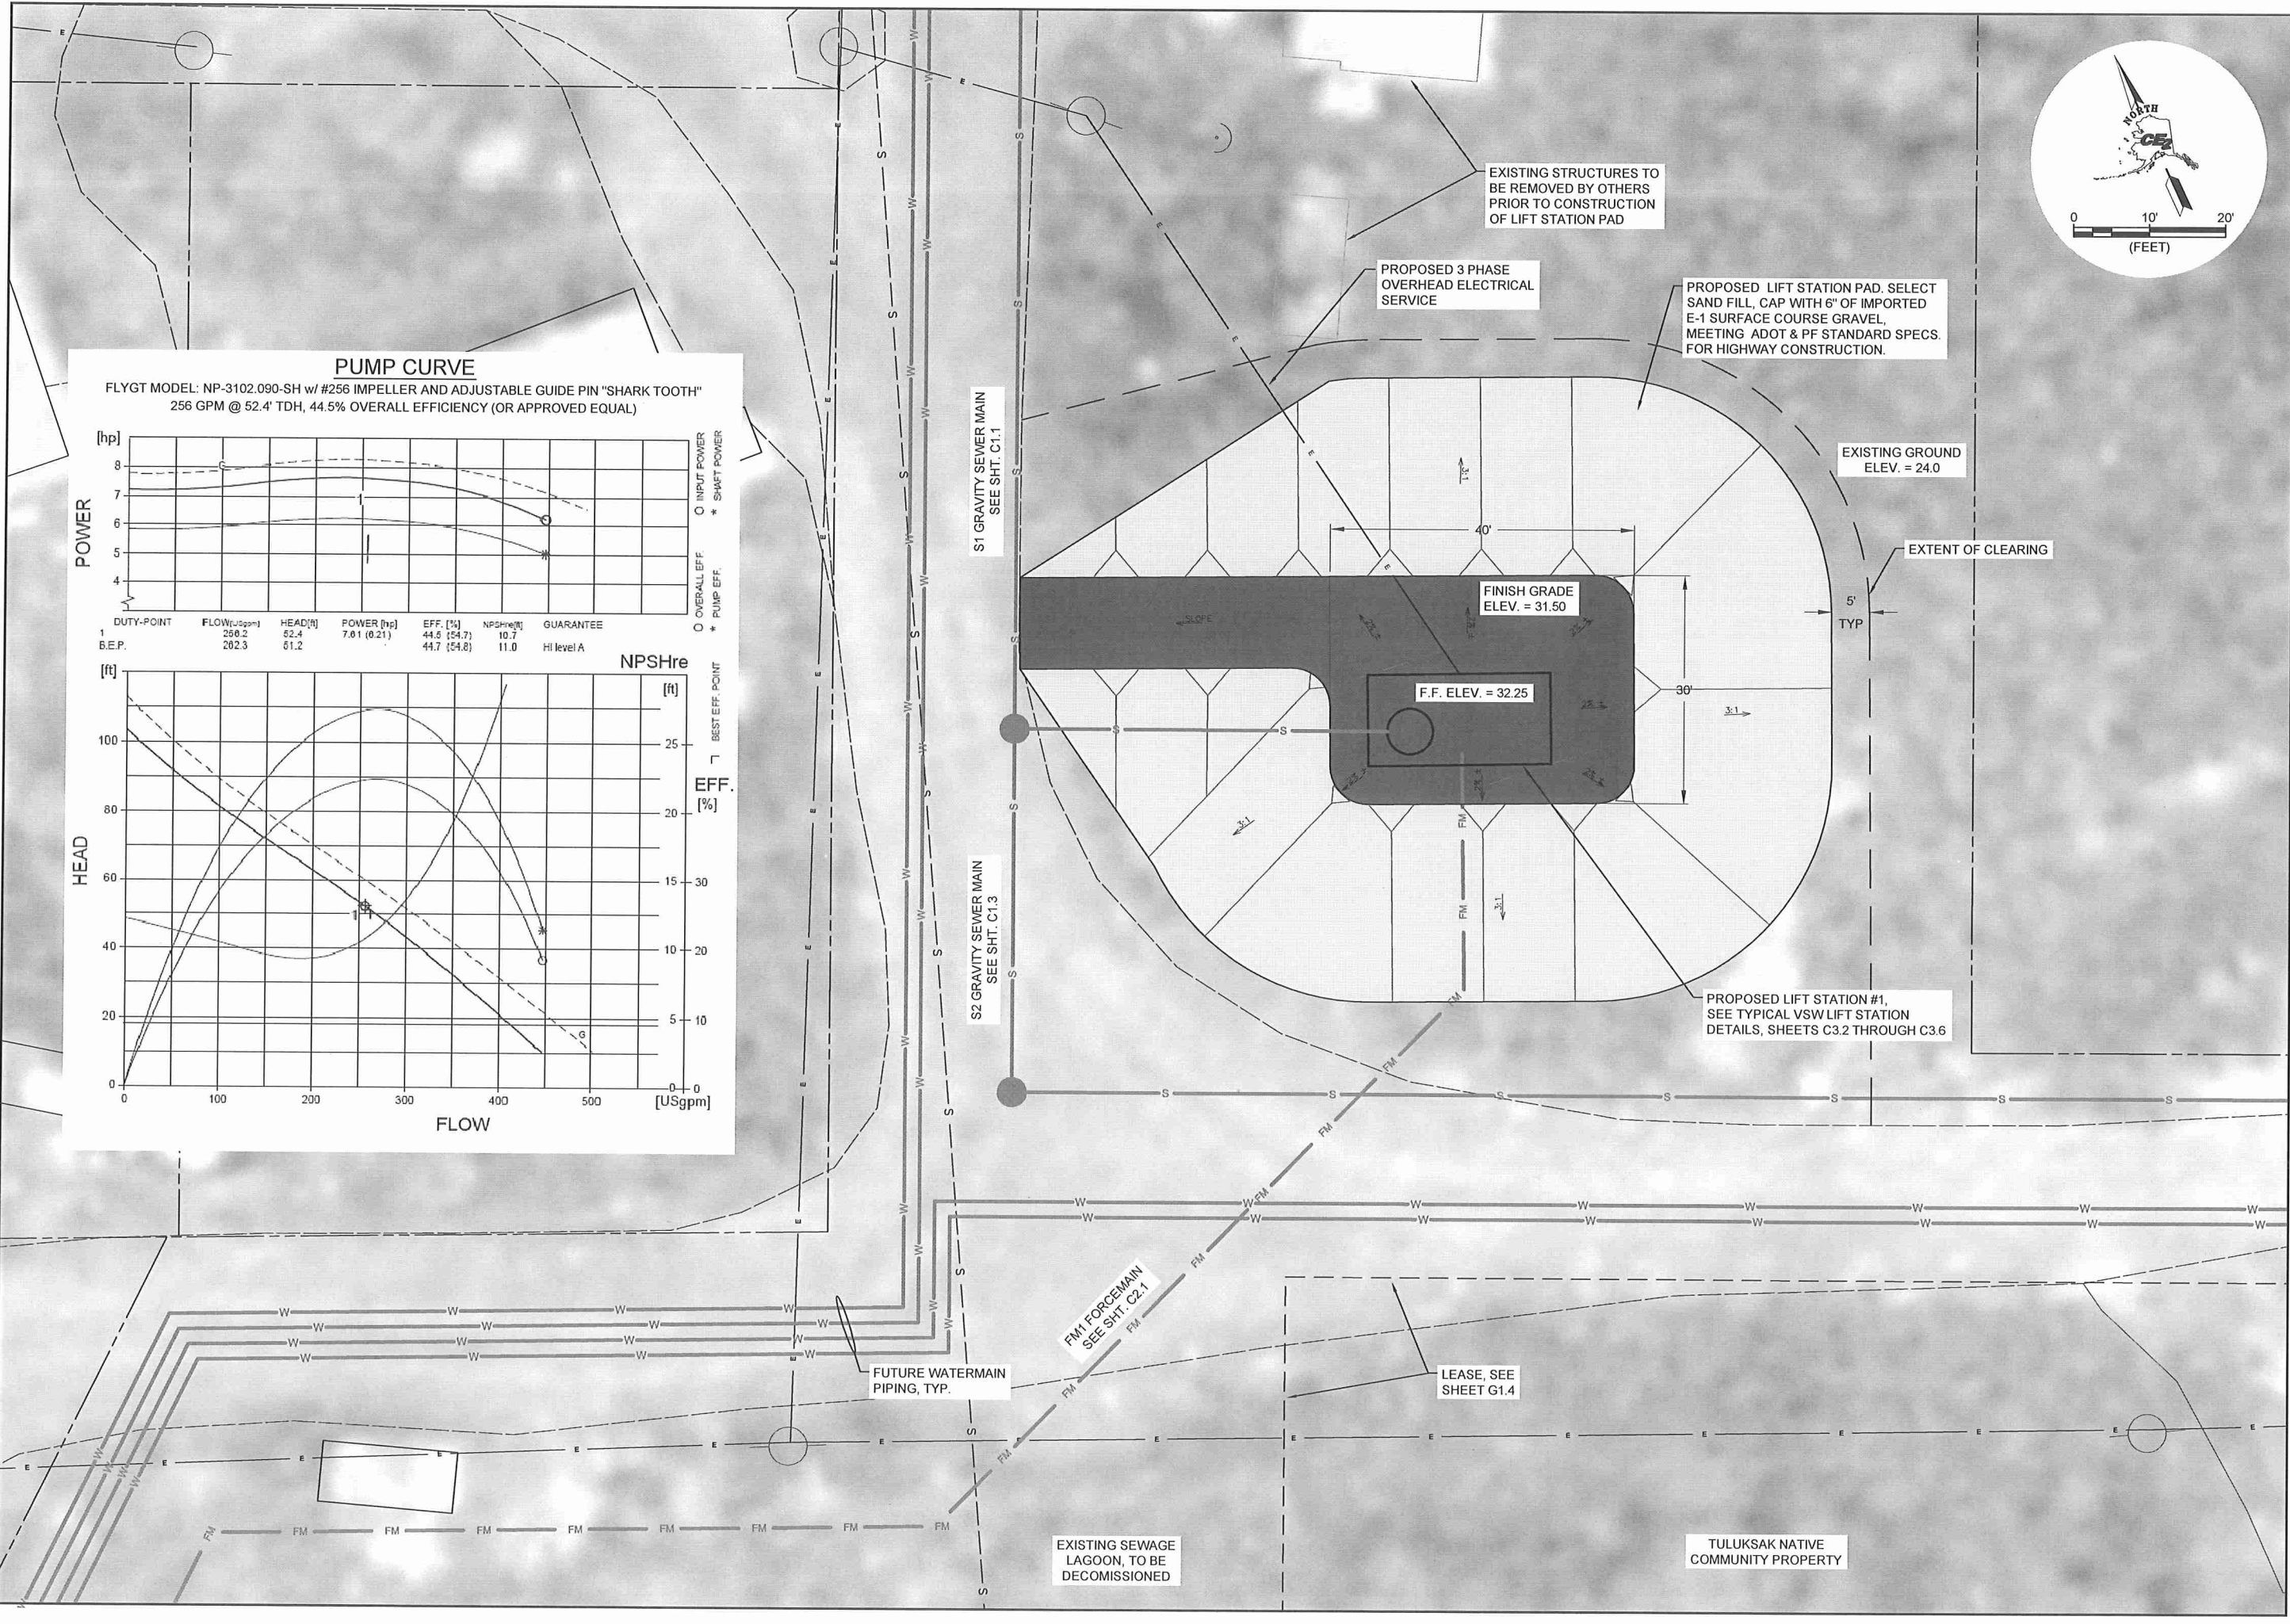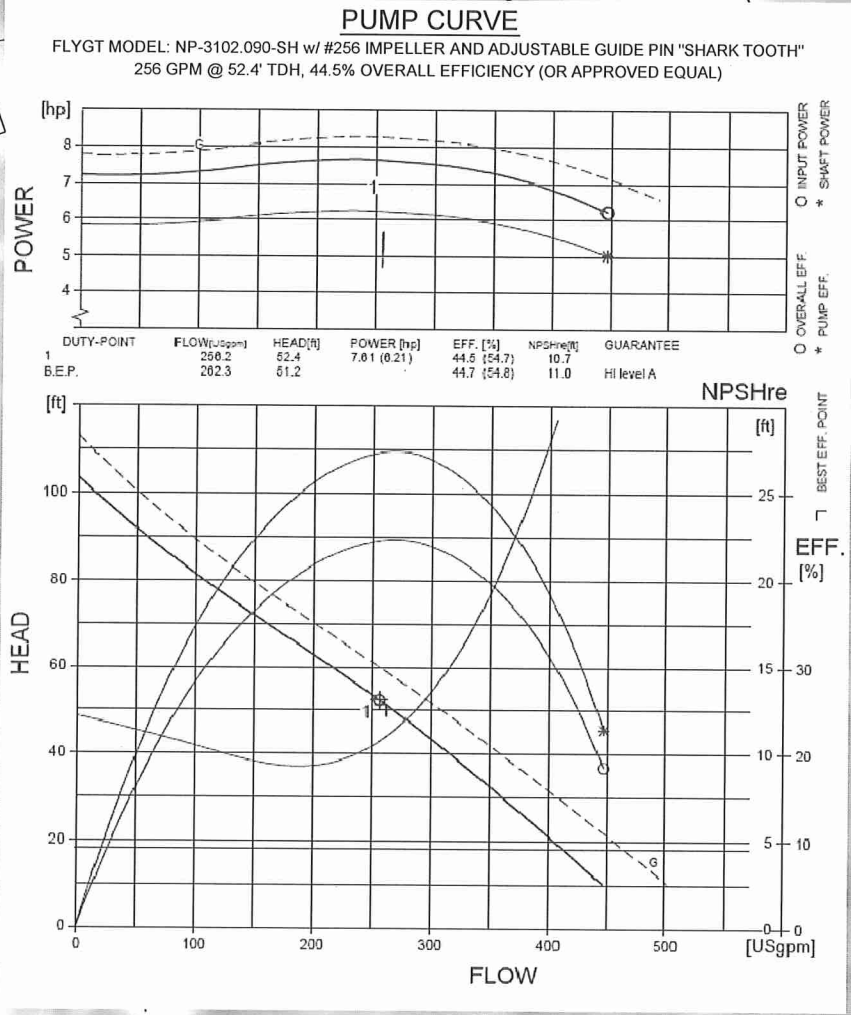

RECORD DRAWING CERTIFICATE
THESE DRAWINGS REFLECT RECORDED INFORMATION OBTAINED DURING CONSTRUCTION. INFORMATION PROVIDED HEREIN IS ACCURATE TO THE BEST OF MY KNOWLEDGE.

SCALE: AS SHOWN

DATE: _____

NAME: _____

PROJECT: _____

DATE: JUNE 2009

DESIGNED: JFK

DRAWN: CM

APPROVED: LAP

SHEET NO. C3.1

2010-11 WASTEWATER SYSTEM IMPROVEMENTS

LIFT STATION #1 SITE PLAN AND PUMP CURVE

TULUKSAK, ALASKA

CE2
ENGINEERS, INC.

PO BOX 22046 ANCHORAGE, AK 99523 PH: 907-349-1010 FAX: 907-349-1015

G:\ACAD\TULUKSAK\T10901 2008 Waste water disposal area\C3.2_THRU_3.6 revised format.dwg, 1/11/2011 12:57:46 PM, gmerz, LANIER MP C2050_LD520C PCL 6.pcl3

GENERAL CONSTRUCTION NOTES:

1. INSTALL 6 MIL VISQUEEN UNDER SLAB.

FOUNDATION CONSTRUCTION NOTES:

1. INSTALL BOARD STOCK INSULATION TO 18" BELOW TOP OF SLAB. BOARD STOCK CAN BE USED AS FORM MATERIAL WITH PROPER SUPPORT.
2. NFS SAND FILL TO 12" BELOW BOTTOM OF SLAB. COMPACT SUB GRADE PRIOR TO PLACEMENT. GRAVEL PLACED IN 6" LIFTS.
3. THE WET WELL WILL BE A PRE-CAST MANHOLE A SPECIFIED IN THE DRAWINGS.
4. CAST-IN-PLACE CONCRETE MUST HAVE A MINIMUM COMPRESSIVE STRENGTH OF 3000 PSI AT 28 DAYS. EACH YARD OF CONCRETE MUST CONTAIN NOT LESS THAN 5-1/2 SACKS OF CEMENT AND NOT MORE THAN 6.5 GALLONS OF WATER PER SACK OF CEMENT.
5. DEFORMED REINFORCING STEEL MUST CONFORM TO ASTM SPECIFICATION A615 AND HAVE A MINIMUM YIELD STRENGTH OF 60,000 PSI. LAP BARS MUST BE A MINIMUM OF 30 DIAMETERS. REINFORCING STEEL LAYOUT AND PLACING WILL CONFORM TO THE STANDARD BUILDING CODE REQUIREMENTS FOR REINFORCED CONCRETE (ACI 318-83).
6. WELDED WIRE FABRIC FOR ENTRY SLAB WILL CONFORM TO ASTM A185. LAPS TO BE ONE CROSSWISE SPACING PLUS 1-1/2".
7. CONCRETE COVER FOR THE REINFORCING STEEL MUST BE 3 INCHES FOR THE FOOTINGS AND TWO INCHES FOR THE WALLS AND SLAB.
8. METAL ROOFING WILL CONSIST OF 1-1/2" TWIN RIB ALUMINUM.
9. THE SEALS ON THE PRE-CAST MANHOLE SECTIONS WILL BE RAMNEK.
10. THE INTERIOR OF THE LIFT STATION WET WELL, INCLUDING METAL PIPING, WILL BE PAINTED WITH 46H-413 HI-BUILD TNEPEC TAR, 13 DRY FILM MILLS.
11. THE LIFT STATION WILL BE FILLED AND PRESSURE TESTED FOR LEAKS BEFORE ANY EFFLUENT ENTERS THE STATION.
12. ALL CONSTRUCTION SHALL BE DONE IN A SAFE, WORKMANLIKE MANNER TO INDUSTRY STANDARDS AND IN CONFORMANCE WITH APPLICABLE LOCAL, STATE AND FEDERAL CODES AND REGULATIONS.
13. HANGERS AND ANCHORS USED FOR SUPPORTING HORIZONTAL PIPING SHALL BE OF MATERIAL OF SUFFICIENT STRENGTH AND ADEQUATELY ANCHORED TO MAINTAIN EACH SUPPORT'S PROPORTIONAL SHARE OF THE WEIGHT OF THE PIPE AND CONTENTS.
14. SUPPORTS FOR HORIZONTAL IRON PIPE SHALL BE PROVIDED AT INTERVALS OF NOT MORE THAN 10 FEET OR AS SHOWN ON THE PLANS. SUPPORTS SHALL BE ADEQUATE TO PREVENT STRESS AT JOINTS DUE TO SAGGING. SUPPORTS SHALL BE PROVIDED AT EACH HORIZONTAL BRANCH CONNECTION. SUSPENDED LINES SHALL BE SUITABLY BRACED TO PREVENT HORIZONTAL MOVEMENT.


SEWAGE LIFT STATION
ELECTRICAL CODE REVIEW

1999 NFPA 820 STANDARD FOR FIRE PROTECTION IN WASTEWATER TREATMENT AND COLLECTION FACILITIES CHAPTER 2 TABLE 2-2 OUTLINES THE REQUIREMENTS AND AREA CLASSIFICATIONS FOR THE INSTALLATION CONFIGURATIONS TYPICALLY USED. THIS INSTALLATION IS AN ABOVE GRADE WASTEWATER PUMPING STATION WHERE THE CONTROL ROOM IS PHYSICALLY SEPARATED WITH NO PERSONNEL ACCESS TO THE WET WELL. THE REQUIREMENTS CAN BE FOUND IN TABLE 2-2.

THE TABLE STATES THE FOLLOWING FOR THE CONTROL ROOM (TABLE 2.2 ITEM 18):
FIRE AND EXPLOSION HAZARD: NOT APPLICABLE
VENTILATION: NOT REQUIRED
EXTENT OF CLASSIFIED AREA: NOT APPLICABLE
NEC-AREA ELECTRICAL CLASSIFICATION: UNCLASSIFIED

THE TABLE STATES THE FOLLOWING FOR THE WET WELL SIDE (TABLE 2.2 ITEM 19):
FIRE AND EXPLOSION HAZARD: POSSIBLE IGNITION OF FLAMMABLE GASES
VENTILATION: NONE (CLASS 1, DIV. 1); 12 AIR CHANGES OR MORE (CLASS 1, DIV. 2)
EXTENT OF CLASSIFIED AREA: ENTIRE SPACE OR ROOM
NEC-AREA ELECTRICAL CLASSIFICATION: DIVISION 1 OR 2 DEPENDING ON VENTILATION

THE INSTALLATION WILL ALLOW THE USE OF UNCLASSIFIED EQUIPMENT AND WIRING METHODS IN THE CONTROL ROOM. HOWEVER, THE SENSING TRANSDUCER MUST HAVE THE RACEWAY SEALED AT THE BOUNDARY INTO THE CLASS 1, DIVISION 1 WET WELL.

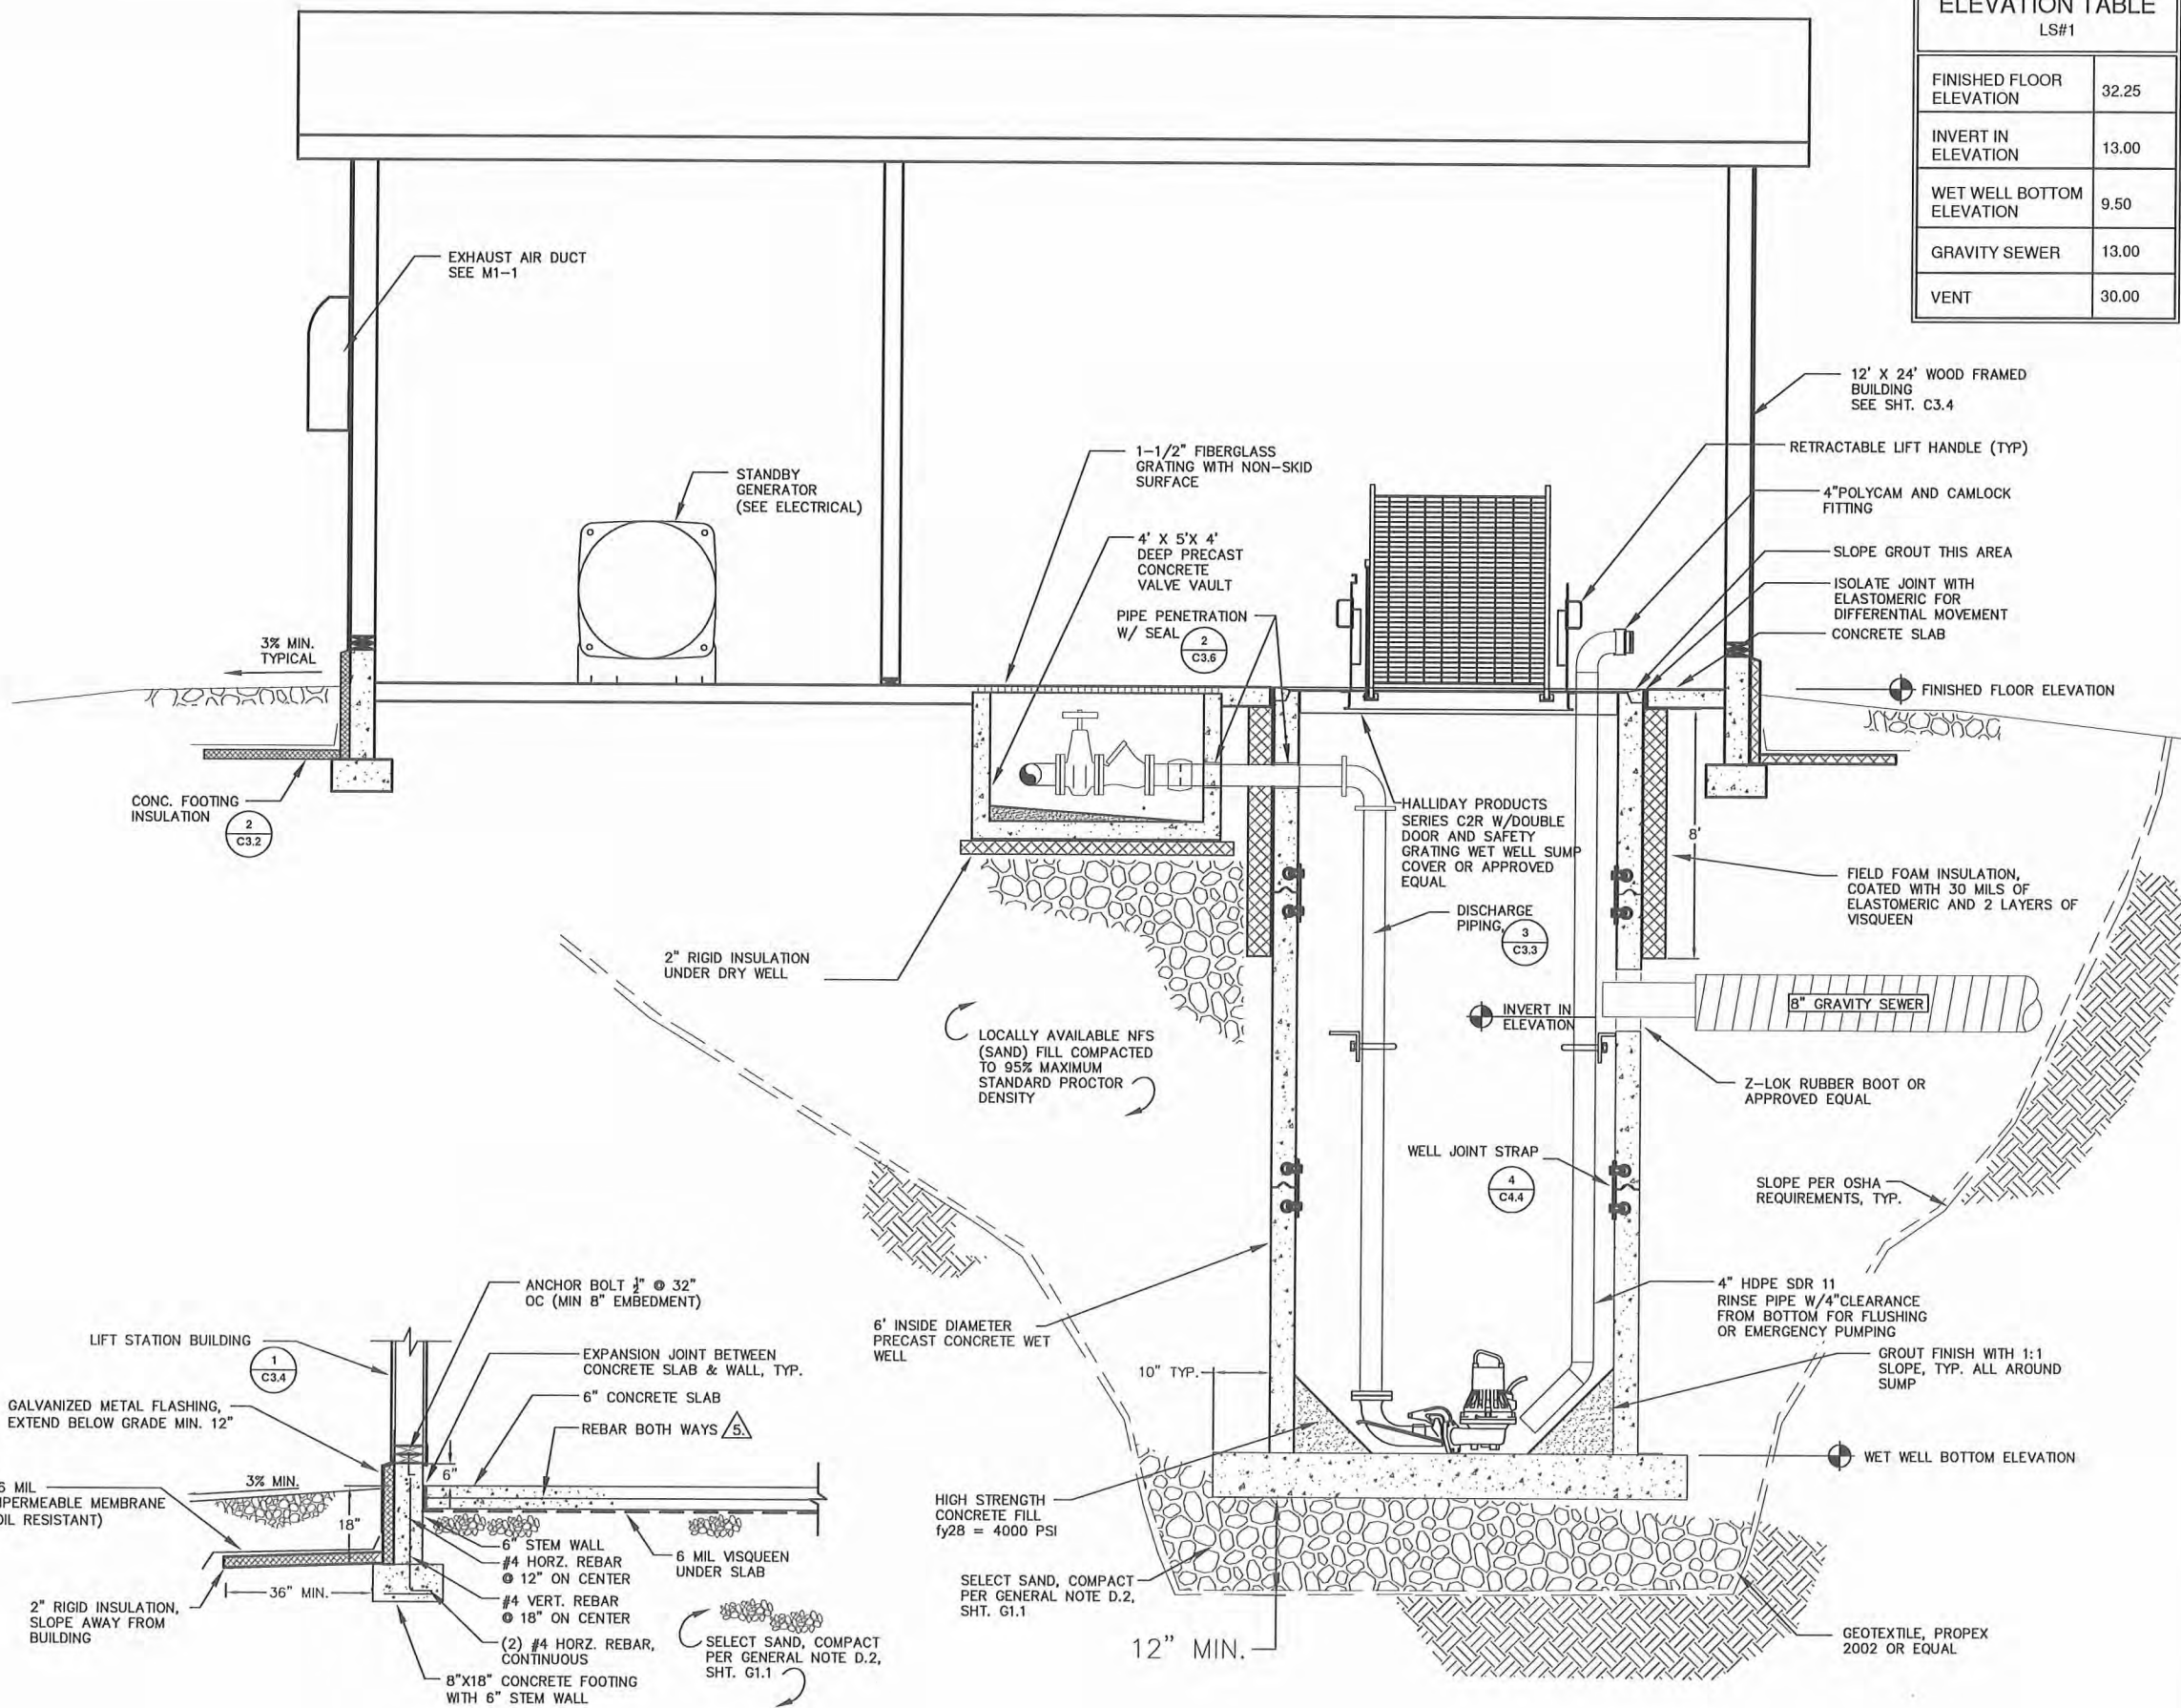

ELEVATION TABLE	
LS#1	
FINISHED FLOOR ELEVATION	32.25
INVERT IN ELEVATION	13.00
WET WELL BOTTOM ELEVATION	9.50
GRAVITY SEWER	13.00
VENT	30.00

2 TYPICAL WALL CONNECT/SLAB DETAIL
C3.2 NTS

3 WET WELL FOUNDATION DETAIL
C3.2 NTS

RECORD DRAWING CERTIFICATE

THESE DRAWINGS REFLECT RECORDED INFORMATION OBTAINED DURING CONSTRUCTION. INFORMATION PROVIDED HEREIN IS ACCURATE TO THE BEST OF MY KNOWLEDGE.

SCALE: 1" = 1'-0"

NAME: _____ DATE: _____

STATE OF ALASKA

REGISTERED PROFESSIONAL ENGINEER

NO. CE 9802

EXPIRATION DATE 11/11/11

LOUIS A. PERROWE

2010-11 WASTEWATER SYSTEM IMPROVEMENTS

LIFT STATION DETAILS

TULUKSAK, ALASKA

CE2 ENGINEERS, INC.


PO BOX 22949 ANCHORAGE, AK 99523 PH: 907-546-0101 FAX: 907-546-1015

REVISION	BY	DATE

Project No.	JUNE 2009
Date	LAP
Designed	VSUW
Drawn	LAP
Approved	

Sheet No. C3.2

G:\ACAD\TULUKSAK\TLT0901 2008 Waste water disposal area\C3.2_THRU_3.6 revised format.dwg, 1/11/2011 1:00:13 PM, cmez, LANIER MP C2050_LDS20C PCL 6.p3

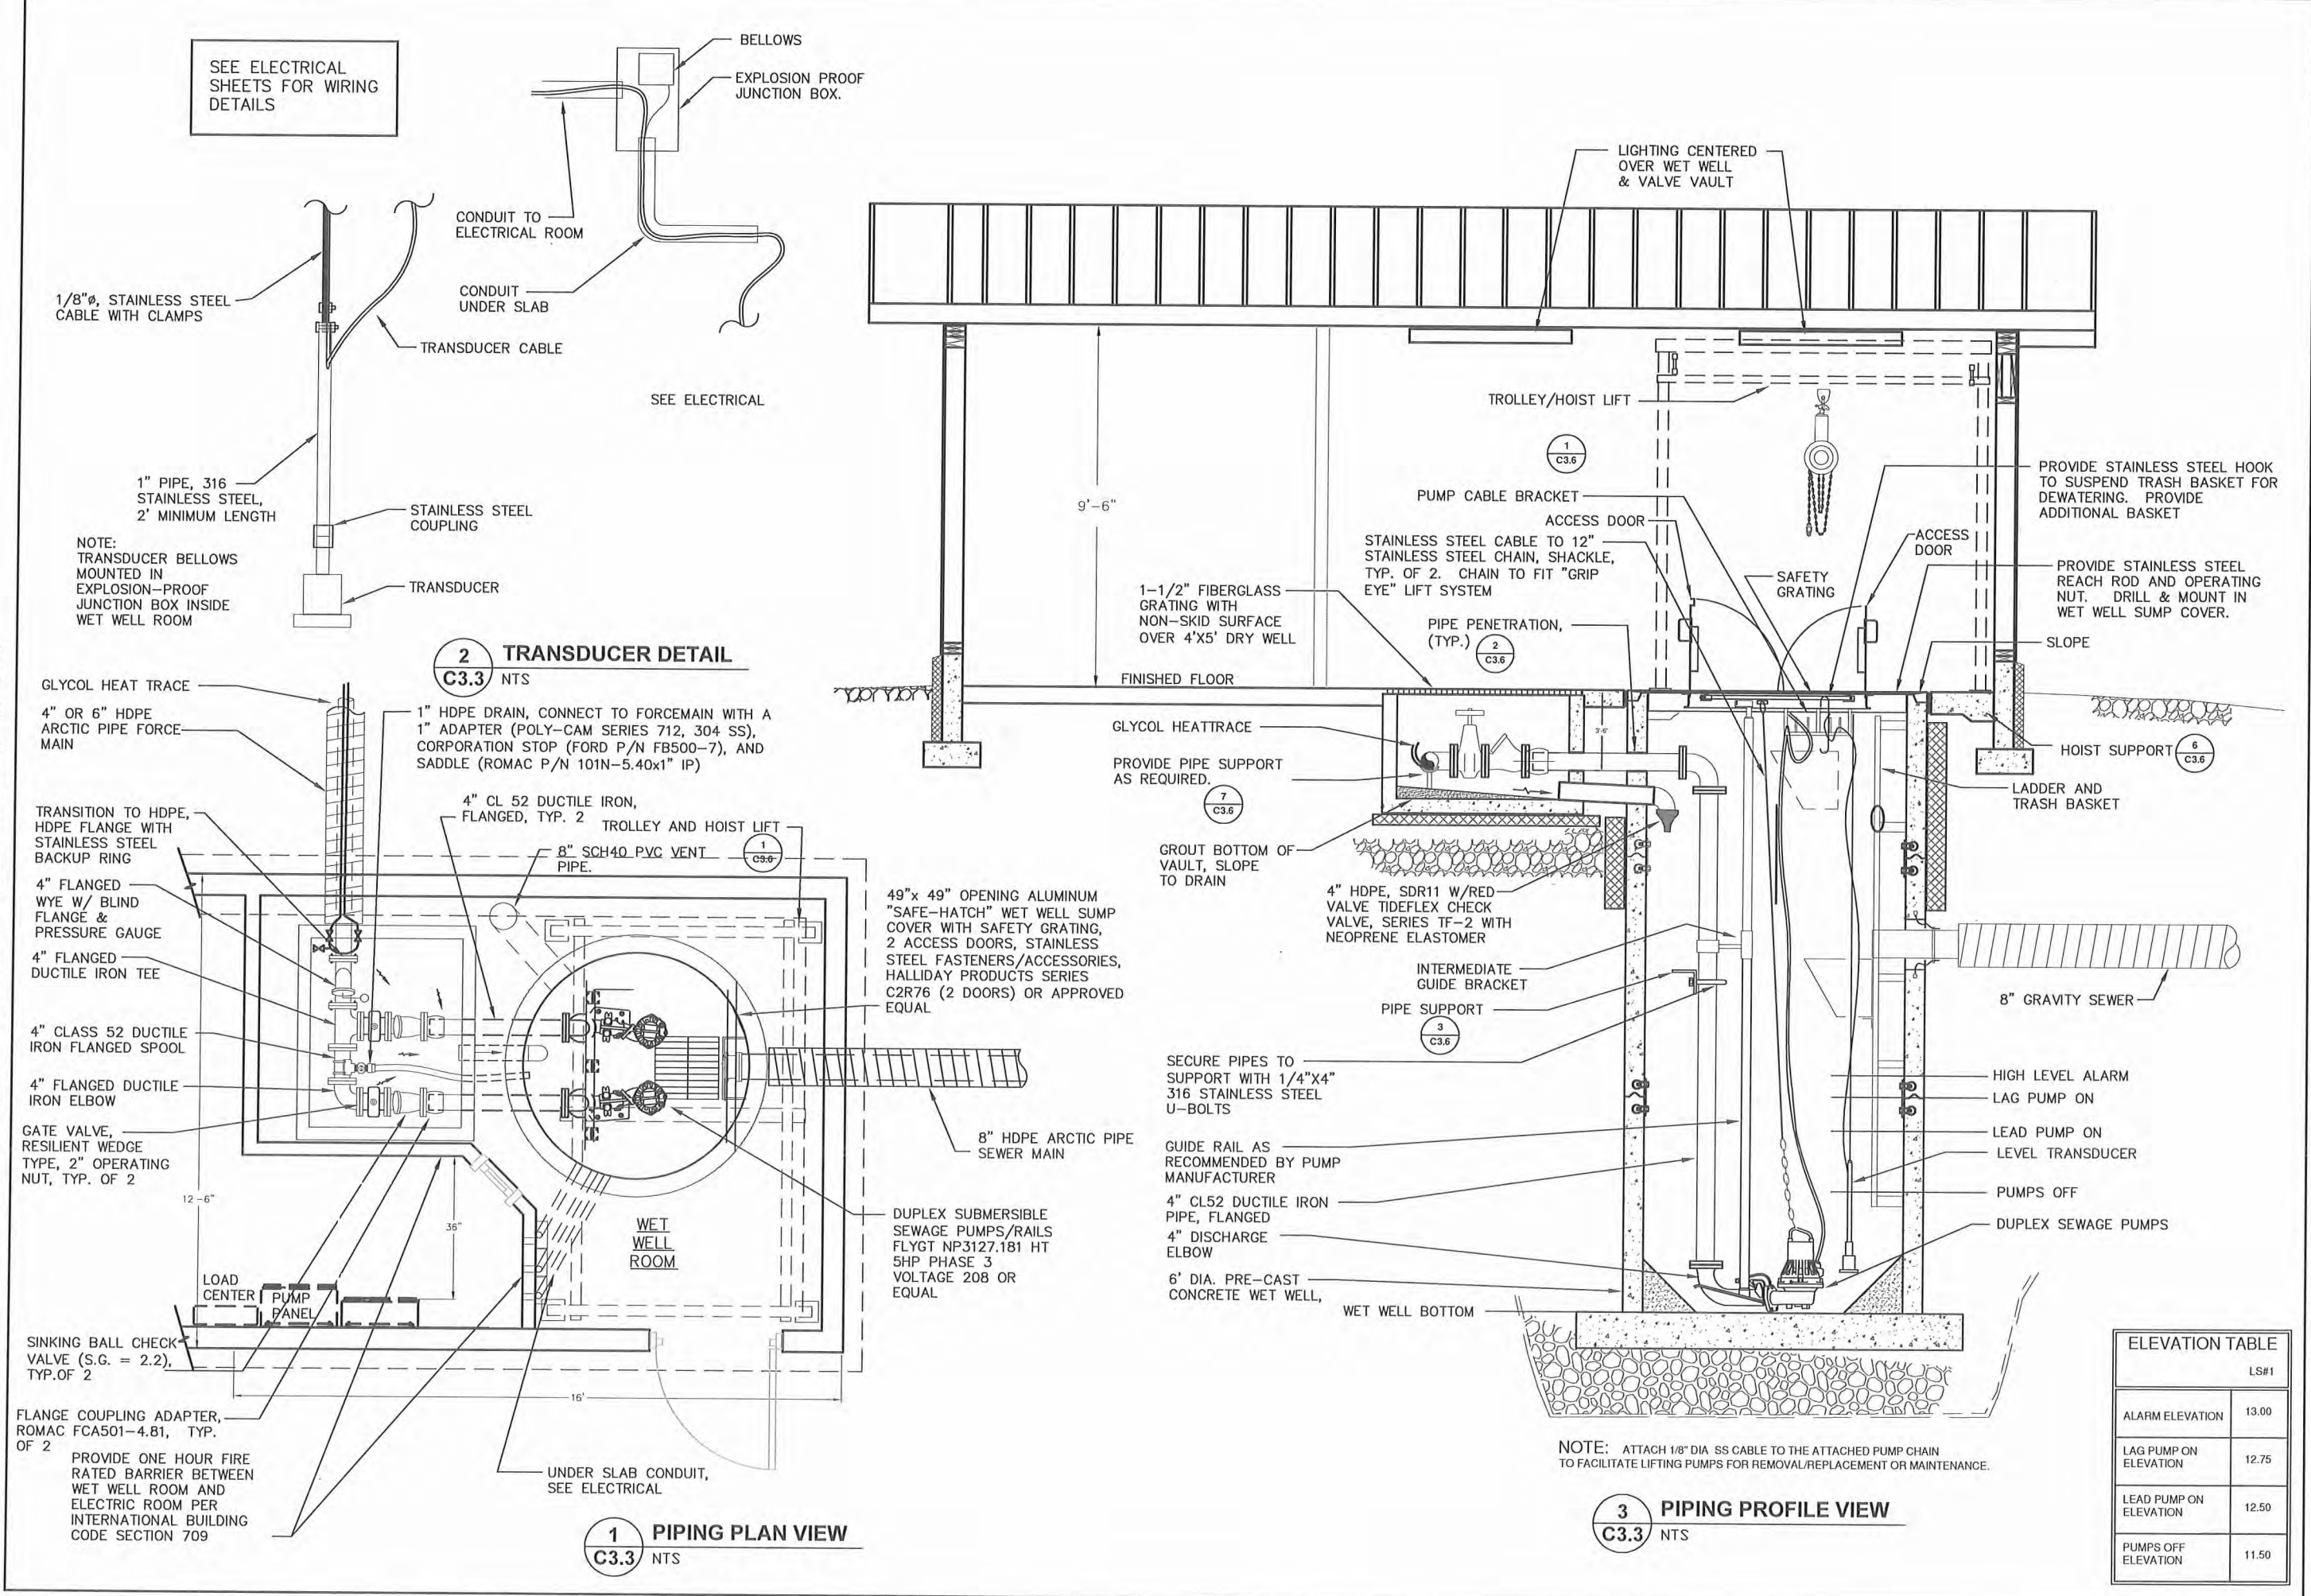

ELEVATION TABLE	
LS#1	
ALARM ELEVATION	13.00
LAG PUMP ON ELEVATION	12.75
LEAD PUMP ON ELEVATION	12.50
PUMPS OFF ELEVATION	11.50

RECORD DRAWING CERTIFICATE
THESE DRAWINGS REFLECT RECORDED
INFORMATION OBTAINED DURING
CONSTRUCTION. INFORMATION PROVIDED
HEREIN IS ACCURATE TO THE BEST OF MY
KNOWLEDGE.

SCALE:
1" = 1'-0"
IF NOT SHOWN IN ORIGINAL DRAWING
IF NOT SHOWN IN ORIGINAL DRAWING
SCALE: 1" = 1'-0"

2010-11 WASTEWATER
SYSTEM IMPROVEMENTS
LIFT STATION PIPING
PLAN AND DETAILS
TULUKSAK, ALASKA



PO BOX 22549 ANCHORAGE, AK 99523 PH: 907-346-0100 FAX: 907-346-1015

REVISION	BY	DATE

Project No.	Date	Designed	Drawn	Approved
	JUNE 2009	LAP	YSW	LAP



Sheet No. C3.3

G:\ACAD\TULUKSAK\T10901 2008 Waste water disposal area\C3.2_THRU_3.6 revised format.dwg, 1/11/2011 1:14:22 PM, cmerz, LANIER MP C2050_LD520C PCL 6.pcl

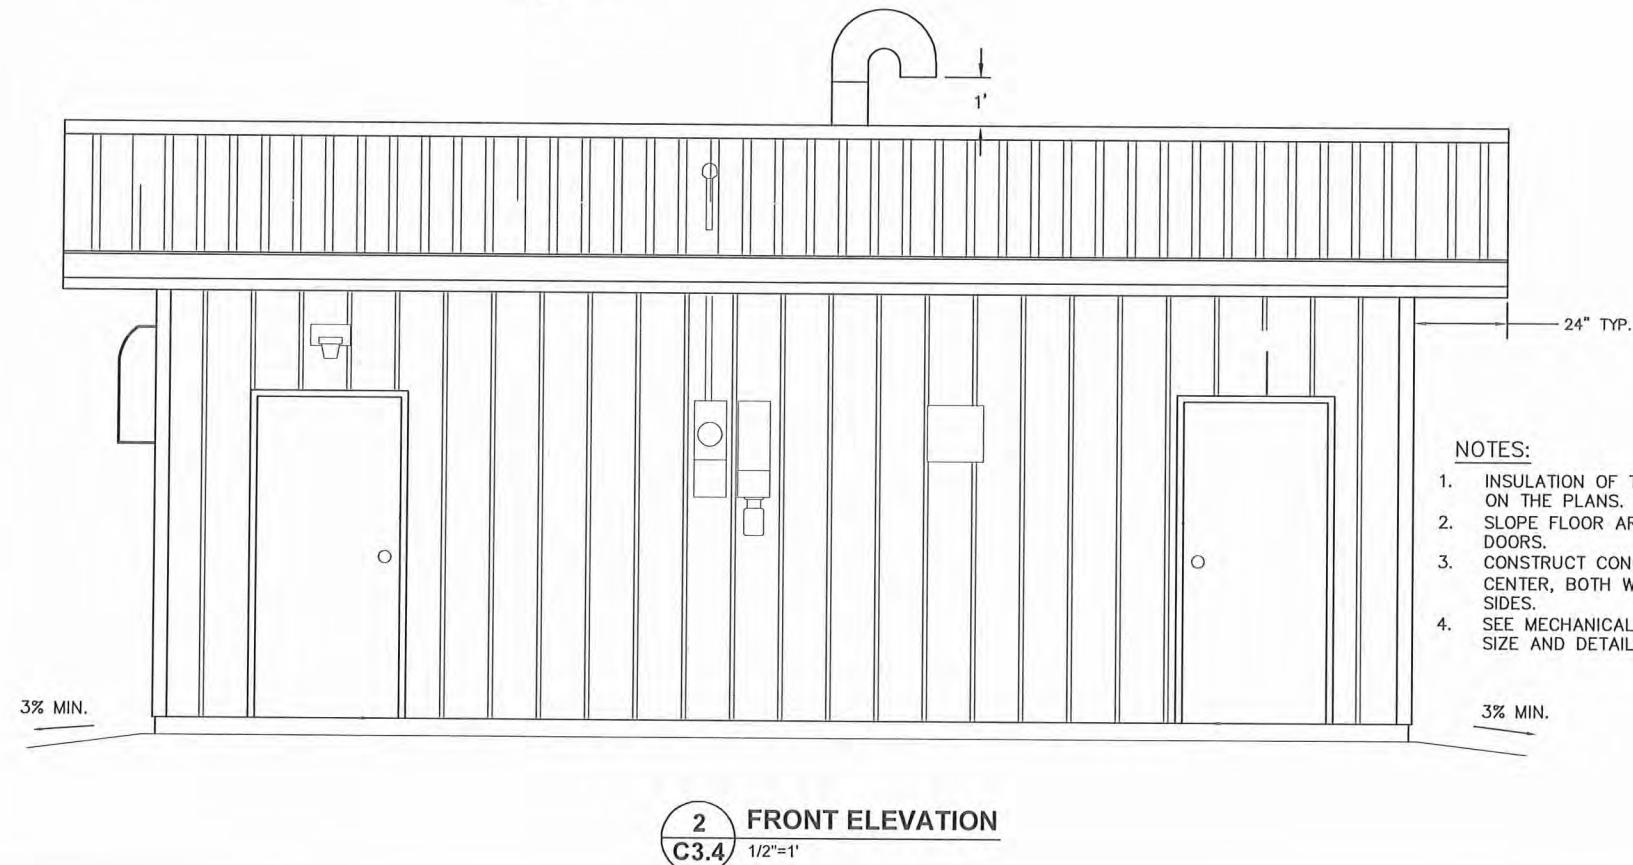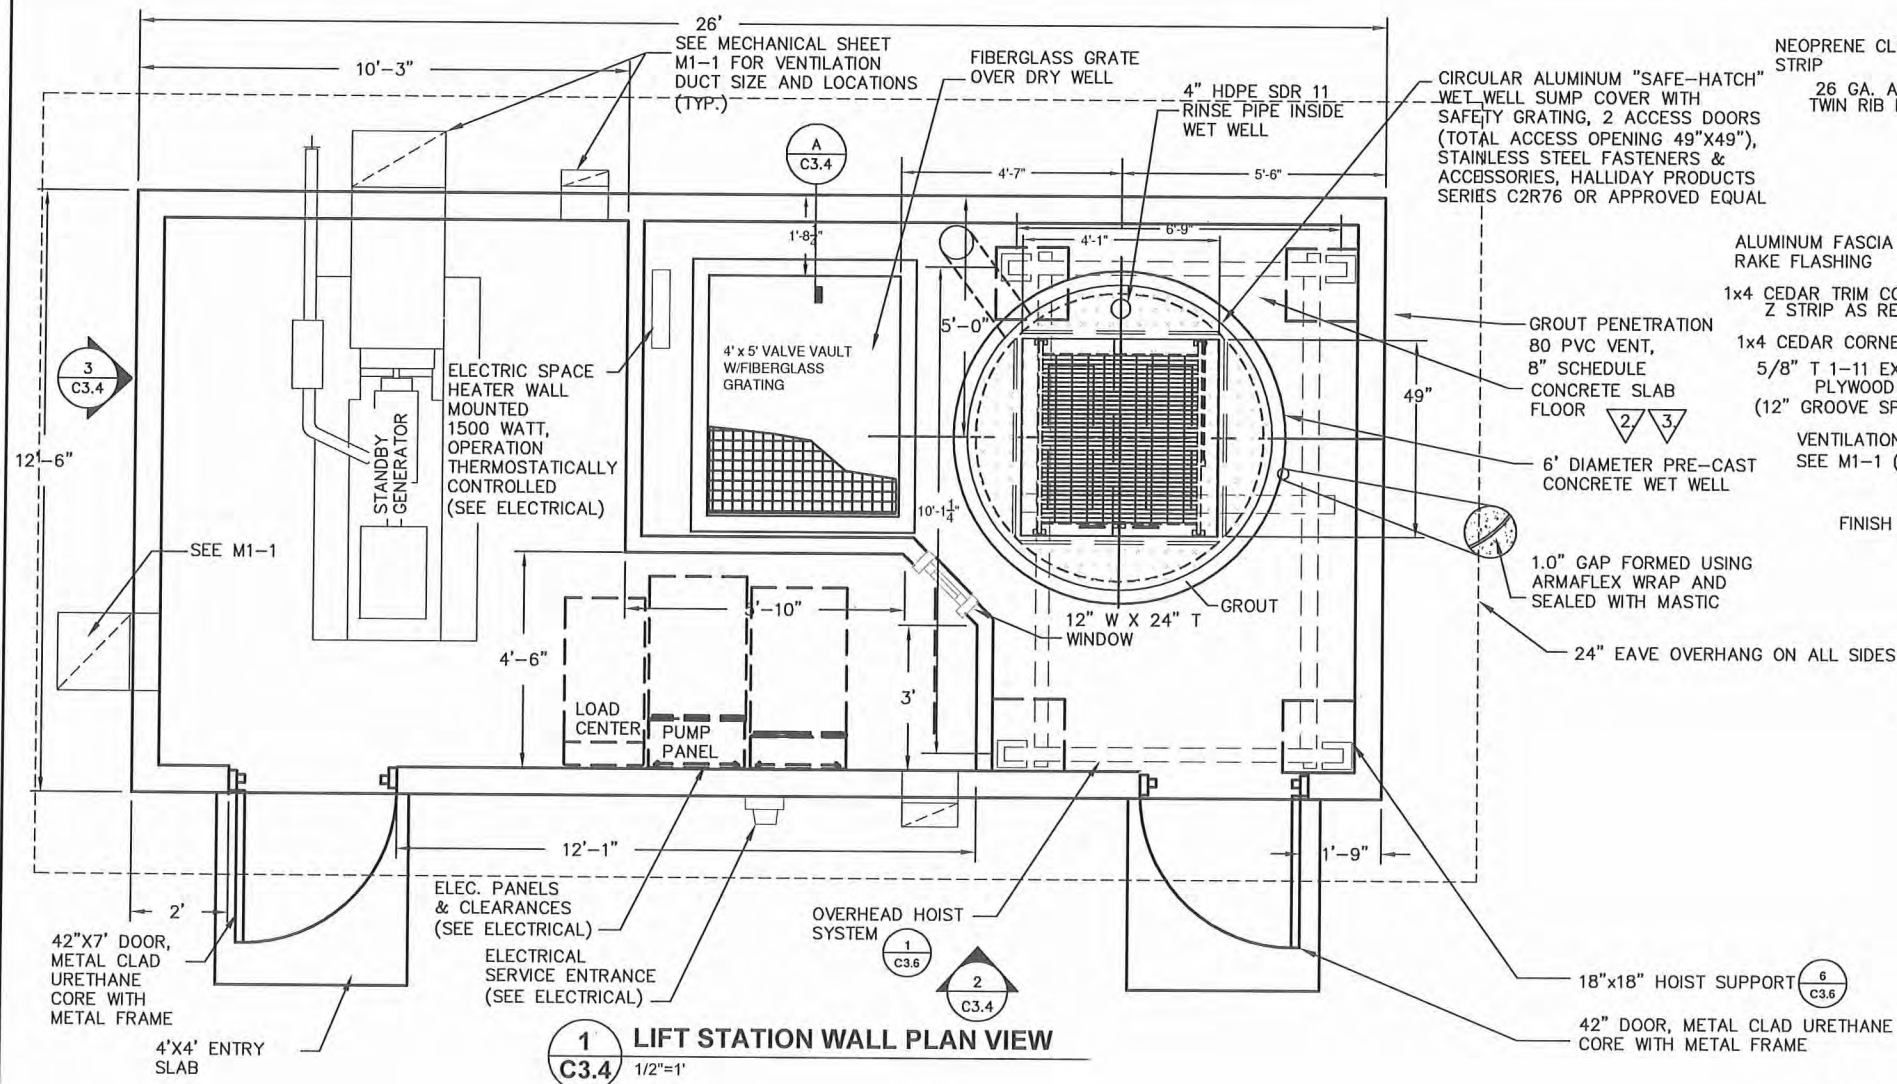

NOTES:

1. INSULATION OF THIS BUILDING IS REQUIRED AS SHOWN ON THE PLANS.
2. SLOPE FLOOR AREAS TO DRAIN TOWARD PUMP ACCESS DOORS.
3. CONSTRUCT CONCRETE SLAB W/ 1/2" REBAR @ 12" ON CENTER, BOTH WAYS. ALLOW FOR 2" COVER ON ALL SIDES.
4. SEE MECHANICAL SHEET M1-1 FOR VENTILATION DUCT SIZE AND DETAILS

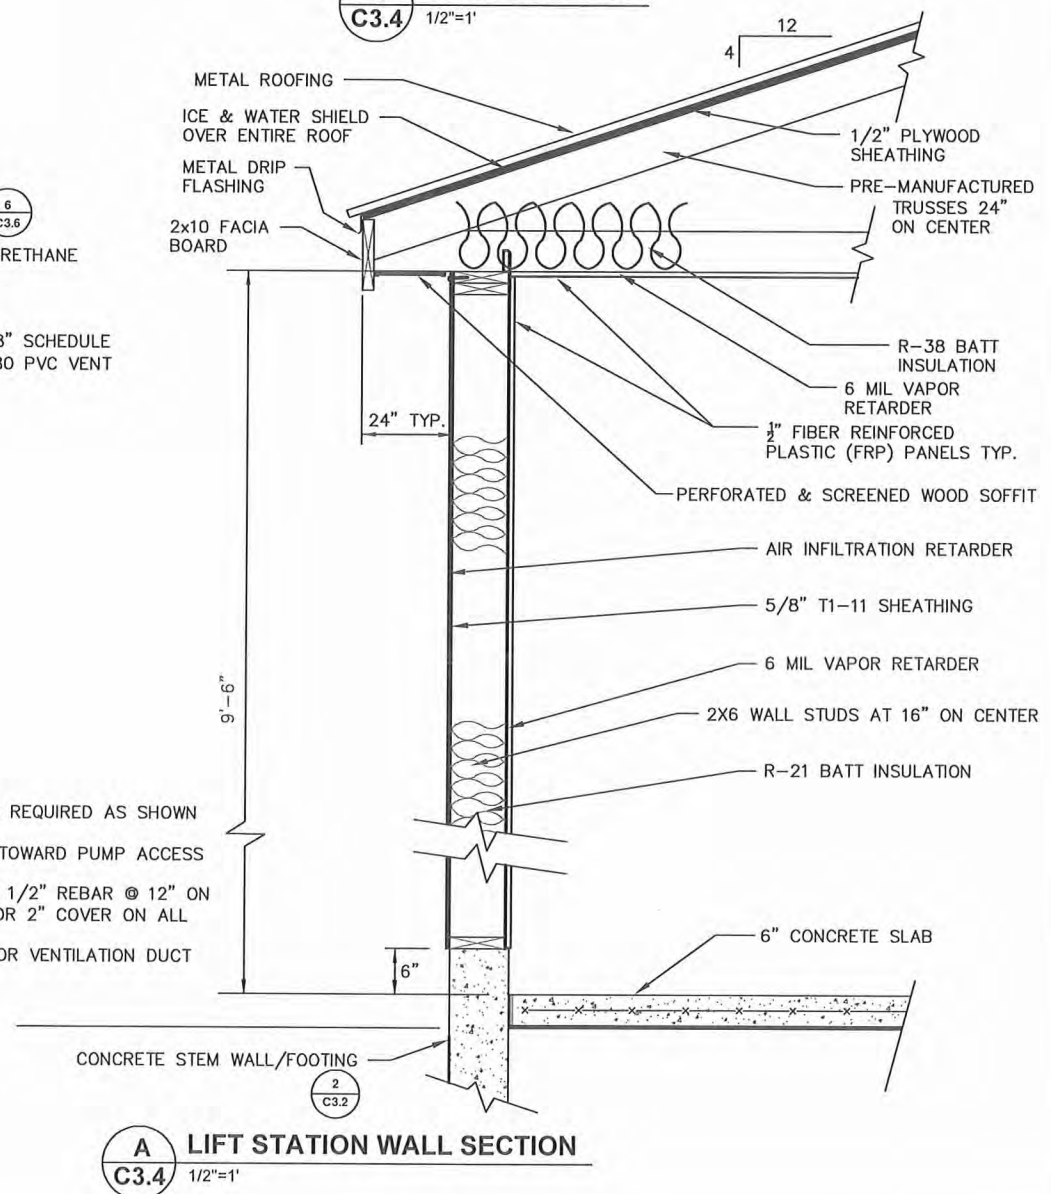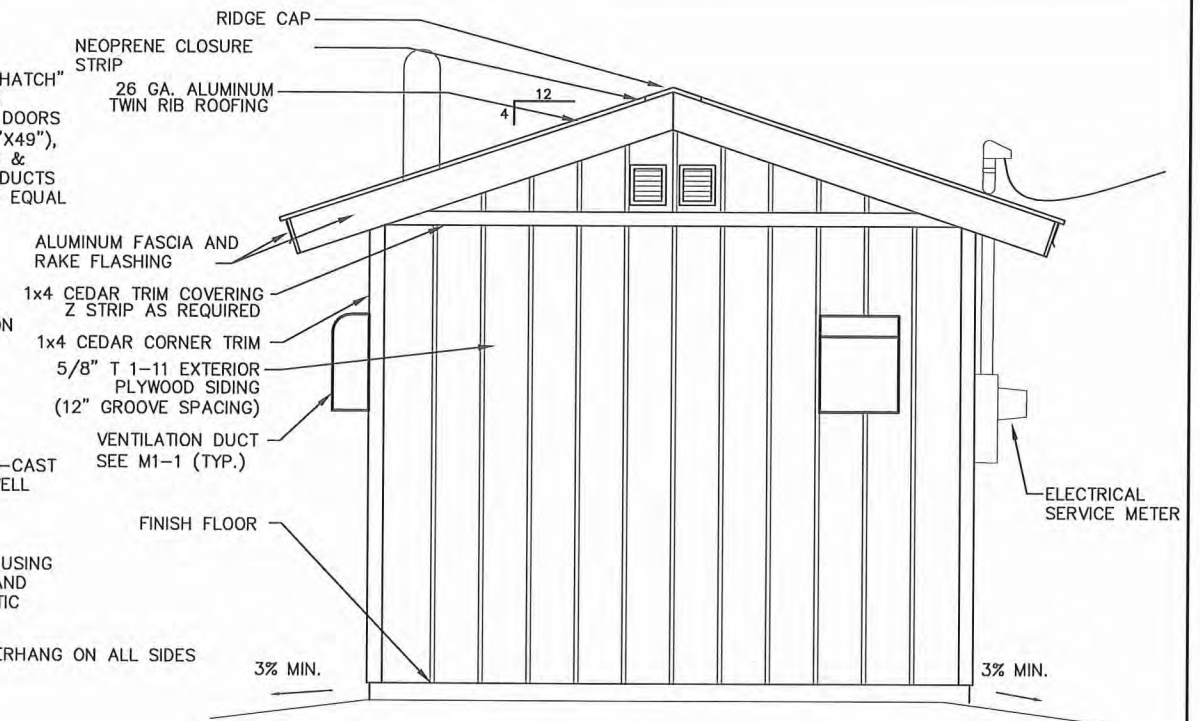

RECORD DRAWING CERTIFICATE
THESE DRAWINGS REFLECT RECORDED INFORMATION OBTAINED DURING CONSTRUCTION. INFORMATION PROVIDED HEREIN IS ACCURATE TO THE BEST OF MY KNOWLEDGE.

NAME _____ DATE _____

SCALE:
1" = 1'-0"
IF NOT INDICATED ON THE SHEET, ADJUST SCALES ACCORDINGLY



2010-11 WASTEWATER SYSTEM IMPROVEMENTS
BUILDING SECTION AND DETAILS
TULLUKSAK, ALASKA

CE2
ENGINEERS, INC.
PO BOX 2294 ANCHORAGE, AK 99501 TEL: 907-346-9100 FAX: 907-346-0115

REVISION	BY	DATE


Project No.	Date	Designed	Drawn	Approved
	JUNE 2009	LAP	VSW	LAP

Sheet No. C3.4


G:\ACAD\TULUKSAK\T0901 2008 Waste water disposal area\C3.2_THRU_3.6 revised format.dwg, 1/11/2011 1:20:38 PM, cmerz, LANIER MP C2050_LD520C PCL 6.pcl

NOTES:


1. PREMANUFACTURED LADDER AND BASKET WITH VERTICAL BAR SCREEN. SIMILAR TO HALLIDAY PRODUCTS, LADDER L1B & TRASH BASKET B1B, OR APPROVED EQUAL. STANDARD FEATURES SHALL INCLUDE:
- ALL ALUMINUM BASKET AND RAILS
 - SOLID ALUMINUM WHEELS AND STAINLESS STEEL AXLES
 - HEAVY DUTY LADDER/GUIDERAIL COMBINATION
 - SLIP RESISTANT RUNGS
 - BAR SCREEN STYLE BASKET
2. REQUIRED INFORMATION
- WET WELL DIAMETER
 - RAIL/LADDER LENGTH
 - STANDOFF LENGTH (10" MIN FOR LADDER COMBO)
 - FIELD VERIFY DISTANCE REQUIRED FOR BASKET TO CLEAR THE FINISH ACCESS OPENING.

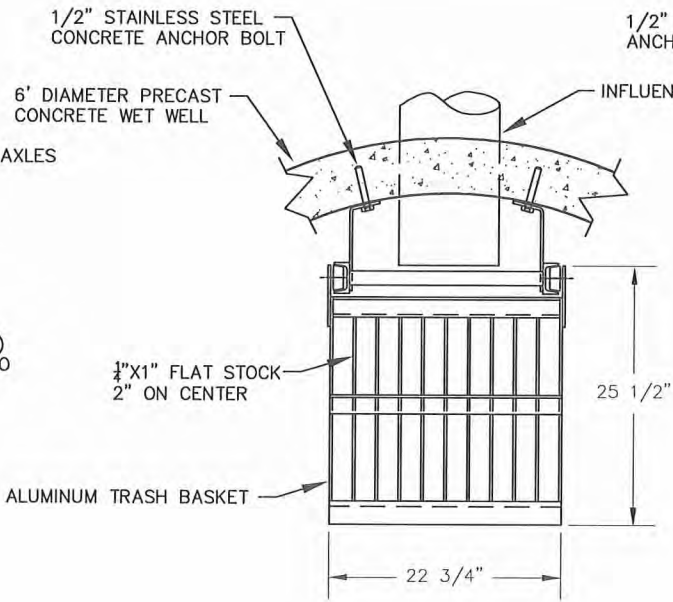

1 PLAN VIEW
C3.5 NTS

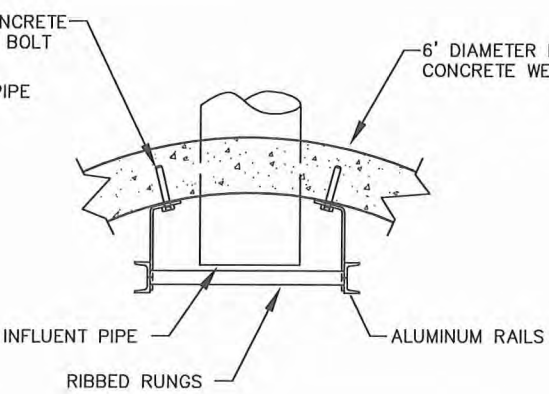


2 LADDER SUPPORT DETAIL
C3.5 NTS

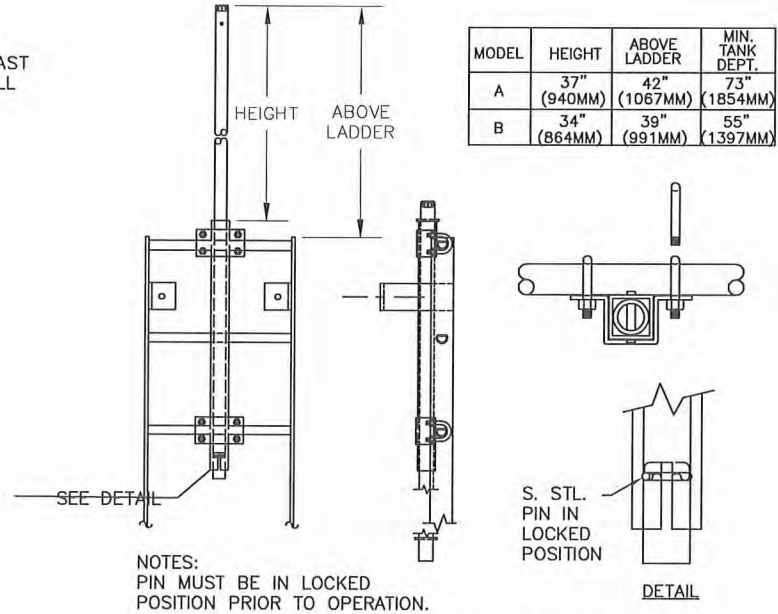


NOTES:
PIN MUST BE IN LOCKED POSITION PRIOR TO OPERATION.


8 LADDER EXTENSION DETAIL
C3.5 NTS

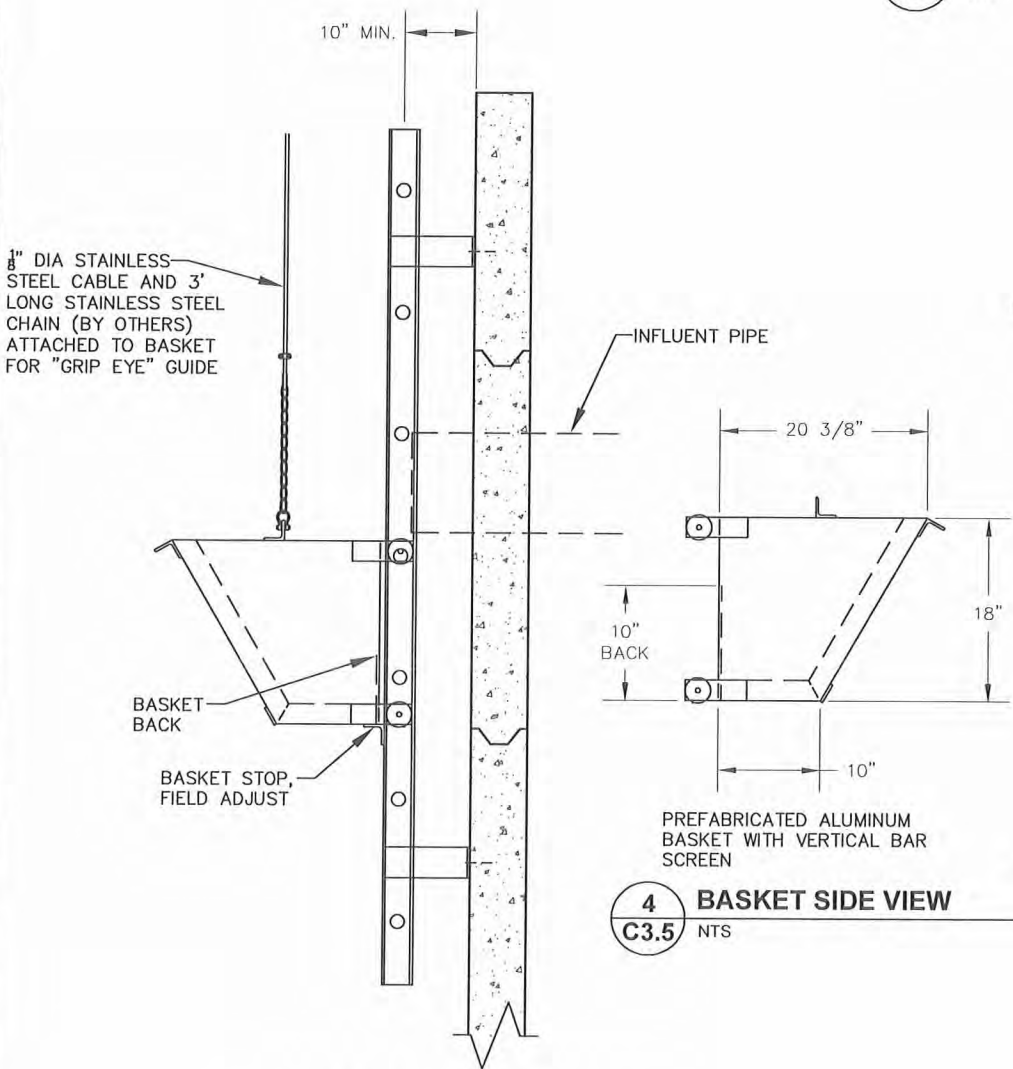


3 LADDER/BASKET SIDE VIEW
C3.5 NTS

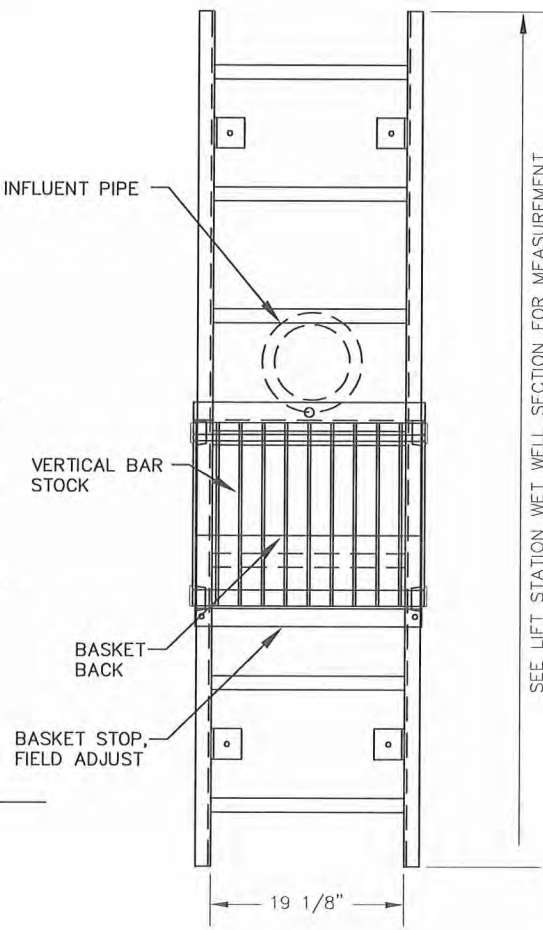

5 LADDER/BASKET FRONT VIEW
C3.5 NTS

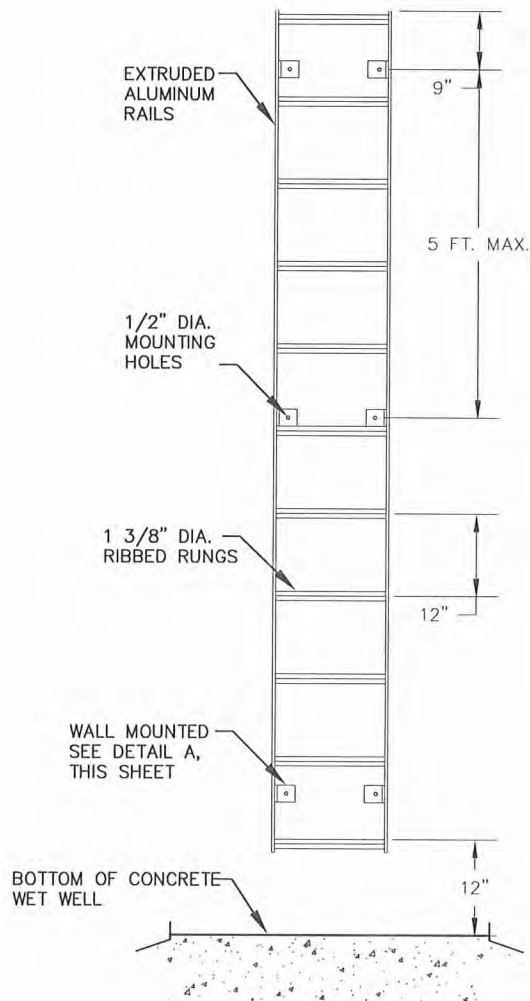

6 LADDER FRONT VIEW
C3.5 NTS

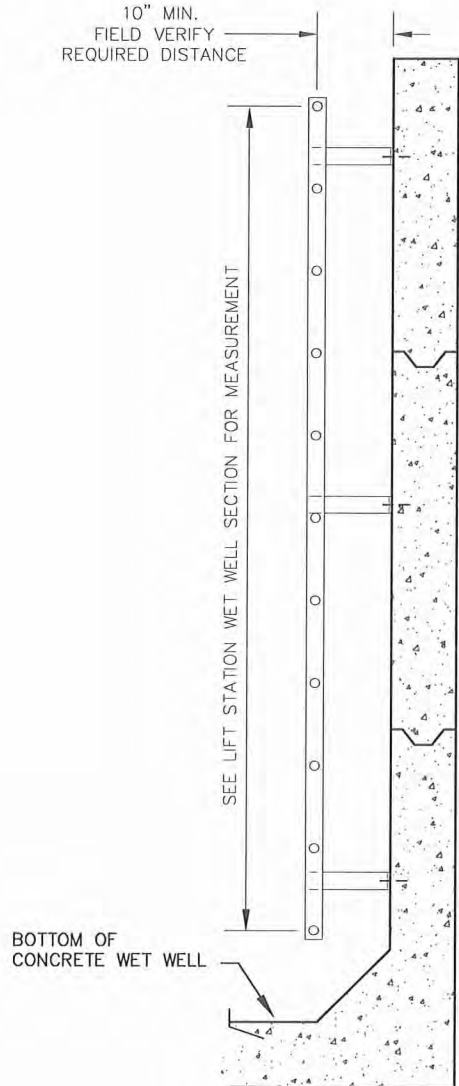

7 LADDER SIDE VIEW
C3.5 NTS

RECORD DRAWING CERTIFICATE

THESE DRAWINGS REFLECT RECORDED INFORMATION OBTAINED DURING CONSTRUCTION. INFORMATION PROVIDED HEREIN IS ACCURATE TO THE BEST OF MY KNOWLEDGE.

SCALE: 1" = 1'-0"

IF ANY SCALE IS USED, THIS SHEET MUST BE SCALED ACCORDINGLY.

NAME: _____ DATE: _____

2010-11 WASTEWATER SYSTEM IMPROVEMENTS

LIFT STATION LADDER DETAILS

TULUKSAK, ALASKA


CER ENGINEERS, INC.

PO BOX 22206 ANCHORAGE, AK 99523 PH 907-546-1001 FAX 907-546-1015


Project No. _____ Date: JUNE 2009 Designed: LAP Drawn: VSWL Approved: LAP

Sheet No. C3.5


G:\ACAD\TULUUKSAK\T\T0901 2008 Waste water disposal area\C3.2_THRU_3.6 revised format.dwg, 1/11/2011 1:21:05 PM, cmerz, LANIER MP C2050_LD520C PCL 6.ppt

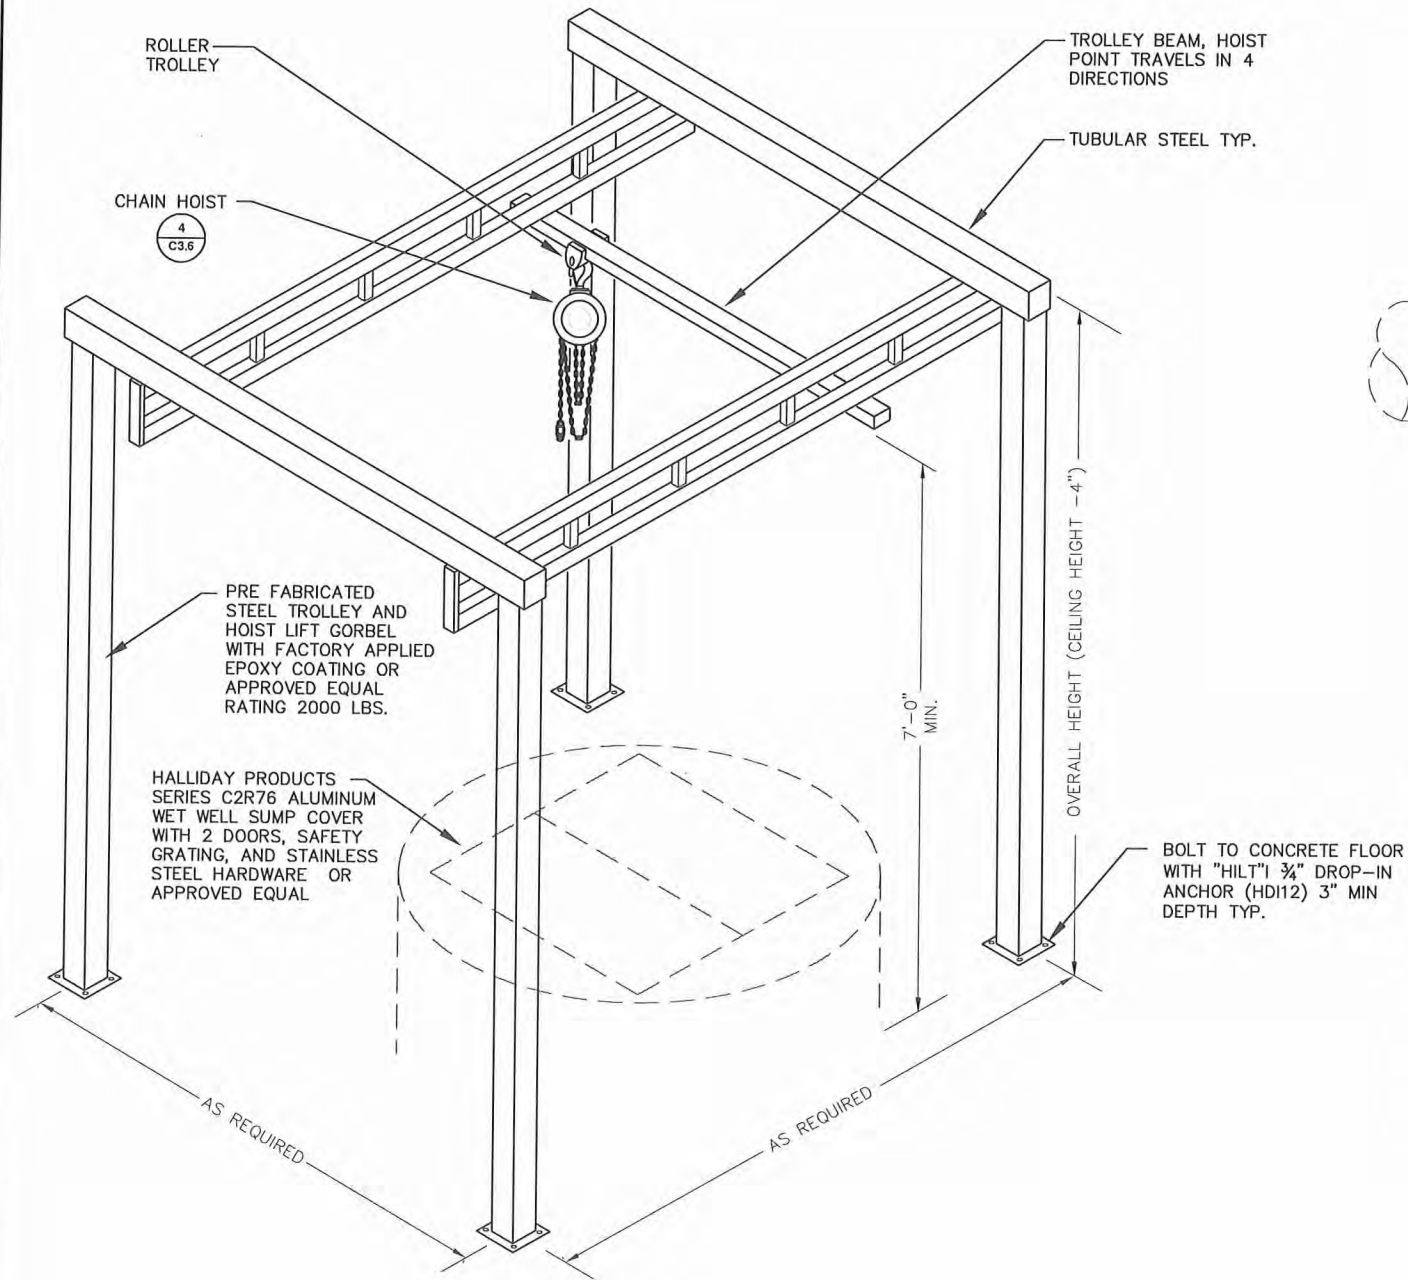


1 TROLLEY FRAME DETAIL
C3.6 NTS

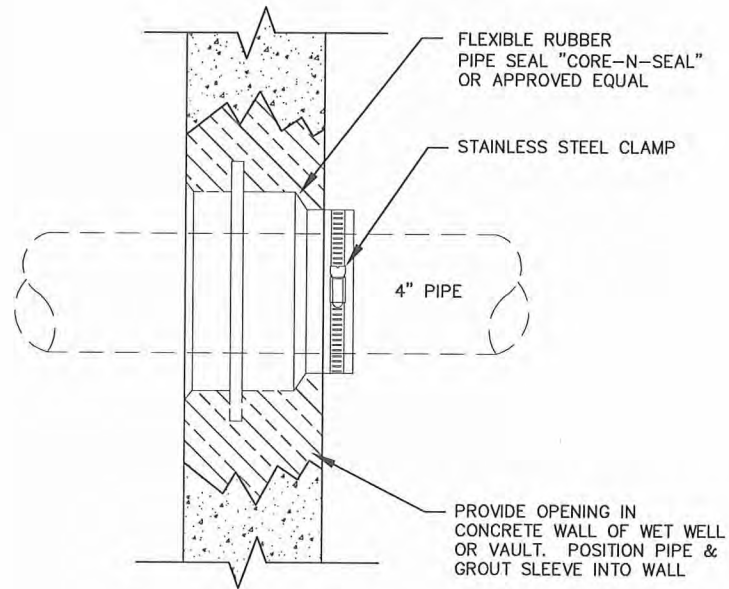


2 PIPE SLEEVE DETAIL
C3.6 NTS

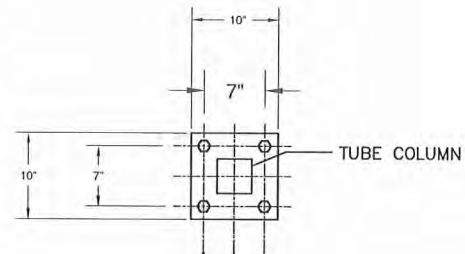


3 PIPE SUPPORT DETAIL
C3.6 NTS

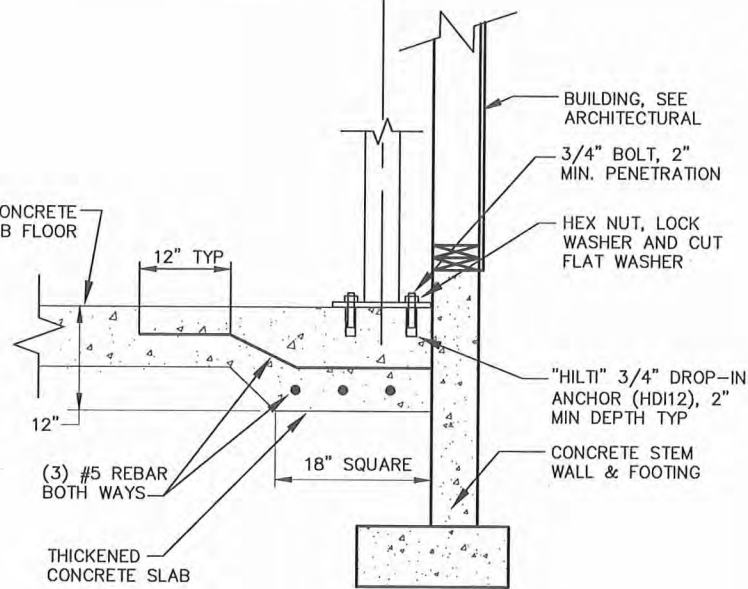

4 CHAIN HOIST
C3.6 NTS

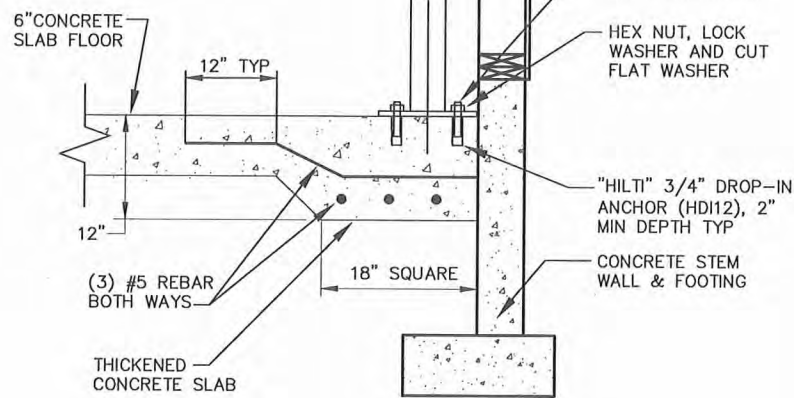

5 HOIST SUPPORT DETAIL
C3.6 NTS

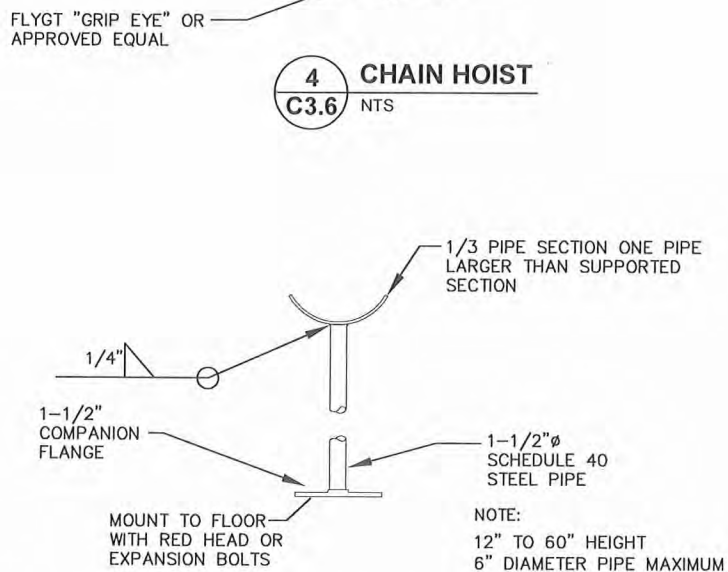

6 FLOOR MOUNT PIPE SUPPORT DETAIL
C3.6 NTS

RECORD DRAWING CERTIFICATE
THESE DRAWINGS REFLECT RECORDED
INFORMATION OBTAINED DURING
CONSTRUCTION. INFORMATION PROVIDED
HEREIN IS ACCURATE TO THE BEST OF MY
KNOWLEDGE.

SCALE:
1" = 1'-0"
IF NOT ONE INCH ON
THIS SHEET, ADJUST
SCALES ACCORDINGLY

NAME _____
DATE _____

2010-11 WASTEWATER
SYSTEM IMPROVEMENTS
LIFT STATION
HOIST AND PIPE
SUPPORT DETAILS
TULUUKSAK, ALASKA

CE2
ENGINEERS, INC.
PO BOX 22546 ANCHORAGE, AK 99523 PH: 907-346-1010 FAX: 907-346-1015

REVISION	BY	DATE

Project No. _____
Date JUNE 2009
Designed LAP
Drawn VSW
Approved LAP

Sheet No. _____
C3.6


USS 3797

PROPOSED
FORCEMAIN #1
(PHASE II)

PROPOSED
WASTEWATER LAGOON
(PHASE I)

BIA
NATIVE ALLOTMENT
SER. #FF017363

 TULKISARMUTE
CORPORATION
PROPERTY



WASTEWATER LAGOON DESIGN CRITERIA			
Design Criteria			
Assumptions	Qty.	Unit	Notes
2010 Design Population	497	People	
2030 Design Population	669	People	
Design Flow Rate	50	Gal/Cap-Day	Assumed
BOD	0.17	lbs/Cap-Day	Minimum loading suggested by Ten States Standards (referred to by ADEC).
Treatment Cell BOD Loading (Maximum)	38	lbs/acre	ADEC Lagoon Construction Guidelines
Treatment Cell Hydraulic Retention Time (HRT)	60	Days	Assumed
Treatment Cell Maximum Depth	10	Feet	ADEC Lagoon Construction Guidelines
Percolation Days Per Year	365	Days	Assumed
2030 Design Conditions			
Average Daily Flow	36,950	Gallons	Calculated
BOD/day production	113.7	lbs	Calculated
Treatment Cell Size (based on BOD Loading)	3.0	Acres	Calculated
Treatment Cell Volume	2,771,244	Gallons	Min. HRT plus 25% Sludge Holding Cap.
Treatment Cell Average Depth	2.84	Feet	Use 7 Foot min. depth for freeze protection.
Required Percolation Cell Holding Volume (non-perk Days)	-	Gallons	
Percolation Calculations			
Average Perc Rate	5.6	min./in.	Measured average of 3 perc tests
Saturation Test Loading	40	min./in.	Measured
Daily Loading Rate	0.90	Gal/Sq.Ft.-Day	Seepage Pit Loading Rate from the 10-States Standard for Individual Sewage Systems, 1980 Edition, for Perc Rate 6-10 min./in.
Required Holding Cell Floor Area	41,055	Sq. Feet	
2010 Design Conditions (After Completion of Phase II)			
2010 Service Area	28	Homes	Based on existing occupied homes located in the core of the community
2010 served population	130	people	Calculated
2010 Average Daily Flow	10,450	Gal/Day	Calculated
2010 BOD/day production	22.1	lbs	Calculated
Primary Cell BOD Loading	7.4	lbs/acre	OK. Does not include Honeybucket Loading waste stream.
Proposed Lagoon Sizing			
Treatment Cell Size	3.0	Acres	
Treatment Cell Volume	5,995,315	Gallons	
Treatment Cell Calculated HRT	162	Days	
Percolation Bed Size	0.94	Acres	Use 1.0 Acre

RECORD DRAWING CERTIFICATE
THESE DRAWINGS REFLECT RECORDED
INFORMATION OBTAINED DURING
CONSTRUCTION. INFORMATION PROVIDED
HEREIN IS ACCURATE TO THE BEST OF MY
KNOWLEDGE.

SCALE:
1" = 100'
NOT ONE INCH ON
THIS DRAWING
REPRESENTS
100 FEET
UNLESS OTHERWISE
NOTED


2010-11 WASTEWATER
SYSTEM IMPROVEMENTS
LAGOON SITE PLAN
AND DESIGN CRITERIA
TULUKSAK, ALASKA

REVISION	BY	DATE

Project No.	
Date	JUNE 2009
Designed	LAP
Drawn	CM/LAW
Approved	LAP


Sheet No. C4.0

G:\ACAD\TULUKSAK\TLT0901 2008 Waste water disposal area\C4.1 LAGOON PLAN AND PROFILE.dwg, 1/11/2011 1:35:46 PM, Flash, LANIER MP C2050_LD520C PCL 6BLK WHIT.p3

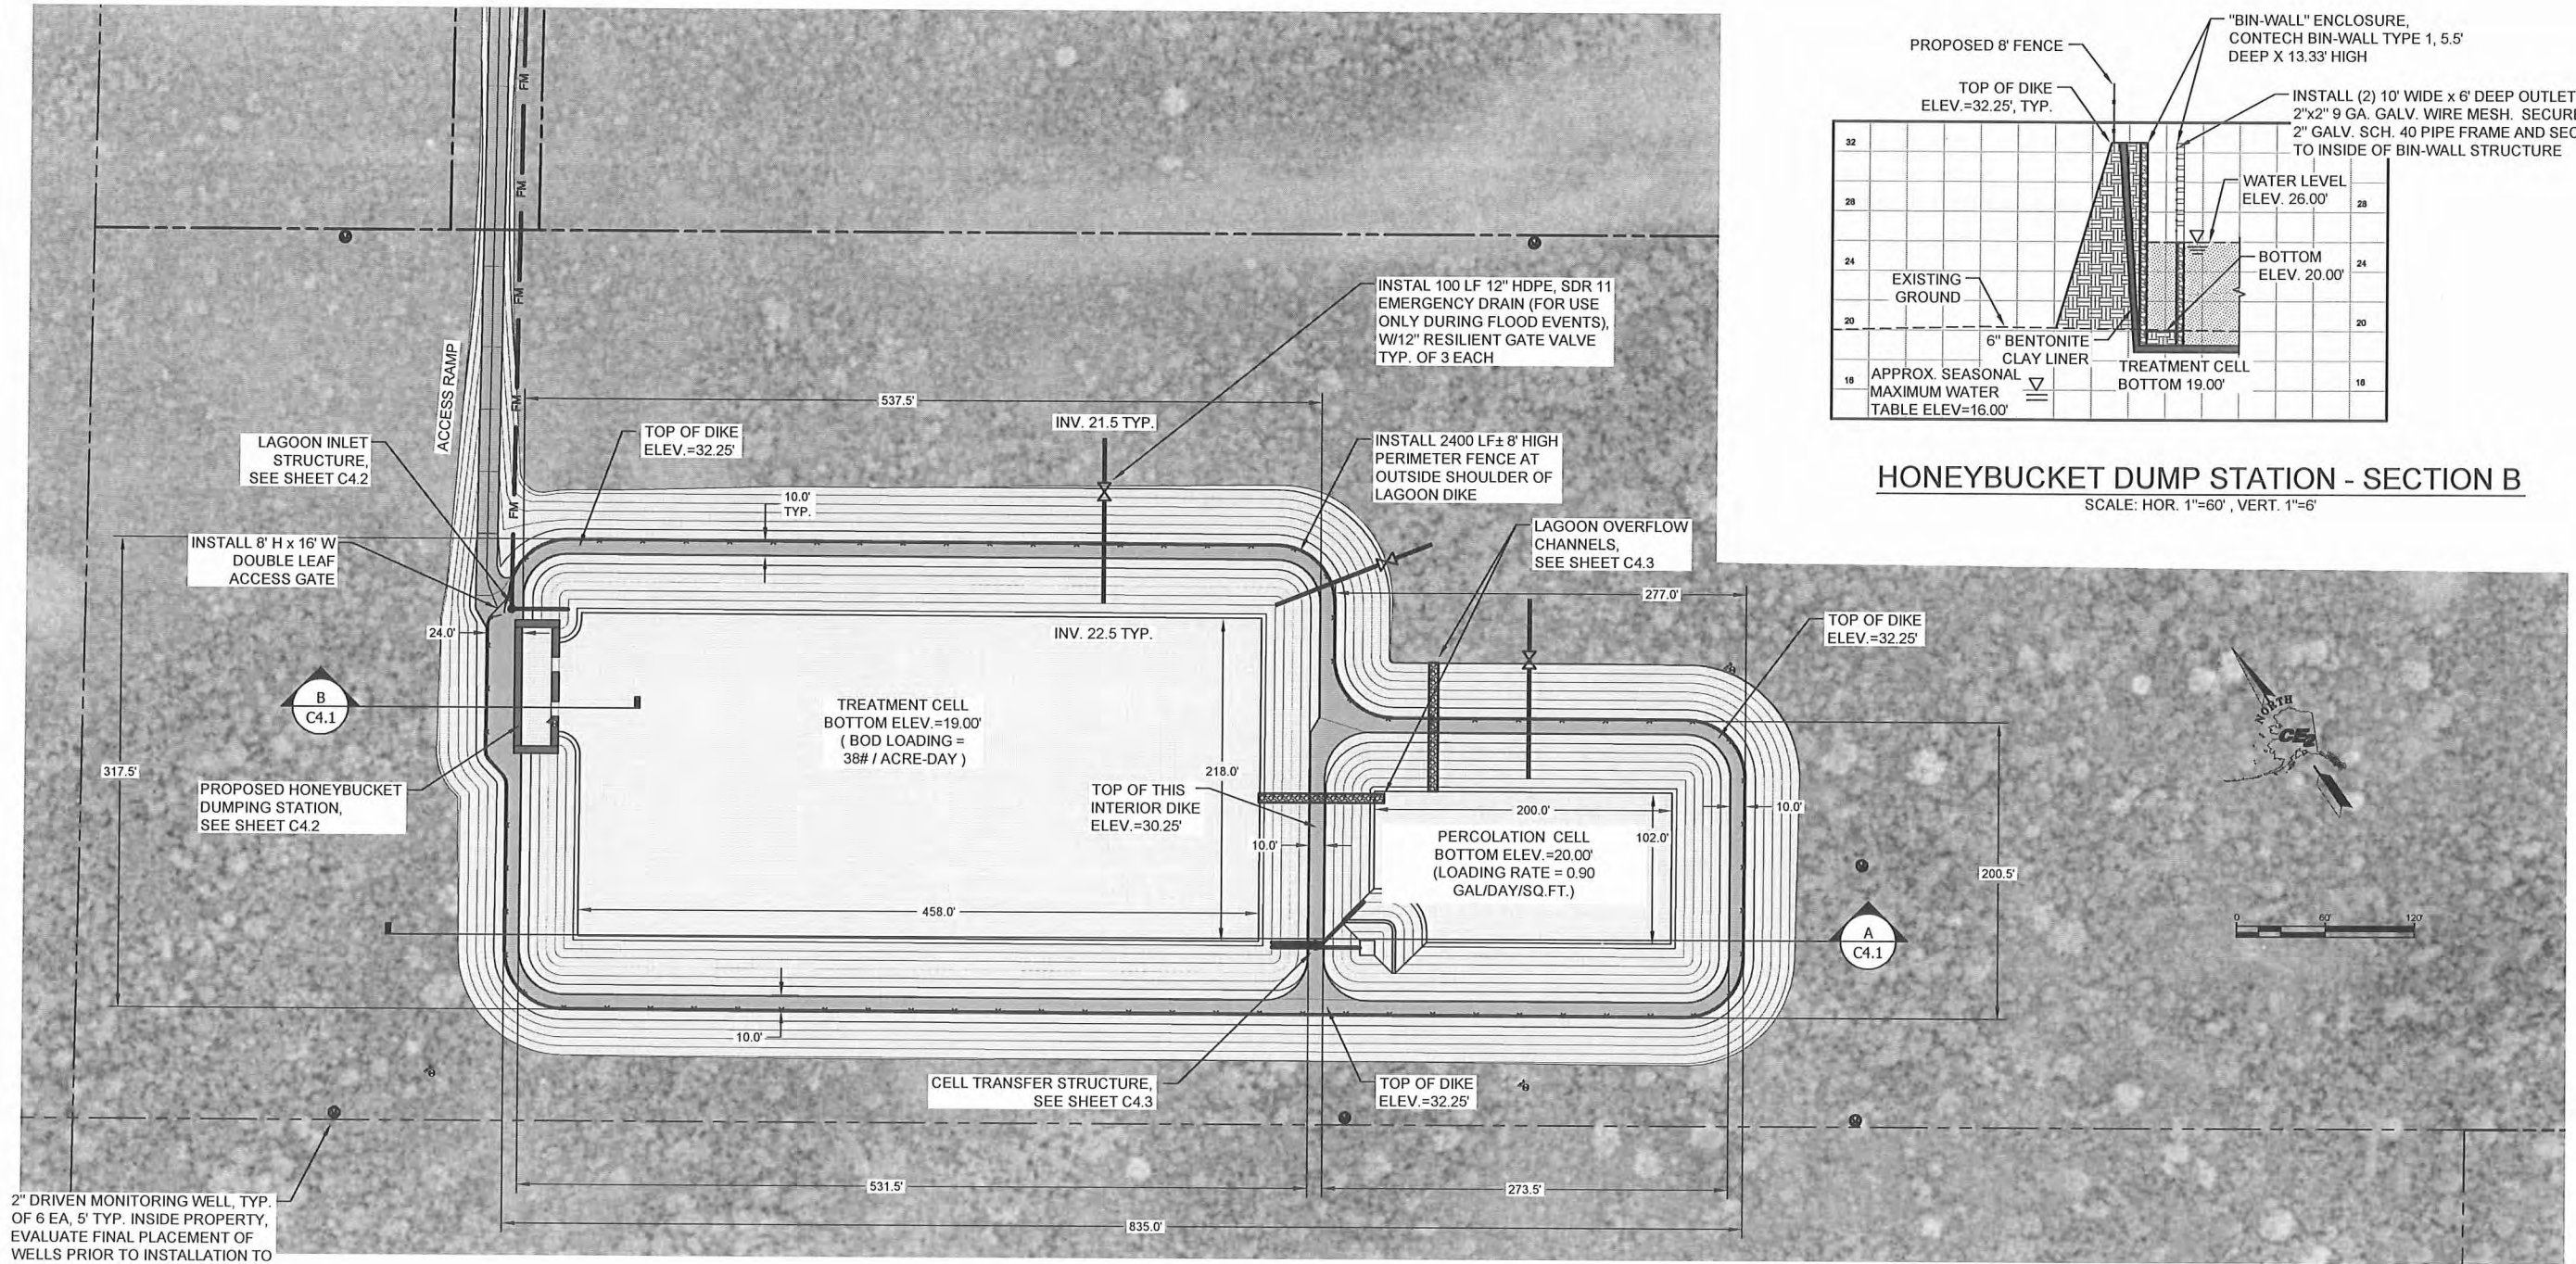


2" DRIVEN MONITORING WELL, TYP. OF 6 EA, 5' TYP. INSIDE PROPERTY, EVALUATE FINAL PLACEMENT OF WELLS PRIOR TO INSTALLATION TO TARGET AREAS DOWN-GRADIENT FROM THE PERCOLATION CELL, SEE

2
C4.1

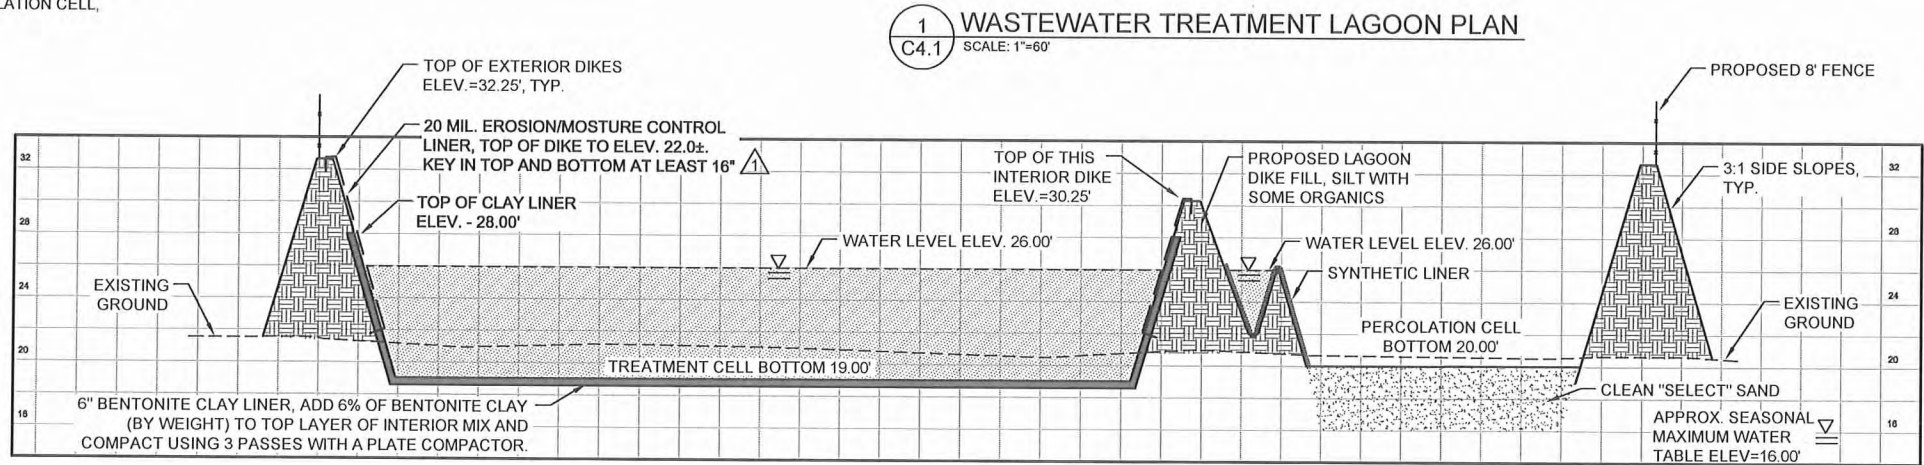


LAGOON - SECTION A
SCALE: HOR. 1"=60', VERT. 1"=6'

REF. IND. PERMALON 20 MIL OR APPROVED EQUAL

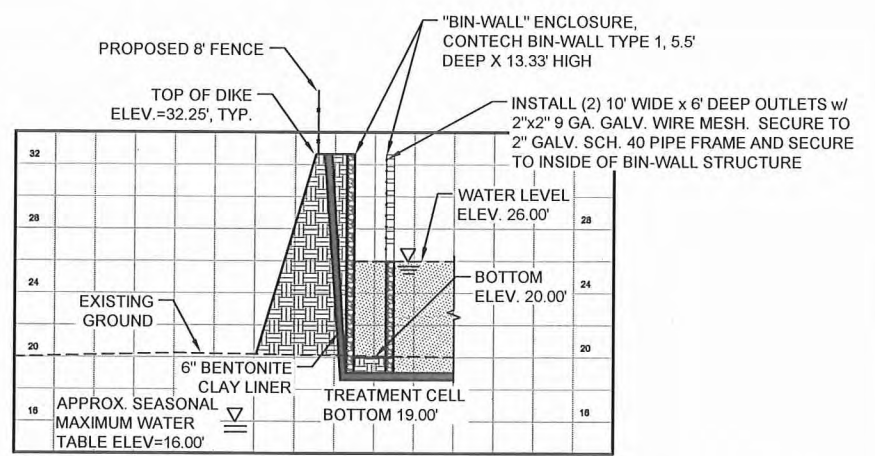

HONEYBUCKET DUMP STATION - SECTION B
SCALE: HOR. 1"=60', VERT. 1"=6'

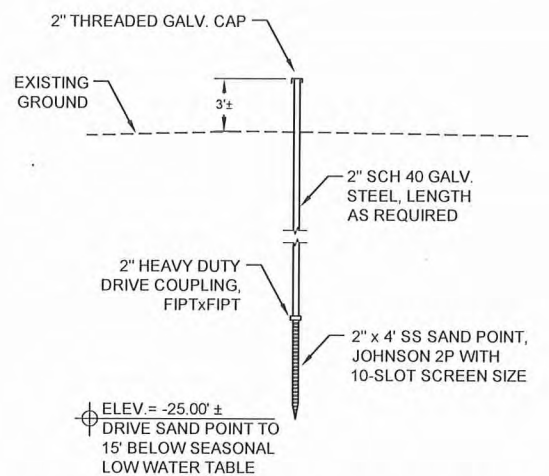

2
C4.1
DRIVEN MONITORING WELL DETAIL
SCALE: NTS

RECORD DRAWING CERTIFICATE
THESE DRAWINGS REFLECT RECORDED
INFORMATION OBTAINED DURING
CONSTRUCTION. INFORMATION PROVIDED
HEREIN IS ACCURATE TO THE BEST OF MY
KNOWLEDGE.

SCALE:
AS SHOWN
1" = 60'
IF ANY ONE HAS TO
THIS SHEET, ADJUST
SCALE ACCORDINGLY






2010-11 WASTEWATER
SYSTEM IMPROVEMENTS
LAGOON PLAN
AND PROFILE
TULUKSAK, ALASKA

CE2
ENGINEERS, INC.
PO BOX 2264 ANCHORAGE, AK 99523 PH: 907-345-0101 FAX: 907-345-1015

REVISION	BY	DATE
NOTES ADDED	LAW	2/10
LAGOON RELOCATION	CM	8/10



Project No.	JUNE 2009	LAP
Date	DESIGNED	DOR
Drawn	APPROVED	LAP

Sheet No.
C4.1

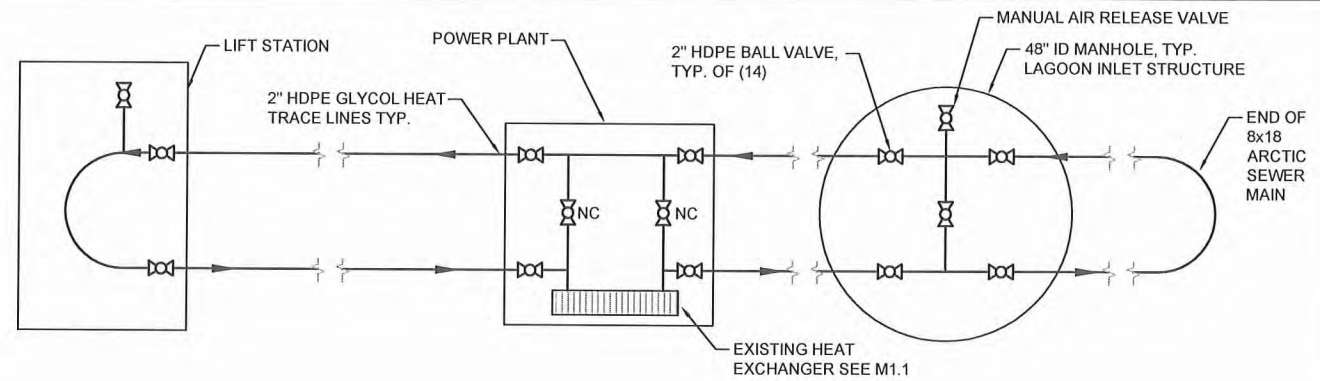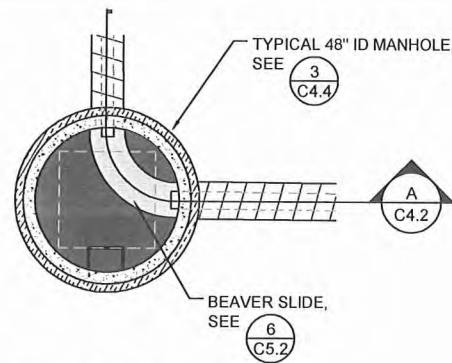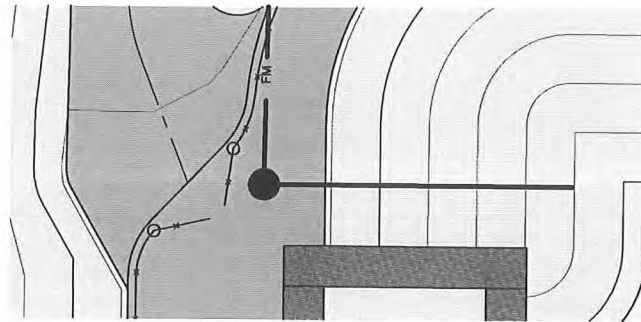


1 LAGOON INLET STRUCTURE PLAN
C4.2 NTS

2 GLYCOL HEAT TRACE SCHEMATIC
C4.2 NTS

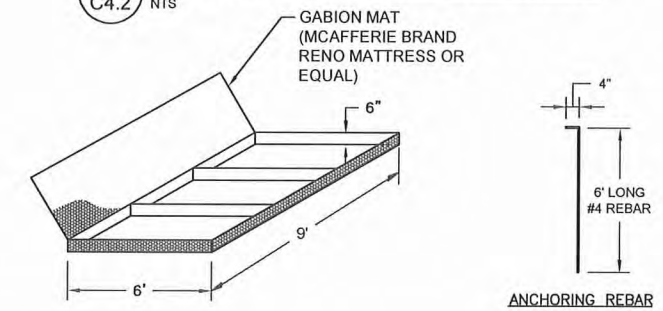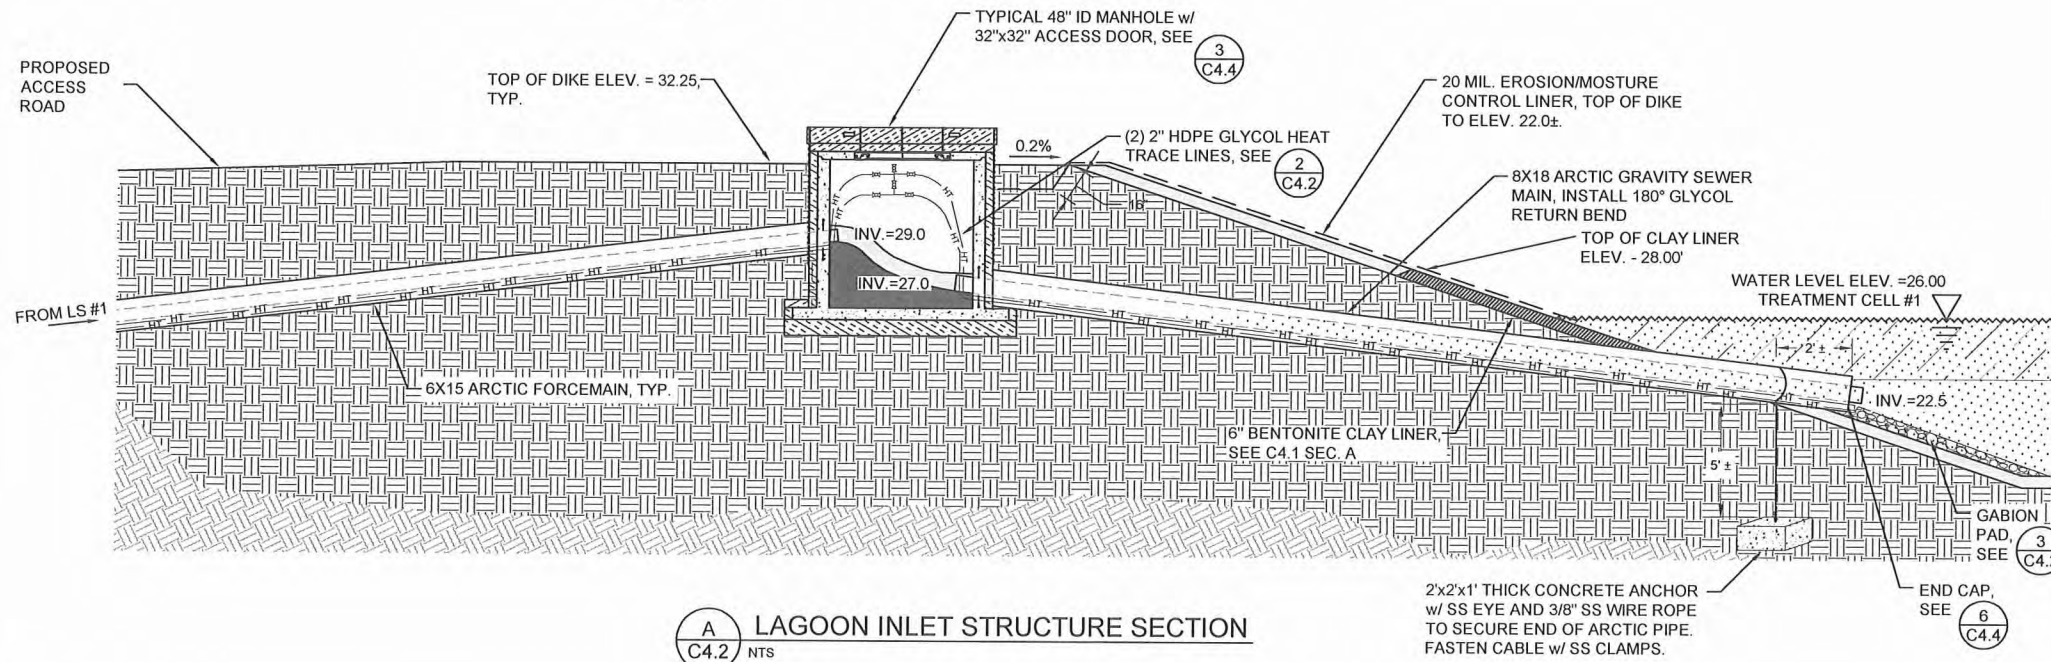


- NOTES:
- GABIONS SHALL BE LINED WITH A U.V. RESISTANT, WOVEN GEOTEXTILE AMOCO 2016 OR EQUAL, PRIOR TO BEING FILLED. AFTER LINING, GABIONS SHALL BE FILLED, PER MANUFACTURER'S RECOMMENDED PROCEDURES, WITH IMPORTED ROCK OR BROKEN CONCRETE (3"-4" PARTICLE SIZE).
 - ANCHOR GABIONS INSTALLED ON SLOPES USING 6' LONG, HOOKED #4 REBAR, AS NECESSARY.
 - INTERLOCK GABION "MATTRESSES" USING HOG RINGS AT 1' O.C.

3 GABION MAT DETAILS
C4.2 NTS

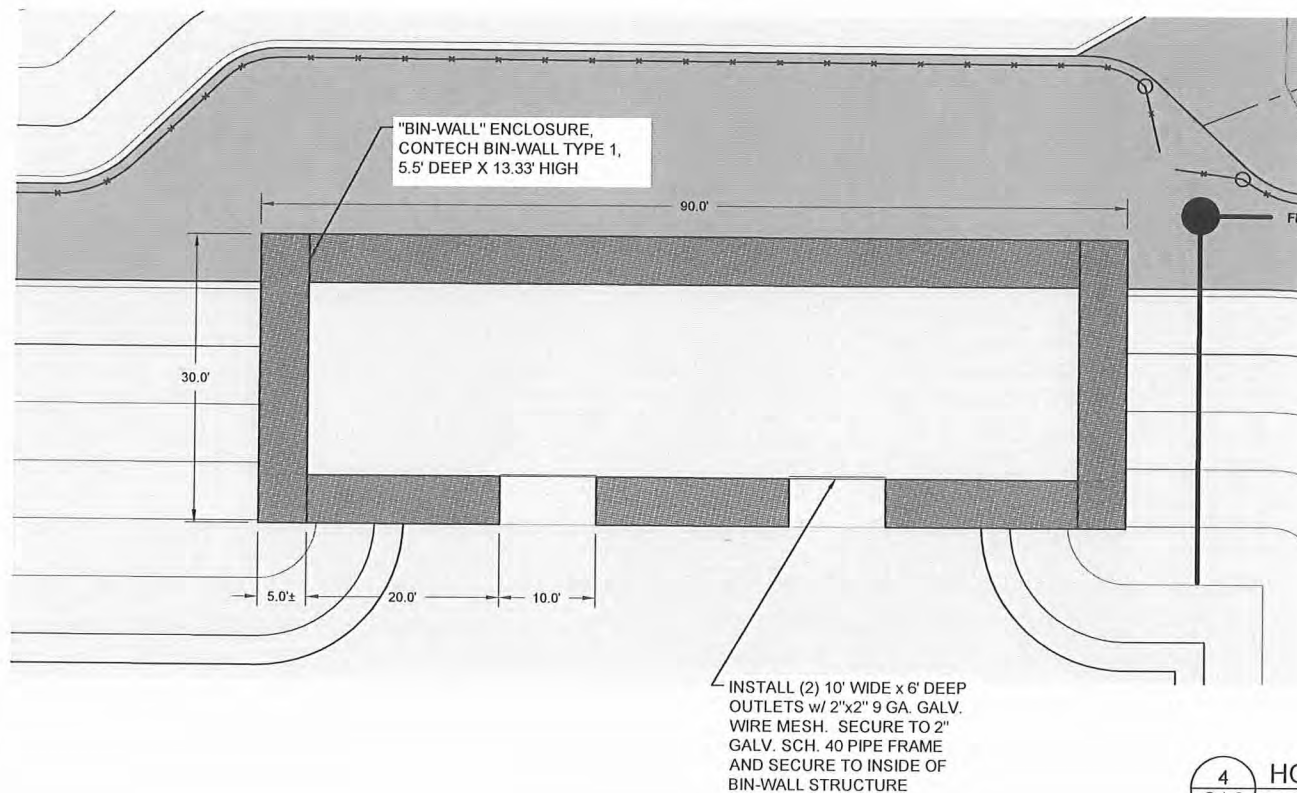

4 HONEY BUCKET DUMP STATION
C4.2 NTS

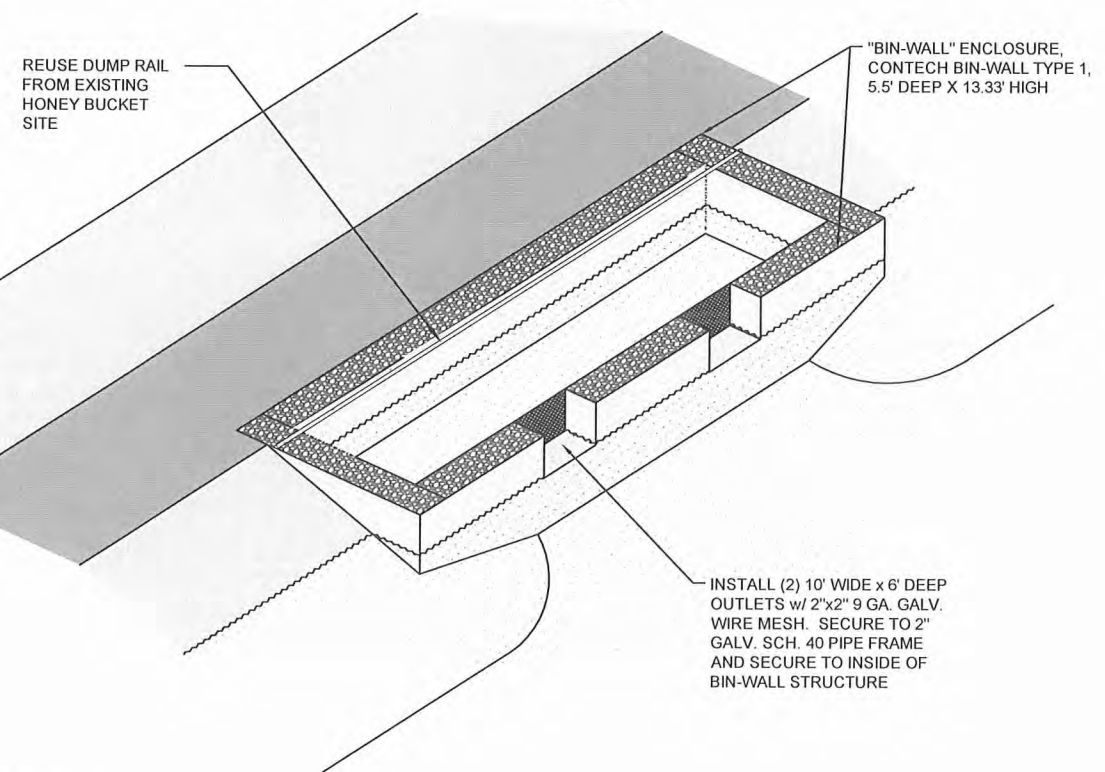

RECORD DRAWING CERTIFICATE

THESE DRAWINGS REFLECT RECORDED INFORMATION OBTAINED DURING CONSTRUCTION. INFORMATION PROVIDED HEREIN IS ACCURATE TO THE BEST OF MY KNOWLEDGE.

NAME _____

DATE _____

SCALE: AS SHOWN

1"

0

IF NOT ONE INCH ON THIS SHEET, ADJUST SCALES ACCORDINGLY



2010-11 WASTEWATER SYSTEM IMPROVEMENTS

LAGOON INLET STRUCTURE

TULUKSAK, ALASKA

CE2

ENGINEERS, INC.


PO BOX 22946 ANCHORAGE, AK 99523 PH: 907-349-1010 FAX: 907-349-1015

REVISION	BY	DATE
NOTES ADDED	LAW	2/10





Project No.	JUNE 2009
Date	LAP
Designed	LAP
Drawn	LAP
Approved	LAP

Sheet No. C4.2

G:\ACAD\TULUKSAK\T10901 2008 Waste water disposal area\C4.3 TRANSFER STRUCTURE 15 inch jacket.dwg, 1/11/2011 1:39:14 PM, Flash, LANIER MP C2050_LD520C PCL 6BLK WHIT, pc3

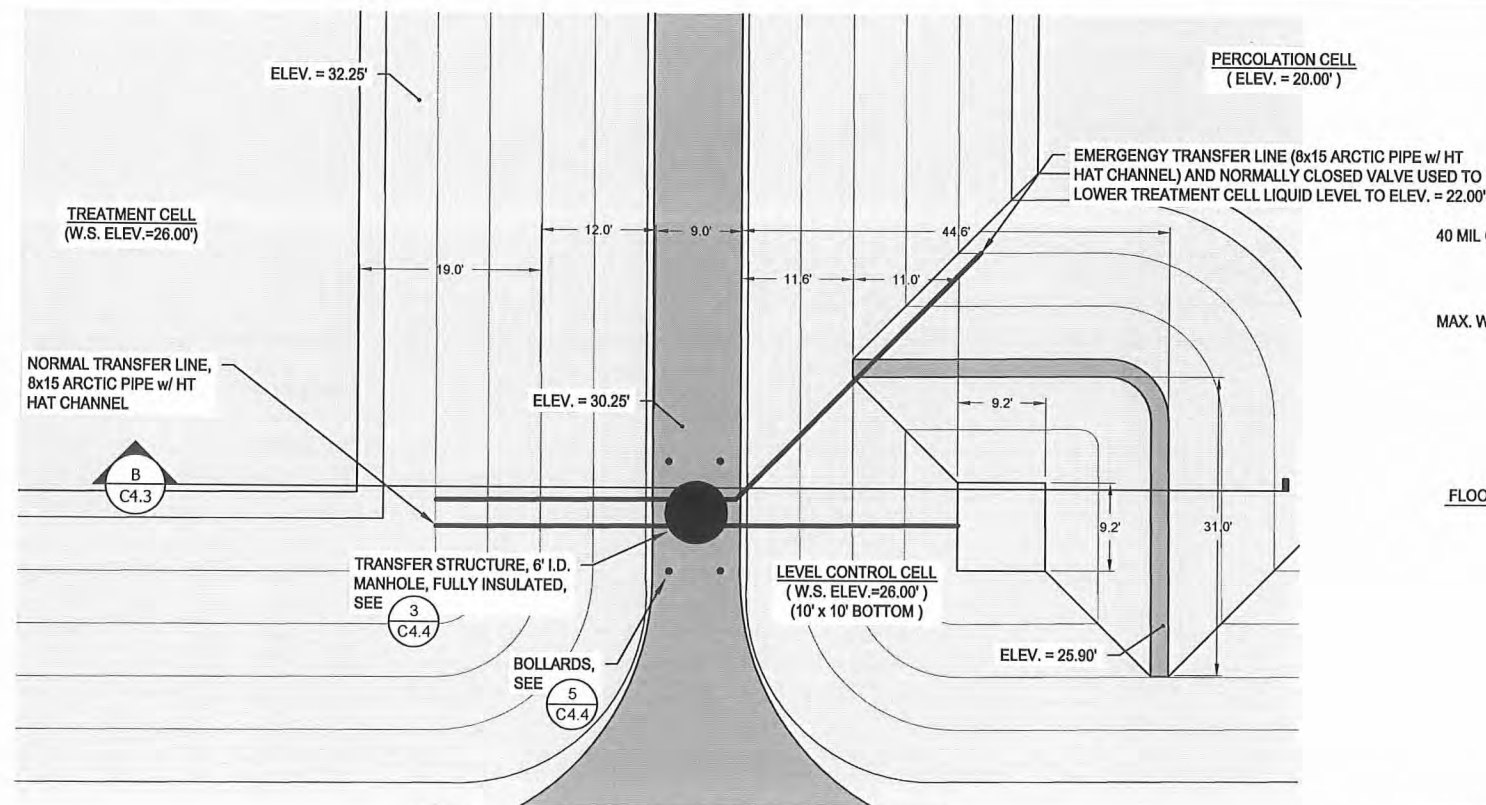

8" HDPE, SDR 11 BALL VALVE w/ 2" SQUARE NUT (NORMALLY CLOSED) INV. ELEV. = 22.25

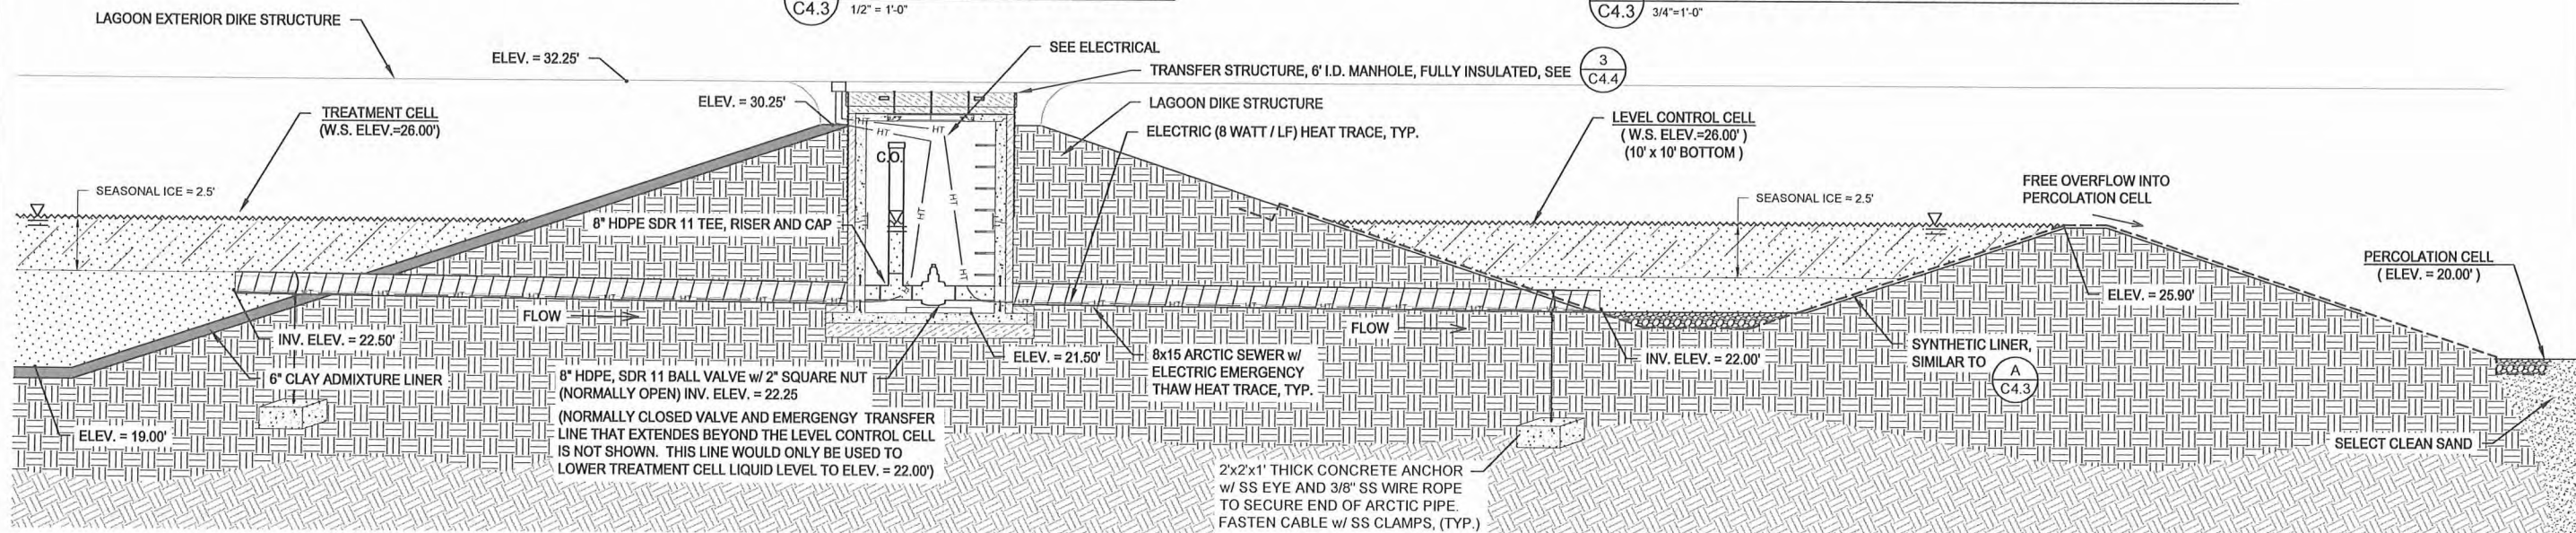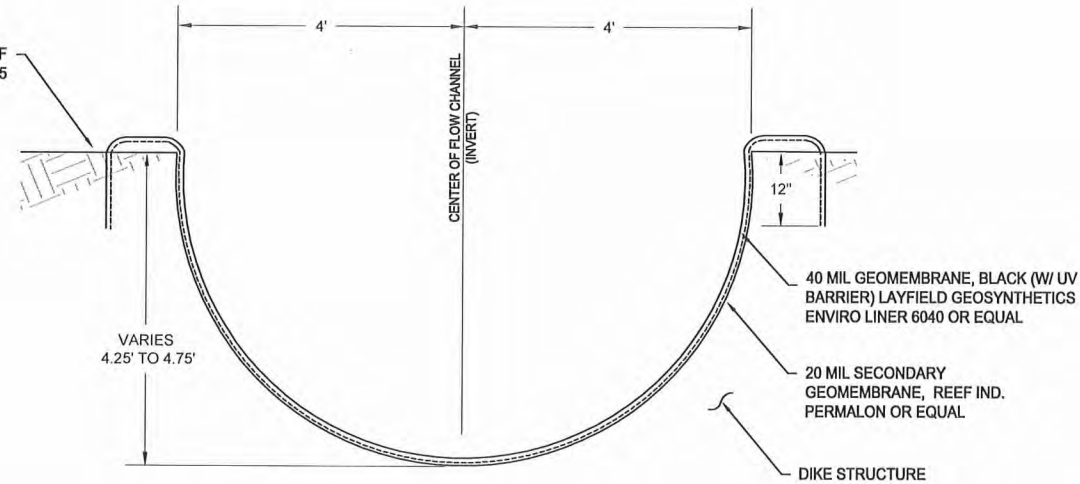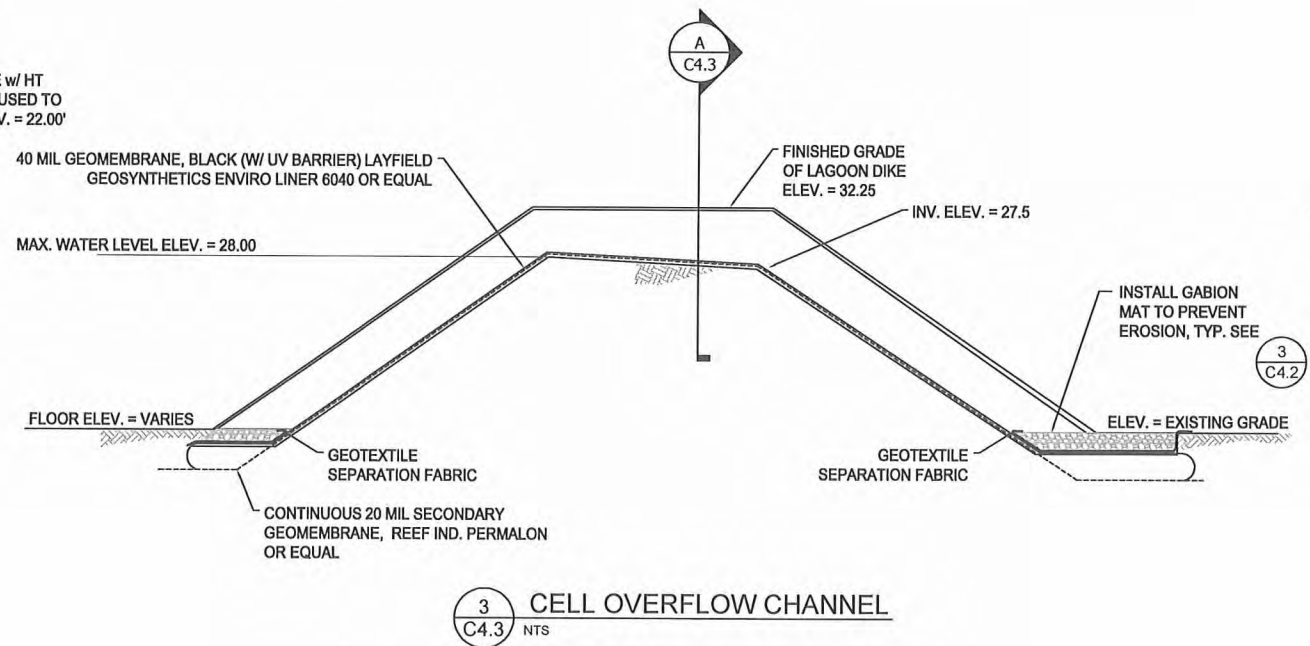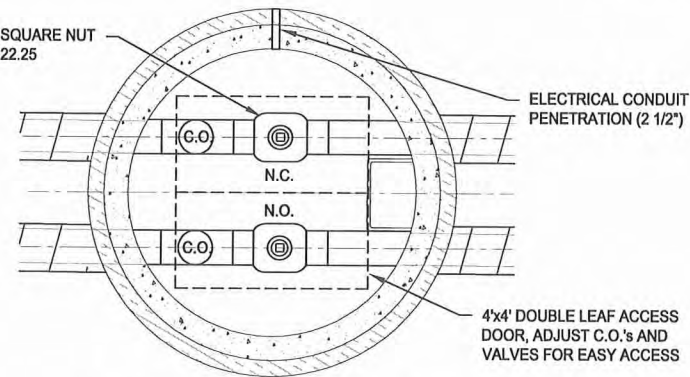

RECORD DRAWING CERTIFICATE
THESE DRAWINGS REFLECT RECORDED INFORMATION OBTAINED DURING CONSTRUCTION. INFORMATION PROVIDED HEREIN IS ACCURATE TO THE BEST OF MY KNOWLEDGE.

SCALE: AS SHOWN

DATE

IF NOT ONE INCH ON THIS SHEET, ADJUST SCALES ACCORDINGLY



2010-11 WASTEWATER SYSTEM IMPROVEMENTS

CELL TRANSFER STRUCTURE AND OVERFLOW CHANNELS

TULUKSAK, ALASKA


CE2 ENGINEERS, INC.
PO BOX 22504 ANCHORAGE, AK 99523 PH: 907-349-1010 FAX: 907-349-1015

BY	DATE
LAW	2/10
REVISION	NOTES


Project No.	Date	Designed	Drawn	Approved
	JUNE 2009	LAP	LAP	LAP

Sheet No. C4.3

G:\ACAD\TULUKSAK\TLT0901 2008 Waste water disposal area\C4.5 LAGOON CLOSEOUT.dwg, 1/11/2011 1:40:26 PM, Flash, LANIER MP C2050_LD520C PCL 6BLK WHIT.pcl

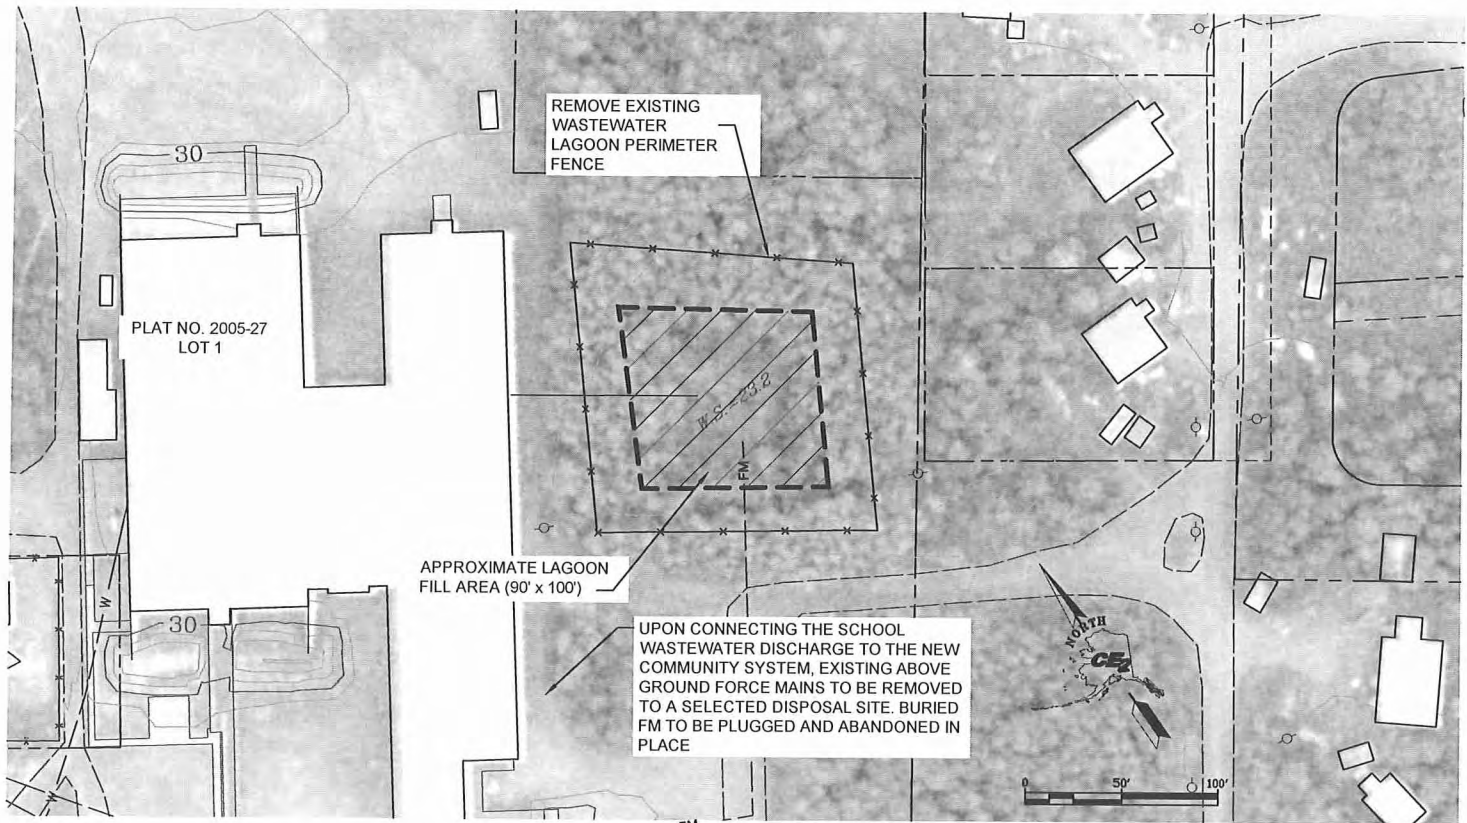

1
C4.5
EXISTING SCHOOL WASTEWATER LAGOON

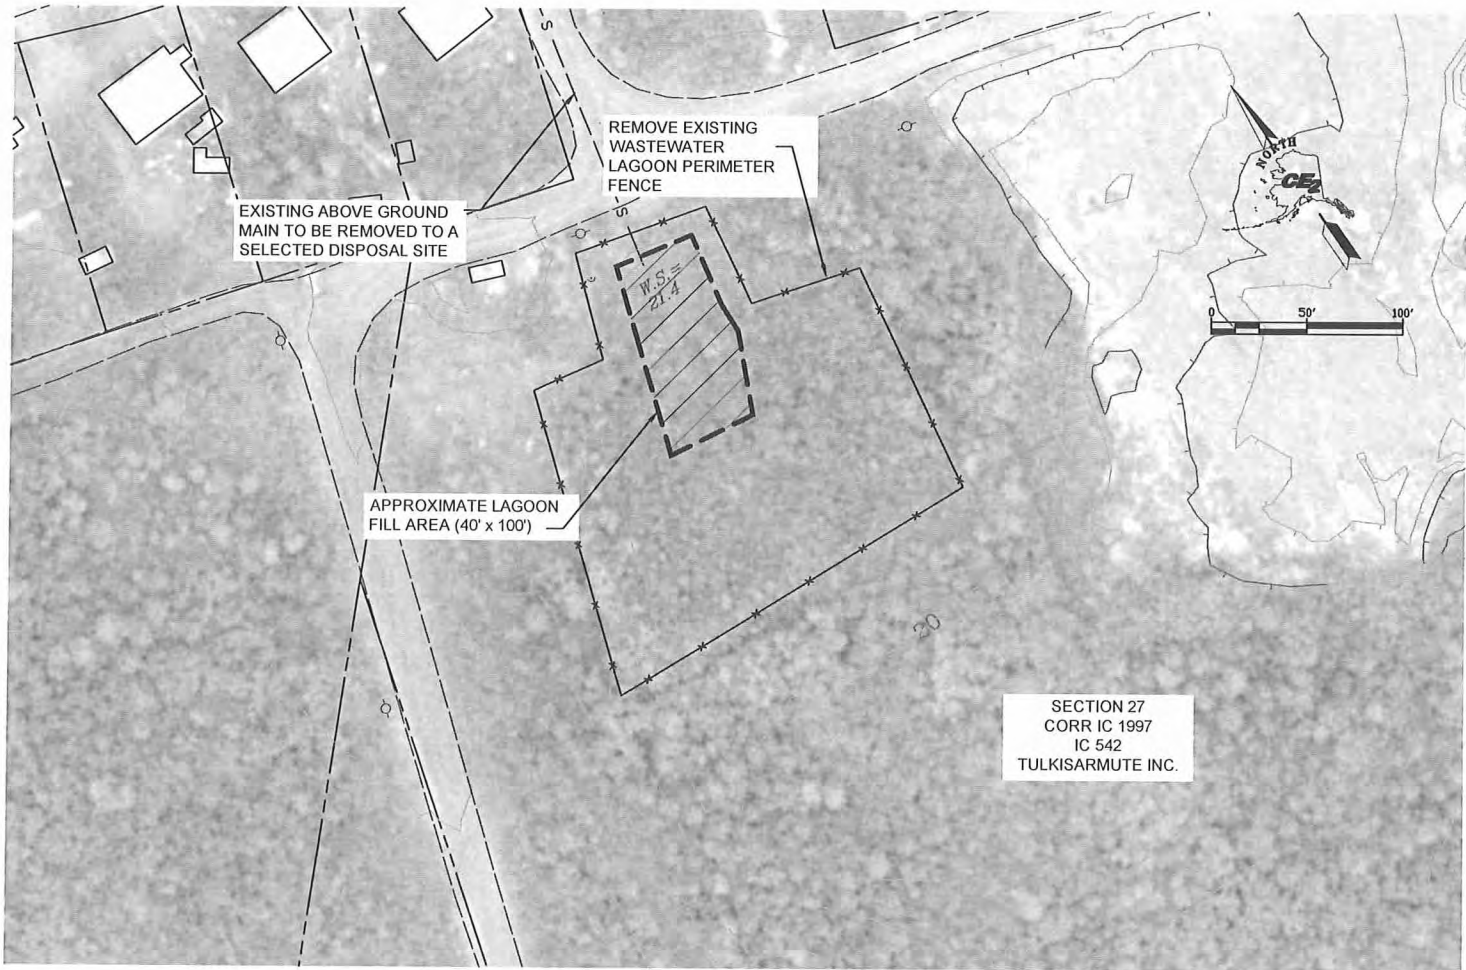

2
C4.5
EXISTING COMMUNITY WASTEWATER LAGOON

CLOSE OUT PLAN OF EXISTING TULUKSAK WASTEWATER LAGOONS

OBJECTIVE:

- TO CLOSE OUT THE EXISTING SCHOOL WASTEWATER LAGOON AND THE EXISTING COMMUNITY LAGOON. THE LAGOONS ARE CURRENTLY IN USE. THE LAGOONS CAN BE ABANDONED UPON CONSTRUCTION OF THE PHASE I AND II WASTEWATER IMPROVEMENTS BEING CONSTRUCTED BY TULUKSAK NATIVE COMMUNITY (TNC) USING VILLAGE SAFE WATER FUNDING

ASSUMPTIONS:

- SLUDGE PROPOSED TO BE COVERED UNDER THIS PLAN IS ASSUMED NOT TO CONTAIN HAZARDOUS WASTES (SLUDGE HAS BEEN GENERATED FROM DOMESTIC WASTEWATER) AND DOES NOT CONTAIN CONCENTRATIONS OF POLYCHLORINATED BIPHENYLS (PCB) WASTES.
- SLUDGE TO BE COVERED UNDER THIS PLAN DOES NOT CONTAIN "FREE LIQUIDS" AS DEFINED BY EPA METHOD 9095 (PAINT FILTER LIQUIDS TEST) AND LIQUIDS ARE NOT IGNITABLE OR CORROSIVE.

CLOSURE PLAN:

- LIQUID CONTENTS OF THE LAGOONS AT THE TIME OF CLOSEOUT WILL BE PUMPED INTO THE NEW WASTEWATER SYSTEM FOR DISCHARGE INTO THE NEW COMMUNITY WASTEWATER LAGOON.
- AFTER PUMPING OUT THE LIQUID PORTION, SELECTIVE BRUSH CUTTING WILL PREPARE THE AREA TO BE CLOSED. THE BRUSH WILL BE HAULED TO THE COMMUNITY DISPOSAL SITE.
- THE REMAINING SLUDGE WILL BE TREATED WITH HYDRATED LIME TO DESTROY EXISTING PATHOGENS.
 - SCHOOL LAGOON - UNIFORMLY SPREAD 2700# OF LIME OVER THE 90' X 100' AREA (3#/10SQ. FT.)
 - COMMUNITY LAGOON - UNIFORMLY SPREAD 1200# OF LIME OVER THE 40'X100' AREA (3#/10 SQ. FT.)LIME COVERAGE WILL BE AT THE RATE OF 50 POUNDS PER 1000 GALLONS OF SLUDGE. THE LIME WILL BE INTEGRATED INTO THE TOP THREE INCHES. THIS HYDRATED LIME ADDITION WILL BRING THE PH TO 12 FOR A MINIMUM OF THIRTY MINUTES.
- LOCAL SILT WILL BE PLACED OVER THE LIMED SLUDGE TO A DEPTH THAT PROVIDES DRAINAGE AWAY FROM THE AREA. MINIMUM DEPTH OF FILL WILL BE TWO FEET.
- AGGRESSIVELY REVEGETATE LAGOON COVER MATERIAL TO ELIMINATE EROSION OF NEW LAGOON COVER MATERIAL. (SEE GENERAL NOTES FOR REQUIREMENTS.)

RECORD DRAWING CERTIFICATE
THESE DRAWINGS REFLECT RECORDED
INFORMATION OBTAINED DURING
CONSTRUCTION. INFORMATION PROVIDED
HEREIN IS ACCURATE TO THE BEST OF MY
KNOWLEDGE.
NAME _____ DATE _____

SCALE:
AS SHOWN
BARS IN ONE INCH ON
ORIGINAL DRAWING
1"
IF ANY SCALE IS ON
THIS SHEET, ADJUST
SCALES ACCORDINGLY



2010-11 WASTEWATER
SYSTEM IMPROVEMENTS
EXISTING WASTEWATER
LAGOON'S CLOSE-OUT
TULUKSAK, ALASKA



REVISION	BY	DATE
LAGOON RELOCATION	LP	8/10

Project No.	SEPT 2010	LAP
Date		
Designed		
Drawn	Civil/LAW	
Approved	LAP	

Sheet No.
C4.5



Project No.	SEPT 2010
Date	LAP
Designed	Civilaw
Drawn	LAP
Approved	

Sheet No.	C4.6
-----------	------

CFE2
ENGINEERS, INC.

PO BOX 2264 ANCHORAGE AK 99523 PH: 907-346-0100 FAX: 907-346-1015

2010-11 WASTEWATER
SYSTEM IMPROVEMENTS

FIVE ARRA
SERVICE LINES

TULUKSAK, ALASKA



SCALE:
AS SHOWN

1" = 10'

IF NOT ONE INCH ON THIS SHEET, ADJUST SCALES ACCORDINGLY


RECORD DRAWING CERTIFICATE

THESE DRAWINGS REFLECT RECORDED INFORMATION OBTAINED DURING CONSTRUCTION. INFORMATION PROVIDED HEREIN IS ACCURATE TO THE BEST OF MY KNOWLEDGE.

NAME _____


DATE _____

G:\ACAD\TULUKSAK\TLT0901 2008 Waste water disposal area\C5.1 ARCTIC PIPE DETAILS.dwg, 1/11/2011 1:44:01 PM, Flash, LANIER NP C2050_LD520C PCL 6BLK WHIT .p3

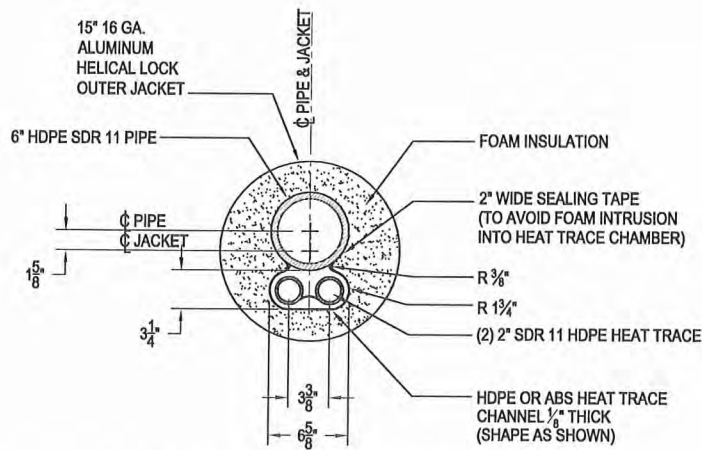


1
C5.1 1 1/2"=1'-0"

6" X 15" HDPE ARCTIC PIPE
CROSS SECTION - GLYCOL TRACED

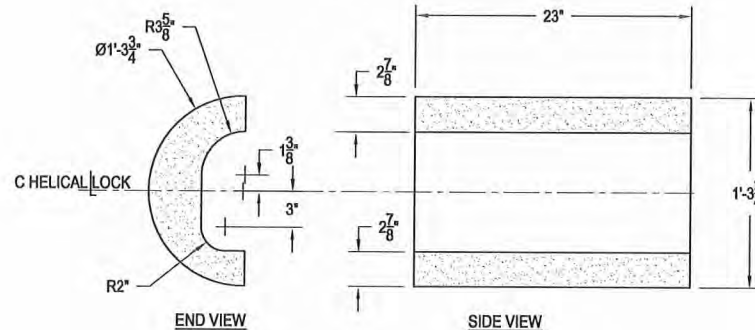


2
C5.1 1 1/2"=1'-0"

6" X 15" HDPE ARCTIC PIPE
HALF SHELL - GLYCOL TRACED

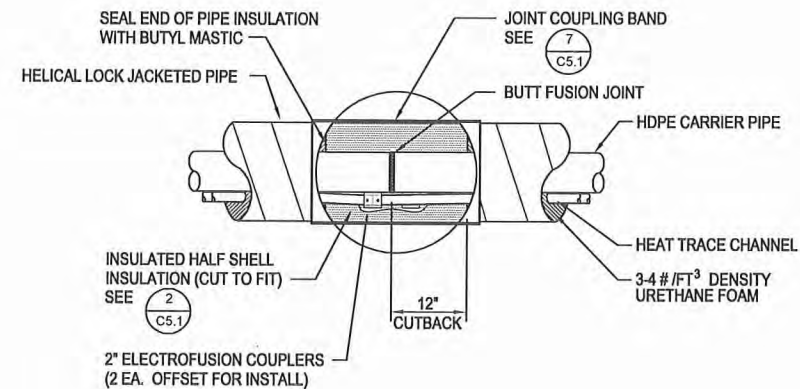

3
C5.1 NTS (FORCEMAIN ONLY)


BUTT FUSION JOINT w/ HEAT
TRACE ELECTROFUSION COUPLERS

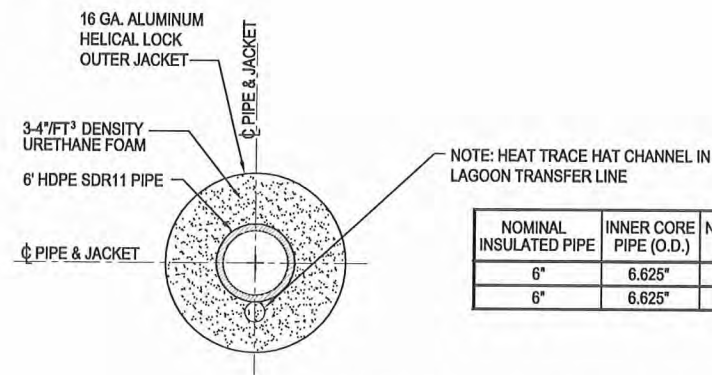

4
C5.1 NTS

HDPE ARCTIC PIPE CROSS
SECTION LAGOON TRANSFER LINE

NOMINAL INSULATED PIPE	INNER CORE PIPE (O.D.)	NOMINAL OUTSIDE JACKET SIZE	AVERAGE OUTER JACKET SIZE (O.D.)
6"	6.625"	15" MIN.	15.75"
6"	6.625"	12" MIN.	12.75"

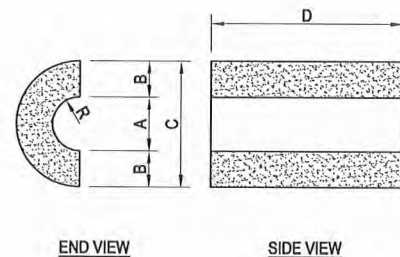


HALF SHELL	A	B	C	D
6"	6 3/4"	4 1/2"	15 3/4"	23"
6"	6 3/4"	3"	12 3/4"	23"

R=A/2
C=OUTSIDE DIAMETER


5
C5.1 NTS

INSULATION HALF SHELL DETAIL

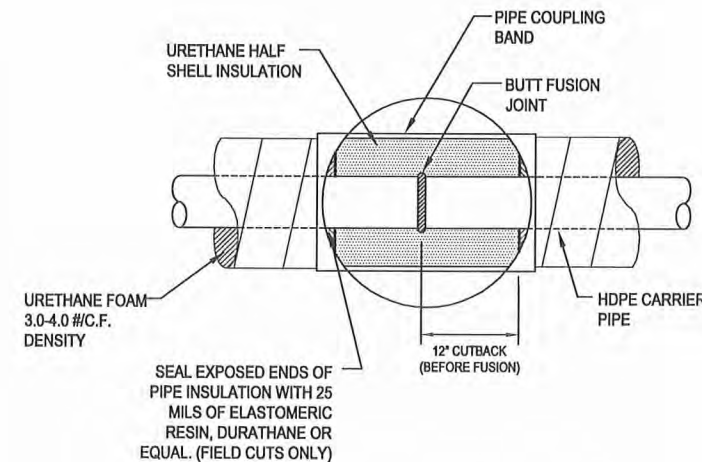


6
C5.1 NTS (WATERMAIN AND SERVICE DUCT)

BUTT FUSED JOINT DETAIL

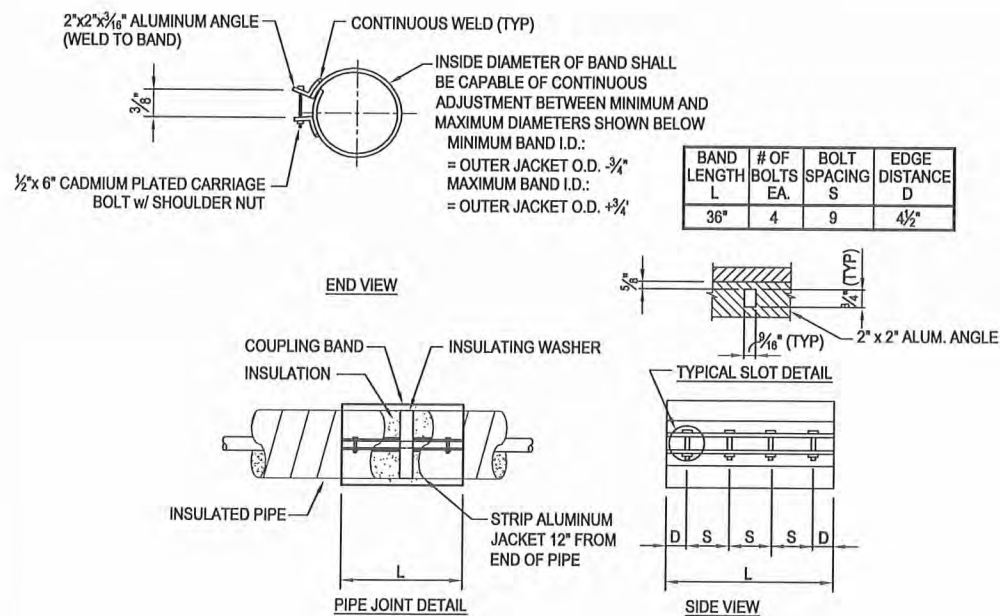

7
C5.1 NTS

ARCTIC PIPE COUPLING BAND

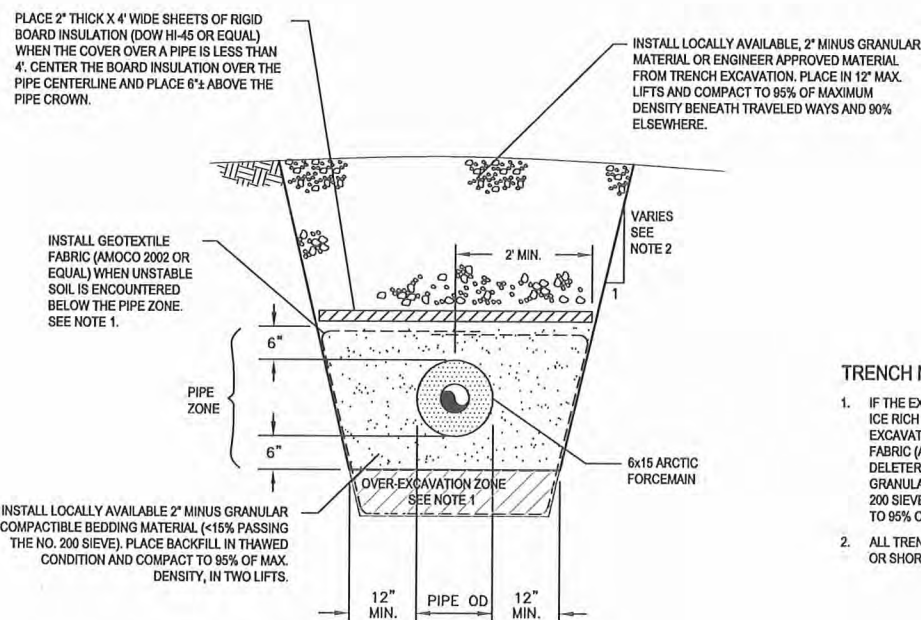

A
C5.1 NTS

TYPICAL TRENCH SECTION FOR PIPE
INSTALLED BENEATH PROPOSED ACCESS ROAD

TRENCH NOTES:

- IF THE EXCAVATION ENCOUNTERS ORGANICS, SILTS AND/OR ICE RICH PERMAFROST BENEATH THE PIPE ZONE, OVER EXCAVATE A MINIMUM OF 12" AND INSTALL GEOTEXTILE FABRIC (AMOCO 2002 OR EQUAL) AS SHOWN. REPLACE THE DELETERIOUS MATERIAL WITH LOCALLY AVAILABLE 2" MINUS GRANULAR COMPACTIBLE FILL (WITH <15% PASSING THE NO. 200 SIEVE). PLACE FILL IN THAWED CONDITION AND COMPACT TO 95% OF MAXIMUM MODIFIED PROCTOR DRY DENSITY.
- ALL TRENCHES AND OTHER EXCAVATIONS SHALL BE SLOPED OR SHORED IN ACCORDANCE WITH OSHA STANDARDS.

RECORD DRAWING CERTIFICATE
THESE DRAWINGS REFLECT RECORDED
INFORMATION OBTAINED DURING
CONSTRUCTION. INFORMATION PROVIDED
HEREIN IS ACCURATE TO THE BEST OF MY
KNOWLEDGE.

SCALE:
AS SHOWN
BARS TO ONE INCH ON
ORIGINAL DRAWING
IF NOT ONE INCH ON
THIS SHEET, ADJUST
SCALES ACCORDINGLY



2010-11 WASTEWATER
SYSTEM IMPROVEMENTS
ARTIC PIPE DETAILS
TULUKSAK, ALASKA


CE2
ENGINEERS, INC.
PO BOX 22504 ANCHORAGE, AK 99523 PH: 907-346-0100 FAX: 907-346-1015

REVISION	BY	DATE


Project No.	Date	Designed	Drawn	Approved
	JUNE 2009	LAP	DDR	LAP

Sheet No.
C5.1


G:\ACAD\TULUKSAK\TLT0901 2008 Waste water disposal area\C5.2.dwg, 1/11/2011 1:47:10 PM, Flash, LANIER MP C2050_LD520C PCL 6BLK WHIT, pc3

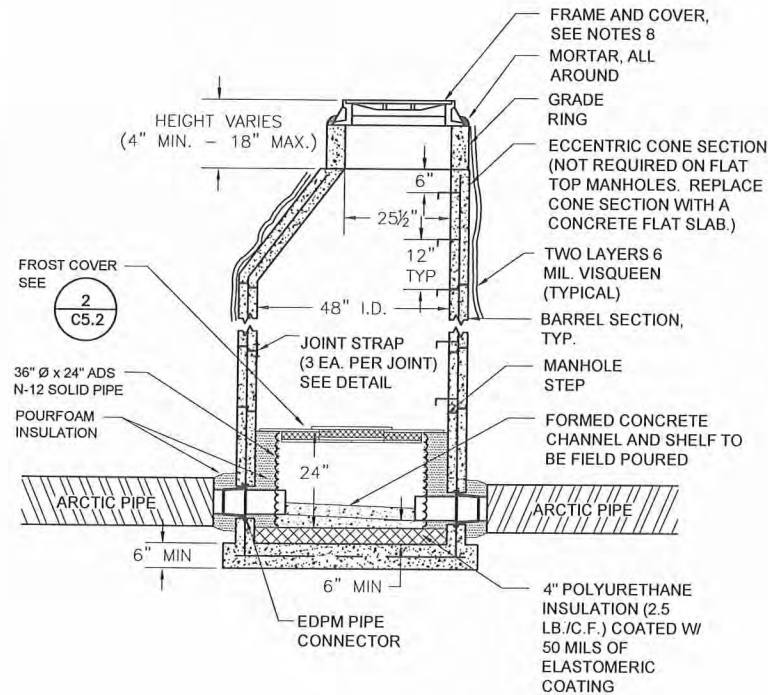


1 MANHOLE DETAILS
C5.2 SCALE: NTS

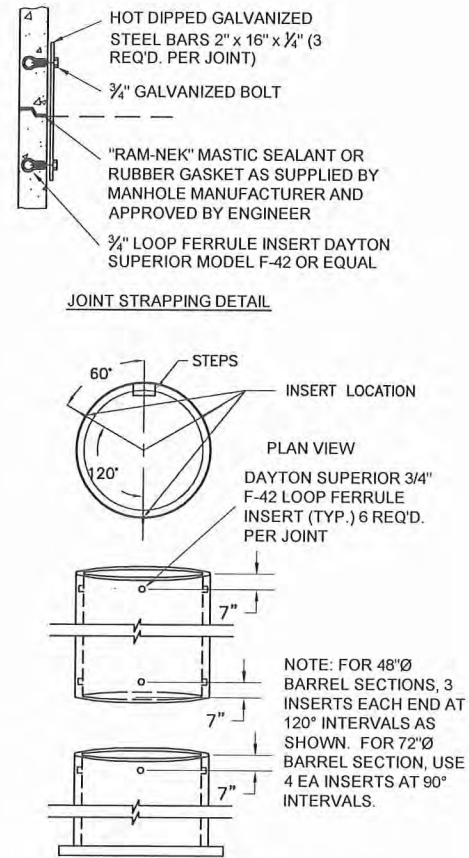


FERRULE INSERT LOCATIONS

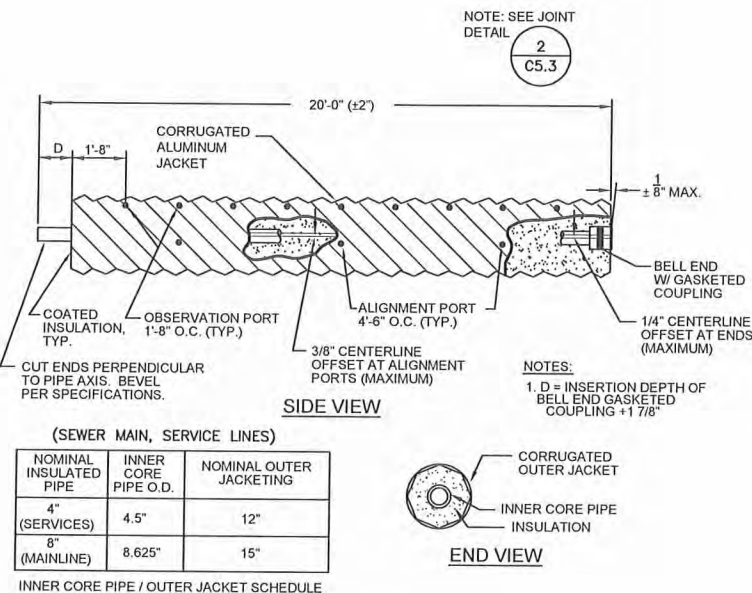


3 HDPE SEWER MAIN ALUMINUM JACKET
C5.2 SCALE: NTS

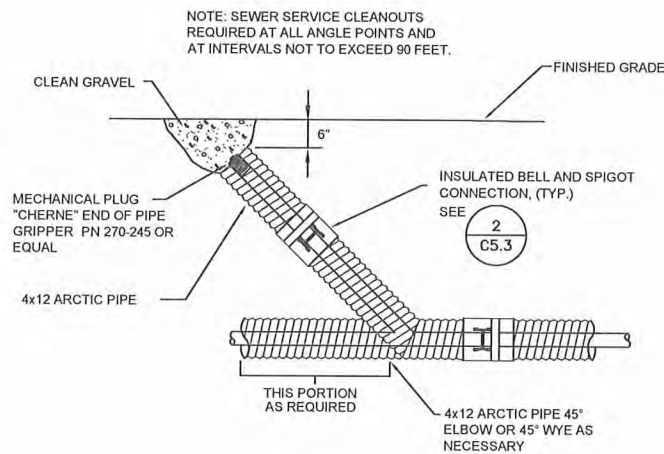


4 SEWER SERVICE CLEANOUT
C5.2 SCALE: NTS

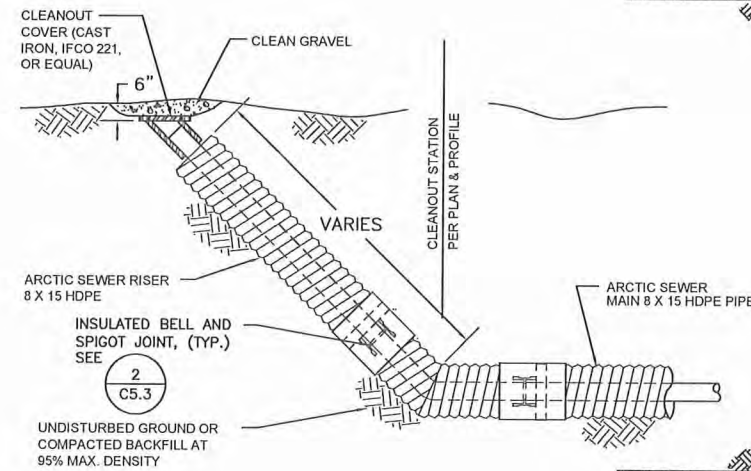

5 SEWER MAIN CLEANOUT
C5.2 SCALE: NTS

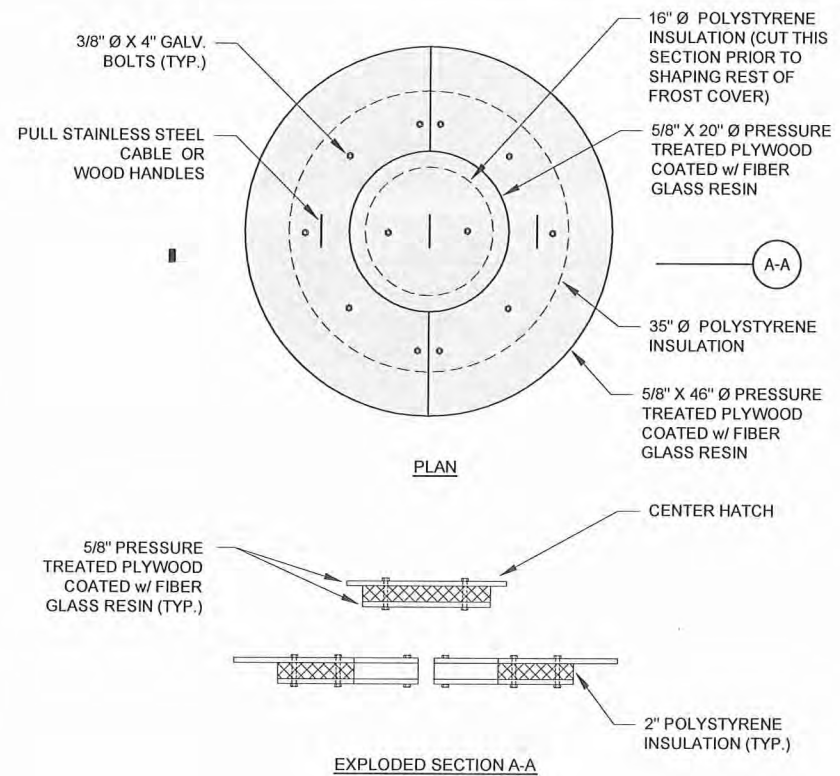

2 MANHOLE FROST COVER DETAILS
C5.2 SCALE: NTS

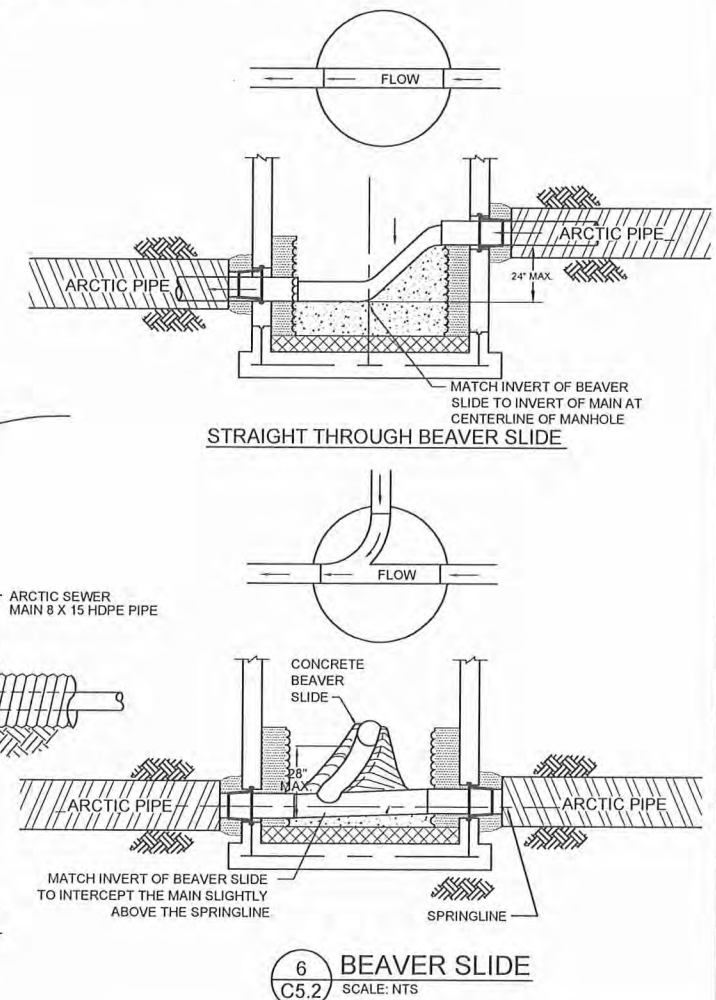

6 BEAVER SLIDE
C5.2 SCALE: NTS

SANITARY MANHOLE NOTES:

1. PRECAST MANHOLE SECTIONS SHALL BE REINFORCED CONCRETE CONFORMING TO ASTM C-478.
2. THE MANHOLE BASE SHALL BE INTEGRALLY CAST WITH THE BOTTOM BARREL SECTION.
3. RAM-NEK SEALANT OR ENGINEER APPROVED RUBBER GASKET AS SUPPLIED FROM MANHOLE MANUFACTURER SHALL BE INSTALLED AT ALL PRECAST JOINTS.
4. LOOP FERRULE INSERTS AND JOINT STRAPS SHALL BE PROVIDED AS SHOWN ON THE DETAIL.
5. EDPM PIPE CONNECTORS (Z-LOCK OR EQUAL) SHALL BE INSTALLED AT ALL PIPE PENETRATIONS.
6. PIPES PENETRATING THE MANHOLE SHALL EXTEND 3 INCHES INTO THE MANHOLE.
7. FOR MANHOLE HEIGHTS LESS THAN 6 FEET, SUBSTITUTE A PRECAST REINFORCED CONCRETE FLAT SLAB TOP FOR THE ECCENTRIC CONE SECTION.
8. MANHOLE RING, CATCH PAN AND SOLID COVER MARKED "SEWER" SHALL MEET ALASKA DEPARTMENT OF TRANSPORTATION STANDARD SPECIFICATION (IFCO 740 OR EQUAL).
9. MANHOLE STEPS SHALL BE CAST IN PLACE, AND SHALL BE 1/2" GRADE 60 STEEL REINFORCEMENT DIPPED IN COPOLYMER POLYPROPYLENE PLASTIC.
10. MANHOLE SHALL BE WRAPPED WITH 2 LAYERS OF 6 MIL VISQUEEN PRIOR TO BACKFILL.
11. TOP OF CASTING (T.O.C.) ELEVATION:
(a) GRAVEL ROAD SURFACE - 6" BELOW FINAL GRADE.
(b) PAVED ROAD SURFACE - INSTALL TOP OF COVER 1/2" BELOW SURFACE OF ASPHALT.
(c) OFF ROADS AND TRAVELED WAY - INSTALL TOP 6" ABOVE FINAL GRADE.

RECORD DRAWING CERTIFICATE
THESE DRAWINGS REFLECT RECORDED INFORMATION OBTAINED DURING CONSTRUCTION. INFORMATION PROVIDED HEREIN IS ACCURATE TO THE BEST OF MY KNOWLEDGE.

SCALE: AS SHOWN
1" = 1'-0"




2010-11 WASTEWATER SYSTEM IMPROVEMENTS
SEWER MAIN AND MANHOLE DETAILS
TULUKSAK, ALASKA

CER ENGINEERS, INC.
PO BOX 2294 ANCHORAGE, AK 99523 PH: 907-349-0010 FAX: 907-349-1015


REVISION	BY	DATE

Project No. JUNE 2009
Date JUNE 2009
Designed JFJ
Drawn LAM
Approved LAP

Sheet No. C5.2

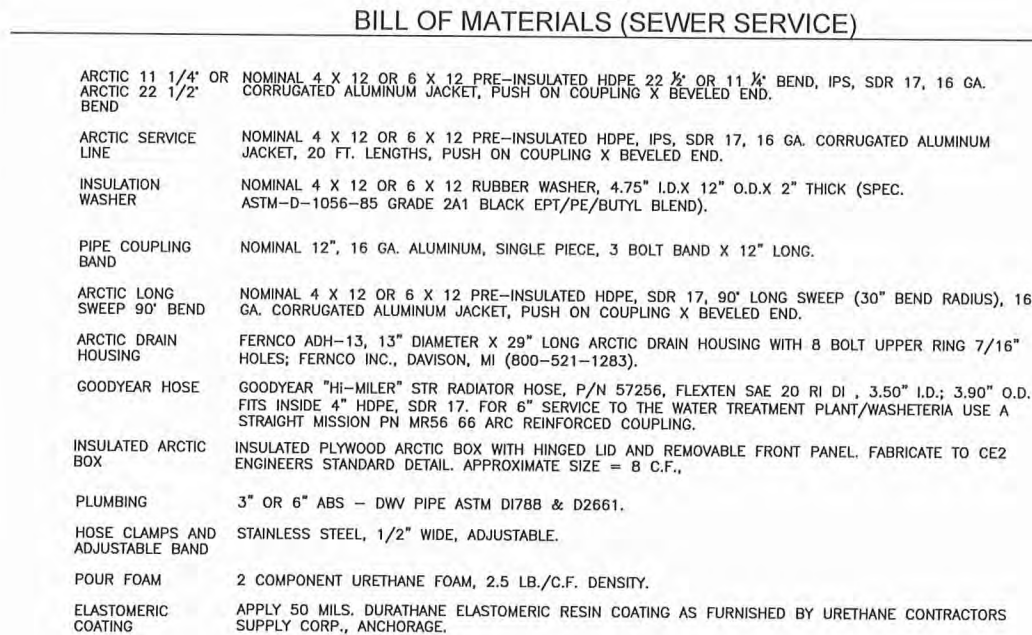


1) TYPICAL SEWER SERVICE CONNECTION TO MAIN

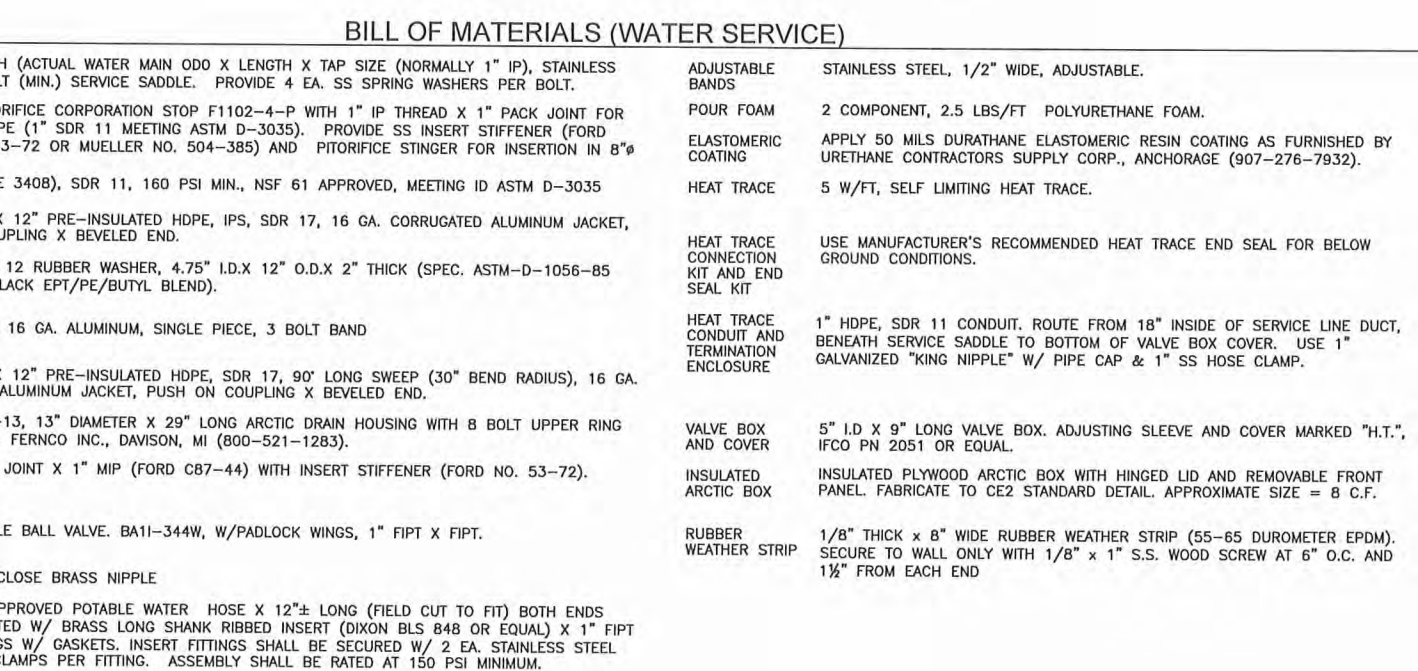

2 TYPICAL WATER SERVICE CONNECTION TO MAIN
C5.4 NTS




Sheet No. C5.4

G:\ACAD\TULUKSAK\T0901 2008 Waste water disposal area\C5.5 ARCTIC BOX DETAILS.dwg, 1/11/2011 1:46:45 PM, Flash, LANIER MP C2050_LD520C PCL 6BLK WHITE.p3

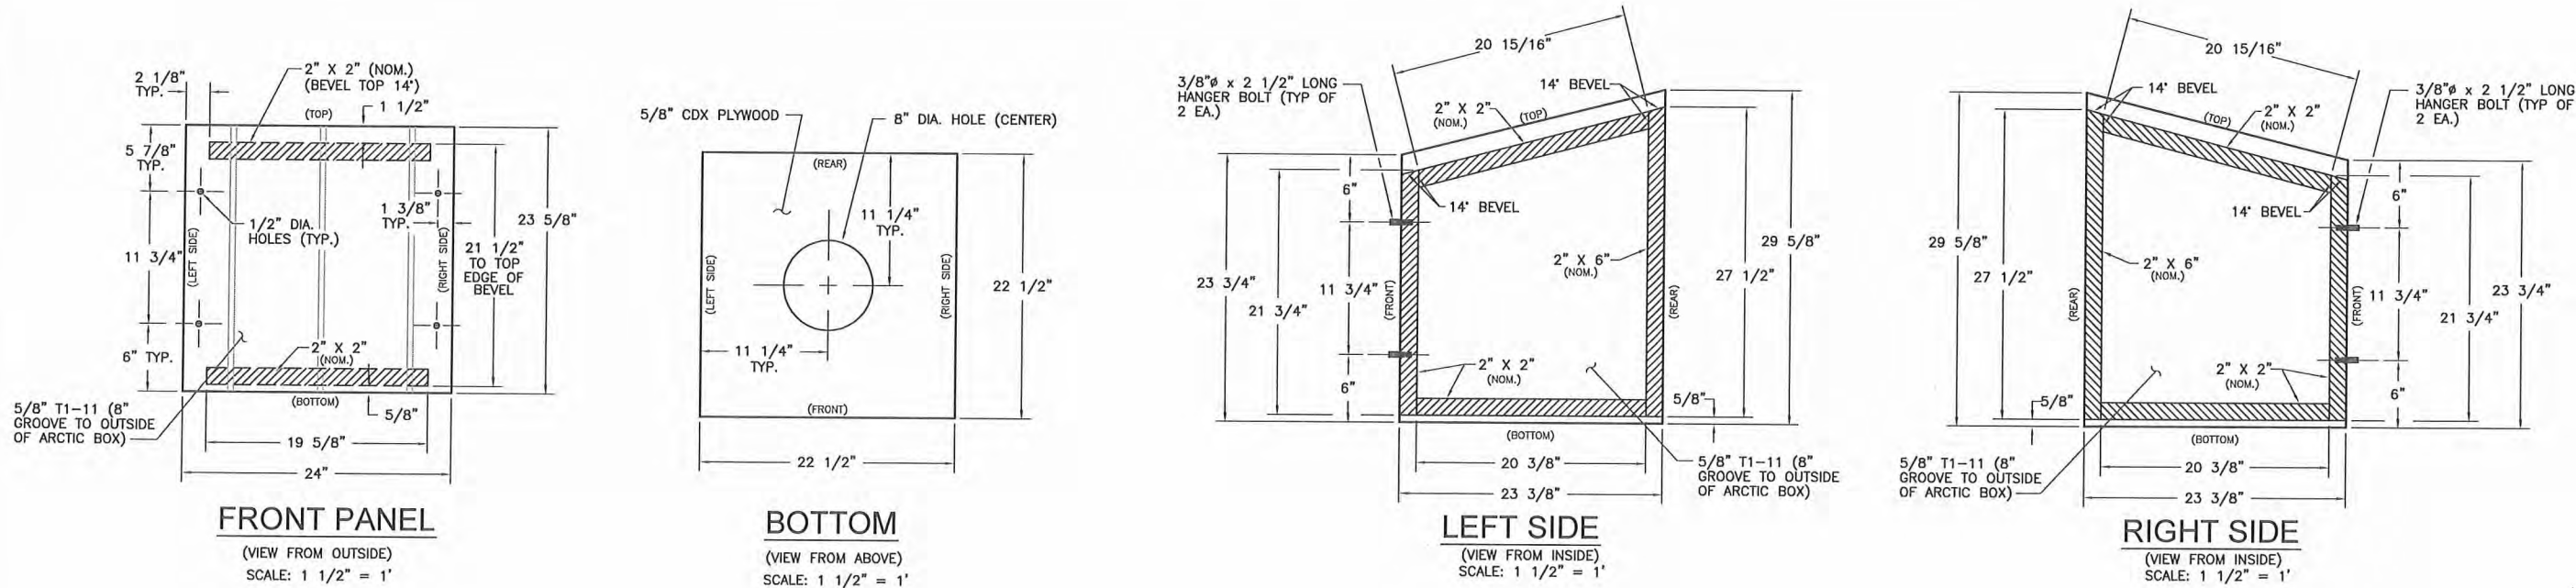

GENERAL NOTES:

- ALL "2x" MATERIAL SHALL BE GRADE #2 OR BETTER.
- FLAWED CONSTRUCTION MATERIAL SHALL NOT BE USED IN ARCTIC BOX CONSTRUCTION. FLAWED MATERIAL INCLUDES LARGE KNOTS, CRACKS, CHECKS, DELAMINATIONS, AND SPLITS CAUSED DURING ASSEMBLY.
- ALL "2X" MATERIAL SHALL BE FASTENED TO PLYWOOD AND T1-11 WITH #6 X 1 5/8" DECK SCREWS OR 1 1/2" LONG 16 GA. STAPLES AT 4" O.C.

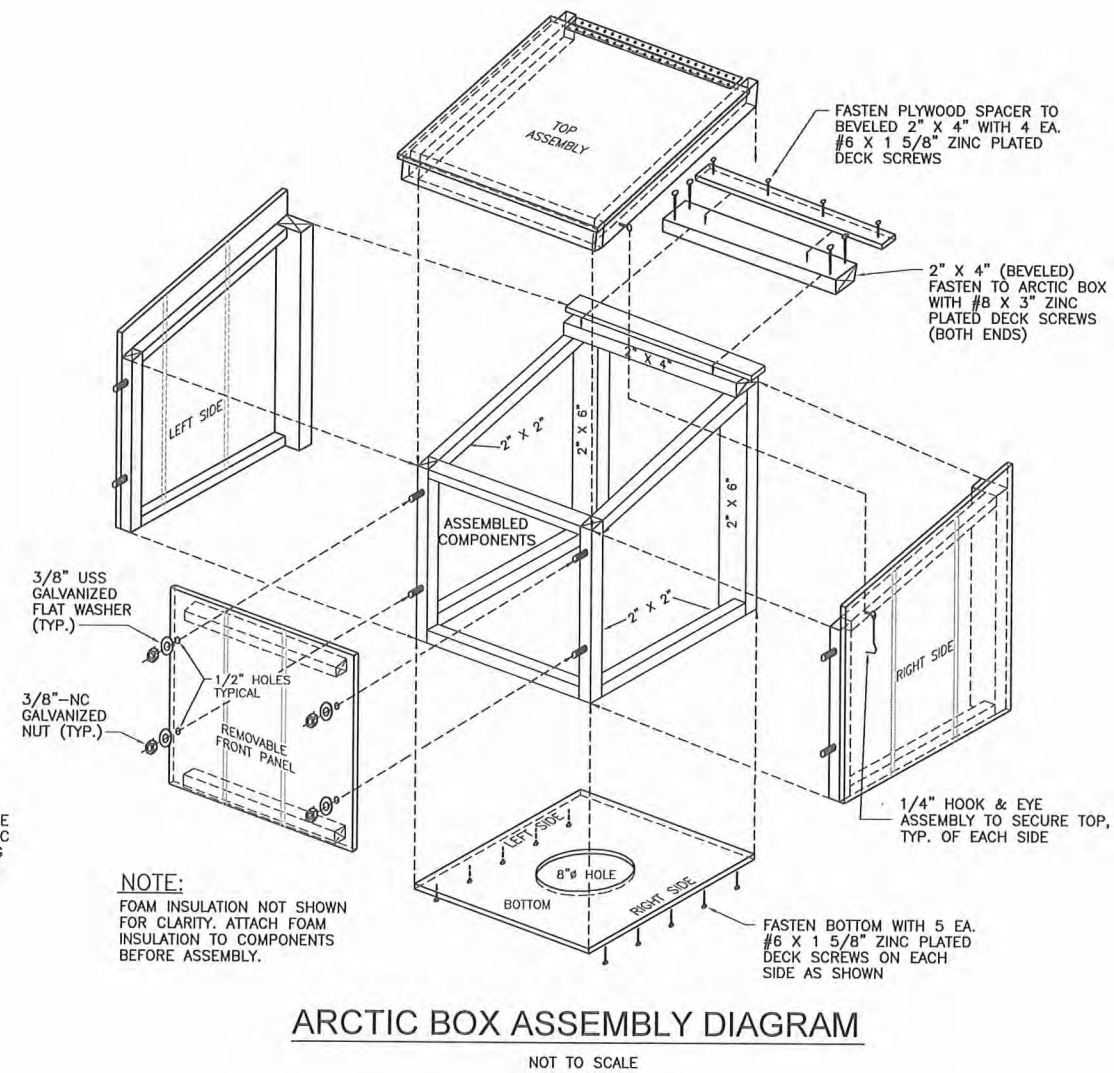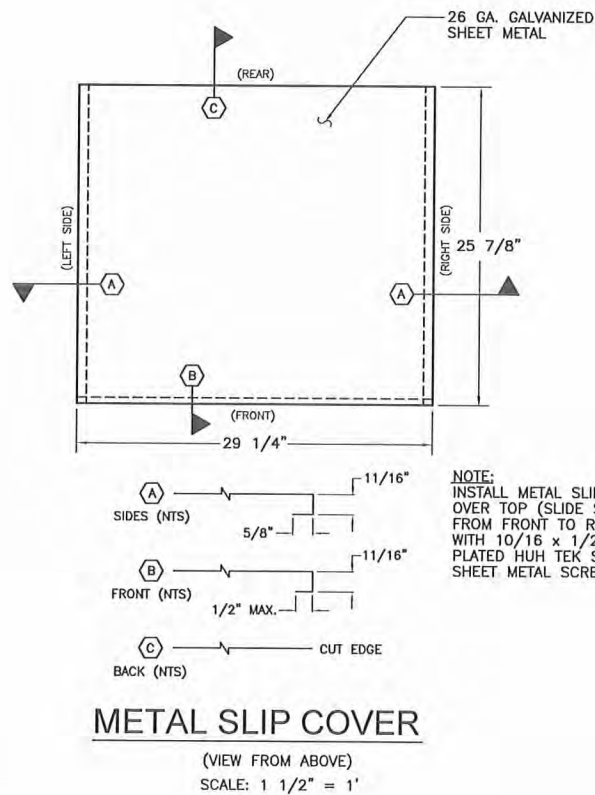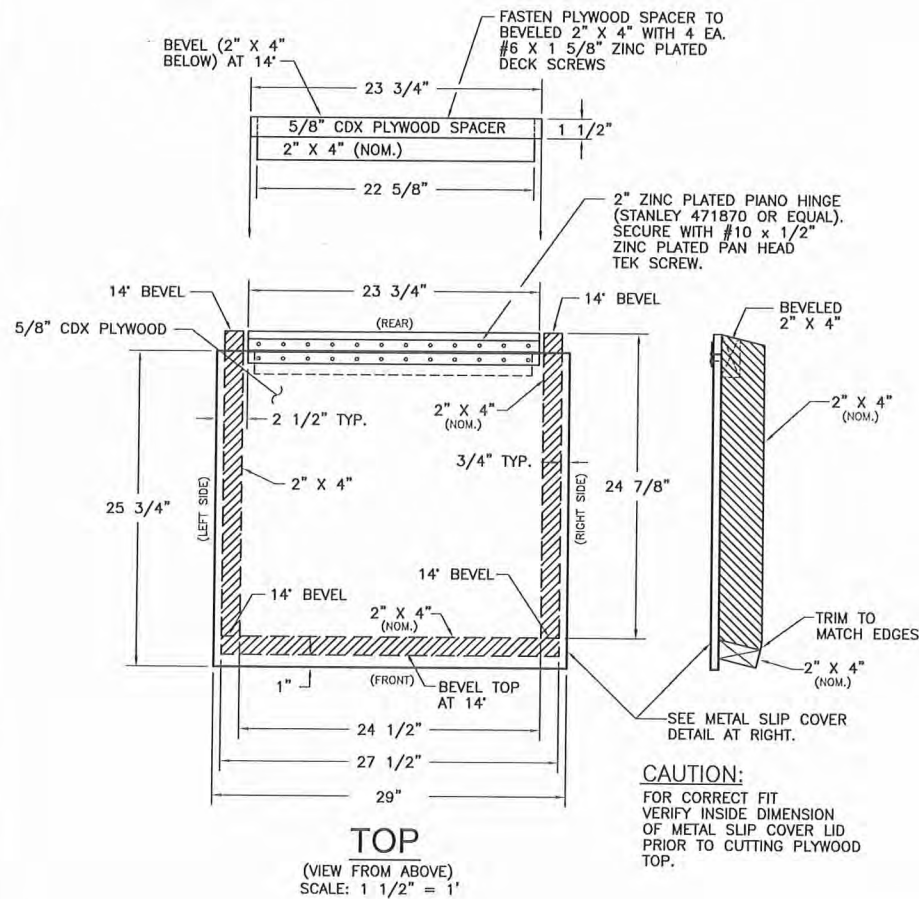

RECORD DRAWING CERTIFICATE
THESE DRAWINGS REFLECT RECORDED
INFORMATION OBTAINED DURING
CONSTRUCTION. INFORMATION PROVIDED
HEREIN IS ACCURATE TO THE BEST OF MY
KNOWLEDGE.

SCALE:
AS SHOWN
1" = 1'-0"



2010-11 WASTEWATER
SYSTEM IMPROVEMENTS
ARCTIC BOX DETAILS
TULUKSAK, ALASKA


CE2
ENGINEERS, INC.
PO BOX 22946 ANCHORAGE, AK 99502 PH: 907-346-0101 FAX: 907-346-1015

REVISION	BY	DATE
LAGOON RELOCATION	LP	8/10


Project No.	JUNE 2009	Designed	JDL	Drawn	JDL	Approved	LAP
-------------	-----------	----------	-----	-------	-----	----------	-----

Sheet No.
C5.5

G:\ACAD\TULUKSAK\TLT0901 2008 Waste water disposal area\C5.6 ARCTIC BOX DETAILS.dwg, 4/11/2011 1:31:41 PM, cmerz, LANIER MP C2050_LD520C PCL 6.pcl

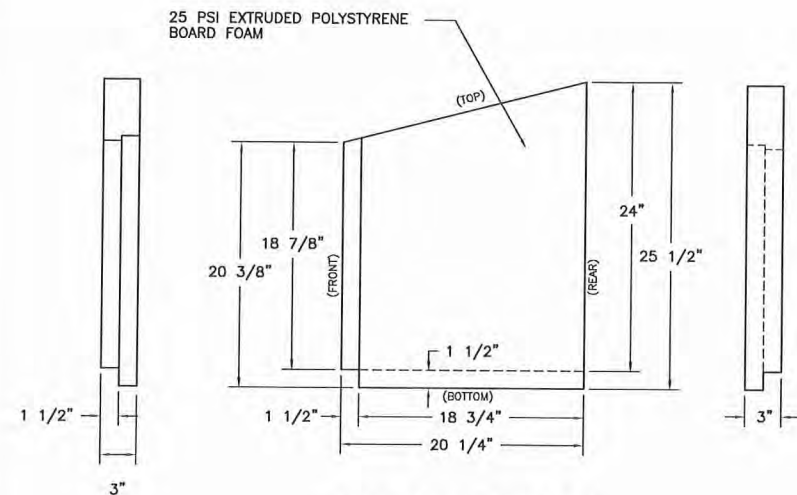


LEFT SIDE FOAM
(VIEW FROM INSIDE ARCTIC BOX)
SCALE: 1 1/2" = 1'

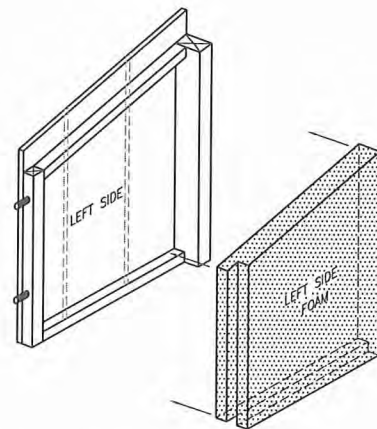


LEFT SIDE ASSEMBLY
NOT TO SCALE


NOTE:
ALL FOAM INSULATION SHALL BE SECURELY GLUED TO THE INSIDE FACE OF THE T1-11 ARCTIC BOX WITH FOAM-PLYWOOD ADHESIVE (LIQUID NAILS LN 603) TYPICAL.

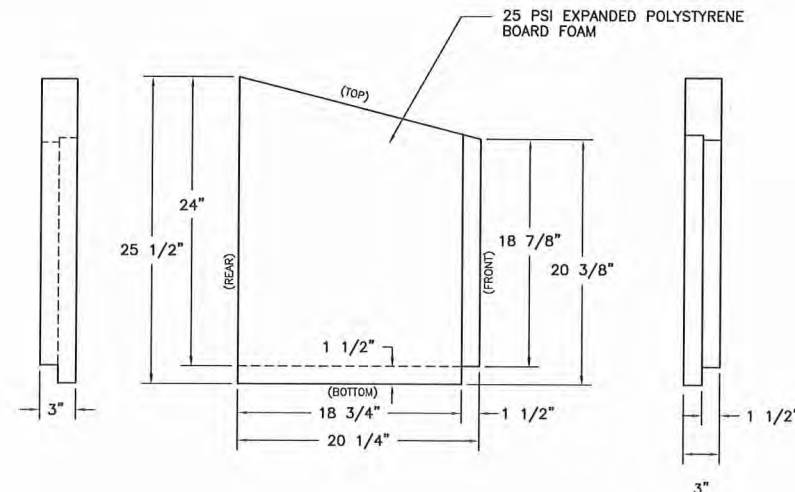


RIGHT SIDE FOAM
(VIEW FROM INSIDE ARCTIC BOX)
SCALE: 1 1/2" = 1'

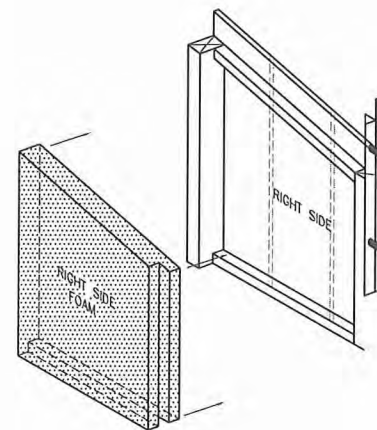


RIGHT SIDE ASSEMBLY
NOT TO SCALE

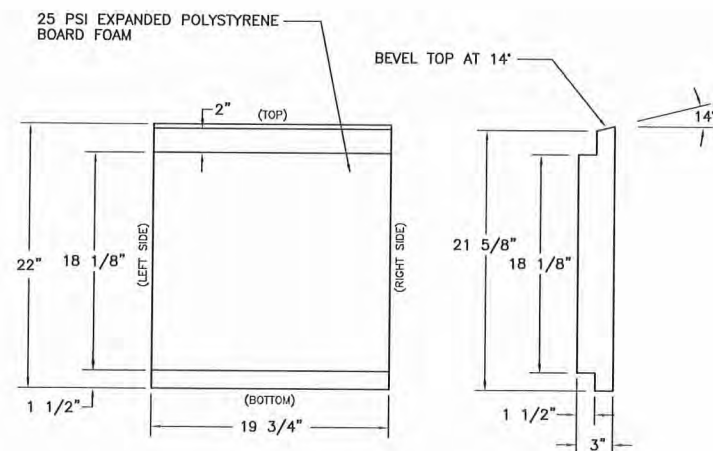


FRONT PANEL FOAM
SCALE: 1 1/2" = 1'

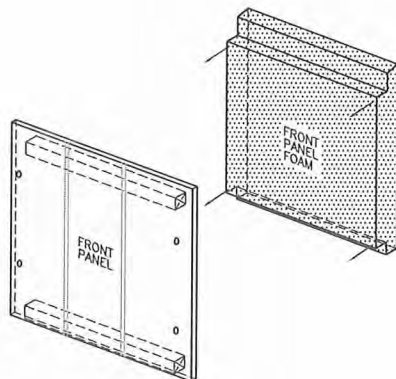

FRONT PANEL ASSEMBLY
NOT TO SCALE

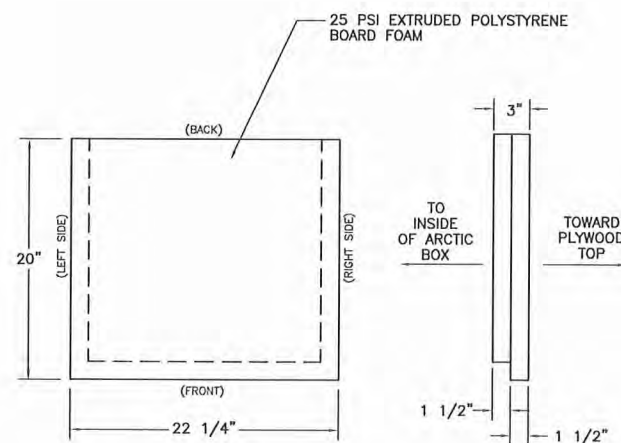

TOP FOAM
(VIEW FROM ABOVE)
SCALE: 1 1/2" = 1'

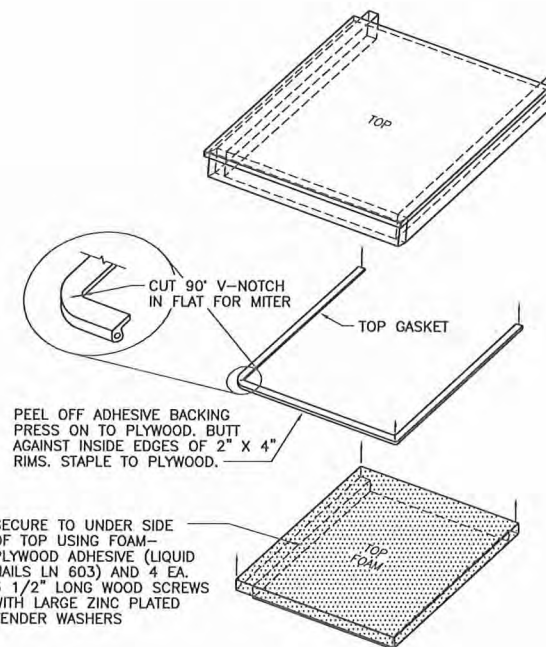

TOP ASSEMBLY
NOT TO SCALE

RECORD DRAWING CERTIFICATE
THESE DRAWINGS REFLECT RECORDED INFORMATION OBTAINED DURING CONSTRUCTION. INFORMATION PROVIDED HEREIN IS ACCURATE TO THE BEST OF MY KNOWLEDGE.
NAME _____ DATE _____

SCALE:
AS SHOWN
BAR IS ONE INCH ON ORIGINAL DRAWING
1"
0
1"
FAST ONE INCH ON THIS SHEET ADJUST SCALES ACCORDINGLY



2010-11 WASTEWATER SYSTEM IMPROVEMENTS
ARCTIC BOX DETAILS
TULUKSAK, ALASKA



CE2 ENGINEERS, INC.
PO BOX 22364 ANCHORAGE, AK 99523 PH: 907-549-1001 FAX: 907-549-1015

REVISION	BY	DATE
LAGOON RELOCATION	LP	8/10

Project No.	JUNE 2009
Date	JUN 2009
Designed	JDJ
Drawn	JDJ
Approved	LAP

Sheet No. **C5.6**

G:\ACAD\TULUKSAK\TUL0901 2008 Waste water disposal area\TFC Rev Jan 2011\W1-1 Mechanical Fred Belz.dwg, 10/14/2011 4:37:21 PM, cmerz, \\Cezmain\LANIER MP C2050\LD520C PCL 6

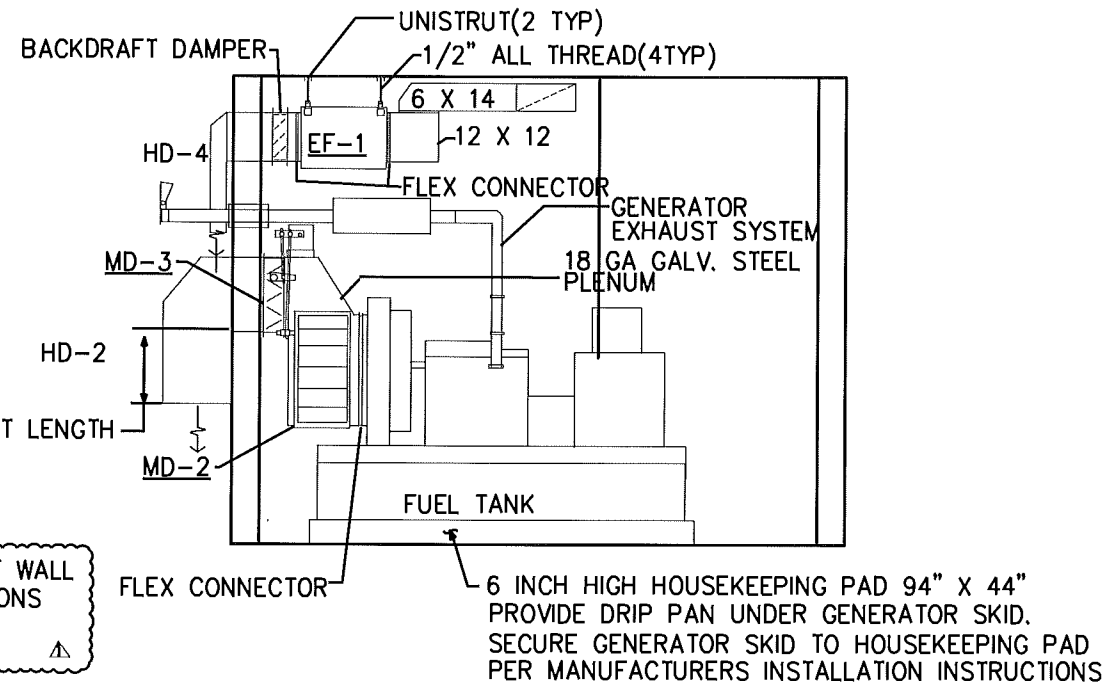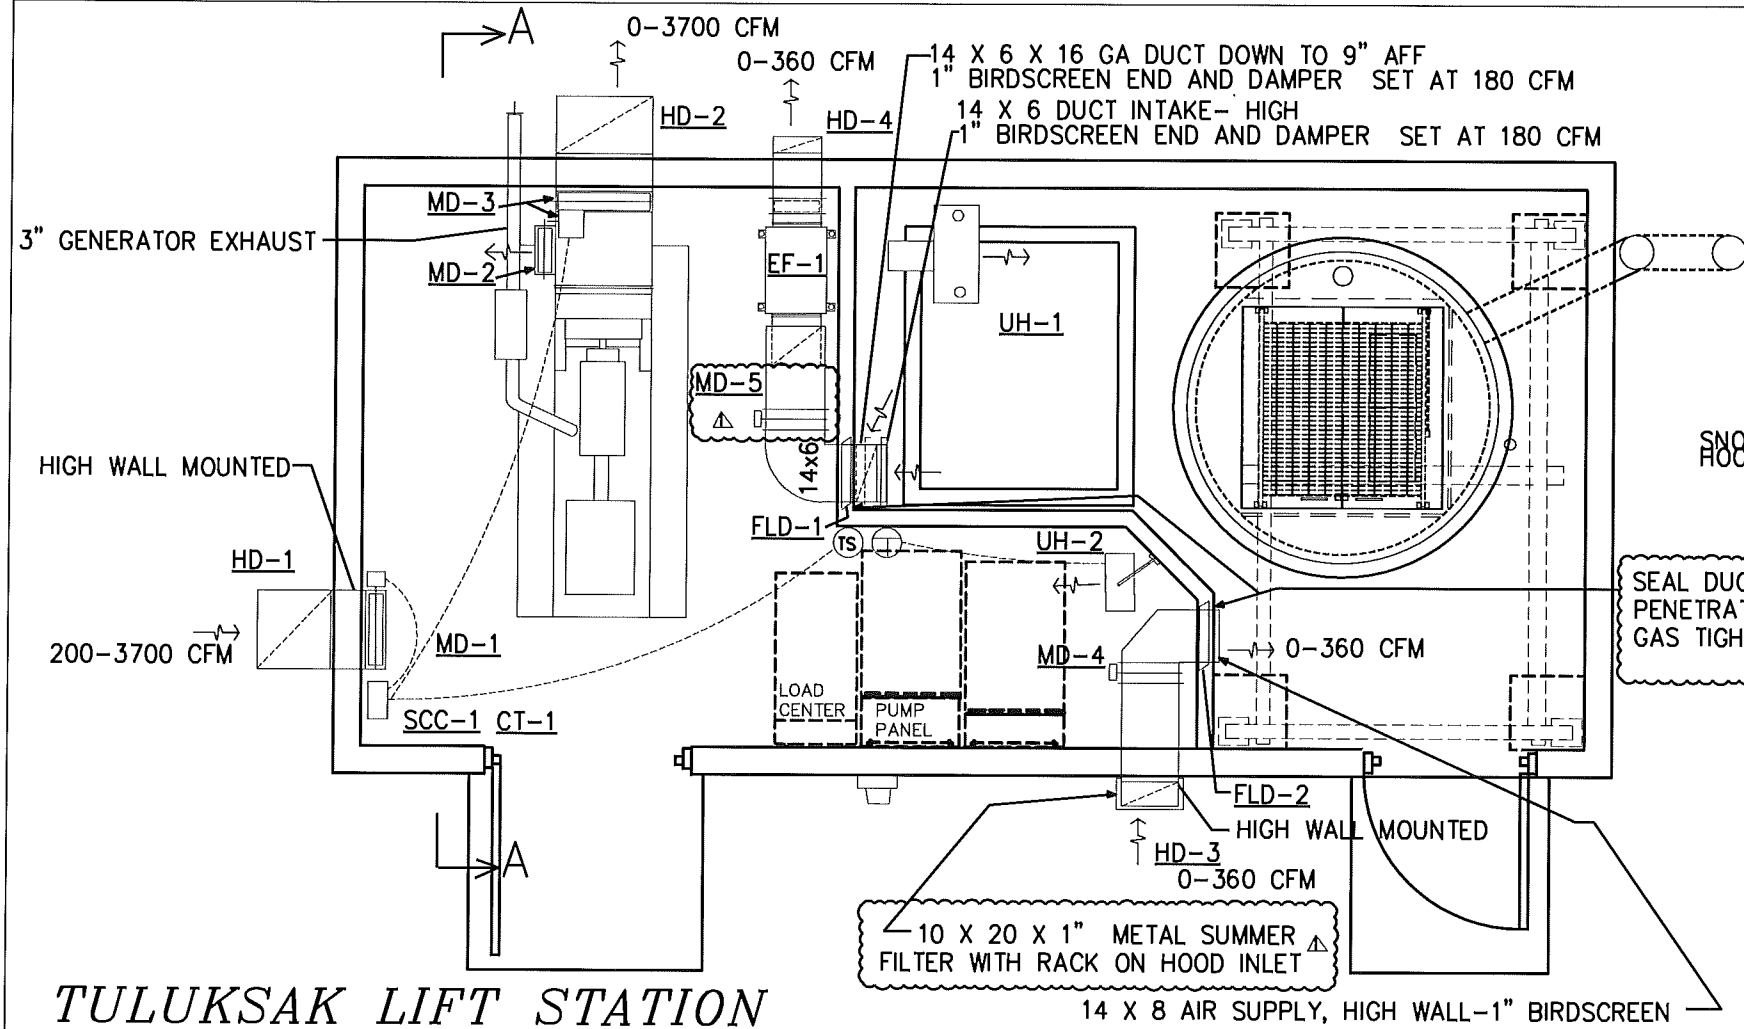

SECTION A-A

SCALE: 1/4"=1'-0"

SCC-1 CONTROLLER FOR MD-1 DAMPER MOTOR, MD-2, MD-3 DAMPER MOTOR:
2 INPUTS: START-STOP CONTROL, ANALOG ROOM TEMPERATURE
2 OUTPUTS: RELAY CONTROL OPEN CLOSE MD-1 MODULATE 4-20 MA MD-2,3
DAMPER CONTROL SIGNAL
MFG: HONEYWELL T775M2006 WITH C7130B1009 ROOM SENSOR

TULUKSAK LIFT STATION

MD-1 MOTORIZED DAMPER 24 WIDE X 16 HIGH. LOW LEAKAGE, 3 POSITION DAMPER SCALE: 1/4"=1'-0"

MFG: RUSKIN CD-50 DAMPER WITH BELIMO AF24 W/ZDB-AF2 SPRING RETURN ACTUATOR 24 VAC 5 VA
SUMMER FILTER: 16 X 25 X 1 AAF 316-001-600 OR EQUAL

MD-2 MOTORIZED DAMPER 12" WIDE X 26" HIGH. LOW LEAKAGE, VARIABLE POSITION DAMPER

MFG: DAMPER: RUSKIN CD-50 WITH COMMON OPERATOR WITH MD-3

MD-3 MOTORIZED DAMPER 24" WIDE X 18" HIGH. LOW LEAKAGE, VARIABLE POSITION DAMPER

MFG: RUSKIN CD-50 DAMPER WITH HONEYWELL M9185E MOTOR W/4074 EDC MODULE 24 VAC 24 VA
PROVIDE CRANK ARMS, RODS, AND FITTINGS TO EFFECT 2 DAMPER CONTROL

MD-4 MOTORIZED DAMPER 14" WIDE X 8" HIGH. LOW LEAKAGE, TWO POSITION DAMPER

MFG: RUSKIN CD-50 DAMPER WITH BELIMO AF24 W/ZDB-AF2 SPRING RETURN ACTUATOR 24 VAC 5 VA

MD-5 MOTORIZED DAMPER 14" WIDE X 6" HIGH. LOW LEAKAGE, TWO POSITION DAMPER

MFG: RUSKIN CD-50 DAMPER WITH BELIMO AF24 W/ZDB-AF2 SPRING RETURN ACTUATOR 24 VAC 5 VA

SUMMER FILTER: 10 X 20 X 1 AAF 316-001-200 OR EQUAL

HD-1 INTAKE HOOD: 24" WIDE X 18" DEEP WITH 36 INCH SNOOT. 16 GA. GALVANIZED
STEEL, 1" BIRDSCREEN, SEE DETAIL SHEET M1-2

HD-2 EXHAUST HOOD: 24" WIDE X 16" DEEP WITH 9 INCH SNOOT. 16 GA. GALVANIZED
STEEL, 1" BIRDSCREEN, SEE DETAIL SHEET M1-2

HD-3 INTAKE HOOD: 14" WIDE X 8" DEEP WITH 18 INCH SNOOT. 16 GA. GALVANIZED
STEEL, 1" BIRDSCREEN, SEE DETAIL SHEET M1-2

FLARE INTAKE OF HD-3 FOR 10x20 METAL FILTER w/ RACK FOR SUMMER FILTER

HD-4 EXHAUST HOOD: 12" WIDE X 5" DEEP WITH 16 INCH SNOOT. 16 GA. GALVANIZED
STEEL, 1" BIRDSCREEN, SEE DETAIL SHEET M1-2

FLD-1 DYNAMIC FIRE DAMPER 14 X 6 MFG: RUSKIN DIBD2 OR EQUAL

FLD-2 DYNAMIC FIRE DAMPER 14 X 8 MFG: RUSKIN DIBD2 OR EQUAL

SEQUENCE OF OPERATION: LIFT STATION AREA

EF-1, MD-4, MD-5 OPERATION: EF-1, MD-4, MD-5 ARE INTERLOCKED. WHEN WALL SWITCH OUTSIDE
LIFT STATION DOOR IS SET TO "ON" EF-1 STARTS, MD-4 OPENS, MD-5 OPENS TO FULL OPEN. SWITCH ACTIVATES
FLASHING RED LIGHT (LABELED "UNSAFE TO ENTER"). LIGHT IS ON FOR 5 MINUTES TO PURGE AREA AND AT
THE END OF THE 5 MINUTE TIME A GREEN LIGHT (LABELED "MONITOR WET WELL ROOM WITH COMBUSTIBLE GAS
DETECTOR PRIOR TO ENTRY"). WHEN OPERATOR LEAVES WORK AREA THE SWITCH IS SET TO "OFF" AND
EF-1 STOPS & MD-5, MD-5 DAMPERS CLOSE.

CT-1 CONTROL TRANSFORMER: 120 V PRIMARY/ 24 VAC SECONDARY 60 VA MFG: HONEYWELL OR EQUAL

EF-1 EXHAUST FAN: INLINE TYPE, BELT DRIVE. 360 CFM@ 0.4 INCHES W.C., ALUMINUM HOUSING AND WHEEL
STAINLESS STEEL FASTENERS, PERMATECTOR COATING, TOGGLE SWITCH, DUAL DRIVES, GRIP NOTCH BELTS
SPRING HANGER ISOLATORS, GREASABLE BEARINGS WITH EXTENDED LUBE LINES, TEFC MOTOR, BACKDRAFT
DAMPER, MOTOR COVER. MFG: GREENHECK BSQ 90-4 1/4 HP/115V/1 PH OR APPROVED EQUAL

GENERATOR: NOMINAL 40 KW 208/3 PH/60 HZ SEE ELECTRICAL FOR CONFIG: MFG: KOHLER 40RE0ZJC (VERIFY)
WIDE SKID CONFIG, DIESEL ENGINE, 1530 LB, 113 GALLON INTEGRAL SKID FUEL TANK (14 HIGH X 90.5 L X 41 WIDE,
GENERATOR EXHAUST: 355 CFM, GENERATOR RADIATOR AIR 3400 CFM, COMBUSTION AIR-130 CFM

GENERATOR EXHAUST SYSTEM:

PROVIDE 3 INCH STAINLESS STEEL EXHAUST SYSTEM WITH PIPE, FLEX CONNECTOR, WALL THIMBLE FOR WOOD
FRAME WALL, CLAMPS, FITTINGS, FASTENERS, HANGERS, RESIDENTIAL MUFFLER, FLAPPER,
WRAP EXHAUST WITH APPROVED BLANKET INSULATION. 3M 615-(1 WRAP) OR EQUAL

HOUSEKEEPING PAD: PROVIDE CONCRETE PAD AND DRIP PAN UNDER SKID.

UH-1: UNIT HEATER. 10 KW, 208 V, 3 PH. HANGING UNIT HEATER WITH PROPELLOR FAN
EXPLOSION PROOF UNIT WITH BUILT IN SPACE THERMOSTAT. PROVIDE CEILING MOUNTING KIT
MFG: Q MARK GUX1000832 WITH SPACE T STAT. 29.2 AMPS, 840 CFM

UH-2: UNIT HEATER. 3 KW, 208/240 V, 1 PH. HANGING UNIT HEATER WITH PROPELLOR FAN
PROVIDE WALL MOUNTING KIT, AND LOW VOLTAGE WALL THERMOSTAT.
MFG: Q MARK MUH 0321 11/12.5 AMPS, 350 CFM

SEQUENCE OF OPERATION: GENERATOR OPERATION


MD-1, MD-2, MD-3 OPERATION: OFF POSITION: MD-1 IS CLOSED, MD-2 IS FULL OPEN, MD-3 IS FULL CLOSED
GENERATOR IS STARTED: MD-1 OPENS, MD-2 BYPASSES AIR TO ROOM AND BEGINS TO MODULATE CLOSED
WHILE MD-3 BEGINS TO OPEN. DAMPER MOTOR MODULATES TO ALLOW GENERATOR RADIATOR AIR TO HEAT ROOM
ROOM SET POINT: 75 F. ON GENERATOR SHUT DOWN SYSTEM RETURNS TO OFF POSITION

SEQUENCE OF OPERATION: UNIT HEATERS UH-1, UH-2

UH-1 CYCLES ON BUILT IN THERMOSTAT: SET 50 F

UH-2 CYCLES ON ROOM THERMOSTAT: SET 55 F

03-23-2011 REVISE DUCT
WORK, MD-4, SEQUENCE OF
OPERATION

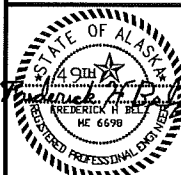

JAN 10, 2011

MECHANICAL DETAILS AND INSERTS
TULUKSAK LIFT STATION
TULAKSAK, ALASKA

DATE: JAN 10, 2011
DRAWN: F.H. BELZ
CHKD:
SCALE: AS NOTED
REVISED: MARCH 23, 2011
JOB NO. C378


SHEET NO.
M1-1 1 OF 3

CAPSTONE ENGINEERING LLC
MECHANICAL ENGINEERS
12110 BUSINESS BLVD STE 6 PMB 169
EAGLE RIVER, ALASKA 99577
TELEPHONE & FAX 541-884-9065

G:\ACAD\TULUKSAK\T0901 2008 Waste water disposal area\JFC Rev Jan 2011\M1-3 Mechanical Fred Beltz.dwg, 10/14/2011 4:36:50 PM, cmezz, \\c2main\LANIER MP C2050\LD520C PCL 6

BACK-UP GLYCOL HEAT TRACE NOTES:

1. THE BACK-UP HEAT TRACE SYSTEM IS DESIGNED TO MAINTAIN FORCEMAIN TEMPERATURE IN THE EVENT THAT THE TEMPERATURE OF THE WASTEWATER IS INADEQUATE TO PREVENT FREEZING
2. HEAT TRANSFER FLUID WILL BE A 50/50 INHIBITED PROPYLENE GLYCOL / WATER MIX, WHICH WILL ALLOW FLUID FLOW TO -30°F AND FREEZE PROTECTION OF THE GLYCOL TO -60°F.

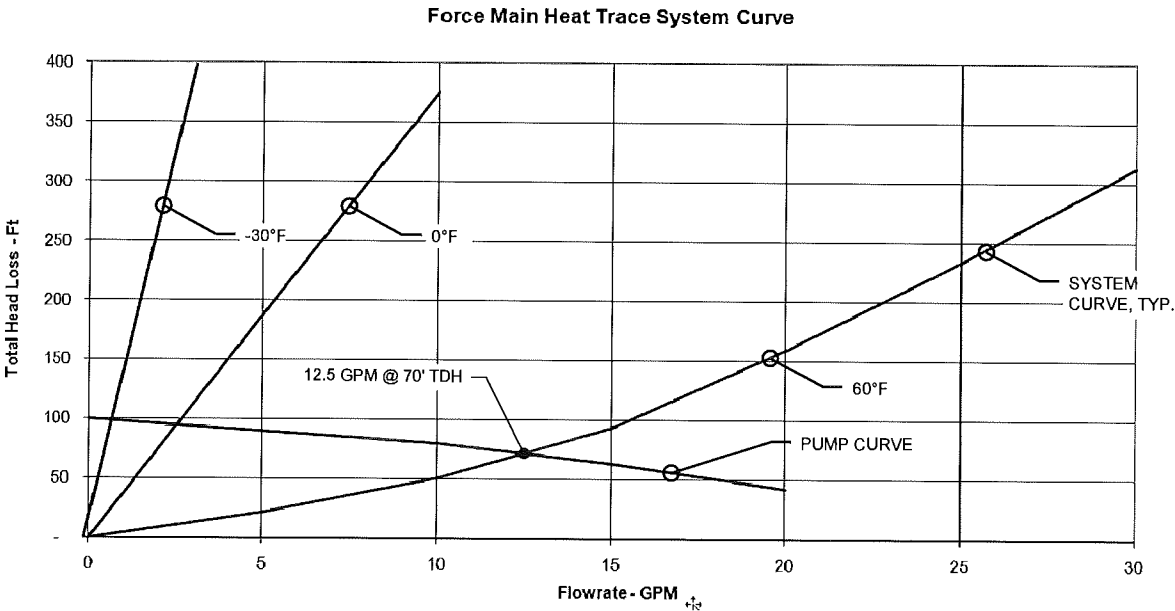


FORCEMAIN BACKUP HEAT TRACE SYSTEM CURVE

BACKUP GLYCOL HEAT TRACE FOR FORCEMAIN SYSTEM
EQUIVALENT LOOP LENGTH WITH FITTINGS: 7,600 LF
PIPE: 2" SDR 11 HDPE
PUMP: G&L #1SVC-2 STAGE VERTICAL SS CENTRIFUGAL
MODEL# 1SVB1C9B0
TAG# CP-1A AND 1B

TOTAL FORCEMAIN HEAT DEMAND = 21,600 Btu/Hr

1 GLYCOL CIRC. PUMP CURVE
M1-3 NTS

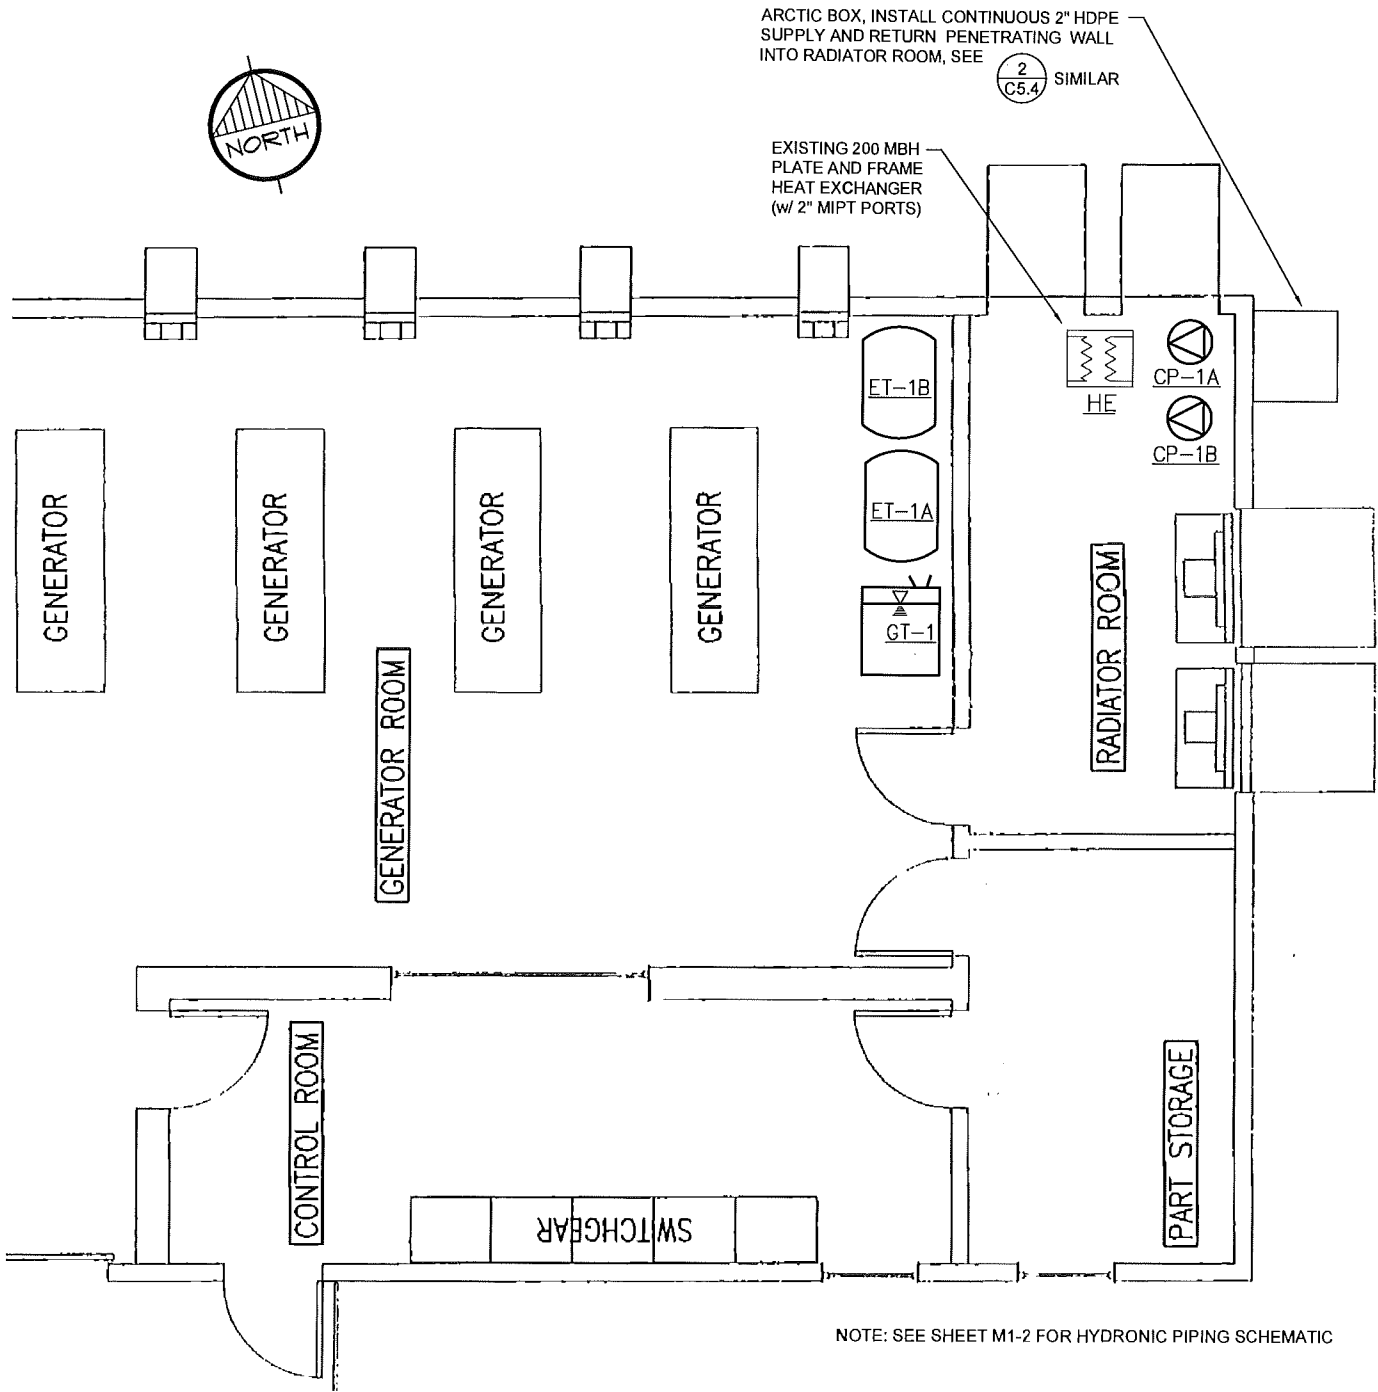

2 POWER PLANT MECH. PLAN
M1-3 NTS

CAPSTONE ENGINEERING LLC
MECHANICAL ENGINEERS
12110 BUSINESS BLVD. STE. 6, RM. 169
EAGLE RIVER, ALASKA 99577
TELEPHONE & FAX 947-884-8065



MECHANICAL DETAILS AND INSERTS
TULUKSAK LIFT STATION
TULAKSAK, ALASKA

DATE: JAN 10, 2011
DRAWN: F.H. BELZ
CHKD: AS NOTED
REVISD: C378
JOB NO.

SHEET NO.
M1-3 3 OF 3

ELECTRICAL LEGEND

(NOTE: THIS IS A STANDARD LEGEND AND NOT ALL SYMBOLS ARE NECESSARILY USED.)

	EXTERIOR LIGHT FIXTURE, POLE MOUNTED, HEADS AS SHOWN
	HAND HOLE
	ELECTRIC VAULT
	PHOTOCELL CONTROL
	LUMINAIRE - TYPE AS NOTED ON PLAN
	LUMINAIRE - WALL MOUNTED: TYPE AS NOTED ON PLAN
	LUMINAIRE - EMERGENCY LIGHT
	TRACK LIGHTING - TRACK LENGTH AS SCALED: TYPE AS NOTED ON PLAN
	EMERGENCY LIGHTING UNIT (WALL; CEILING; REMOTE HEAD): TYPE "E", UON
	EMERGENCY BATTERY TO POWER REMOTE HEAD(S); TYPE "ERB", UON
	EXIT SIGN (CEILING; WALL); SHADE DENOTES FACE; ARROWS AS INDICATED; TYPE "X", UON
	SWITCH - SINGLE POLE, SINGLE THROW, UON
	SWITCH - THREE WAY
	SWITCH - FOUR WAY
	SWITCH CONTROL FOR FIXTURES DENOTED WITH "a" APPENDED TO CIRCUIT NUMBER
	SWITCH - LOW VOLTAGE
	SWITCH - ELECTRONIC DIMMER SWITCH COMPATIBLE WITH LIGHT FIXTURE
	SWITCH - KEYED
	SWITCH - PILOT LIGHT
	SWITCH - INTEGRAL MOTOR OVERLOAD
	SWITCH - VARIABLE SPEED CONTROL
	LIGHT CONTROL OCCUPANCY SENSOR - WALL SWITCH BOX MOUNTED
	LIGHT CONTROL OCCUPANCY SENSOR - CEILING MOUNTED
	POWER DISTRIBUTION PANELBOARD
	METERING DEVICE
	CURRENT TRANSFORMER ENCLOSURE
	POWER PANELBOARD ([NEW - SURFACE; RECESSED], [EXISTING - SURFACE; RECESSED])
	TRANSFORMER: APPROX. PHYSICAL SIZE AS SCALED; ACTUAL RATING AS NOTED ON ONE-LINE DIAGRAMS
	MOTOR CONNECTION
	COMBINATION BATHROOM FAN/LIGHT: TYPE AS NOTED ON PLAN
	NON-FUSED SAFETY SWITCH
	FUSED SAFETY SWITCH
	ENCLOSED CIRCUIT BREAKER SWITCH
	MOTOR STARTER
	COMBINATION MOTOR STARTER SAFETY SWITCH
	PUSH BUTTON CONTROL STATION
	JUNCTION BOX OR EQUIPMENT CONNECTION - FLEX OR RECEPTACLE AS REQUIRED (CEILING; WALL; FLOOR)
	POWER CONNECTION TO FSD CONTROLLED BY FIRE ALARM SYSTEM
	SIMPLEX RECEPTACLE
	DUPLEX RECEPTACLE
	DOUBLE DUPLEX RECEPTACLE
	DUPLEX RECEPTACLE - SPLIT WIRED FOR SWITCH CONTROL OF LOWER OUTLET
	DUPLEX RECEPTACLE - GFCI PROTECTED
	DUPLEX RECEPTACLE - GFCI PROTECTED MOUNTED +48" AFF
	DUPLEX RECEPTACLE - GFCI PROTECTED MOUNTED ABOVE COUNTERTOP
	DUPLEX RECEPTACLE - MOUNTED ABOVE COUNTERTOP
	DUPLEX RECEPTACLE - FLOOR MOUNTED FIRE RATED POKE THROUGH, UON
	DOUBLE DUPLEX RECEPTACLE - FLOOR MOUNTED FIRE RATED POKE THROUGH, UON
	RECEPTACLE - PENDANT MOUNTED FROM CEILING
	RECEPTACLE - FLUSH MOUNTED IN CEILING
	DRYER RECEPTACLE - 30A, 3 POLE, 4 WIRE NEMA 14-30R
	ELECTRIC RANGE RECEPTACLE - 50A, 3 POLE, 4 WIRE, NEMA 14-50R
	SPECIAL PURPOSE RECEPTACLE - NEMA CONFIGURATION AS NOTED (SURFACE; WALL)
	GROUND CONNECTION POINT
	DUAL CHANNEL SURFACE MOUNTED RACEWAY - LENGTH AS SCALED
	SINGLE CHANNEL SURFACE MOUNTED RACEWAY - LENGTH AS SCALED
	TELECOMMUNICATION OUTLET (WALL; FLOOR)
	TELEPHONE OUTLET
	TELEVISION OUTLET (WALL; CEILING)
	DUAL CHANNEL SERVICE POLE
	TELECOMMUNICATION FLOOR STANDING RACK
	TELECOMMUNICATION WALL MOUNTED RACK
	TELECOMMUNICATION MAIN GROUNDING BUS
	TELECOMMUNICATION GROUNDING BUS
	CONTROL PANEL - TYPE AS NOTED (SURFACE; RECESSED)

	FIRE ALARM CONTROLLED MAGNETIC DOOR HOLDER / RELEASE
	ABORT STATION
	CARBON MONOXIDE DETECTOR
	HEAT DETECTOR - RATE OF RISE
	HEAT DETECTOR - FIXED TEMPERATURE AS NOTED
	SMOKE DETECTOR - PHOTOELECTRIC TYPE
	SMOKE DETECTOR - MULTI-SENSOR TECHNOLOGY TYPE
	SMOKE DETECTOR - DUCT MOUNTED
	SMOKE DETECTOR - BEAM RECEIVER
	SMOKE DETECTOR - BEAM TRANSMITTER
	FLAME DETECTOR
	LINE TYPE HEAT SENSITIVE CABLE DETECTOR
	FIRE ALARM HORN
	FIRE ALARM STROBE
	FIRE ALARM COMBINATION HORN/STROBE
	FIRE ALARM PULL STATION
	FIRE ALARM CONTROL PANEL
	FIRE SYSTEM ANNUNCIATOR PANEL
	HALON CONTROL PANEL
	FIRE ALARM SPEAKER STROBE
	WATER FLOW BELL - 120V CONTROLLED BY FLOW SWITCH
	FIRE ALARM FLOW SWITCH
	FIRE ALARM TAMPER SWITCH
	MICROPHONE INPUT JACK
	MICROPHONE INPUT JACK - FLOOR MOUNTED
	INTERCOM CALL BUTTON
	INTERCOM ADMINISTRATION PHONE
	SPEAKER (WALL; CEILING)
	CLOCK SPEAKER COMBINATION WALL MOUNT UNIT
	CLOCK - WALL MOUNTED
	SECURITY ACCESS CARD READER
	DOOR CONTROL SOLENOID
	DOOR MAGNETIC CONTACT
	SECURITY SYSTEM - GLASS BREAK SENSOR
	SECURITY SYSTEM - MOTION SENSOR
	SECURITY SYSTEM - DOOR POSITION SENSOR
	SECURITY SYSTEM - REQUEST TO EXIT MOTION DETECTOR
	SECURITY SYSTEM - ACCESS KEY PAD
	SECURITY SYSTEM - MOTION SENSOR - NARROW PATTERN
	SECURITY SYSTEM - CAMERA
	ACCESS PANEL
	LINETYPE DENOTING CABLE TRAY
	LINETYPE/LINEWEIGHT DENOTING FUTURE WORK
	LINETYPE/LINEWEIGHT DENOTING EXISTING WORK TO REMAIN
	LINETYPE/LINEWEIGHT DENOTING NEW WORK
	LINETYPE/LINEWEIGHT DENOTING DEMO WORK
	DENOTES AVAILABLE FAULT CURRENT

EQUIPMENT TAG LEGEND

LUMINAIRES		LUMINAIRE TYPE (UNDERLINED) THE NUMBER IN BRACKETS INDICATES HOW MANY TYPICAL LUMINAIRES OF THIS TYPE ARE IN THIS AREA CIRCUIT AND SWITCHLEG PANEL TYPICAL LUMINAIRE
CONTROL SWITCHES		LOWER CASE LETTER DENOTES SWITCH LEG FOR CORRESPONDING LUMINAIRE CONTROL UPPERCASE LETTER OR NUMBER DENOTES SWITCH CONFIGURATION
EQUIPMENT CONNECTIONS		EQUIPMENT ID (UNDERLINED) REFER TO EQUIPMENT CONNECTION SCHEDULE FOR REQUIREMENTS TYPICAL EQUIPMENT (MOTOR STARTER SHOWN) CIRCUIT NUMBER(S) PANEL
RECEPTACLES		MOUNTING HEIGHT AFF PANEL CIRCUIT NUMBER(S) NEMA CONFIGURATION FOR SPECIAL RECEPTACLES (UNDERLINED)

ABBREVIATIONS

(E)	EXISTING
A	AMPERES
AC	ABOVE COUNTER
AFF	ABOVE FINISHED FLOOR
AFCI	ARC FAULT CIRCUIT INTERRUPTER
AFG	ABOVE FINISHED GRADE
AHJ	AUTHORITY HAVING JURISDICTION
AC	AMPS INTERRUPTING CAPACITY
C	CONDUIT OR CELCIUS
CAT	CATEGORY
CB	CIRCUIT BREAKER
CO	CONDUIT ONLY
CT	CURRENT TRANSFORMER
(D)	DEMOLISH
DISC	DISCONNECT
EGC	EQUIPMENT GROUNDING CONDUCTOR
F	FAHRENHEIT
FAA	FIRE ALARM ANNUNCIATOR
FACP	FIRE ALARM CONTROL PANEL
FHP	FRACTIONAL HORSEPOWER
FLA	FULL LOAD AMPS
FSD	FIRE SMOKE DAMPER
FT	FEET
FU	FUSE
G	GROUND FAULT CIRCUIT INTERRUPTER
GEC	GROUNDING ELECTRODE CONDUCTOR
HP	HORSEPOWER
ID	IDENTIFICATION
IN	INCHES
KVA	KILOVOLT-AMPERE
KW	KILOWATT
LRA	LOCKED ROTOR AMPS
LTG	LIGHTING
MCA	MINIMUM CIRCUIT AMPACITY
MDP	MAIN DISTRIBUTION PANEL
MDS	MAIN DISTRIBUTION SWITCHBOARD
MFS	MAXIMUM FUSE SIZE
(N)	NEW
NC	NORMALLY CLOSED
NO	NORMALLY OPEN
P	POLES
PC	PHOTO CELL
PH, Ø	PHASE
PHL	PANEL
PRI	PRIMARY
REC	RECEPTACLE
(R)	RELOCATED
RIB	RELAY IN A BOX (MOTOR RATED)
SCCR	SHORT CIRCUIT CURRENT RATING
SE	SERVICE ENTRANCE RATED
SEC	SECONDARY
SSEBJ	SUPPLY SIDE EQUIPMENT BONDING JUMPER
SVC	SERVICE
TELECOM	TELECOMMUNICATION
TGB	TELECOMMUNICATION GROUNDING BUSBAR
TMGB	TELECOMMUNICATION MAIN GROUNDING BUSBAR
TYP	TYPICAL
UON	UNLESS OTHERWISE NOTED
V	VOLTS
VA	VOLT-AMPERES
VFD	VARIABLE FREQUENCY DRIVE
W	WATTS OR WIRE
WG	WIRE GUARD
WP	WEATHERPROOF (NEMA 4 RATED)
XFMR	TRANSFORMER

MOUNTING HEIGHT SCHEDULE

PANELBOARDS (TOP)	+70"
SPECIAL SYSTEM PANELS (TOP)	+66"
POWER METER BASE (CENTER LINE OF SOCKET)	+66"
CONTACTORS, MOTOR STARTERS, DISCONNECT SWITCHES (TOP)	+66"
RECEPTACLES IN OFFICE AREAS	+18"
RECEPTACLES IN NON-FINISHED AND MECHANICAL SPACES	+46"
ABOVE COUNTER DEVICES (DENOTED "AC" OR BY SYMBOL)	SEE NOTES
WALL MOUNTED SWITCHES	+46"
TELECOMMUNICATION OUTLETS	+18"
WALL MOUNTED TELEPHONE OUTLET (DENOTED "W")	+54"
CLOCK OUTLETS	+80" TO BOTTOM
HORNS/STROBES/HORN STROBES/DOORBELL RINGER	+80" TO BOTTOM
PULL STATIONS, PUSH BUTTONS, DOORBELL PUSHBUTTON	+46"

NOTES:

- COORDINATE AND INSTALL ALL EQUIPMENT AND DEVICES WITH THE ARCHITECTURAL PLANS AND ANY SPECIFICALLY DENOTED REQUIREMENTS.
- MOUNTED HEIGHTS SHALL PREVAIL UNLESS OTHERWISE NOTED OR FIELD CONDITIONS REQUIRE DEVIATION.
- MOUNTING HEIGHTS ARE FROM FINISHED FLOOR TO THE CENTERLINE OF THE DEVICE UNLESS OTHERWISE NOTED.
- COORDINATE MOUNTING HEIGHTS AND LOCATIONS OF OUTLETS DENOTED AS ABOVE COUNTER TO BE INSTALLED 6" ABOVE COUNTERS OR BACKSPASHES, WHICHEVER IS HIGHER.

GENERAL REQUIREMENTS

- ALL ELECTRICAL WORK SHALL BE INSTALLED IN ACCORDANCE WITH ALL REQUIREMENTS OF THE LATEST EDITION OF THE NATIONAL ELECTRIC CODE, STATE, MUNICIPAL, AND FEDERAL LAWS, AMENDMENTS AND/OR ORDINANCES GOVERNING THE PROJECT. IF IN ANY INSTANCE THE PLANS AND SPECIFICATIONS ARE IN DIRECT CONFLICT WITH SUCH CODES, LAWS, AND/OR ORDINANCES, THE CODE, LAWS, AND/OR ORDINANCES SHALL HAVE JURISDICTION AND THE WORK IN QUESTION SHALL BE INSTALLED ACCORDING TO THE CODES, LAWS, AND/OR ORDINANCES. ALL WORK SHALL BE PERFORMED UNDER THE SUPERVISION OF A CERTIFIED ELECTRICIAN.
- THE CONTRACTOR SHALL OBTAIN ALL REQUIRED CONSTRUCTION PERMITS AND PAY ALL ASSOCIATED FEES.
- MATERIALS AND EQUIPMENT SHALL BE COMMERCIAL GRADE AND ACCEPTABLE TO THE AUTHORITY HAVING JURISDICTION AS SUITABLE FOR THE USE INTENDED. ALL ELECTRICAL EQUIPMENT SHALL INCLUDE THE SEAL OF A NATIONALLY RECOGNIZED TESTING LABORATORY FOR THE PURPOSE FOR WHICH IT IS INSTALLED. WHENEVER POSSIBLE, SIMILAR ITEMS SHALL BE SUPPLIED BY THE SAME MANUFACTURER THROUGHOUT THE PROJECT.
- COORDINATE AND PROVIDE THE EQUIPMENT WITH THE SHORT CIRCUIT CURRENT RATING (SCCR) FOR THE AVAILABLE FAULT CURRENT AT THE POINT OF THE SYSTEM WHERE INSTALLED. SERIES RATING OF EQUIPMENT IS ACCEPTABLE. PROVIDE ARC FAULT WARNING LABELS ON ALL PANELBOARDS, MCC UNITS AND SIMILAR EQUIPMENT PER NEC REQUIREMENTS.
- THE FOLLOWING WIRING METHODS SHALL BE ACCEPTABLE FOR INSTALLATION OF ELECTRICAL CIRCUITS: TYPE MC CABLE, INTERMEDIATE METAL CONDUIT, RIGID METAL CONDUIT, RIGID NONMETALLIC CONDUIT (FOR UNDERGROUND USE ONLY), ELECTRICAL METALLIC TUBING, FLEXIBLE METALLIC TUBING, FLEXIBLE METAL CONDUIT, AND LIQUID TIGHT FLEXIBLE CONDUIT. ALL WIRING METHODS SHALL INCLUDE AN EQUIPMENT GROUNDING CONDUCTOR TO BE INSTALLED THEREIN AND SIZED FOR THE CIRCUITS SERVED.
- ALL CONDUCTORS SHALL BE COPPER. ALL CONDUCTORS IN UNHEATED SPACES OF THE BUILDING OR LOCATED OUTSIDE OF THE BUILDING ARE REQUIRED TO HAVE TYPE XHHW 90 DEGREE C INSULATION. ALL CONDUCTORS LOCATED IN HEATED SPACES CAN BE XHHW OR THHN 90 DEGREE C INSULATION UNLESS NOTED OTHERWISE. CONDUCTOR AMPACITY SHALL BE BASED ON TABLE 310-16 OF THE NEC. USE 60-DEGREE C. RATING FOR CIRCUITS TERMINATING ON DEVICES RATED BELOW 100A. USE 75-DEGREE C RATING FOR CIRCUITS TERMINATING ON DEVICES AND IN ENCLOSURES RATED 100A AND OVER. DERATE CONDUCTORS PER NEC REQUIREMENTS.
- CONCEAL ALL ELECTRICAL RACEWAYS, BOXES, CABLING, CONDUCTORS AND THE LIKE IN WALLS, BELOW FLOORS, SLABS OR ABOVE FINISHED CEILING SPACES. ELECTRICAL EQUIPMENT AND WIRING CAN BE EXPOSED IN MECHANICAL ROOMS, TELECOMMUNICATION ROOMS OR WHERE SPECIFICALLY NOTED.
- DO NOT ROUTE RACEWAYS ON THE EXTERIOR SURFACE OF THE BUILDING OR THE ROOF UNLESS SPECIFICALLY NOTED OTHERWISE.
- PROVIDE ALL WIRING AND EQUIPMENT IN WET AND EXTERIOR LOCATIONS USING EQUIPMENT AND WIRING METHODS RATED FOR WET ENVIRONMENTS.
- ALL CABLING LOCATED IN CEILING SPACES THAT ARE PLENUMS SHALL BE PLENUM RATED.
- PROVIDE ACCESS PANELS FOR ALL LOCATION NECESSARY TO ACCESS ELECTRICAL EQUIPMENT AND JUNCTION BOXES. ACCESS PANELS SHALL BE FIRE RATED EQUAL TO OR EXCEEDING THE ADJACENT WALL OR CEILING CONSTRUCTION AND PAINTED TO MATCH.
- CONNECT ALL EMERGENCY LIGHTING UNITS AND MODULES TO THE LOCAL AREA LIGHTING CIRCUITS AHEAD OF ANY SWITCHES OR RELAYS. LOCATE REMOTE TEST SWITCHES AND INDICATOR LIGHTS AS NECESSARY FOR TEST SWITCHES ON EMERGENCY MODULES.
- SEAL ALL PENETRATIONS. SEAL PENETRATIONS AT ALL FIRE WALLS WITH APPROVED FIRE STOPPING COMPOUND.
- OUTLET BOXES LOCATED BACK TO BACK IN FIRE RATED WALLS SHALL BE SPACED A MINIMUM OF 2 FEET HORIZONTALLY OR PROVIDE AN APPROVED FIRE PROTECTIVE MATERIAL PLACED ON OR AROUND THEM LISTED FOR THE FIRE RATING OF THE WALL.
- CONTRACTOR SHALL SUBMIT REQUEST FOR SUBSTITUTION IN WRITING TO THE ENGINEER.
- PROVIDE SEISMIC SUPPORT AND DESIGN PER IBC REQUIREMENTS.
- THE ELECTRICAL CONTRACTOR SHALL CONTACT EACH SERVING UTILITY CO. AND VERIFY EXACT SERVICE REQUIREMENTS FOR POWER AND TELEPHONE. THE CONTRACTOR SHALL COORDINATE AND PROVIDE ALL REQUIREMENTS OF EACH SERVING UTILITY AND ALL EQUIPMENT SHALL CONFORM TO THE SERVING UTILITY STANDARDS AND REQUIREMENTS.

ELECTRICAL SHEET LIST

E1.1	ELECTRICAL LEGEND & SCHEDULES
E2.1	ELECTRICAL SITE PLAN
E3.1	ELECTRICAL NEC CLASSIFIED BOUNDARY DETAILS
E4.1	ELECTRICAL CELL TRANSFER MANHOLE PLANS
E4.2	ELECTRICAL POWER PLANT PLANS
E5.1	ELECTRICAL LIFT STATION PLANS
E5.2	ELECTRICAL LIFT STATION PLANS
E6.1	ELECTRICAL LIFT STATION DIAGRAMS & PANEL SCHEDULES
E6.2	ELECTRICAL LIFT STATION CONTROLS
E6.3	ELECTRICAL POWER PLANT CONTROLS & DIAGRAMS

EIC ENGINEERS, INC
ELECTRICAL ENGINEERS



6927 OLD SEWARD HWY, SUITE 200
ANCHORAGE, AK 99518
T 907.349.9712
F 907.349.9713
www.eiceng.com

RECORD DRAWING CERTIFICATE

THESE DRAWINGS REFLECT RECORDED INFORMATION OBTAINED DURING CONSTRUCTION. INFORMATION PROVIDED HEREIN IS ACCURATE TO THE BEST OF MY KNOWLEDGE.

NAME _____ DATE _____

SCALE:

1" = 10'-0"

IF NOT ONE INCH ON ORIGINAL DRAWING, SCALES ACCORDINGLY



2009 WASTEWATER SYSTEM IMPROVEMENTS

ELECTRICAL LEGEND & SCHEDULES

TULUKSAK, ALASKA




REVISION	BY	DATE

Project No. _____ Date _____ BLS _____

Designed _____ Drawn _____ EDC _____

Approved _____

Sheet No. E1.1

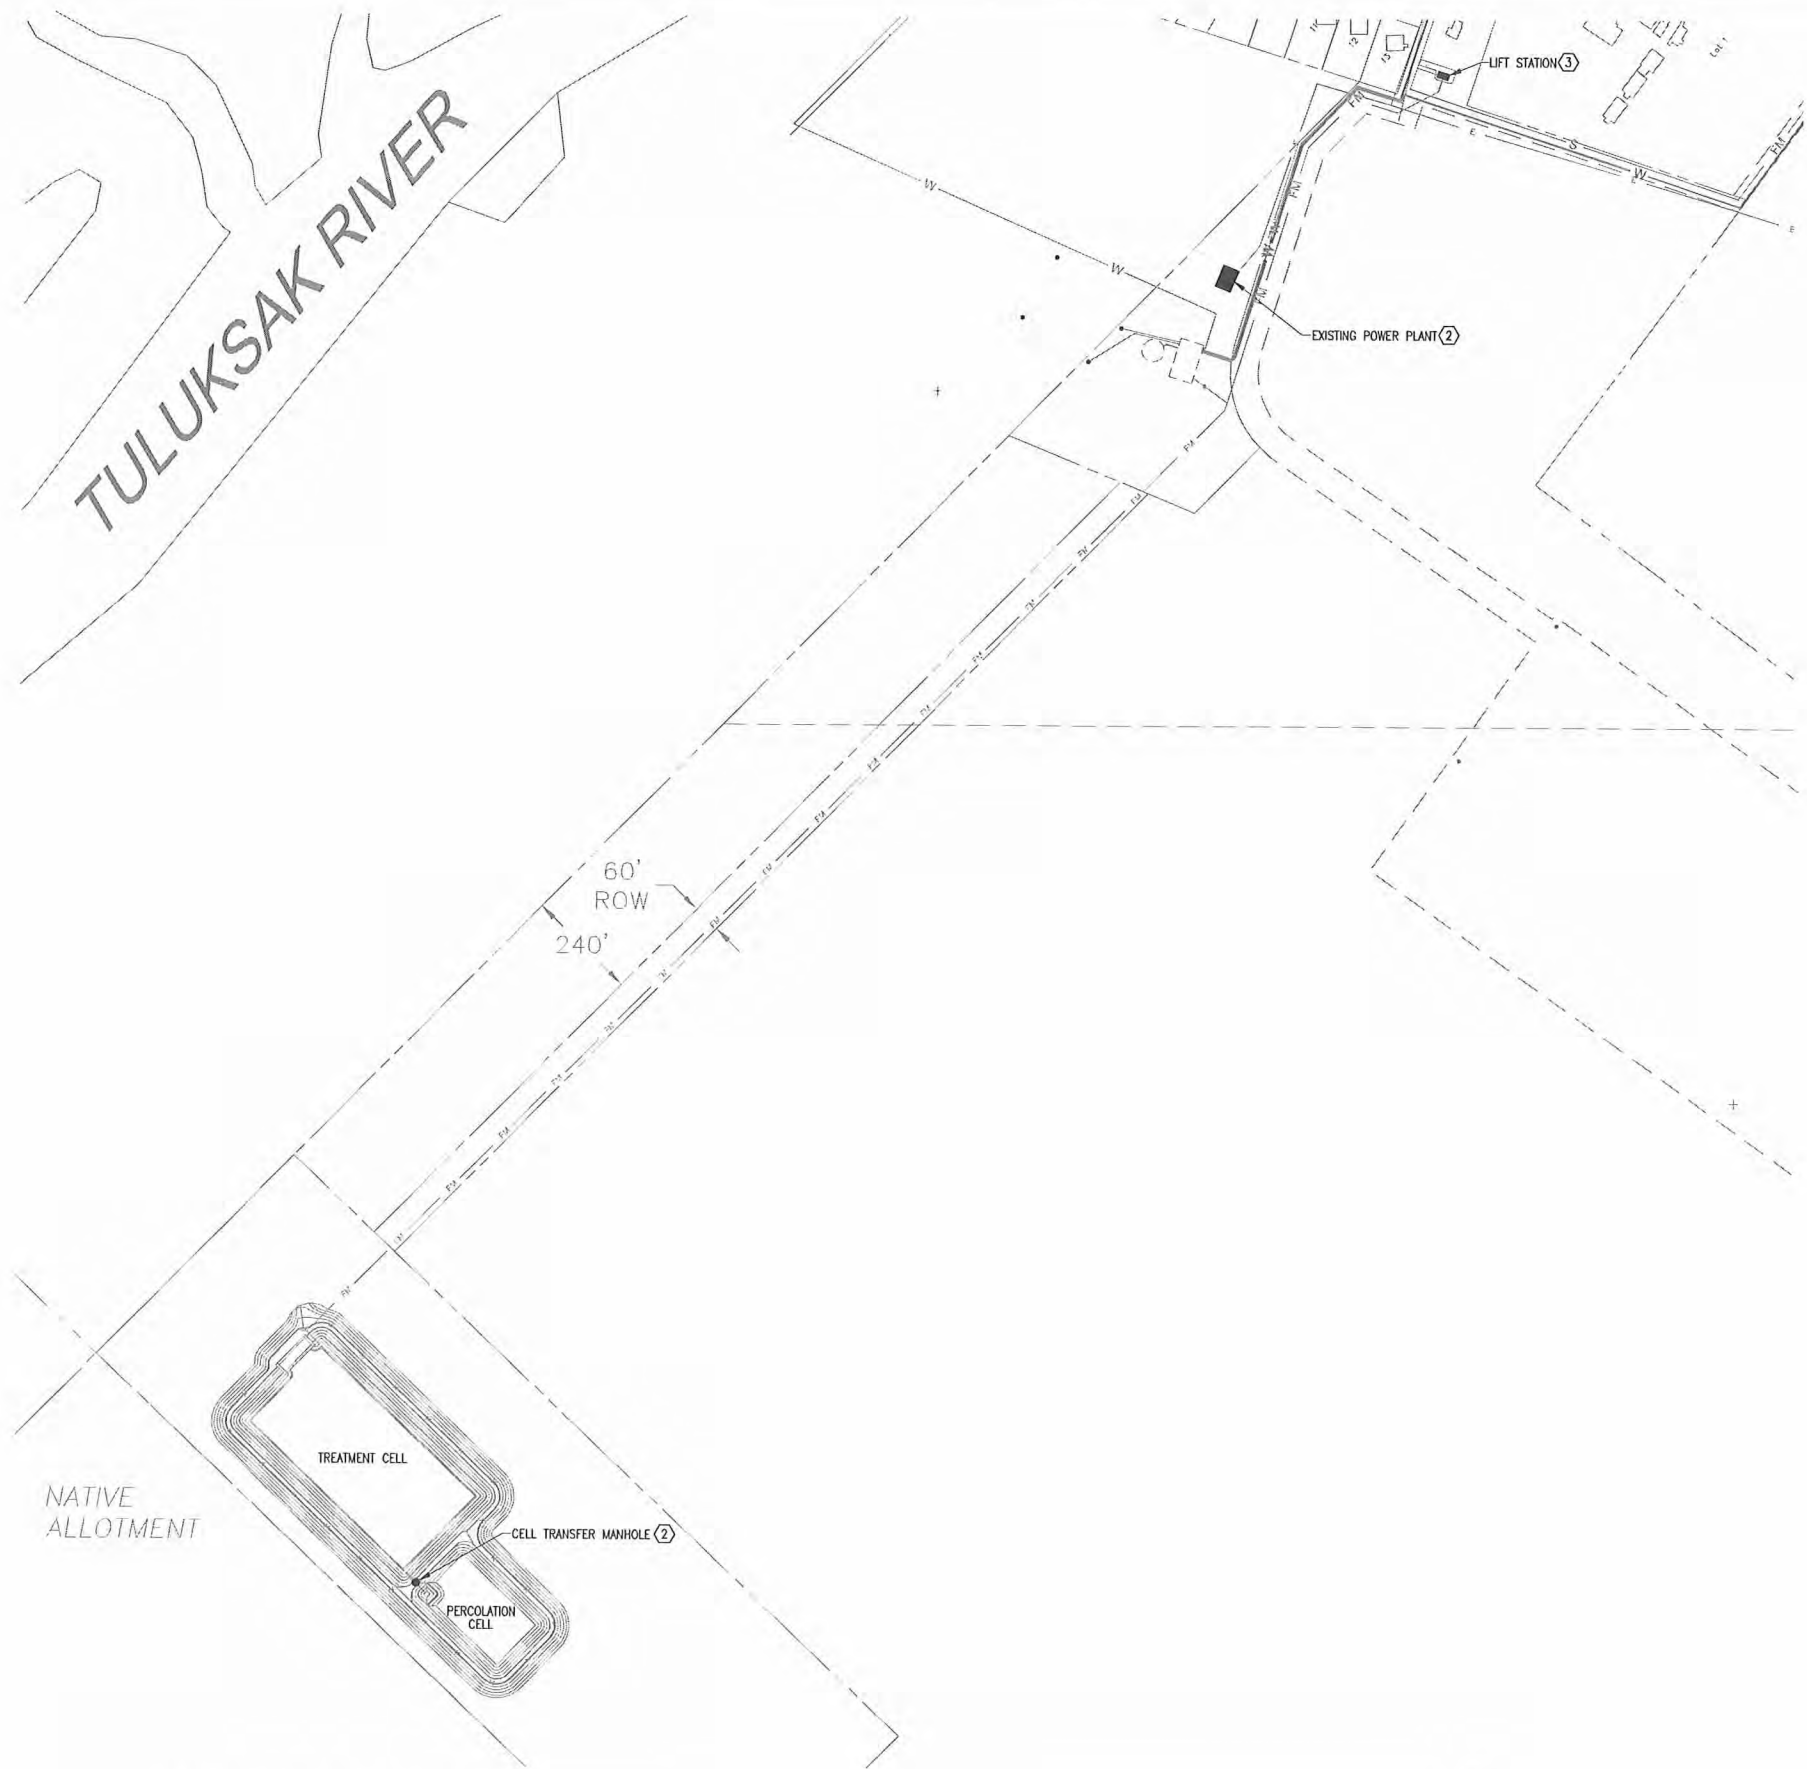

- SHEET NOTES**
- ① CONTRACTOR TO PROVIDE PORTABLE GENERATOR POWER CONNECTION AND SEWER PIPE HEAT TRACE AT NEW CELL TRANSFER MANHOLE LOCATION. SEE E4.1 FOR DETAIL.
 - ② CONTRACTOR TO PROVIDE NEW BRANCH CIRCUITS IN EXISTING POWER PLANT FOR HEAT LOOP PUMP CONTROL PANEL AND CIRCULATION PUMPS. SEE 1/E4.2 FOR DETAIL.
 - ③ CONTRACTOR TO PROVIDE ELECTRICAL INSTALLATIONS IN NEW LIFT STATION. SEE E5.1, E5.2, AND E6.1 FOR DETAIL.

1 ELECTRICAL SITE PLAN
E2.1 SCALE: 1" = 200'-0"





EIC ENGINEERS, INC
ELECTRICAL ENGINEERS

6927 OLD SEWARD HWY, SUITE 200
ANCHORAGE, AK 99518
T 907.349.9712
F 907.349.9713
www.eiceng.com

Project No. _____
Date JAN 2011
Designed BLS
Drawn BLS
Approved EDC

REVISION	BY	DATE

2009 WASTEWATER
SYSTEM IMPROVEMENTS
ELECTRICAL
SITE PLAN

TULUKSAK, ALASKA




RECORD DRAWING CERTIFICATE


THESE DRAWINGS REFLECT RECORDED
INFORMATION OBTAINED DURING
CONSTRUCTION. INFORMATION PROVIDED
HEREIN IS ACCURATE TO THE BEST OF MY
KNOWLEDGE.

SCALE:
AS SHOWN
ORIGINAL DRAWING
IF NOT ONE NOTION
SCALE ACCORDINGLY

NAME
DATE

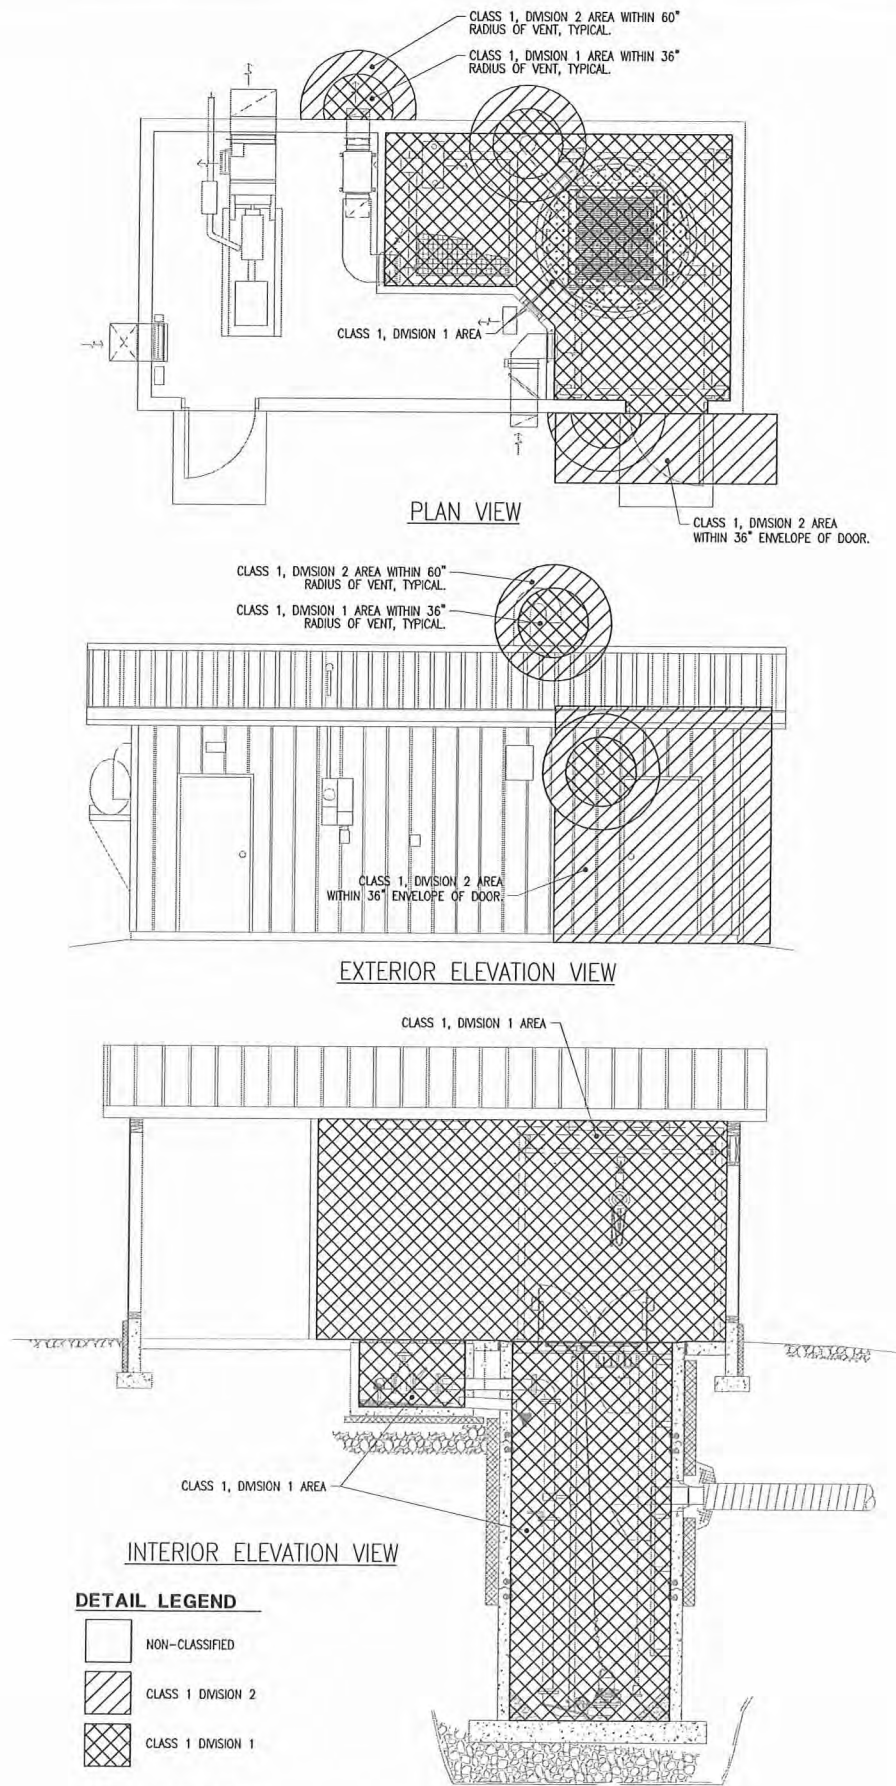

1
E3.1
**LIFT STATION
NEC CLASSIFIED BOUNDARY DETAIL**
SCALE: 1/4" = 1'-0"

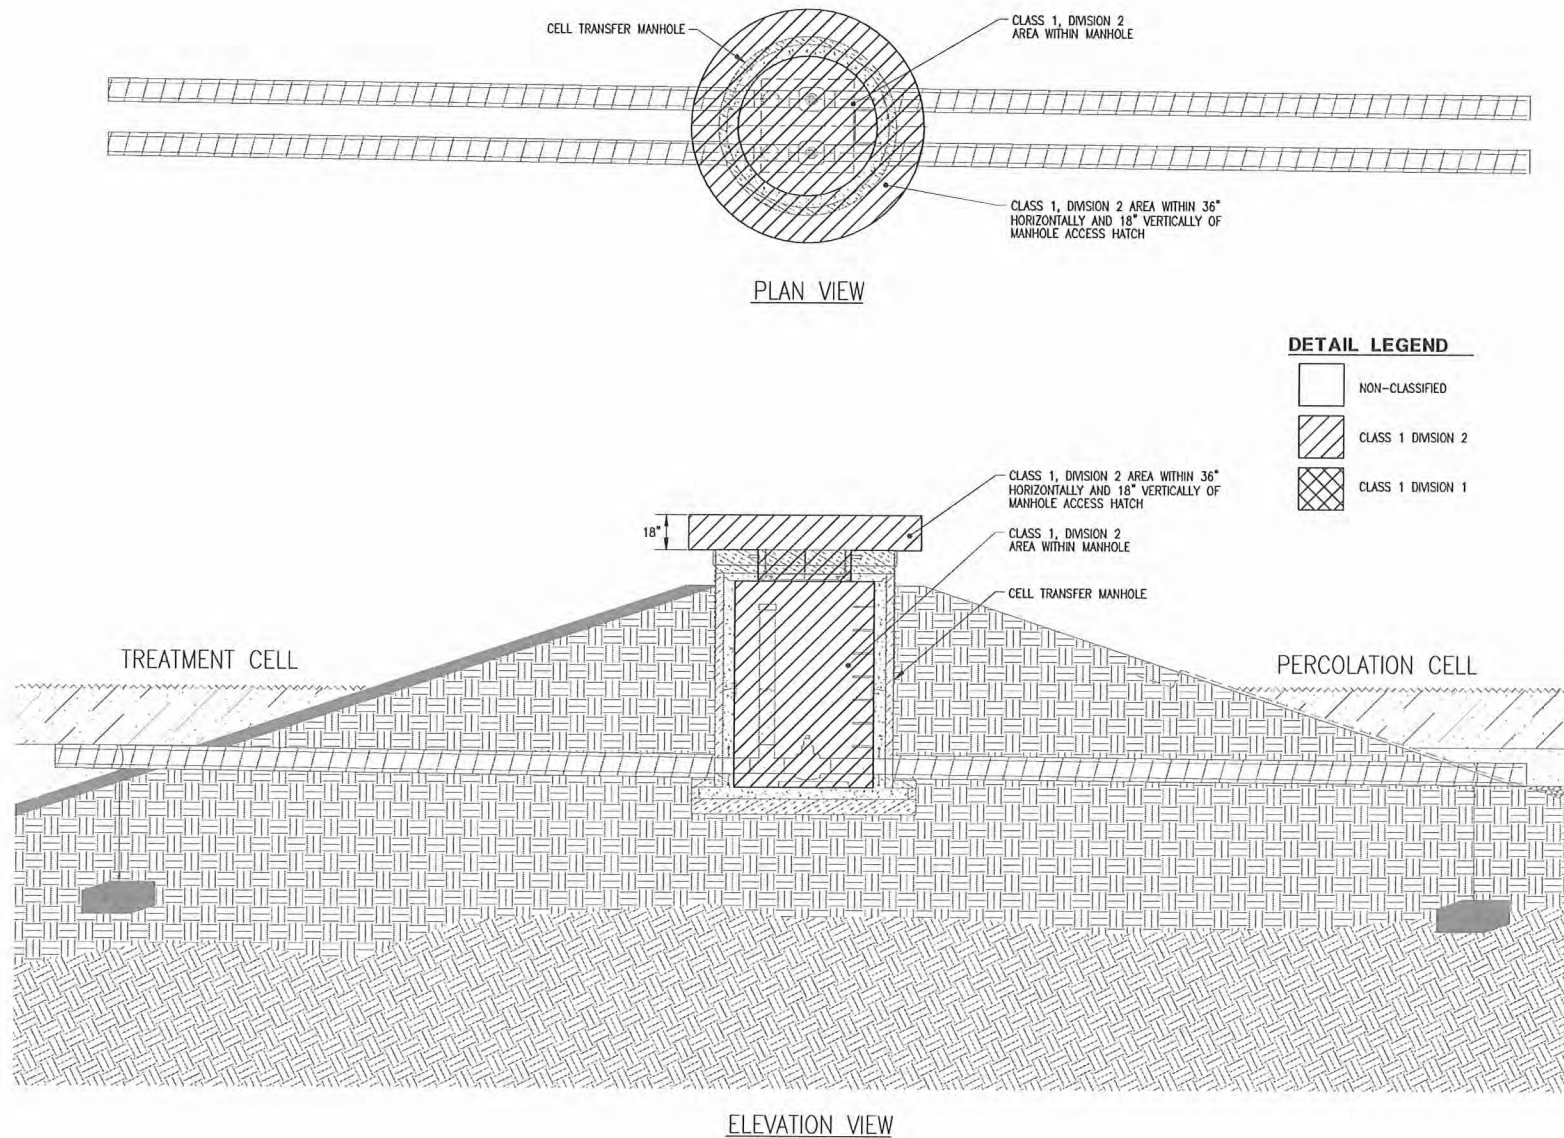

2
E3.1
**CELL TRANSFER MANHOLE
NEC CLASSIFIED BOUNDARY DETAIL**
SCALE: 1/4" = 1'-0"



EIC ENGINEERS, INC
ELECTRICAL ENGINEERS

6927 OLD SEWARD HWY, SUITE 200
ANCHORAGE, AK 99518
T 907.349.9712
F 907.349.9713
www.elceng.com

BIC JOB #E10-1323

RECORD DRAWING CERTIFICATE

THESE DRAWINGS REFLECT RECORDED INFORMATION OBTAINED DURING CONSTRUCTION. INFORMATION PROVIDED HEREIN IS ACCURATE TO THE BEST OF MY KNOWLEDGE.

NAME _____ DATE _____

SCALE:

BASED ON ONE INCH ON ORIGINAL DRAWING

IF NOT ONE INCH ON THIS SHEET, ADJUST SCALES ACCORDINGLY

2009 WASTEWATER
SYSTEM IMPROVEMENTS
ELECTRICAL
NEC CLASSIFIED
BOUNDARY PLANS

TULUKSAK, ALASKA

BY DATE

REVISION					
----------	--	--	--	--	--


Project No. _____ Date _____ JAN 2011

Designed BLS


Drawn BLS

Approved EDC

Sheet No. **E3.1**

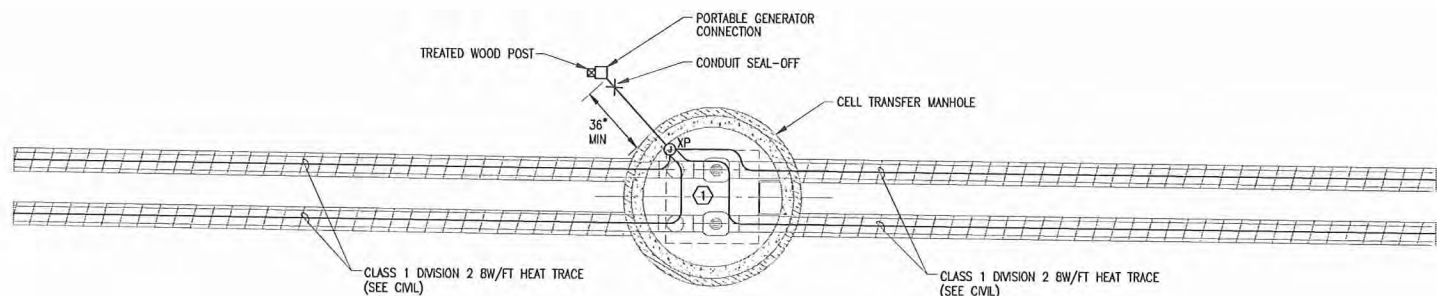


1 CELL TRANSFER MANHOLE ELECTRICAL PLAN
E4.1 SCALE: 1/4" = 1'-0"

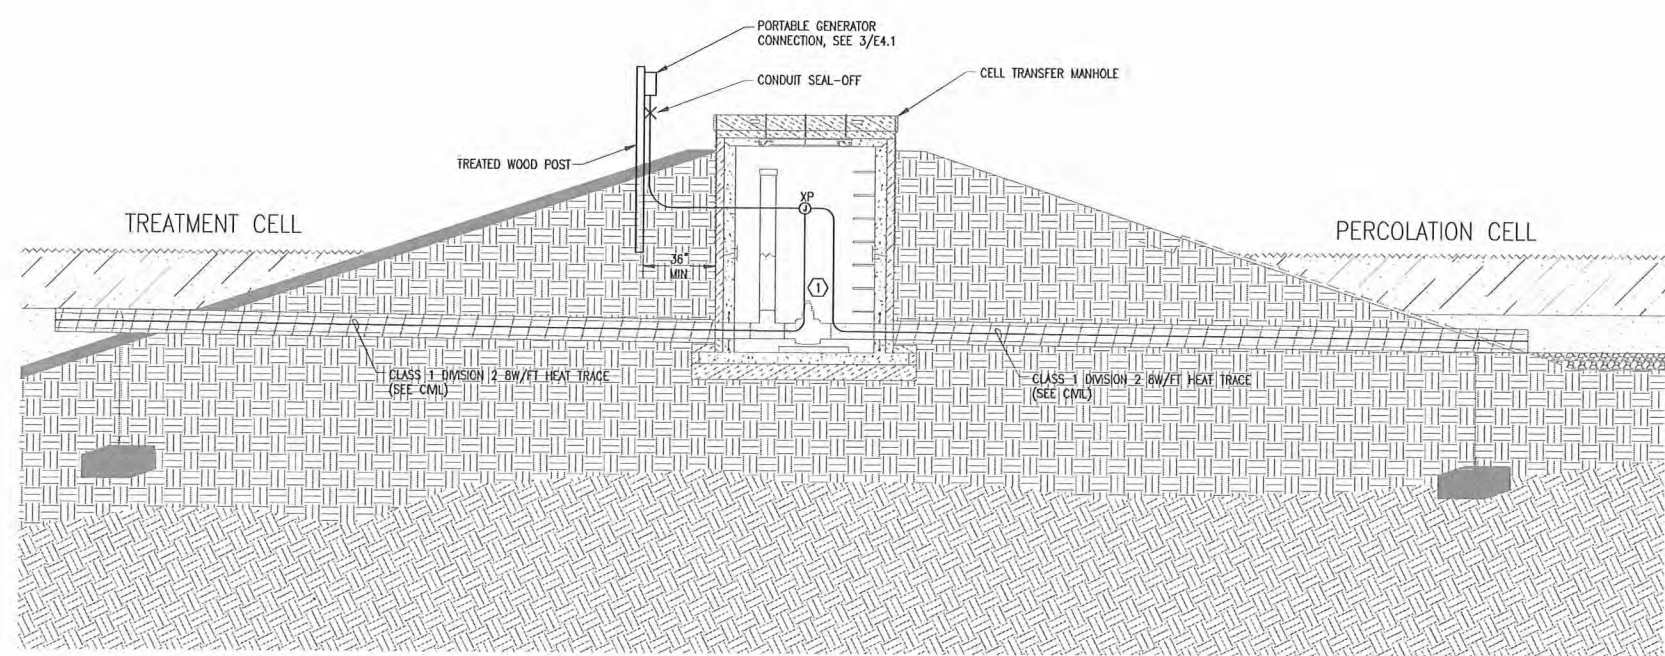

2 CELL TRANSFER MANHOLE ELEVATION
E4.1 SCALE: 1/4" = 1'-0"

SHEET NOTES
① WRAP EXPOSED PIPING AND VALVES IN MANHOLE WITH HEAT TRACE FOR FREEZE PROTECTION. PROVIDE AT LEAST 1 REVOLUTION PER FOOT ON EACH OF THE PIPES.

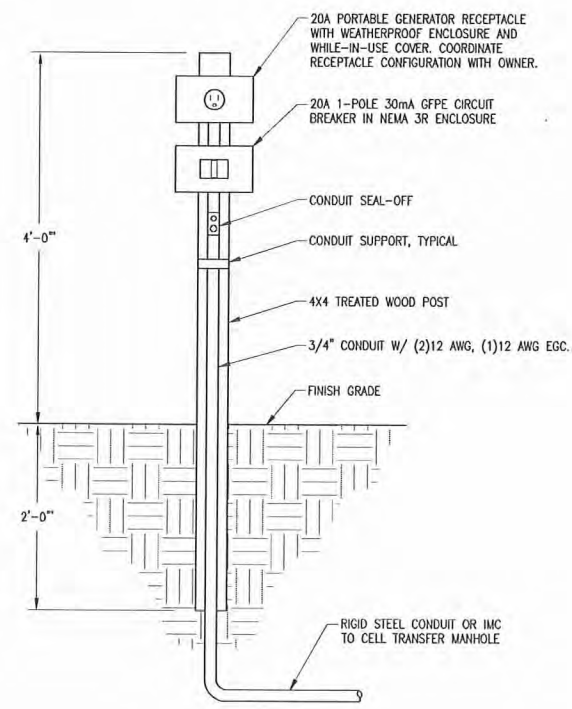

3 PORTABLE GENERATOR CONNECTION DETAIL
E4.1 SCALE: NONE

EIC ENGINEERS, INC
ELECTRICAL ENGINEERS

6927 OLD SEWARD HWY, SUITE 200
ANCHORAGE, AK 99518
T 907.349.9712
F 907.349.9713
www.eiceng.com

Project No. _____

Date JAN 2011

Designed BLS

Drawn BLS

Approved EDC

RECORD DRAWING CERTIFICATE

THESE DRAWINGS REFLECT RECORDED INFORMATION OBTAINED DURING CONSTRUCTION. INFORMATION PROVIDED HEREIN IS ACCURATE TO THE BEST OF MY KNOWLEDGE.

NAME _____ DATE _____

SCALE:

1" = 10'-0"

IF NOT SHOWN ON ORIGINAL DRAWING, SCALES ACCORDINGLY

2009 WASTEWATER SYSTEM IMPROVEMENTS


ELECTRICAL CELL TRANSFER MANHOLE PLANS

TULUKSAK, ALASKA

PO BOX 22964 ANCHORAGE, AK 99522 PH: 907-545-1010 FAX: 907-545-1015

REVISION	BY	DATE

Sheet No. **E4.1**

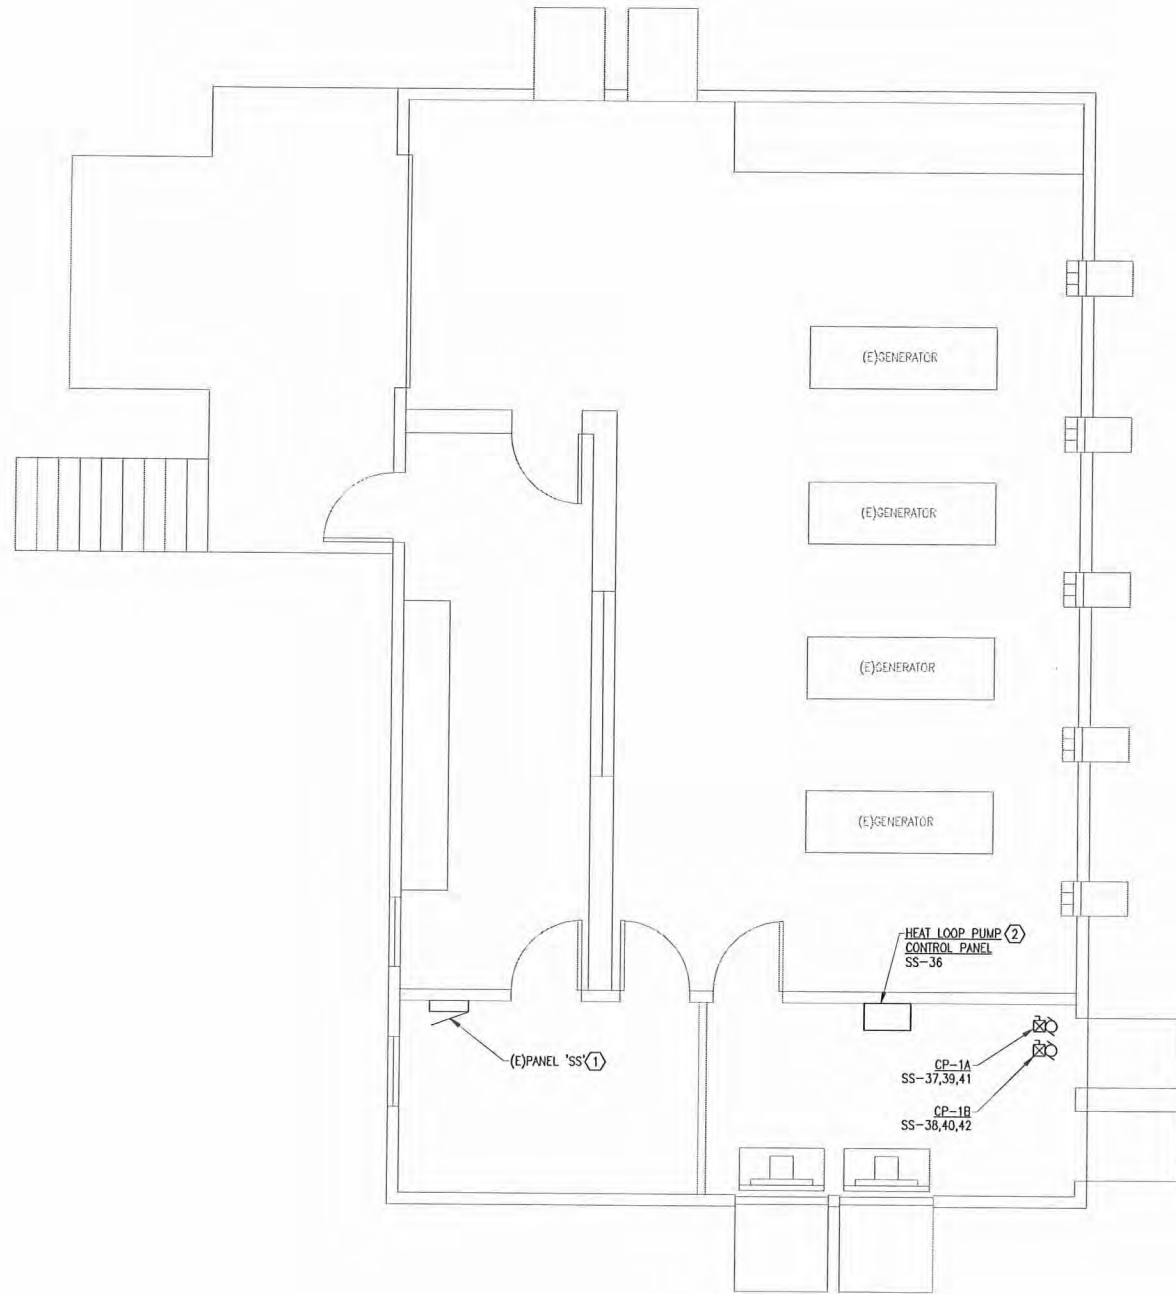

1 EXISTING POWER PLANT PLAN
E4.2 SCALE: 1/4" = 1'-0"

SHEET NOTES

- 1 PROVIDE BRANCH CIRCUITS IN EXISTING PANEL 'SS' (208Y/120V, 150A, 3Ø, 4W) FOR FEED TO NEW HEAT LOOP CONTROL PANEL AND CIRCULATION PUMPS. SEE 3/E6.3 FOR DETAIL.
- 2 PROVIDE HEAT LOOP PUMP CONTROL PANEL. SEE 1/E6.3 AND 2/E6.3 FOR DETAIL.



EIC JCB # E10-1323

EIC ENGINEERS, INC

ELECTRICAL ENGINEERS

6927 OLD SEWARD HWY, SUITE 200
ANCHORAGE, AK 99518
T 907.349.9712
F 907.349.9713
www.eiceng.com

REVISION	BY	DATE

Project No.	Date	Designed	Drawn	Approved
	JAN 2011	BLS	BLS	EDC

Sheet No. **E4.2**

2009 WASTEWATER
SYSTEM IMPROVEMENTS
ELECTRICAL
POWER PLANT PLANS
TULUKSAK, ALASKA




SCALE:
1" = 10'-0"

IF NOT ONE INCH ON
ORIGINAL DRAWING
0 1" 2"


RECORD DRAWING CERTIFICATE
THESE DRAWINGS REFLECT RECORDED
INFORMATION OBTAINED DURING
CONSTRUCTION. INFORMATION PROVIDED
HEREIN IS ACCURATE TO THE BEST OF MY
KNOWLEDGE.

NAME
DATE


LUMINAIRE SCHEDULE					
TYPE	DESCRIPTION	LAMPS	MOUNTING	MANUFACTURER/MODEL	NOTES
LB2	LOW PROFILE ARCHITECTURAL WRAP W/ PRISMATIC LENS	(2) 32W T8	CEILING SURFACE	LITHONIA #LB-2-32-MVOLT-GEB10IS	
LB2E	IDENTICAL TO TYPE 'LB2' EXCEPT W/ 1400 LUMEN BATTERY UNIT	(2) 32W T8	CEILING SURFACE	LITHONIA #LB-2-32-MVOLT-GEB10IS-EL14	
XP1	CLASS 1 DIVISION 1 INCANDESCENT GLOBE & GUARD	(1) 150W INCAN	CEILING SURFACE	HUBBELL #HLE-M-1-15-120-X2-G-HLEMG1	
ZW1	WALL MOUNTED AREA LIGHT W/ CUTOFF OPTICS & INTEGRAL PHOTOCELL	(1) 35W HPS	EXTERIOR WALL	LITHONIA #TWAC-35S-120-PE	
A) CATALOG NUMBERS ARE FOR GENERAL REFERENCE AND ARE NOT INCLUSIVE OF ALL OPTIONS OR REQUIREMENTS DENOTED ON PLANS AND SPECIFICATIONS. B) REFER TO ARCHITECTURAL DRAWINGS FOR EXACT LOCATION AND PROVIDE MOUNTING HARDWARE/FLANGES ETC FOR ALL LUMINAIRES FOR CEILING TYPES SHOWN. C) LUMINAIRES NOTED ON THE FLOOR PLANS AS 'NL' (NIGHTLIGHT) SHALL BE CONNECTED TO UNSWITCHED POWER CIRCUIT NOTED ON DRAWINGS. D) ALL FLUORESCENT BALLASTS TO BE ELECTRONIC WITH LESS THAN OR EQUAL 10% TOTAL HARMONIC DISTORTION. E) ALL FLUORESCENT LAMPS TO BE 3500K. F) PROVIDE ROUGH SERVICE LAMPS FOR ALL INCANDESCENT LUMINAIRES.					
REFERENCED NOTES					
1) NONE.					

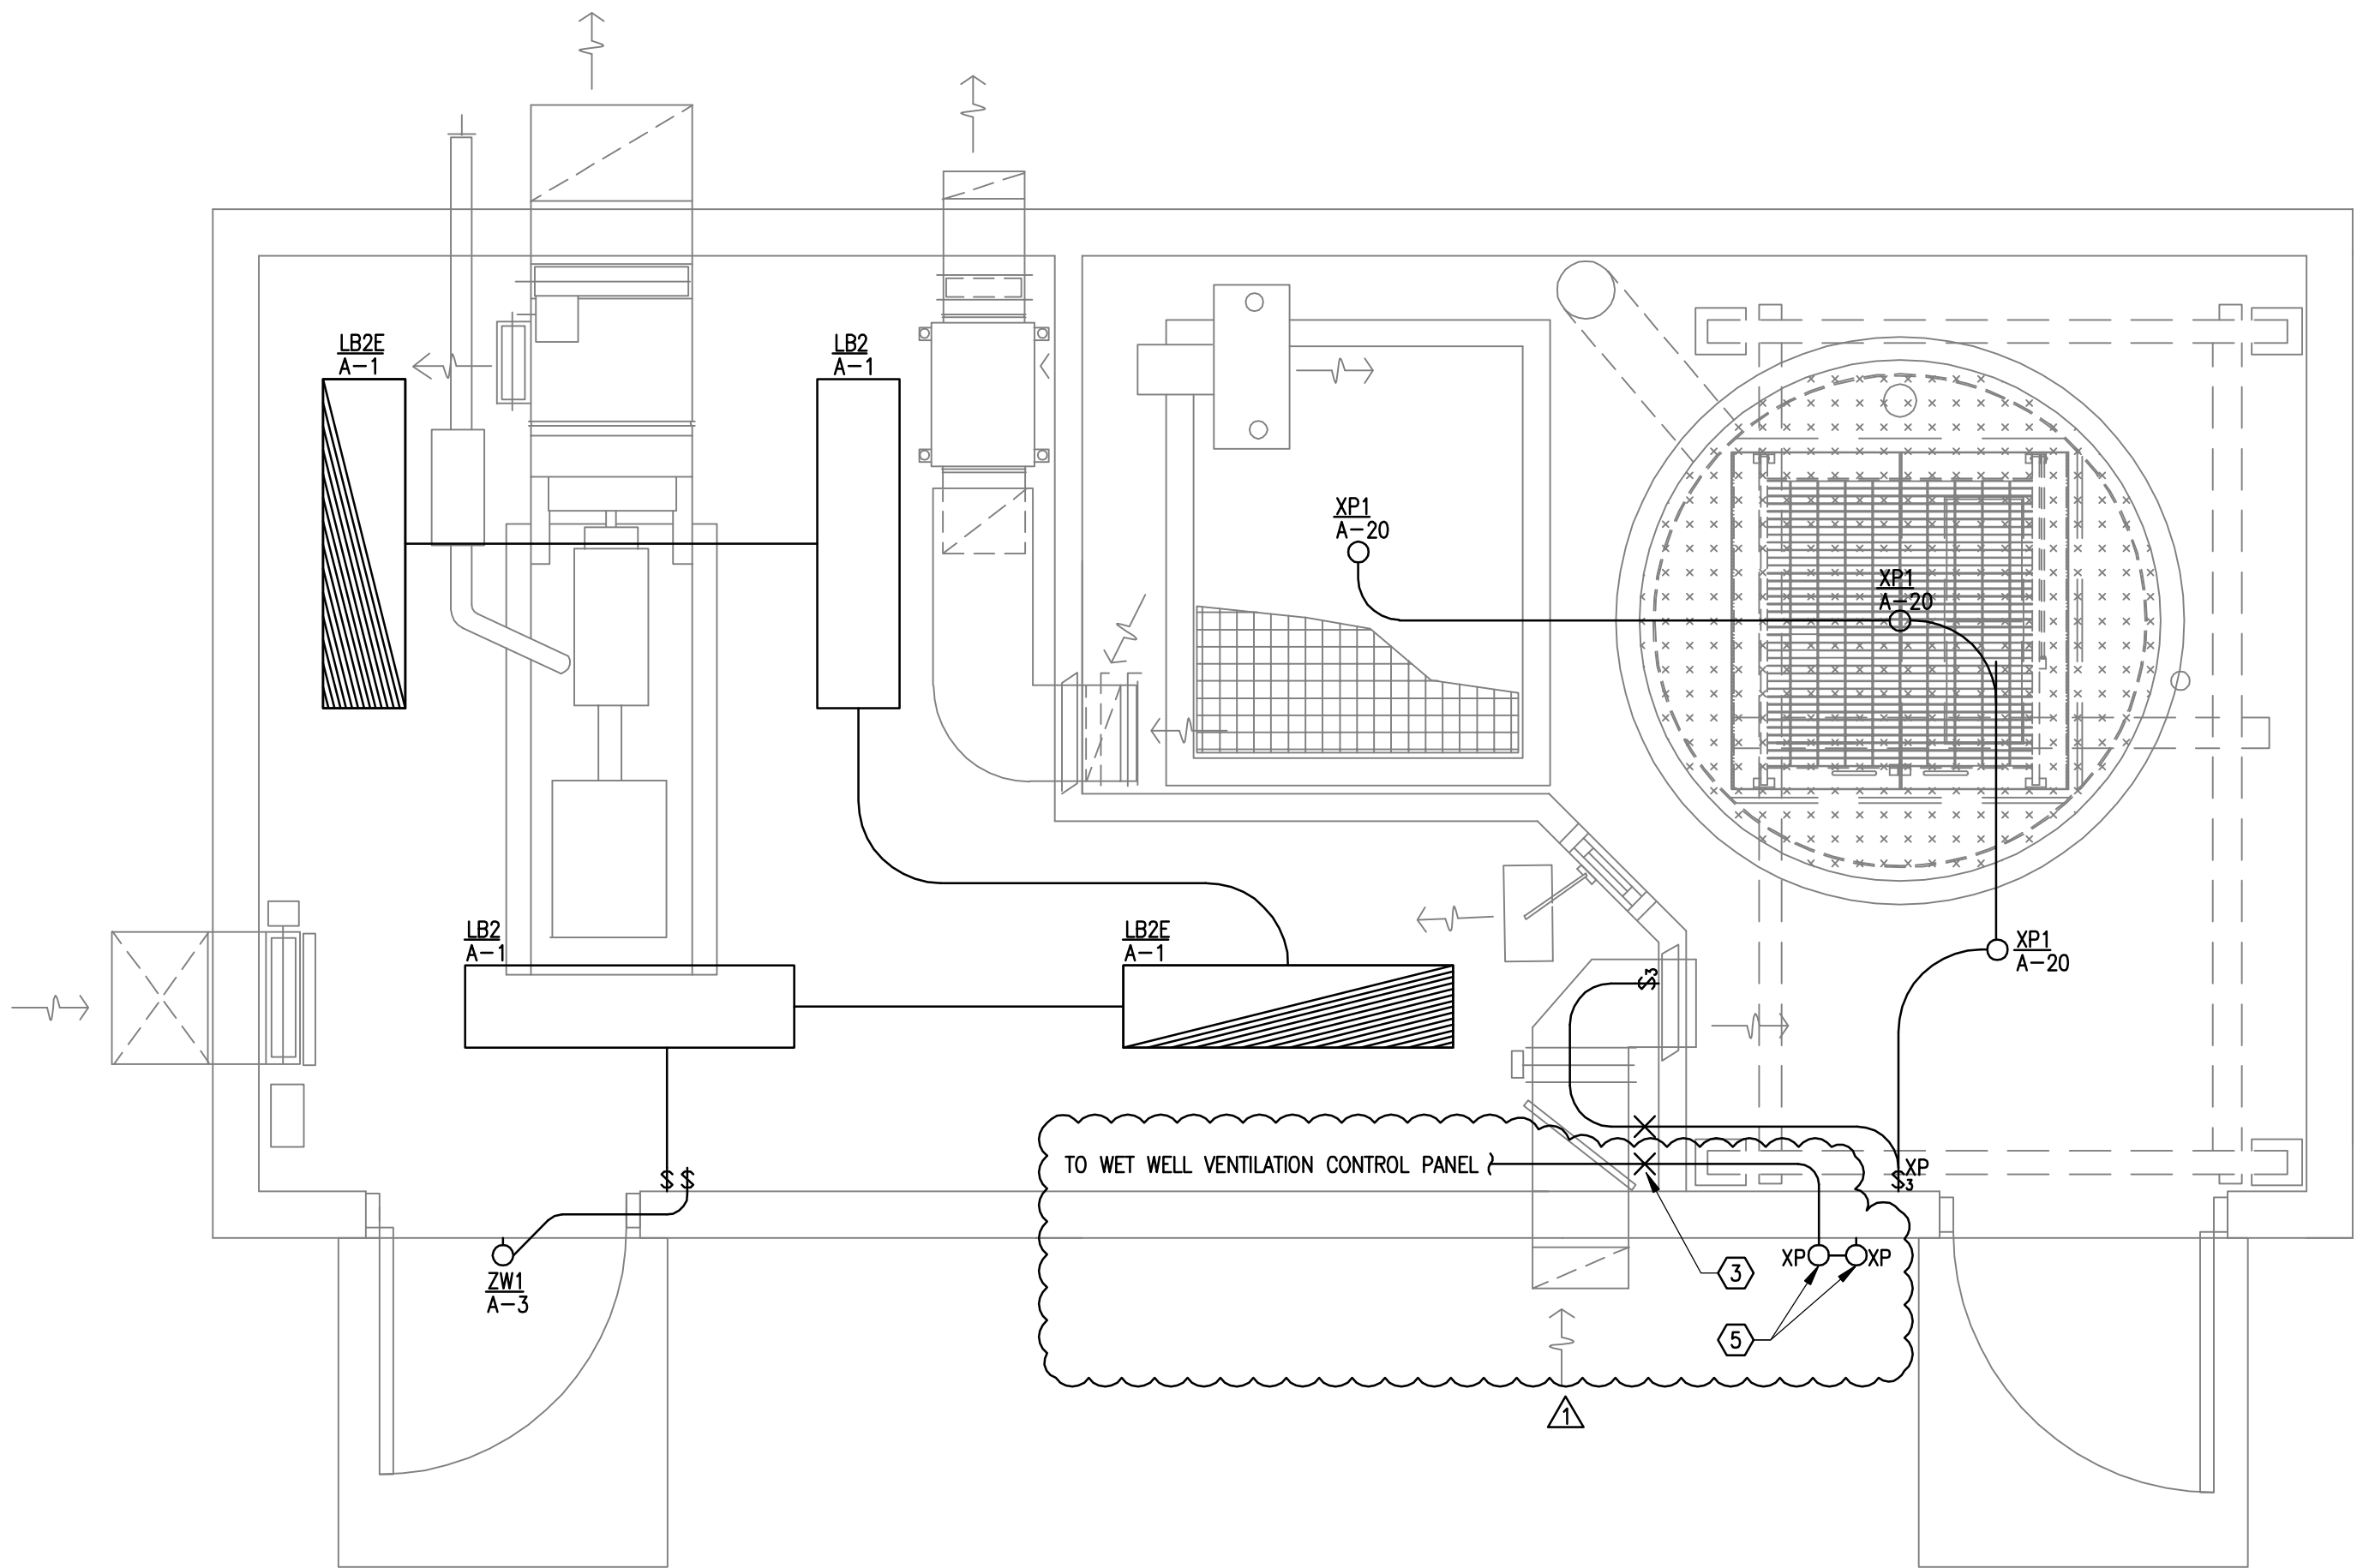

1
E5.1
LIFT STATION ELECTRICAL LIGHTING PLAN
SCALE: 1/2" = 1'-0"

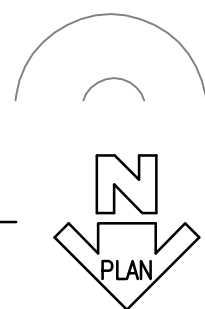

MECHANICAL EQUIPMENT CONNECTION SCHEDULE											
UNIT ID	LOCATION OR FUNCTION	LOAD RATINGS						CONDUCTORS & CONDUIT	NOTES		
		KVA	HP	FLA	MCA	MFS	V	PH			
EF-1	CLASS 1 DIVISION 1 EXHAUST FAN		1/4				120	1	(2)12 AWG, (1)12 AWG EGC, 1/2" C.	2	
SP-1	SEWAGE PUMP		10				208	3	SEE ONE-LINE DIAGRAM	1	
SP-2	SEWAGE PUMP		10				208	3	SEE ONE-LINE DIAGRAM	1	
UH-1	CLASS 1 DIVISION 1 ELECTRIC UNIT HEATER	10					208	3	(3)8 AWG, (1)10 AWG EGC, 3/4" C.		
UH-2	ELECTRIC UNIT HEATER	3					208	1	(2)12 AWG, (1)12 AWG EGC, 1/2" C.		
STANDARD NOTES											
A) REFER TO FLOOR PLAN DRAWINGS FOR EQUIPMENT TYPE REQUIREMENTS, LOCATIONS AND QUANTITIES. B) COORDINATE ALL CONNECTION REQUIREMENTS WITH MECHANICAL AND ACTUAL EQUIPMENT SUPPLIED PRIOR TO ROUGH-IN.											
REFERENCED NOTES											
1) PUMP PROVIDED WITH SOFT START. COORDINATE WITH MECHANICAL. 2) EF-1 CONTROLLED THRU WET WELL VENTILATION CONTROL PANEL.											

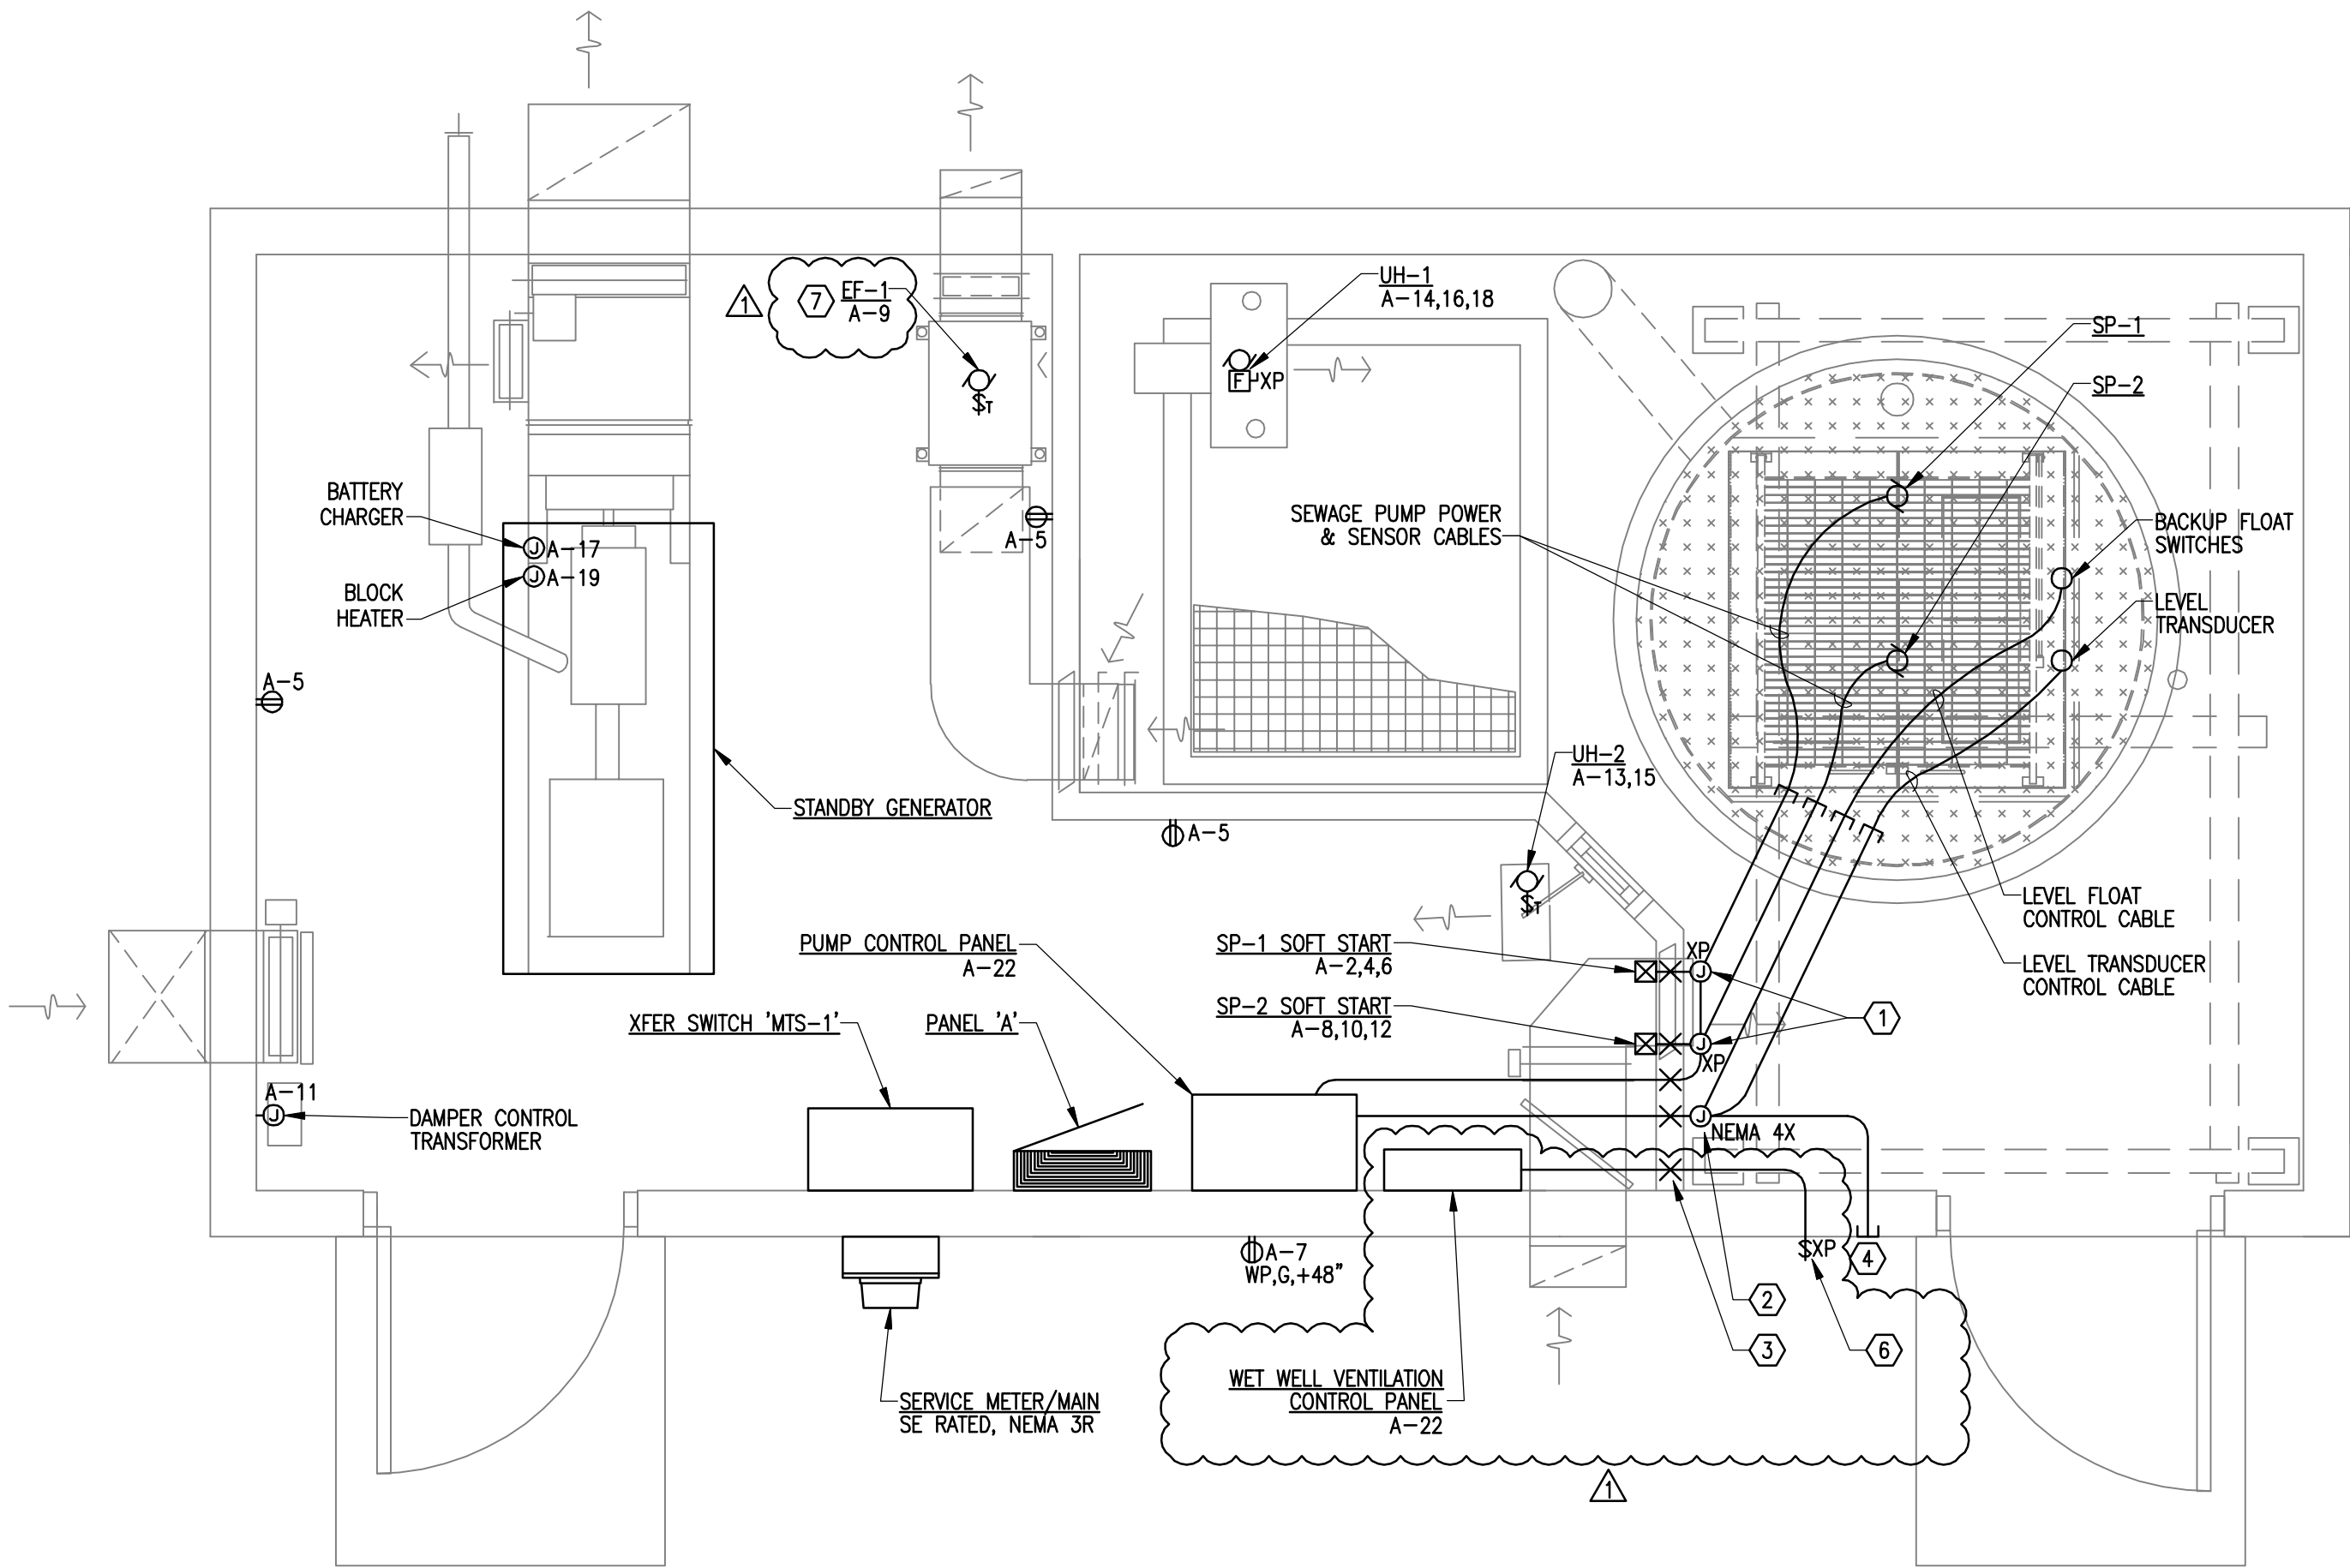

2
E5.1
LIFT STATION ELECTRICAL POWER PLAN
SCALE: 1/2" = 1'-0"



EIC ENGINEERS, INC
ELECTRICAL ENGINEERS


EIC JOB #E10-1323

6927 OLD SEWARD HWY, SUITE 200
ANCHORAGE, AK 99518
T 907.349.9712
F 907.349.9713
www.eiceng.com

SHEET NOTES

- 1) PROVIDE EXPLOSION PROOF JUNCTION BOXES FOR WET WELL PUMP CABLE TERMINATIONS. SEE 2/E5.2 FOR DETAIL.
- 2) PROVIDE NEMA 4X JUNCTION FOR FLOAT SWITCH, AND LEVEL TRANSDUCER CABLE TERMINATIONS. SEE 2/E5.2 FOR DETAIL.
- 3) PROVIDE CONDUIT SEAL-OFF AT HAZARDOUS BOUNDARY, TYPICAL.
- 4) PROVIDE CONDUIT FROM CONTROL J-BOX TO BUILDING EXTERIOR FOR LEVEL TRANSDUCER BELLOWS VENTILATION.
- 5) PROVIDE EXPLOSION PROOF STATUS LIGHTS TO BUILDING EXTERIOR, CONTROL FROM WET WELL VENTILATION CONTROL PANEL. SEE MECHANICAL AND 1/E6.4 FOR DETAIL.
- 6) PROVIDE EXPLOSION PROOF SELECTOR SWITCH TO BUILDING EXTERIOR, CONTROL FROM WET WELL VENTILATION CONTROL PANEL. SEE MECHANICAL AND 1/E6.4 FOR DETAIL.
- 7) EF-1 CONTROLLED THRU WET WELL VENTILATION CONTROL PANEL. SEE MECHANICAL AND 1/E6.4 FOR DETAIL.

RECORD DRAWING CERTIFICATE


THESE DRAWINGS REFLECT RECORDED INFORMATION OBTAINED DURING CONSTRUCTION. INFORMATION PROVIDED HEREIN IS ACCURATE TO THE BEST OF MY KNOWLEDGE.

SCALE: AS SHOWN

IF NOT ONE INCH ON THIS SHEET, ADJUST SCALES ACCORDINGLY.

NAME

DATE

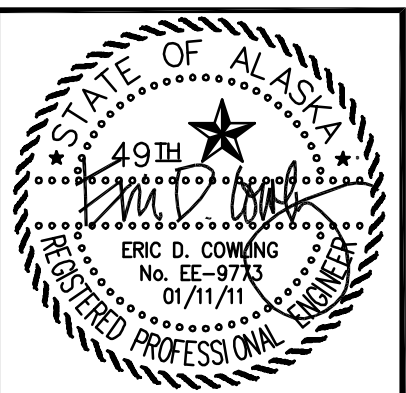

2009 WASTEWATER SYSTEM IMPROVEMENTS

ELECTRICAL LIFT STATION PLANS

TULUKSAK, ALASKA

EIC ENGINEERS, INC.


PO BOX 22846 ANCHORAGE, AK 99523 PH: 907-349-1010 FAX: 907-349-1016

REVISION	BY	DATE
1	BLS	11/09/11


Project No.	Date	Designed	BLS	Drawn	BLS	Approved	EDC
	JAN 2011						

Sheet No.

E5.1

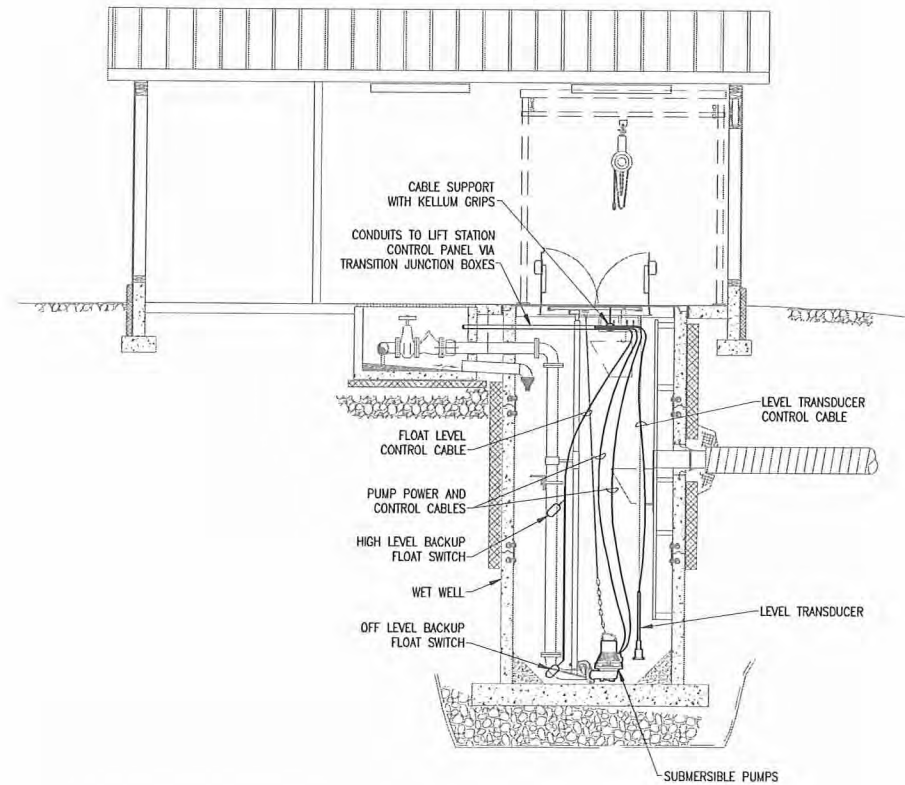

1 LIFT STATION WET WELL ELEVATION
E5.2 SCALE: 1/4" = 1'-0"

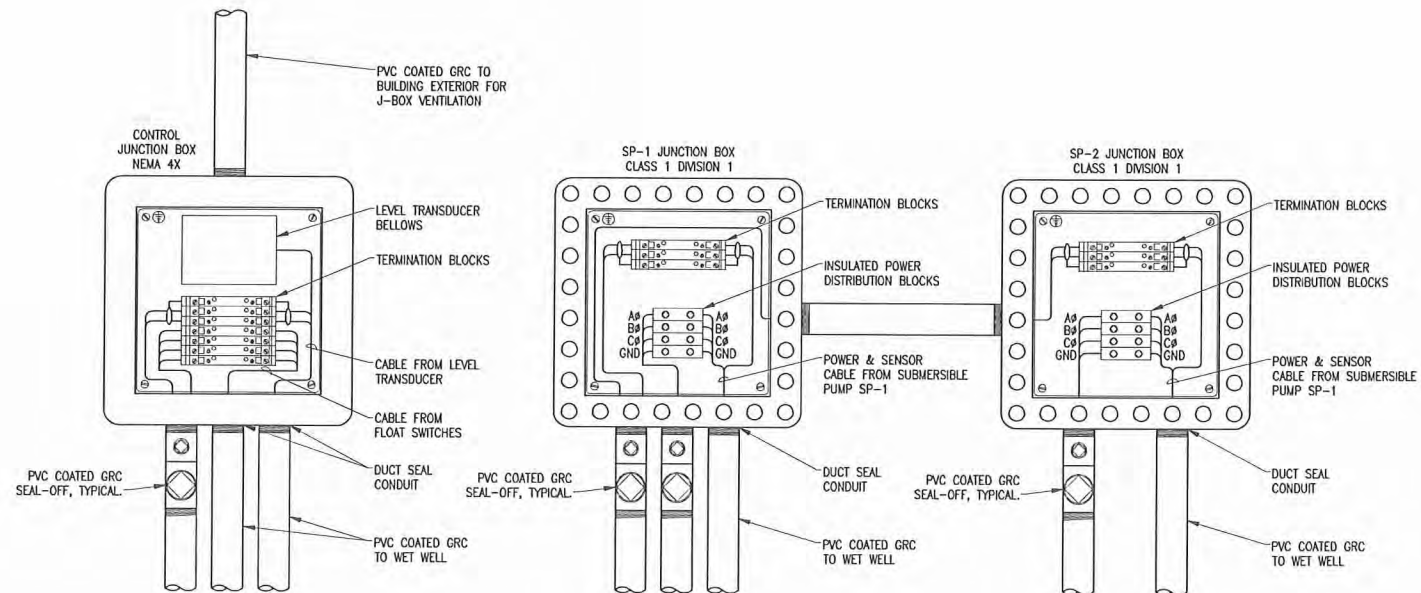

DETAIL NOTES

- JUNCTION BOXES SHALL BE SIZED AS REQUIRED TO HOUSE TERMINATION COMPONENTS AND WIRING PER NEC.
- ALL WIRING ROUTED THROUGH THE NEMA 4X CONTROL JUNCTION BOX SHALL BE INTRINSICALLY SAFE.

2 LIFT STATION TRANSITION JUNCTION BOX DETAIL
E5.2 SCALE: NONE

EIC ENGINEERS, INC
ELECTRICAL ENGINEERS

6927 OLD SEWARD HWY, SUITE 200
ANCHORAGE, AK 99518
T 907.349.9712
F 907.349.9713
www.eiceng.com

BC JOB #E10-1323

RECORD DRAWING CERTIFICATE
THESE DRAWINGS REFLECT RECORDED INFORMATION OBTAINED DURING CONSTRUCTION. INFORMATION PROVIDED HEREIN IS ACCURATE TO THE BEST OF MY KNOWLEDGE.

SCALE: 1" = 1'-0" (IF NOT ONE INCH ON DRAWING, SCALES ACCORDINGLY)

DATE: 01/11/11

NAME: _____ DATE: _____

STATE OF ALASKA
19TH DISTRICT
ERIC D. COMBING
No. EE-9713
01/11/11
REGISTERED PROFESSIONAL ENGINEER

2009 WASTEWATER SYSTEM IMPROVEMENTS ELECTRICAL LIFT STATION PLANS
TULUKSAK, ALASKA

CE2 ENGINEERS, INC.
PO BOX 222946 ANCHORAGE, AK 99523 PH: 907-346-1010 FAX: 907-346-1015


REVISION	BY	DATE

Project No. _____ Date JAN 2011
Designed by BLS
Drawn by BLS
Approved by EDC


Sheet No. **E5.2**

- (1) **SERVICE METER/MAIN-**
SE RATED, NEMA 3R, 200A MAIN CB, 208Y/120V, 3ø, 4W,
SQUARE D OR EQUIVALENT.
- (2) **MANUAL TRANSFER SWITCH "MIS-1"**-
NEMA 1, 3-POLE, 200A, 208/120V, 3ø, 4W. ASCO OR
EQUIVALENT.
- (3) **PANEL "A"**-
NEMA 1, 225A, 208Y/120V, 3ø, 4W, 42 SPACE. SQUARE D
TYPE NQOD OR EQUIVALENT. PROVIDE WITH TRANSIENT
VOLTAGE SURGE SUPPRESSION (TVSS).
- (4) **PUMP CONTROL PANEL-**
DUPLEX PUMP CONTROL PANEL
(SEE SHEET E6.2)
- (5) **SEWAGE PUMP SOFT START MOTOR STARTER-**
10HP, 208V 3ø, IP20 ENCLOSURE
PROGRAMMABLE PUMP CURVES
DANFOSS OR EQUIVALENT
(SEE SHEET E6.2)
- (6) **STANDBY GENERATOR-**
40KW/SOKIVA, 208Y/120V, 3ø, 4 WIRE
DIESEL, WITH BASE TANK
KOHLER OR EQUIVALENT

FEEDER SCHEDULE				NOTES
FEEDER ID	RACEWAY		CONDUCTORS	NOTES
	QNTY	SIZE		
60	1	1"	(3)6 AWG, (1)10 AWG EGC	
100N	1	1-1/4"	(4)2 AWG, (1)8 AWG EGC	
150N	1	2"	(4)1/0 AWG, (1)6 AWG EGC	
200N	1	2"	(4)3/0 AWG, (1)6 AWG EGC	
PC1	1	1-1/2"	PUMP POWER & SENSOR CABLE	
TC1	1	3/4"	(1)16/2 TWSD, (4)12 AWG (FLOAT & LEVEL TRANSDUCER CONTROL WIRING)	2
TC2	1	1-1/2"	LEVEL TRANSDUCER CABLE	
TC3	1	1-1/2"	FLOAT SWITCH CABLE	
TC4	1	3/4"	(4)12 AWG (PUMP START/STOP & PHASE FAIL CONTROL WIRING)	2
TC5	1	1/2"	(2)16/2 TWSD (PUMP SENSOR CONTROL WIRING)	2
TC6	1	1/2"	(1)16/2 TWSD (PUMP SENSOR CONTROL WIRING)	2
SE	1	2"	CONDUIT ONLY	1
STANDARD NOTES				
A) ALL CONDUCTOR SIZES SHOWN ARE COPPER.				
REFERENCED NOTES				
1) CONDUIT STUB WITH WEATHER HEAD FOR OVERHEAD UTILITY CONNECTION.				
2) CONTRACTOR TO VERIFY CONDUIT WIRING WITH ACTUAL EQUIPMENT SUPPLIED.				

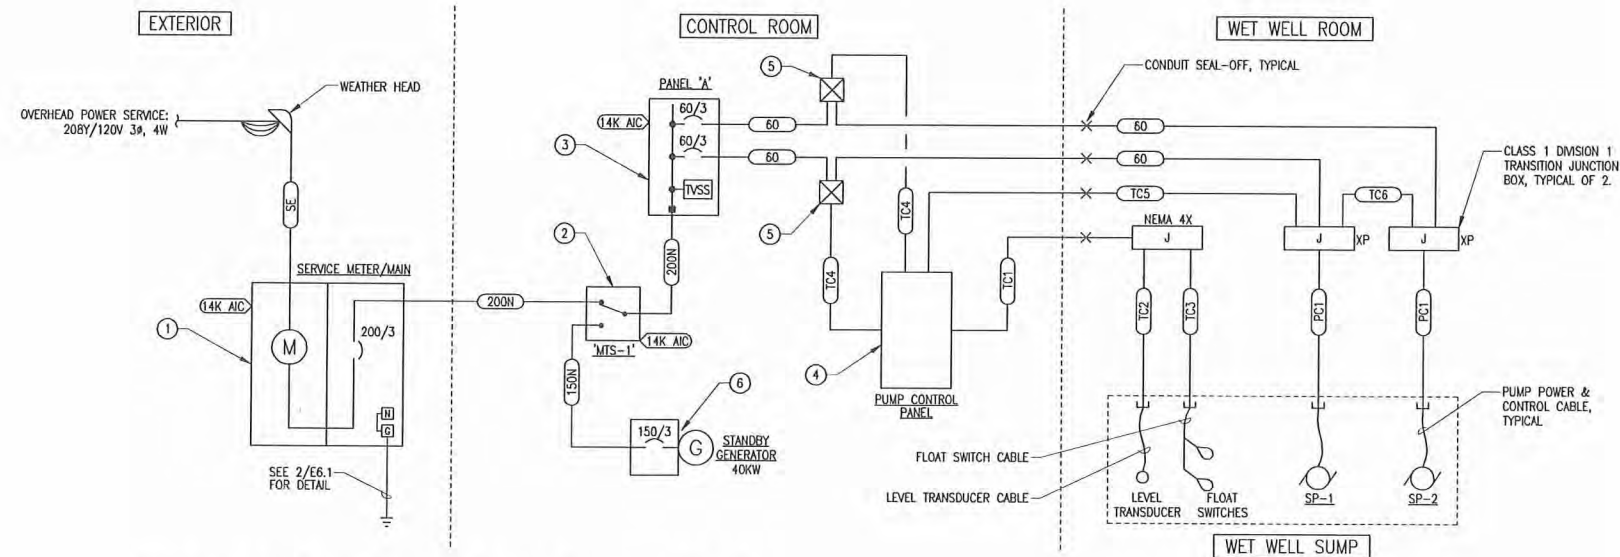

1 LIFT STATION POWER ONE-LINE DIAGRAM
E6.1 SCALE: NONE

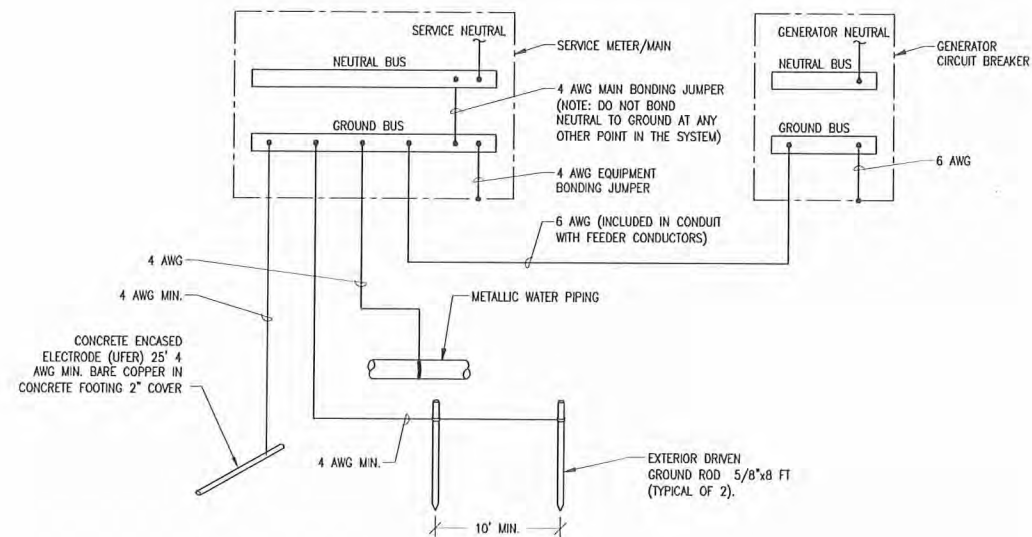

2 LIFT STATION GROUNDING DIAGRAM
E6.1 SCALE: NONE

VOLTAGE: 208Y/120V, 3PH, 4W
BUS: 225
MAIN-LUGS ONLY - FED BY 225A CB

PANEL "A" SCHEDULE

MIN. A.I.C. RATINGS: SEE PANEL
ENCLOSURE: NEMA 1
MOUNTING: SURFACE

LOAD DESCRIPTION	NOTE	KVA	LOAD	AMP	P	CKT	ABC	CKT	AMP	P	LOAD DESCRIPTION	NOTE	KVA	LOAD
LTC-CONTROL ROOM	0.28	L	20	1	1	2			60	3	SP-1			
LTC-EXT-ROOM	0.07	L	20	1	1	4							11.10	LM
REC-CONTROL ROOM	0.54	R	20	1	5	6								
REC-EXT-ROOM	0.18	R	20	1	7	8			60	3	SP-2		11.10	1
LP-1	0.70	M	20	1	9	10								
MOTORIZED DAMPERS	0.10	C	15	1	11	12								
UH-2	3.00	C	20	2	13	14			40	3	UH-1		10.00	C
GENERATOR BATTERY CHARGER	1.20	C	20	1	17	18								
GENERATOR BLOCK HEATER	1.50	C	20	1	19	20			20	1	LTC-WET WELL		0.21	L
SPARE			20	1	21	22			20	1	PUMP CONTROL PANEL		0.25	R
SPARE			20	1	23	24			1		SPACE			
SPARE			20	1	25	26			1		SPACE			
SPARE			20	1	27	28			1		SPACE			
SPARE			20	1	29	30			1		SPACE			
SPARE			20	1	31	32			1		SPACE			
SPARE			20	1	33	34			1		SPACE			
SPARE			20	1	35	36			1		SPACE			
SPARE			20	1	37	38			1		SPACE			
SPARE			20	1	39	40			1		SPACE			
SPARE			20	1	41	42			1		SPACE			


SUMMARY BY LOAD TYPE	CONNECTED KVA				TOTAL KVA	NEC %	TOTAL	NOTES:
G GENERAL LOADS	PH A	PH B	PH C	FEED		N/A		1. PROVIDE PANEL WITH TRANSIENT VOLTAGE SURGE SUPPRESSION (TVSS).
A APPLIANCE						0.75		
E ELECTRIC RANGE						1.00		
L LIGHTING	0.5	0.1			0.6	1.25	0.7	
R RECEPTACLES	0.2	0.3	0.5		1.0	10K+500	1.0	
M MOTORS	3.7	4.4	3.7		11.8	1.00	11.8	
LM LARGEST MOTOR	3.7	3.7	3.7		1.1	1.25	1.3	
C CONTINUOUS	6.3	4.8	4.6		15.8	1.25	19.8	
N NON-CONTINUOUS						1.00		
S SPACE						1.00		
Y NON-COINCIDENT						0.00		
K KITCHEN						1.00		
D DRYER						1.00		
O OTHER						1.00		
ETR OSTS TO REMAIN						1.25		
F FEEDER								
TOTAL KVA (PHASE)	14.4	13.2	12.6		40.2		47.1	
TOTAL AMPERES	115.9	110.3	104.7		111.7		130.7	
PHASE BALANCE, ABC		B-C	C-A					
PERCENT	8.6%	5.0%	13.6%					

EIC ENGINEERS, INC.
ELECTRICAL ENGINEERS

 6927 OLD SEWARD HWY, SUITE 200
ANCHORAGE, AK 99518
T 907.349.9712
F 907.349.9713
www.eiceng.com

EIC JOB #E10-1323

RECORD DRAWING CERTIFICATE	NAME	DATE
THESE DRAWINGS REFLECT RECORDED INFORMATION OBTAINED DURING CONSTRUCTION. INFORMATION PROVIDED HEREIN IS ACCURATE TO THE BEST OF MY KNOWLEDGE.		

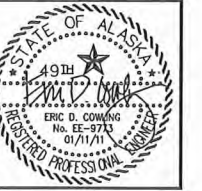

**2009 WASTEWATER
SYSTEM IMPROVEMENTS**

**ELECTRICAL
LIFT STATION
DIAGRAMS &
PANEL SCHEDULE**

TULUKSAK, ALASKA

CE2
ENGINEERS, INC.
PO BOX 22546 ANCHORAGE, AK 99522 PH: 907-546-1010 FAX: 907-546-1015

No. _____


Date JAN 2011

Designed _____ BLS

Drawn _____ BLS


Approved _____ EDC

E6.1

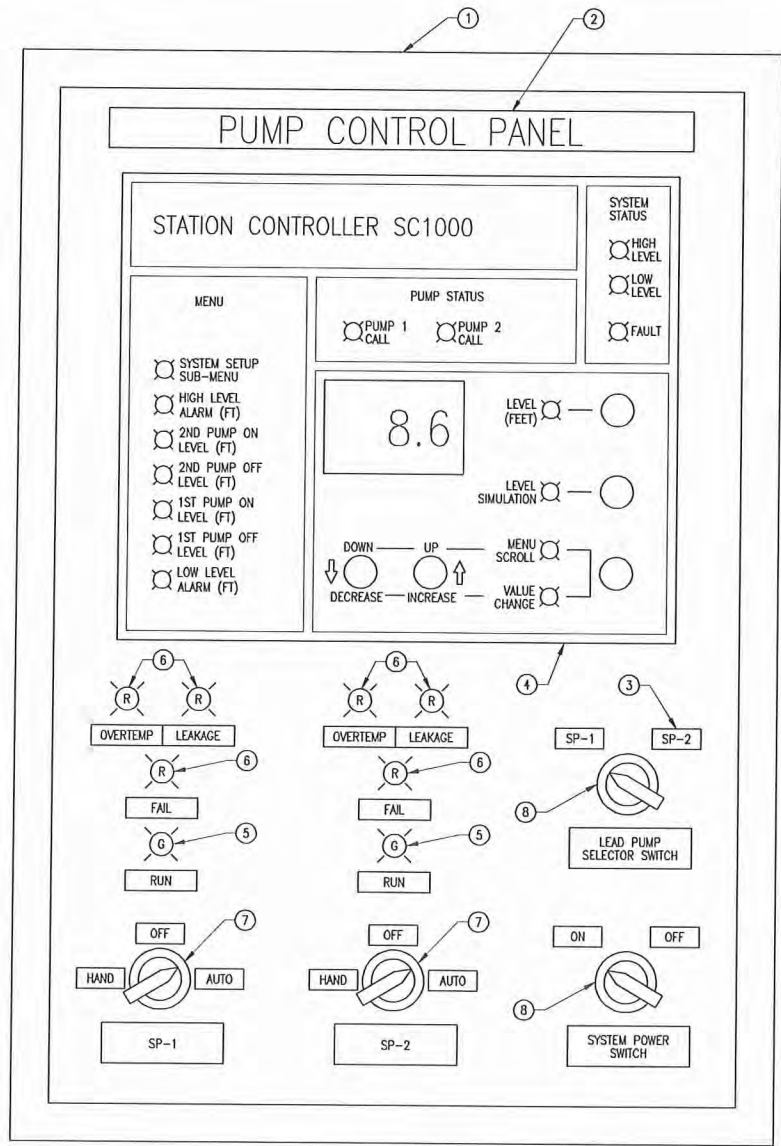

CONTROL PANEL COMPONENT SCHEDULE		
ITEM	DESCRIPTION	NOTES
①	CONTROL PANEL ENCLOSURE- NEMA 4, SIZED ADEQUATE TO HOUSE COMPONENTS.	
②	NAME TAG- BLACK LAMINATED PLASTIC W/ WHITE CORE, SCREW MOUNTED, 1/2" ENGRAVED LETTERS	
③	NAME TAG- BLACK LAMINATED PLASTIC W/ WHITE CORE, SCREW MOUNTED, 1/4" ENGRAVED LETTERS	
④	DUPLEX PUMP CONTROLLER- MPE, INC STATION CONTROLLER SC1000	
⑤	PILOT LIGHT- 30mm, GREEN, LED, 120VAC, PUSH TO TEST TYPE, ALLEN BRADLEY 800T-P1H16G	
⑥	PILOT LIGHT- 30mm, RED, LED, 120VAC, PUSH TO TEST TYPE, ALLEN BRADLEY 800T-P1H16R	
⑦	SELECTOR SWITCH- 30mm, 3-POSITION MAINTAINED W/ TERMINAL BLOCKS & CAM SHOWN, ALLEN BRADLEY 800 SERIES	
⑧	SELECTOR SWITCH- 30mm, 2-POSITION MAINTAINED W/ TERMINAL BLOCKS & CAM SHOWN, ALLEN BRADLEY 800 SERIES	
STANDARD NOTES		
A) CONTRACTOR TO PROVIDE PART NUMBERS SHOWN OR EQUIVALENT.		
REFERENCED NOTES		
1) NONE.		

1 PUMP CONTROL PANEL LAYOUT & CONTROL DIAGRAM
E6.2 SCALE: NONE

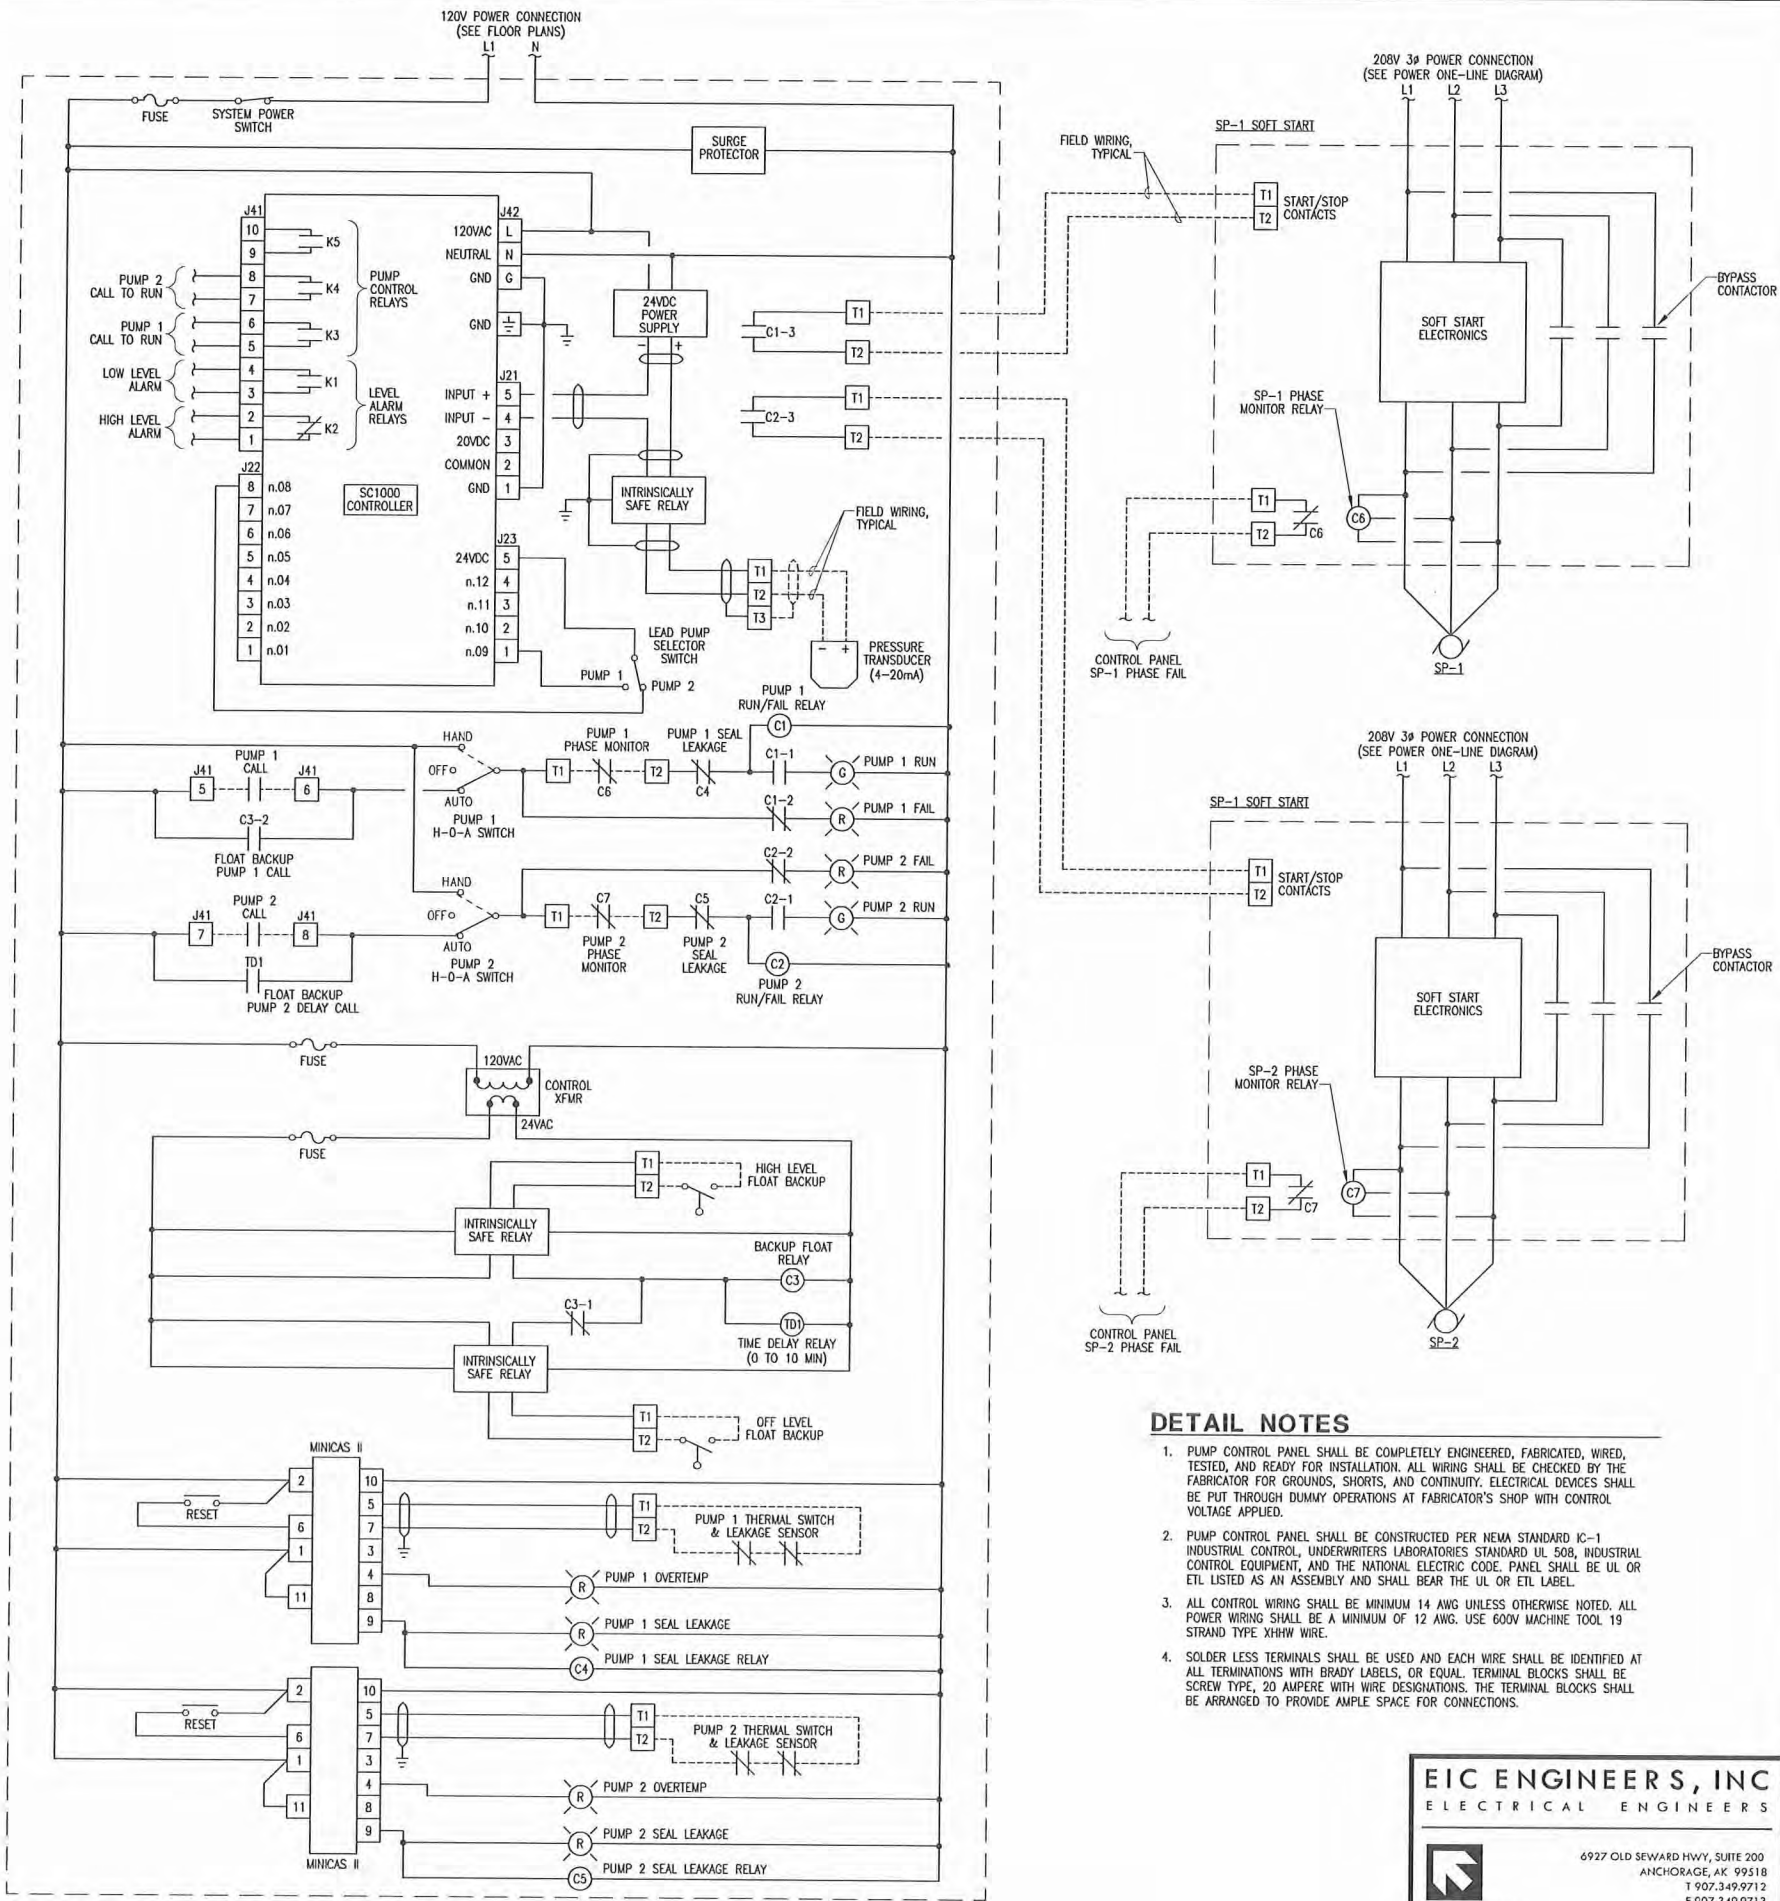

DETAIL NOTES

- PUMP CONTROL PANEL SHALL BE COMPLETELY ENGINEERED, FABRICATED, WIRED, TESTED, AND READY FOR INSTALLATION. ALL WIRING SHALL BE CHECKED BY THE FABRICATOR FOR GROUNDS, SHORTS, AND CONTINUITY. ELECTRICAL DEVICES SHALL BE PUT THROUGH DUMMY OPERATIONS AT FABRICATOR'S SHOP WITH CONTROL VOLTAGE APPLIED.
- PUMP CONTROL PANEL SHALL BE CONSTRUCTED PER NEMA STANDARD IC-1 INDUSTRIAL CONTROL, UNDERWRITERS LABORATORIES STANDARD UL 508, INDUSTRIAL CONTROL EQUIPMENT, AND THE NATIONAL ELECTRIC CODE. PANEL SHALL BE UL OR ETL LISTED AS AN ASSEMBLY AND SHALL BEAR THE UL OR ETL LABEL.
- ALL CONTROL WIRING SHALL BE MINIMUM 14 AWG UNLESS OTHERWISE NOTED. ALL POWER WIRING SHALL BE A MINIMUM OF 12 AWG. USE 600V MACHINE TOOL 19 STRAND TYPE XHHW WIRE.
- SOLDER LESS TERMINALS SHALL BE USED AND EACH WIRE SHALL BE IDENTIFIED AT ALL TERMINATIONS WITH BRADY LABELS, OR EQUAL. TERMINAL BLOCKS SHALL BE SCREW TYPE, 20 AMPERE WITH WIRE DESIGNATIONS. THE TERMINAL BLOCKS SHALL BE ARRANGED TO PROVIDE AMPLE SPACE FOR CONNECTIONS.

EIC ENGINEERS, INC
ELECTRICAL ENGINEERS

6927 OLD SEWARD HWY, SUITE 200
ANCHORAGE, AK 99518
T 907.349.9712
F 907.349.9713
www.eiceng.com

RECORD DRAWING CERTIFICATE
THESE DRAWINGS REFLECT RECORDED
INFORMATION OBTAINED DURING
CONSTRUCTION. INFORMATION PROVIDED
HEREIN IS ACCURATE TO THE BEST OF MY
KNOWLEDGE.

SCALE: 1" = 1'-0"

STATE OF ALASKA
49th
EPC D. COWAN
No. EE-9713
01/11/11
REGISTERED PROFESSIONAL ENGINEER


2009 WASTEWATER
SYSTEM IMPROVEMENTS
ELECTRICAL
LIFT STATION
CONTROLS

TULUKSAK, ALASKA

ENGINEERS, INC.
PO BOX 22596 ANCHORAGE AK 99523 PH: 907-545-0110 FAX: 907-545-0105


Project No. _____ Date _____
Designed _____ BLS
Drawn _____ BLS
Approved _____ EDC

Sheet No. E6.2

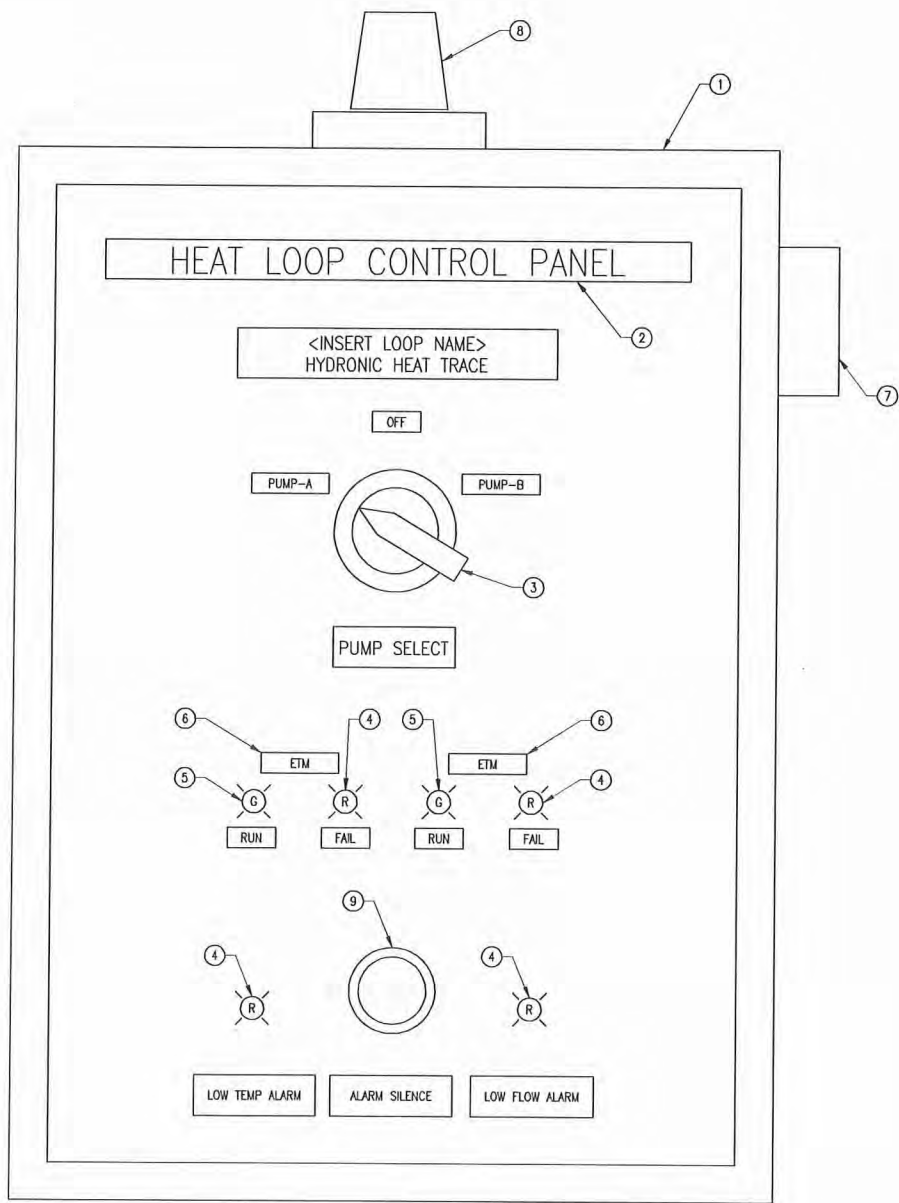


1 POWER PLANT GLYCOL HEAT LOOP PUMP CONTROL PANEL
E6.3 SCALE: NONE

HEAT LOOP CONTROL PANEL COMPONENT SCHEDULE		
ITEM	DESCRIPTION	NOTES
1	CONTROL PANEL ENCLOSURE- NEMA 3R, SIZED AS ADEQUATE TO HOUSE COMPONENTS	
2	NAME TAG- BLACK LAMINATED PLASTIC W/ WHITE CORE, SCREW MOUNTED, 1/4" (1/2" FOR FRONT DOOR ONLY) ENGRAVED LETTERS	
3	SELECTOR SWITCH- 30mm, 3-POSITION MAINTAINED W/ TERMINAL BLOCKS & CAM SHOWN	
4	PILOT LIGHT- 18mm, RED, LED, 120VAC, PUSH TO TEST TYPE, ALLEN BRADLEY 800T-PSH16R	
5	PILOT LIGHT- 18mm, GREEN, LED, 120VAC, PUSH TO TEST TYPE, ALLEN BRADLEY 800T-PSH16G	
6	ELAPSE TIME METER- HOUR METER, NON-RESETTABLE, 99999.9 HOUR REGISTER, HOBBS #20017	
7	ALARM HORN- 120VAC, WEATHERPROOF, CAST BACK BOX	
8	ALARM STROBE- 120VAC, WEATHERPROOF, CASE BACK BOX, AMBER LENS	
9	ALARM SILENCE PUSHBUTTON- MOMENTARY SWITCH, 120VAC, RED	
STANDARD NOTES		
A) CONTRACTOR TO PROVIDE PART NUMBERS SHOWN OR EQUIVALENT.		
REFERENCED NOTES		
1) NONE		

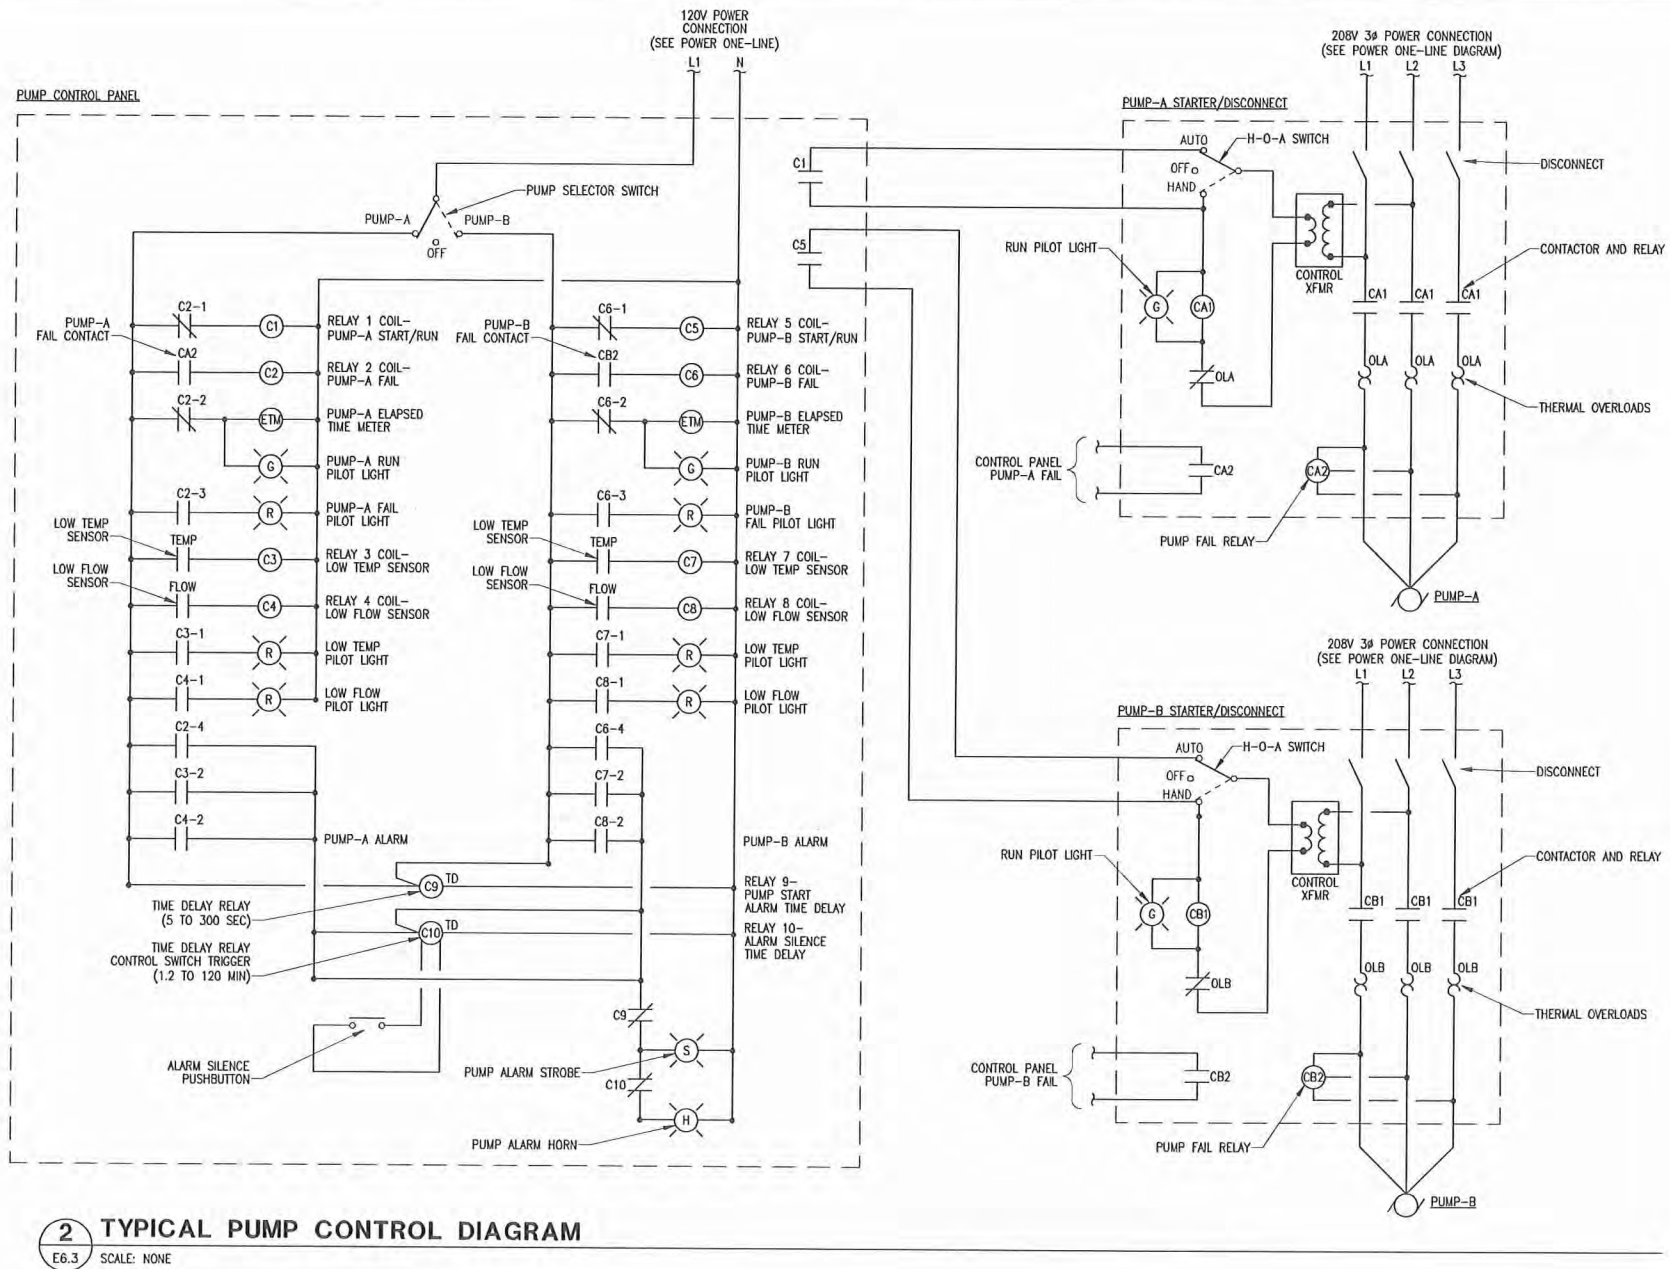

2 TYPICAL PUMP CONTROL DIAGRAM
E6.3 SCALE: NONE

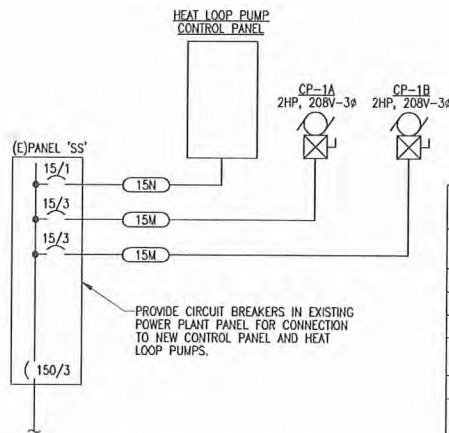

3 POWER PLANT POWER ONE-LINE DIAGRAM
E6.3 SCALE: NONE

FEEDER SCHEDULE				
FEEDER ID	RACEWAY QNTY	SIZE	CONDUCTORS	NOTES
15N	1	1/2"	(2)12 AWG, (1)12 AWG EGC	
15M	1	1/2"	(3)12 AWG, (1)12 AWG EGC	
STANDARD NOTES				
A) ALL CONDUCTOR SIZES SHOWN ARE COPPER.				
REFERENCED NOTES				
1) NONE				

PANEL 'SS' LOAD SUMMARY	
EXISTING LOAD	
PANEL 'SS' LOAD (FROM ASBUILTS) =	37.0 KVA
NEW LOAD	
CP-1A/B =	2.70 KVA
HEAT LOOP PUMP CONTROL PANEL =	0.75 KVA
25% LARGEST MOTOR =	0.68 KVA
	41.1 TOTAL KVA
CALCULATED CURRENT = 114.2 AMPS @ 208 V, 3 PHASE	
EXISTING 150 A, 208 V, 3 PHASE, 4 WIRE PANEL IS ADEQUATE	

EIC ENGINEERS, INC.
ELECTRICAL ENGINEERS

6927 OLD SEWARD HWY, SUITE 200
ANCHORAGE, AK 99518
T 907.349.9712
F 907.349.9713
www.eiceng.com

RECORD DRAWING CERTIFICATE
THESE DRAWINGS REFLECT RECORDED INFORMATION OBTAINED DURING CONSTRUCTION. INFORMATION PROVIDED HEREIN IS ACCURATE TO THE BEST OF MY KNOWLEDGE.

SCALE: 1" = 1'-0"

STATE OF ALASKA
49th
ERIC D. COMBING
No. EE-9713
01/11/11
REGISTERED PROFESSIONAL ENGINEER


2009 WASTEWATER SYSTEM IMPROVEMENTS
ELECTRICAL POWER PLANT CONTROLS & DIAGRAMS
TULUKSAK, ALASKA

CE2 ENGINEERS, INC.
PO BOX 222946 ANCHORAGE, AK 99522 PH: 907-345-1010 FAX: 907-345-1015

REVISION	BY	DATE

Project No.	Date	Designed	Drawn	Approved
	JAN 2011	BLS	BLS	EDC

Sheet No. **E6.3**

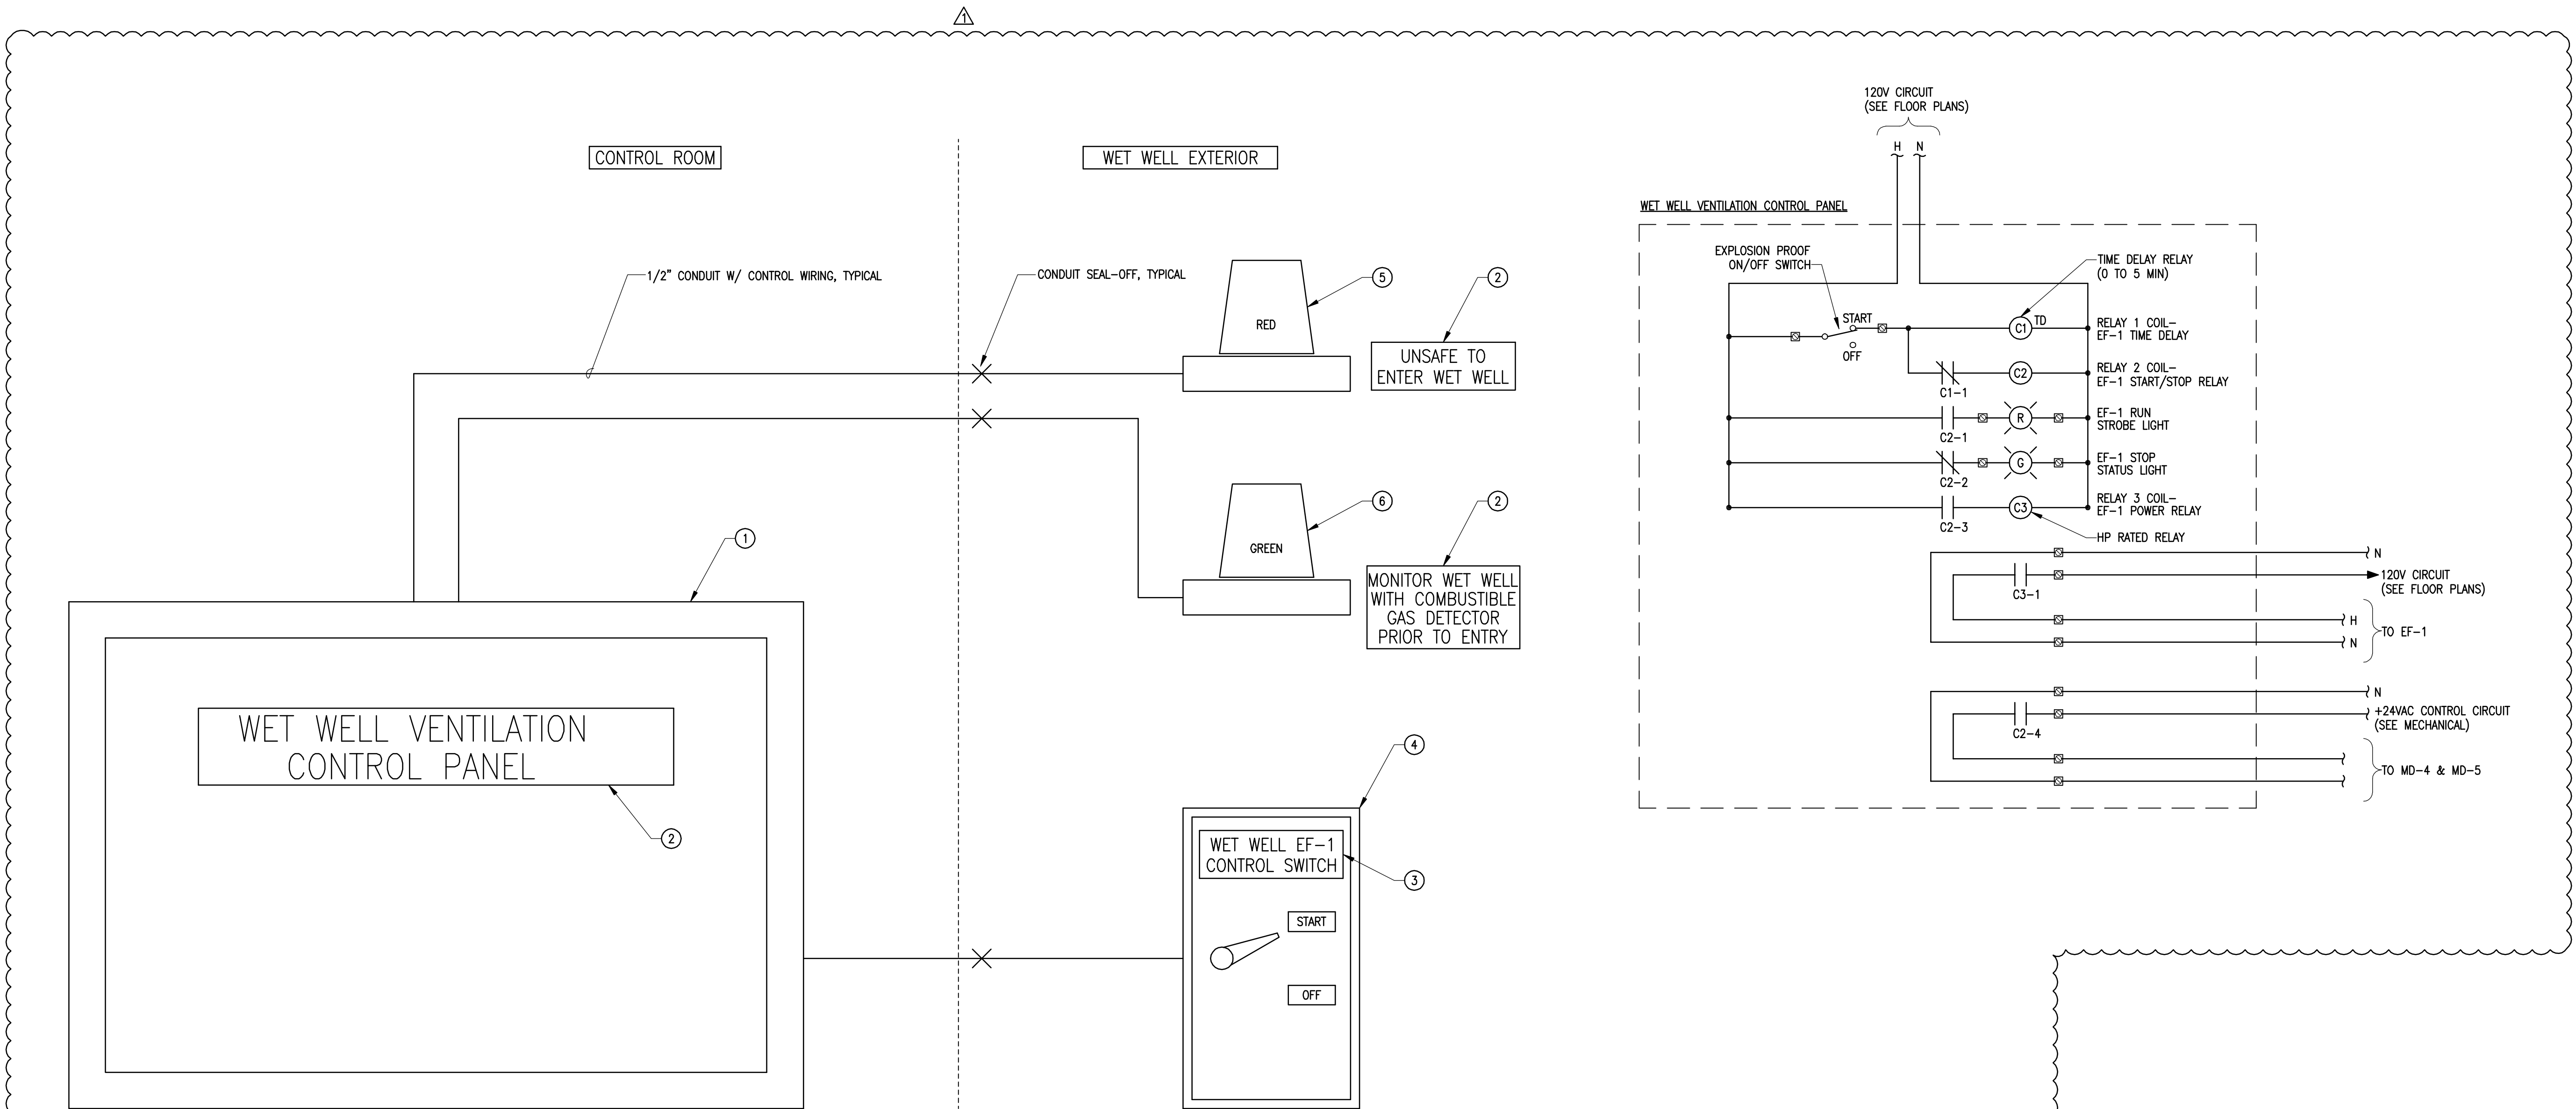

CONTROL PANEL COMPONENT SCHEDULE		
ITEM	DESCRIPTION	NOTES
1	CONTROL PANEL ENCLOSURE- NEMA 4, SIZED ADEQUATE TO HOUSE COMPONENTS.	
2	NAME TAG- BLACK LAMINATED PLASTIC W/ WHITE CORE, SCREW MOUNTED, 1/2" ENGRAVED LETTERS	
3	NAME TAG- BLACK LAMINATED PLASTIC W/ WHITE CORE, SCREW MOUNTED, 1/4" ENGRAVED LETTERS	
4	2-POSITION CLASS 1 DIVISION 2 EXPLOSION PROOF SELECTOR SWITCH	
5	RED CLASS 1 DIVISION 2 EXPLOSION PROOF STROBE LIGHT, RATED -40° F	
6	GREEN CLASS 1 DIVISION 2 EXPLOSION PROOF STATUS LIGHT, RATED -40° F	
STANDARD NOTES		
A) CONTRACTOR TO SELECT EXACT EQUIPMENT UTILIZED.		
REFERENCED NOTES		
1) NONE.		

DETAIL NOTES

- CONTROL PANEL SHALL BE COMPLETELY ENGINEERED, FABRICATED, WIRED, TESTED, AND READY FOR INSTALLATION. ALL WIRING SHALL BE CHECKED BY THE FABRICATOR FOR GROUNDS, SHORTS, AND CONTINUITY. ELECTRICAL DEVICES SHALL BE PUT THROUGH DUMMY OPERATIONS AT FABRICATOR'S SHOP WITH CONTROL VOLTAGE APPLIED.
- PUMP CONTROL PANEL SHALL BE CONSTRUCTED PER NEMA STANDARD IC-1 INDUSTRIAL CONTROL, UNDERWRITERS LABORATORIES STANDARD UL 508, INDUSTRIAL CONTROL EQUIPMENT, AND THE NATIONAL ELECTRIC CODE. PANEL SHALL BE UL OR ETL LISTED AS AN ASSEMBLY AND SHALL BEAR THE UL OR ETL LABEL.
- ALL CONTROL WIRING SHALL BE MINIMUM 14 AWG UNLESS OTHERWISE NOTED. ALL POWER WIRING SHALL BE A MINIMUM OF 12 AWG. USE 600V MACHINE TOOL 19 STRAND TYPE XHHW WIRE.
- SOLDER LESS TERMINALS SHALL BE USED AND EACH WIRE SHALL BE IDENTIFIED AT ALL TERMINATIONS WITH BRADY LABELS, OR EQUAL. TERMINAL BLOCKS SHALL BE SCREW TYPE, 20 AMPERE WITH WIRE DESIGNATIONS. THE TERMINAL BLOCKS SHALL BE ARRANGED TO PROVIDE AMPLE SPACE FOR CONNECTIONS.

1 WET WELL VENTILATION CONTROL PANEL LAYOUT & CONTROL DIAGRAM

E6.4 SCALE: NONE


EIC ENGINEERS, INC
ELECTRICAL ENGINEERS



6927 OLD SEWARD HWY, SUITE 200
ANCHORAGE, AK 99518
T 907.349.9712
F 907.349.9713
www.eiceng.com

RECORD DRAWING CERTIFICATE	
THESE DRAWINGS REFLECT RECORDED INFORMATION OBTAINED DURING CONSTRUCTION. INFORMATION PROVIDED HEREIN IS ACCURATE TO THE BEST OF MY KNOWLEDGE.	
NAME	DATE

SCALE:	AS SHOWN
1" = 1'	
IF NOT ONE INCH ON THIS SHEET, ADJUST SCALES ACCORDINGLY.	

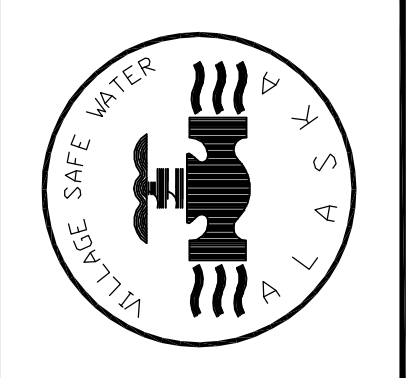

2009 WASTEWATER SYSTEM IMPROVEMENTS

ELECTRICAL POWER PLANT CONTROLS & DIAGRAMS

TULUKSAK, ALASKA

EIC ENGINEERS, INC.

PO BOX 22896 ANCHORAGE, AK 99523 PH: 907-349-1010 FAX: 907-349-1016

REVISION	BY	DATE
1	BLS	11/09/11

Project No.	Date	Designed	BLS	Drawn	BLS	Approved	EDC
	JAN 2011						