

TULUKSAK, ALASKA WASTEWATER SYSTEM IMPROVEMENTS PHASE I & II

- COMMUNITY HONEYBUCKET DUMPSITE IMPROVEMENTS
- WASTEWATER TREATMENT AND DISPOSAL AREA
- COMMUNITY LIFT STATION
- GRAVITY SEWER AND FORCEMAIN PIPING

Prepared for the Tuluksak Native Community


In Cooperation with the State of Alaska
Department of Environmental Conservation
Village Safe Water Program

REISSUED FOR CONSTRUCTION - JUNE 17, 2014



SHEET INDEX

No.	Title
	COVER SHEET
G1.1	GENERAL NOTES, DESIGN CRITERIA AND LEGEND
G1.2	2010 AND 2011 IMPROVEMENT - SHEET INDEX
G1.3	2010 AND 2011 IMPROVEMENT - SHEET INDEX
G1.4	SITE CONTROL
G2.0	HORIZONTAL AND VERTICAL CONTROL
G3.0	TEST HOLE SITE LOCATION MAP
G3.1	TEST HOLE BORING LOGS
G3.2	TEST HOLE BORING LOGS
G3.3	TEST HOLE BORING LOGS
G3.4	TEST HOLE BORING LOGS
G3.5	TEST HOLE BORING LOGS
G3.6	TEST HOLE BORING LOGS
G3.7	TEST HOLE BORING LOGS
G3.8	TEST HOLE BORING LOGS
G3.9	TEST HOLE BORING LOGS
C1.1	S1 GRAVITY SEWER PLAN AND PROFILE
C1.2	S1 GRAVITY SEWER PLAN AND PROFILE
C1.3	S2 GRAVITY SEWER PLAN AND PROFILE
C1.4	S2 GRAVITY SEWER PLAN AND PROFILE
C2.1	FM1 FORCEMAIN PLAN AND PROFILE
C2.2	FM1 FORCEMAIN PLAN AND PROFILE
C2.3	FM1 FORCEMAIN PLAN AND PROFILE
C2.4	FM1 FORCEMAIN PLAN AND PROFILE
C2.5	FM1 FORCEMAIN PLAN AND PROFILE
C2.6	FM1 FORCEMAIN PLAN AND PROFILE
C2.7	FM1 FORCEMAIN PLAN AND PROFILE
C2.8	FM1 FORCEMAIN PLAN AND PROFILE
C2.9	FM2 FORCEMAIN PLAN AND PROFILE
C2.10	FM2 CONNECTION TO SCHOOL UTILITIES
C3.1	LIFT STATION #1 SITE PLAN AND PUMP CURVE
C3.2	LIFT STATION DETAILS
C3.3	LIFT STATION PIPING PLAN AND DETAILS
C3.4	BUILDING SECTION AND DETAILS
C3.5	LIFT STATION LADDER DETAILS
C3.6	LIFT STATION HOIST AND PIPE SUPPORT DETAILS
C4.0	LAGOON SITE PLAN AND DESIGN CRITERIA
C4.1	LAGOON PLAN AND PROFILE
C4.2	LAGOON INLET STRUCTURE DETAILS
C4.3	CELL TRANSFER STRUCTURE AND OVERFLOW CHANNELS
C4.4	TYPICAL CONTROL STRUCTURE DETAILS
C4.5	LAGOON CLOSEOUT
C4.6	SEWER SERVICE PLAN
C4.7	HONEY BUCKET DISPOSAL AREA PLAN
C4.8	HONEY BUCKET DISPOSAL AREA DETAILS
C5.1	ARCTIC PIPE DETAILS
C5.2	SEWER MAIN AND MANHOLE DETAILS
C5.3	TRENCH AND SEWER CONNECTION DETAILS
C5.4	SEWER SERVICE LINE DETAILS
C5.5	ARCTIC BOX DETAILS
C5.6	ARCTIC BOX DETAILS
C5.7	FENCING DETAILS
M1-1	LIFT STATION MECHANICAL PLAN
M1-2	HYDRONIC PIPING SCHEMATIC
M1-3	POWER PLANT MECHANICAL PLAN
E1.1	ELECTRICAL LEGEND & SCHEDULE
E2.1	ELECTRICAL SITE PLAN
E3.1	ELECTRICAL NEC CLASSIFIED BOUNDARY PLANS
E4.1	ELECTRICAL CELL TRANSFER MANHOLE PLANS
E4.2	ELECTRICAL POWER PLANT PLANS
E5.1	ELECTRICAL LIFT STATION PLANS
E5.2	ELECTRICAL LIFT STATION PLANS
E6.1	ELECTRICAL LIFT STATION DIAGRAMS & PANEL SCHEDULE
E6.2	ELECTRICAL LIFT STATION CONTROLS
E6.3	ELECTRICAL POWER PLANT CONTROLS AND DIAGRAMS

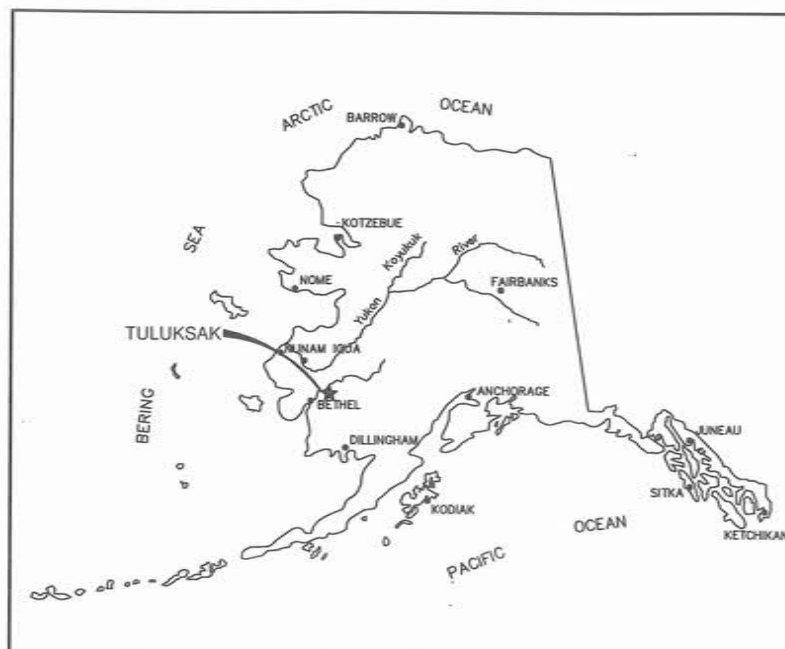

LOCATION MAP

CE₂
ENGINEERS, INC.

PO BOX 222946 ANCHORAGE, AK 99523 PH: 907-348-1010 FAX: 907-348-1015



RECORD DRAWING CERTIFICATE

THESE DRAWINGS REFLECT RECORDED
INFORMATION OBTAINED DURING
CONSTRUCTION.
INFORMATION PROVIDED HEREIN IS
ACCURATE TO THE BEST OF MY
KNOWLEDGE.

NAME

DATE

SCOPE OF THE PROJECT

THIS PLAN SET COVERS PHASE I & II OF THE TULUKSAK WASTEWATER SYSTEM IMPROVEMENTS PROJECT. WHEN FULLY IMPLEMENTED, THIS PROJECT WILL PROVIDE BURIED PIPED GRAVITY SEWER SERVING THE CORE AREA (WASHETERIA, TEEN CENTER, CLINIC, CONSTRUCTION CAMP, STORE AND SCHOOL). THE PROJECT WILL CONSTRUCT A SEWER LIFT STATION, SEWER FORCEMAIN AND WASTEWATER LAGOON WITH A HONEY BUCKET DUMP.

G:\ACAD\TULUKSAK\TLT0901 2008 Waste water disposal area\JFC Rev Apr 2014\G1.1 GENERAL NOTES LEGEND & DESIGN CRITERIA.dwg, 5/6/2014 5:42:56 PM, cmerz, \\C2main\LANIER MP C2050\LD520C PCL 6

GENERAL NOTES

A. GENERAL:

- THE PROJECT SUPERINTENDENT SHALL MAINTAIN A CLEAN SET OF "AS BUILT" RECORD DRAWINGS SHOWING THE LOCATIONS AND SWING TIES TO ALL APPURTENANCES. ALL ELEVATIONS SHALL BE MARKED ASB (AS-BUILT) WITH THE CORRECT VALUE INSERTED. DRAWINGS SHALL BE KEPT CURRENT IN RED PENCIL ON A DAILY BASIS IN A NEAT, LEGIBLE FASHION. COPIES OF THE AS-BUILT DRAWINGS SHALL BE SUBMITTED TO THE TULUKSAK NATIVE COMMUNITY AND VSW UPON COMPLETION OF CONSTRUCTION.
- THE BASIS OF BEARINGS FOR HORIZONTAL CONTROL IS SHOWN ON SHEET G2.0.
- THE BASIS OF VERTICAL CONTROL IS SHOWN ON SHEET G2.0.
- EXISTING UTILITIES ARE SHOWN IN APPROXIMATE LOCATIONS TO THE BEST KNOWLEDGE OF THE ENGINEER AT THE TIME OF DESIGN. RECORDS MAY NOT BE COMPLETELY ACCURATE. THE PROJECT SUPERINTENDENT SHALL VERIFY HORIZONTAL AND VERTICAL LOCATIONS OF UTILITIES WITHIN EACH CONSTRUCTION REACH PRIOR TO BEGINNING WORK.
- THE RECOMMENDED FINISHED FLOOR ELEVATION OF STRUCTURES IS 2.0 FEET ABOVE THE CORPS OF ENGINEERS 100-YEAR FLOOD ELEVATION. FOR THIS PROJECT THE 100-YEAR FLOOD STAGE IS ELEV. 30.3 FEET AND MINIMUM FINISHED FLOOR ELEVATION IS 32.3 FEET.

B. ARCTIC PIPE:

- CARRIER PIPE:
FORCEMAINS SHALL BE 4" AND 6" HDPE, SDR 11. GRAVITY MAINS SHALL BE 8" HDPE, SDR 17. ALL HDPE PIPING SHALL BE LISTED BY THE PPI WITH A DESIGNATION OF PE3408 AND A CELL CLASSIFICATION OF 345434C OR BETTER AS PER ASTM D3350.
- INSULATION:
ARCTIC PIPE INSULATION SHALL BE CLOSED CELL (ASTM D2341 CELL CLASSIFICATION 550874970034) URETHANE FOAM WITH A MAXIMUM K FACTOR OF 0.155 BTU-IN/HR-SF-DEG F. THE INSULATION CORE DENSITY SHALL BE BETWEEN 3.0 AND 4.0 LBS/CF. VOIDS GREATER THAN 0.05 CUBIC INCHES BEYOND 24 INCHES OF EITHER END OF THE PIPE SECTION WILL BE CAUSE FOR REJECTION OF THE PIPE. SEE TECHNICAL SPECIFICATION FOR FURTHER REQUIREMENTS.
- OUTER JACKET MATERIAL:
THE OUTER JACKET MATERIAL FOR ALL ARCTIC PIPE AND FITTINGS SHALL BE 16 GAUGE HELICAL CORRUGATED ALUMINUM PIPE WITH SEAMS THAT WILL WITHSTAND A HYDROSTATIC PRESSURE OF 5 FEET OF WATER WITH NO LEAKAGE.
- HYDRONIC HEAT TRACE:
HYDRONIC HEAT TRACE (WHERE SPECIFIED) SHALL BE A MINIMUM OF 2" DIA. HDPE, SDR 11 AND LISTED BY THE PPI WITH A DESIGNATION OF PE3408 AND A CELL CLASSIFICATION OF 345434C OR BETTER AS PER ASTM D3350.

C. CLEARING AND GRUBBING:

- THE CONSTRUCTION CREW SHALL REMOVE ALL TREES, BRUSH, VEGETATIVE MAT, AND OTHER OBJECTIONABLE MATERIAL WITHIN THE ROAD FOOTPRINT. WHERE DIKE FILL IS TO BE PLACED OVER SOFT, SATURATED TUNDRA, THE GROUND SURFACE MAY BE PREPARED BY CUTTING BRUSH AND TREES WITHIN THE DIKE FOOTPRINT AND GRUBBING AN 8-FOOT WIDE KEYWAY ALONG THE CENTER OF THE DIKE.
- ALL GRUBBED MATERIAL SHALL BE DISPOSED OF IN THE DESIGNATED SPOILS DEPOSITION AREA OR THE BORROW AREA EAST OF THE LAGOON AND WITHIN THE PROJECT PROPERTY. A PORTION OF THE GRUBBED ORGANIC TOPSOIL SHALL BE STOCKPILED AND LATER USED TO COVER AND REVEGETATE THE DIKE SIDESLOPES, BORROW AREA, AND OTHER AREAS DISTURBED BY CONSTRUCTION.

D. EARTHWORK:

- SIDE WALLS OF EXCAVATIONS SHALL BE SLOPED OR SUFFICIENTLY BRACED IN CONFORMANCE WITH SECTION 05.160 OF THE STATE OF ALASKA DEPARTMENT OF LABOR STANDARDS AND THE LATEST FEDERAL OSHA EXCAVATION AND TRENCHING STANDARDS. IF IT IS NECESSARY TO LEAVE AN OPEN EXCAVATION UNATTENDED, THE OPEN EXCAVATION SHALL BE ADEQUATELY SIGNED AND BARRICADED TO WARN RESIDENTS OF THE HAZARD.
- COMPACTION OF STRUCTURAL FOUNDATIONS, PIPE ZONE MATERIALS, EMBANKMENTS AND ROADWAYS SHALL BE ACCOMPLISHED USING A MINIMUM OF THREE (3) PASSES WITH A 15,000 POUND VIBRATORY DRUM COMPACTOR. EMBANKMENT FILL SHALL BE COMPACTED IN MAXIMUM 8-INCH LIFTS PRIOR TO SUBSEQUENT PLACEMENT OF FILL. SUPERINTENDENT SHALL COORDINATE AN INITIAL EFFORT INSPECTION WITH THE ENGINEER AND VSW TO VERIFY THE ACTUAL COMPACTIVE EFFORT REQUIRED. IF LIGHTER EQUIPMENT IS SUBSTITUTED THE LIFT DEPTH AND NUMBER OF PASSES SHALL BE ADJUSTED TO OBTAIN THE SAME COMPACTIVE EFFORT.
- WHERE EXCAVATIONS ENCOUNTER GROUNDWATER, DEWATERING SHALL BE IMPLEMENTED AND TEMPORARY SHORING MAY BE REQUIRED TO STABILIZE THE WALLS WHILE EXCESS WATER IS ALLOWED TO DRAIN OR PUMPED OUT OF THE EXCAVATION.

E. PIPELINE TESTING:

- GENERAL:
ALL TESTING SHALL BE IN CONFORMANCE WITH THE FOLLOWING REQUIREMENTS:
ALL TESTS SHALL BE WITNESSED BY A REPRESENTATIVE DESIGNATED BY THE COMMUNITY. UPON SUCCESSFUL COMPLETION OF A TEST THE RESULTS OF THE TEST SHALL BE DOCUMENTED ON A TEST FORM AND ACKNOWLEDGED BY SIGNATURE OF THE COMMUNITY'S REPRESENTATIVE WITNESSING THE TEST AND BY THE PROJECT SUPERINTENDENT. THE SUPERINTENDENTS RED LINED AS-BUILT DRAWINGS SHALL ALSO NOTE THE TIME AND DATE OF THE TEST, AS WELL AS THE NAME OF THE COMMUNITY'S WITNESS, FOR EACH PIPE SEGMENT TESTED.
- FORCEMAIN TESTING:
PERFORM HYDROSTATIC TESTING OF ALL FORCEMAIN PIPING. FILL THE LINES WITH POTABLE WATER AND REMOVE AIR POCKETS PRIOR TO STARTING THE TEST. PRESSURIZE TO 100 PSI AND LEAVE FOR A MINIMUM OF 1 HOUR. AFTER THIS INITIAL PERIOD, ADD WATER TO BRING THE PRESSURE UP TO 100 PSI AND BEGIN A ONE HOUR TEST. THERE SHALL BE NO LOSS IN PRESSURE DURING THE 1 HOUR TEST FOR THE PIPING TO BE ACCEPTED.
- GRAVITY SEWER MAIN TESTING:
THE CONSTRUCTION CREW SHALL CLEAN AND FLUSH ALL SANITARY SEWER MAINS PRIOR TO VISUAL INSPECTION (LAMPING) AND PRESSURE TESTING.
EACH REACH OF SEWER MAIN SHALL BE LAMPED, MANHOLE TO MANHOLE, WITH A HIGH INTENSITY LIGHT AND LARGE MIRROR. SEGMENTS NOT LAMPING TO 7/8 OF A FULL MOON SHALL BE REALIGNED AND/OR REGRADED AS NECESSARY TO MEET THE 7/8 MOON REQUIREMENT.
ALL SEGMENTS OF COMPLETED SEWER MAIN AND OUTFALL SHALL BE PRESSURE TESTED FROM MANHOLE TO MANHOLE OR TERMINUS TO TERMINUS WITH AIR AT THE END OF CONSTRUCTION (PRIOR TO CONNECTING SEWER SERVICE LINES). AIR SHALL BE SLOWLY SUPPLIED TO THE PLUGGED PIPE INSTALLATION UNTIL THE INTERNAL AIR PRESSURE REACHES 4.0 POUNDS PER SQUARE INCH (PSI) GREATER THAN THE AVERAGE BACK PRESSURE OF ANY GROUNDWATER THAT MAY SUBMERGE THE PIPE. AT LEAST TWO (2) MINUTES SHALL BE ALLOWED FOR TEMPERATURE STABILIZATION BEFORE PROCEEDING WITH THE TEST. AT THE END OF THE STABILIZATION PERIOD THE AIR PRESSURE SHALL BE ADJUSTED TO THE TEST PRESSURE AND THE 10 MINUTE TEST PERIOD SHALL BEGIN. THE MAXIMUM ALLOWABLE PRESSURE DROP FOR ANY SEWER MAIN SEGMENT DURING THE 10 MINUTE TEST PERIOD SHALL BE 2.7 PSI.
- SEWER MANHOLE TESTING:

F. REVEGETATION SPECIFICATION:

- THE ENTIRE AREA DISTURBED BY CONSTRUCTION SHALL BE REVEGETATED AS QUICKLY AS GOOD CONSTRUCTION PRACTICE ALLOWS. AREAS TO BE REVEGETATED SHALL FIRST BE COVERED WITH A MINIMUM 6-INCH LAYER OF FRIABLE, LOOSELY PLACED TOPSOIL, FREE OF DEBRIS. THE FOLLOWING SEED MIXTURE AND FERTILIZER APPLICATION RATES SHALL BE APPLIED:

SEED	NAME/TYPE	RATE	METHOD
Red Fescue	Arctic Red	14 lbs/acre	Broadcast
Bering Hairgrass	Norcoast	16 lbs/acre	Broadcast
Rye Grass	Annual	2 lbs/acre	Broadcast
FERTILIZER	20-20-20	180 lbs/acre	Broadcast

- EROSION CONTROL FABRIC:
USE BIODEGRADABLE JUTE MESH WITH A LIFE OF 1-2 YEARS. INSTALL ON SLOPES AFTER SEEDING AND ANCHOR SECURELY WITH GROUND STAPLES.

G. HONEYBUCKET DUMPSITE CLOSURE:

- THE DUMPSITE CLOSURE WILL OCCUR ONCE THE NEW LAGOON IS OPERATIONAL.

PROJECT DESCRIPTION

THIS PROJECT CONSTRUCTS A TWO-CELL FACULTATIVE PERCOLATION LAGOON, A LIFT STATION, AND A SEWAGE FORCE MAIN BETWEEN THE LAGOON AND LIFT STATION.

THE LAGOON SYSTEM WILL PROVIDE WASTEWATER TREATMENT OF DOMESTIC WASTEWATER. TREATMENT INVOLVES A COMBINATION OF PROCESSES THAT REMOVE SOLIDS, BIODEGRADABLE ORGANICS, AND PATHOGENS FROM THE WATER PRIOR TO ITS RELEASE INTO THE PERCOLATION CELL.

THE FIRST CELL WILL RECEIVE RAW WASTEWATER VIA A FORCE MAIN FROM A LIFT STATION LOCATED WITHIN THE VILLAGE. CELL 1 IS DESIGNED TO PROVIDE A QUIESCENT ZONE FOR DIGESTION OF ORGANIC MATTER AND BIODEGRADABLE CONTAMINANTS BY BOTH AEROBIC AND ANAEROBIC MICROBES AND STORAGE FOR NON-DIGESTIBLE SOLIDS. A MAX. LOADING RATE OF 38#/ACRE-DAY. CELL 1 IS HYDRAULICALLY CONNECTED TO CELL 2 WITH AN INTERCONNECTING DUAL PIPE CONTROL STRUCTURE DESIGNED TO MAINTAIN A LIQUID DEPTH OF NO MORE THAN 7.0 FEET IN CELL 1. CELL 2 IS DESIGNED TO PERCOLATE WITH A MAXIMUM HYDRAULIC APPLICATION RATE OF 0.9 GAL/SF-DAY.

WORK SUMMARY

CONSTRUCT A DUAL-CELL, LINED WASTEWATER TREATMENT LAGOON AND ASSOCIATED HYDRAULIC CONTROL FEATURES.

INSTALL A FORCEMAIN AND GRAVITY SEWER MAIN FROM THE CORE PART OF THE COMMUNITY TO THE PROPOSED FACULTATIVE LAGOON SITE.

INSTALL A CENTRAL COMMUNITY LIFT STATION AND HONEYBUCKET DUMPING FACILITY.

INSTALL A HYDRONIC HEAT TRACE AND WASTE HEAT RECOVER SYSTEM TO PROVIDE FREEZE PROTECTION OF THE LAGOON FORCEMAIN AND HONEYBUCKET DUMPING STATION.

SYSTEM STARTUP

LIFT STATION STARTUP

AFTER INSTALLATION OF ALL NEW LIFT STATION EQUIPMENT, THE PROJECT SUPERINTENDENT SHALL START AND FIELD TEST EACH PUMP UNIT TO DEMONSTRATE ITS ABILITY TO PUMP WITHOUT EXCESSIVE VIBRATION, MOTOR OVERLOADING OR OVERHEATING. EACH PUMP SHALL BE OPERATED FOR A SUFFICIENT PERIOD OF TIME TO PERMIT THOROUGH OBSERVATION OF ALL PUMP COMPONENTS. THE PROJECT SUPERINTENDENT SHALL VERIFY THE PROPER SEQUENCING AND OPERATION OF ALL CONTROLS.

AFTER THE LIFT STATION INSTALLATION IS COMPLETE BUT PRIOR TO DRAWING WASTEWATER INTO THE WET WELL, THE SUPERINTENDENT SHALL DETERMINE THE DISCHARGE RATE OF EACH OF THE SUBMERSIBLE WASTEWATER PUMPS, INDEPENDENTLY AND IN TANDEM. THESE MEASUREMENTS SHALL BE RECORDED ON THE RECORD DRAWINGS FOR FUTURE REFERENCE.

THE DISCHARGE PUMPING RATE SHALL BE DETERMINED BY MEASURING DRAWDOWN OF POTABLE WATER PLACED IN THE WET WELL. ALL LIFT STATION TESTING SHALL BE PERFORMED WITH POTABLE WATER.

LAGOON STARTUP

SAMPLING WELLS SHOULD BE USED TO DETERMINE THE INITIAL NITRATE LEVELS PRIOR TO USE OF THE LAGOON SYSTEM.

STORM WATER MANAGEMENT PLAN


CONSTRUCTION SHALL BE PLANNED AND EXECUTED TO EXPEDITIOUSLY COMPLETE THE PROJECT WHILE MAINTAINING THE CONSTRUCTION SITE IN A MANNER THAT REDUCES THE POTENTIAL FOR CONTAMINATED STORM RUNOFF. SPECIFIC STEPS ARE TO INCLUDE THE FOLLOWING:

- PRIOR TO CONSTRUCTION DEVELOP A STORMWATER POLLUTION PREVENTION PLAN (SWPPP), WHICH UTILIZES THE BEST MANAGEMENT PRACTICES (BMPs) AND IS IN COMPLIANCE WITH THE NATIONAL POLLUTANT DISCHARGE ELIMINATION SYSTEM (NPDES) AND THE ALASKA CONSTRUCTION GENERAL PERMIT NO. AKR10000. THIS PLAN MUST BE APPROVED BY THE STATE OF ALASKA ADEC.
- FILE A NOTICE OF INTENT (NOI) WITH THE EPA A MINIMUM OF 7-DAYS PRIOR TO THE START OF CONSTRUCTION.
- CONSTRUCTOR SHALL BE VIGILANT WITH IMPLEMENTATION OF THE PLAN.

LEGEND

EXISTING		PROPOSED		DESCRIPTION
PLAN VIEW	PROFILE VIEW	PLAN VIEW	PROFILE VIEW	
				GROUND SURFACE
				DRAINAGE/WATER FEATURE
				SEWER FORCE MAIN, LIFT STATION, REDUCER, AND DOUBLE WYE CLEANOUT
				SEWER SERVICE LINE
				CULVERT
				BURIED ELECTRICAL LINE
				BURIED FUEL OIL LINE
				BURIED TELEPHONE LINE
				OVERHEAD ELECTRIC
				EASEMENT
				UTILITY POLE
				FENCE
				ROADS AND TRAVELED WAYS
				CONTOUR LINE
				R.O.W. (RIGHT-OF-WAY)
				SHORELINE
				TREES AND/OR BRUSH
				STRUCTURE
				GROUND PROFILE
				PROPERTY LINE
				SECTION LINE
				BLM BRASS CAPPED MONUMENT
				BENCHMARK
				SPOT ELEVATION
				REBAR - ABILITY SURVEY POINT NO.
				YELLOW PLASTIC CAP (REBAR)
				TRACT NUMBER
				LOT NUMBER
				HEAT TRACE POWER SUPPLY

SECTION AND DETAIL DESIGNATIONS

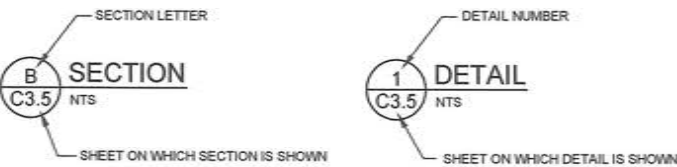

MATERIAL QUANTITIES

ITEM	ESTIMATED QUANTITY
LAGOON OVERBURDEN	7,500 CU. YDS.
LAGOON CUT/FILL VOLUME	40,000 CU. YDS.
6" ARCTIC FORCEMAIN	3,740 L.F.
4" ARCTIC FORCEMAIN	511 L.F.
8" ARCTIC SEWER MAIN	1,351 L.F.
FORCEMAIN CLEAN OUT ASSEMBLY	8 EACH

ABBREVIATIONS

A.P.	ANGLE POINT (HORIZONTAL)
CMP	CORRUGATED METAL PIPE
C.O.E.	CORPS OF ENGINEERS
CULV.	CULVERT
FF	FINISHED FLOOR ELEVATION
G.B.	GRADE BREAK (VERTICAL)
G.V.	GATE VALVE
HDPE	HIGH DENSITY POLYETHYLENE PIPE
INV.	INVERT
IPS	IRON PIPE SIZE (INDUSTRY STANDARD OUTSIDE PIPE DIAMETER)
LF	LINEAR FEET
MFR	MANUFACTURER
MH	MANHOLE
SDR	SIDE DIMENSION RATIO
SHT.	SHEET
SS	STAINLESS STEEL
STA.	STATION
TOJ	TOP OF PIPE JACKET
V.B.	VALVE BOX
WS	WATER SURFACE

RECORD DRAWING CERTIFICATE
THESE DRAWINGS REFLECT RECORDED INFORMATION OBTAINED DURING CONSTRUCTION. INFORMATION PROVIDED HEREIN IS ACCURATE TO THE BEST OF MY KNOWLEDGE.

SCALE: AS SHOWN
DATE: _____
NAME: _____



2010-11 WASTEWATER SYSTEM IMPROVEMENTS
GENERAL NOTES, DESIGN CRITERIA AND LEGEND
TULUKSAK, ALASKA




REVISION	DATE	BY

Project No. _____
Date: APRIL 2014
Designed: LAP
Drawn: DDR
Approved: LAP

Sheet No. G1.1

G:\ACAD\TULUKSAK\T10901 2008 Waste water disposal area\TFC Rev Apr 2014\G1.2 - G1.3 SHEET INDEX.dwg, 5/6/2014 6:33:57 PM, cmerz, \\ce2main\LANIER NP C2050\LD520C PCL 6

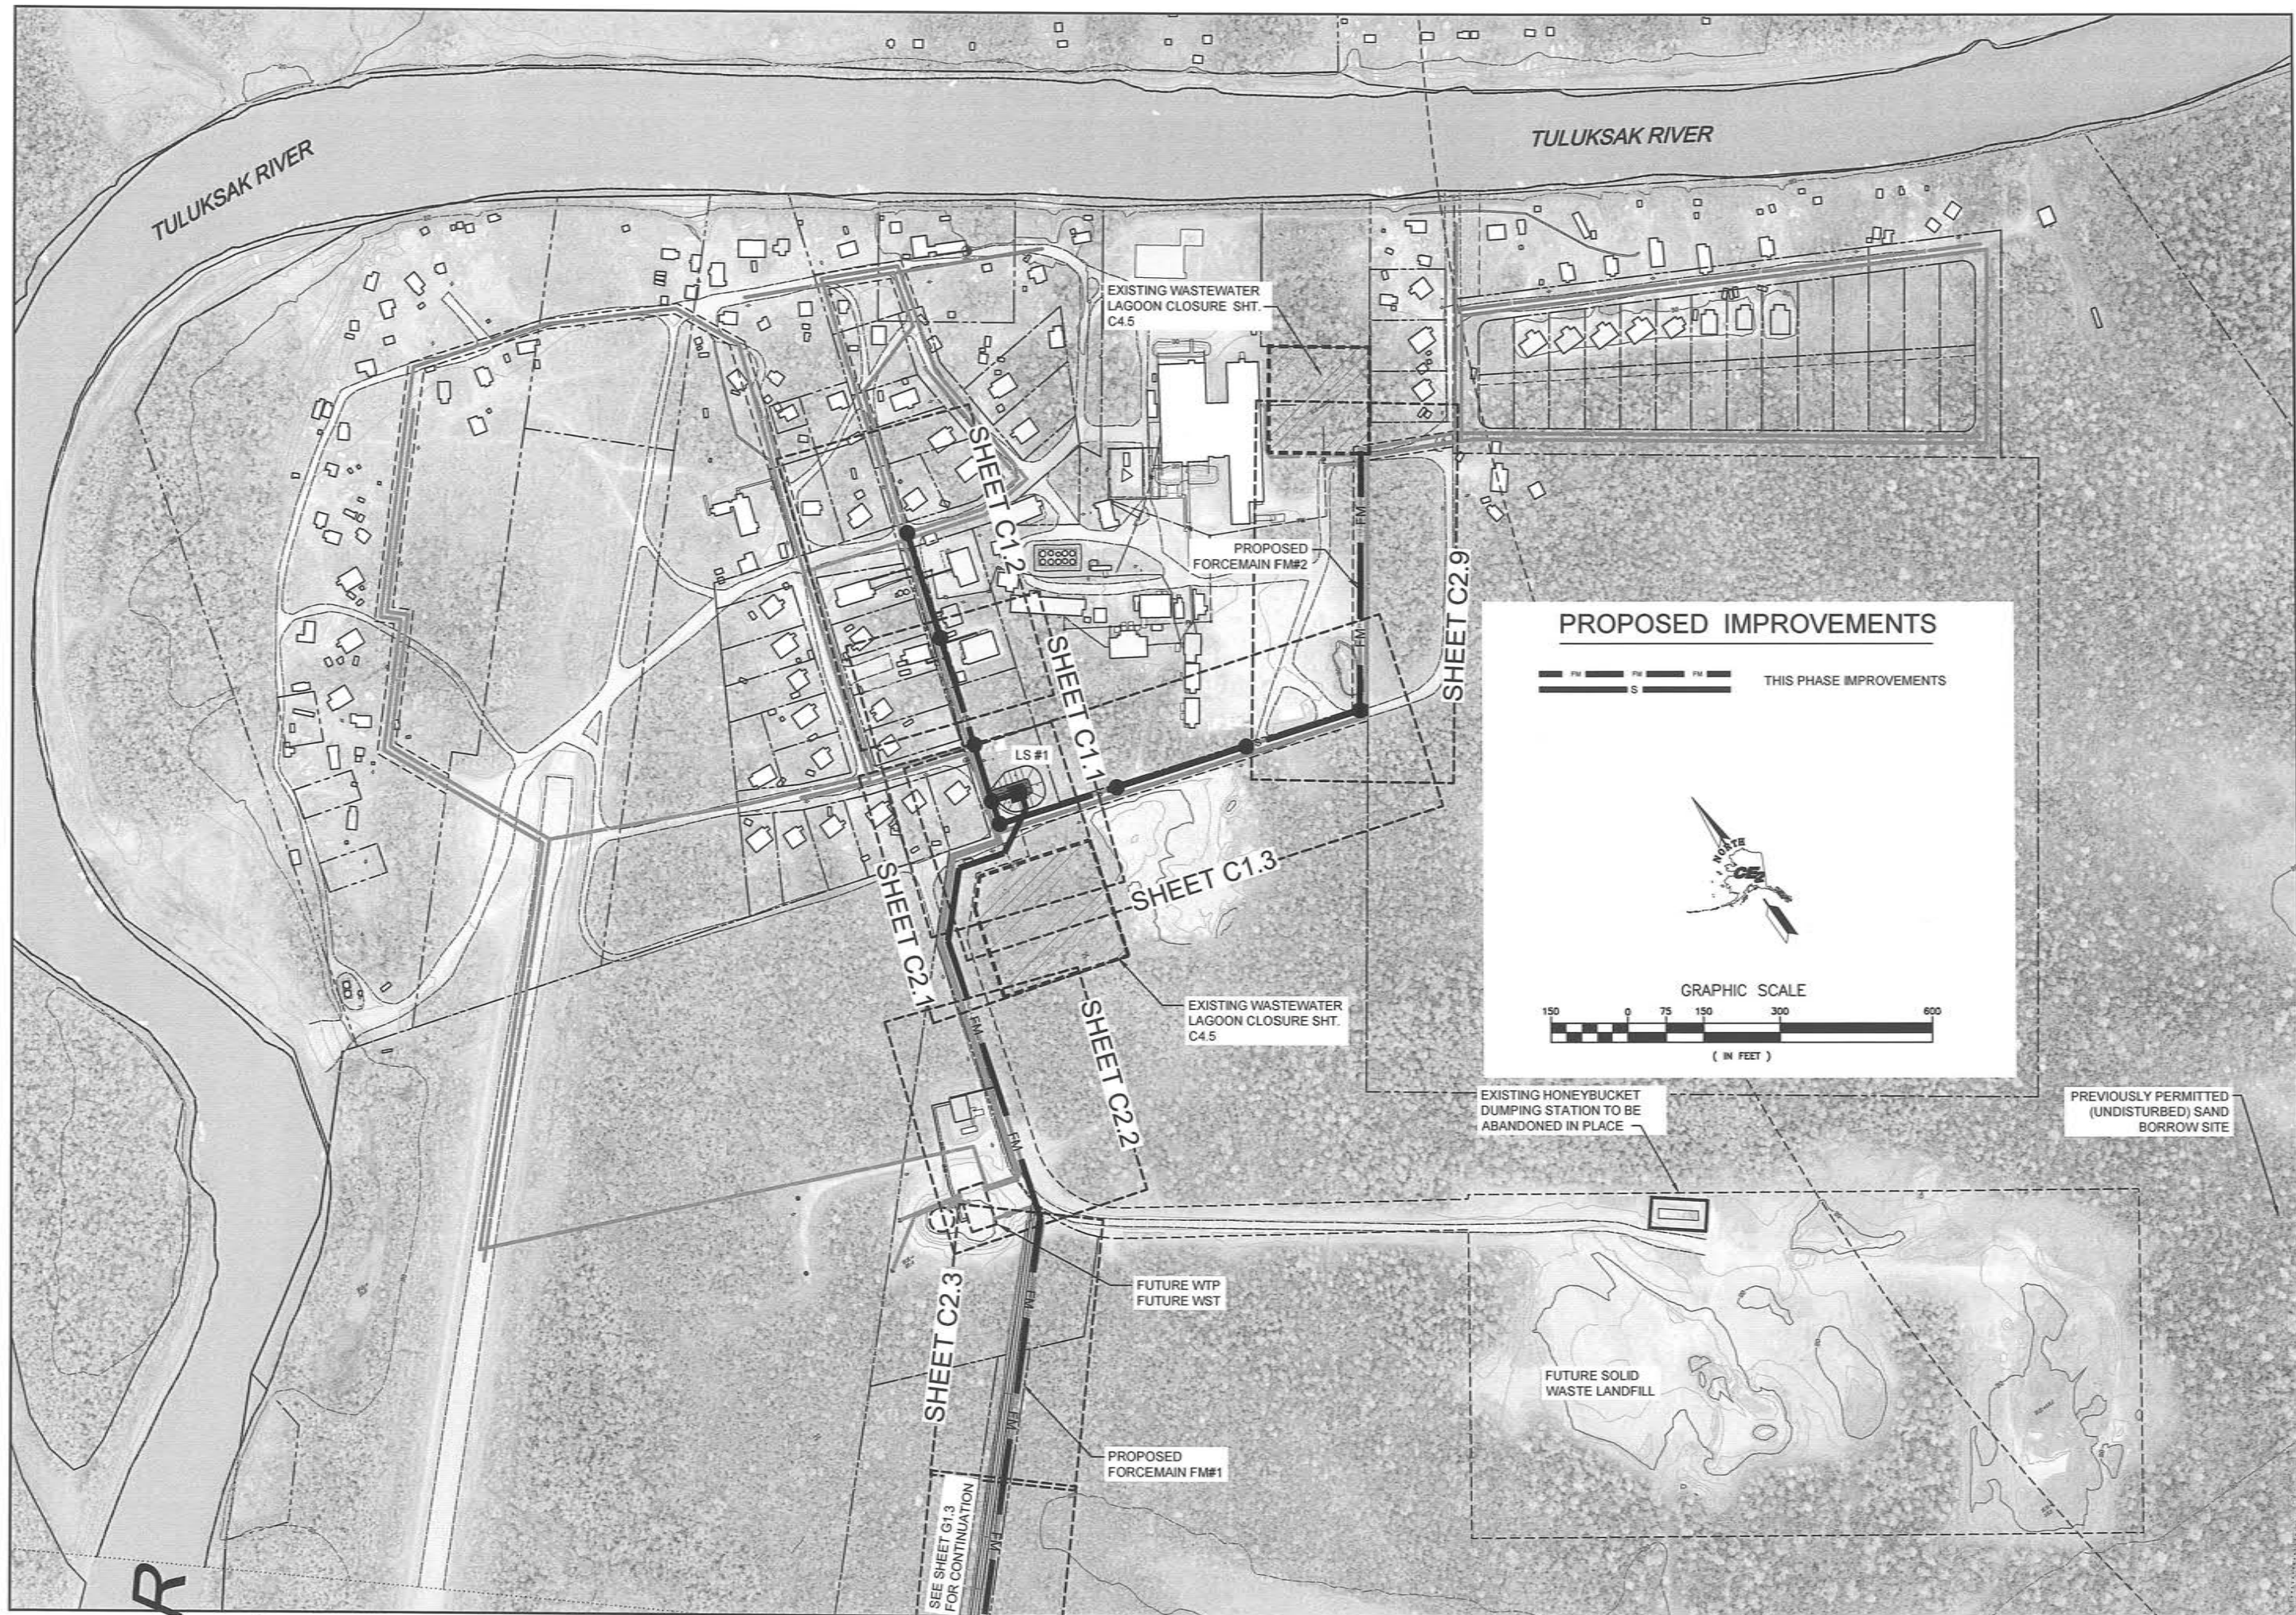

RECORD DRAWING CERTIFICATE
THESE DRAWINGS REFLECT RECORDED
INFORMATION OBTAINED DURING
CONSTRUCTION. INFORMATION PROVIDED
HEREIN IS ACCURATE TO THE BEST OF MY
KNOWLEDGE.

SCALE:
AS SHOWN
BASED ON DESIGN
GRAPHIC SCALE
IF NOT ONE INCH ON
DRAWING EQUALS
FOOT ON GROUND
SCALE ACCORDINGLY

5/7/14

2010-11 WASTEWATER
SYSTEM IMPROVEMENTS

2010 AND 2011
IMPROVEMENTS
SHEET INDEX
TULUKSAK, ALASKA

CFE2
ENGINEERS, INC.
PO BOX 22296 ANCHORAGE, AK 99523 PH 807-949-0100 FAX 807-949-0105

Project No.	BY	DATE

REVISION	DATE

Project No.	Date	Designed	Drawn	Approved
	APRIL 2014	LAP	CM/AJW	LAP

 
Sheet No.
G1.2

G:\ACAD\TULUKSAK\TLT0901 2008 Waste water disposal area\JFC Rev June 2014\G1.2 - G1.3 SHEET INDEX.dwg, 6/12/2014 12:51:23 PM, cmerz, \\ce2main\LANIER MP C2050\LD520C PCL 6



PHASE IMPROVEMENTS

THIS PHASE IMPROVEMENTS
PREVIOUS PHASE IMPROVEMENTS



RECORD DRAWING CERTIFICATE
THESE DRAWINGS REFLECT RECORDED
INFORMATION OBTAINED DURING
CONSTRUCTION. INFORMATION PROVIDED
HEREIN IS ACCURATE TO THE BEST OF MY
KNOWLEDGE.

SCALE:
AS SHOWN
DATE: 6/12/2014
BY: CM
ORIGINAL DRAWING
IF NOT ONE HUNDRED
SCALE, ACCURATELY

NAME
DATE

2010-11 WASTEWATER
SYSTEM IMPROVEMENTS

2010 AND 2011
IMPROVEMENTS
SHEET INDEX

TULUKSAK, ALASKA

CE2
ENGINEERS, INC.

PO BOX 23266 ANCHORAGE, AK 99523 PH: 907-346-0101 FAX: 907-346-1015

REVISION	BY	DATE
LAGOON RELOCATION	CM	4/14
PERC. CELL RESIZED	CM	6/14

Project No. _____

Date: APRIL 2014

Designed: MRE

Drawn: CM/LAW

Approved: MRE

Sheet No. G1.3

PROJECT CONTROL (GROUND) COORDINATE TABLE

Number	Northing	Easting	Elevation	Row Desc
3000	2594492.041	1824290.109	23.43	BASE BLK BRASS CAP COR. 2, USS 875, (1960)
3001	2594442.588	1824701.089	27.26	BLK BRASS CAP LOT 3, COR. 2, USS 4435 (1991)
3002	2594542.493	1824021.080	28.34	2" ALUMINUM CAP -1975-TSA LT-186714 (1997)
3003	2594692.476	1818857.680	27.93	BLK BRASS CAP LOT 1, COR. 4, USS 3797 (1960 & 1991)
3004	2594687.470	1819688.122	26.32	BLK BRASS CAP LOT 1, COR. 3, USS 3797 (1960 & 1991)
3013	2594543.462	1825409.100	28.30	RED PLASTIC CAP (DOVL) (POLINTOCO)
3015	2594298.755	1825060.781	27.97	1" REBAR
3016	2594887.953	1825402.475	23.25	BLK BRASS CAP COR. 3, LOT 2, USS 4435 (1991)
3017	2594373.211	1825472.689	28.29	BLK BRASS CAP COR. 2, LOT 2, USS 4435 (1991) BURIED 0.7'
3018	2594649.098	1825500.544	28.29	POWER POLE SPIKE TBM
3019	2594846.307	1825673.705	27.78	BLK BRASS CAP COR. 1, LOT 2, USS 4435 (1991)
3020	2594834.269	1825461.451	28.42	BLK BRASS CAP COR. 3, LOT 5, COR. 6, LOT 1, USS 4435 (1991)
3021	2594714.793	1825371.604	28.49	1" REBAR
3022	2594785.016	1825155.676	24.62	BLK BRASS CAP COR. 4, LOT 1, COR. 4, LOT 4, USS 4435 (1991)
3023	2595271.081	1824542.942	24.86	1" REBAR
3025	2594151.080	1823704.447	28.24	RED PLASTIC CAP (DOVL), 5' ABOVE GROUND
3030	2594829.251	1823518.867	24.55	RED PLASTIC CAP (DOVL) BURIED, 1'
3031	2594817.777	1823506.447	24.03	5/8" REBAR (BENT SHOT BASE) -CL-2+125
3033	2594521.291	1824207.672	24.42	BLK BRASS CAP COR. 2, LOT 1, USS 3797 (1960)
3051	2595171.691	1824112.749	24.23	1.5" ALUMINUM CAP (IN ROAD)
3052	2595455.259	1824925.012	30.25	ARMORY-TBM-SPK AT CORP OF ENG. HIGH WATER MARK (SIGN)
3053	2595541.654	1824636.014	29.63	POWER POLE SPIKE TBM
3054	2595254.918	1824736.236	28.21	SET SPIKE IN ROAD

LEGEND

3015 TYPICAL CONTROL POINT IDENTIFIER

3015 TYPICAL CONTROL POINT IDENTIFIER WITH CONVENTIONAL DIFFERENTIAL ELEVATION

SURVEY NOTES

THIS SURVEY WAS PERFORMED WITH TRIMBLE MODEL 4700 RECEIVERS AND TRIMBLE GEOMATICS OFFICE VERSION 1.5 PROCESSING SOFTWARE. THE HORIZONTAL POSITIONS WERE DETERMINED WITH REAL TIME KINETIC METHODS BASED UPON POINT NUMBER 3000, THE BASE STATION POINT. SEE LOCAL PROJECT COORDINATE TABLE FOR POINT 3000 LOCAL PROJECT COORDINATES. POINT 3000 ALSO HAD "NAD 83 AK STATE PLANE ZONE 7" COORDINATES OF N=2594539.253 USFT, E=1824246.230 USFT, OR N=790817.126 M, E=646031.363 M, DETERMINED BY POST PROCESSING 3 STATIC SESSIONS WITH 5 OTHER CORS STATIONS.

THIS SURVEY'S COORDINATES ARE US SURVEY FEET BASED ON ALASKA DATUM PROJECT AKSAS 51795, TULUKSAK AIRPORT, 1957 SURVEY CONTROL, SUBMITTED BY STANLEY E. PONSNESS, LSJ6714. THIS SURVEY WAS CALIBRATED OR LOCALIZED TO SAID SURVEY BY A LEAST SQUARES BEST FIT USING SIX OF THE FORMER SURVEY CONTROL POINTS SPREAD AROUND THIS PROJECT. ALL SIX POINTS OF THIS SURVEY FIT WITHIN 0.1 USFT OF THE FORMER SURVEY PUBLISHED VALUES. THIS SURVEY THEREFORE MAINTAINS THE FORMER SURVEY HORIZONTAL GROUND DISTANCES AND LOCAL PLANE BEARINGS AS ORIENTED TO THE MEAN HAD 83 GEODETIC BEARING OF N 340°42'E BETWEEN MONUMENTS SET TO DEFINE THE CENTERLINE OF A PLANNED FUTURE RUNWAY CENTERLINE. SAID BEARINGS WERE REPORTED TO BE DETERMINED FROM GPS SURVEY METHODS ORIGINATING AT NGS B ORDER GPS STATION "CABIN" LOCATED NEAR BETHEL.

VERTICAL DATUM IS NAVD83 BASED UPON THIS SURVEY'S AFOREMENTIONED POST PROCESSING. THE ELIPSOIDAL HEIGHT OF POINT NO. 3000 WAS DETERMINED TO BE 87.010 USFT, AND THE ORTHOMETRIC HEIGHT (ABOVE GEOID OR APPROXIMATE MEAN SEA LEVEL) WAS HELD AS 23.834 USFT.

CONVENTIONAL DIFFERENTIAL LEVEL LOOPS WERE USED TO CONTROL THE VERTICAL POSITIONS, USING THE ELEVATION OF 23.834 USFT OF POINT NO. 3000 AS THE BASIS OF ELEVATION.

US ARMY CORP. OF ENGINEERS FLOOD WATER GAUGE ELEVATION 0.0 IS ELEVATION 28.33 (THIS SURVEY) AS DETERMINED AT THE GAUGE SIGN ON THE CLASSROOM BUILDING IN FRONT OF THE HIGH SCHOOL. THE FLOOD WATER GAUGE SIGN LISTS THE HIGH WATER MARK AT 3.9 FEET AND THE RECOMMENDED BUILDING ELEVATION AT 5.9 FEET.

TBM 7 EL=30.40'
HIGHEST PART OF 30"x30" CONC.
WIND SOCK BASE (TIPPED OVER)

TBM 6 EL=29.81'
SPIKE IN SOUTH SIDE OF
POWER POLE W/ TRANSFORMER

TBM 4 EL=29.63'
6" SPIKE IN NORTH SIDE OF POWER POLE

TBM 8 EL=26.30'
6" SPIKE, 1' ABOVE GROUND IN SOUTH SIDE OF POWER POLE
C.O.E. HIGH WATER MARK ON SAME POLE, EL=30.24'

TBM 13 EL=29.22'
SPIKE IN SE SIDE OF POWER POLE (#852),
1' ABOVE GROUND

TBM 14 EL=29.99'
SPIKE IN SOUTH SIDE OF POWER POLE (#870),
2' ABOVE GROUND

TBM 15 EL=28.43'
SPIKE IN SOUTH SIDE OF POWER POLE

TBM FINISH FLOOR
TULUKSAK NATIVE STORE
EL=28.74'

TBM 9 EL=26.30'
SPIKE IN WEST SIDE OF POWER POLE
1' ABOVE GROUND

TBM SPIKE EL=25.43'
NORTH SIDE OF POWER POLE
1' ABOVE GROUND

REQUIRE EASEMENT

USS 4435
LOT 2

LONG TERM LEASE FROM
TULUKSAMUIT CORP
19-

DATE 10-20-03
SCALE 1"=300'
SHEET 1 OF 1
JOB No. 3698
DRAWING: 3698TULUKSAK

TULUKSAK
SURVEY CONTROL DIAGRAM

ABILITY SURVEYS

GARY D. NELSON, P.L.S.
(907)235-2440
152 DEHEL AVE., HOMER, ALASKA

RECORD DRAWING CERTIFICATE
THESE DRAWINGS REFLECT RECORDED
INFORMATION OBTAINED DURING
CONSTRUCTION. INFORMATION PROVIDED
HEREIN IS ACCURATE TO THE BEST OF MY
KNOWLEDGE.

SCALE:
AS SHOWN



2010-11 WASTEWATER
SYSTEM IMPROVEMENTS

HORIZONTAL AND
VERTICAL CONTROL

TULUKSAK, ALASKA

CE2
ENGINEERS, INC.
PO BOX 2534 ANCHORAGE, AK 99523 PH: 907-346-1816 FAX: 907-346-1815


REVISION	BY	DATE

Project No.	Date	Designed	LAP
	JUNE 2009		
		Drawn	ABILITY
			LAP

Sheet No.

G2.0

TULUKSAK RIVER

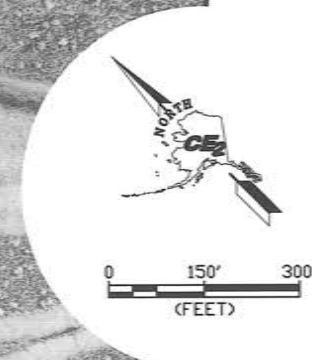

 2002 DOWL BORE HOLE LOCATION - 1-10
 2003 DM&A TEST PIT LOCATION - TP1-TP-5
 (PROPOSED WTP & WST)
 2004 DM&A TEST PIT LOCATION- UC1-3
 2008 CE2 PERCOLATION TEST HOLES
 PT1-4
 2010 CE2 PERCOLATION TEST HOLES
 A-G
 2013 CE2 TEST HOLES TLT1 - TLT4

REVISION	BY	DATE
LAGOON RELOCATION	CM	4/14
PERC. CELL RESIZED	CM	6/14

Project No. _____	Date APRIL 2014	Designed MRE	Drawn CM	Approved MRE
-------------------	-----------------	--------------	----------	--------------

Sheet No. **G3.0**

**2010-11 WASTEWATER
SYSTEM IMPROVEMENTS**

**TEST HOLE SITE
LOCATION MAP**


TULUKSAK, ALASKA




RECORD DRAWING CERTIFICATE

THESE DRAWINGS REFLECT RECORDED
INFORMATION OBTAINED DURING
CONSTRUCTION. INFORMATION PROVIDED
HEREIN IS ACCURATE TO THE BEST OF MY
KNOWLEDGE.


NAME _____ DATE _____

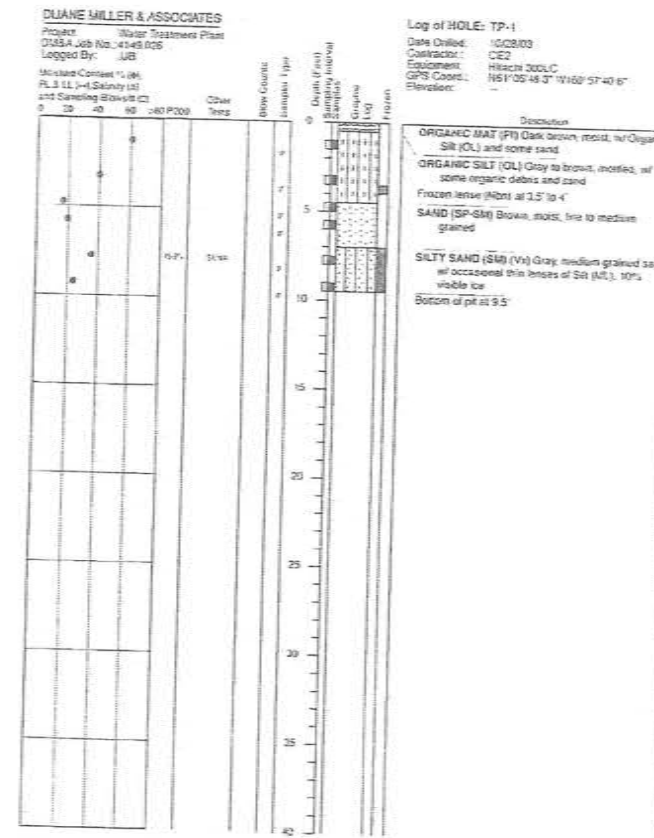


LOG of TEST PIT TP-1
Water & Sewer
Tuluklak, Alaska
Plate 2

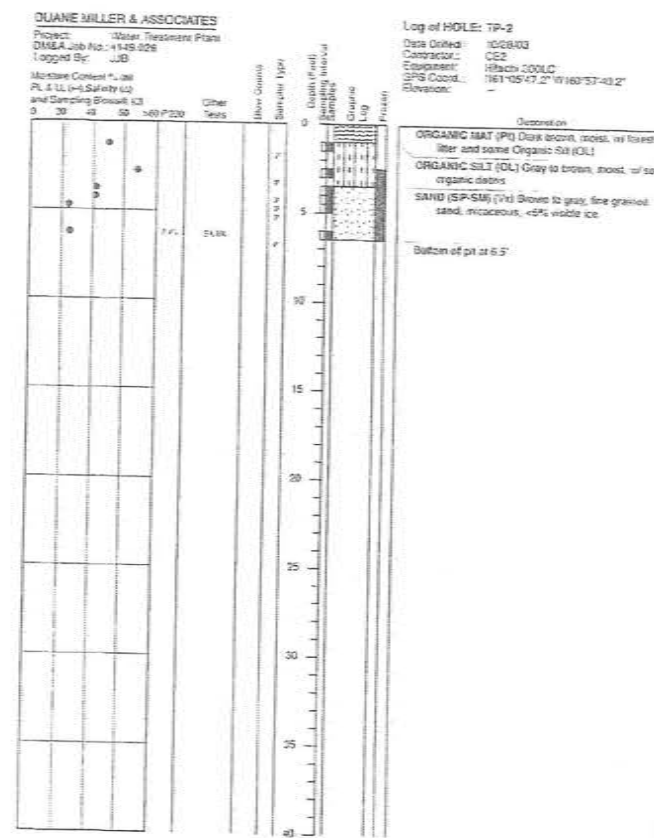


LOG of TEST PIT TP-2
Water & Sewer
Tuluklak, Alaska
Plate 3

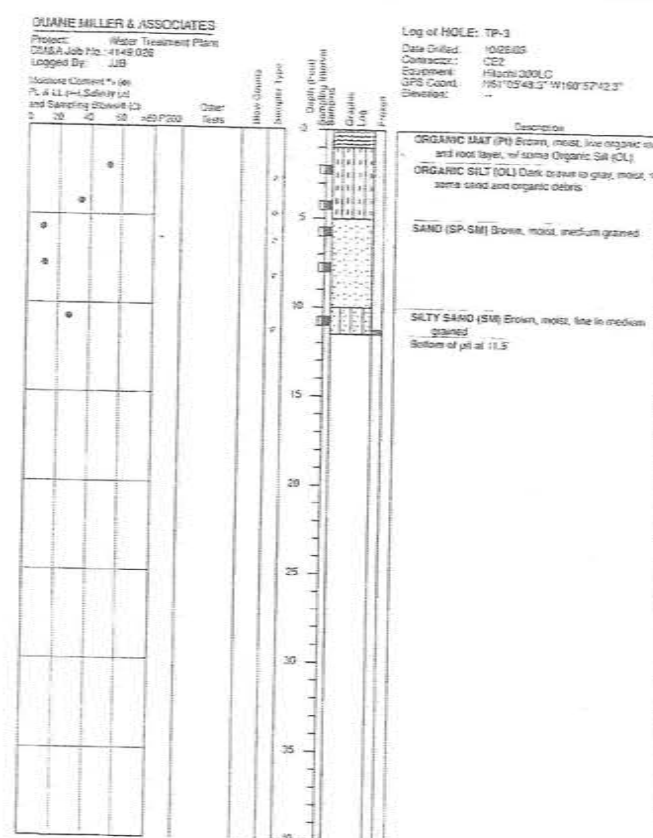


LOG of TEST PIT TP-3
Water & Sewer
Tuluklak, Alaska
Plate 4

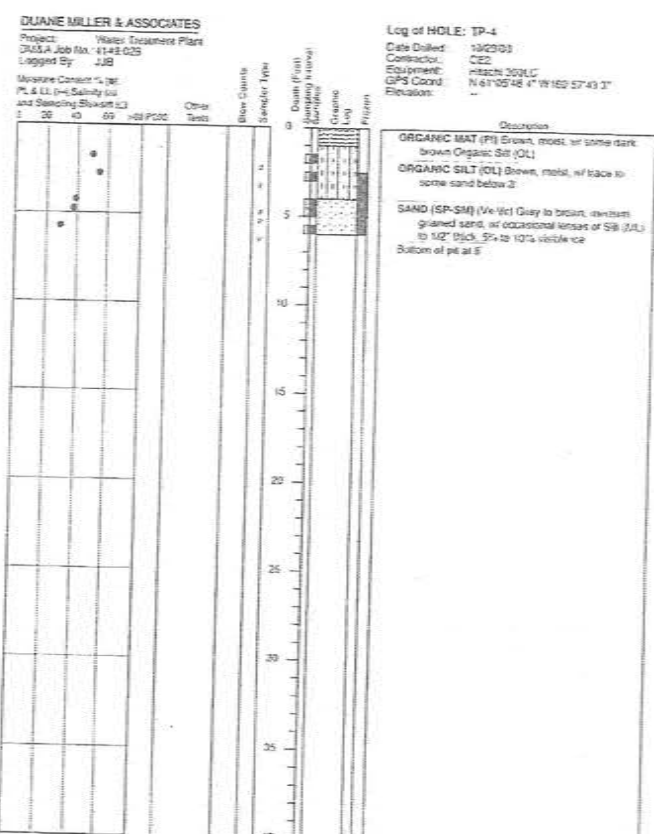

LOG of TEST PIT TP-4
Water & Sewer
Tuluklak, Alaska
Plate 5

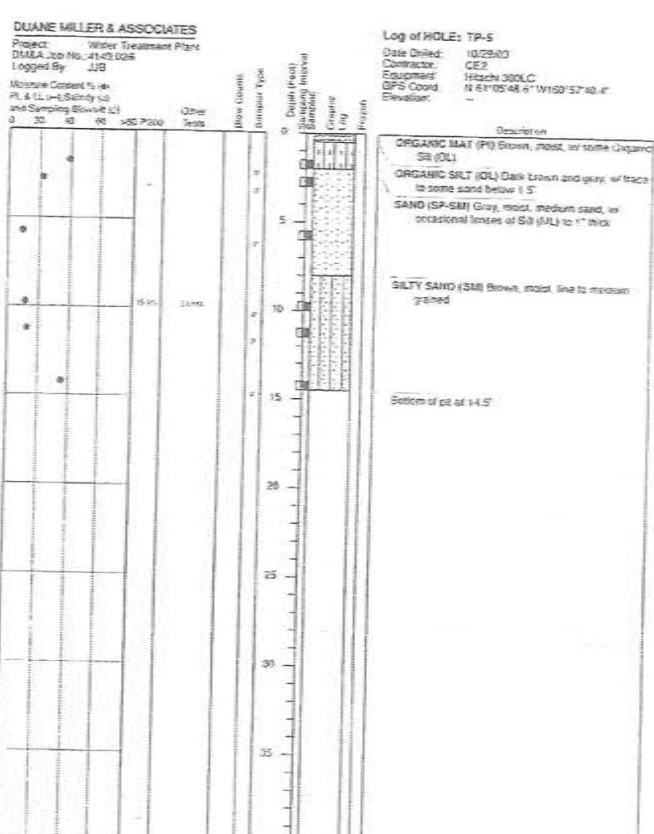

LOG of TEST PIT TP-5
Water & Sewer
Tuluklak, Alaska
Plate 6

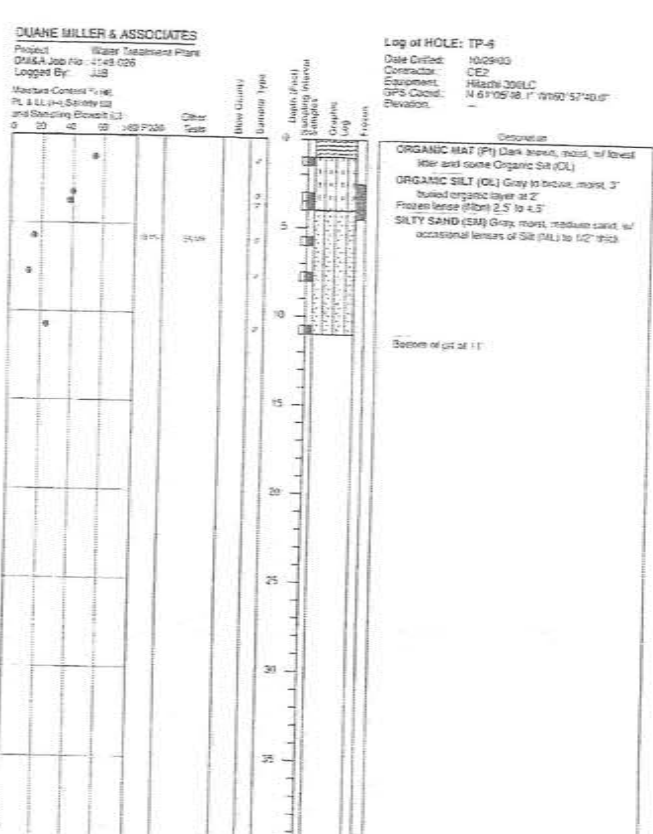

LOG of TEST PIT TP-6
Water & Sewer
Tuluklak, Alaska
Plate 7

RECORD DRAWING CERTIFICATE
THESE DRAWINGS REFLECT RECORDED INFORMATION OBTAINED DURING CONSTRUCTION. INFORMATION PROVIDED HEREIN IS ACCURATE TO THE BEST OF MY KNOWLEDGE.

DATE: _____
NAME: _____

SCALE: 1" = 10'-0"

1" = 10'-0"

1" = 10'-0"

2010-11 WASTEWATER SYSTEM IMPROVEMENTS

TEST HOLE BORING LOGS


TULUKSAK, ALASKA

CE2 ENGINEERS, INC.
PO BOX 22046 ANCHORAGE, AK 99521 PH 907-546-0108 FAX 907-546-1015

Project No. _____
Date: JUNE 2009
Designed: LAP
Drawn: OM
Approved: LAP

Sheet No. G3.1

DUANE MILLER & ASSOCIATES
Project: Water & Sewer
DMA Job No.: 4149.026
Logged By: N. Lutzky

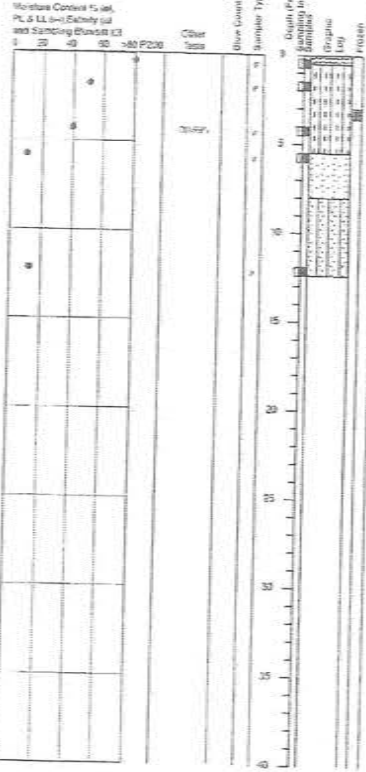


Log of HOLE: UC-1
Date Drilled: 12/16/04
Contractor: CE2
Equipment: Hach EX300LC
GPS Coord.: N 61°05' 51.7" W 160°57' 58.7"
Elevation:

ORGANIC MAT (PM) Dark brown, moist, fibrous, w/ some Organic Silt (OL)
ORGANIC SILT (OL) Dark brown, moist, w/ fibrous organics, no trace of sand at 2' to 3.5'
SAND (SP-SM) Brown, moist, medium grained
SILTY SAND (SM) Brown, moist, medium grained

LOG of TEST PIT UC-1
Water & Sewer
Tulaksak, Alaska
Date: February 2005

Plate 8

DUANE MILLER & ASSOCIATES
Project: Water & Sewer
DMA Job No.: 4149.026
Logged By: N. Lutzky

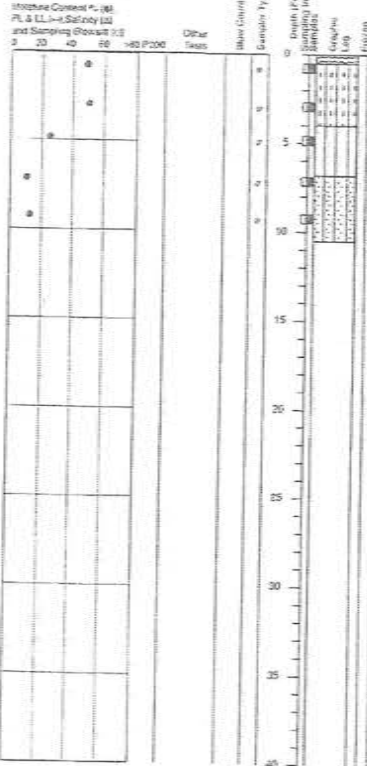


Log of HOLE: UC-2
Date Drilled: 12/16/04
Contractor: CE2
Equipment: Hach EX300LC
GPS Coord.: N 61°05' 51.6" W 160°57' 7.1"
Elevation:

ORGANIC MAT (PM) Dark brown, moist
ORGANIC SILT (OL) Dark brown, moist, w/ trace sand and some organic debris
SILT (ML) Gray to brown, moist, w/ trace fine sand
SILTY SAND (SM) Brown, moist, medium grained

LOG of TEST PIT UC-2
Water & Sewer
Tulaksak, Alaska
Date: February 2005

Plate 9

DUANE MILLER & ASSOCIATES
Project: Water & Sewer
DMA Job No.: 4149.026
Logged By: N. Lutzky

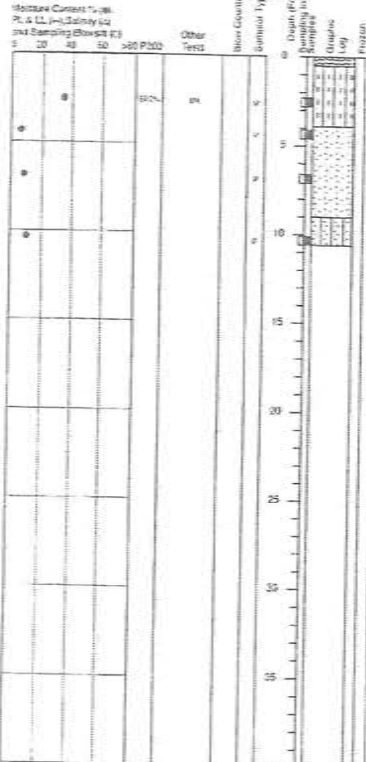


Log of HOLE: UC-3
Date Drilled: 12/16/04
Contractor: CE2
Equipment: Hach EX300LC
GPS Coord.: N 61°05' 52.2" W 160°57' 7.0"
Elevation:

ORGANIC MAT (PM) Brown, moist
ORGANIC SILT (OL) Dark brown, moist, w/ trace sand and some organic debris
SAND (SP-SM) Brown, moist, w/ trace fine gravel
SILTY SAND (SM) Brown, moist, medium grained

LOG of TEST PIT UC-3
Water & Sewer
Tulaksak, Alaska
Date: February 2005

Plate 10

DUANE MILLER & ASSOCIATES
Project: Water & Sewer
DMA Job No.: 4149.026
Logged By: N. Lutzky

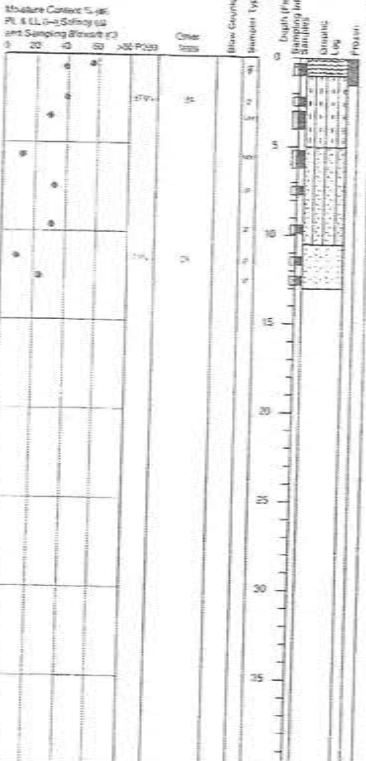

Log of HOLE: LF-1
Date Drilled: 12/16/04
Contractor: CE2
Equipment: Hach EX300LC
GPS Coord.: N 61°05' 55.6" W 160°57' 1.0"
Elevation:

ORGANIC MAT (PM) Dark brown, moist, fibrous, w/ some Organic Silt (OL)
ORGANIC SILT (OL) Dark brown, moist, w/ some organic debris, unbroken below 1.5'
SILTY SAND (SM) Brown, moist, fine to medium grained
SAND (SP-SM) Brown, moist, fine grained

LOG of TEST PIT LF-1
Water & Sewer
Tulaksak, Alaska
Date: February 2005

Plate 11

DUANE MILLER & ASSOCIATES
Project: Water & Sewer
DMA Job No.: 4149.026
Logged By: N. Lutzky




Log of HOLE: LF-2
Date Drilled: 12/16/04
Contractor: CE2
Equipment: Hach EX300LC
GPS Coord.: N 61°05' 52.6" W 160°57' 16.1"
Elevation:

ORGANIC MAT (PM) Dark brown, moist, fibrous, w/ some Organic Silt (OL)
ORGANIC SILT (OL) Brown, moist
SAND (SP-SM) Brown, moist, fine to medium grained
SILTY SAND (SM) Brown, moist, fine grained, w/ trace organics
SAND (SP) Brown, moist, medium grained

LOG of TEST PIT LF-2
Water & Sewer
Tulaksak, Alaska
Date: February 2005

Plate 12

DUANE MILLER & ASSOCIATES
Project: Water & Sewer
DMA Job No.: 4149.026
Logged By: N. Lutzky

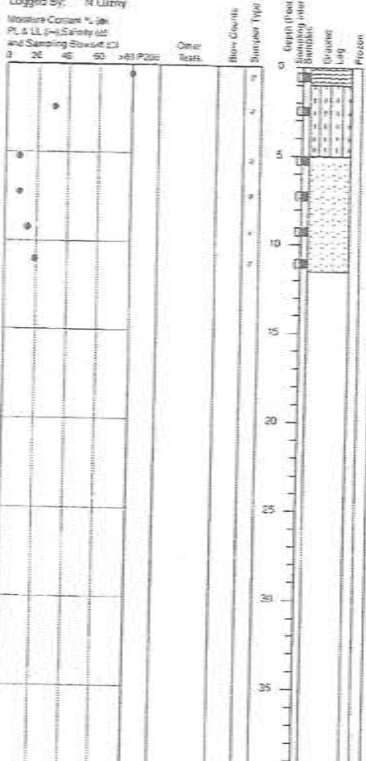

Log of HOLE: LF-3
Date Drilled: 12/16/04
Contractor: CE2
Equipment: Hach EX300LC
GPS Coord.: N 61°05' 54.7" W 160°57' 22.2"
Elevation:


ORGANIC MAT (PM) Dark brown, moist, fibrous, w/ some Organic Silt (OL)
ORGANIC SILT (OL) Brown, moist, w/ some organic debris
SAND (SP) Brown, moist, w/ occasional clasts of Silty Sand (SM)

LOG of TEST PIT LF-3
Water & Sewer
Tulaksak, Alaska
Date: February 2005

Plate 13

RECORD DRAWING CERTIFICATE
THESE DRAWINGS REFLECT RECORDED INFORMATION OBTAINED DURING CONSTRUCTION. INFORMATION PROVIDED HEREIN IS ACCURATE TO THE BEST OF MY KNOWLEDGE.
NAME: _____ DATE: _____

SCALE: 1" = 10'-0"

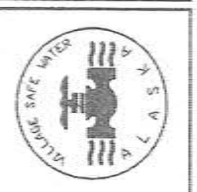

2010-11 WASTEWATER SYSTEM IMPROVEMENTS
TEST HOLE BORING LOGS
TULAKS, ALASKA

CE2 ENGINEERS, INC.
PO BOX 22046 ANCHORAGE, AK 99522 PH 907-465-0018 FAX 907-309-1015

REVISION	BY	DATE


Project No.: _____
Date: JUNE 2009
Designed: LAP
Drawn: CMA
Approved: LAP

Sheet No.: G3.2

DUANE MILLER & ASSOCIATES

Project: Water & Sewer
 DMSA Job No.: 4149.025
 Logged By: N. Lunny

Moisture Content % (at)
 PL & LL (w/1.5) (at)
 and Sampling Blows (at)

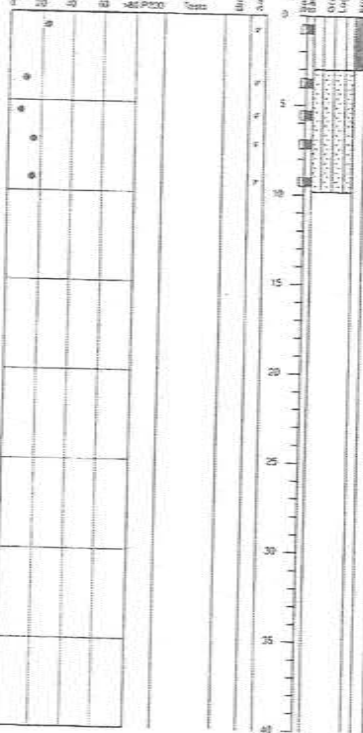

Log of HOLE: S-1

Date Drilled: 12/15/04
 Contractor: CE2
 Equipment: Hitachi EX300LC
 GPS Coord: N 61°05.655' W 160°57'33.5"
 Elevation:

Description:
 SANDY SILT (ML) (fine brown, w/ medium grained sand)
 SILTY SAND (SM) Brown, moist, fine to medium grained

Refusal on penetration at 9.8'

Duane Miller & Associates
 Job No.: 4149.025
 Date: February 2005


LOG of TEST PIT S-1
Water & Sewer
Tuluksoak, Alaska

Plate 14

DUANE MILLER & ASSOCIATES

Project: Water & Sewer
 DMSA Job No.: 4149.025
 Logged By: N. Lunny

Moisture Content % (at)
 PL & LL (w/1.5) (at)
 and Sampling Blows (at)

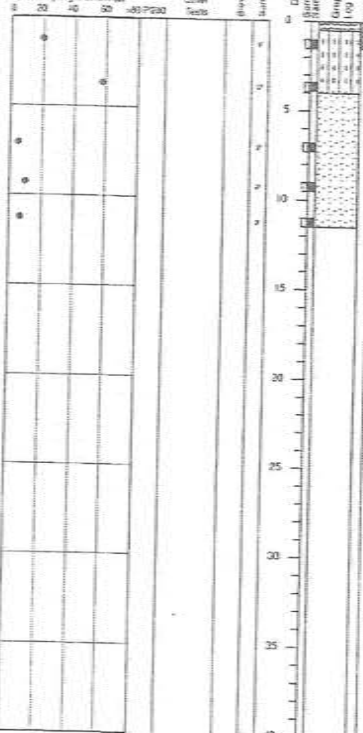

Log of HOLE: S-2

Date Drilled: 12/16/04
 Contractor: CE2
 Equipment: Hitachi EX300LC
 GPS Coord: N 61°05.793' W 160°57.541"
 Elevation:

Description:
 ORGANIC MAT (FI) (NO) Dark brown, fibrous organics w/ some Organic Silt (OL)
 ORGANIC SILT (OL) (fine) Dark brown, w/ some organic debris, unfrozen below 1.5'
 SAND (SP-SM) Brown, medium grained sand, w/ trace fine gravel

Duane Miller & Associates
 Job No.: 4149.025
 Date: February 2005


LOG of TEST PIT S-2
Water & Sewer
Tuluksoak, Alaska

Plate 15

DUANE MILLER & ASSOCIATES

Project: Water & Sewer
 DMSA Job No.: 4149.025
 Logged By: N. Lunny

Moisture Content % (at)
 PL & LL (w/1.5) (at)
 and Sampling Blows (at)

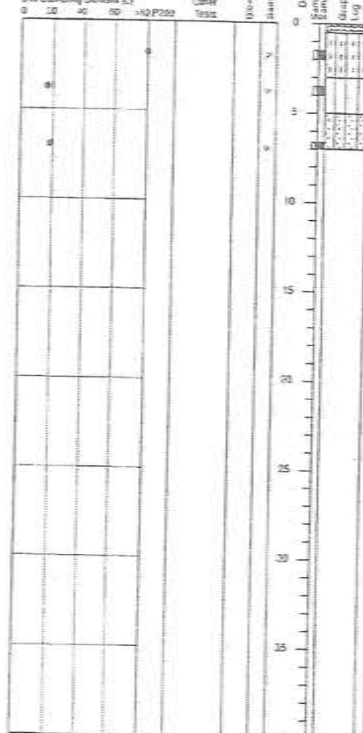

Log of HOLE: S-3

Date Drilled: 12/17/04
 Contractor: CE2
 Equipment: Hitachi EX300LC
 GPS Coord: N 61°05.793' W 160°57.550"
 Elevation:

Description:
 ORGANIC MAT (FI) (NO) Dark brown, fibrous, w/ some Organic Silt (OL)
 ORGANIC SILT (OL) (fine) Dark brown, w/ some fibrous organics, unfrozen below 1.5'
 SILT (ML) Brown to gray, moist, w/ some fine sand and trace organics
 SILTY SAND (SM) Brown, moist, fine grained
 Refusal on penetration at 9.8'

Duane Miller & Associates
 Job No.: 4149.025
 Date: February 2005


LOG of TEST PIT S-3
Water & Sewer
Tuluksoak, Alaska

Plate 16

DUANE MILLER & ASSOCIATES

Project: Water & Sewer
 DMSA Job No.: 4149.025
 Logged By: N. Lunny

Moisture Content % (at)
 PL & LL (w/1.5) (at)
 and Sampling Blows (at)

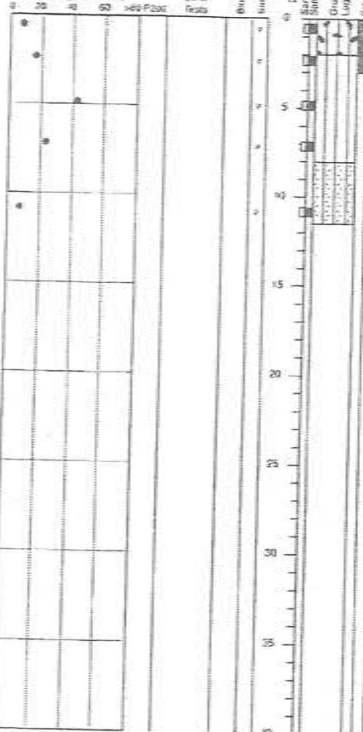

Log of HOLE: S-4

Date Drilled: 12/17/04
 Contractor: CE2
 Equipment: Hitachi EX300LC
 GPS Coord: N 61°05.955' W 160°57'47.8"
 Elevation:

Description:
 SILTY GRAVEL (GM) (fine) Brown, fine gravel, occasional clasts to 1" diameter, w/ medium to coarse sand, very well bonded
 SILT (ML) (fine) Gray to brown, w/ some sand and trace fine gravel, unfrozen below 3'
 SILTY SAND (SM) Brown, moist, fine grained

Duane Miller & Associates
 Job No.: 4149.025
 Date: February 2005


LOG of TEST PIT S-4
Water & Sewer
Tuluksoak, Alaska

Plate 17

DUANE MILLER & ASSOCIATES

Project: Water & Sewer
 DMSA Job No.: 4149.025
 Logged By: N. Lunny

Moisture Content % (at)
 PL & LL (w/1.5) (at)
 and Sampling Blows (at)

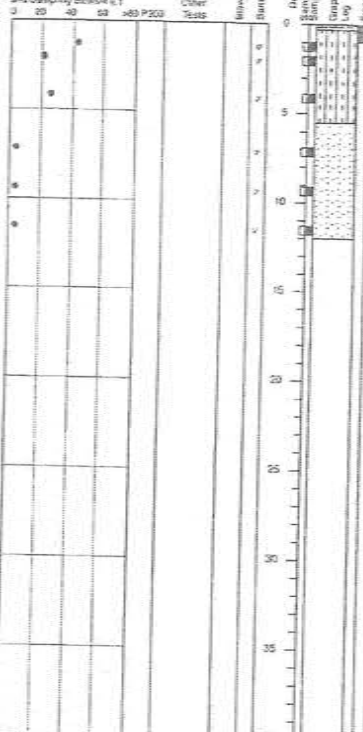

Log of HOLE: S-5

Date Drilled: 12/17/04
 Contractor: CE2
 Equipment: Hitachi EX300LC
 GPS Coord: N 61°05.024' W 160°57'51.7"
 Elevation:

Description:
 ORGANIC MAT (FI) (NO) Dark brown, w/ some Organic Silt (OL)
 ORGANIC SILT (OL) (fine) Dark brown, w/ some fibrous organics, unfrozen below 1.5'
 SAND (SP-SM) Brown, moist, fine to medium grained

Duane Miller & Associates
 Job No.: 4149.025
 Date: February 2005


LOG of TEST PIT S-5
Water & Sewer
Tuluksoak, Alaska

Plate 18

DUANE MILLER & ASSOCIATES

Project: Water & Sewer
 DMSA Job No.: 4149.025
 Logged By: N. Lunny

Moisture Content % (at)
 PL & LL (w/1.5) (at)
 and Sampling Blows (at)

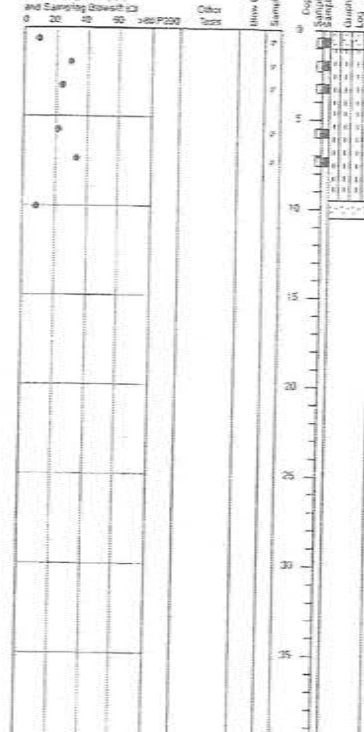

Log of HOLE: S-6

Date Drilled: 12/17/04
 Contractor: CE2
 Equipment: Hitachi EX300LC
 GPS Coord: N 61°05.035' W 160°57'58.5"
 Elevation:

Description:
 SILTY SAND (SM) (fine) Brown, medium to coarse sand, w/ some fine to coarse gravel
 ORGANIC SILT (OL) (fine) Brown, w/ organics and woody debris, trace gravel at 5'
 SAND (SP-SM) Brown, moist, fine grained

Duane Miller & Associates
 Job No.: 4149.025
 Date: February 2005

LOG of TEST PIT S-6
Water & Sewer
Tuluksoak, Alaska

Plate 19

RECORD DRAWING CERTIFICATE
 THESE DRAWINGS REFLECT RECORDED
 INFORMATION OBTAINED DURING
 CONSTRUCTION. INFORMATION PROVIDED
 HEREIN IS ACCURATE TO THE BEST OF MY
 KNOWLEDGE.

SCALE:
 1" = 10' (VERTICAL)
 1" = 100' (HORIZONTAL)
 IF NOT SHOWN, USE
 THESE SCALES ACCORDINGLY



2010-11 WASTEWATER
 SYSTEM IMPROVEMENTS
 TEST HOLE
 BORING LOGS
 TULUKSAK, ALASKA


CE2
 ENGINEERS, INC.
 P.O. BOX 22944 ANCHORAGE, AK 99521 TEL 307-408-1000 FAX 307-408-1015

REVISION	BY	DATE


Project No.: _____
 Date: JUN 2009
 Designed: LAP
 Drawn: CM
 Approved: LAP

Sheet No.


G3.3

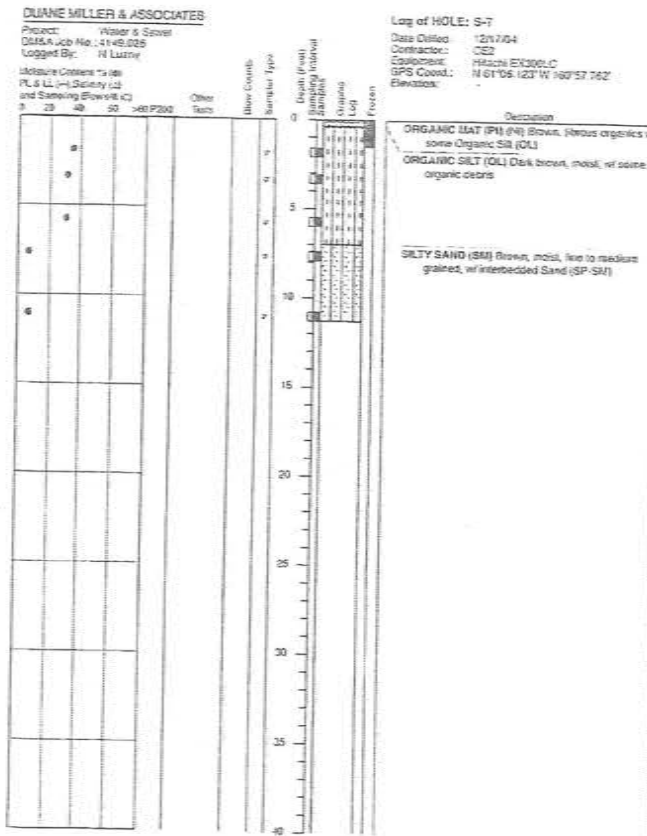


LOG of TEST PIT S-7
 Water & Sewer
 Tuluksak, Alaska
 Plate 20

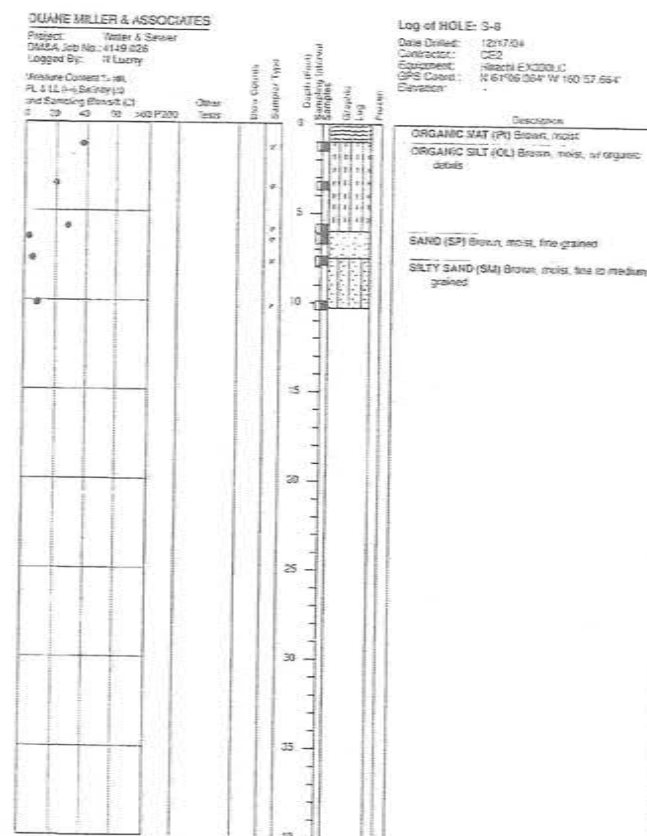


LOG of TEST PIT S-8
 Water & Sewer
 Tuluksak, Alaska
 Plate 21

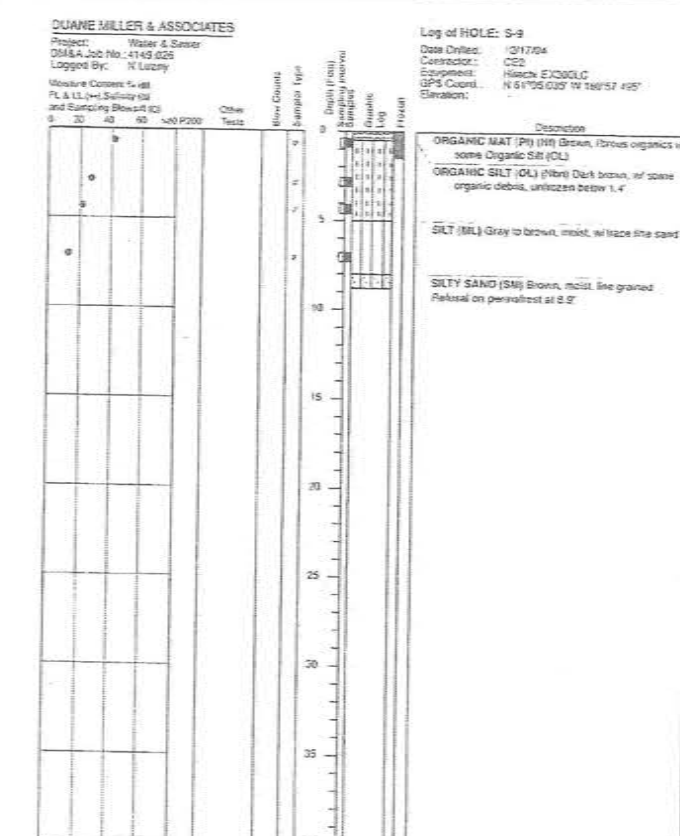


LOG of TEST PIT S-9
 Water & Sewer
 Tuluksak, Alaska
 Plate 22

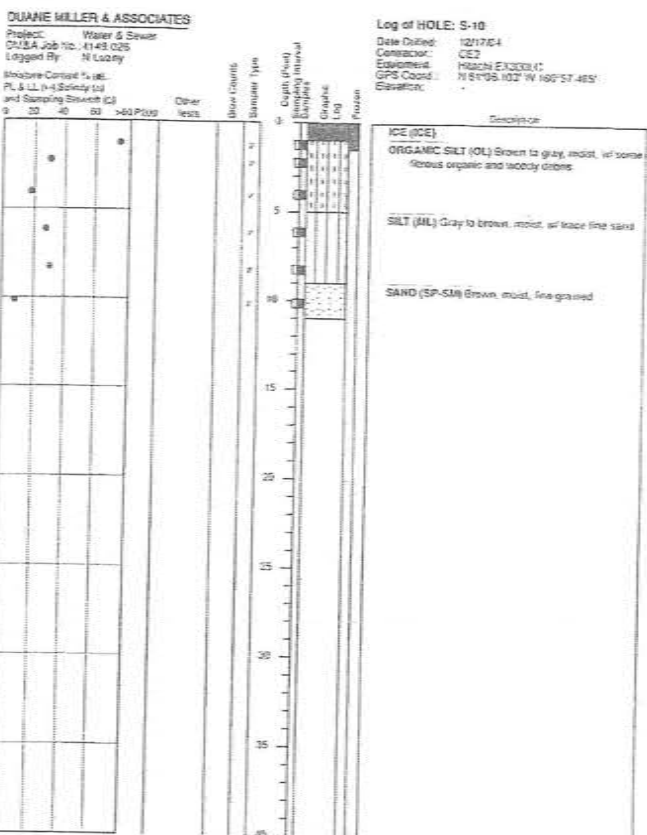

LOG of TEST PIT S-10
 Water & Sewer
 Tuluksak, Alaska
 Plate 23

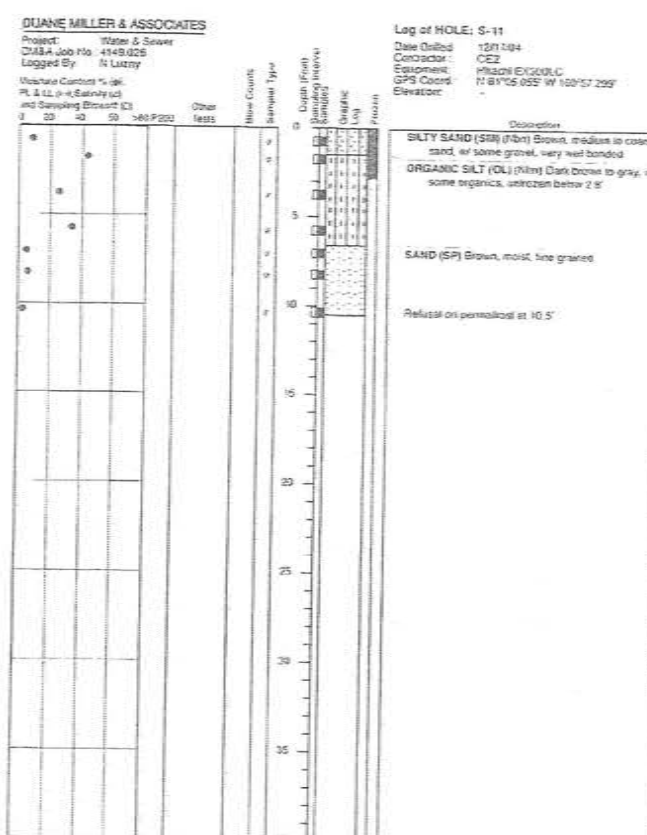

LOG of TEST PIT S-11
 Water & Sewer
 Tuluksak, Alaska
 Plate 24

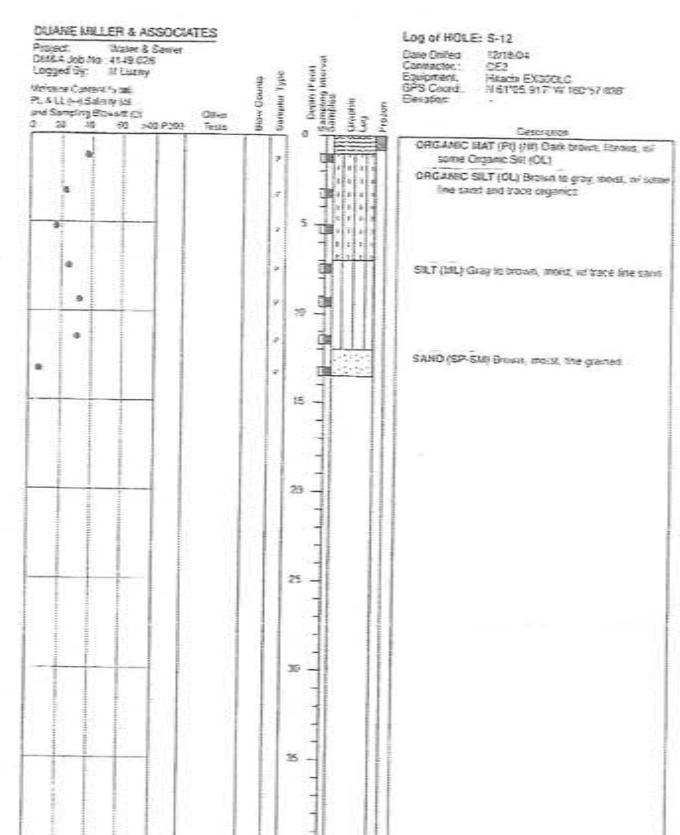

LOG of TEST PIT S-12
 Water & Sewer
 Tuluksak, Alaska
 Plate 25

RECORD DRAWING CERTIFICATE
 THESE DRAWINGS REFLECT RECORDED INFORMATION OBTAINED DURING CONSTRUCTION. INFORMATION PROVIDED HEREIN IS ACCURATE TO THE BEST OF MY KNOWLEDGE.

SCALE: 1" = 10' (See Notes on Drawing for Details)

DATE: _____

NAME: _____

2010-11 WASTEWATER SYSTEM IMPROVEMENTS

TEST HOLE BORING LOGS

TULUksak, ALASKA

CE2 ENGINEERS, INC.
 10 BOX 23046 ANCHORAGE, AK 99523 TEL 907-548-9116 FAX 907-548-1015

Project No. _____ Date: JUNE 2009
 Designed: LAP
 Drawn: CM
 Approved: LAP

Sheet No. G3.4

TULUKSAK, AK

TEST PIT "A"

N 61° 05' 21.8"
W 160° 57' 57.1"

30°-35°F


4" 6" SNOW COVER

CLEAR

D. HARVEY (CE2)

LOCAL OPERATOR: MIKE NABOKA

VEGETATION: ALDER, SOME BIRCH & SPRUCE

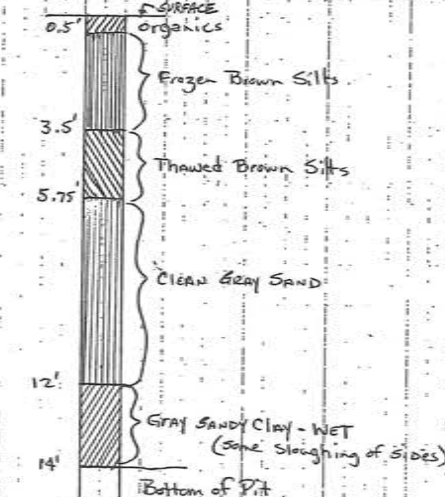

TULUKSAK, AK

TEST PIT "B"

N 61° 05' 20.6"
W 160° 57' 53.7"


20°F, 4" SNOW COVER

CLOUDY

R. ZEITLER

LOCAL OPERATOR: MIKE NABOKA

VEGETATION: ALDER WITH SPARSE BIRCH & SPRUCE

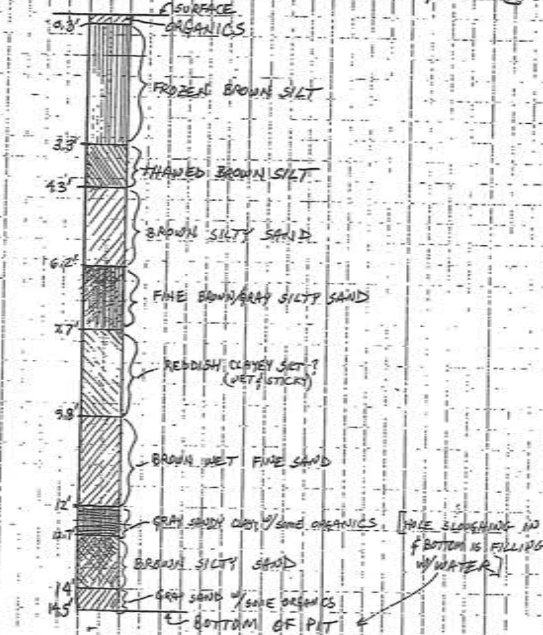

TULUKSAK, AK

TEST PIT "C"

N 61° 05' 19.8"
W 160° 57' 50.1"


35°F, CLOUDY

4" SNOW COVER

R. ZEITLER

LOCAL OPERATOR: MIKE NABOKA

VEGETATION: ALDER & SPARSE BIRCH & SPRUCE

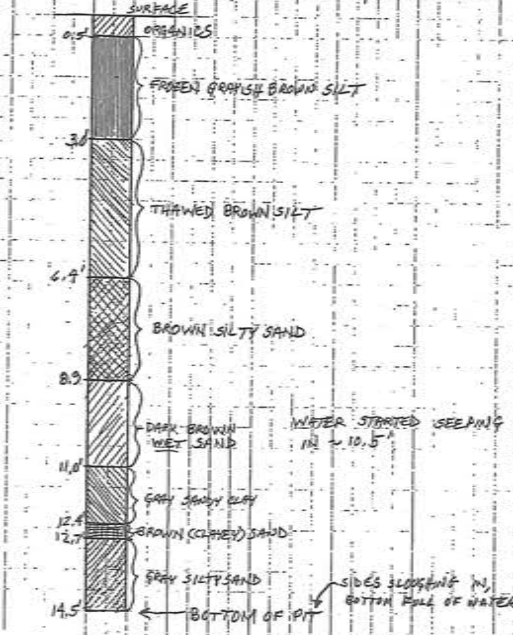

TULUKSAK - Alternate Lagoon Site Investigation

Test Hole Logs, 29 July 2013

M. Erdman, CE2 Engineers

TH - TLT1

- 0-2' Organics
- 2-6' Silty SAND
- 6-10' SAND (Frozen @ 8')
- Seeps @ 6-8'

TH - TLT2

- 0-1' Organics
- 1-6' Silty SAND
- 6-8.5' SAND (Frozen)

TH - TLT3

- 0-1' Organics
- 1-5' Silty SAND
- 5-10' (Discontinuously Frozen)

TH - TLT4

- 0-1.5' Organics
- 1.5-10' Silty SAND
- (Frozen @ 5')

TULUKSAK, AK

TEST PIT "D"

N 61° 5' 24.0"
W 160° 58' 20.3"


30°F, CLOUDY, LIGHT SNOW

4" SNOW COVER

R. ZEITLER (CE2 ENGINEERS)

LOCAL OPERATOR: MIKE NABOKA

VEGETATION: ALDER, SPARSE SPRUCE

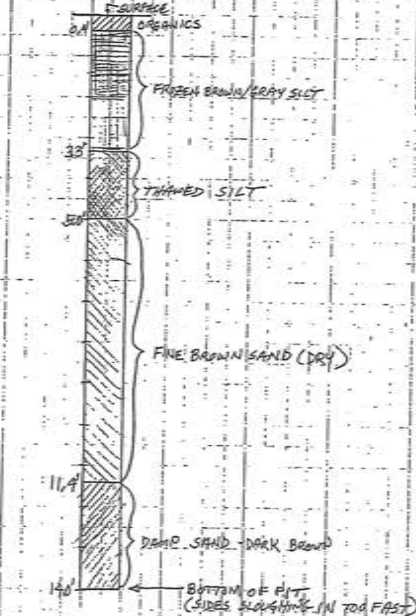

TULUKSAK, AK

TEST PIT "E"

N 61° 5' 21.1"
W 160° 58' 35.1"


20°F, CLOUDY

4" SNOW COVER

R. ZEITLER (CE2 ENGINEERS)

LOCAL OPERATOR: MIKE NABOKA

VEGETATION: ALDER, BIRCH, & SPRUCE

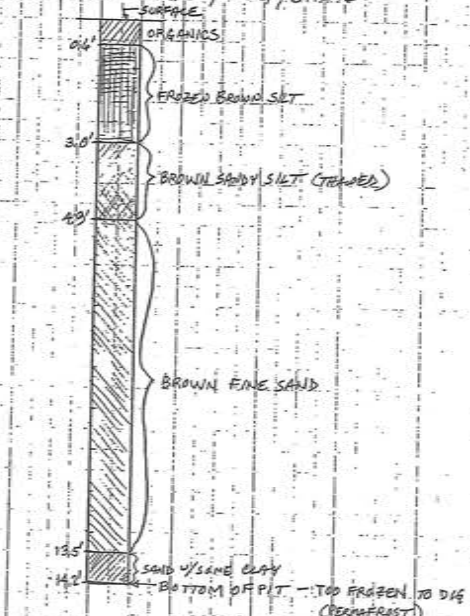

TULUKSAK, AK

TEST PIT "F"


N 61° 5' 16.4"
W 160° 58' 23.4"

30°F, CLOUDY, 4" SNOW COVER

R. ZEITLER (CE2)

LOCAL OPERATOR: MIKE NABOKA

VEGETATION: BIRCH, ALDER, & SPRUCE

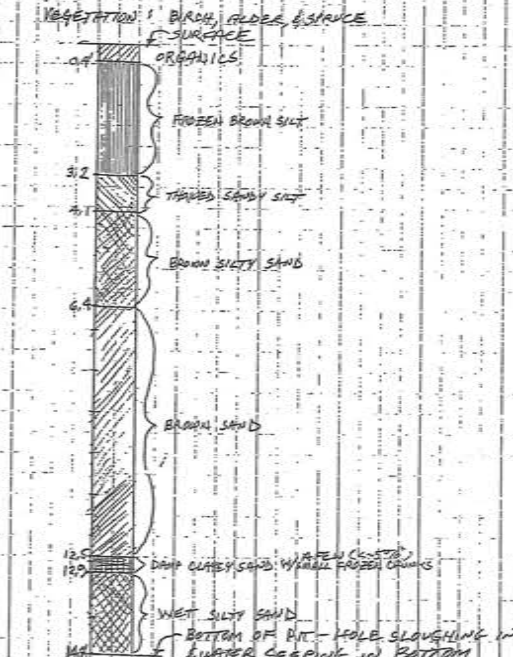

TULUKSAK, AK

TEST PIT "G"


N 61° 5' 18.9"
W 160° 58' 18.1"

35°F, CLOUDY, 4" SNOW COVER

R. ZEITLER (CE2)

LOCAL OPERATOR: MIKE NABOKA

VEGETATION: SPRUCE, BIRCH, & ALDER

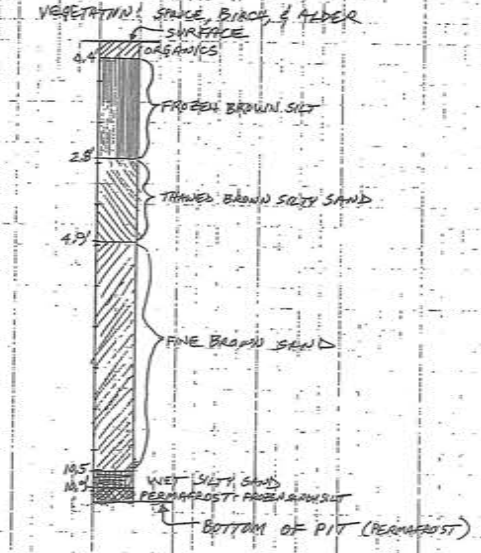

RECORD DRAWING CERTIFICATE
THESE DRAWINGS REFLECT RECORDED
INFORMATION OBTAINED DURING
CONSTRUCTION. INFORMATION PROVIDED
HEREIN IS ACCURATE TO THE BEST OF MY
KNOWLEDGE.

SCALE:
DATE: ONE INCH ON
ORIGINAL DRAWING
EQUALS ONE FOOT ON
THIS SHEET. ADJUST
SCALE ACCORDINGLY




2010-11 WASTEWATER
SYSTEM IMPROVEMENTS
TEST HOLE
BORING LOGS
TULUKSAK, ALASKA







CE2
ENGINEERS, INC.
PO BOX 225046 ANCHORAGE, AK 99523 PH 907-340-0010 FX 907-340-0015

REVISION	BY	DATE

Project No.	Date	Designed	LAP	Drawn	CE2	Approved	LAP
	APRIL 2014						

Sheet No.

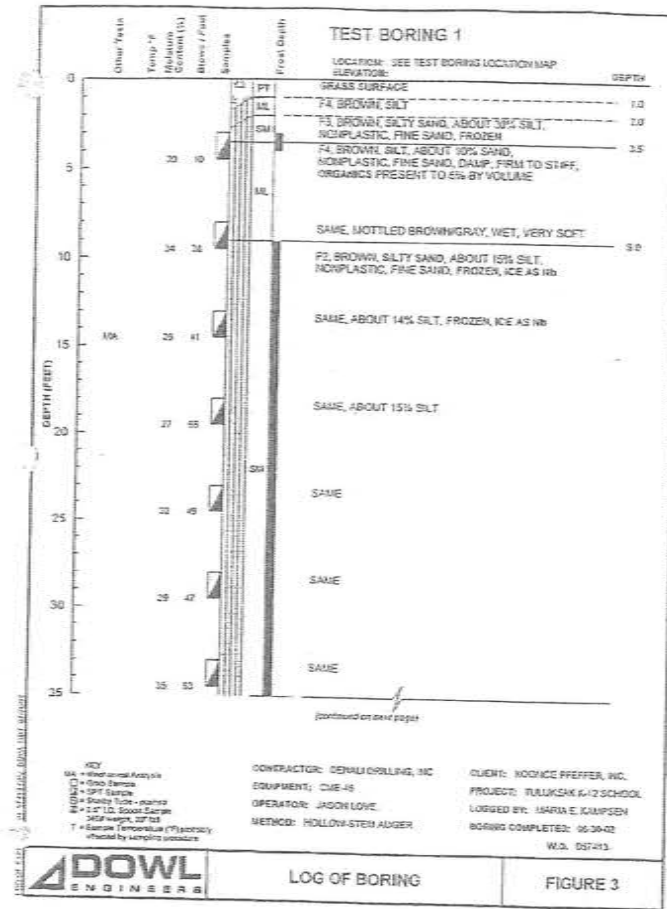

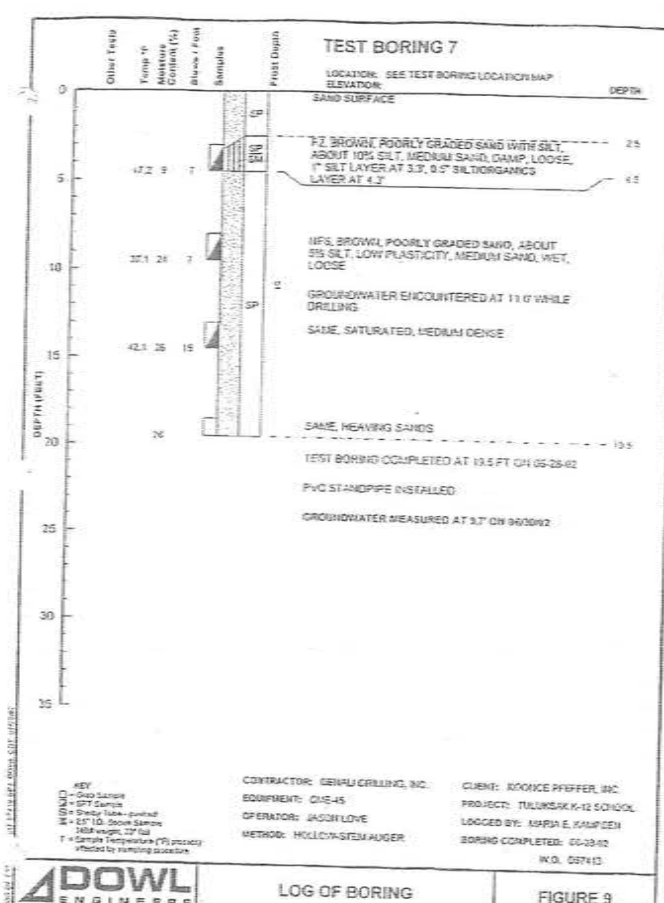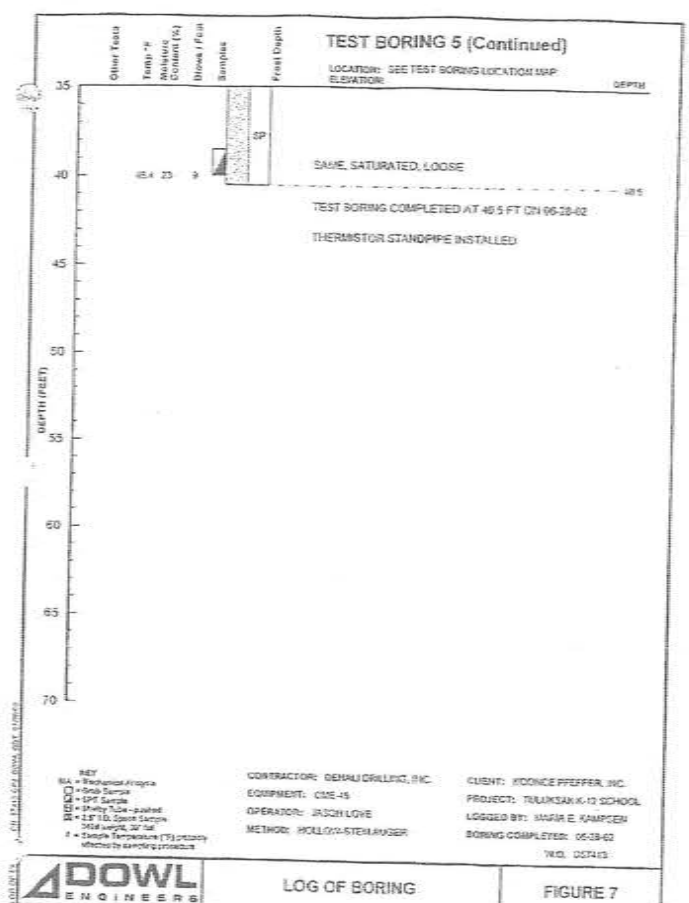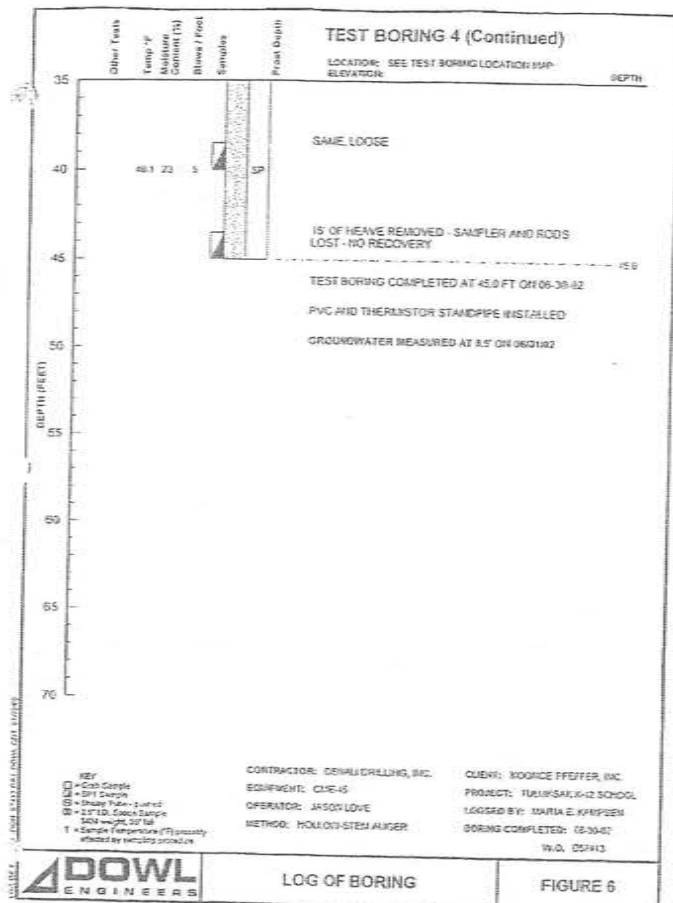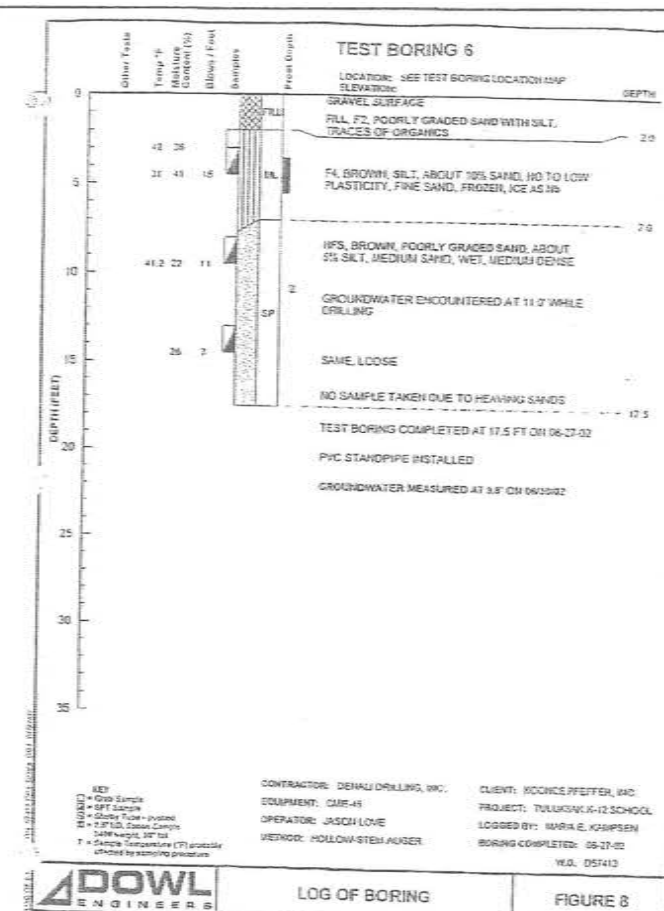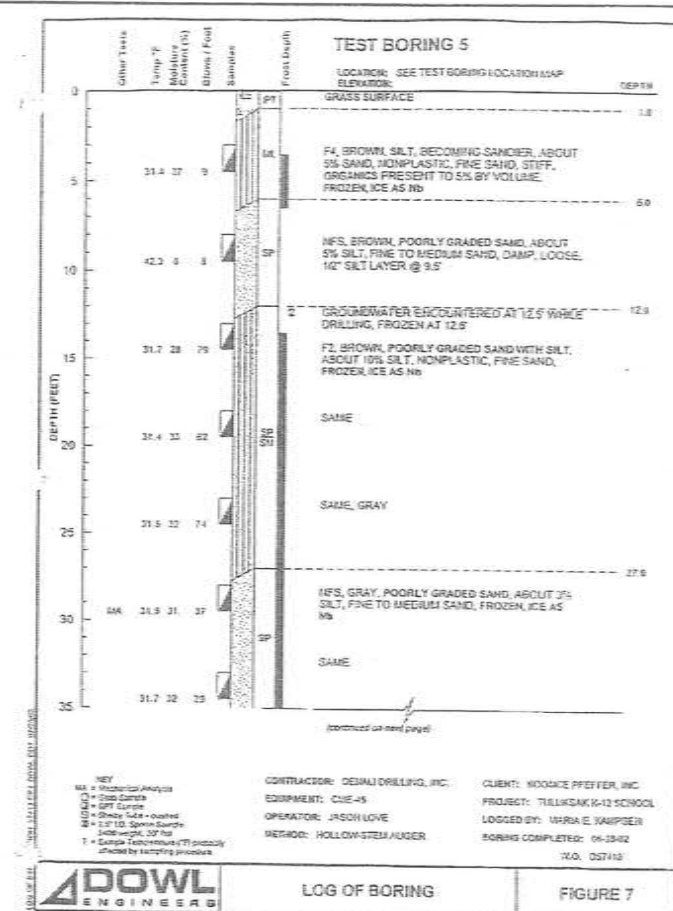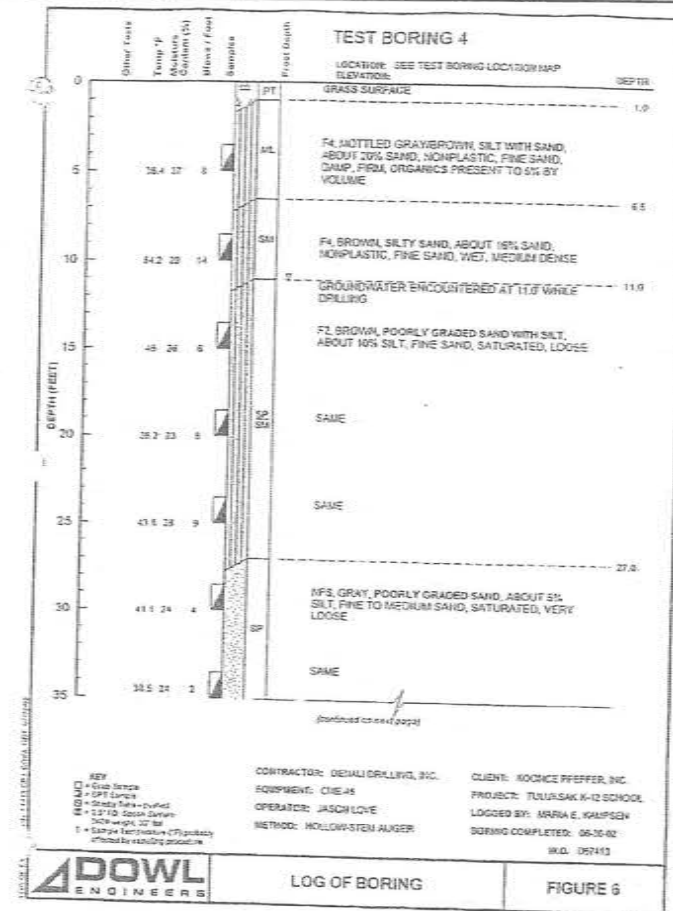

RECORD DRAWING CERTIFICATE

THESE DRAWINGS REFLECT RECORDED INFORMATION OBTAINED DURING CONSTRUCTION. INFORMATION PROVIDED HEREIN IS ACCURATE TO THE BEST OF MY KNOWLEDGE.

NAME: _____ DATE: _____

SCALE: 1" = 10' (VERTICAL) 1" = 10' (HORIZONTAL)

2010-11 WASTEWATER SYSTEM IMPROVEMENTS

TEST HOLE BORING LOGS

TULUSAK, ALASKA




CEER ENGINEERS, INC.

PO BOX 21294 ANCHORAGE, AK 99521 PH: 907-548-1005 FAX: 907-548-1016

REVISION	BY	DATE

Project No. _____ Date: JUNE 2009 Designed: LAP Drawn: CM Approved: LAP

Sheet No. **G3.8**

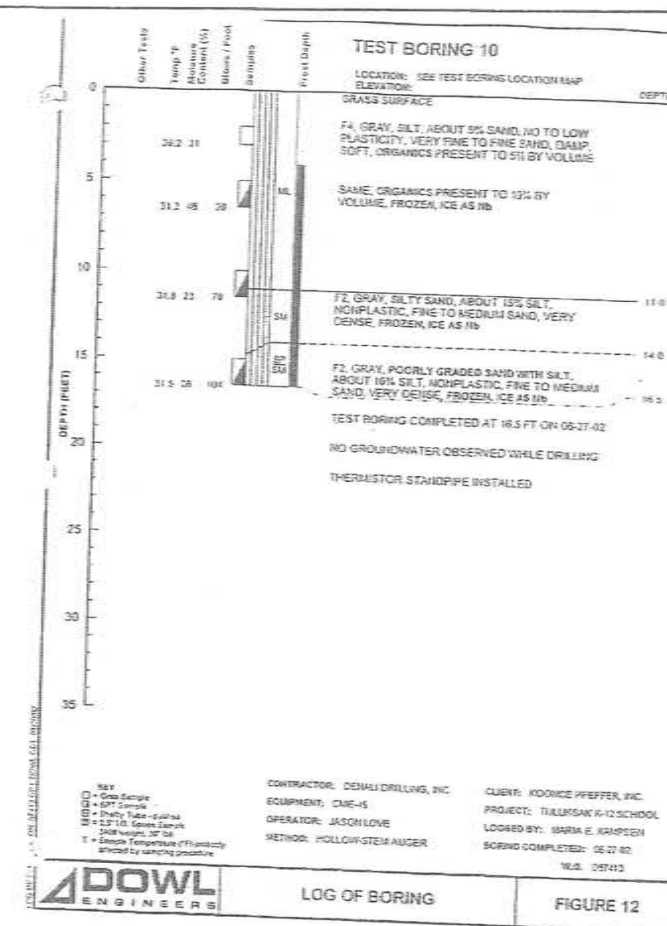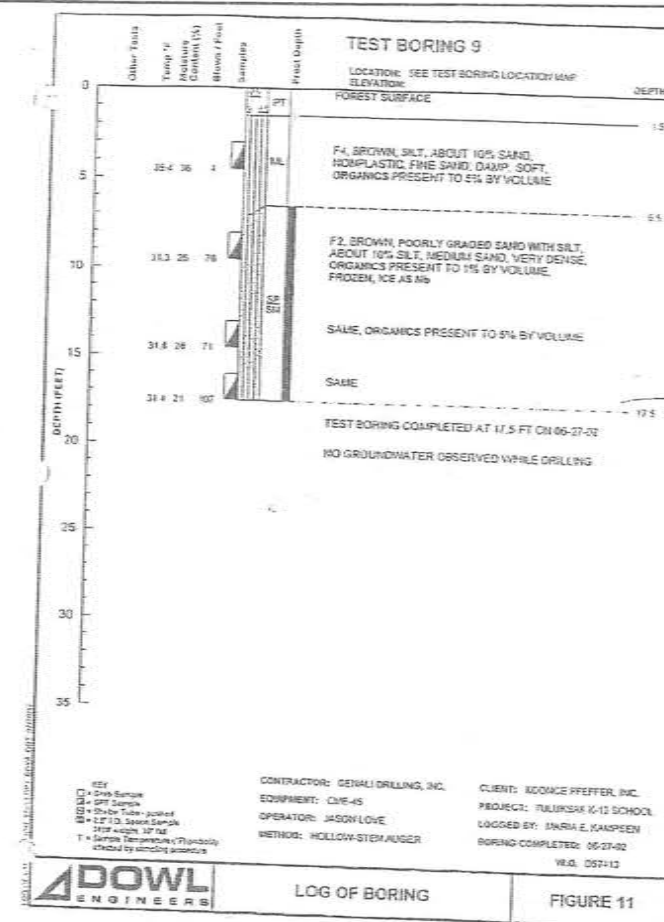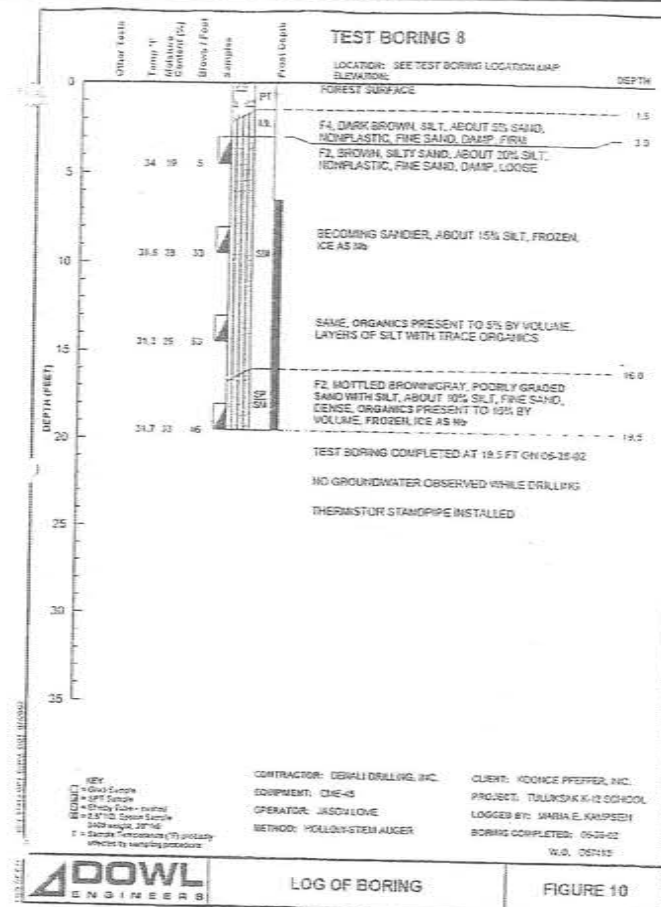

PT-1
SOIL PROFILE/PERCOLATION TEST
DATA FORM

Property Location: Tuluklak Wastewater Lagoon Site - Percolation/Storage Cell

Test Pit Number and Location: Test Pit No. 1, N 61°05'31.3", W 160°57'13.9", excavated and monitoring tube set 10/20/2007

Elevations: Existing Ground 18.93'
Bottom/Top of Sand 13.25'
3:6:08 No water noted in test hole to Elev. 7' (12' below existing ground)

Soil Profile: Depth (inches)
0 - 12" Soil Texture
12" - 64" Organic Overburden (Pi), fibrous
64" - Organic silt (OL) and Silty Sand (SM) Mixture, dry
Poorly graded clean fine sand (SP)

No groundwater encountered

Time	Time Interval (Minutes)	End of Period Measurement (Feet)	Start of Period Measurement (Feet)	Drop in Water Level (Feet)	Percolation Rate (Hrs/Feet)	Remarks
6:48			6.30			Start soaking period.
7:04	0:16	6.37	6.37	0.07	3.48	Start percolation test. Water level 12" above bottom of hole.
7:19	0:15	6.62	6.30	0.25	1.06	
7:34	0:15	6.50	6.32	0.20	1:15	
7:49	0:15	6.54	6.22	0.22	1:08	
8:04	0:15	6.46	6.40	0.24	1:02	
8:20	0:16	6.63	6.37	0.23	1:09	
8:35	0:15	6.61	6.41	0.24	1:02	
8:50	0:15	6.62	6.38	0.27	1:08	
9:05	0:15	6.62		0.24	1:02	End of Test.

Percolation rate = 5.2 minutes per inch

Date of test March 6, 2008 Percolation test by: Lloyd Persson, P.E.

** 6:10:08 Water Elev. measured above sand at 14.59' (seasonal high groundwater).

PT-2
SOIL PROFILE/PERCOLATION TEST
DATA FORM

Property Location: Tuluklak Wastewater Lagoon Site - Percolation/Storage Cell

Test Pit Number and Location: Test Pit No. 2, N 61°05'31.7", W 160°57'12.2", excavated and monitoring tube set 10/20/2007

Elevations: Existing Ground 22.41'
Bottom/Top of Sand 15.95'
3:6:08 No water noted in test hole to Elev. 10.4' (12' below existing ground)

Soil Profile: Depth (inches)
0 - 12" Soil Texture
12" - 82" Organic Overburden (Pi), fibrous
82" - Organic silt (OL) and Silty Sand (SM) Mixture, dry
Poorly graded clean fine sand (SP)

No groundwater encountered

Time	Time Interval (Minutes)	End of Period Measurement (Feet)	Start of Period Measurement (Feet)	Drop in Water Level (Feet)	Percolation Rate (Hrs/Feet)	Remarks
6:55			6.09			Start soaking period.
7:10	0:15	6.36	5.74	0.25	1:00	Start percolation test. Water level 12" above bottom of hole.
7:25	0:15	5.85	5.85	0.15	1:40	
7:41	0:16	6.06	6.05	0.20	1:30	
7:56	0:15	6.18	5.95	0.13	1:55	
8:11	0:15	6.07	6.07	0.12	2:29	
8:26	0:15	6.20	6.10	0.13	1:53	
8:41	0:15	6.21	5.92	0.13	2:16	
8:56	0:15	6.06		0.14	1:47	End of Test.

Percolation rate = 10 minutes per inch

Date of test March 6, 2008 Percolation test by: Lloyd Persson, P.E.

PT-3
SOIL PROFILE/PERCOLATION TEST
DATA FORM

Property Location: Tuluklak Wastewater Lagoon Site - Percolation/Storage Cell

Test Pit Number and Location: Test Pit No. 3, N 61°05'32.2", W 160°57'14.7", excavated and monitoring tube set 10/20/2007

Elevations: Existing Ground 21.81'
Bottom/Top of Sand 14.95'
3:6:08 No water noted in test hole to Elev. 7'-8" (Excavated to 11' below existing ground and found no water.)

Soil Profile: Depth (inches)
0 - 12" Soil Texture
12" - 64" Organic Overburden (Pi), fibrous
64" - Organic silt (OL) and Silty Sand (SM) Mixture, dry
Poorly graded clean fine sand (SP)

No groundwater encountered

Time	Time Interval (Minutes)	End of Period Measurement (Feet)	Start of Period Measurement (Feet)	Drop in Water Level (Feet)	Percolation Rate (Hrs/Feet)	Remarks
7:01			6.62			Start soaking period.
7:16	0:15	7.65	6.65	1.00	0:15	Start percolation test. Water level 12" above bottom of hole.
7:31	0:15	7.70	6.50	1.02	0:14	
7:46	0:15	7.55	6.50	1.05	0:14	
8:01	0:15	7.52	6.62	0.94	0:15	
8:16	0:15	7.50	6.53	0.88	0:17	
8:31	0:15	7.43	6.60	0.84	0:17	
8:46	0:15	7.33	6.55	0.78	0:20	
9:01	0:15	7.36		0.81	0:18	End of Test.

Percolation rate = 1.5 minutes per inch

Date of test March 6, 2008 Percolation test by: Lloyd Persson, P.E.

** 6:10:08 Water Elev. measured above sand at 14.95' (seasonal high groundwater).

RECORD DRAWING CERTIFICATE
THESE DRAWINGS REFLECT RECORDED INFORMATION OBTAINED DURING CONSTRUCTION. INFORMATION PROVIDED HEREIN IS ACCURATE TO THE BEST OF MY KNOWLEDGE.

SCALE: 1" = 10' (unless otherwise noted)

DATE



2010-11 WASTEWATER SYSTEM IMPROVEMENTS
TEST HOLE BORING LOGS
TULUKSAK, ALASKA





REVISION	BY	DATE

Project No.	Date	Drawn	Checked	Approved

Sheet No. G3.9

G:\ACAD\TULUKSAK\T10901 2008 waste water disposal area\C1.1 thru C1.4 and C2.9.dwg, 1/11/2011 1:11:26 PM, Flasi, LAMIER MP C2050_L0520C PCL 68LK WHIT pc3

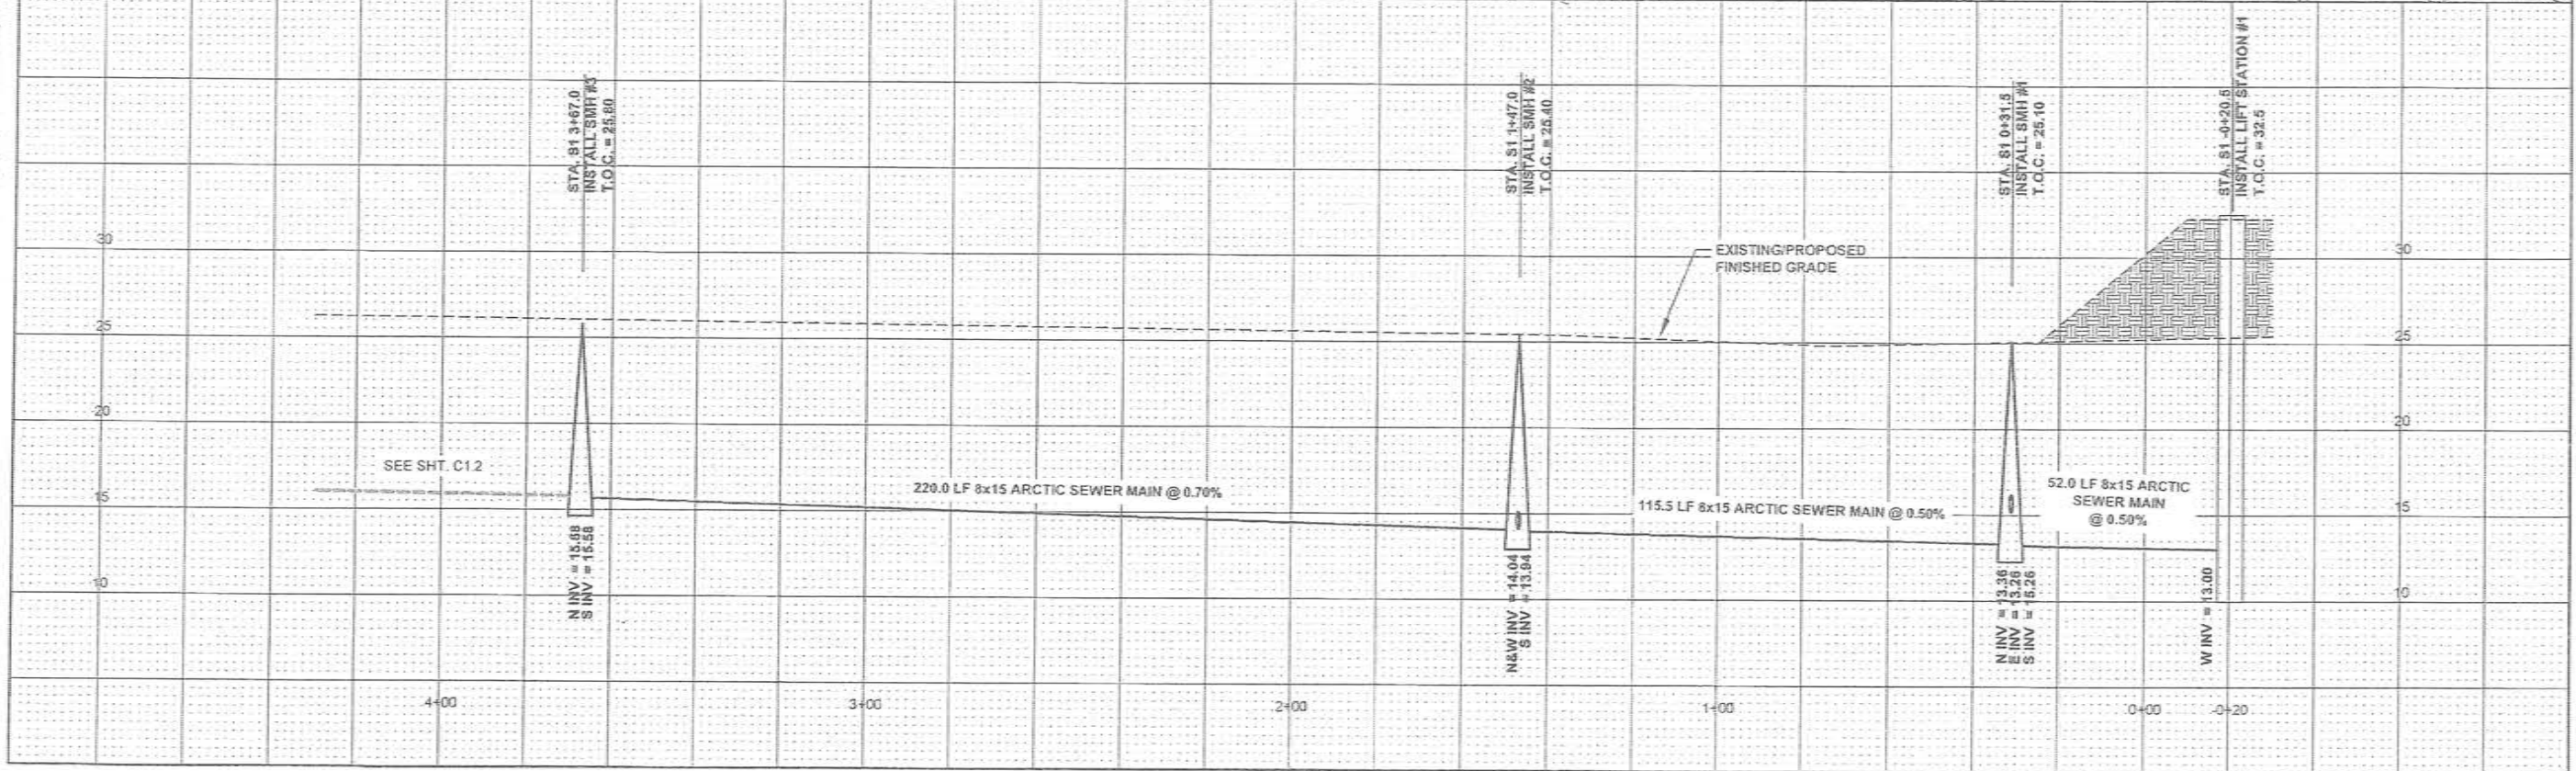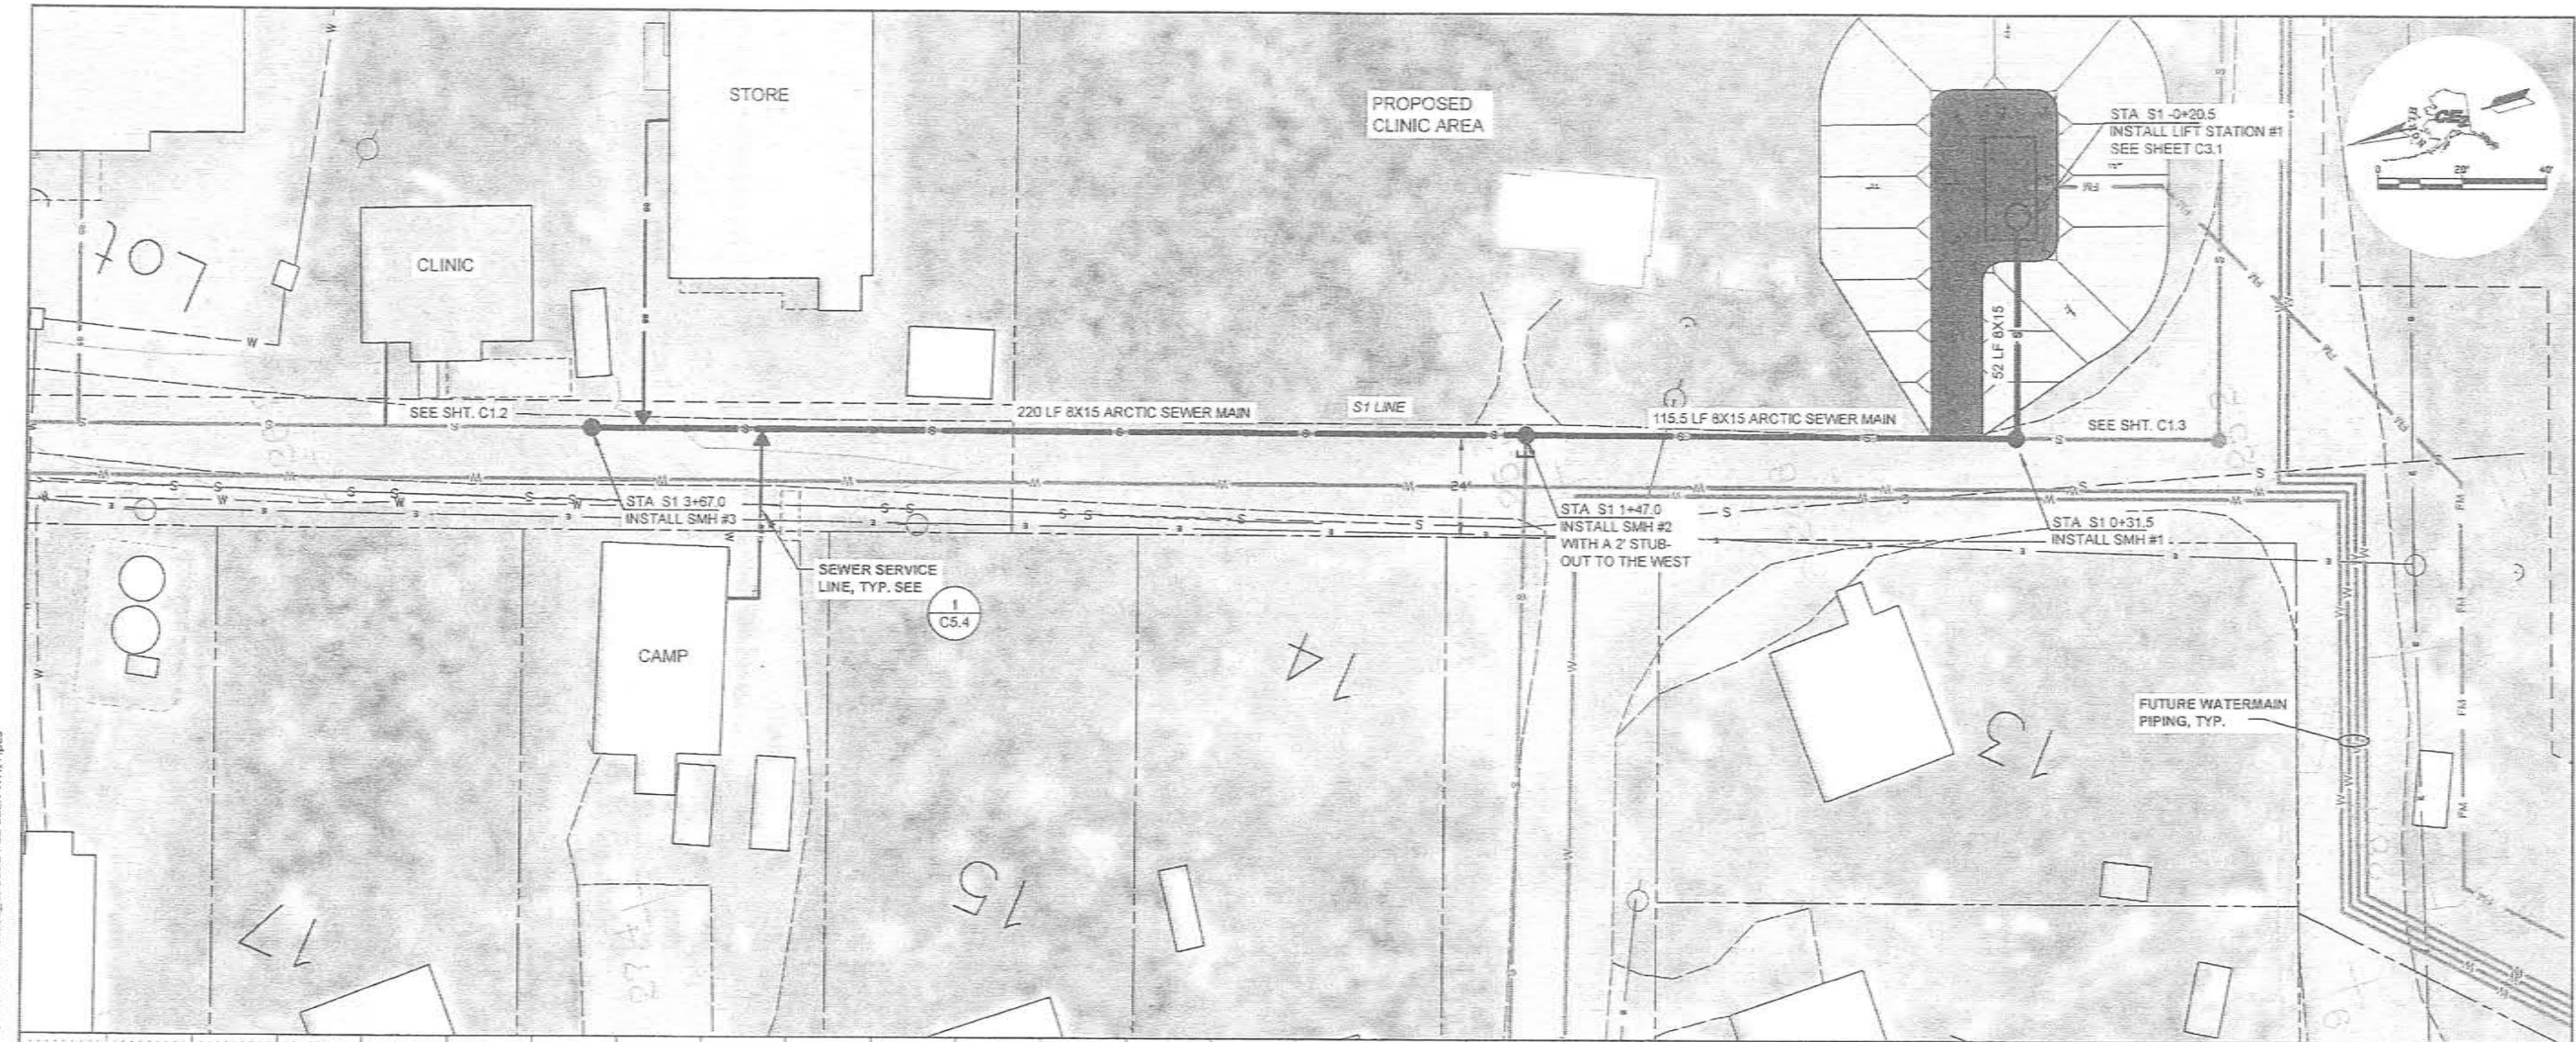

RECORD DRAWING CERTIFICATE
THESE DRAWINGS REFLECT RECORDED
INFORMATION OBTAINED DURING
CONSTRUCTION INFORMATION PROVIDED
HEREIN IS ACCURATE TO THE BEST OF MY
KNOWLEDGE.

SCALE:
PLAN 1"=20'
PROF 1"=20'
DATE: 06/01/2009
DRAWN: [Signature]
CHECKED: [Signature]
APPROVED: [Signature]




2010-11 WASTEWATER
SYSTEM IMPROVEMENTS
S1 GRAVITY SEWER
PLAN AND PROFILE
TULUKSAK, ALASKA



REVISION	BY	DATE

Project No. _____
Date: JUNE 2009
Designed: LAP
Drawn: LAW
Approved: LAP

Sheet No. C1.1

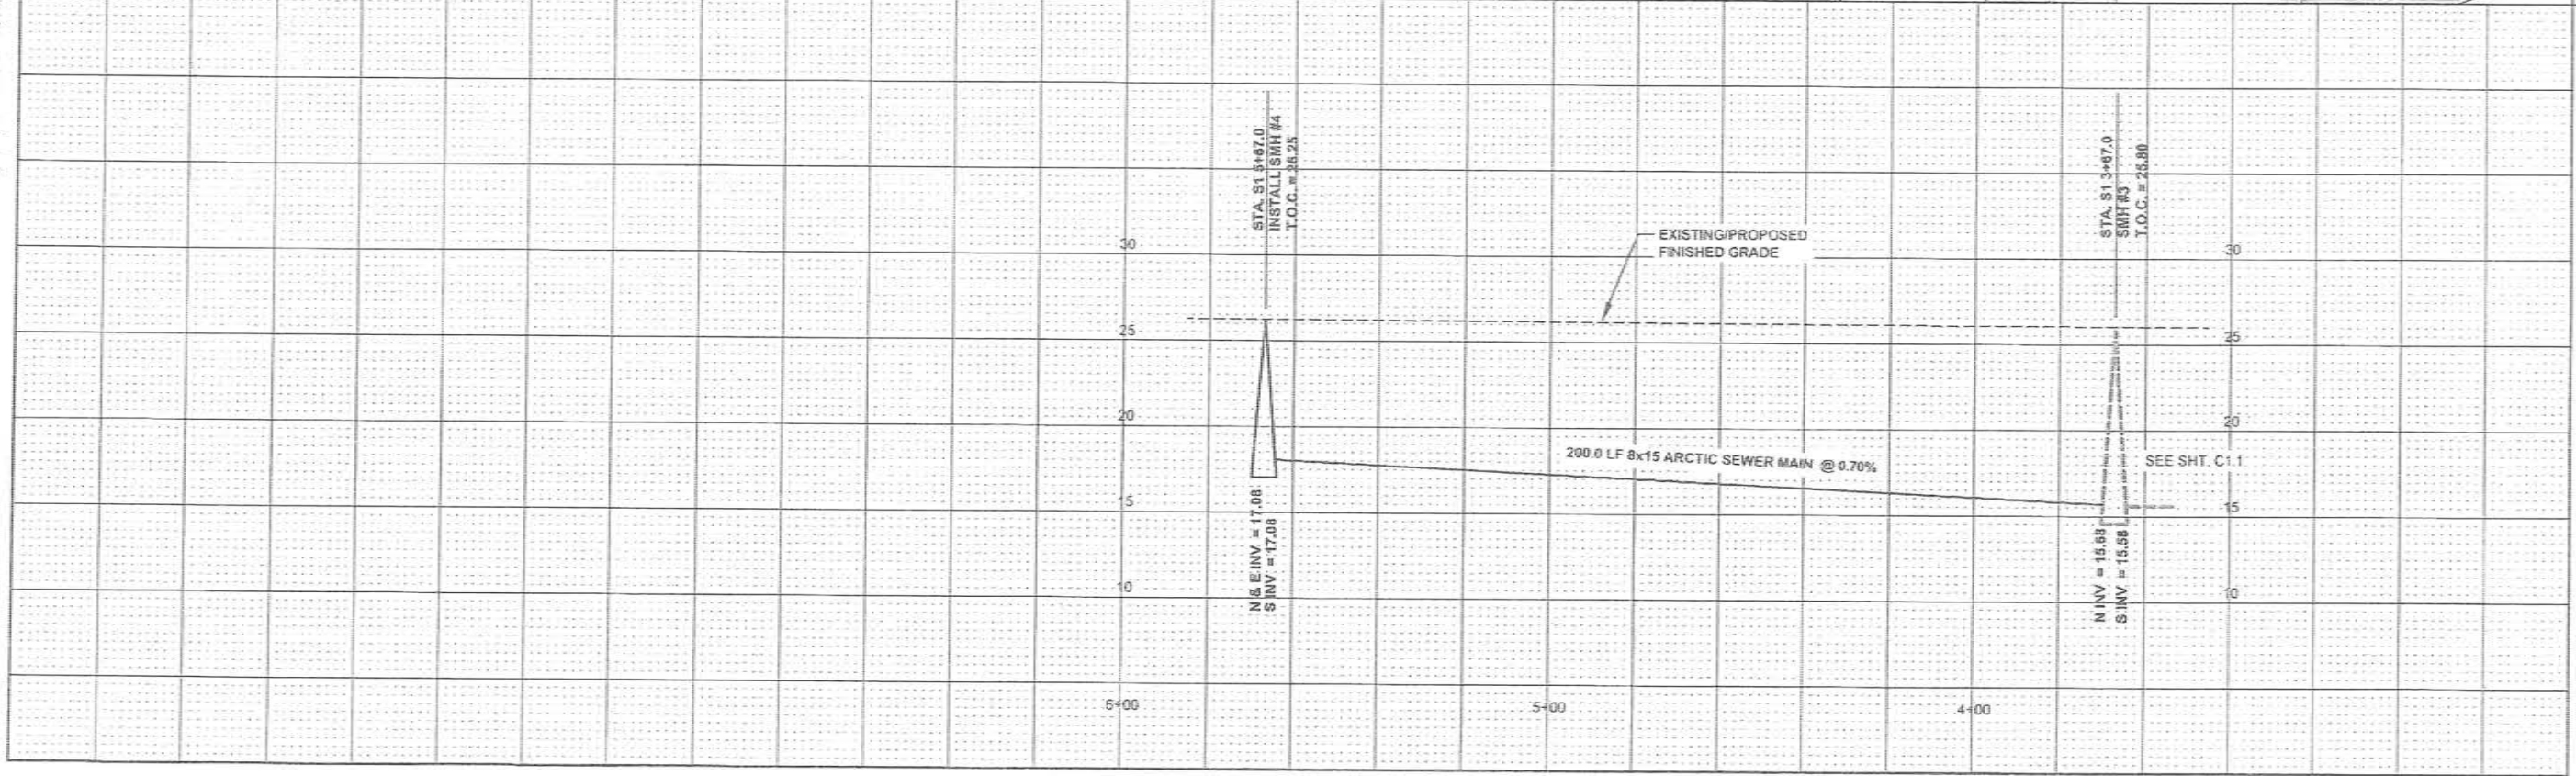

RECORD DRAWING CERTIFICATE
THESE DRAWINGS REFLECT RECORDED
INFORMATION OBTAINED DURING
CONSTRUCTION. INFORMATION PROVIDED
HEREIN IS ACCURATE TO THE BEST OF MY
KNOWLEDGE.

NAME _____ DATE _____

SCALE:
PLAN 1"=20'
PROFILE 1"=25'
SECTION 1"=25'

SEE SHT. C1.1

STATE OF ALASKA
DEPARTMENT OF ENVIRONMENTAL CONSERVATION
DIVISION OF WATER

2010-11 WASTEWATER
SYSTEM IMPROVEMENTS

2010-11 WASTEWATER
SYSTEM IMPROVEMENTS

S1 GRAVITY SEWER
PLAN AND PROFILE

TULUKSAK, ALASKA


CE2
ENGINEERS, INC.

PO BOX 22248 ANCHORAGE, AK 99522 PH: 907-348-8103 FAX: 907-348-1818


Project No. _____
Date: JUNE 2009
Designed: LAP
Drawn: LAW
Approved: LAP

Revision _____
By _____
Date _____

Sheet No. _____
C1.2


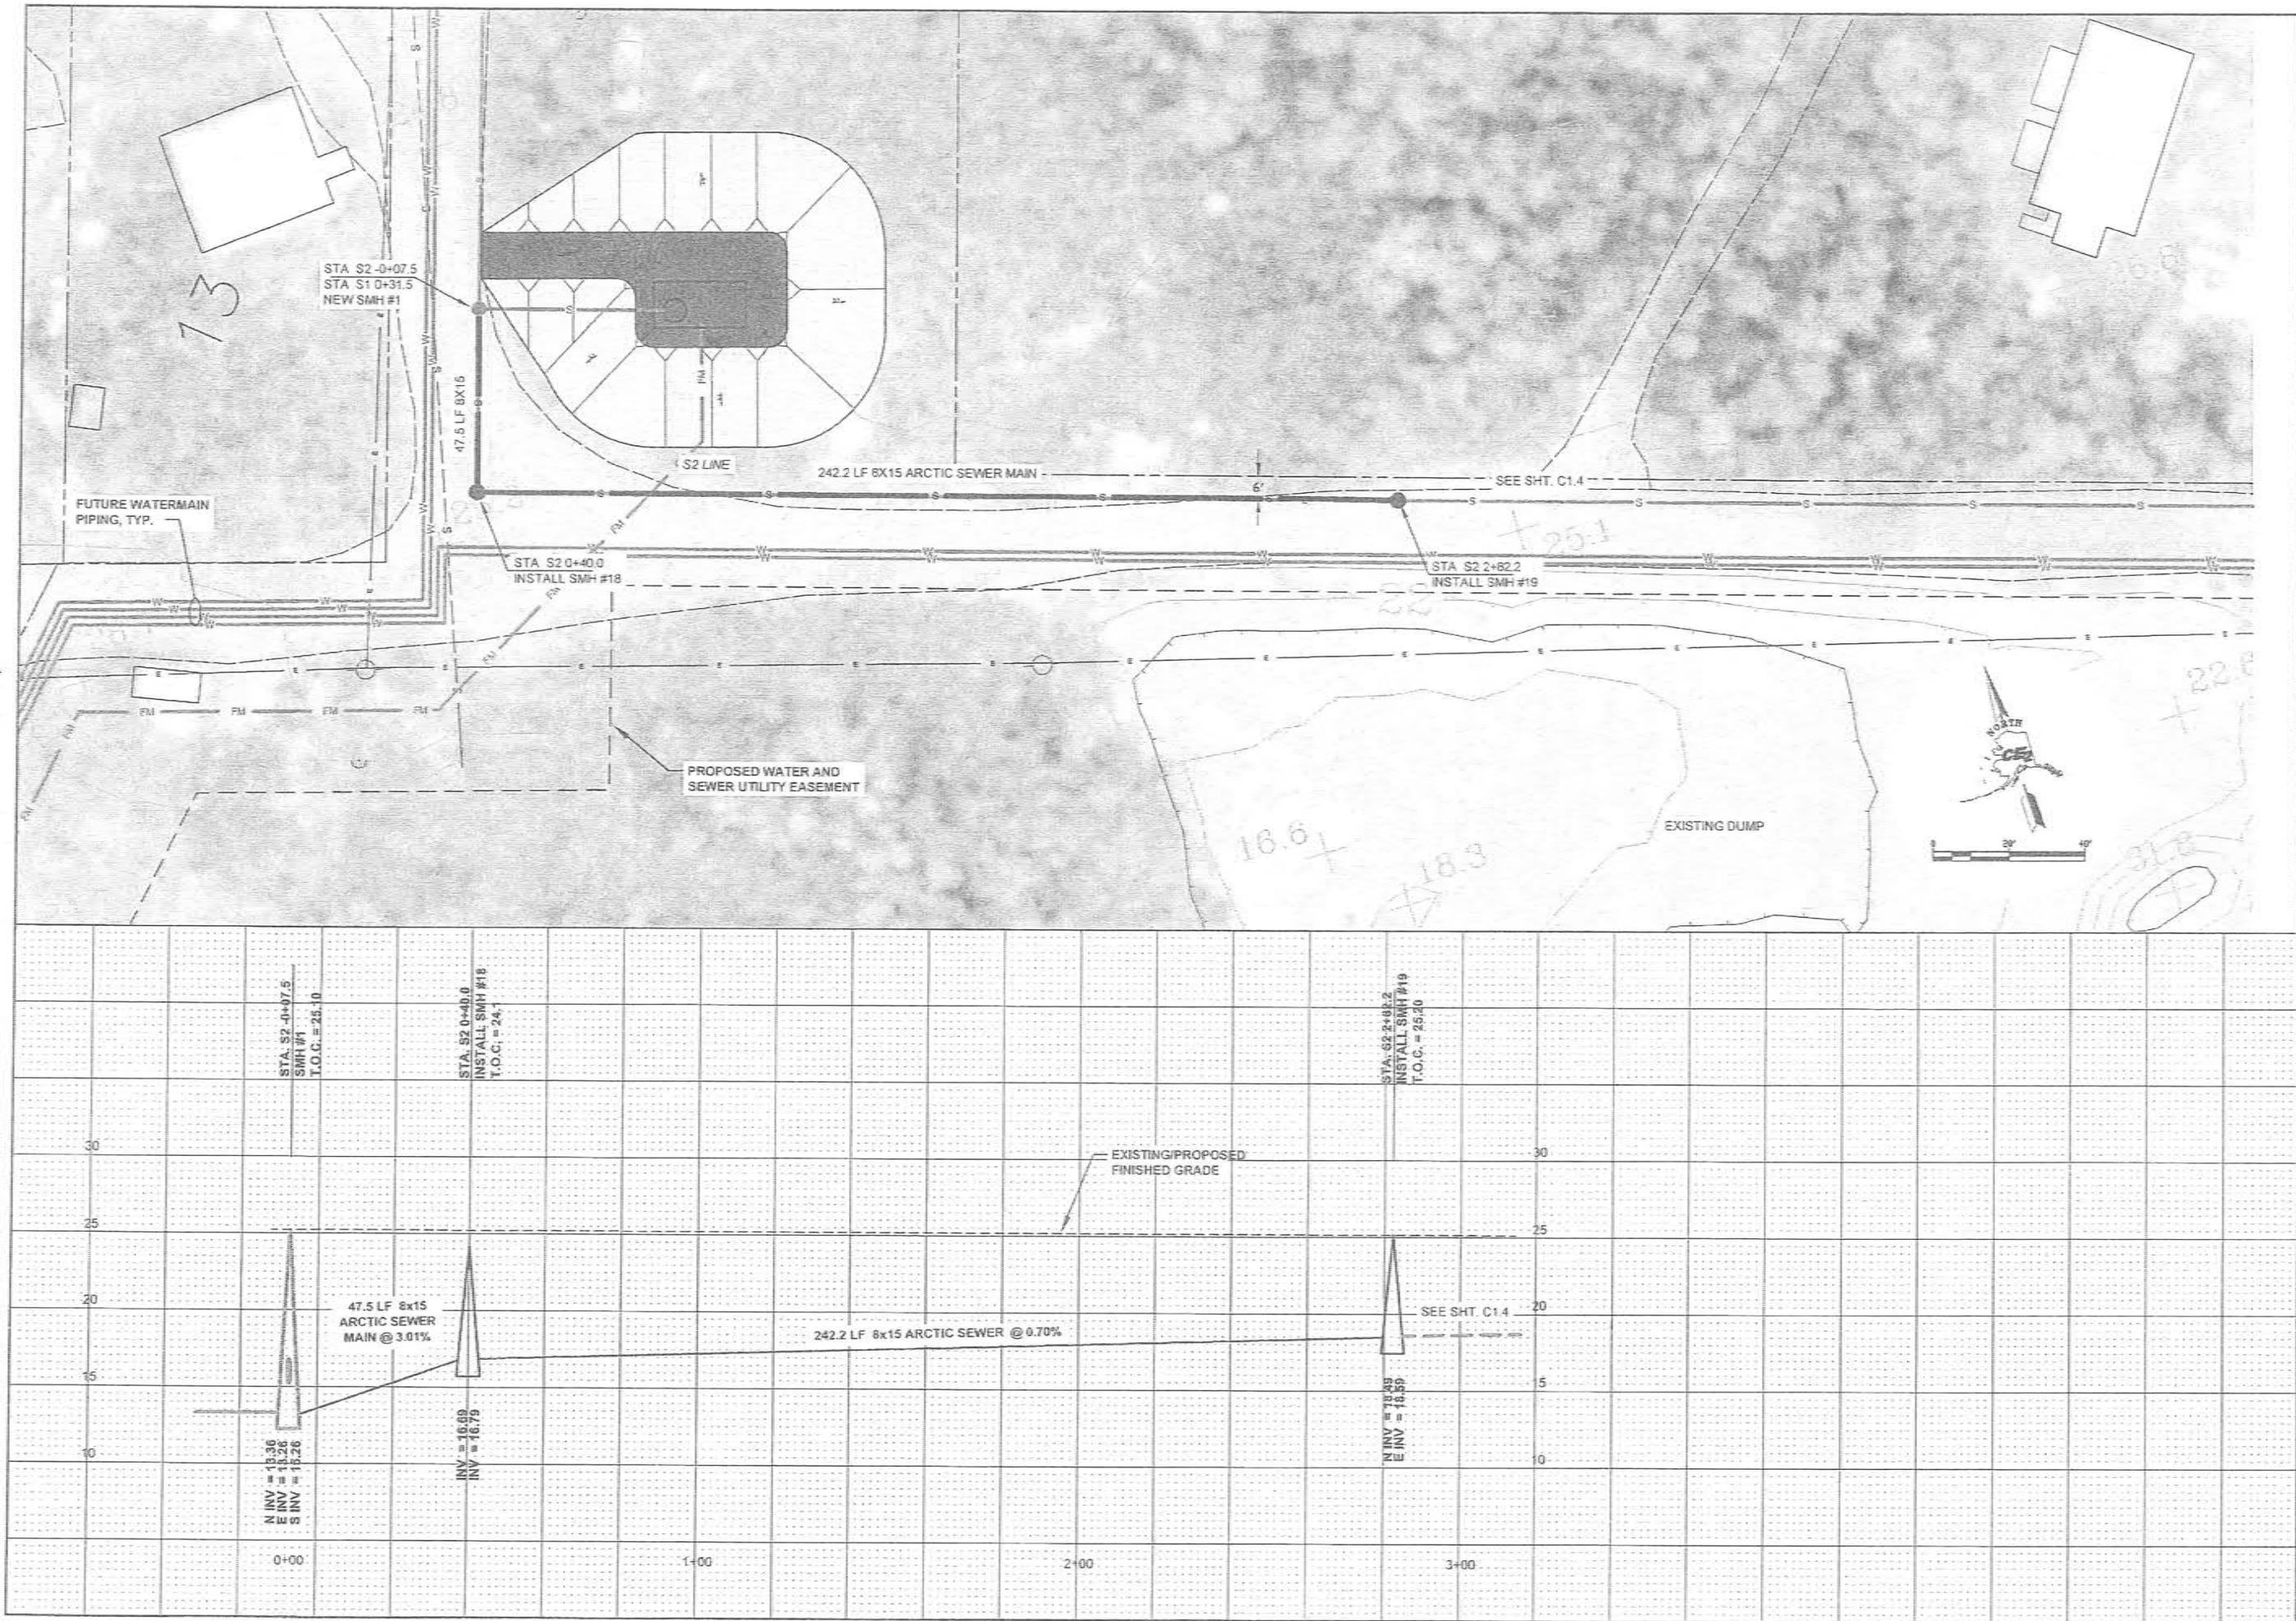


RECORD DRAWING CERTIFICATE THESE DRAWINGS REFLECT RECORDED INFORMATION OBTAINED DURING CONSTRUCTION. INFORMATION PROVIDED HEREIN IS ACCURATE TO THE BEST OF MY KNOWLEDGE.		NAME _____ DATE _____
SCALE: PLAN: 1"=20' PROFILES: 1"=20' VERTICAL: 1"=5'		DATE FOR RECORD DRAWING: 1/11/2011
2010-11 WASTEWATER SYSTEM IMPROVEMENTS S2 GRAVITY SEWER PLAN AND PROFILE		TULUKSAK, ALASKA
Project No. _____	BY _____	DATE _____
Date: JUNE 2009	DESIGNED: LAP	
Drawn: LAW	Approved: LAP	
Sheet No. C1.3		

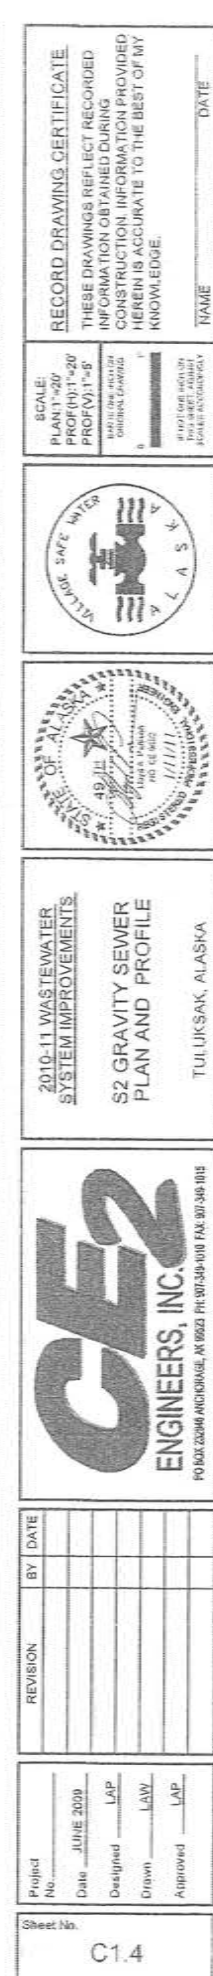

SEQUENCE OF CONSTRUCTION

1. CLEAR CUT ALL BRUSH AND TREES WITHIN THE PROPOSED UTILITY PIPING AREA, LAGOON AND BORROW PIT AREAS AS REQUIRED OR DIRECTED BY THE ENGINEER. LIMB ALL TREES WITH A TRUNK DIAMETER LARGER THAN 4 INCHES, CUT TRUNK INTO 8 FT LENGTHS AND STACK THE LENGTHS PERIODICALLY AT THE EDGE OF THE RIGHT OF WAY FOR HAUL OFF BY THOSE NEEDING FIREWOOD. DISPOSE OF REMAINING CLEAR CUT DEBRIS AT AN APPROVED LOCATION.
2. GRUB ALL AREAS BENEATH THE FOOTPRINT OF THE PROPOSED ACCESS ROAD CONSTRUCTION. IN ADDITION, GRUB THE BORROW SITE(S) AND AN ACCESS CORRIDOR BETWEEN THE BORROW SOURCE AND THE WORK AS DIRECTED BY THE ENGINEER. GRUBBING SHALL REMOVE ALL ORGANIC MATERIALS DOWN TO IN-SITU SANDY SOILS (AVERAGE ORGANIC DEPTH 1.5). GRUBBING SHALL BE HAULED OFF TO AN APPROVED LOCATION. TOPSOIL SHALL BE STOCKPILED IN THE BORROW SITE OR ALONG THE EDGE OF THE RIGHT OF WAY FOR LATER USE IN RE-VEGETATION.
3. INSTALL LIFT STATION AND FORCEMAIN AS SHOWN ON THE PLANS. USE IN-SITU SANDS FOR TRENCH BACKFILL TO THE GREATEST EXTENT POSSIBLE.
4. OPEN THE BORROW PIT AS DIRECTED BY THE ENGINEER.
5. COVER THE FORCEMAIN WITH A MINIMUM OF 3 FEET OF TRENCH BACKFILL AND EMBANKMENT FILL BEFORE ALLOWING FULL DUMP TRUCKS TO HAUL OVER THE PIPELINE.

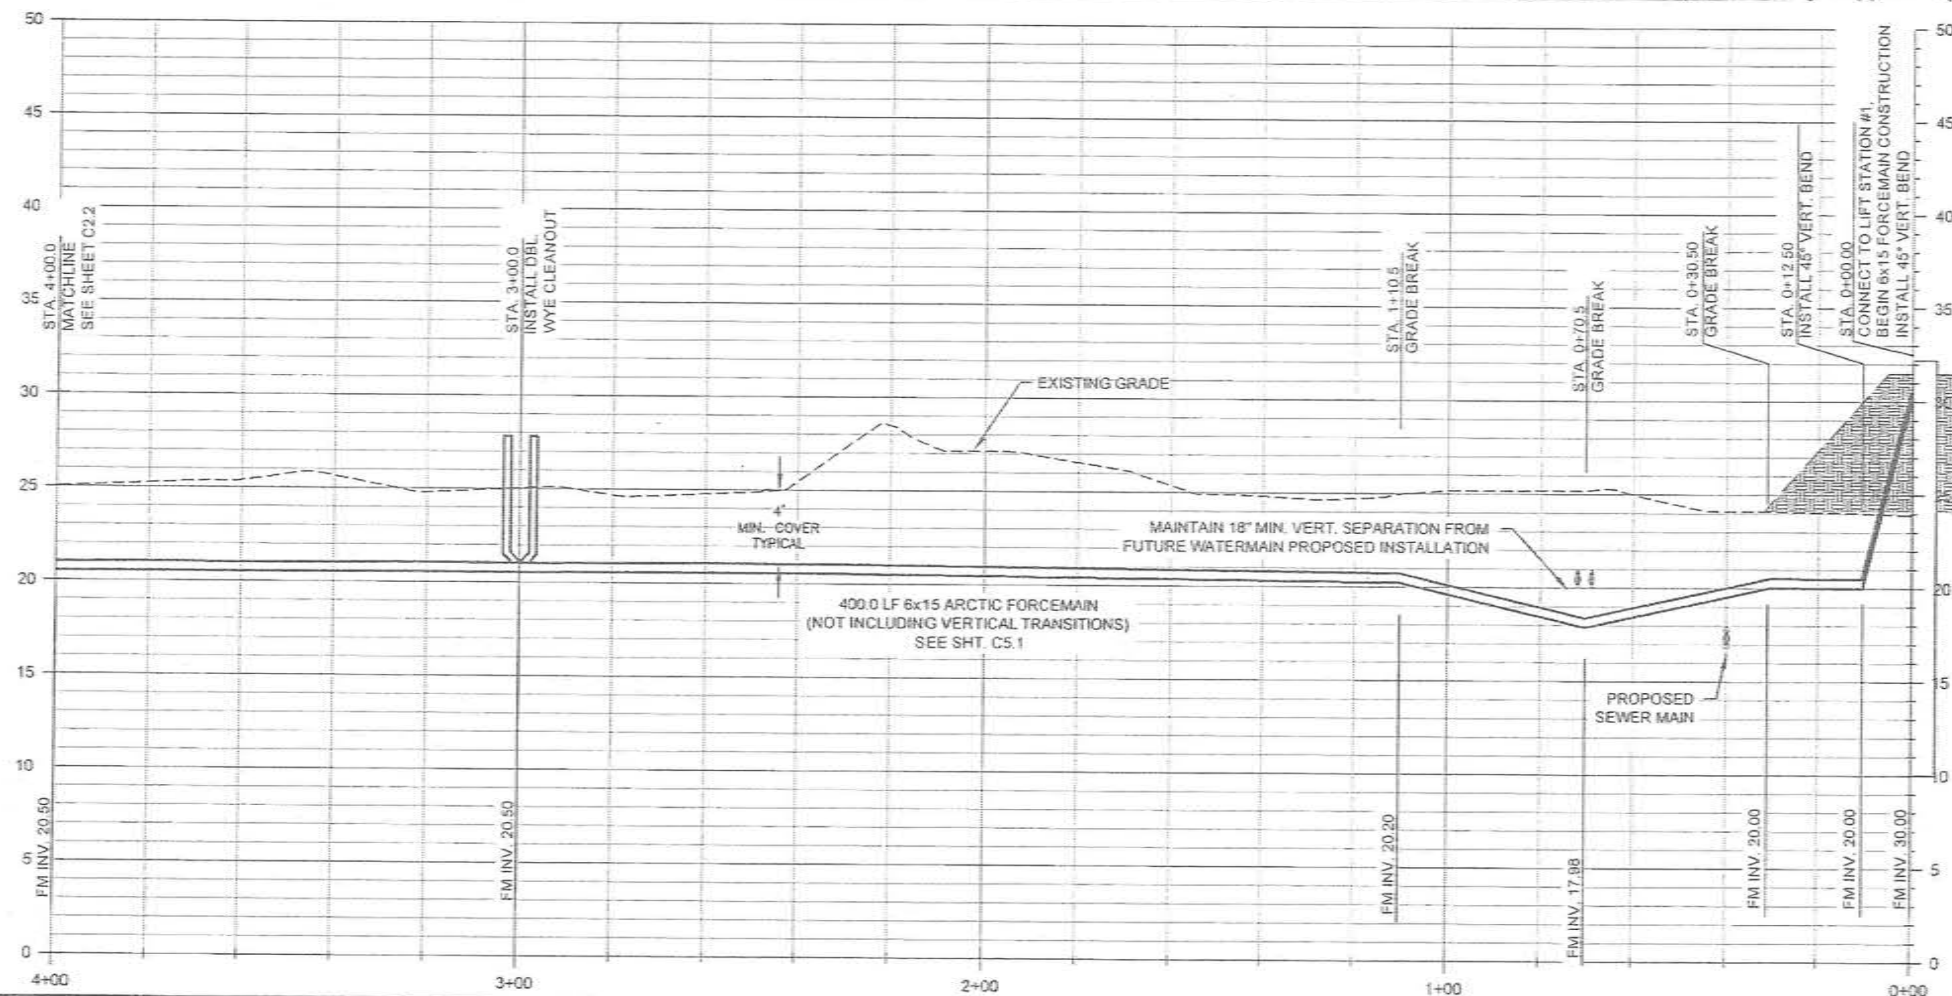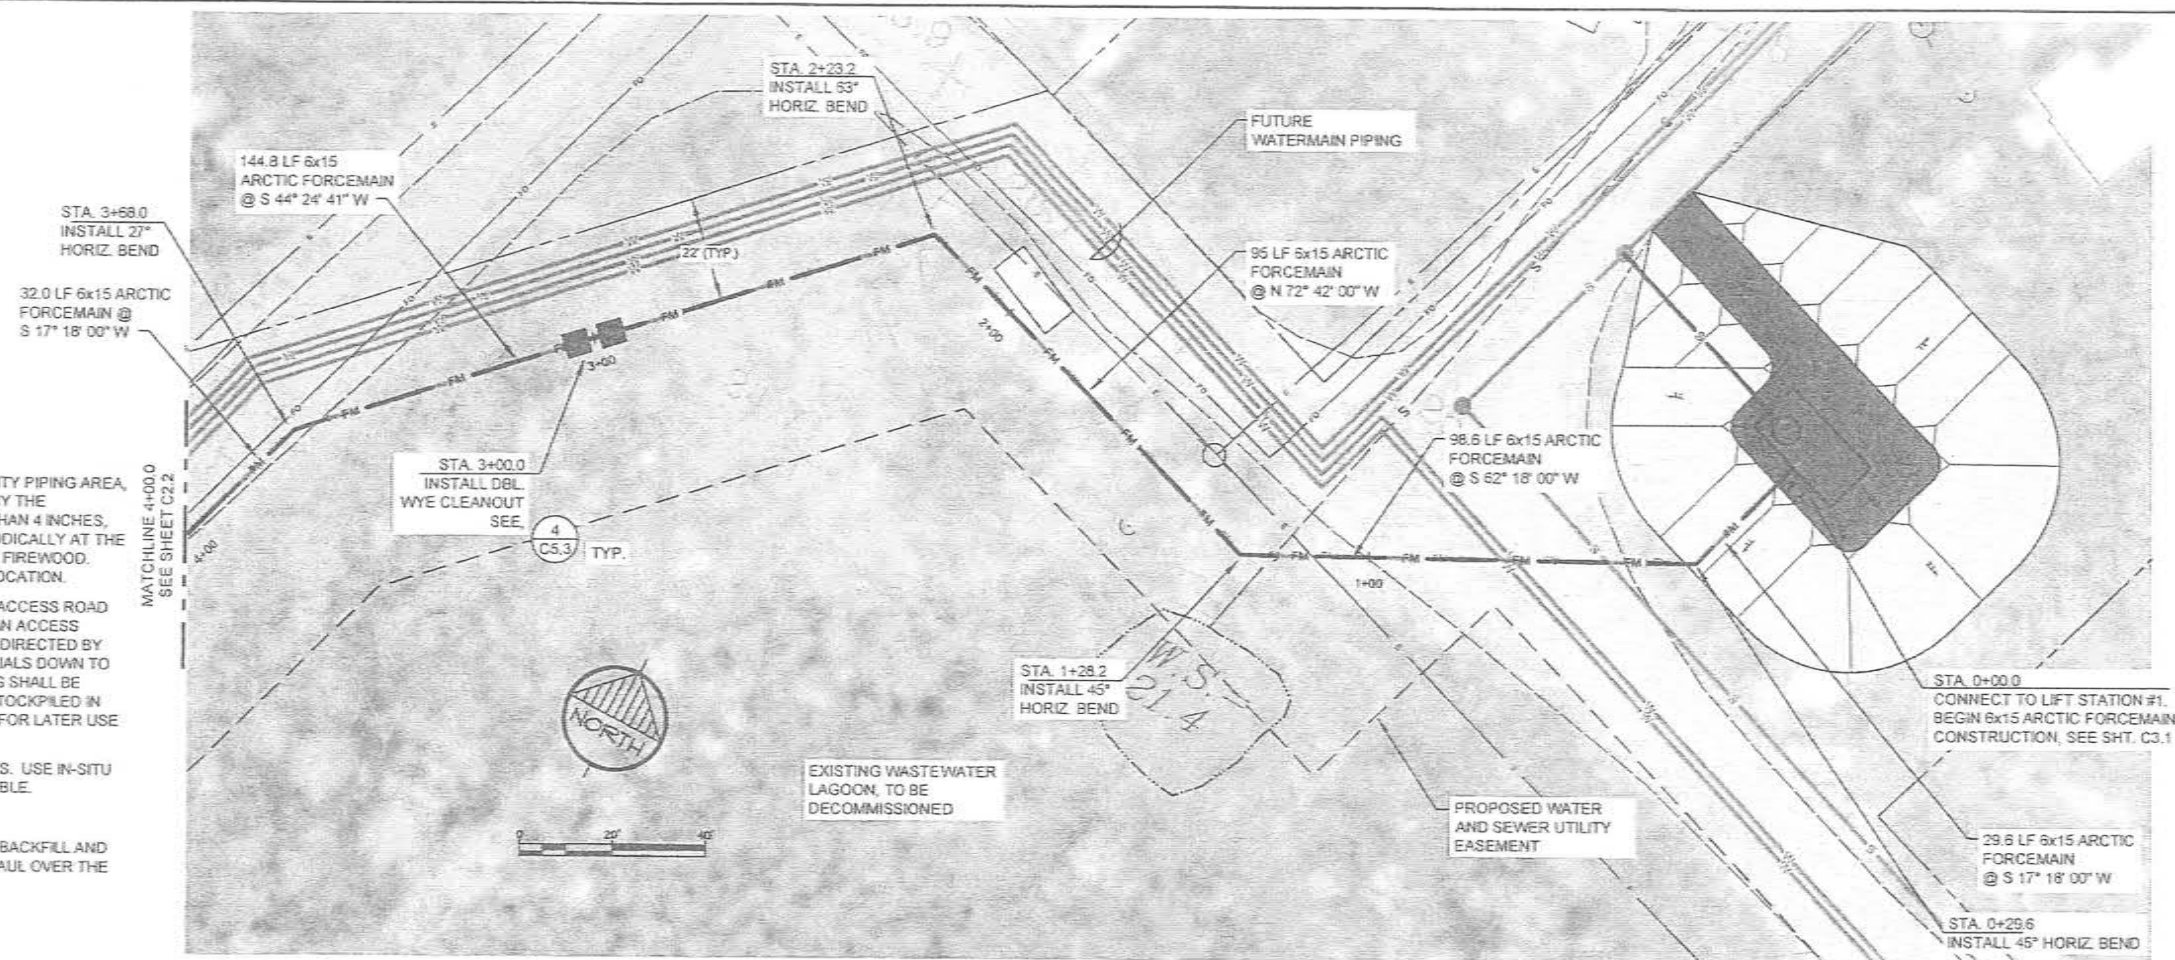

RECORD DRAWING CERTIFICATE
THESE DRAWINGS REFLECT RECORDED
INFORMATION OBTAINED DURING
CONSTRUCTION INFORMATION PROVIDED
HEREIN IS ACCURATE TO THE BEST OF MY
KNOWLEDGE.

SCALE:
AS SHOWN






2010-11 WASTEWATER
SYSTEM IMPROVEMENTS
FM1 FORCE MAIN
PLAN AND PROFILE
TULUKSAK, ALASKA



REVISION	BY	DATE
LAGOON RELOCATION	CM	8/10

Project No. JUNE 2009
Designed L&P
Drawn CM
Approved L&P
Sheet No. C2.1

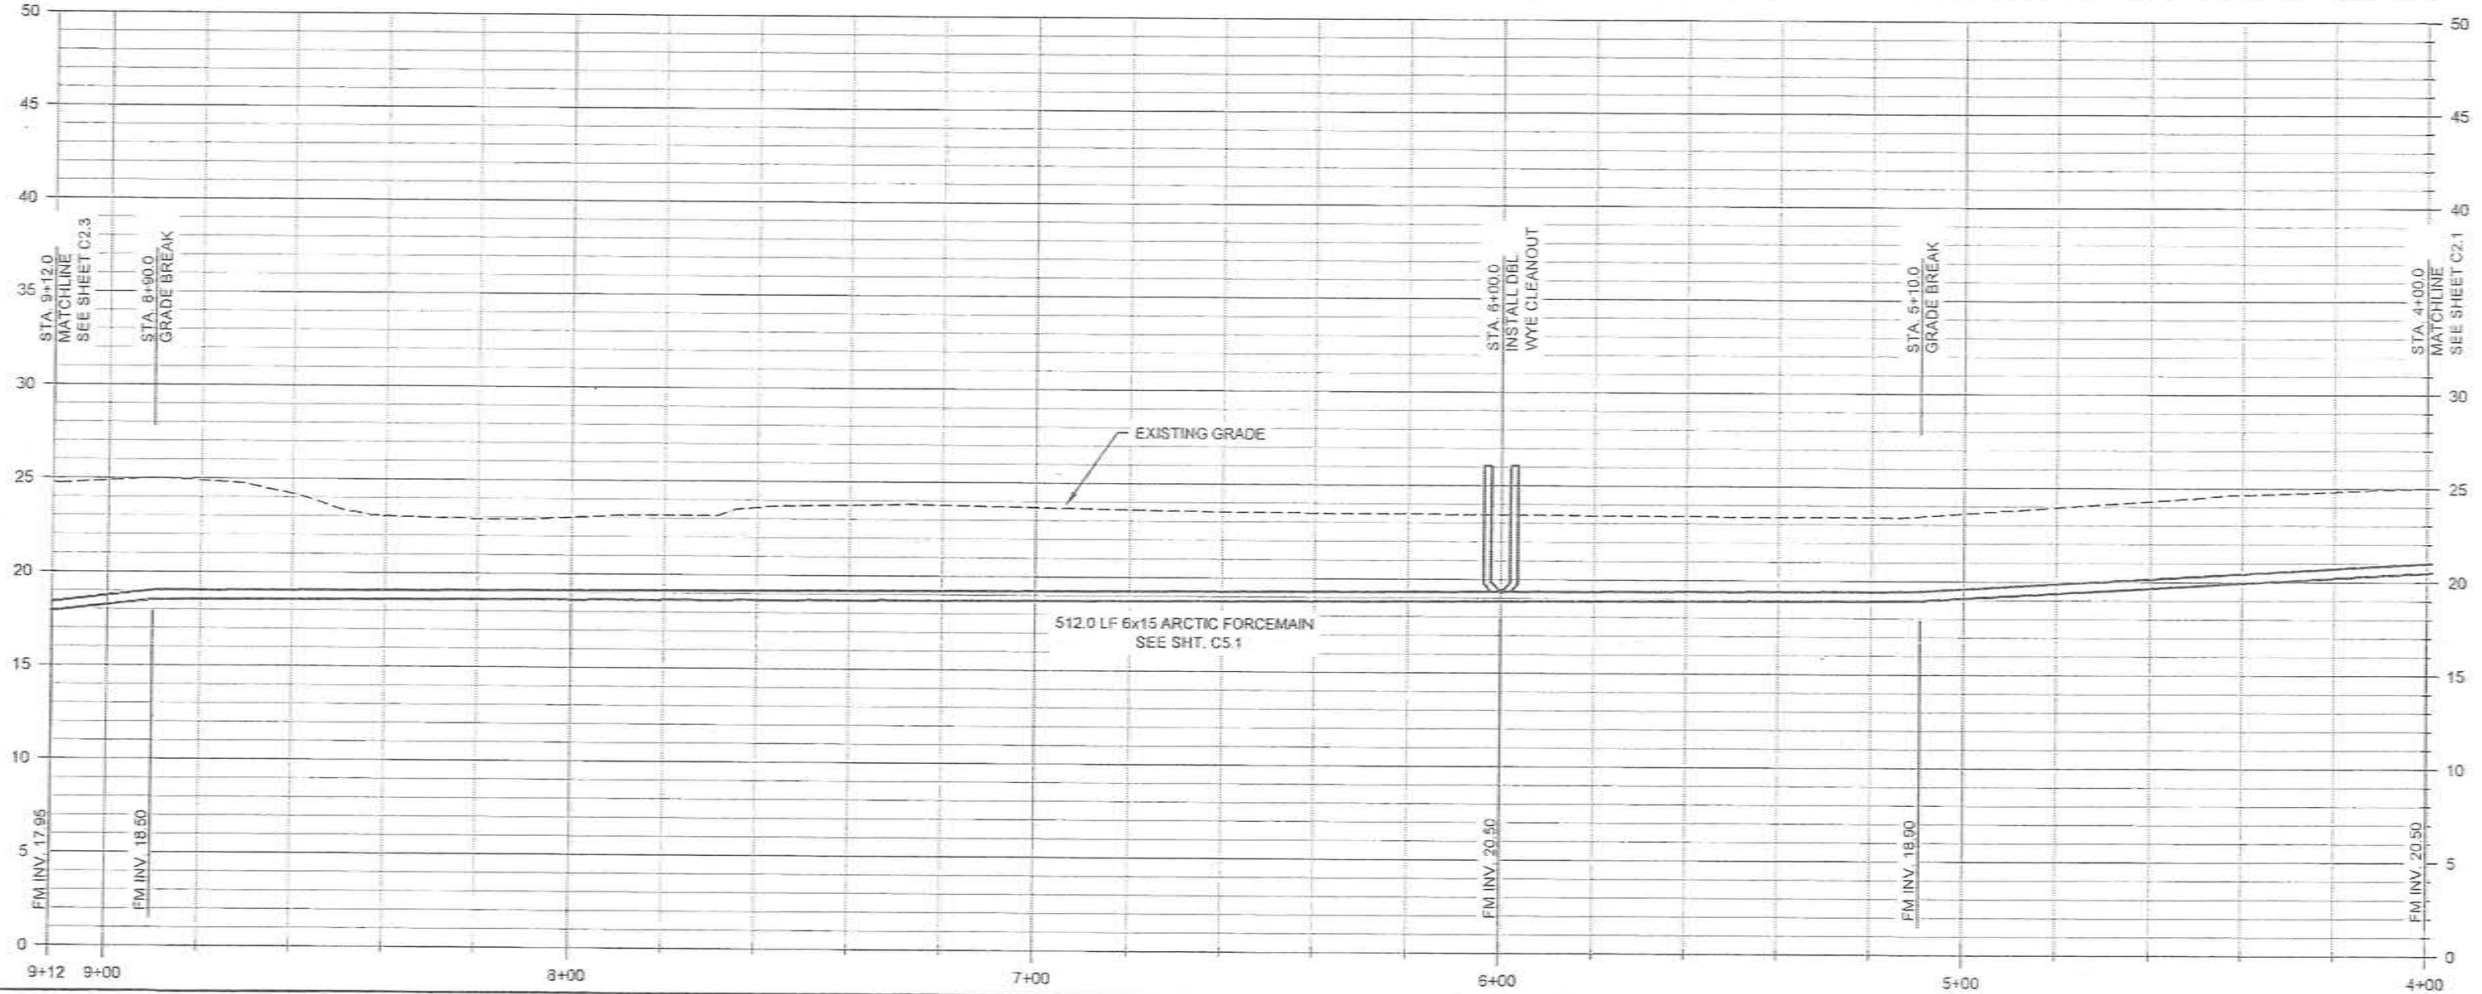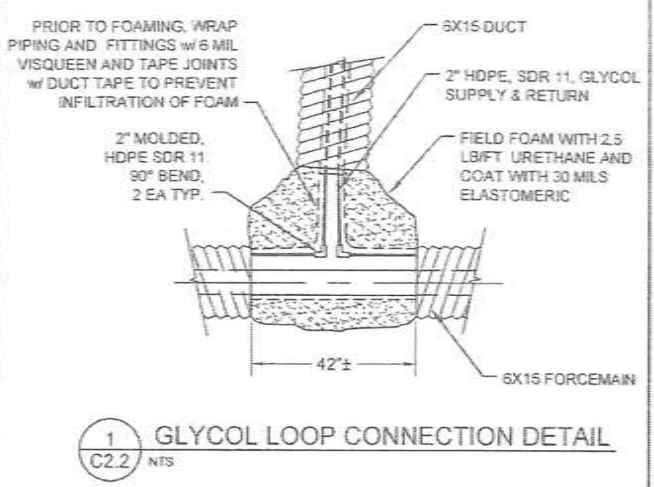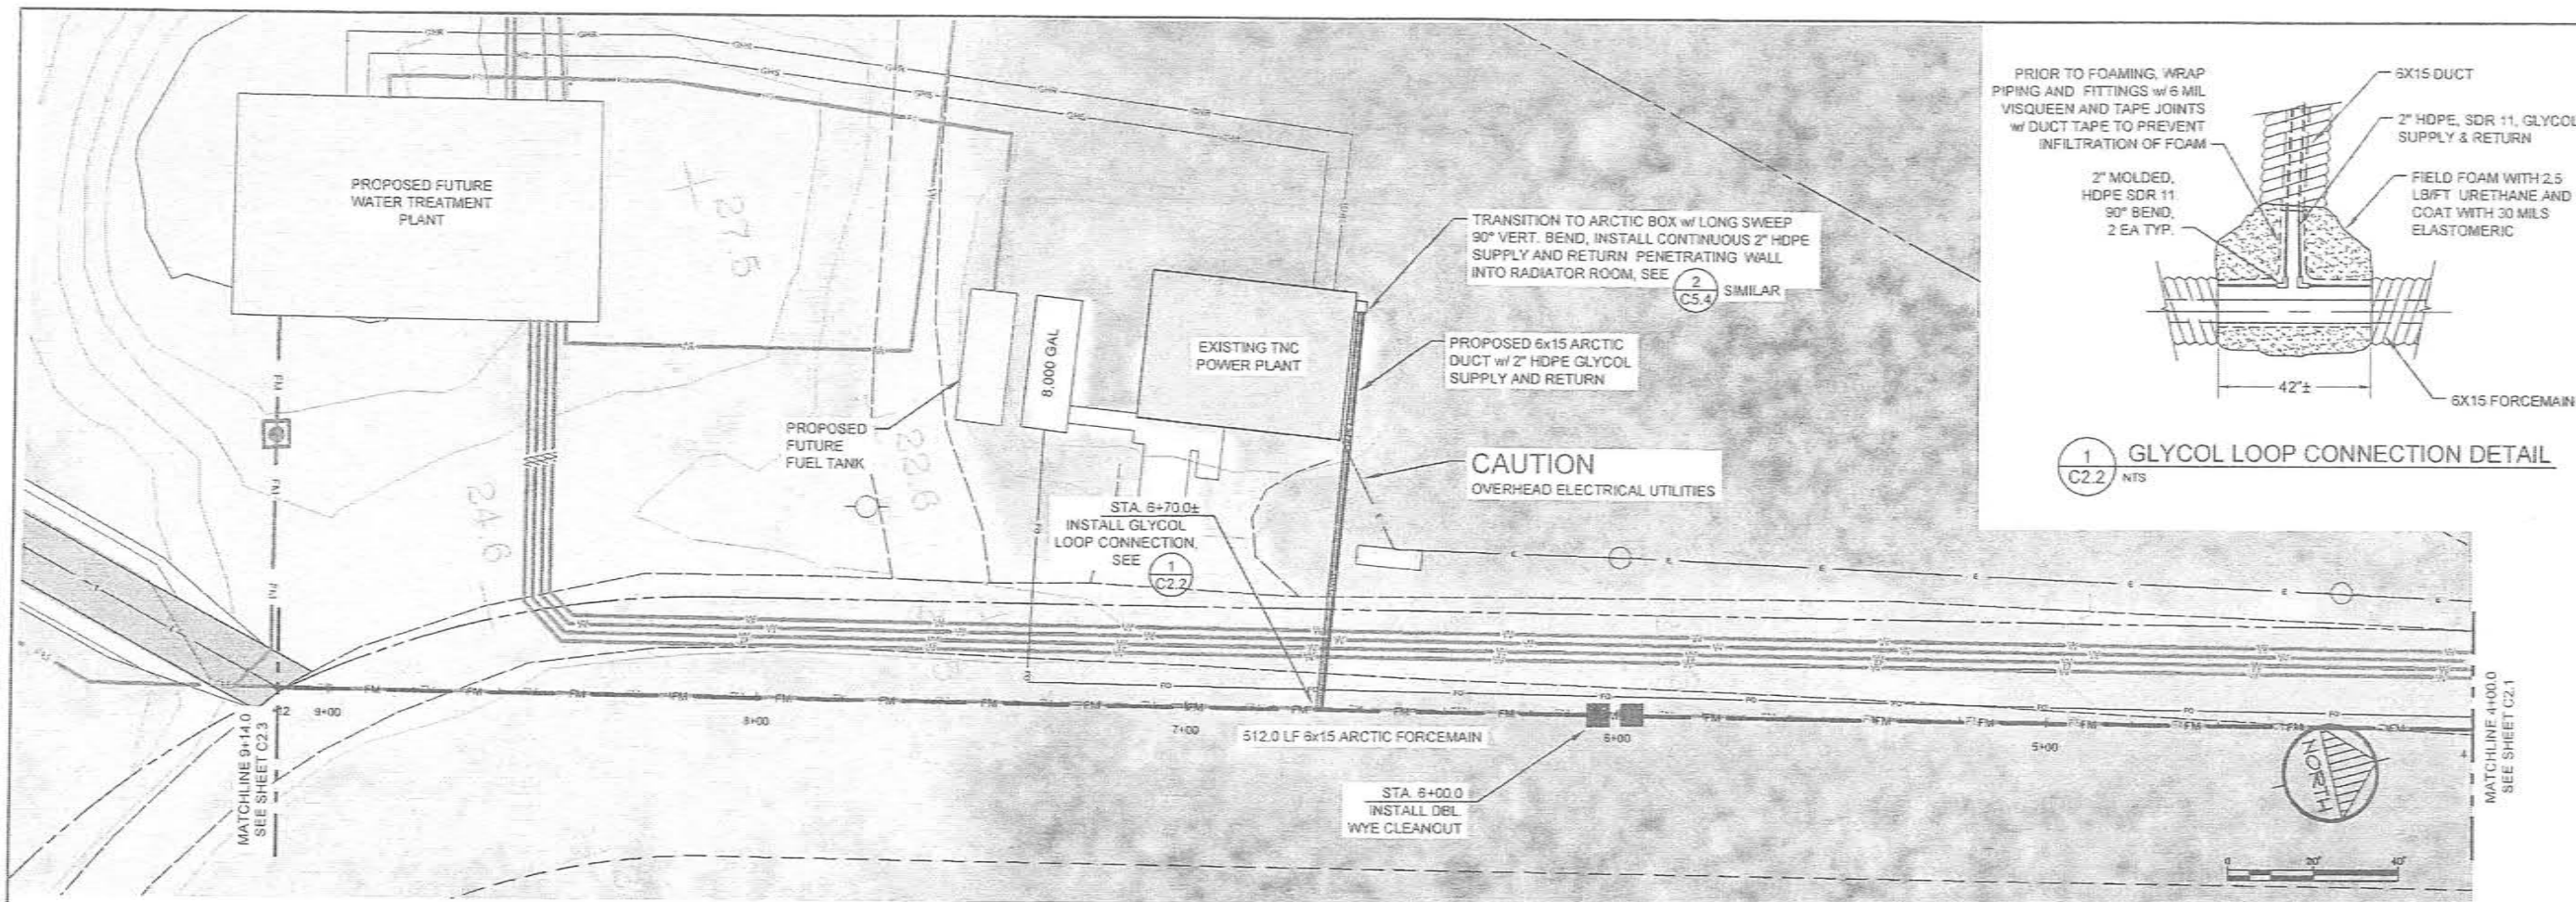

RECORD DRAWING CERTIFICATE

THESE DRAWINGS REFLECT RECORDED INFORMATION OBTAINED DURING CONSTRUCTION. INFORMATION PROVIDED HEREIN IS ACCURATE TO THE BEST OF MY KNOWLEDGE.

NAME _____ DATE _____

SCALE: AS SHOWN

1" = 40' HORIZONTAL
1" = 10' VERTICAL

2010-11 WASTEWATER SYSTEM IMPROVEMENTS




FM1 FORCE MAIN PLAN AND PROFILE

TULUKSAK, ALASKA

REVISION	BY	DATE
LAGOON RELOCATION	CM	9/10

Project No.	JUNE 2009
Design	LAP
Drawn	CM
Approved	LAP

Sheet No. **C2.2**

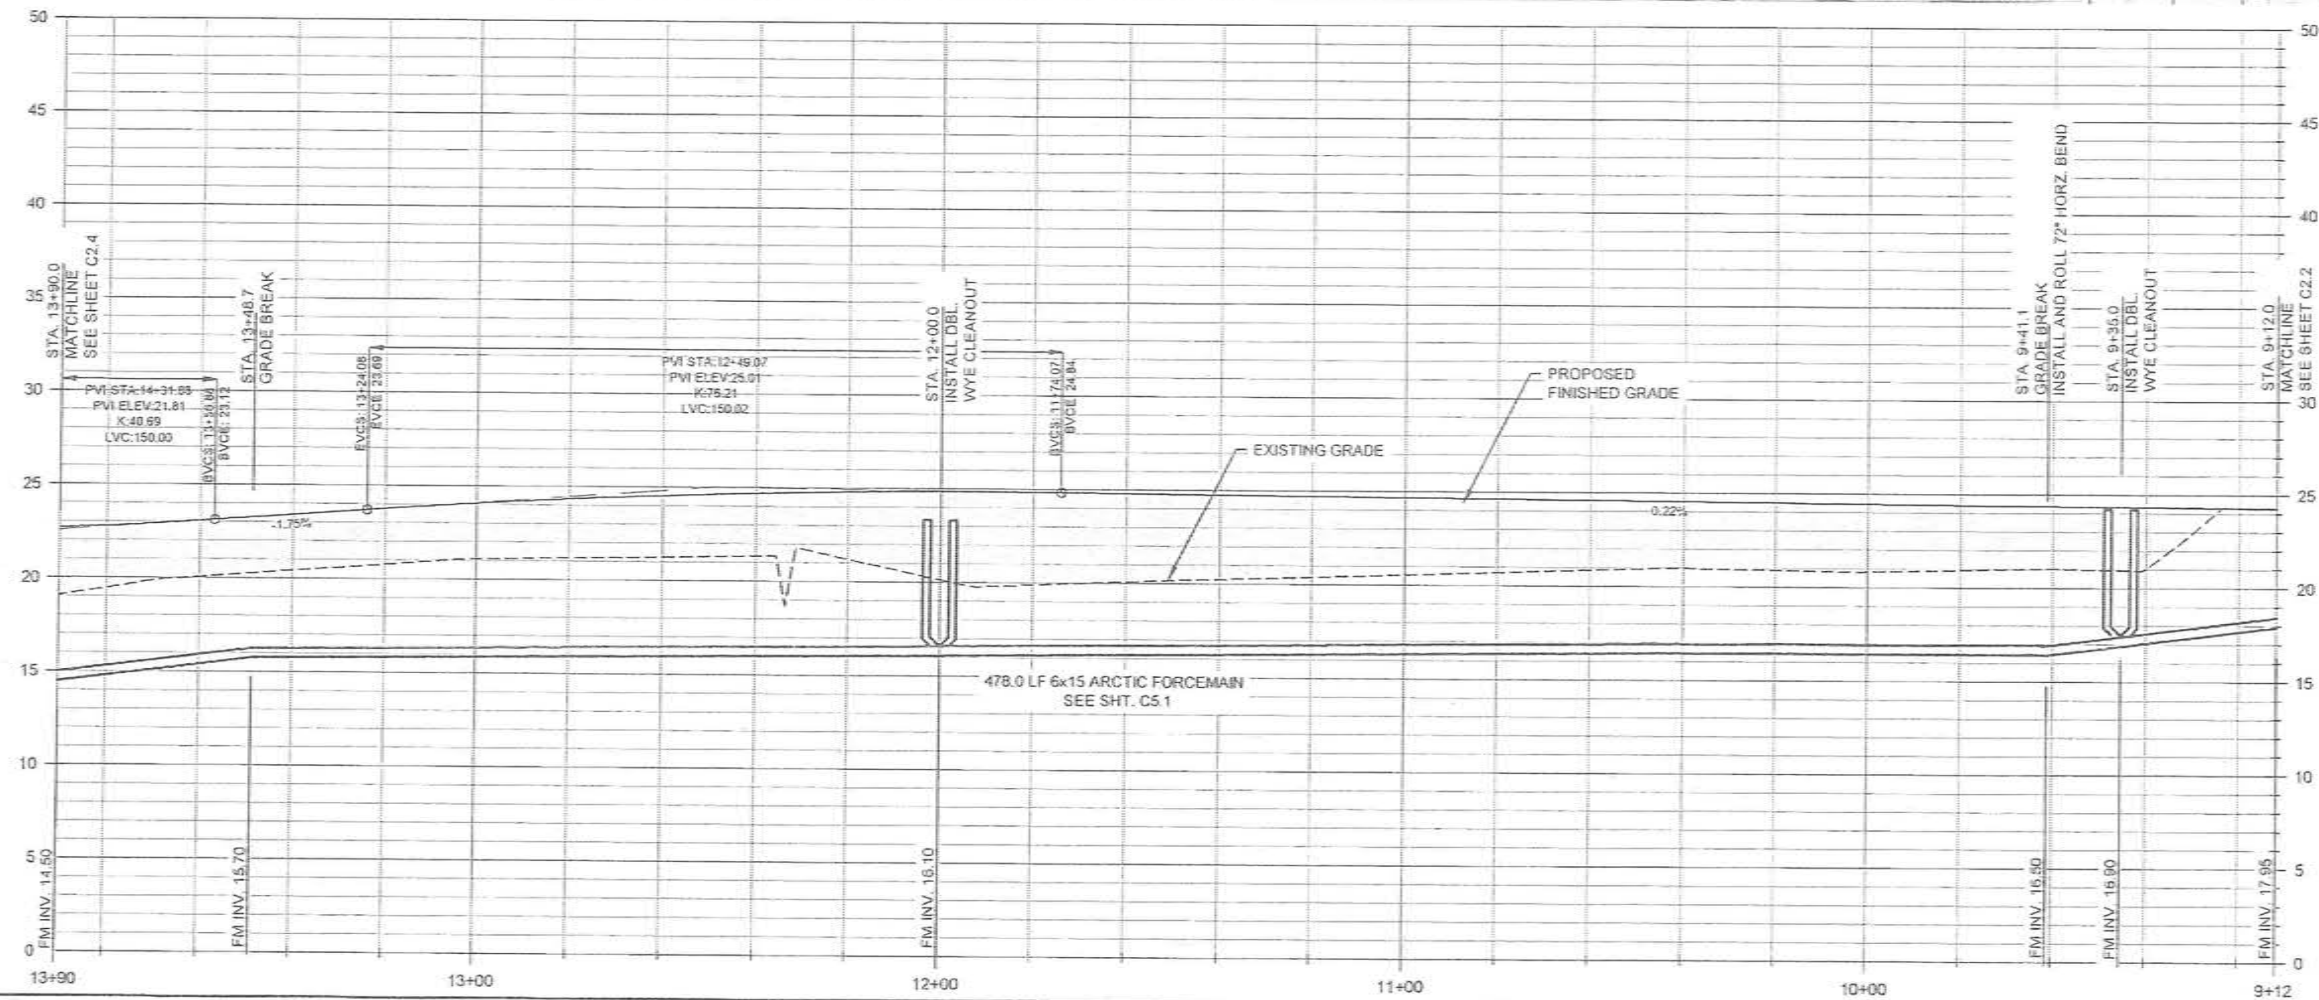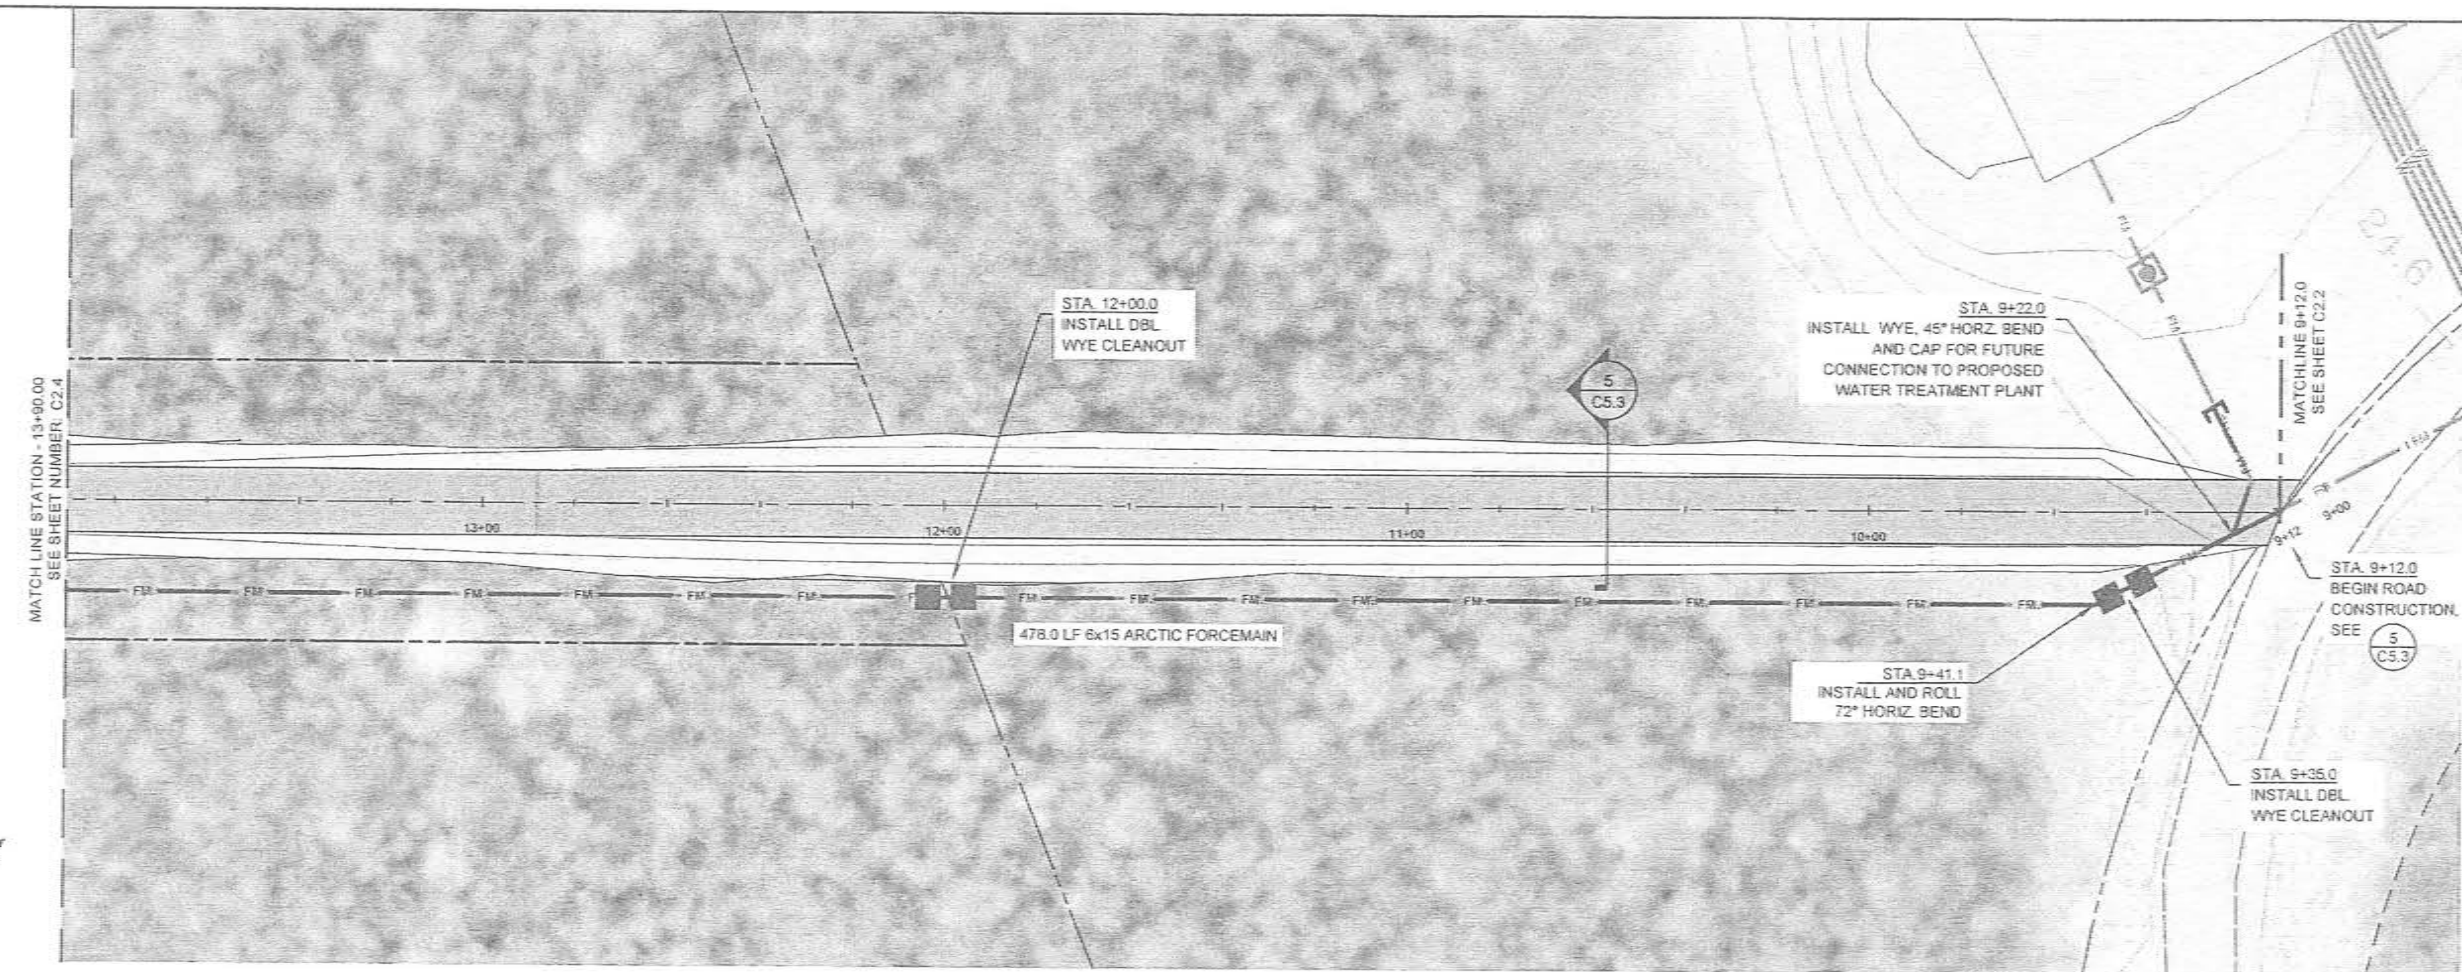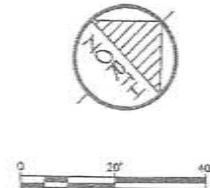

RECORD DRAWING CERTIFICATE
THESE DRAWINGS REFLECT RECORDED
INFORMATION OBTAINED DURING
CONSTRUCTION. INFORMATION PROVIDED
HEREIN IS ACCURATE TO THE BEST OF MY
KNOWLEDGE.
NAME _____ DATE _____


SCALE:
AS SHOWN
1" = 40'
1" = 80'
1" = 160'
1" = 320'
1" = 640'
1" = 1280'

2010-11 WASTEWATER
SYSTEM IMPROVEMENTS
ROAD AND
FM1 FORCE MAIN
PLAN AND PROFILE
TULUKSAK, ALASKA

REVISION	BY	DATE
LAGOON RELOCATION	CM	8/10

Project No.	JUNE 2009
Design	LAP
Drawn	CM
Approved	LAP

Sheet No. C2.3

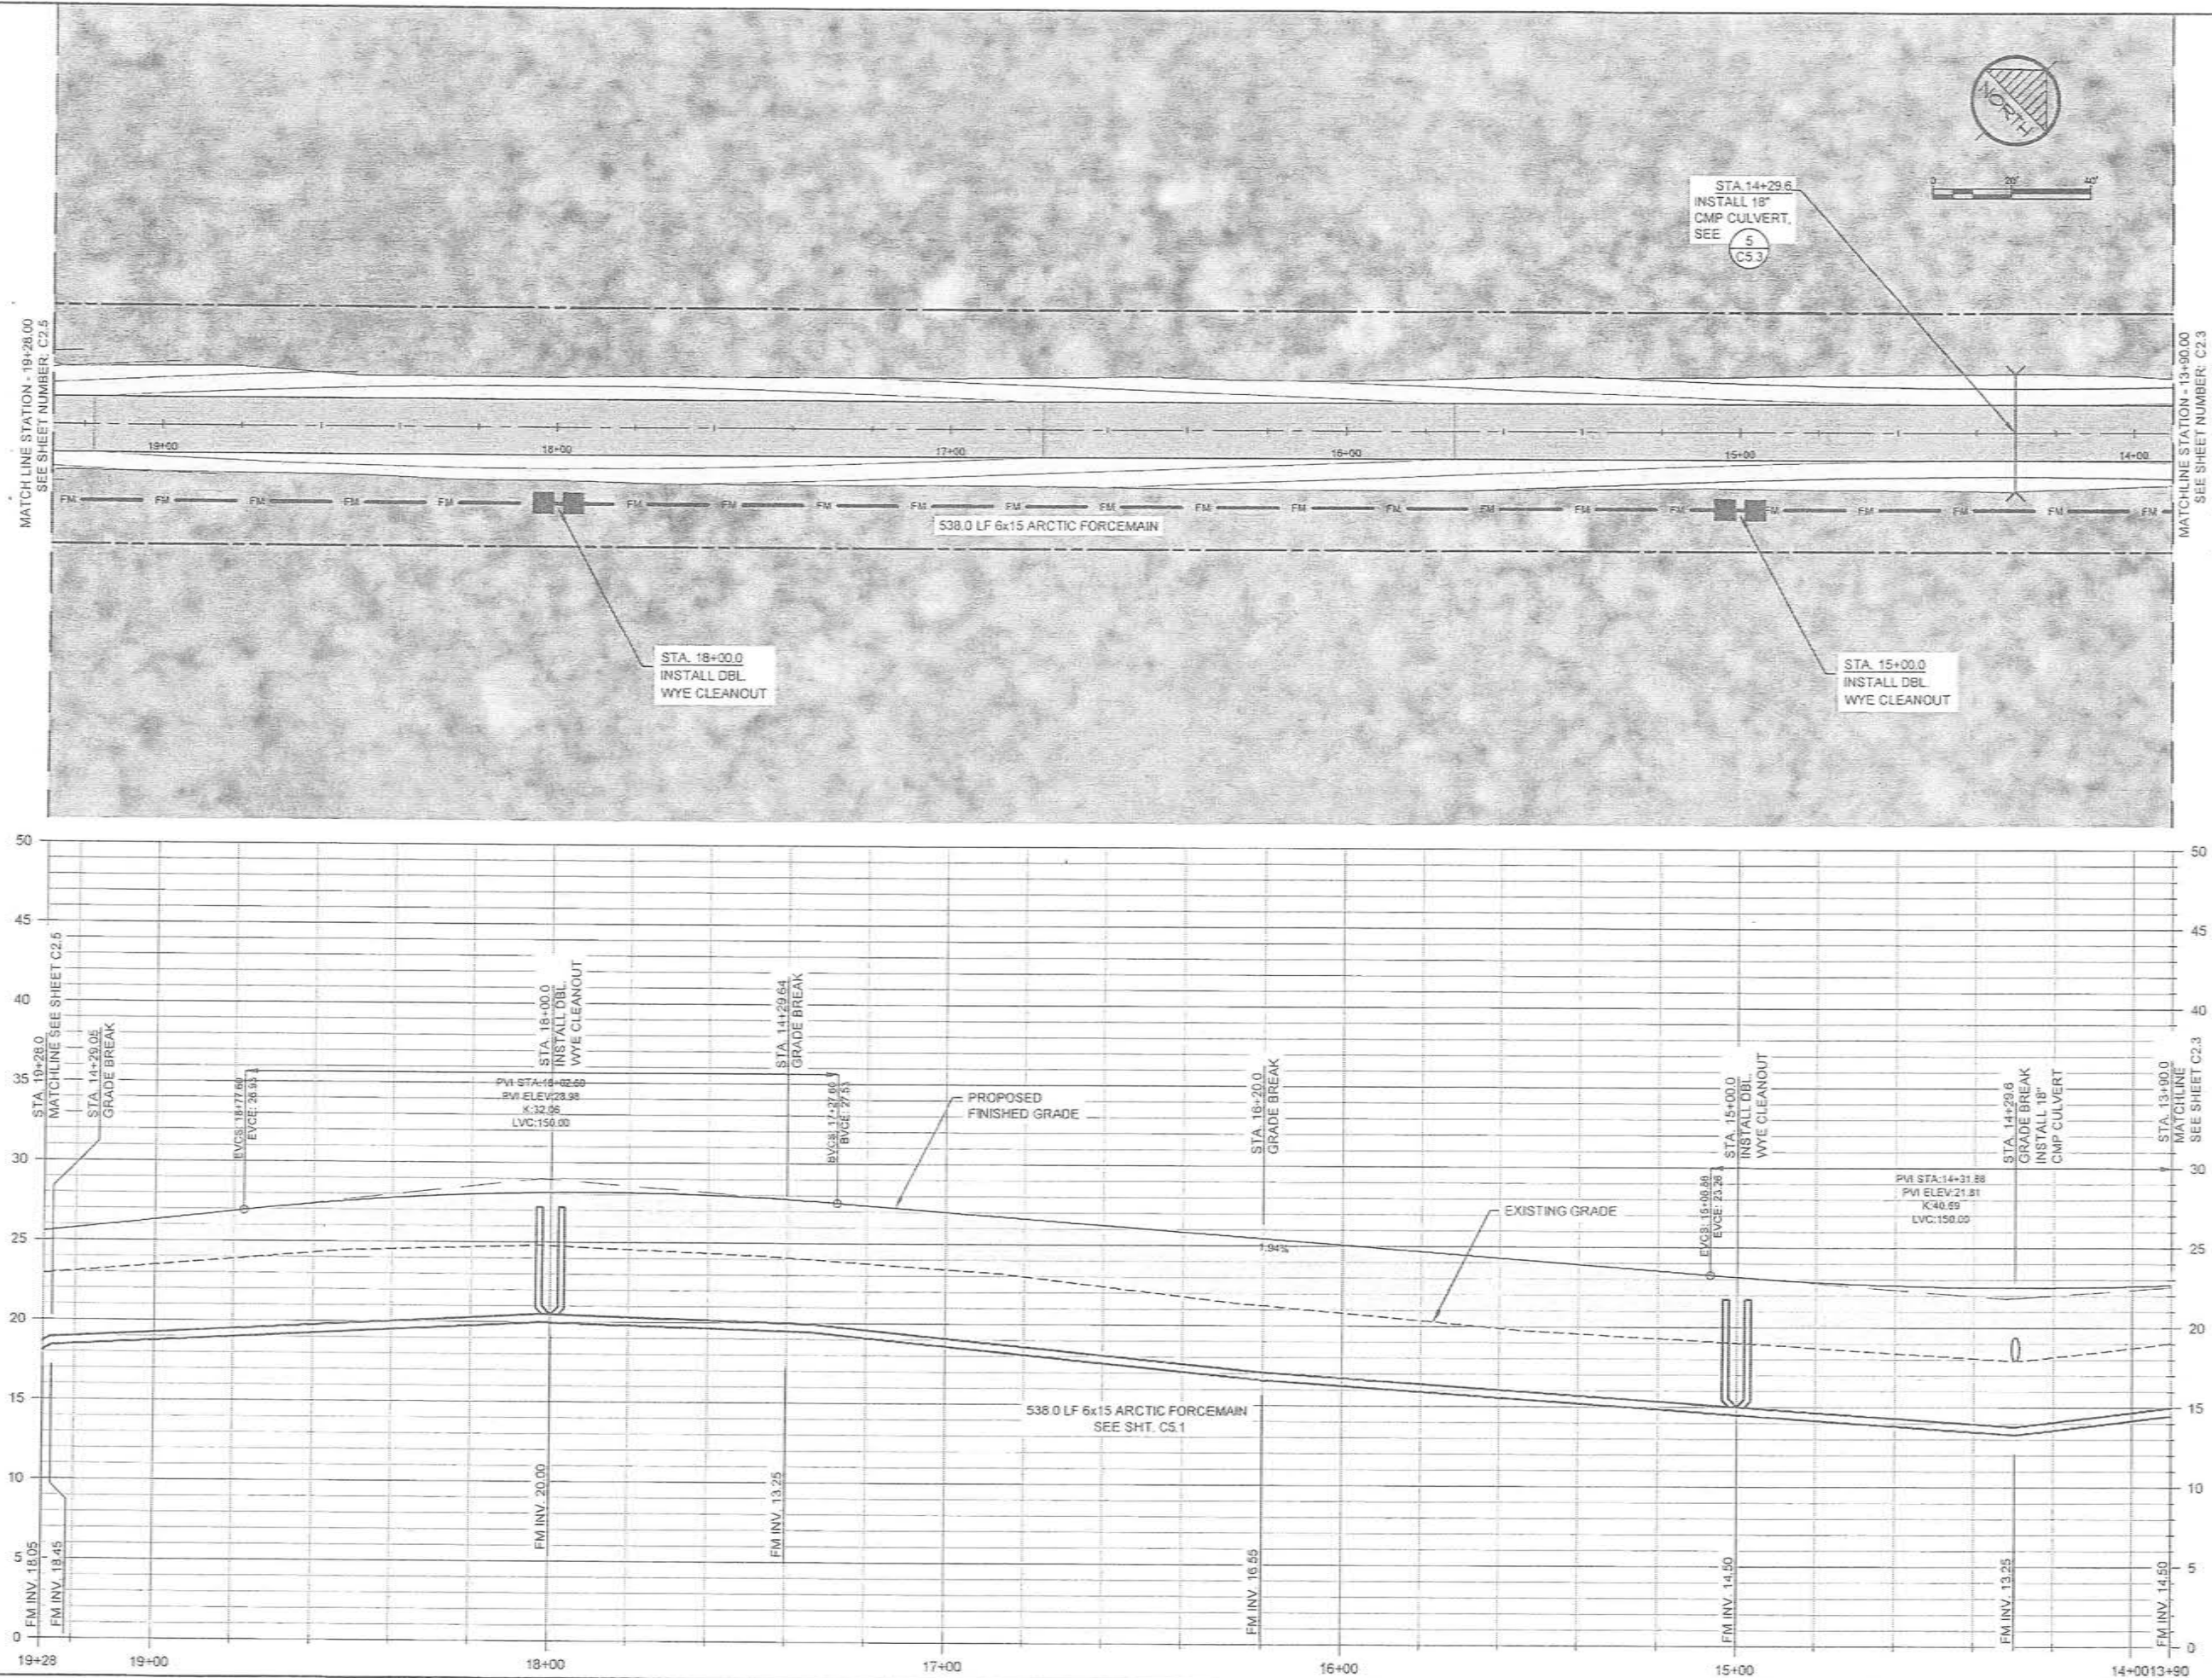

RECORD DRAWING CERTIFICATE
THESE DRAWINGS REFLECT RECORDED
INFORMATION OBTAINED DURING
CONSTRUCTION INFORMATION PROVIDED
HEREIN IS ACCURATE TO THE BEST OF MY
KNOWLEDGE.

SCALE: AS SHOWN

NAME _____ DATE _____



2010-11 WASTEWATER
SYSTEM IMPROVEMENTS

ROAD AND
FM1 FORCE MAIN
PLAN AND PROFILE


TULUKSAK, ALASKA



REVISION	BY	DATE
LAGOON RELOCATION	CM	8/10

Project No.	JUNE 2009
Date	LAP
Designed	CM
Drawn	LAP
Approved	LAP

Sheet No. C2.4

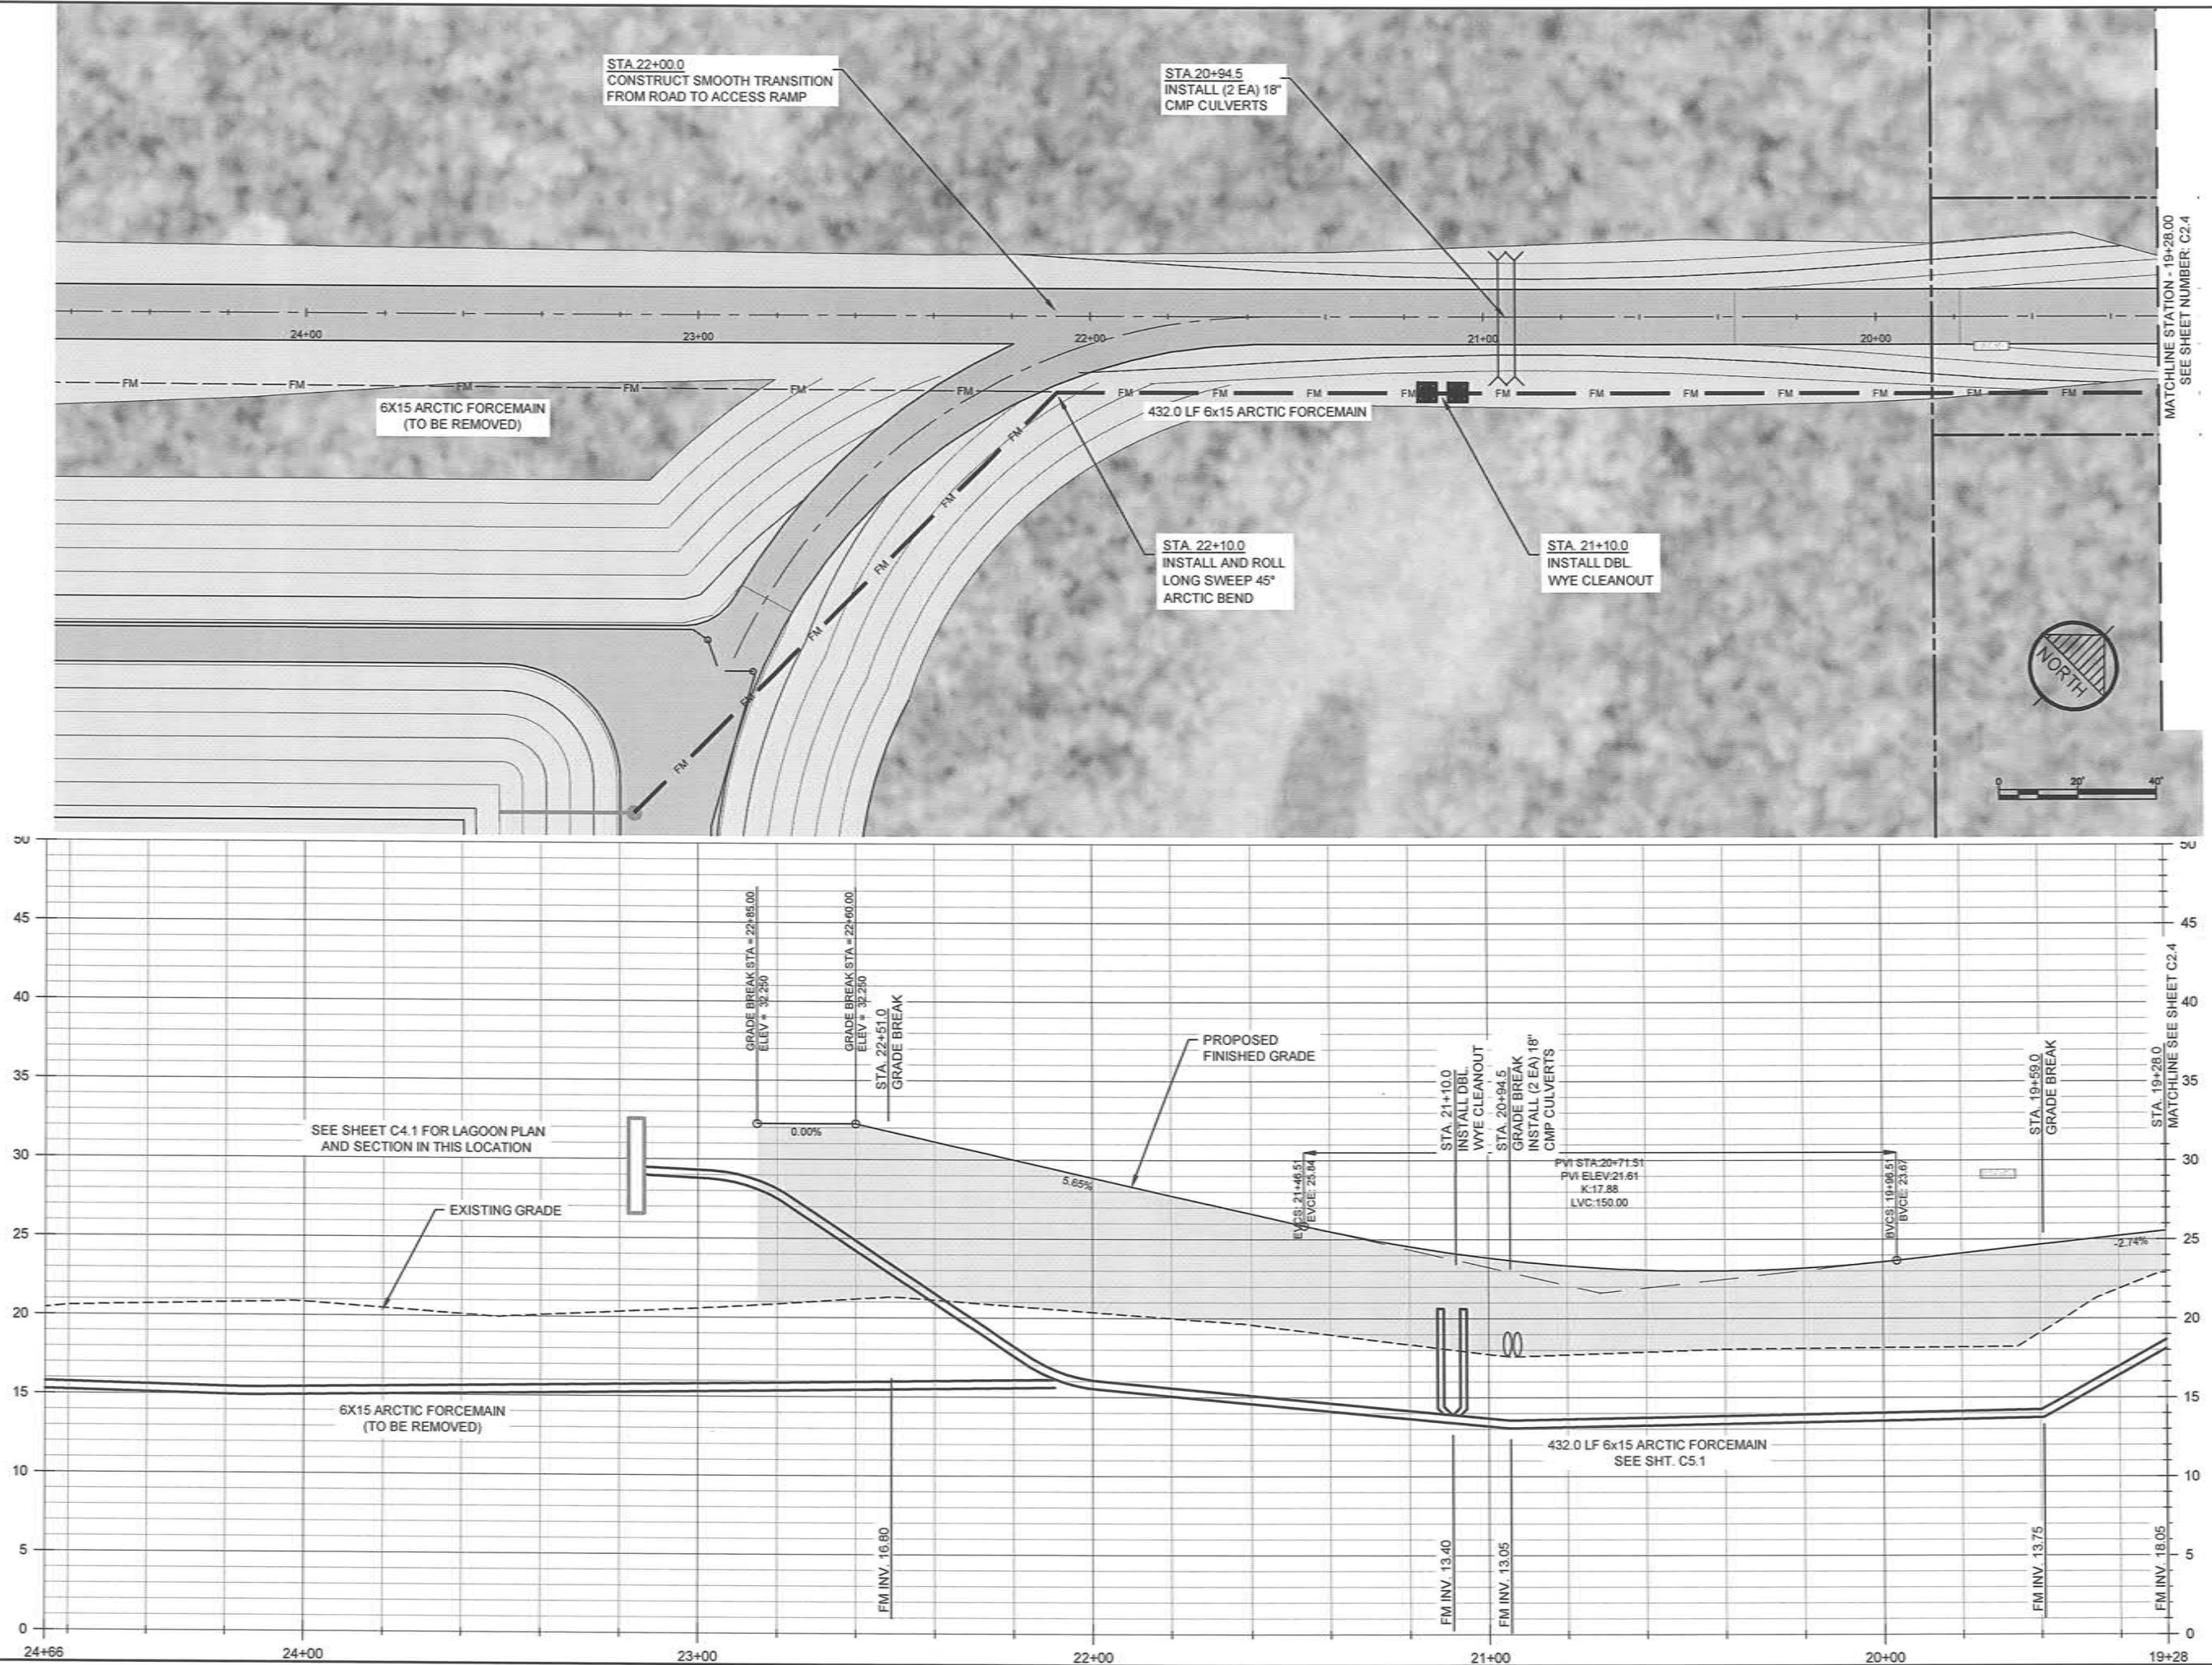


RECORD DRAWING CERTIFICATE
THESE DRAWINGS REFLECT RECORDED
INFORMATION OBTAINED DURING
CONSTRUCTION. INFORMATION PROVIDED
HEREIN IS ACCURATE TO THE BEST OF MY
KNOWLEDGE.

NAME _____ DATE _____

SCALE:
AS SHOWN

DATE IS ONE EIGHT ON
DRAWING NUMBER

IF NOT ONE EIGHT ON
DRAWING NUMBER
SCALE ACCORDINGLY

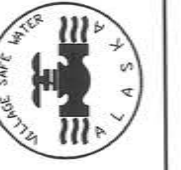

2010-11 WASTEWATER
SYSTEM IMPROVEMENTS

ROAD AND
FM1 FORCE MAIN
PLAN AND PROFILE

TULUKSAK, ALASKA

CER
ENGINEERS, INC.


PO BOX 22046 ANCHORAGE, AK 99503 PH 907-546-9100 FAX 907-546-0105

REVISION	BY	DATE
LAGOON RELOCATION	CM	8/10
LAGOON RELOCATION	CM	4/14

Project No. _____
Date APRIL 2014
Designed MRE
Drawn CM
Approved MRE

Sheet No.
C2.5

G:\ACAD\TULUKSAK\TLT0901 2008 Waste water disposal area\IFC Rev Apr 2014\C2.1_C2.8 ROAD AND FORCEMAIN P&P.dwg, 5/6/2014 6:01:27 PM, cmeiz, \\Ce2main\LANIER MP C2050\LD520C PCL 6

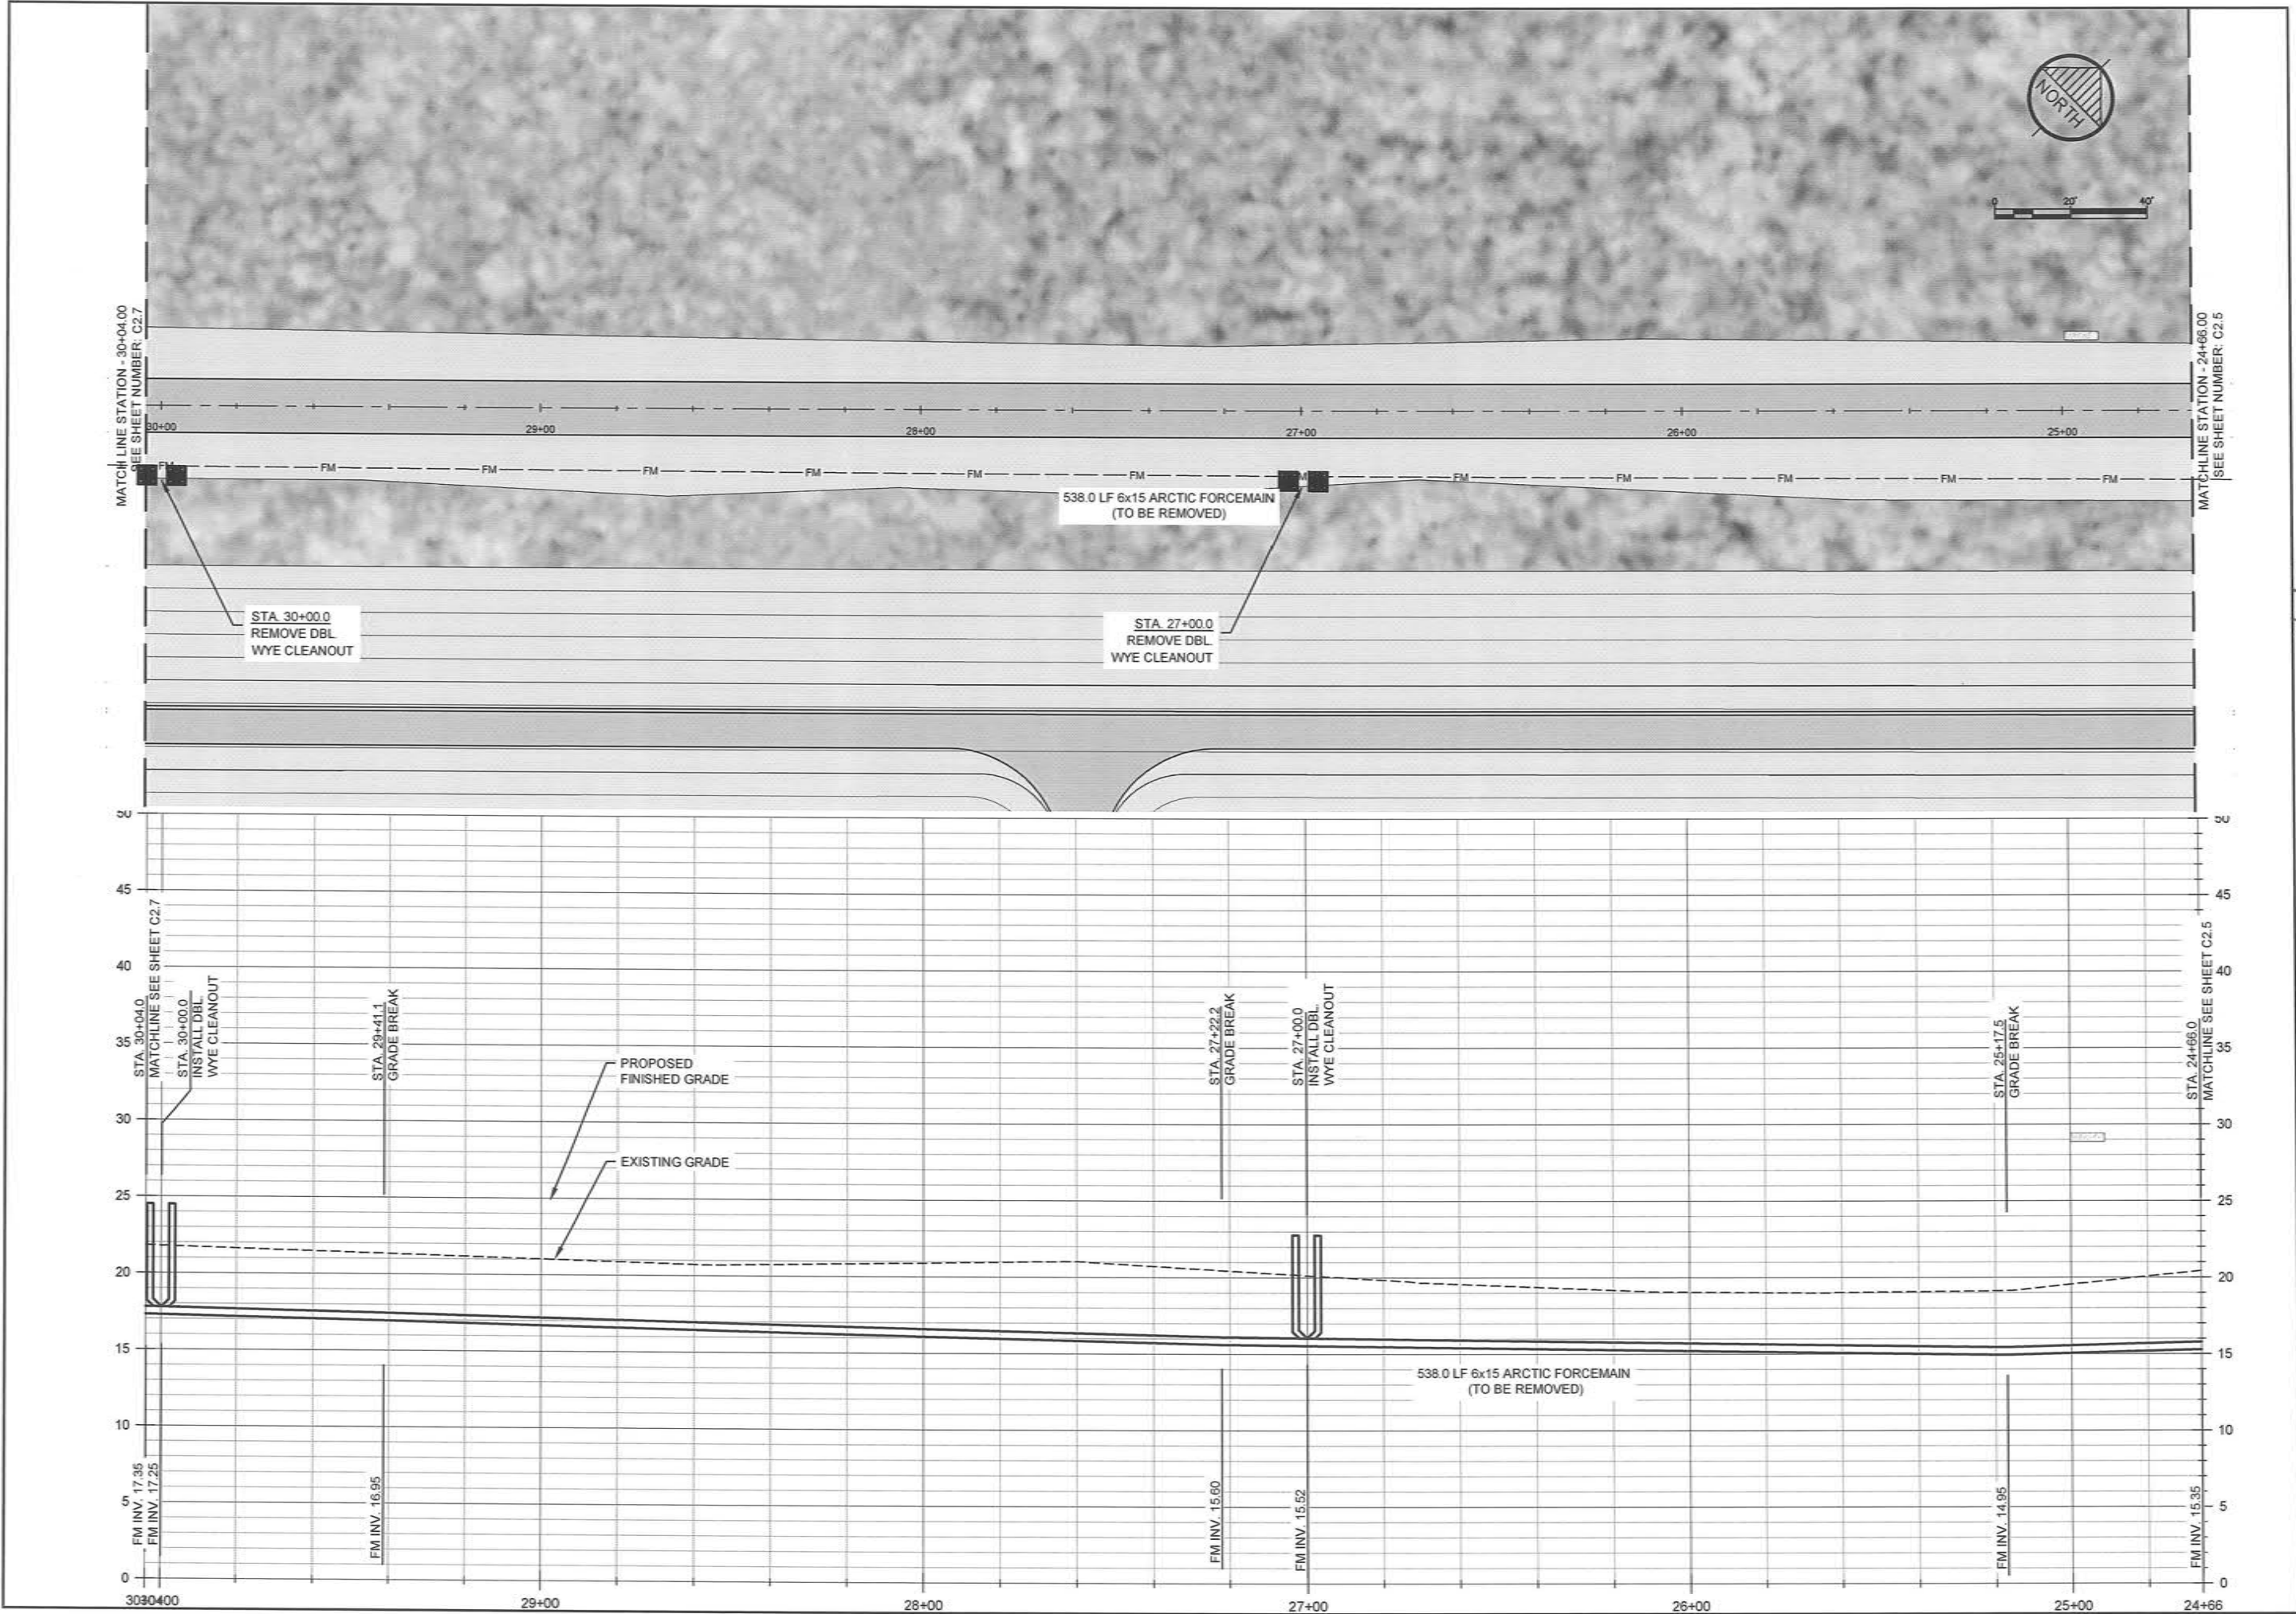

RECORD DRAWING CERTIFICATE
THESE DRAWINGS REFLECT RECORDED
INFORMATION OBTAINED DURING
CONSTRUCTION. INFORMATION PROVIDED
HEREIN IS ACCURATE TO THE BEST OF MY
KNOWLEDGE.

SCALE:
AS SHOWN
IF NOT ONE INCH ON
SCALE ACCORDINGLY



2010-11 WASTEWATER
SYSTEM IMPROVEMENTS
ROAD AND
FM1 FORCE MAIN
PLAN AND PROFILE
TULUKSAK, ALASKA

CE2
ENGINEERS, INC.
PO BOX 22266 ANCHORAGE, AK 99523 PH 907-549-0010 FAX 907-549-0105

REVISION	BY	DATE
LAGOON RELOCATION	CM	8/10
LAGOON RELOCATION	CM	4/14

Project No. APRIL 2014
Date APRIL 2014
Designed MRE
Drawn CM
Approved MRE


Sheet No.
C2.6

MATCHLINE STATION - 35+42.00
SEE SHEET NUMBER: C2.8

STA. 35+42.0
MATCHLINE SEE SHEET C2.8

MATCHLINE STATION - 30+04.00
SEE SHEET NUMBER: C2.6

STA. 30+04.0
MATCHLINE SEE SHEET C2.6

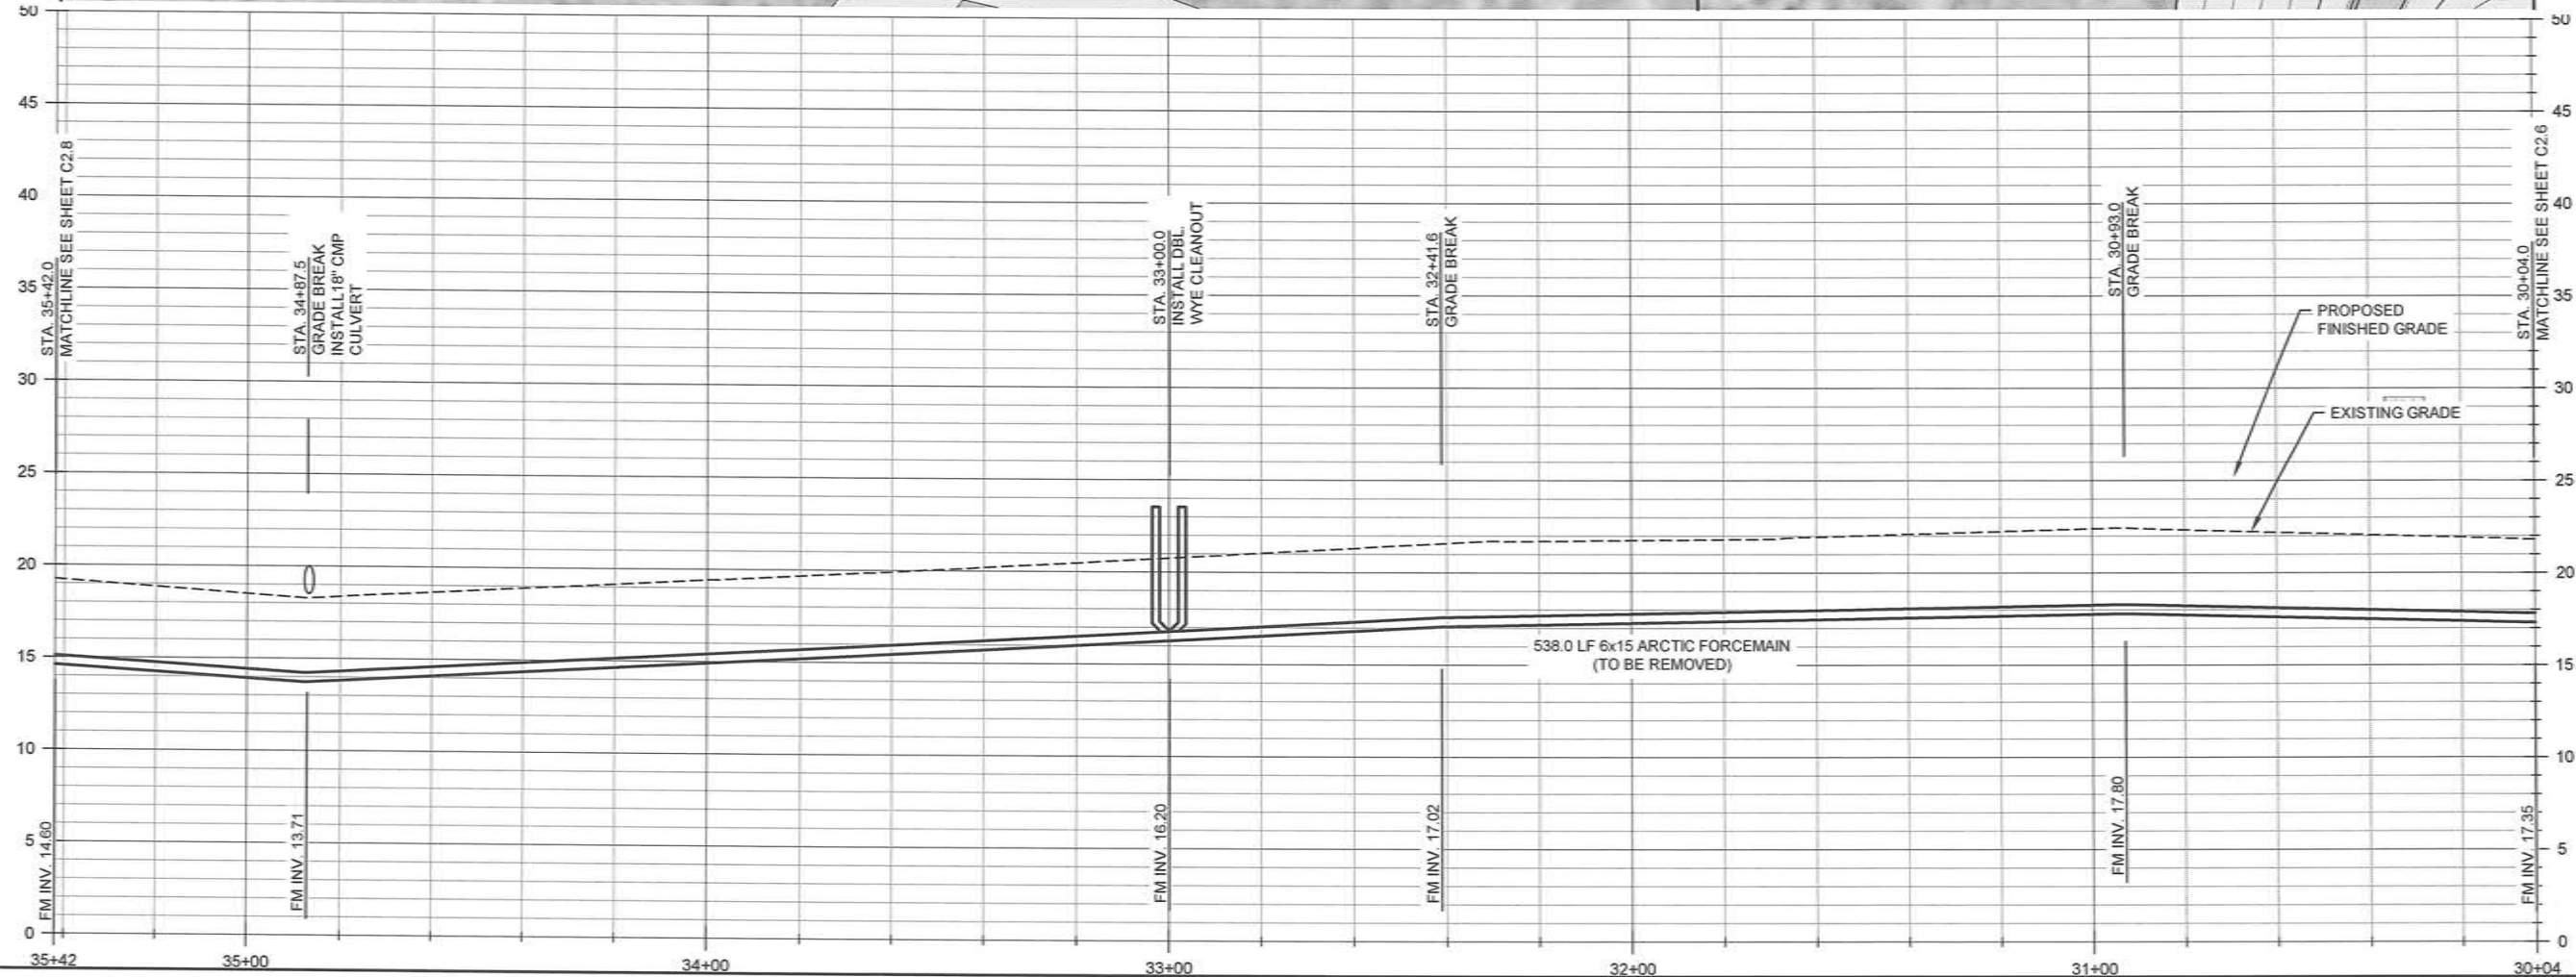

STA 34+87.5
INSTALL (2 EA) 18\"/>

STA. 33+00.0
REMOVE DBL
WYE CLEANOUT

538.0 LF 6x15 ARCTIC FORCEMAIN
(TO BE REMOVED)

STA. 33+00.0
INSTALL DBL
WYE CLEANOUT

STA. 32+41.6
GRADE BREAK

STA. 30+33.0
GRADE BREAK

PROPOSED
FINISHED GRADE

EXISTING GRADE



RECORD DRAWING CERTIFICATE
THESE DRAWINGS REFLECT RECORDED
INFORMATION OBTAINED DURING
CONSTRUCTION. INFORMATION PROVIDED
HEREIN IS ACCURATE TO THE BEST OF MY
KNOWLEDGE.

SCALE:
AS SHOWN

DATE: 5/7/14

NAME: _____ DATE: _____



2010-11 WASTEWATER
SYSTEM IMPROVEMENTS

ROAD AND
FM1 FORCE MAIN
PLAN AND PROFILE

TULUKSAK, ALASKA





REVISION	BY	DATE
LAGOON RELOCATION	CM	8/10
LAGOON RELOCATION	CM	4/14

Project No. _____
Date: APRIL 2014
Designed: MRE
Drawn: MRE
Approved: LAP

Sheet No.
C2.7

G:\ACAD\TULUKSAK\TLT0901. 2008 Waste water disposal area\JFC Rev Apr 2014\C2.1_C2.8 ROAD AND FORCEMAIN P&P.dwg, 5/6/2014 6:05:13 PM, cmerz, \\Cc2main\LANIER MP C2050\LD520C PCL 6

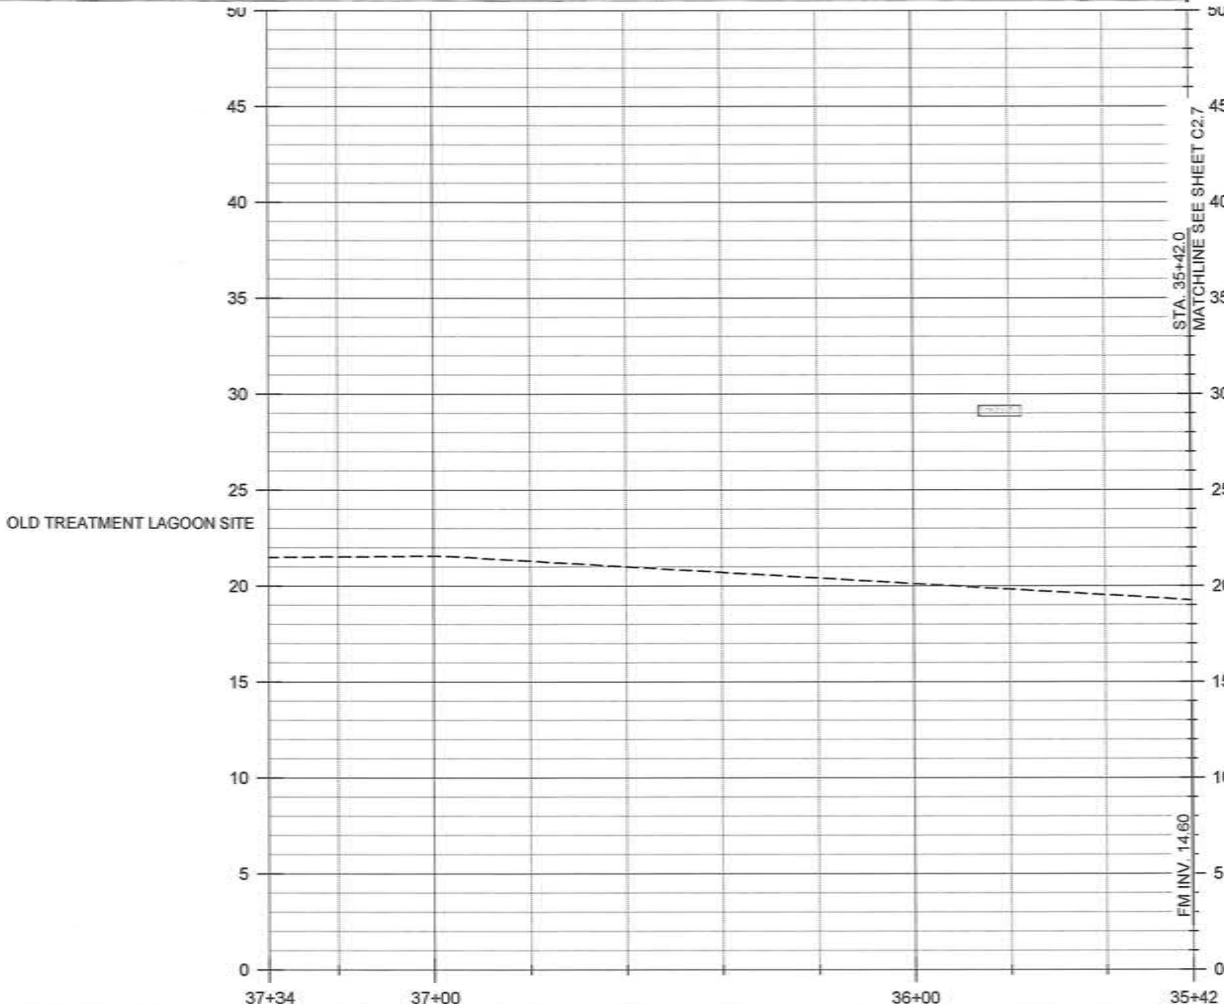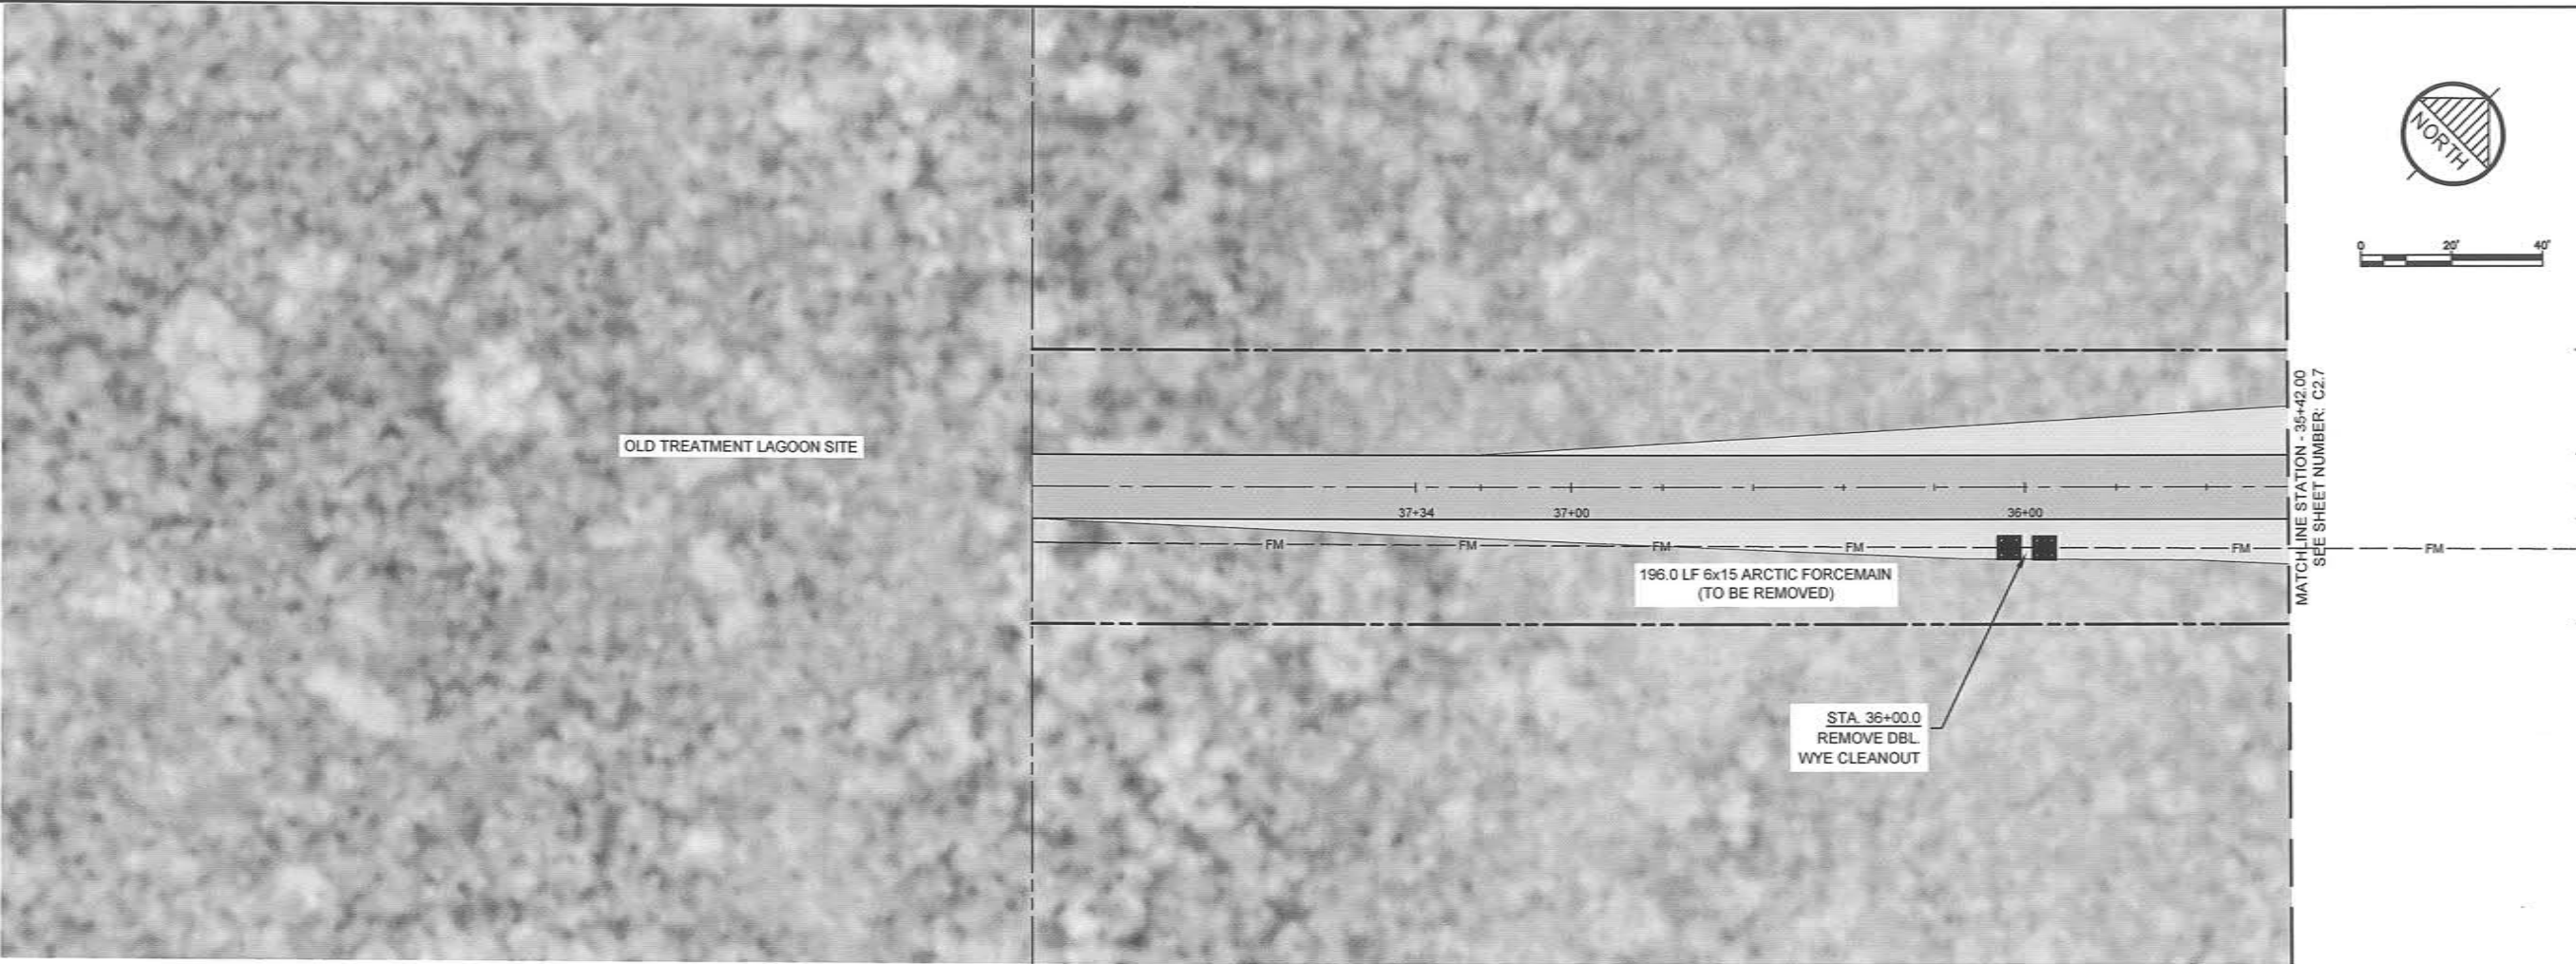

RECORD DRAWING CERTIFICATE
THESE DRAWINGS REFLECT RECORDED
INFORMATION OBTAINED DURING
CONSTRUCTION. INFORMATION PROVIDED
HEREIN IS ACCURATE TO THE BEST OF MY
KNOWLEDGE.

SCALE:
AS SHOWN
DATE: 5/7/14
DRAWN BY: CM
DESIGNED BY: MRE
APPROVED BY: MRE

NAME _____ DATE _____

ALLIANCE WATER
TULUKSAK, ALASKA

STATE OF ALASKA
49 TH
Michael R. Erdman
No. 8252
Professional Engineer

2010-11 WASTEWATER
SYSTEM IMPROVEMENTS
ROAD AND
FM1 FORCE MAIN
PLAN AND PROFILE
TULUKSAK, ALASKA


CE2
ENGINEERS, INC.
PO BOX 22966 ANCHORAGE, AK 99523 PH: 907-546-1010 FAX: 907-546-1015

BY DATE
CM 8/10
CM 4/14

REVISION
LAGOON RELOCATION
LAGOON RELOCATION

Project No. _____
Date: APRIL 2014
Designed: MRE
Drawn: CM
Approved: MRE

Sheet No. C2.8

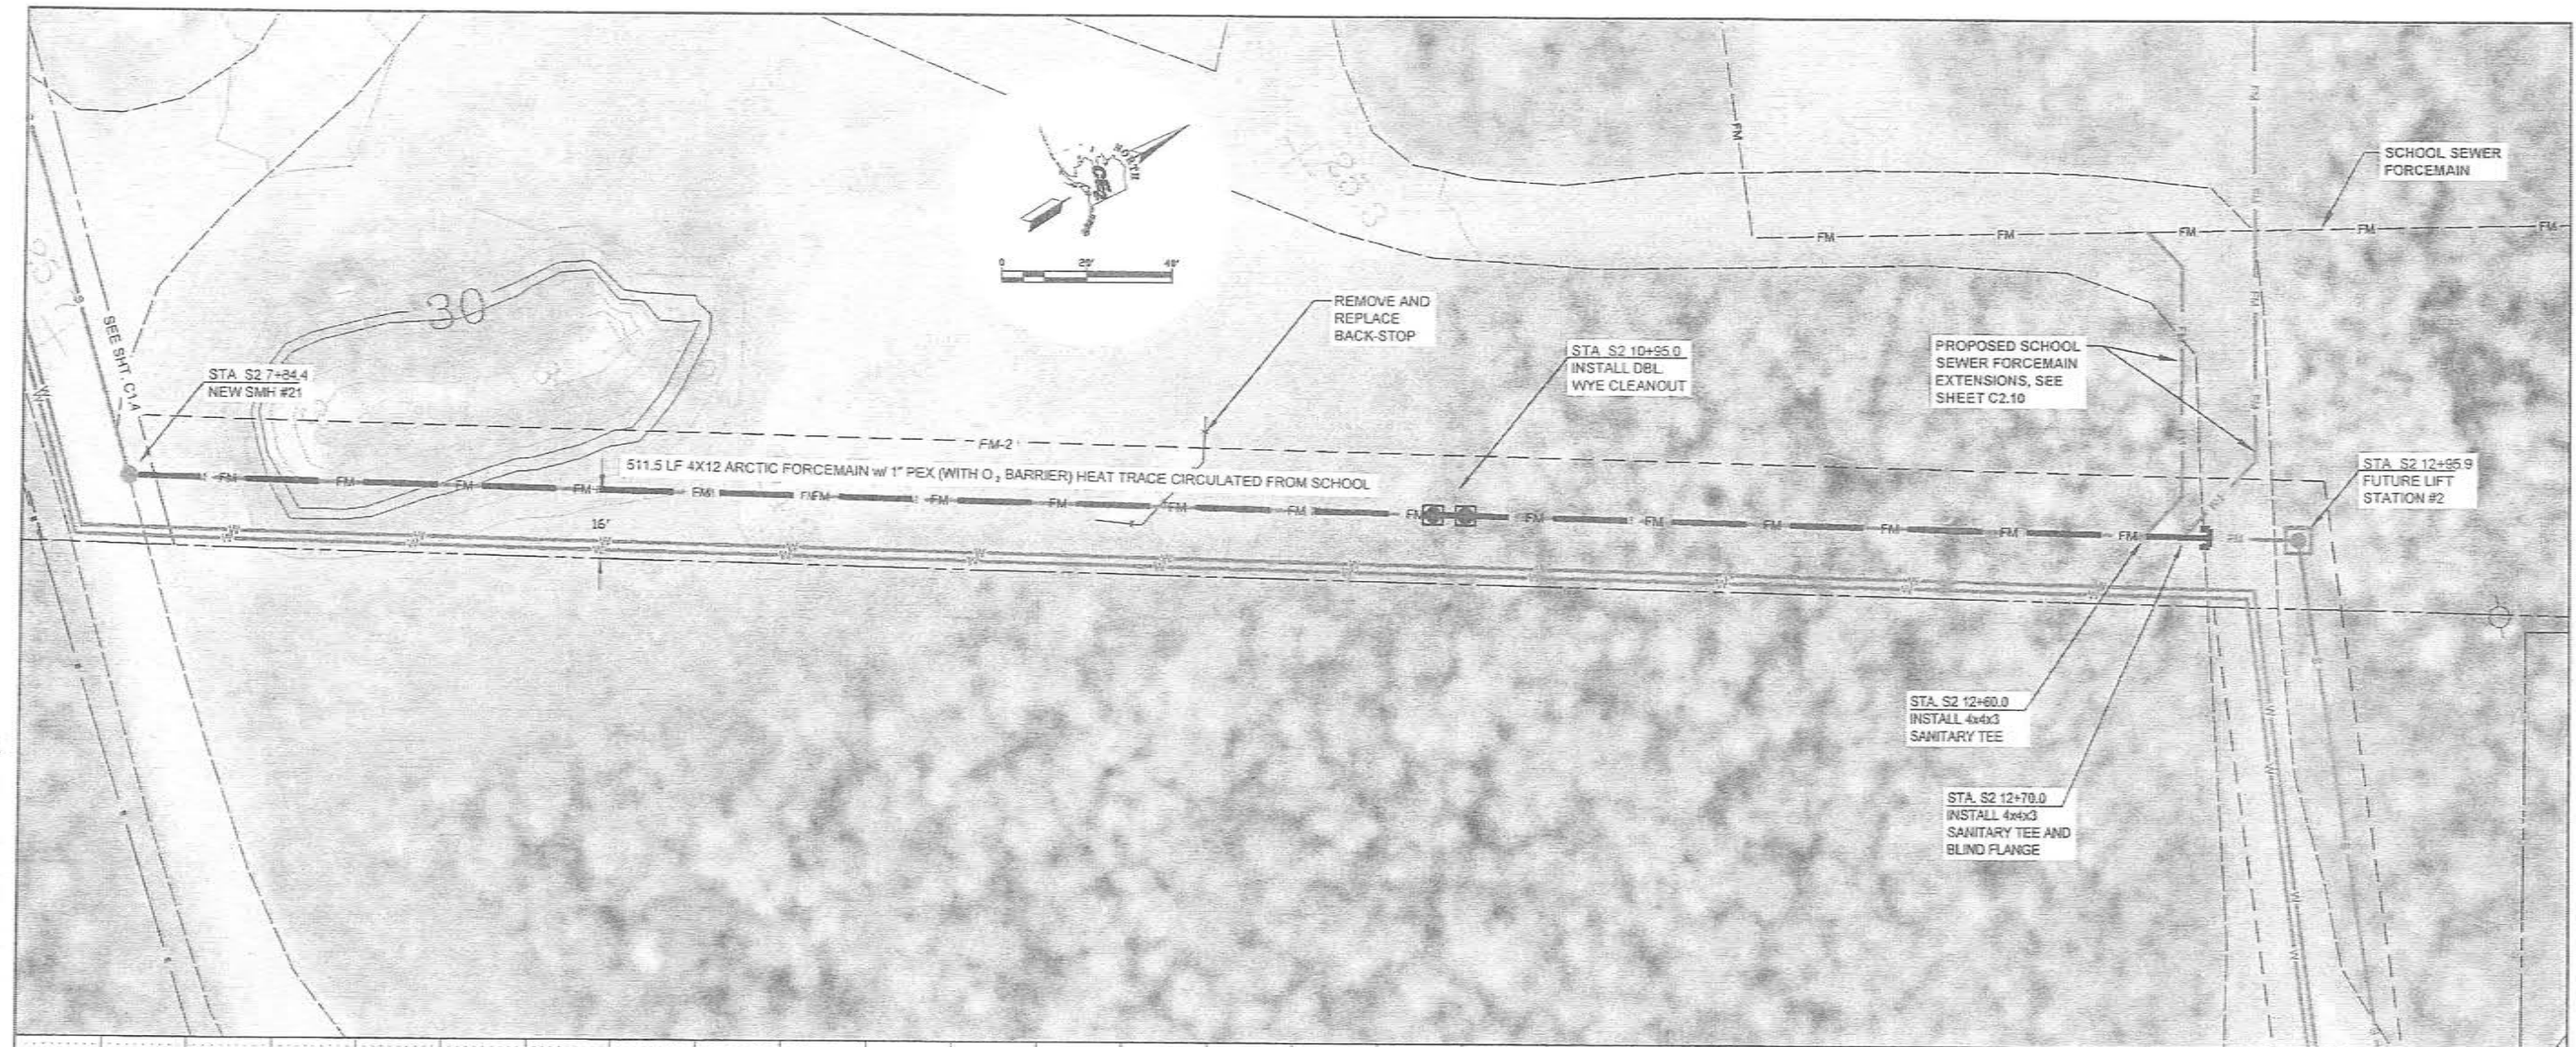

RECORD DRAWING CERTIFICATE
THESE DRAWINGS REFLECT RECORDED
INFORMATION OBTAINED DURING
CONSTRUCTION. INFORMATION PROVIDED
HEREIN IS ACCURATE TO THE BEST OF MY
KNOWLEDGE.

SCALE:
PLAN: 1"=20'
PROFILE: 1"=5'
VERTICAL CURVE: 100'
HORIZONTAL CURVE: 100'

ALL SAFE WORKS
ALASKA

STATE OF ALASKA
DEPARTMENT OF ENVIRONMENTAL CONSERVATION
DIVISION OF WATER RESOURCES
TULUKSAK, ALASKA

2010-11 WASTEWATER
SYSTEM IMPROVEMENTS
FM2 FORCEMAIN
PLAN AND PROFILE
TULUKSAK, ALASKA


CEE
ENGINEERS, INC.
PO BOX 2296 ANCHORAGE, AK 99501 PH 907.349.4000 FAX 907.349.4015

Project No. _____
Date: JUNE 2009
Designed: LAF
Drawn: LAW
Approved: LAF

REVISION
LAGOON RELOCATION

BY: _____
DATE: _____


Sheet No. C2.9

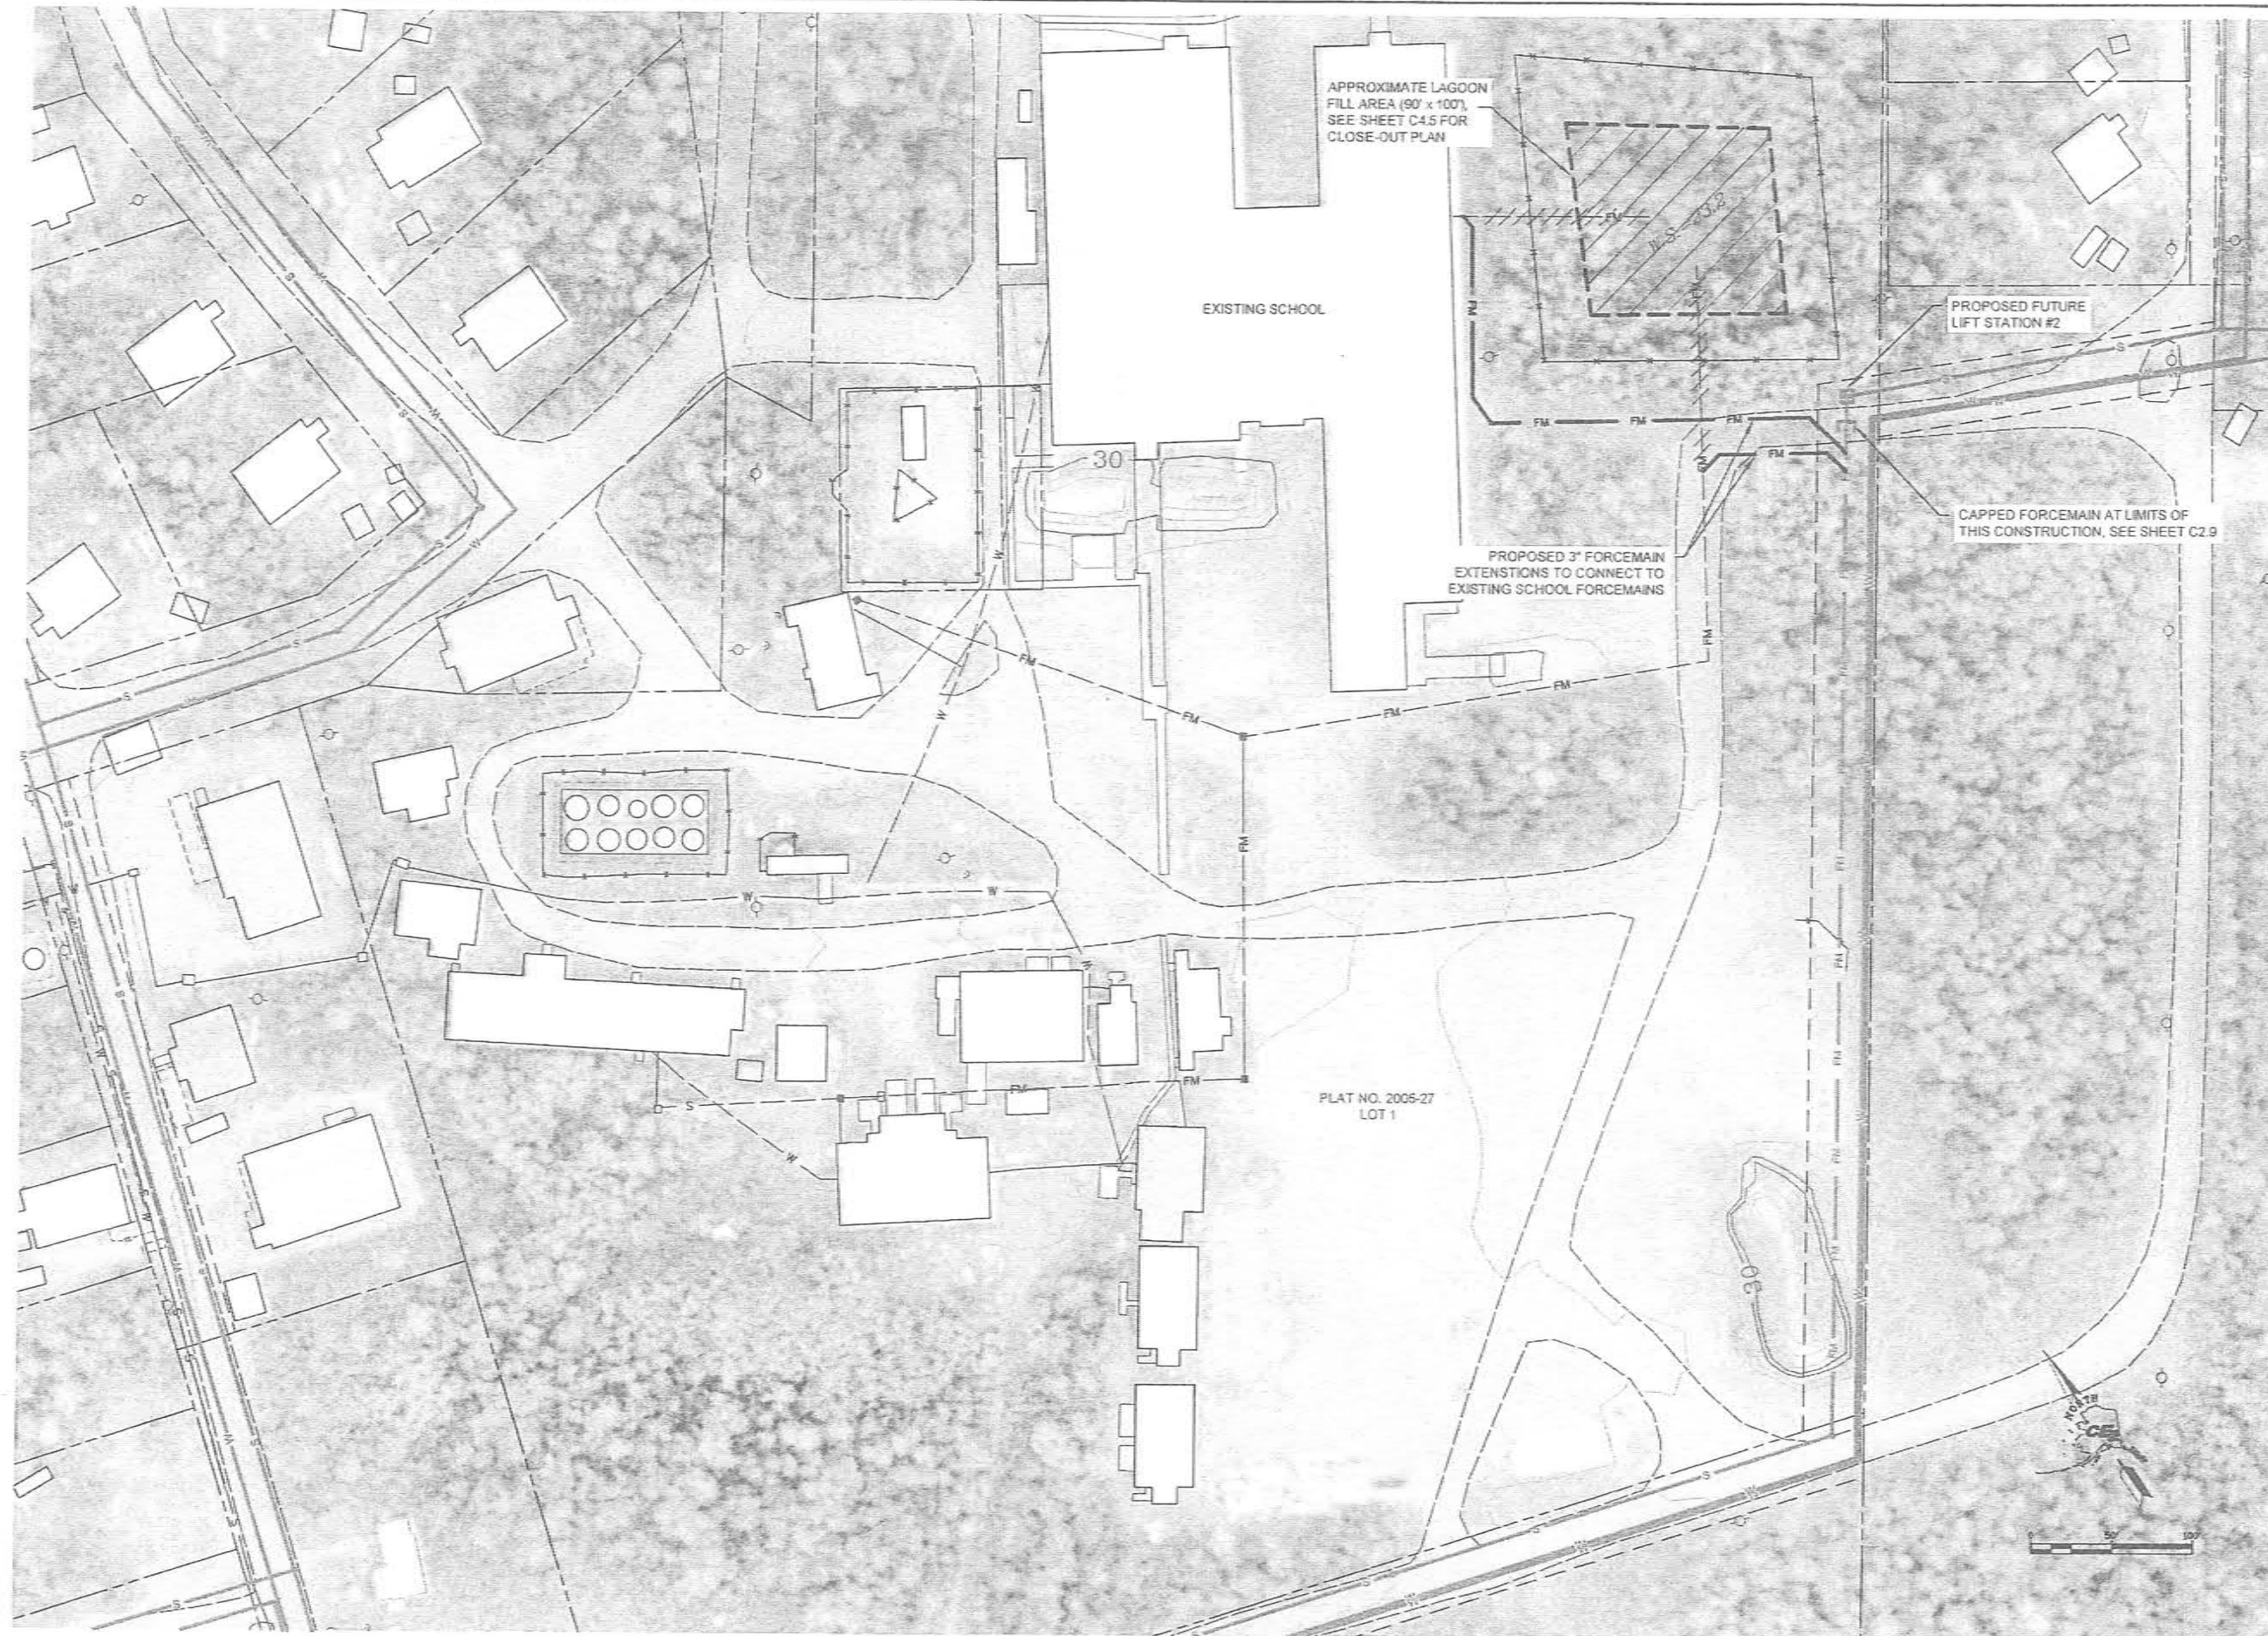

1 CONNECTION TO SCHOOL UTILITIES
C2.10

RECORD DRAWING CERTIFICATE THESE DRAWINGS REFLECT RECORDED INFORMATION OBTAINED DURING CONSTRUCTION. INFORMATION PROVIDED HEREIN IS ACCURATE TO THE BEST OF MY KNOWLEDGE.		NAME _____ DATE _____
SCALE: AS SHOWN		
2010-11 WASTEWATER SYSTEM IMPROVEMENTS CONNECTION TO SCHOOL UTILITIES TULUKSAK, ALASKA		
Project No. _____ Date: SEPT 2010 Designed: LAP Drawn: CM Approved: LAP	REVISION	BY DATE
Sheet No. C2.10		

G:\ACAD\TULUKSAK\T10901 2008 waste water disposal area\C3.1 LIFT STATION SITE PLAN.dwg, 1/11/2011 1:30:13 PM, Flash, LANIER MP C2050, LD520C PCL 68K WHIT, PC3

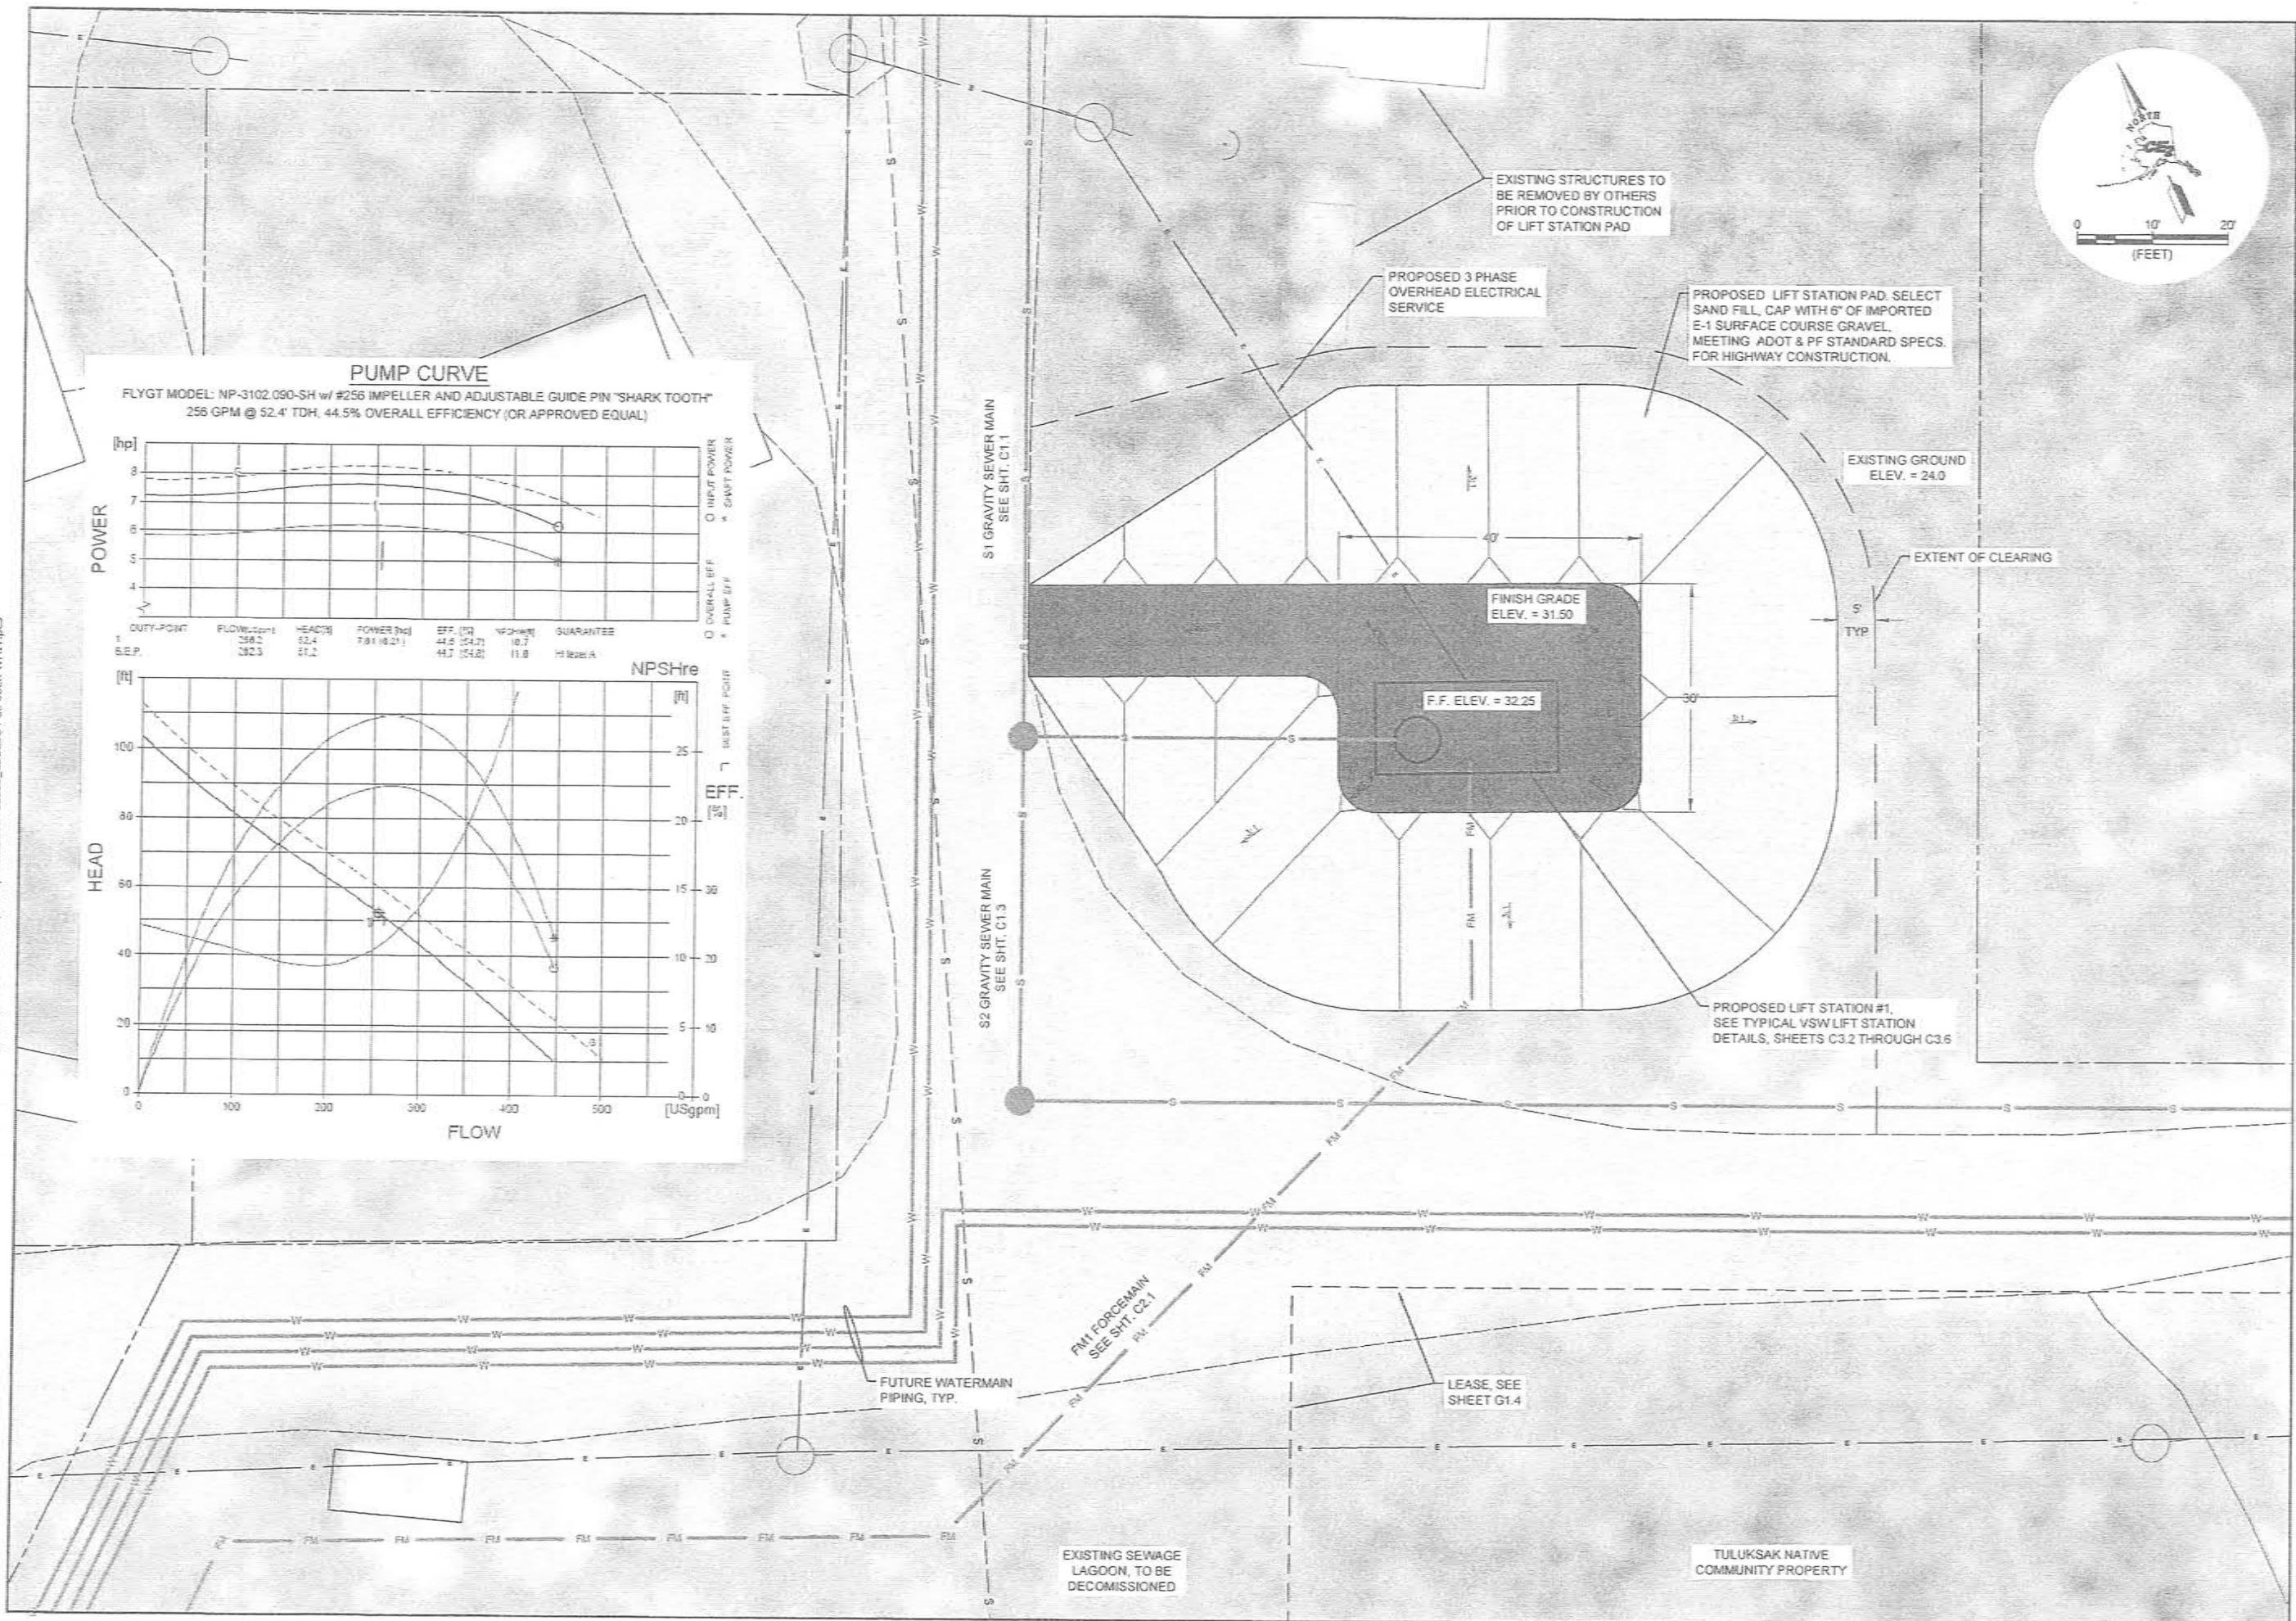

RECORD DRAWING CERTIFICATE
THESE DRAWINGS REFLECT RECORDED
INFORMATION OBTAINED DURING
CONSTRUCTION. INFORMATION PROVIDED
HEREIN IS ACCURATE TO THE BEST OF MY
KNOWLEDGE.

SCALE:
AS SHOWN



2010-11 WASTEWATER
SYSTEM IMPROVEMENTS

LIFT STATION #1
SITE PLAN AND
PUMP CURVE
TULUKSAK, ALASKA

CEI
ENGINEERS, INC.
PO BOX 2284 ANCHORAGE, AK 99501 PH 907 488 0018 FAX 907 488 0015

REVISION	BY	DATE

Project No.	Date	Designed	Drawn	Approved
	JUNE 2009	JFK	CLD	LAP

Sheet No.
C3.1

GENERAL CONSTRUCTION NOTES:

1. INSTALL 6 MIL VISQUEEN UNDER SLAB.

FOUNDATION CONSTRUCTION NOTES:

- INSTALL BOARD STOCK INSULATION TO 18" BELOW TOP OF SLAB. BOARD STOCK CAN BE USED AS FORM MATERIAL WITH PROPER SUPPORT.
- NFS SAND FILL TO 12" BELOW BOTTOM OF SLAB. COMPACT SUB GRADE PRIOR TO PLACEMENT. GRAVEL PLACED IN 6" LIFTS.
- THE WET WELL WILL BE A PRE-CAST MANHOLE A SPECIFIED IN THE DRAWINGS.
- CAST-IN-PLACE CONCRETE MUST HAVE A MINIMUM COMPRESSIVE STRENGTH OF 3000 PSI AT 28 DAYS. EACH YARD OF CONCRETE MUST CONTAIN NOT LESS THAN 5-1/2 SACKS OF CEMENT AND NOT MORE THAN 6.5 GALLONS OF WATER PER SACK OF CEMENT.
- DEFORMED REINFORCING STEEL MUST CONFORM TO ASTM SPECIFICATION A615 AND HAVE A MINIMUM YIELD STRENGTH OF 60,000 PSI. LAP BARS MUST BE A MINIMUM OF 30 DIAMETERS. REINFORCING STEEL LAYOUT AND PLACING WILL CONFORM TO THE STANDARD BUILDING CODE REQUIREMENTS FOR REINFORCED CONCRETE (ACI 318-83).
- WELDED WIRE FABRIC FOR ENTRY SLAB WILL CONFORM TO ASTM A185. LAPS TO BE ONE CROSSWISE SPACING PLUS 1-1/2'.
- CONCRETE COVER FOR THE REINFORCING STEEL MUST BE 3 INCHES FOR THE FOOTINGS AND TWO INCHES FOR THE WALLS AND SLAB.
- METAL ROOFING WILL CONSIST OF 1-1/2" TWIN RIB ALUMINUM.
- THE SEALS ON THE PRE-CAST MANHOLE SECTIONS WILL BE RAMNEX.
- THE INTERIOR OF THE LIFT STATION WET WELL, INCLUDING METAL PIPING, WILL BE PAINTED WITH 46H-413 HI-BUILD TNEVEC TAR, 13 DRY FILM MILLS.
- THE LIFT STATION WILL BE FILLED AND PRESSURE TESTED FOR LEAKS BEFORE ANY EFFLUENT ENTERS THE STATION.
- ALL CONSTRUCTION SHALL BE DONE IN A SAFE, WORKMANLIKE MANNER TO INDUSTRY STANDARDS AND IN CONFORMANCE WITH APPLICABLE LOCAL, STATE AND FEDERAL CODES AND REGULATIONS.
- HANGERS AND ANCHORS USED FOR SUPPORTING HORIZONTAL PIPING SHALL BE OF MATERIAL OF SUFFICIENT STRENGTH AND ADEQUATELY ANCHORED TO MAINTAIN EACH SUPPORT'S PROPORTIONAL SHARE OF THE WEIGHT OF THE PIPE AND CONTENTS.
- SUPPORTS FOR HORIZONTAL IRON PIPE SHALL BE PROVIDED AT INTERVALS OF NOT MORE THAN 10 FEET OR AS SHOWN ON THE PLANS. SUPPORTS SHALL BE ADEQUATE TO PREVENT STRESS AT JOINTS DUE TO SAGGING. SUPPORTS SHALL BE PROVIDED AT EACH HORIZONTAL BRANCH CONNECTION. SUSPENDED LINES SHALL BE SUITABLY BRACED TO PREVENT HORIZONTAL MOVEMENT.

SEWAGE LIFT STATION ELECTRICAL CODE REVIEW

1999 NFPA 820 STANDARD FOR FIRE PROTECTION IN WASTEWATER TREATMENT AND COLLECTION FACILITIES CHAPTER 2 TABLE 2-2 OUTLINES THE REQUIREMENTS AND AREA CLASSIFICATIONS FOR THE INSTALLATION CONFIGURATIONS TYPICALLY USED. THIS INSTALLATION IS AN ABOVE GRADE WASTEWATER PUMPING STATION WHERE THE CONTROL ROOM IS PHYSICALLY SEPARATED WITH NO PERSONNEL ACCESS TO THE WET WELL. THE REQUIREMENTS CAN BE FOUND IN TABLE 2-2.

THE TABLE STATES THE FOLLOWING FOR THE CONTROL ROOM (TABLE 2.2 ITEM 18):
FIRE AND EXPLOSION HAZARD: NOT APPLICABLE
VENTILATION: NOT REQUIRED
EXTENT OF CLASSIFIED AREA: NOT APPLICABLE
NEC-AREA ELECTRICAL CLASSIFICATION: UNCLASSIFIED



THE TABLE STATES THE FOLLOWING FOR THE WET WELL SIDE (TABLE 2.2 ITEM 19):
FIRE AND EXPLOSION HAZARD: POSSIBLE IGNITION OF FLAMMABLE GASES
VENTILATION: NONE (CLASS 1, DIV. 1); 12 AIR CHANGES OR MORE (CLASS 1, DIV. 2)
EXTENT OF CLASSIFIED AREA: ENTIRE SPACE OR ROOM
NEC-AREA ELECTRICAL CLASSIFICATION: DIVISION 1 OR 2 DEPENDING ON VENTILATION

THE INSTALLATION WILL ALLOW THE USE OF UNCLASSIFIED EQUIPMENT AND WIRING METHODS IN THE CONTROL ROOM. HOWEVER, THE SENSING TRANSDUCER MUST HAVE THE RACEWAY SEALED AT THE BOUNDARY INTO THE CLASS 1, DIVISION 1 WET WELL.


ELEVATION TABLE

LS#1

FINISHED FLOOR ELEVATION	32.25
INVERT IN ELEVATION	13.00
WET WELL BOTTOM ELEVATION	9.50
GRAVITY SEWER	13.00
VENT	30.00

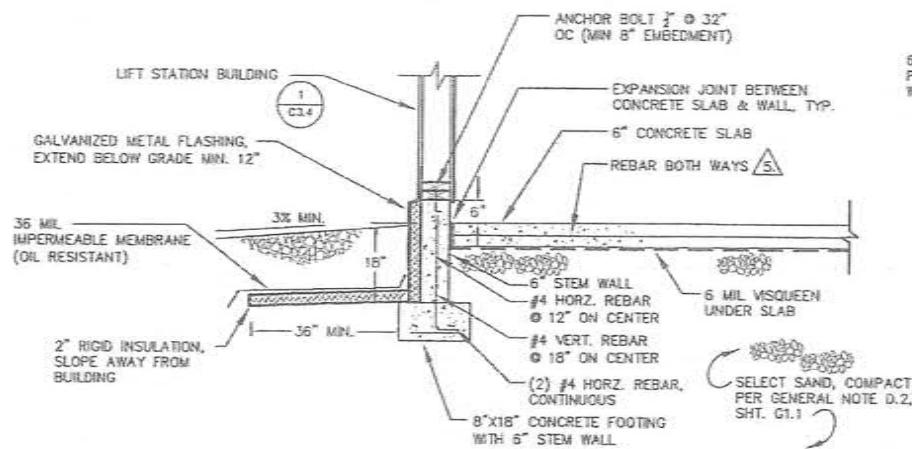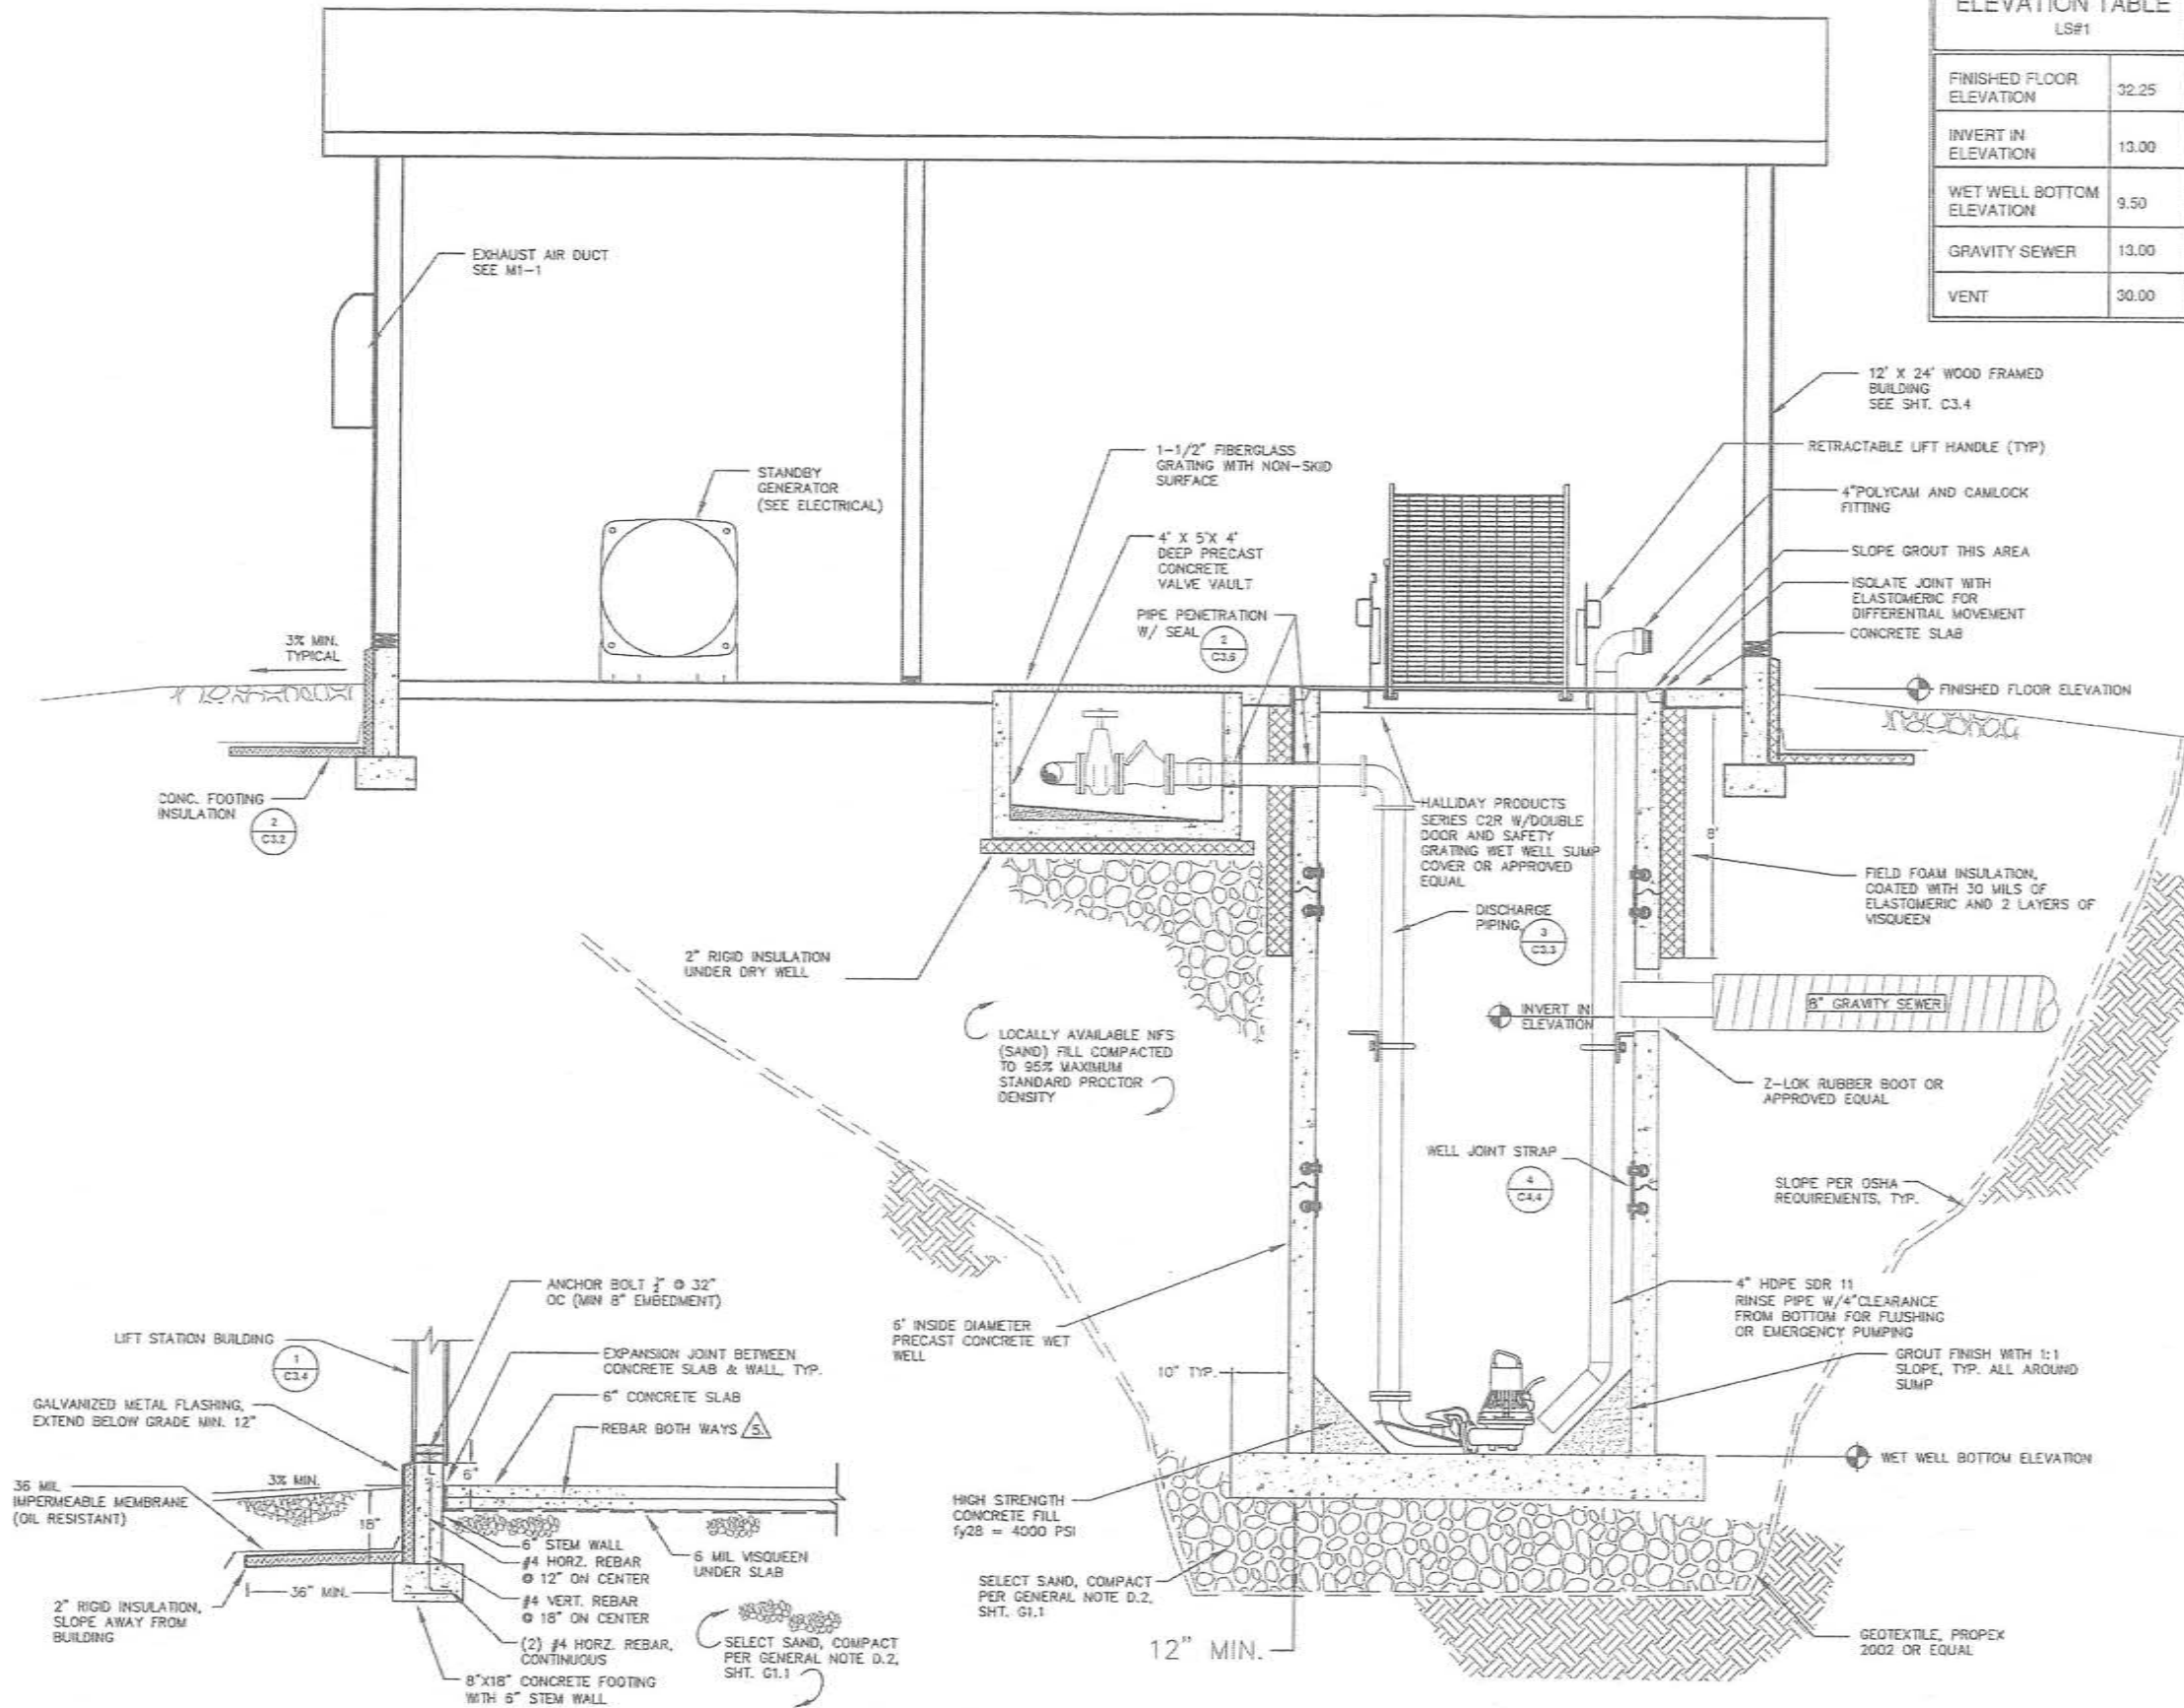

2 TYPICAL WALL CONNECT/SLAB DETAIL
C3.2 NTS

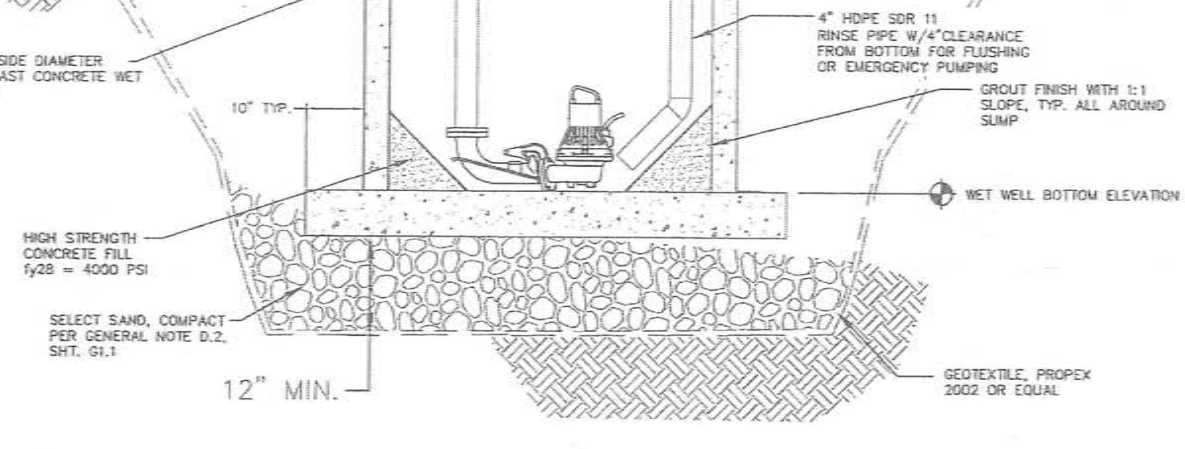

3 WET WELL FOUNDATION DETAIL
C3.2 NTS

RECORD DRAWING CERTIFICATE
THESE DRAWINGS REFLECT RECORDED INFORMATION OBTAINED DURING CONSTRUCTION INFORMATION PROVIDED HEREIN IS ACCURATE TO THE BEST OF MY KNOWLEDGE.

SCALE: 1\"/>



2010-11 WASTEWATER SYSTEM IMPROVEMENTS
LIFT STATION DETAILS
TULAKSAK, ALASKA

CES
ENGINEERS, INC.
PO BOX 22846 ANCHORAGE, AK 99521 PH 907-546-1000 FAX 907-546-1005


REVISION	DATE

Project No.	JUNE 2009
Drawn	LAP
Checked	
Approved	


Sheet No. C3.2

G:\ACAD\TULUKSAK\T0901 2008 Waste water disposal area\C3.2_Thru_3.6 revised format.dwg, 1/11/2011 1:00:13 PM, cmerz, LANIER MP C2050_LDS20C PCL 6.pcs


SEE ELECTRICAL
SHEETS FOR WIRING
DETAILS

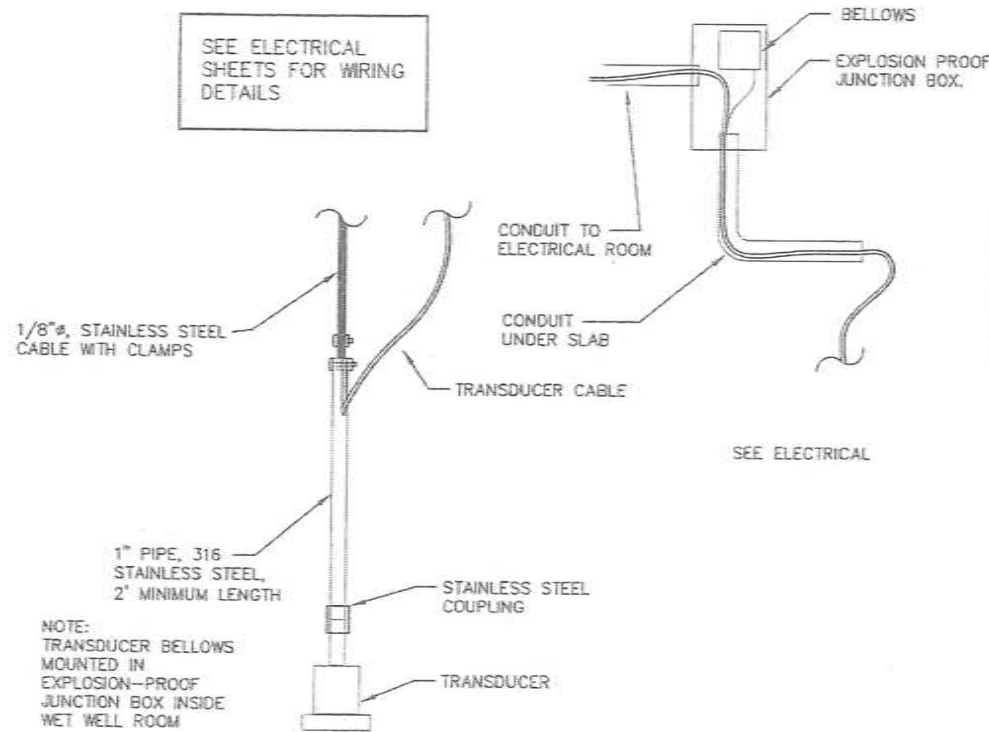

2 TRANSDUCER DETAIL
C3.3 NTS

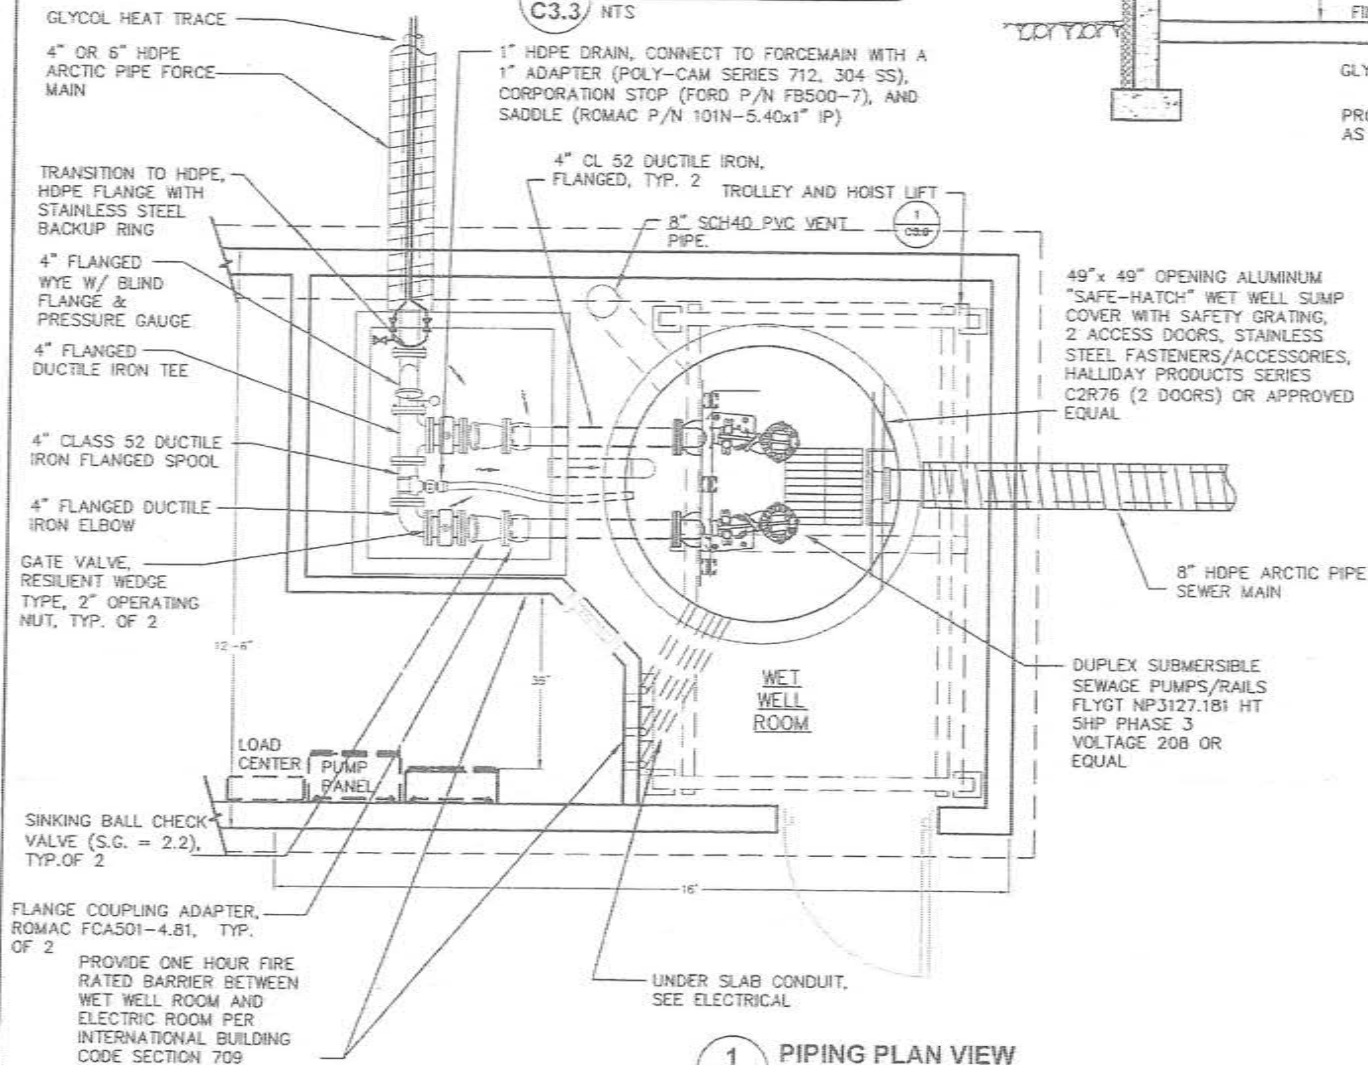

1 PIPING PLAN VIEW
C3.3 NTS

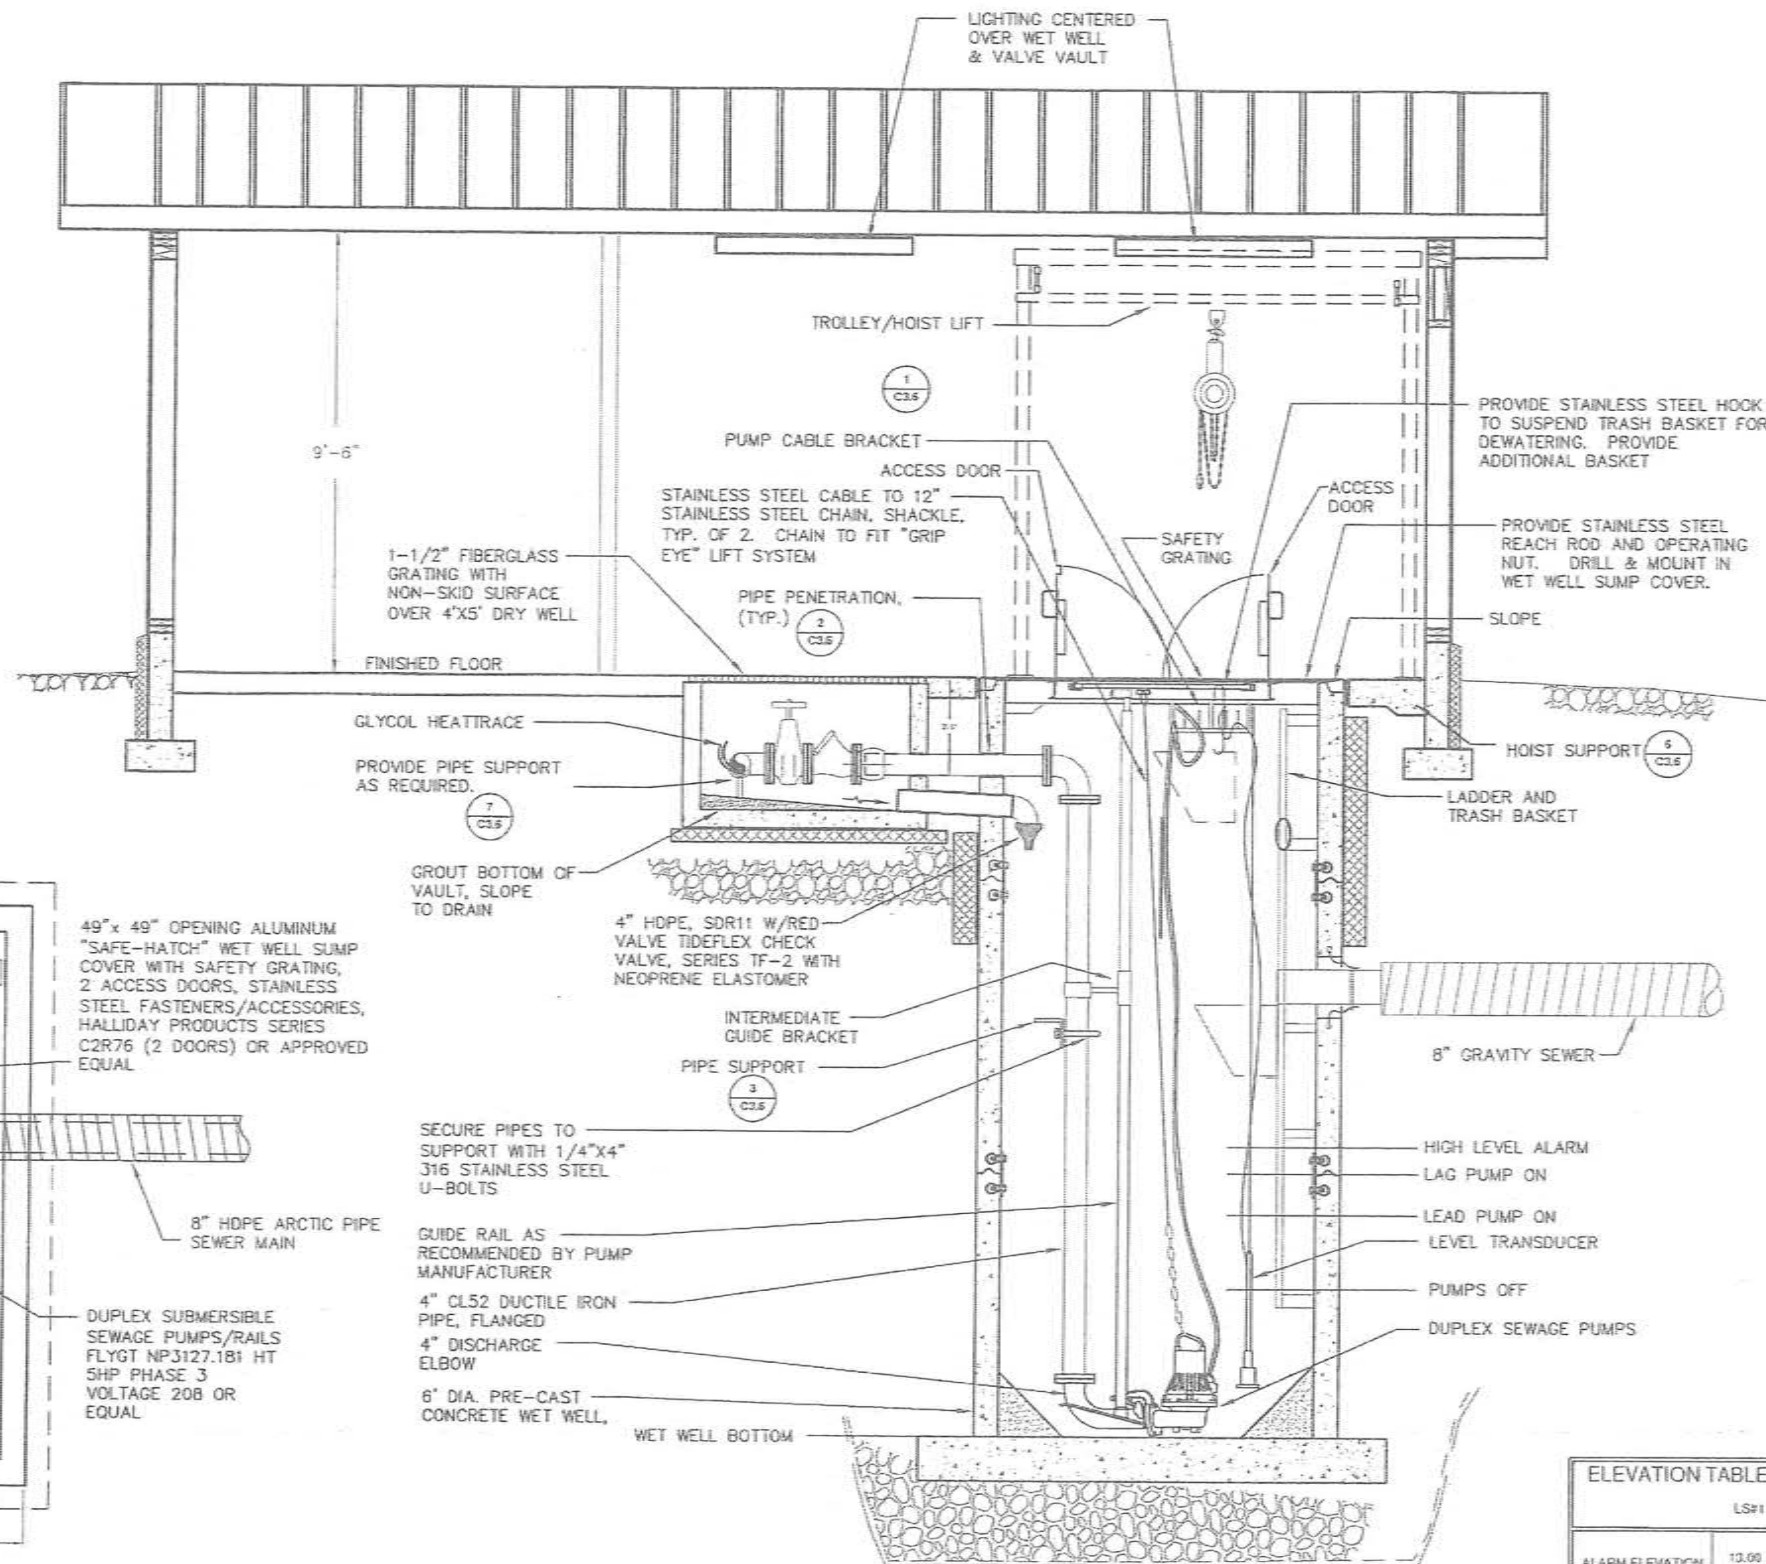

NOTE: ATTACH 1/2" DIA. SS CABLE TO THE ATTACHED PUMP CHAIN
TO FACILITATE LIFTING PUMPS FOR REMOVAL/REPLACEMENT OR MAINTENANCE.

3 PIPING PROFILE VIEW
C3.3 NTS

ELEVATION TABLE	
LS#1	
ALARM ELEVATION	13.00
LAG PUMP ON ELEVATION	12.75
LEAD PUMP ON ELEVATION	12.50
PUMPS OFF ELEVATION	11.50

RECORD DRAWING CERTIFICATE
THESE DRAWINGS REFLECT RECORDED
INFORMATION OBTAINED DURING
CONSTRUCTION. INFORMATION PROVIDED
HEREIN IS ACCURATE TO THE BEST OF MY
KNOWLEDGE.

SCALE: 1" = 10'-0"

DATE: 1/11/2011

NAME: C3.3

2010-11 WASTEWATER
SYSTEM IMPROVEMENTS

LIFT STATION PIPING
PLAN AND DETAILS

TULUKSAK, ALASKA

CEI
ENGINEERS, INC.

PO BOX 22046 ANCHORAGE, AK 99523 TEL 907 348 1010 FAX 907 348 1015

REVISION	BY	DATE

Project No. 2008-06
Date: JUNE 2008
Designed: LAP
Drawn: VAW
Approved: LAP

Sheet No. C3.3


NOTES:

1. PREMANUFACTURED LADDER AND BASKET WITH VERTICAL BAR SCREEN. SIMILAR TO HALLIDAY PRODUCTS, LADDER L1B & TRASH BASKET B1B, OR APPROVED EQUAL. STANDARD FEATURES SHALL INCLUDE:


- ALL ALUMINUM BASKET AND RAILS
- SOLID ALUMINUM WHEELS AND STAINLESS STEEL AXLES
- HEAVY DUTY LADDER/GUIDERAIL COMBINATION
- SLIP RESISTANT RUNGS
- BAR SCREEN STYLE BASKET

2. REQUIRED INFORMATION


- WET WELL DIAMETER
- RAIL/LADDER LENGTH
- STANDOFF LENGTH (10" MIN FOR LADDER COMBO)
- FIELD VERIFY DISTANCE REQUIRED FOR BASKET TO CLEAR THE FINISH ACCESS OPENING.

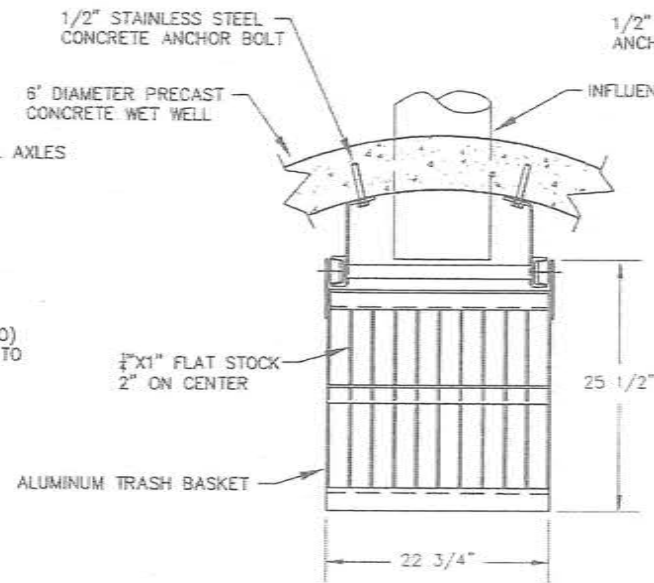


1 PLAN VIEW
C3.5 NTS

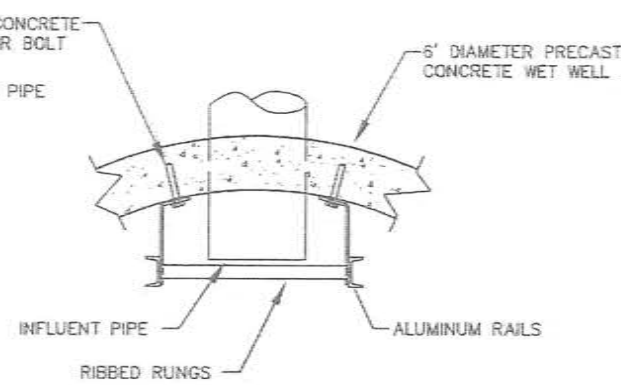


2 LADDER SUPPORT DETAIL
C3.5 NTS

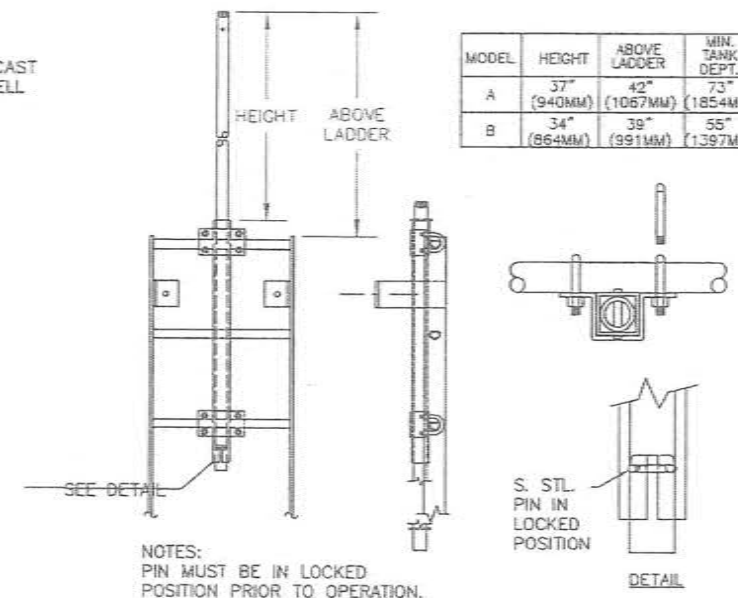


3 LADDER EXTENSION DETAIL
C3.5 NTS

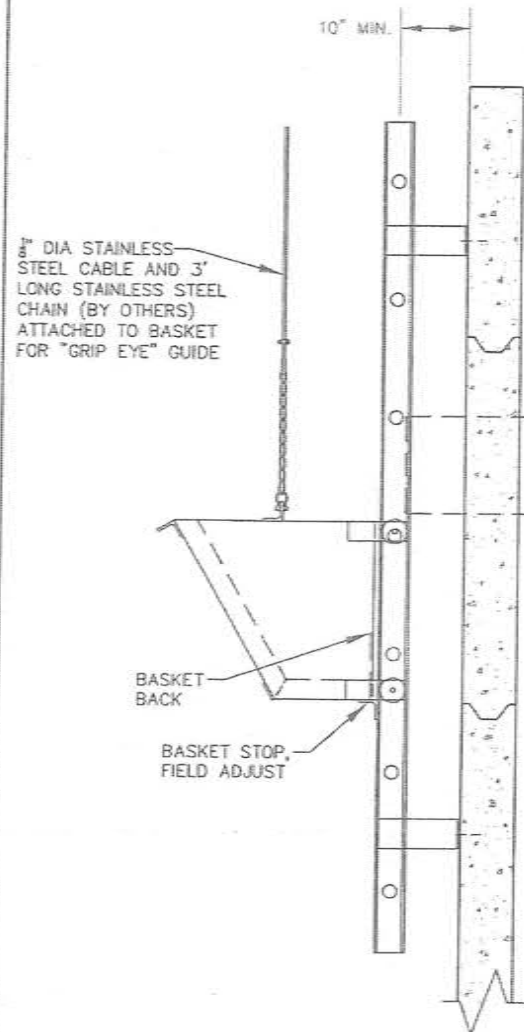


4 BASKET SIDE VIEW
C3.5 NTS

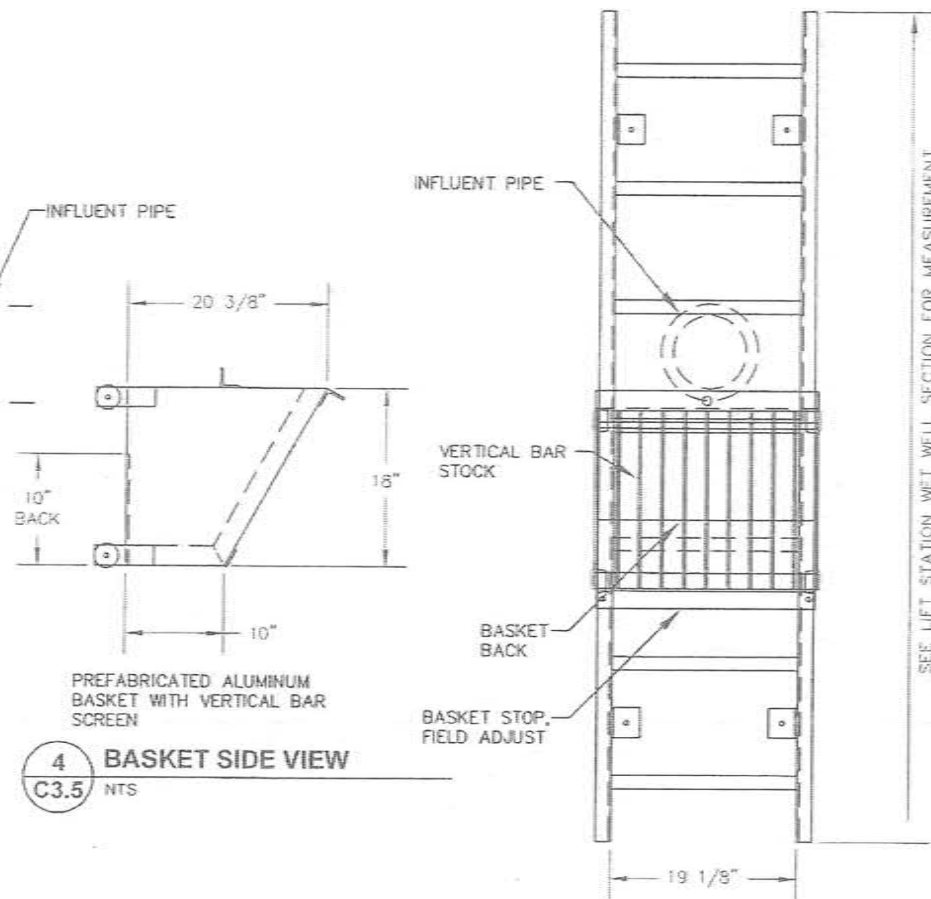


5 LADDER/BASKET FRONT VIEW
C3.5 NTS

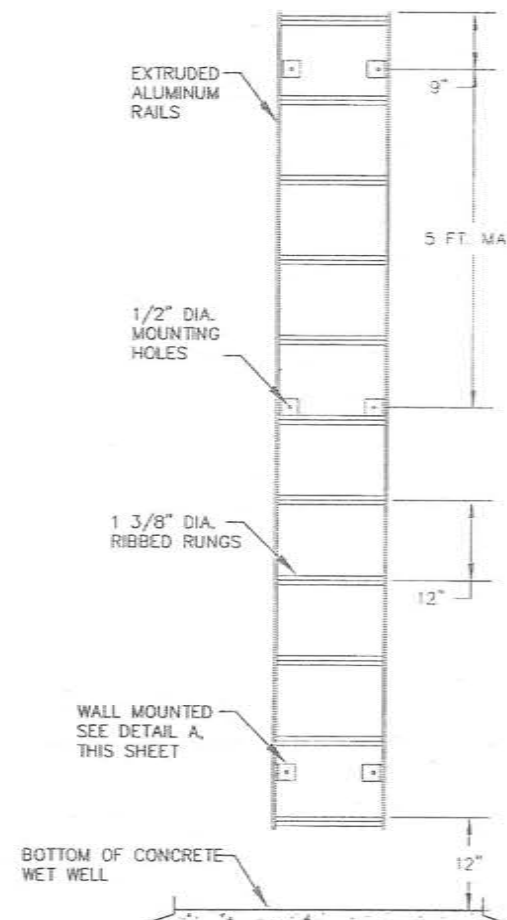


6 LADDER FRONT VIEW
C3.5 NTS

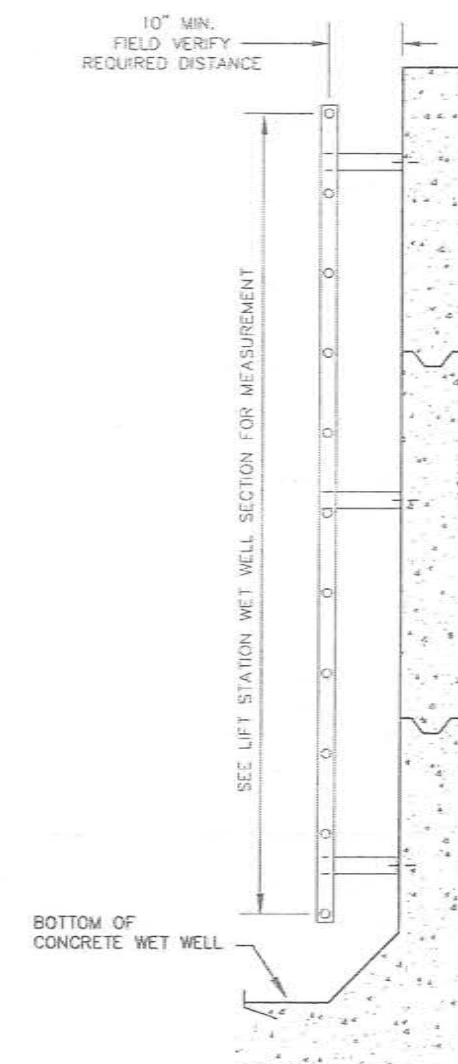


7 LADDER SIDE VIEW
C3.5 NTS

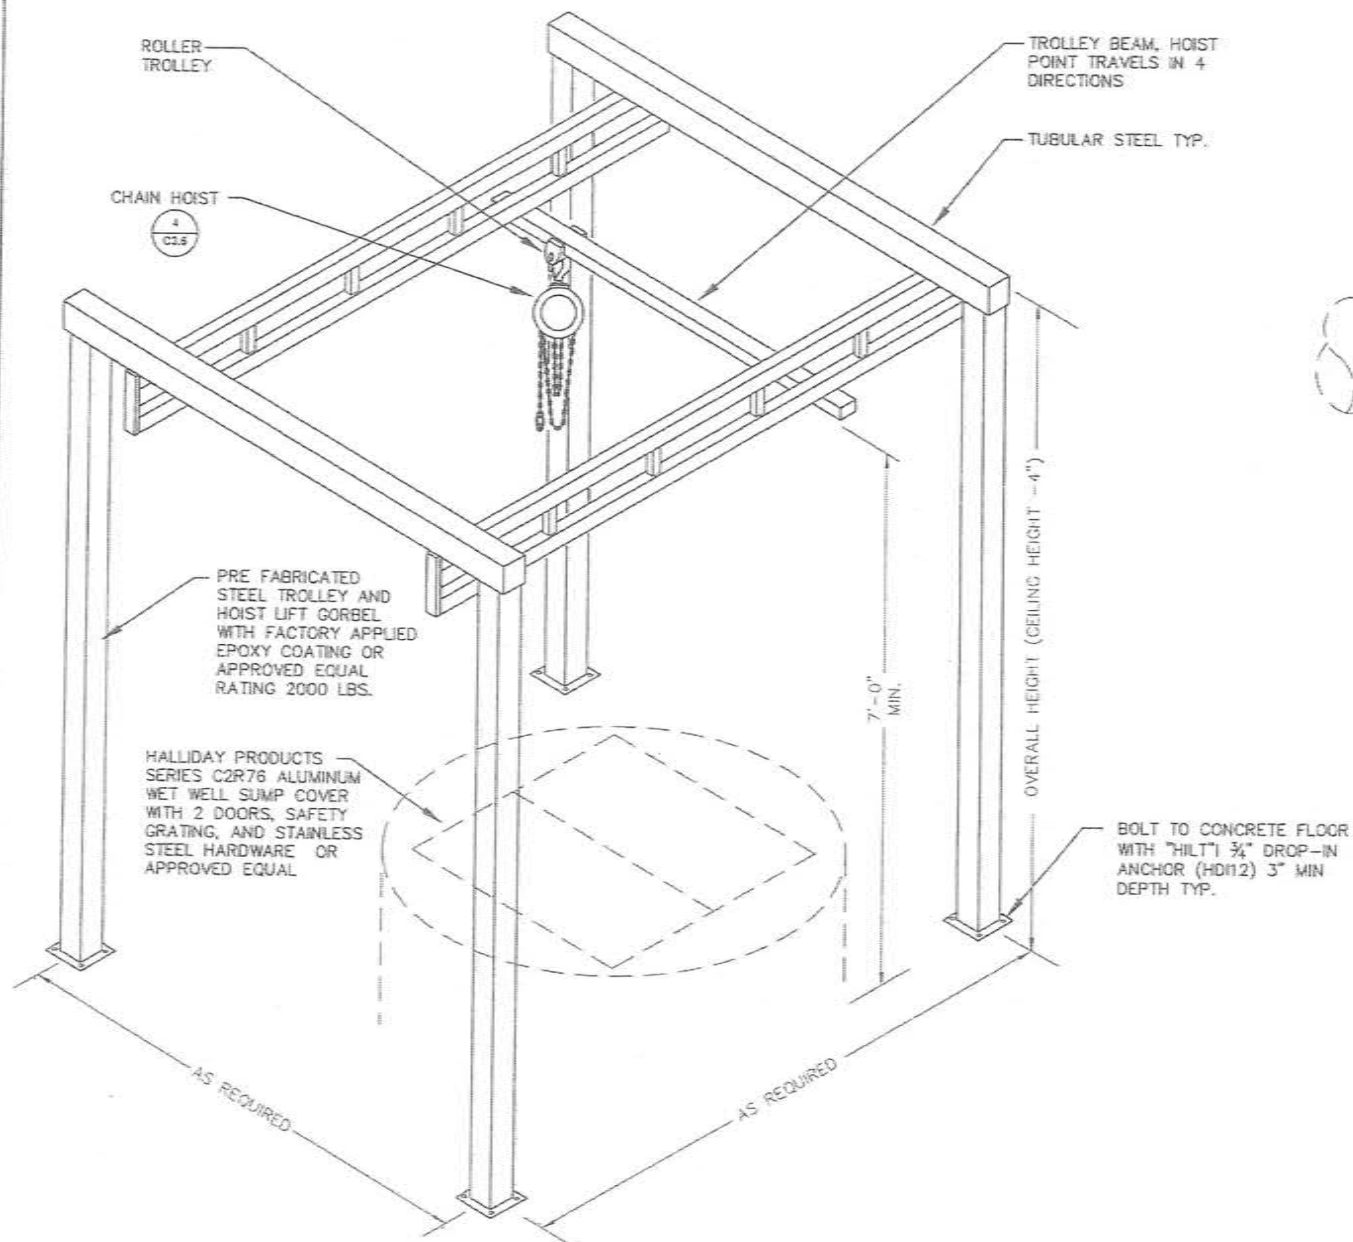


1 TROLLEY FRAME DETAIL
C3.6 NTS

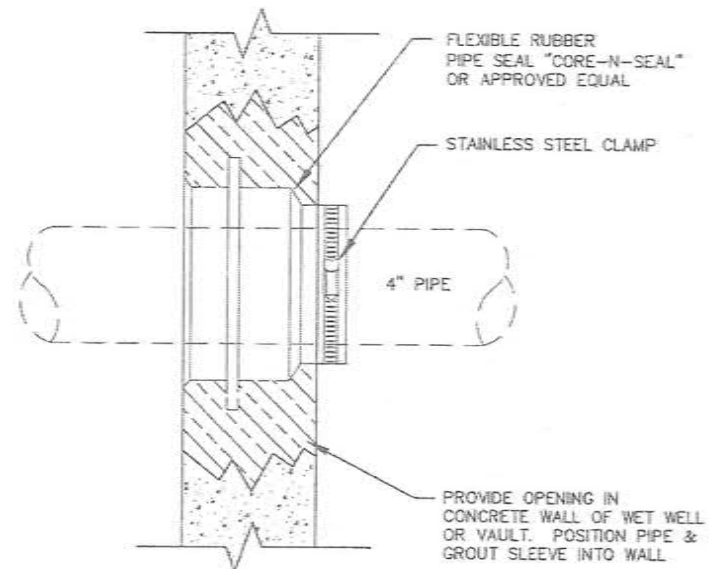


2 PIPE SLEEVE DETAIL
C3.6 NTS

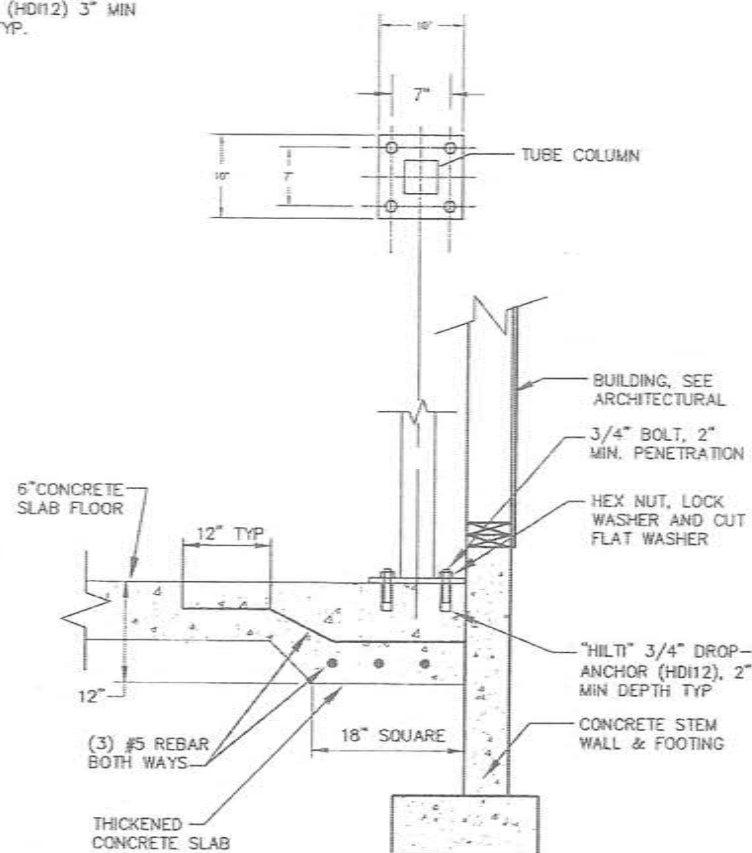


6 HOIST SUPPORT DETAIL
C3.6 NTS

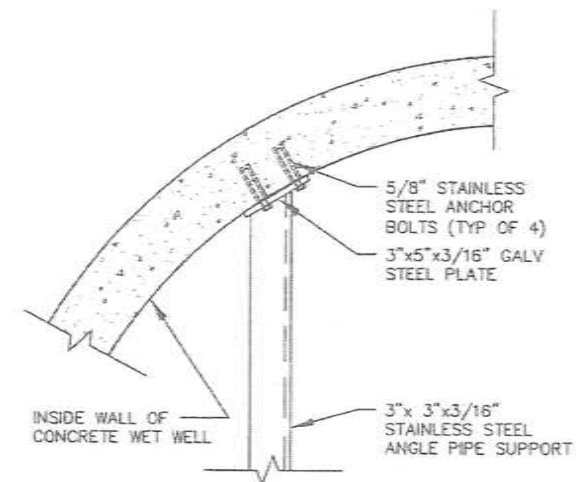

3 PIPE SUPPORT DETAIL
C3.6 NTS

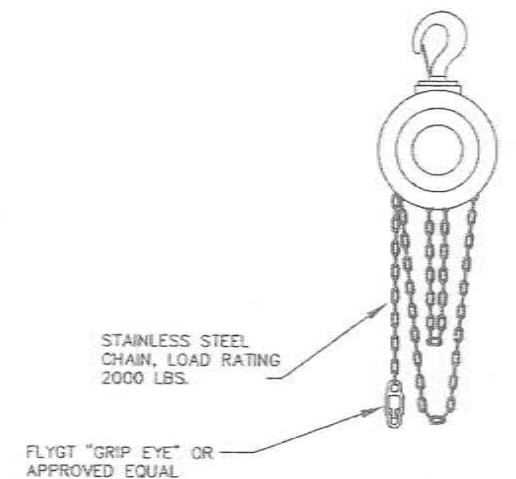

4 CHAIN HOIST
C3.6 NTS

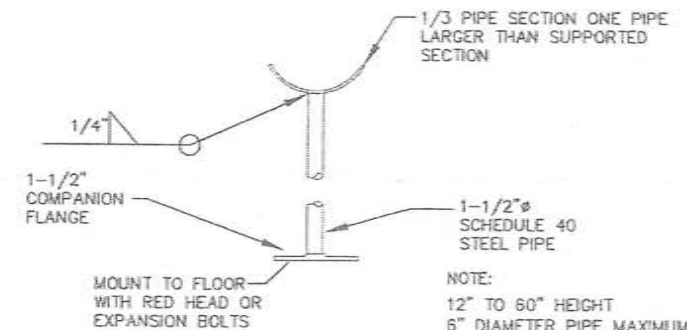

7 FLOOR MOUNT PIPE SUPPORT DETAIL
C3.6 NTS

RECORD DRAWING CERTIFICATE
THESE DRAWINGS REFLECT RECORDED
INFORMATION OBTAINED DURING
CONSTRUCTION. INFORMATION PROVIDED
HEREIN IS ACCURATE TO THE BEST OF MY
KNOWLEDGE.

SCALE:
1" = 1'-0"
1/4" = 3'-0"



2010-11 WASTEWATER
SYSTEM IMPROVEMENTS
LIFT STATION
HOIST AND PIPE
SUPPORT DETAILS
TULLUKSAK, ALASKA

CES
ENGINEERS, INC.
PO BOX 22544 ANCHORAGE, AK 99523 TEL 907-348-9010 FAX 907-348-1015

REVISION	BY	DATE

Project No. _____ Date: JUNE 2009
Designed by: LAP
Drawn by: VSW
Approved by: LAP

Sheet No. C3.6

G:\ACAD\TULUKSAK\T0901 2008 Waste water disposal area\JFC Rev June 2014\C4.0 LAGOON DESIGN CRITERIA.dwg, 6/17/2014 12:54:46 PM, cmerz, LANIER MP C2050_LD520C PCL 6 COLOR.pc3



WASTEWATER LAGOON DESIGN CRITERIA

Assumptions			
	Qty.	Unit	Notes
2010 Population	373	People	U.S. Census
2033 Design Population	421	People	
Design Flow Rate:	10000	Gpd	Calculated
School Population:	170 persons x 15 Gal/Cap-Day = 2,550 gpd		
School Staff:	15 persons x 70 Gal/Cap-Day = 1,050 gpd		
Remaining Population:	236 persons x 5 Gal/Cap-Day = 1,180 gpd		
Wastewater:	5,000 gpd		
Total:	9,780 gpd		
Round up to:	10,000 gpd		
BOD per person	0.17	lbs/Cap-Day	Minimum loading suggested by Ten States Standards (referred to by ADEC).
Treatment Cell BOD Loading (Maximum)	30	lbs/acre	ADEC Lagoon Construction Guidelines for percolation lagoons.
Treatment Cell Hydraulic Retention Time (HRT)	60	Days	Assumed
Treatment Cell Maximum Depth	10	Feet	ADEC Lagoon Construction Guidelines for percolation lagoons.
Percolation Days Per Year	365	Days	Assumed
2033 Design Conditions			
Average Daily Flow	10,000	Gallons	Calculated
BOD/day production	71.6	lbs	Calculated
Treatment Cell Size (based on BOD Loading)	2.4	Acres	Calculated
Treatment Cell Volume	750,000	Gallons	Min. HRT plus 25% Sludge Holding Cap.
Treatment Cell Average Depth	7.00	Feet	Use 7 Foot min. depth for freeze protection.
Required Percolation Cell Holding Volume (non-perk Days)	-	Gallons	
Percolation Calculations			
Average Perc Rate	5.6	min./in.	Measured average of 3 perc tests
Saturation Test Loading	40	min./in.	Measured
Daily Loading Rate	0.90	Gal/Sq.Ft.-Day	Seepage Pit Loading Rate from the 10-States Standard for Individual Sewage Systems, 1980 Edition, for Perc Rate 6-10 min./in.
Required Percolation Cell Floor Area	11,111	Sq. Feet	
Calculated Average Winter Holding Depth	8.00	Feet	
Proposed Lagoon Sizing			
Treatment Cell Size	2.4	Acres	
Treatment Cell Volume	4,778,182	Gallons	
Treatment Cell Calculated HRT	478	Days	
Percolation Cell Floor Area	1.0	Acres	
Percolation Cell Winter Storage Volume	2,521,370	Gallons	OK. > Req. Holding Cell Volume. 8 Foot Max. Depth

RECORD DRAWING CERTIFICATE
THESE DRAWINGS REFLECT RECORDED
INFORMATION OBTAINED DURING
CONSTRUCTION. INFORMATION PROVIDED
HEREIN IS ACCURATE TO THE BEST OF MY
KNOWLEDGE.

SCALE:
1" = 100'
IF NOT ONE INCH ON
SCALE, ACCORDINGLY

6/17/14

ALLIGEE WATER
TULUKSAK, ALASKA

STATE OF ALASKA
49 TH
MICHAEL R. EDMAN
No. 0252
Professional Engineer

2010-11 WASTEWATER
SYSTEM IMPROVEMENTS
LAGOON SITE PLAN
AND DESIGN CRITERIA
TULUKSAK, ALASKA

CE2
ENGINEERS, INC.
PO BOX 22066 ANCHORAGE, AK 99501 PH: 907-548-1010 FAX: 907-548-1015


BY	DATE
CM	4/14
CM	4/14
CM	6/14
CM	6/14

REVISION	DATE
LAGOON RELOCATION	4/14
LAGOON RELOCATION	4/14
PERC. CELL RESIZED	6/14
TABLE UPDATE	6/14

Project No.	APRIL 2014	MRE
Designed	MRE	
Drawn	CM/LAW	
Approved	MRE	

Sheet No.
C4.0


G:\ACAD\TULUKSAK\T10901 2008 Waste water disposal area\TFC Rev June 2014\C4.1 LAGOON PLAN AND PROFILE.dwg, 6/17/2014 4:19:09 PM, cmierz, LAMIER MP C2050_LDS20C PCL 6 COLOR.pc3

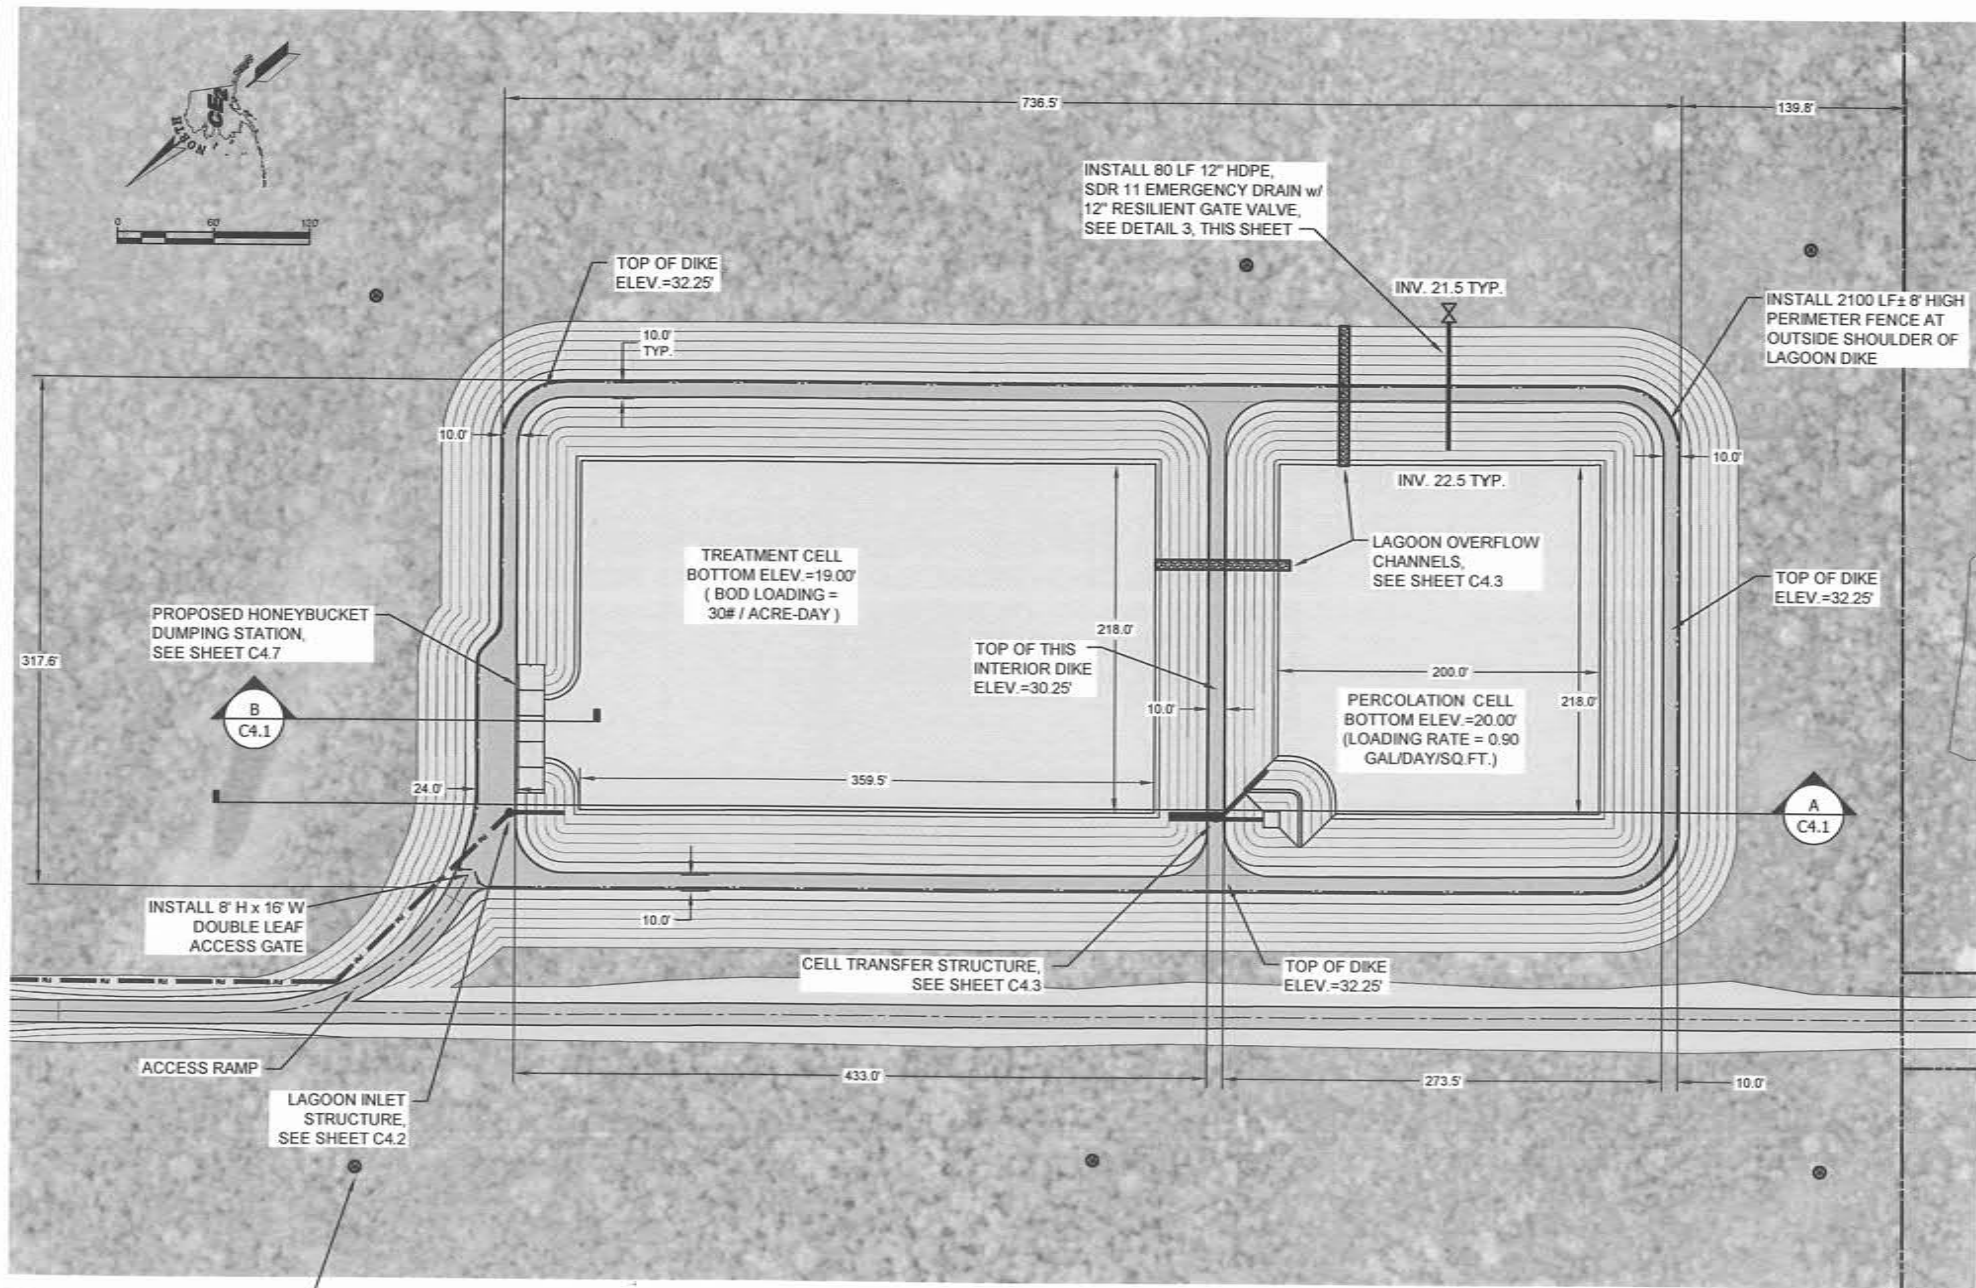


1 WASTEWATER TREATMENT LAGOON PLAN
C4.1 SCALE: 1"=60'

2" DRIVEN MONITORING WELL, TYP. OF 6 EA, 5' TYP. INSIDE PROPERTY, EVALUATE FINAL PLACEMENT OF WELLS PRIOR TO INSTALLATION TO TARGET AREAS DOWN-GRADIENT FROM THE PERCOLATION CELL, SEE


2 C4.1

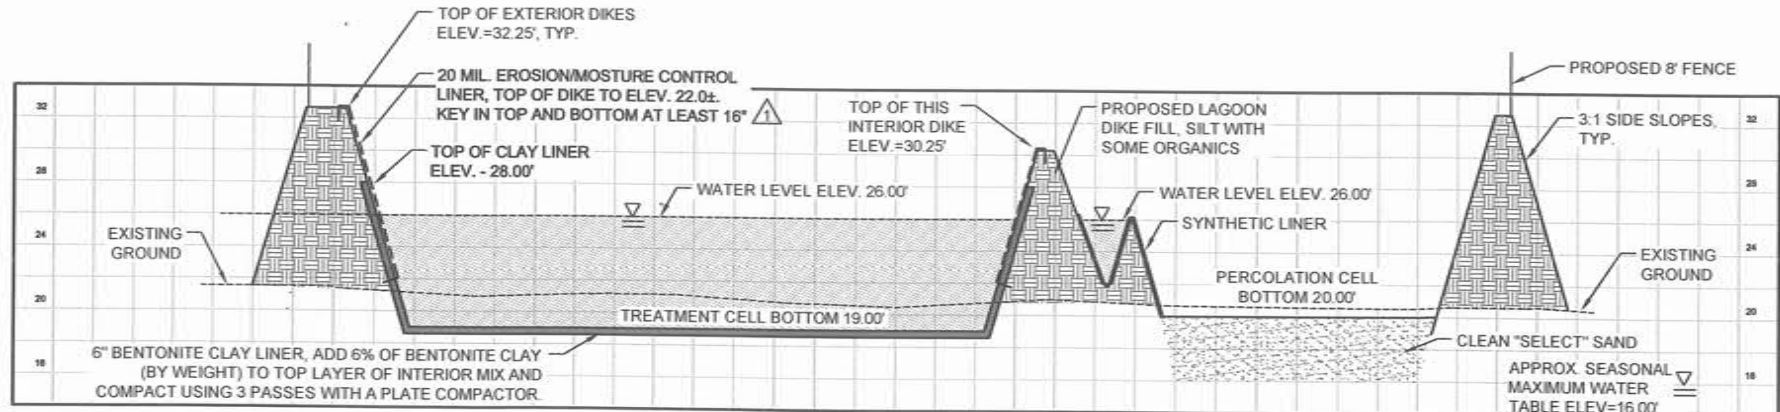


LAGOON - SECTION A
SCALE: HOR. 1"=60', VERT. 1"=6'

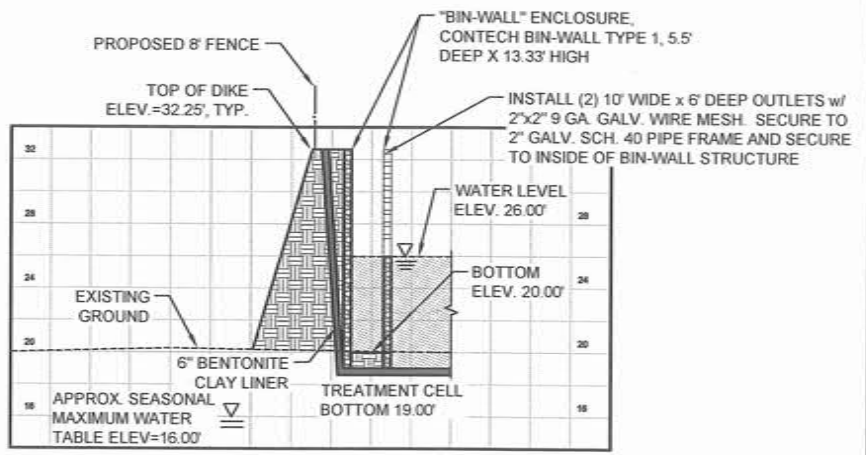

HONEYBUCKET DUMP STATION - SECTION B
SCALE: HOR. 1"=60', VERT. 1"=6'

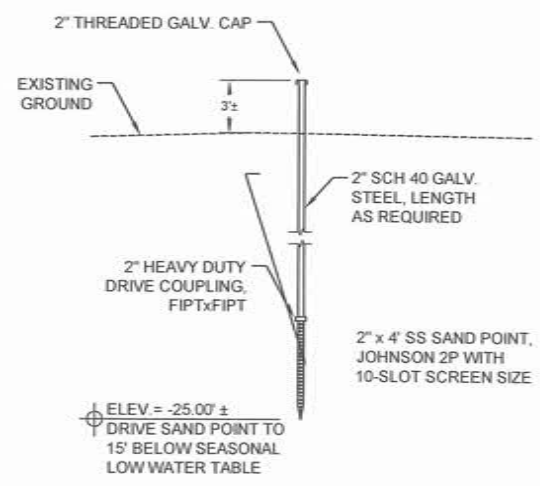

2 DRIVEN MONITORING WELL DETAIL
C4.1 SCALE: NTS

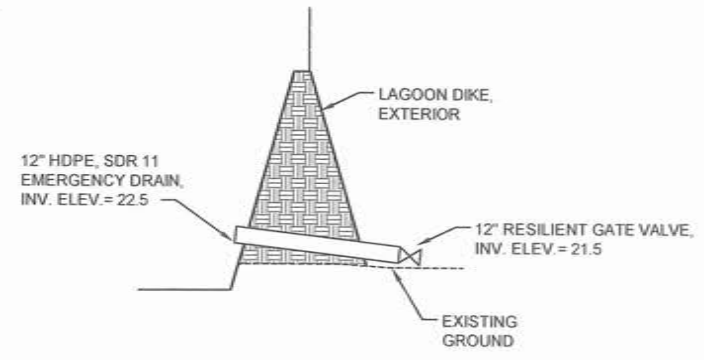

3 EMERGENCY DRAIN DETAIL
C4.1 SCALE: NTS

RECORD DRAWING CERTIFICATE
THESE DRAWINGS REFLECT RECORDED
INFORMATION OBTAINED DURING
CONSTRUCTION. INFORMATION PROVIDED
HEREIN IS ACCURATE TO THE BEST OF MY
KNOWLEDGE.

SCALE:
AS SHOWN

DATE: 6/17/14

NAME: Michael R. Erdman
No. 6252
REGISTERED PROFESSIONAL
ENGINEER
STATE OF ALASKA

2010-11 WASTEWATER
SYSTEM IMPROVEMENTS

LAGOON PLAN
AND PROFILE

TULUKSAK, ALASKA


CFE2
ENGINEERS, INC.

PO BOX 22046 ANCHORAGE, AK 99521 PH: 907-349-1010 FAX: 907-349-1015



REVISION	DATE	BY
NOTES ADDED	2/10	LAW
LAGOON RELOCATION	8/10	CM
LAGOON RELOCATION	4/14	CM
PERC. CELL RESIZED	6/14	CM

Project No. APRIL 2014
Date MRE
Designed CM
Drawn MRE
Approved


Sheet No. C4.1

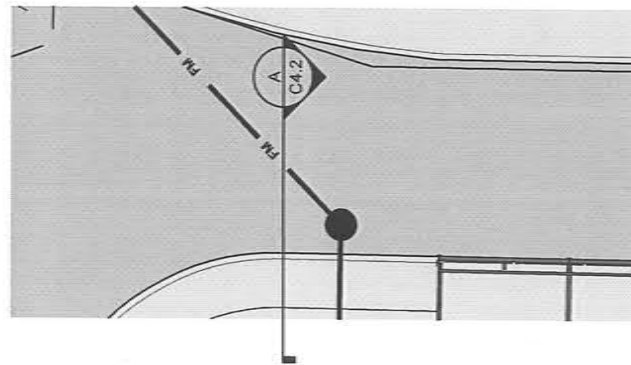


1 LAGOON INLET STRUCTURE PLAN
C4.2 NTS

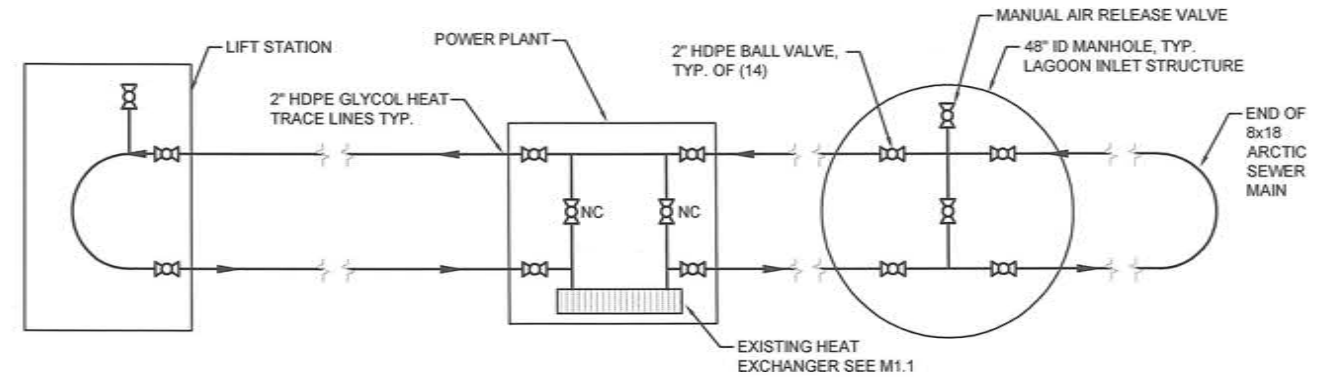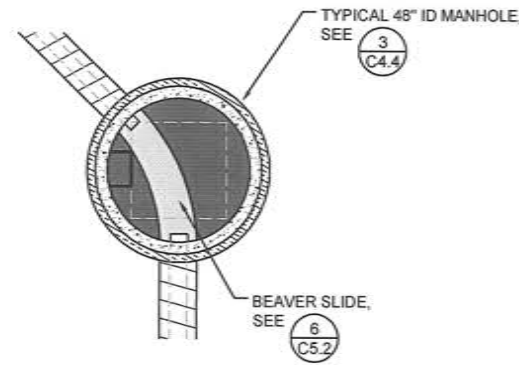

2 GLYCOL HEAT TRACE SCHEMATIC
C4.2 NTS

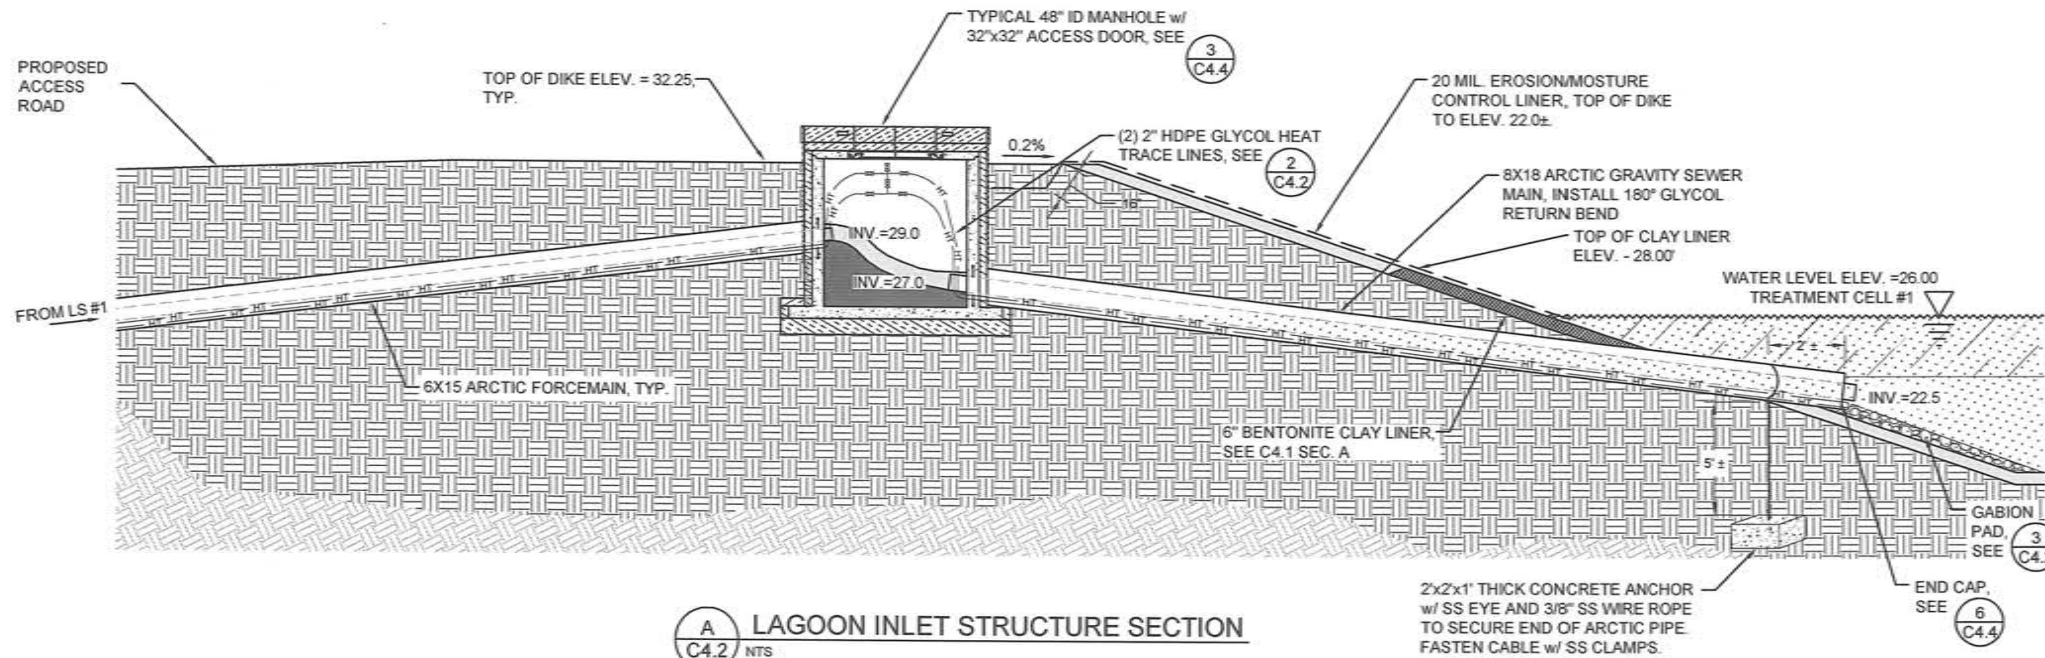

A LAGOON INLET STRUCTURE SECTION
C4.2 NTS

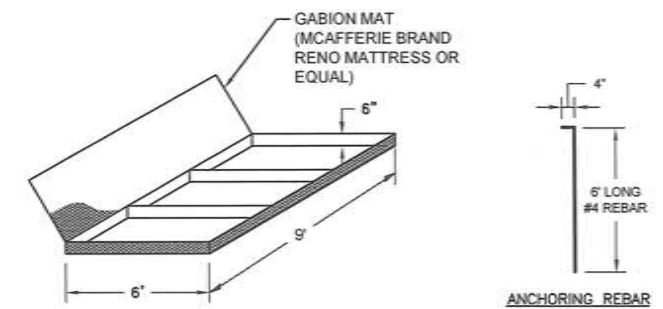

- NOTES:
- GABIONS SHALL BE LINED WITH A U.V. RESISTANT, WOVEN GEOTEXTILE AMOCO 2016 OR EQUAL, PRIOR TO BEING FILLED. AFTER LINING, GABIONS SHALL BE FILLED, PER MANUFACTURER'S RECOMMENDED PROCEDURES, WITH IMPORTED ROCK OR BROKEN CONCRETE (3"-4" PARTICLE SIZE).
 - ANCHOR GABIONS INSTALLED ON SLOPES USING 6' LONG, HOOKED #4 REBAR, AS NECESSARY.
 - INTERLOCK GABION "MATTRESSES" USING HOG RINGS AT 1' O.C.

3 GABION MAT DETAILS
C4.2 NTS

RECORD DRAWING CERTIFICATE
THESE DRAWINGS REFLECT RECORDED INFORMATION OBTAINED DURING CONSTRUCTION. INFORMATION PROVIDED HEREIN IS ACCURATE TO THE BEST OF MY KNOWLEDGE.

SCALE: AS SHOWN

DATE: _____

NAME: _____







2010-11 WASTEWATER SYSTEM IMPROVEMENTS
LAGOON INLET STRUCTURE
TULUKSAK, ALASKA



REVISION	BY	DATE
NOTES	AW	2/10
LAGOON RELOCATION	CM	4/14

Project No.	APRIL 2014
Date	MRE
Designed	CM
Drawn	MRE
Approved	

Sheet No. C4.2

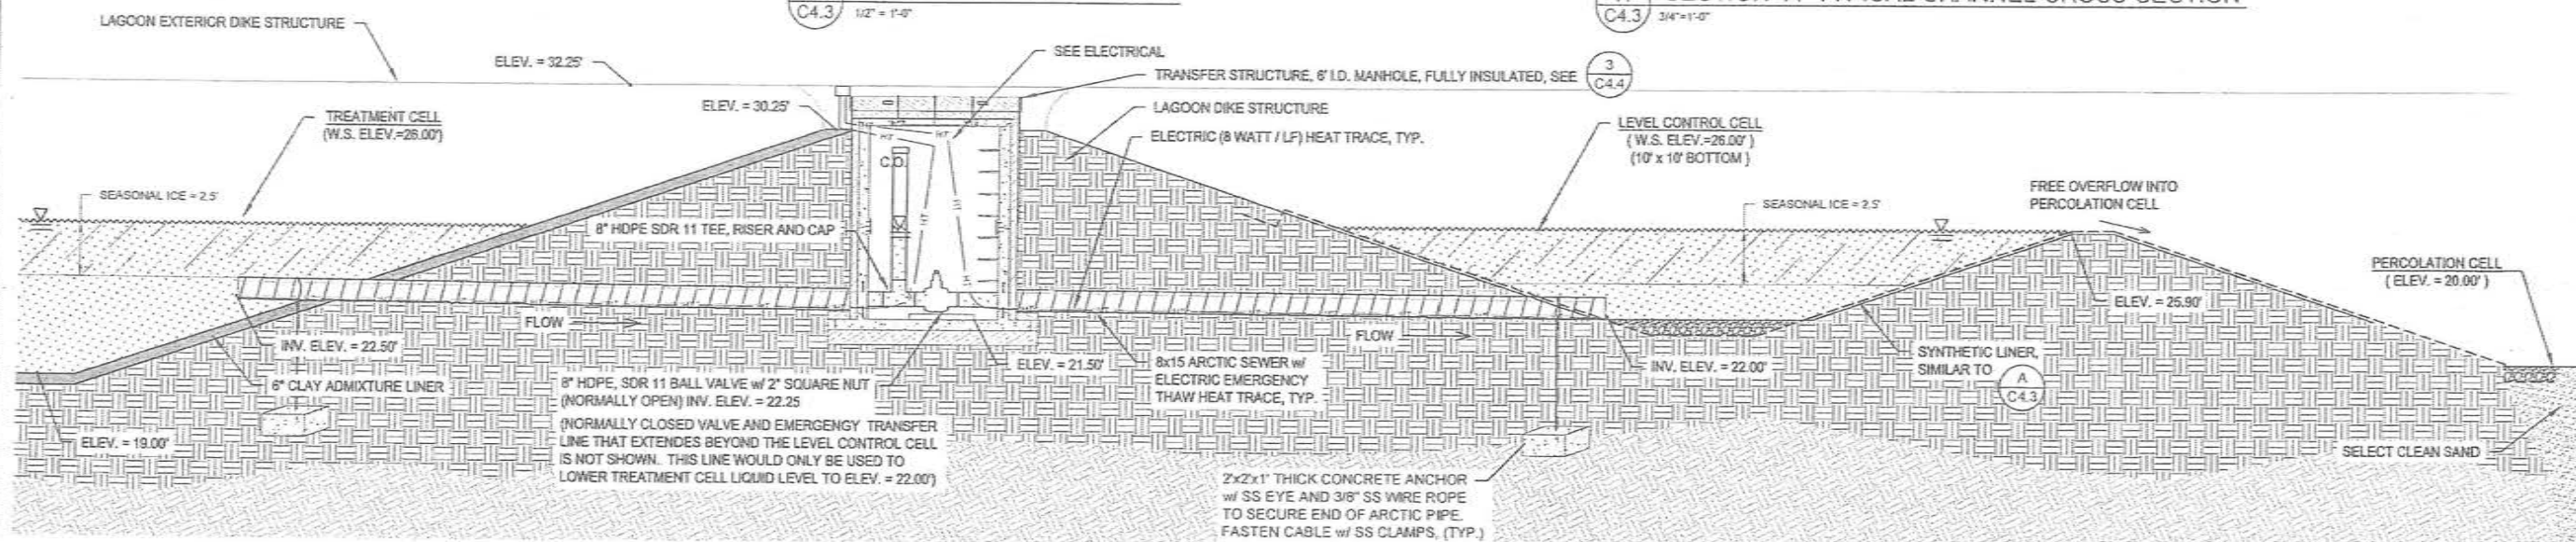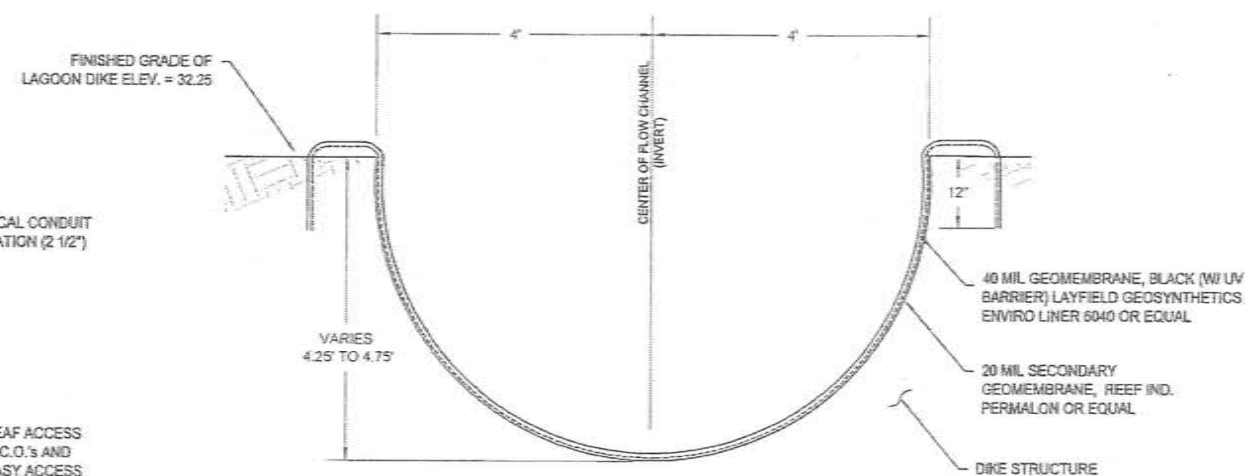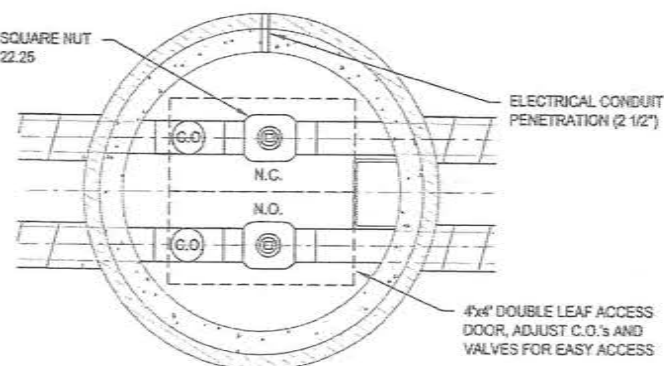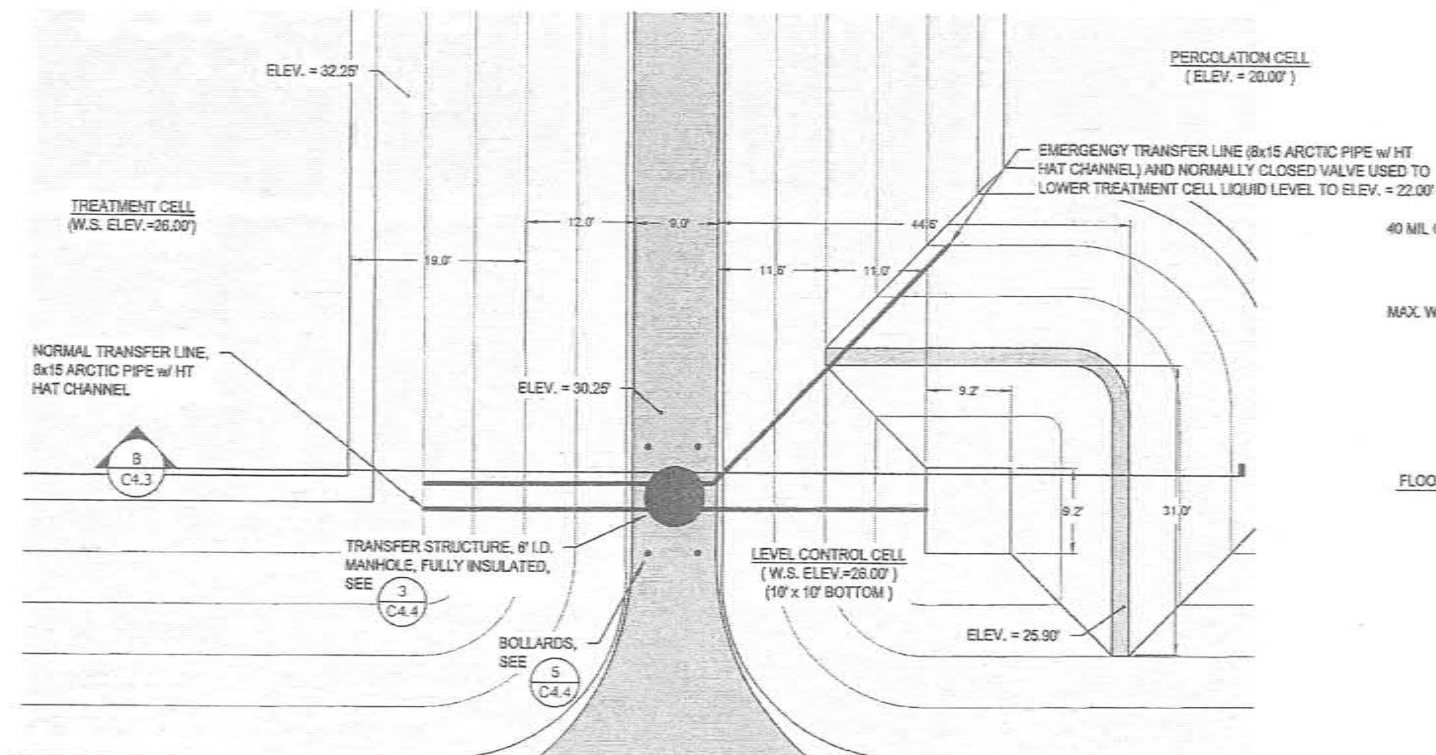

RECORD DRAWING CERTIFICATE
THESE DRAWINGS REFLECT RECORDED INFORMATION OBTAINED DURING CONSTRUCTION. INFORMATION PROVIDED HEREIN IS ACCURATE TO THE BEST OF MY KNOWLEDGE.

SCALE: AS SHOWN

DATE: _____

NAME: _____

2010-11 WASTEWATER SYSTEM IMPROVEMENTS

CELL TRANSFER STRUCTURE AND OVERFLOW CHANNELS


TULUKSAK, ALASKA

CER ENGINEERS, INC.
PO BOX 22044 ANCHORAGE, AK 99523 TEL 907-548-1010 FAX 907-549-1015


REVISION	DATE	BY	DATE
NOTES ADDED	2/10	LAW	2/10

Project No. _____ Date: JUNE 2009 Designed: LAP Drawn: LAP Approved: LAP


Sheet No. **C4.3**

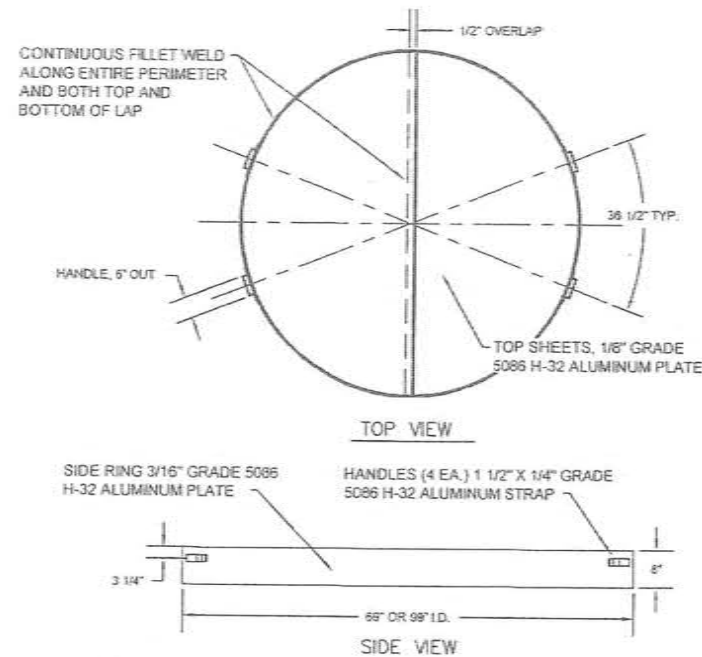



1 REMOVABLE TOP COVER
C4.4 NTS

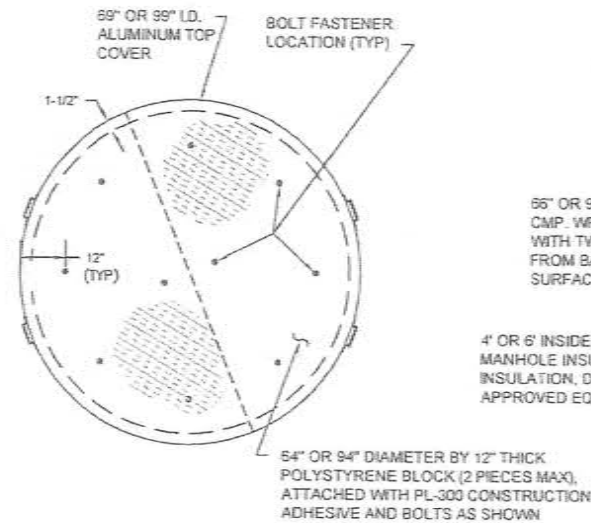


2 INSULATION FASTENERS
C4.4 NTS

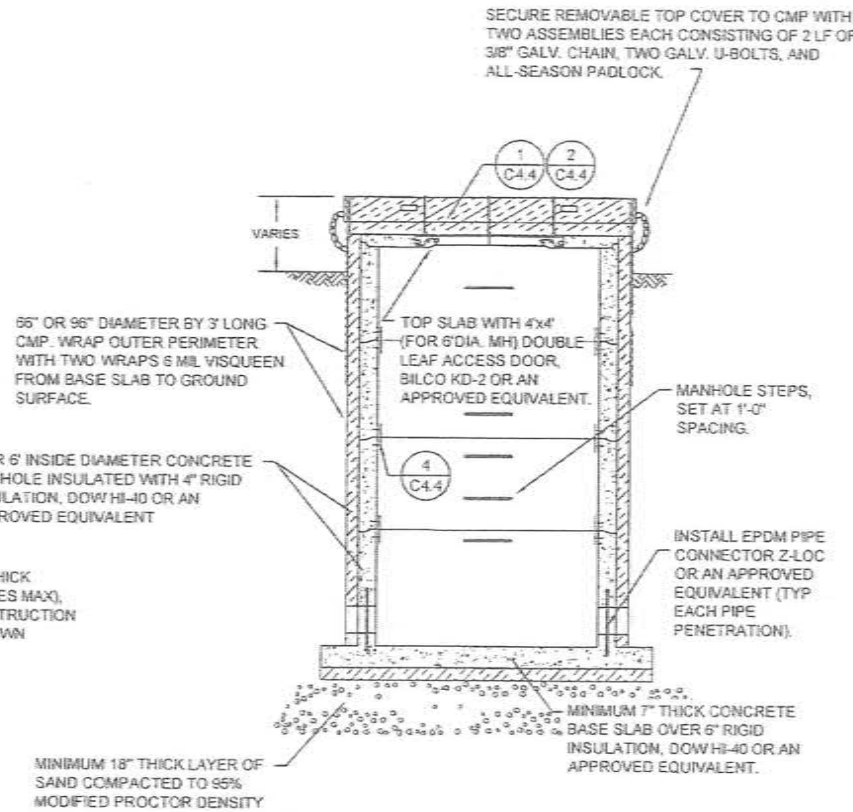


3 MANHOLE STRUCTURE
C4.4 NTS

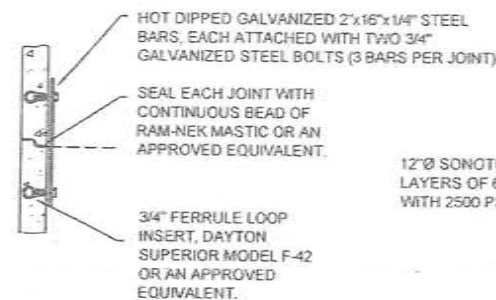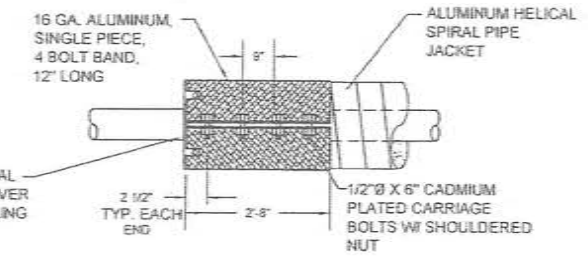

4 JOINT STRAPPING
C4.4 NTS

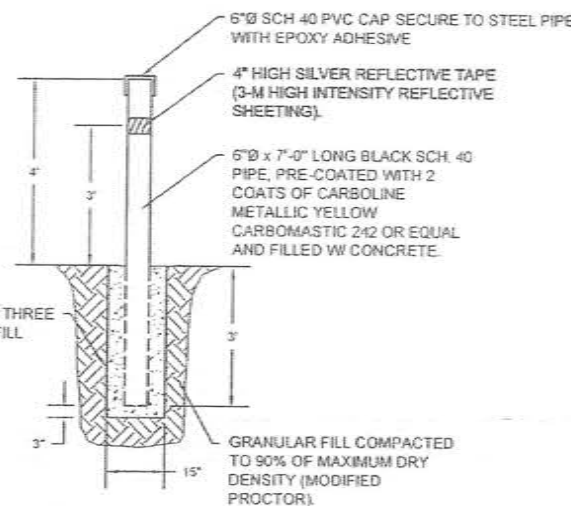

5 BOLLARD
C4.4 NTS

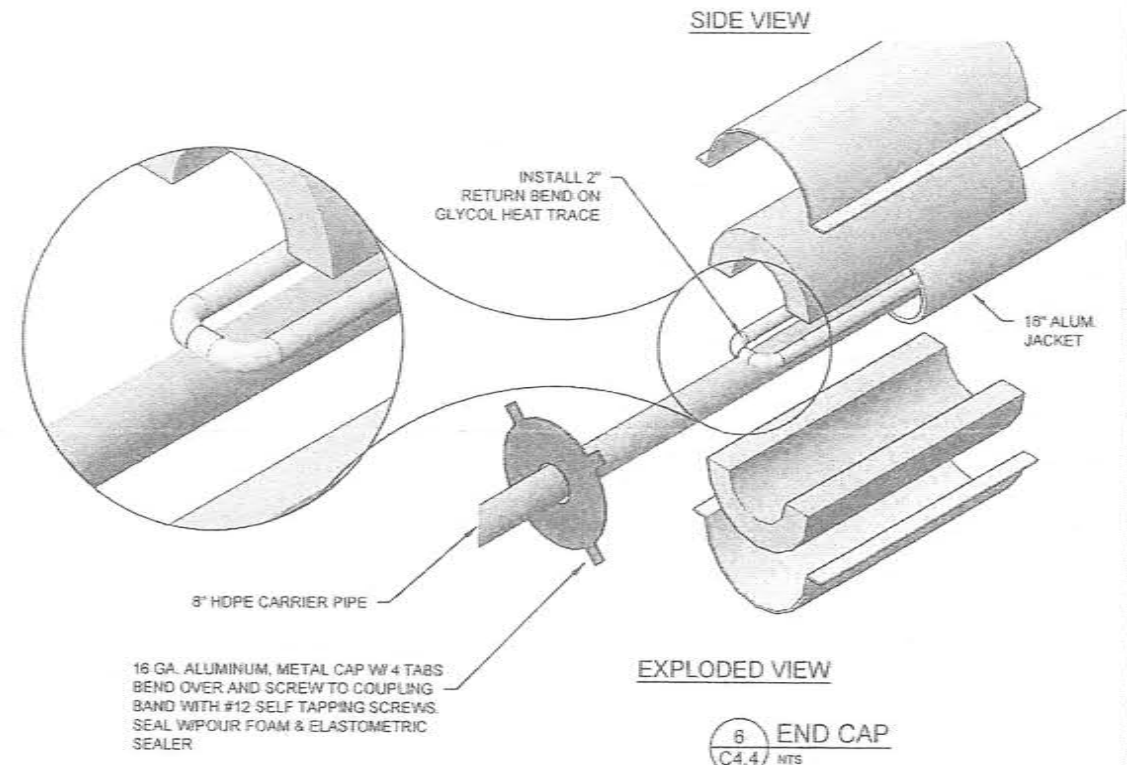

EXPLODED VIEW

6 END CAP
C4.4 NTS

CONTROL STRUCTURE INSTALLATION NOTES

1. PRECAST MANHOLE SECTIONS SHALL BE REINFORCED CONCRETE CONFORMING TO ASTM C-478.
2. THE MANHOLE BASE SHALL BE INTEGRALLY CAST WITH THE BOTTOM BARREL SECTION. FIELD GROUT FILLETS, AS REQUIRED.
3. RAM-NEK SEALANT OR AN ENGINEER APPROVED RUBBER GASKET SUPPLIED BY THE MANHOLE MANUFACTURER SHALL BE INSTALLED TO PROVIDE A COMPLETE, CONTINUOUS SEAL AT ALL PRECAST JOINTS.
4. FERRULE LOOP INSERTS AND JOINT STRAPS SHALL BE PROVIDED AS SHOWN.
5. EPDM PIPE CONNECTORS (Z-LOCK OR EQUAL) SHALL BE INSTALLED AT ALL PIPE PENETRATIONS.
6. MANHOLE COVER SHALL MEET ALASKA DEPARTMENT OF HIGHWAYS STANDARD SPECIFICATIONS (IFCO 740 OR EQUAL.) MANHOLE STEPS SHALL BE CAST IN PLACE AND SHALL BE 1/2" GRADE 60 STEEL REINFORCEMENT DIPPED IN COPOLYMER POLYPROPYLENE PLASTIC.
7. ALL PREFABRICATED ARCTIC PIPE FITTINGS SHALL BE FACTORY ASSEMBLED IN ACCORDANCE WITH THE DRAWINGS AND DELIVERED TO THE JOB SITE READY TO INSTALL.

RECORD DRAWING CERTIFICATE

THESE DRAWINGS REFLECT RECORDED INFORMATION OBTAINED DURING CONSTRUCTION. INFORMATION PROVIDED HEREIN IS ACCURATE TO THE BEST OF MY KNOWLEDGE.

SCALE: AS SHOWN

DATE: _____

NAME: _____



2010-11 WASTEWATER SYSTEM IMPROVEMENTS

TYPICAL CONTROL STRUCTURE DETAILS

TULUKSAK, ALASKA



REVISION	DATE

Project No. _____

Date: JUNE 2008

Designed: GWF

Drawn: DOR

Approved: LAP

Sheet No. C4.4



1 EXISTING SCHOOL WASTEWATER LAGOON
C4.5



2 EXISTING COMMUNITY WASTEWATER LAGOON
C4.5

CLOSE OUT PLAN OF EXISTING TULUKSAK WASTEWATER LAGOONS

OBJECTIVE:

- TO CLOSE OUT THE EXISTING SCHOOL WASTEWATER LAGOON AND THE EXISTING COMMUNITY LAGOON. THE LAGOONS ARE CURRENTLY IN USE. THE LAGOONS CAN BE ABANDONED UPON CONSTRUCTION OF THE PHASE I AND II WASTEWATER IMPROVEMENTS BEING CONSTRUCTED BY TULUKSAK NATIVE COMMUNITY (TNC) USING VILLAGE SAFE WATER FUNDING

ASSUMPTIONS:

- SLUDGE PROPOSED TO BE COVERED UNDER THIS PLAN IS ASSUMED NOT TO CONTAIN HAZARDOUS WASTES (SLUDGE HAS BEEN GENERATED FROM DOMESTIC WASTEWATER) AND DOES NOT CONTAIN CONCENTRATIONS OF POLYCHLORINATED BIPHENYLS (PCB) WASTES.
- SLUDGE TO BE COVERED UNDER THIS PLAN DOES NOT CONTAIN "FREE LIQUIDS" AS DEFINED BY EPA METHOD 3095 (PAINT FILTER LIQUIDS TEST) AND LIQUIDS ARE NOT IGNITABLE OR CORROSIVE.

CLOSURE PLAN:

- LIQUID CONTENTS OF THE LAGOONS AT THE TIME OF CLOSEOUT WILL BE PUMPED INTO THE NEW WASTEWATER SYSTEM FOR DISCHARGE INTO THE NEW COMMUNITY WASTEWATER LAGOON.
- AFTER PUMPING OUT THE LIQUID PORTION, SELECTIVE BRUSH CUTTING WILL PREPARE THE AREA TO BE CLOSED. THE BRUSH WILL BE HAULED TO THE COMMUNITY DISPOSAL SITE.
- THE REMAINING SLUDGE WILL BE TREATED WITH HYDRATED LIME TO DESTROY EXISTING PATHOGENS.
 - SCHOOL LAGOON - UNIFORMLY SPREAD 2700# OF LIME OVER THE 90' X 100' AREA (3#/105Q. FT.)
 - COMMUNITY LAGOON - UNIFORMLY SPREAD 1200# OF LIME OVER THE 40'X100' AREA (3#/10 SQ. FT.)
- LIME COVERAGE WILL BE AT THE RATE OF 50 POUNDS PER 1000 GALLONS OF SLUDGE. THE LIME WILL BE INTEGRATED INTO THE TOP THREE INCHES. THIS HYDRATED LIME ADDITION WILL BRING THE PH TO 12 FOR A MINIMUM OF THIRTY MINUTES.
- LOCAL SILT WILL BE PLACED OVER THE LIMED SLUDGE TO A DEPTH THAT PROVIDES DRAINAGE AWAY FROM THE AREA. MINIMUM DEPTH OF FILL WILL BE TWO FEET.
- AGGRESSIVELY REVEGETATE LAGOON COVER MATERIAL TO ELIMINATE EROSION OF NEW LAGOON COVER MATERIAL. (SEE GENERAL NOTES FOR REQUIREMENTS.)

RECORD DRAWING CERTIFICATE
THESE DRAWINGS REFLECT RECORDED
INFORMATION OBTAINED DURING
CONSTRUCTION. INFORMATION PROVIDED
HEREIN IS ACCURATE TO THE BEST OF MY
KNOWLEDGE
NAME _____ DATE _____

SCALE:
AS SHOWN
DATE OF PREPARED BY
DATE OF CHECKED BY
DATE OF REVIEWED BY
DATE OF APPROVED BY



2010-11 WASTEWATER
SYSTEM IMPROVEMENTS
EXISTING WASTEWATER
LAGOON'S CLOSE-OUT
TULUKSAK, ALASKA

CEI
ENGINEERS, INC.
PO BOX 22006 ANCHORAGE, AK 99523 PH: 907-345-1000 FAX: 907-349-0935

REVISION	BY	DATE
LAGOON RELOCATION	LP	8/10

Project No.	SEPT 2010
Designed	LAP
Drawn	Chilaw
Approved	LAP

Sheet No. C4.5



REVISION	BY	DATE
LAGOON RELOCATION	CM	9/10

Project No. SEPT 2010
Date LAP
Designed CH/LAW
Drawn LAP
Approved LAP

Sheet No. C4.6

CES
ENGINEERS, INC.
PO BOX 22246 ANCHORAGE, AK 99523 PH 907-540-1010 FAX 907-540-1015


2010-11 WASTEWATER
SYSTEM IMPROVEMENTS
FIVE ARRA
SERVICE LINES
TULUKSAK, ALASKA




RECORD DRAWING CERTIFICATE
THESE DRAWINGS REFLECT RECORDED
INFORMATION OBTAINED DURING
CONSTRUCTION. INFORMATION PROVIDED
HEREIN IS ACCURATE TO THE BEST OF MY
KNOWLEDGE.
NAME _____ DATE _____
SCALE: AS SHOWN
1" = 40' (SEE SHEET C5.4 FOR SCALE)
1" = 40' (SEE SHEET C5.4 FOR SCALE)

Sheet No. C4.7


G:\ACAD\TULUKSAK\T10901 2008 Waste water disposal area\TFC Rev Apr 2014\C4.8_8 Honey bucket dump station.dwg, 5/6/2014 5:28:33 PM, cmerz, \\C02main\LANIER MP C2050\LD520C PCL 6

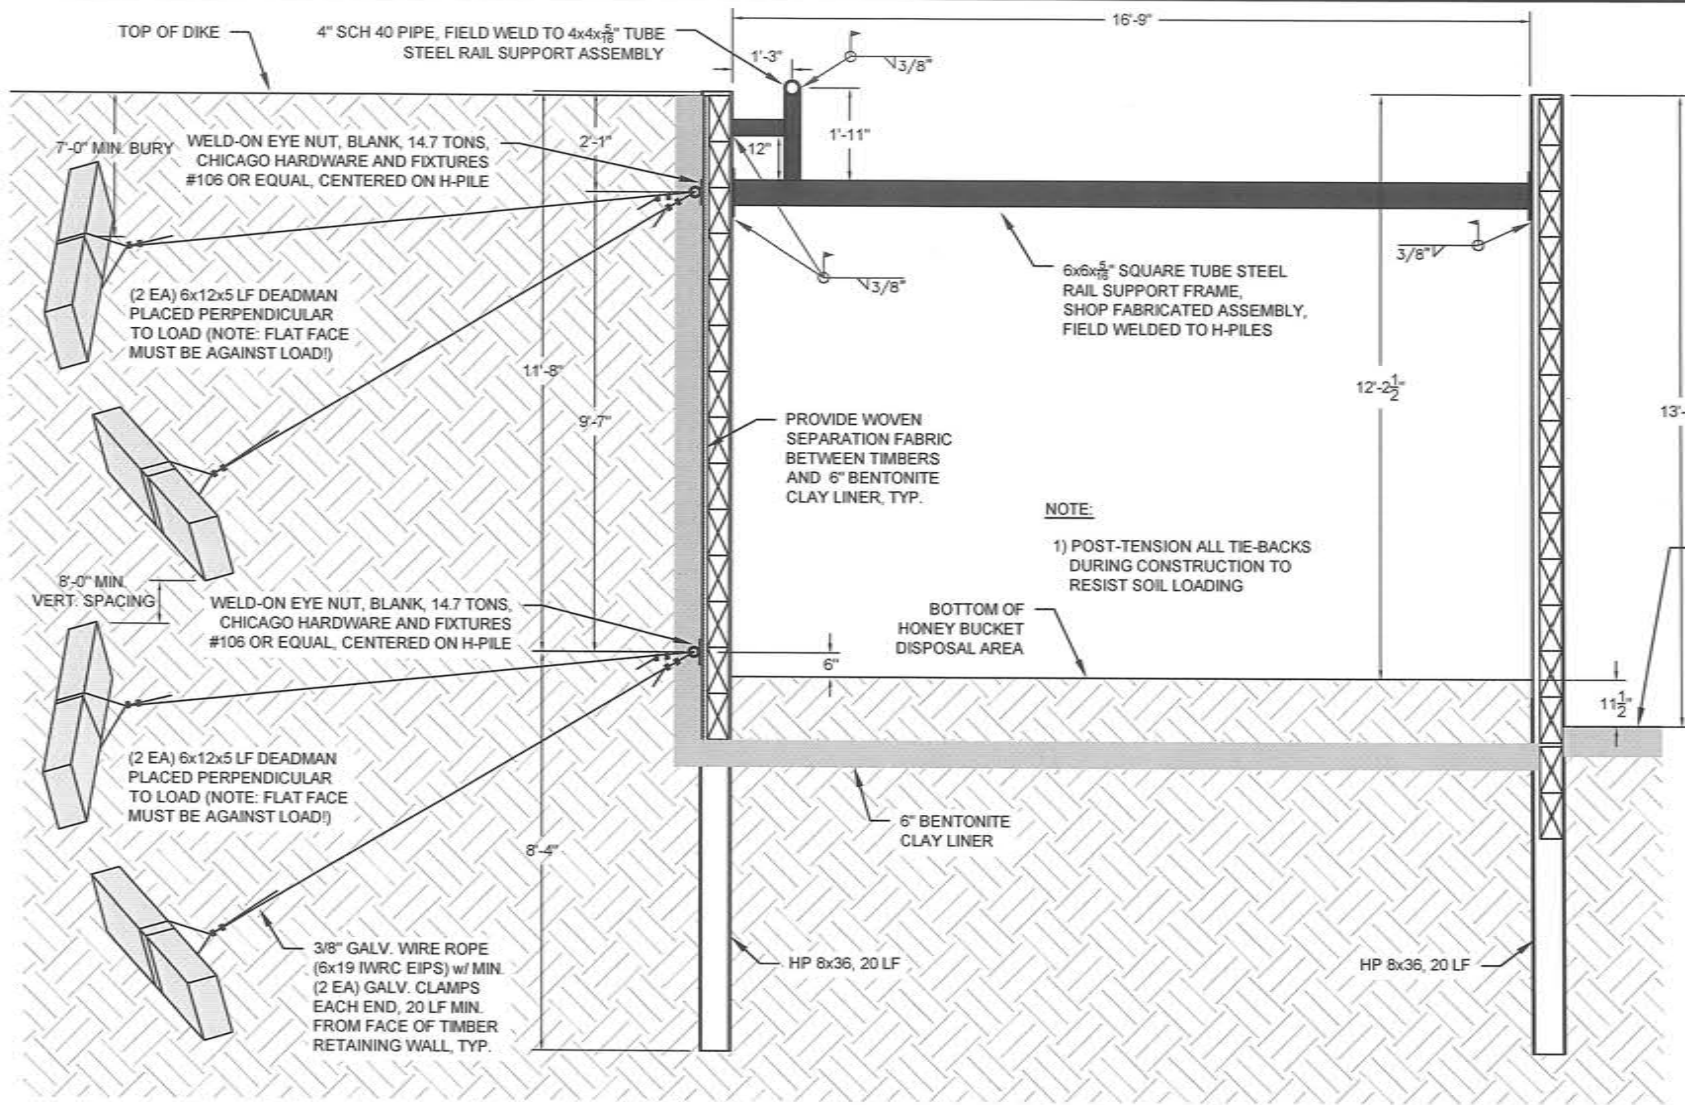


1 H-PILE SECTION VIEW
C4.8 1/2" = 1'-0"

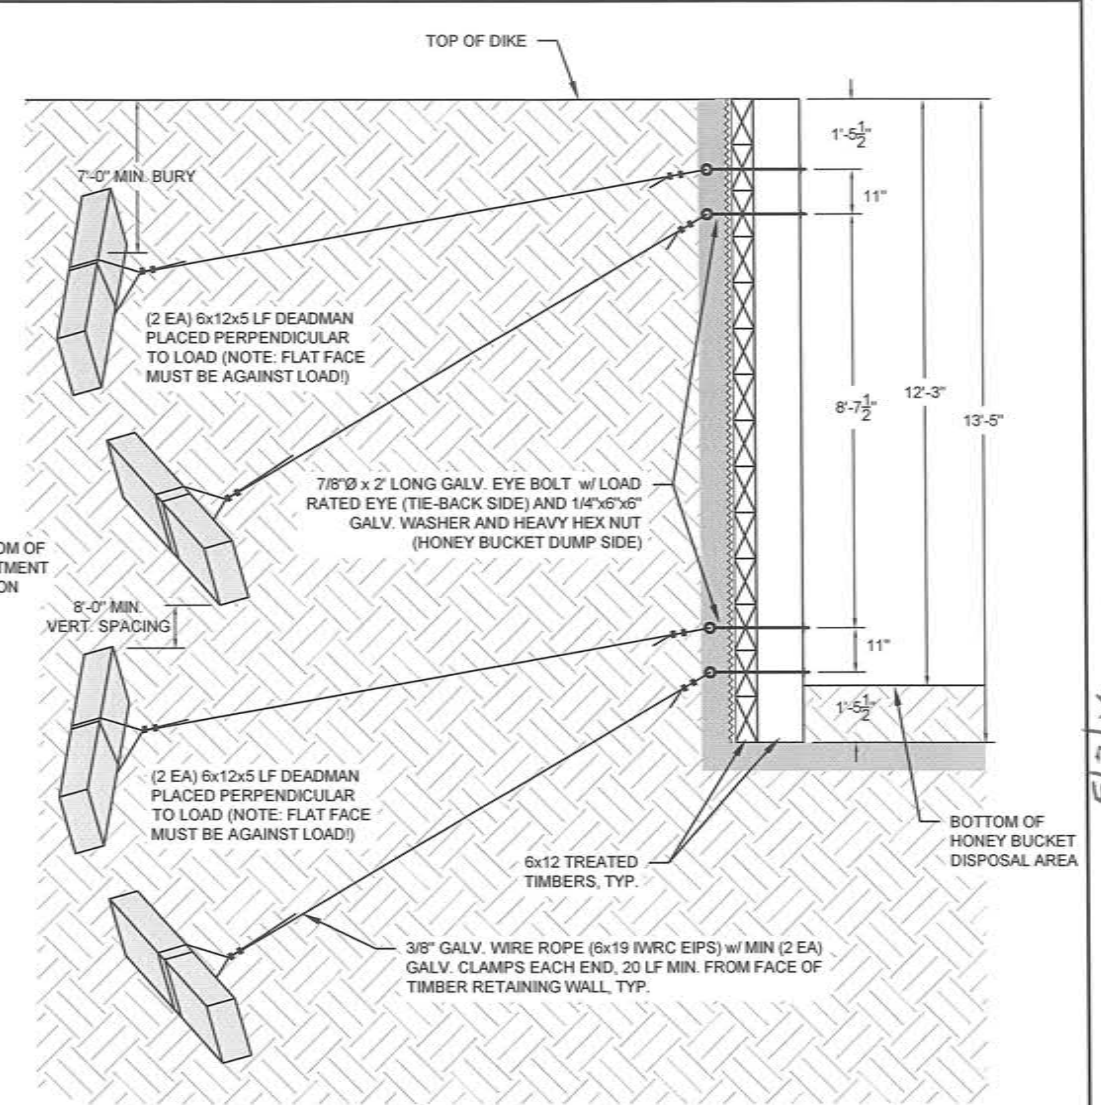


2 STRONG-BACK SECTION VIEW
C4.8 1/2" = 1'-0"

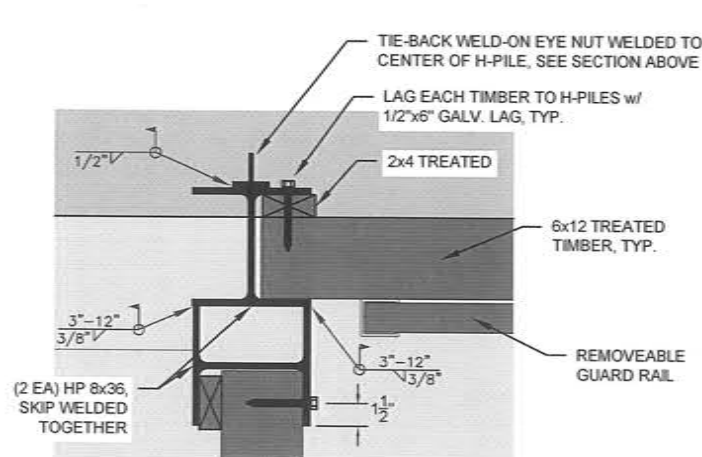

3 CORNER H-PILE PLAN VIEW
C4.8 N.T.S.

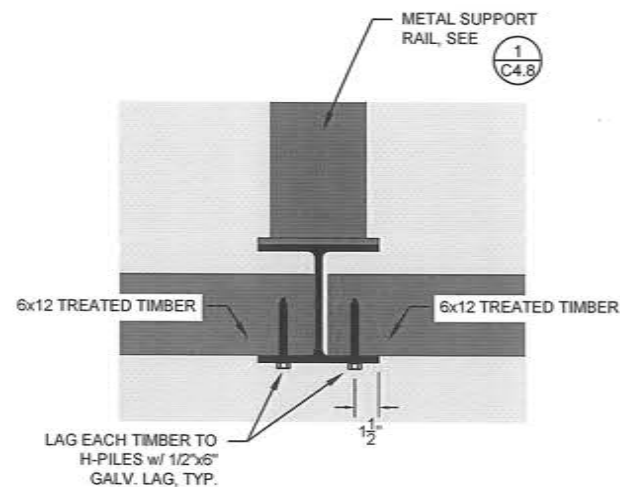

3 TYPICAL H-PILE PLAN VIEW
C4.8 N.T.S.

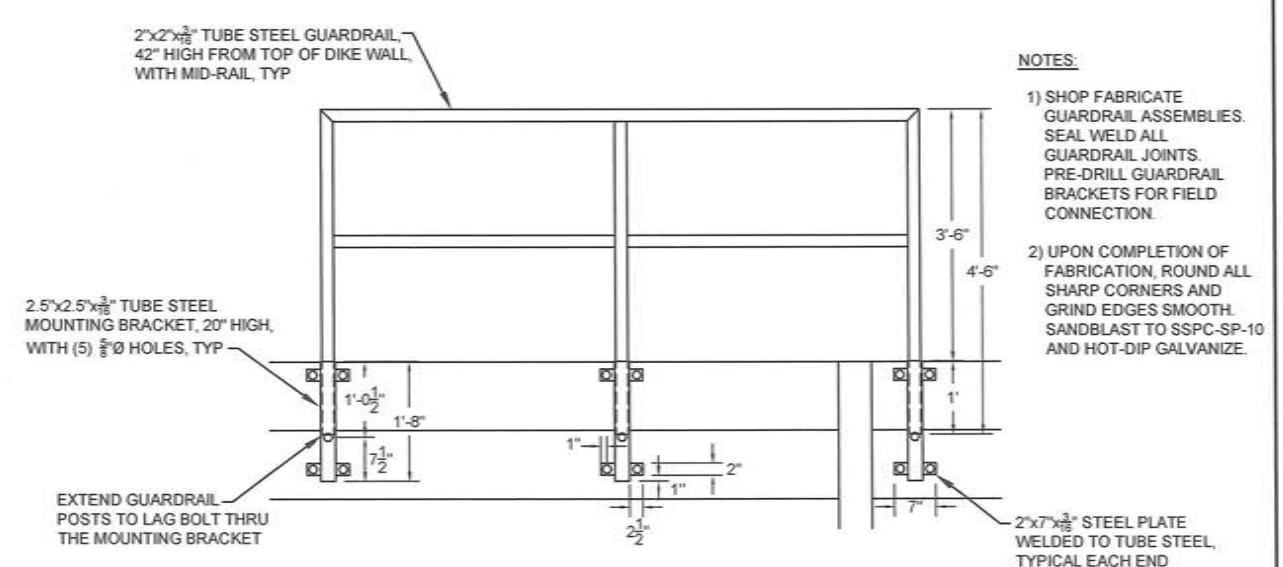

5 REMOVEABLE GUARDRAIL CONNECTION
C4.8 3/4" = 1'-0"

- NOTES:
- 1) SHOP FABRICATE GUARDRAIL ASSEMBLIES. SEAL WELD ALL GUARDRAIL JOINTS. PRE-DRILL GUARDRAIL BRACKETS FOR FIELD CONNECTION.
 - 2) UPON COMPLETION OF FABRICATION, ROUND ALL SHARP CORNERS AND GRIND EDGES SMOOTH. SANDBLAST TO SSPC-SP-10 AND HOT-DIP GALVANIZE.

RECORD DRAWING CERTIFICATE
THESE DRAWINGS REFLECT RECORDED
INFORMATION OBTAINED DURING
CONSTRUCTION. INFORMATION PROVIDED
HEREIN IS ACCURATE TO THE BEST OF MY
KNOWLEDGE.


SCALE:
AS SHOWN
DATE: APRIL 2014
DESIGNED: LAP
DRAWN: CML
APPROVED: MRE

5/7/14
TULUKSAK, ALASKA
HONEY BUCKET
DISPOSAL AREA DETAILS
2010-11 WASTEWATER
SYSTEM IMPROVEMENTS


CE2
ENGINEERS, INC.
PO BOX 22946 ANCHORAGE, AK 99523 PH: 907-546-1010 FAX: 907-546-1015

BY: DATE: REVISION: PROJECT: TULUKSAK, ALASKA
DATE: APRIL 2014
DESIGNED: LAP
DRAWN: CML
APPROVED: MRE
Sheet No. C4.8



G:\ACAD\TULUUKSAK\T0901_2008 Waste water disposal area\C5.1 ARCTIC PIPE DETAILS.dwg, 1/11/2011 1:44:01 PM, Flah, LANIER MP C2050_LDS20C PCL 6BLK WHIT.pcl

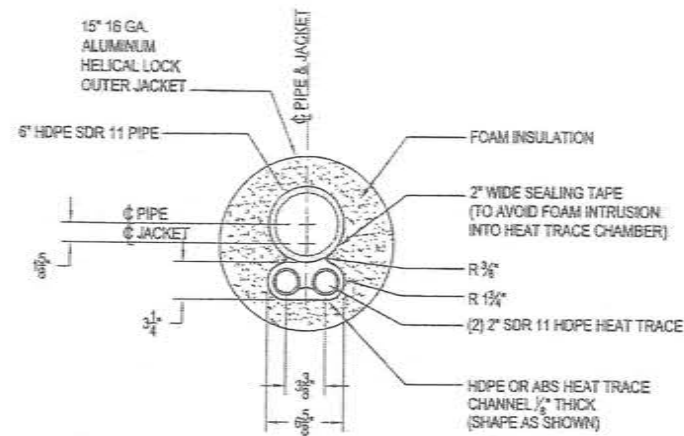


1
C5.1
6" X 15" HDPE ARCTIC PIPE
CROSS SECTION - GLYCOL TRACED
1 1/2" = 1'-0"

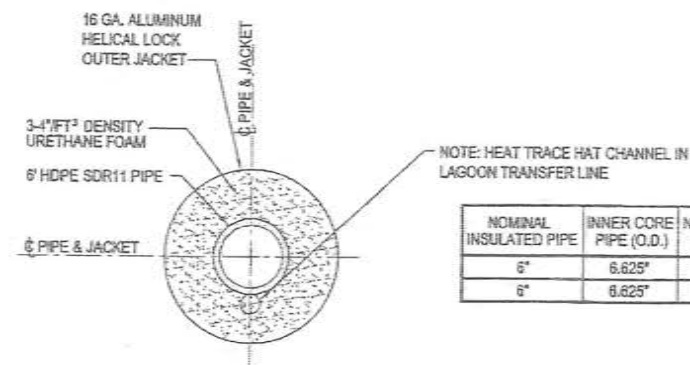


4
C5.1
HDPE ARCTIC PIPE CROSS
SECTION LAGOON TRANSFER LINE
NTS

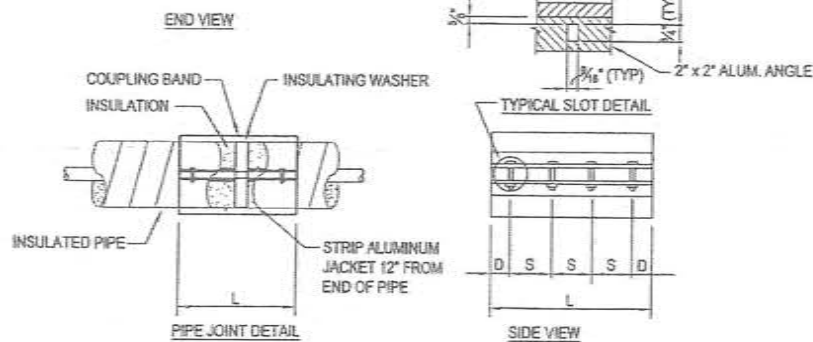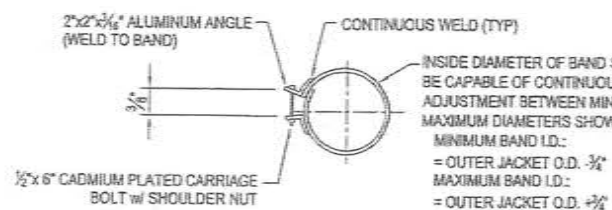


7
C5.1
ARCTIC PIPE COUPLING BAND
NTS

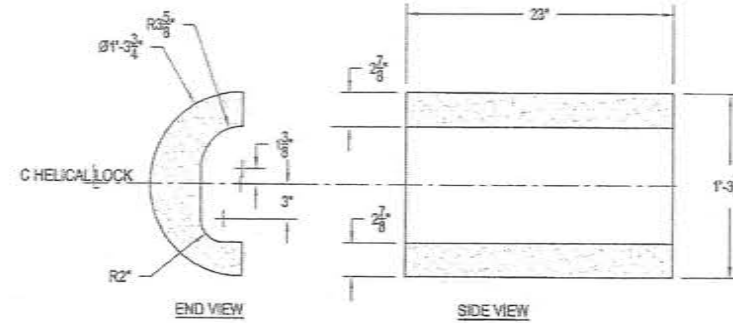


2
C5.1
6" X 15" HDPE ARCTIC PIPE
HALF SHELL - GLYCOL TRACED
1 1/2" = 1'-0"

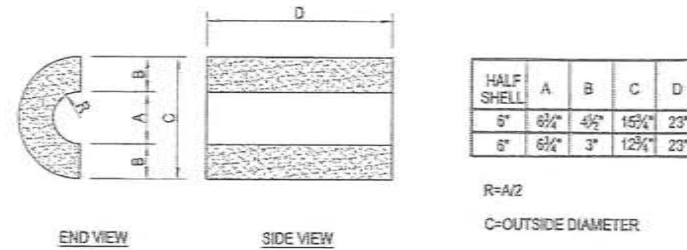


5
C5.1
INSULATION HALF SHELL DETAIL
NTS

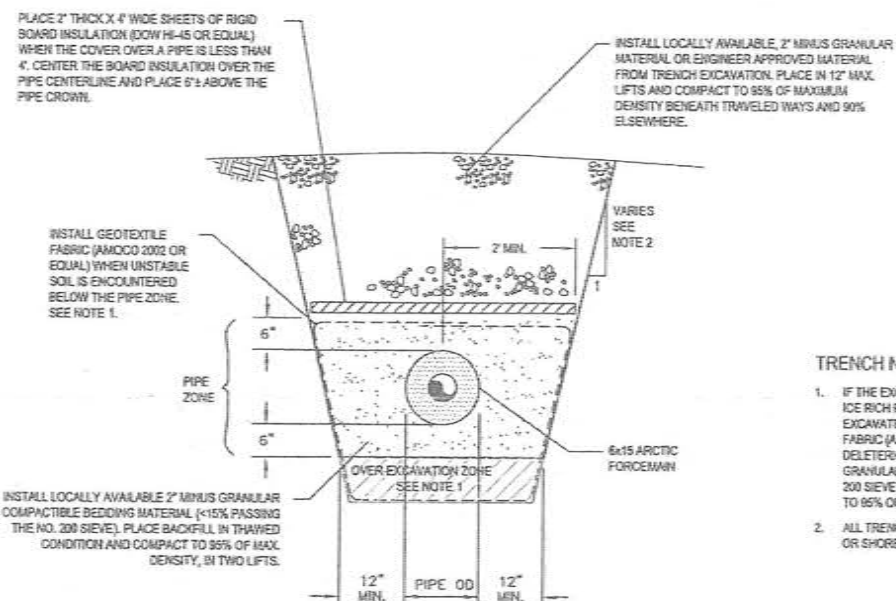

A
C5.1
TYPICAL TRENCH SECTION FOR PIPE
INSTALLED BENEATH PROPOSED ACCESS ROAD
NTS

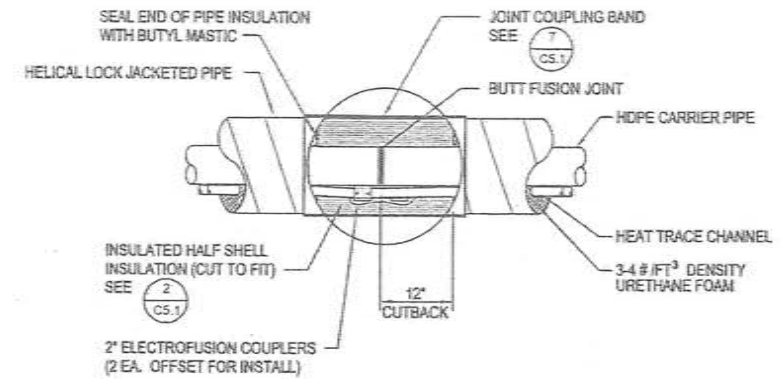

3
C5.1
BUTT FUSION JOINT w/ HEAT
TRACE ELECTROFUSION COUPLERS
NTS (FORCEMAIN ONLY)

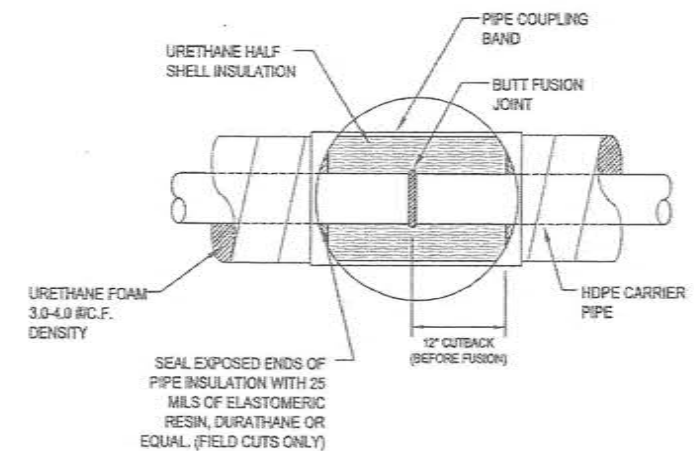

6
C5.1
BUTT FUSED JOINT DETAIL
NTS (WATERMAIN AND SERVICE DUCT)

TRENCH NOTES:

- IF THE EXCAVATION ENCOUNTERS ORGANICS, SILTS AND/OR ICE RICH PERMAFROST BENEATH THE PIPE ZONE, OVER EXCAVATE A MINIMUM OF 12" AND INSTALL GEOTEXTILE FABRIC (AMOCO 2002 OR EQUAL) AS SHOWN. REPLACE THE DELETERIOUS MATERIAL WITH LOCALLY AVAILABLE 2" MINUS GRANULAR COMPACTIBLE FILL (WITH <15% PASSING THE NO. 200 SIEVE). PLACE FILL IN THAWED CONDITION AND COMPACT TO 95% OF MAXIMUM MODIFIED PROCTOR DRY DENSITY.
- ALL TRENCHES AND OTHER EXCAVATIONS SHALL BE SLOPED OR SHORED IN ACCORDANCE WITH OSHA STANDARDS.

RECORD DRAWING CERTIFICATE
THESE DRAWINGS REFLECT RECORDED
INFORMATION OBTAINED DURING
CONSTRUCTION. INFORMATION PROVIDED
HEREIN IS ACCURATE TO THE BEST OF MY
KNOWLEDGE.

SCALE:
AS SHOWN
DATE: _____
NAME: _____




2010-11 WASTEWATER
SYSTEM IMPROVEMENTS
ARTIC PIPE DETAILS
TULUUKSAK, ALASKA

CEE
ENGINEERS, INC.
PO BOX 22046 ANCHORAGE, AK 99523 TEL 907-546-1000 FAX 907-546-1015


REVISION	DATE	BY

Project No. _____
Date: JUNE 2009
Designed: LAP
Drawn: DDR
Approved: LAP

Sheet No. _____
C5.1

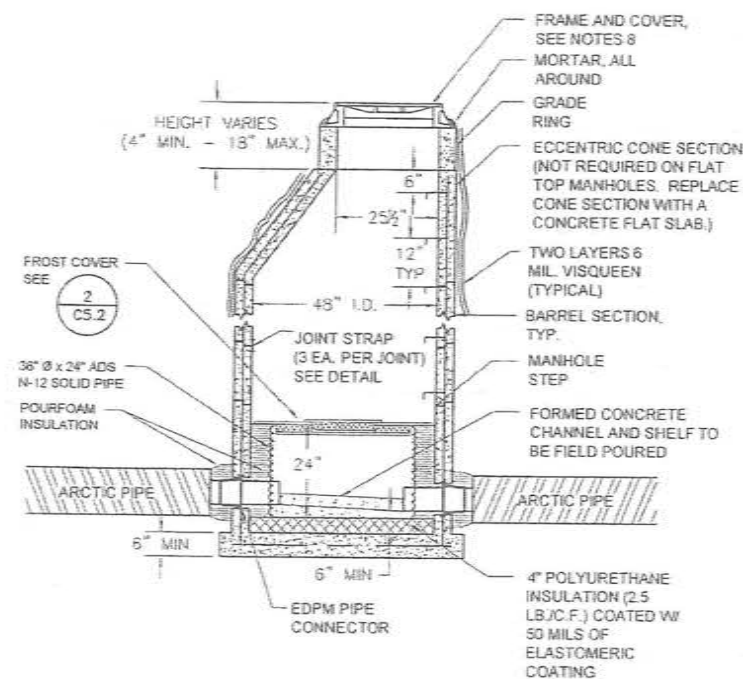


1 MANHOLE DETAILS
SCALE: NTS

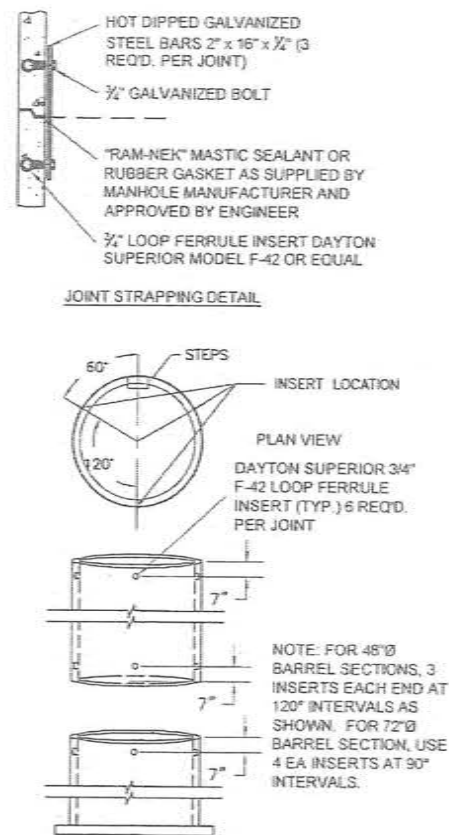


FERRULE INSERT LOCATIONS

SANITARY MANHOLE NOTES:


1. PRECAST MANHOLE SECTIONS SHALL BE REINFORCED CONCRETE CONFORMING TO ASTM C-478.
2. THE MANHOLE BASE SHALL BE INTEGRALLY CAST WITH THE BOTTOM BARREL SECTION.
3. RAM-NEK SEALANT OR ENGINEER APPROVED RUBBER GASKET AS SUPPLIED FROM MANHOLE MANUFACTURER SHALL BE INSTALLED AT ALL PRECAST JOINTS.
4. LOOP FERRULE INSERTS AND JOINT STRAPS SHALL BE PROVIDED AS SHOWN ON THE DETAIL.
5. EDPM PIPE CONNECTORS (Z-LOCK OR EQUAL) SHALL BE INSTALLED AT ALL PIPE PENETRATIONS.
6. PIPES PENETRATING THE MANHOLE SHALL EXTEND 3 INCHES INTO THE MANHOLE.
7. FOR MANHOLE HEIGHTS LESS THAN 6 FEET, SUBSTITUTE A PRECAST REINFORCED CONCRETE FLAT SLAB TOP FOR THE ECCENTRIC CONE SECTION.
8. MANHOLE RING, CATCH PAN AND SOLID COVER MARKED "SEWER" SHALL MEET ALASKA DEPARTMENT OF TRANSPORTATION STANDARD SPECIFICATION (IFCO 740 OR EQUAL).
9. MANHOLE STEPS SHALL BE CAST IN PLACE, AND SHALL BE 1/2" GRADE 60 STEEL REINFORCEMENT DIPPED IN COPOLYMER POLYPROPYLENE PLASTIC.
10. MANHOLE SHALL BE WRAPPED WITH 2 LAYERS OF 6 MIL VISQUEEN PRIOR TO BACKFILL.
11. TOP OF CASTING (T.O.C.) ELEVATION:
(a) GRAVEL ROAD SURFACE - 6" BELOW FINAL GRADE.
(b) PAVED ROAD SURFACE - INSTALL TOP OF COVER 1/2" BELOW SURFACE OF ASPHALT.
(c) OFF ROADS AND TRAVELED WAY - INSTALL TOP 6" ABOVE FINAL GRADE.

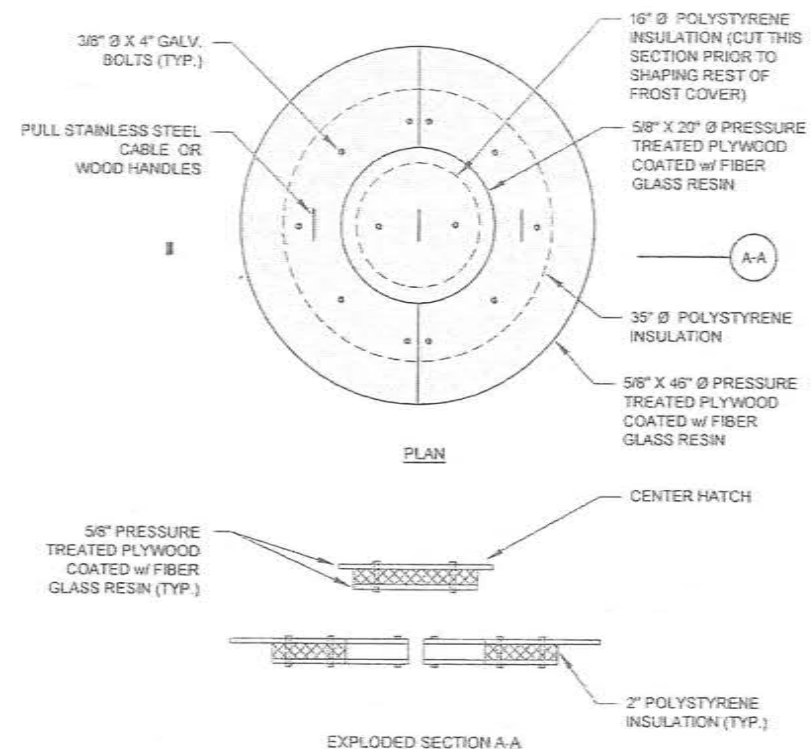


2 MANHOLE FROST COVER DETAILS
SCALE: NTS

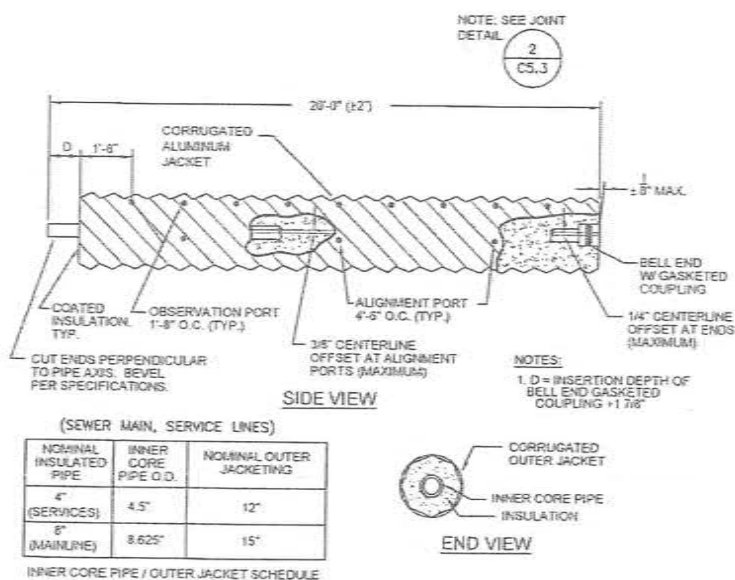


3 HDPE SEWER MAIN ALUMINUM JACKET
SCALE: NTS

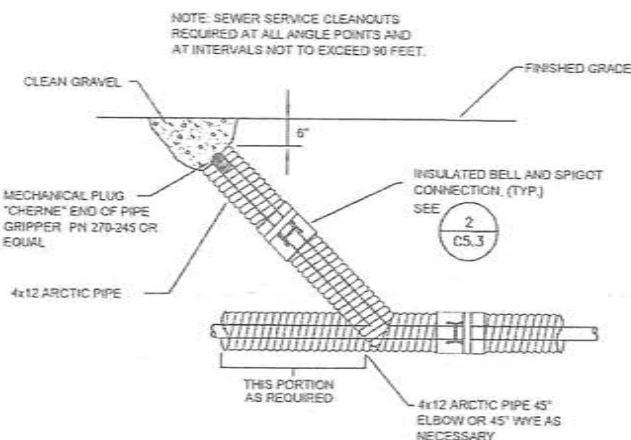

4 SEWER SERVICE CLEANOUT
SCALE: NTS

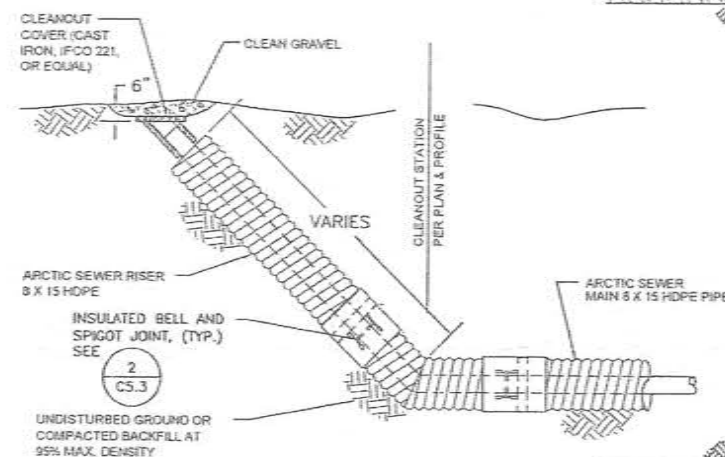

5 SEWER MAIN CLEANOUT
SCALE: NTS

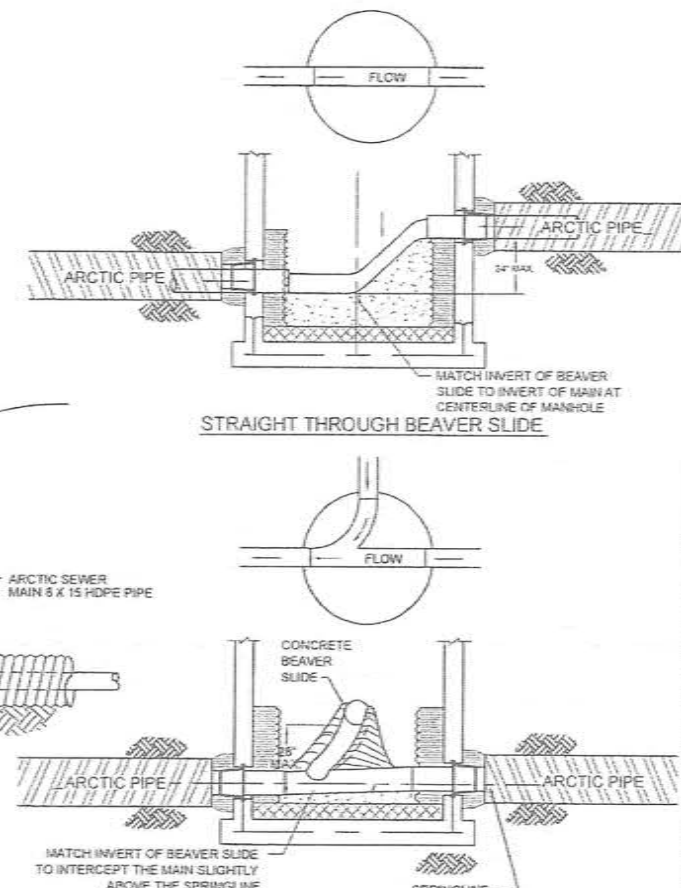

6 BEAVER SLIDE
SCALE: NTS

RECORD DRAWING CERTIFICATE
THESE DRAWINGS REFLECT RECORDED INFORMATION OBTAINED DURING CONSTRUCTION. INFORMATION PROVIDED HEREIN IS ACCURATE TO THE BEST OF MY KNOWLEDGE.
NAME _____ DATE _____

SCALE: AS SHOWN
1" = 10'-0" (VERTICAL)
1" = 10'-0" (HORIZONTAL)



2010-11 WASTEWATER SYSTEM IMPROVEMENTS
SEWER MAIN AND MANHOLE DETAILS
TULUKSAK, ALASKA

CEI
ENGINEERS, INC.
PO BOX 22346 ANCHORAGE, AK 99521 PH 907-549-1010 FAX 907-549-1015

BY	DATE
REVISION	

Project No. _____ Date: JUNE 2000
Designed: JHK
Drawn: LAM
Approved: LAP

Sheet No. C5.2

SECTION AA

3" MIN.

12" MIN.

3" MIN.

COMPACTED LOCAL SELECT FILL
CONSISTING OF WELL-GRADED GRANULAR FILL
PLACED IN 6" LIFTS AND COMPACTED TO 90% DENSITY.

GEOTEXTILE

EXISTING GROUND
IN SITU SOILS (SANDY SILT)

2" x 2" x 3/8" ALUMINUM
ANGLE WELDED TO
BAND (TYP.)

CONTINUOUS WELD (TYP.)

2" OVERLAP AT MAXIMUM BAND I.D.

AS REQUIRED

16 GA. ALUMINUM
SINGLE PIECE BAND

INSIDE DIAMETER OF BAND
SHALL BE CAPABLE OF
CONTINUOUS ADJUSTMENT
BETWEEN MIN. AND MAX.
DIAMETERS SHOWN BELOW

1/2" Ø x 6" CADMIUM PLATED
CARRIAGE BOLTS
W/SHOULDERED NUT
(4 EACH EQ. SPACED)

NOM. JACKET SIZE	ACTUAL JACKET SIZE (O.D.)	INSIDE DIAMETER	
		MIN.	MAX.
12"	12 $\frac{5}{8}$ "	12 $\frac{3}{8}$ "	13 $\frac{5}{8}$ "
15"	15 $\frac{5}{8}$ "	15 $\frac{3}{8}$ "	16 $\frac{5}{8}$ "
16"	16 $\frac{5}{8}$ "	16 $\frac{3}{8}$ "	17 $\frac{5}{8}$ "
18"	18 $\frac{3}{4}$ "	18 $\frac{3}{8}$ "	20"
21"	20 $\frac{3}{4}$ "	20 $\frac{3}{8}$ "	22"

ROAD CENTERLINE

7'

3%

2'

1'

COMPACTED LOCAL SELECT FILL
CONSISTING OF WELL-GRADED
GRANULAR FILL
PLACED IN 5' LIFTS AND
COMPACTED TO 90% DENSITY.

GEOTEXTILE

EXISTING GROUND
IN SITU SOILS (SANDY SILT)

Technical drawing of a bridge deck cross-section. The drawing shows a three-span bridge with a central pier. Dimensions include 7' for the span length, 3% for the deck slope, and 2' for the deck thickness. Labels include 'CMP CULVERT', 'CORTECH H-12 ONE PIECE HUGGER SAND', and 'SEE SECTION AA'.

SIDE VIEW

ELEVATION VIEW

4" HDPEx4" S.S. MIPT ADAPTER
POLYCAM SERIES 710

SERVICE SADDLE, RCMAC
SS1-H-4 50x5x1" IP

8"

THREADED CAP
W/ SQUARE OPERATING "NUT" (S.S.)

NOTE:
NOTCH THE ALUM. CLEANOUT COVER AS
REQUIRED TO ALLOW INSTALLATION AND
REMOVAL OF COVER. SEAL THE NOTCH
WITH A 16 GA. ALUM. SHROUD AND 3" OF
SHAPED NEOPRENE INSULATION. SECURE
SHROUD WITH S.S. SELF-TAPPING SCREWS

1" CORPORATION STOP, FORD F1102-4

RECORD DRAWING CERTIFICATE
THESE DRAWINGS REFLECT RECORDED
INFORMATION OBTAINED DURING
CONSTRUCTION. INFORMATION PROVIDED
HEREIN IS ACCURATE TO THE BEST OF MY
KNOWLEDGE.



2010-11 WASTEWATER SYSTEM IMPROVEMENTS


TRENCH AND SEWER
CONNECTION DETAILS

TULUKSAK, ALASKA

[illegible]

Project No. _____	Date _____	Designed _____	PCW _____
	JUNE 2009	Drawn _____	DDR _____
		Approved _____	PCW _____


Sheet No. C5.3

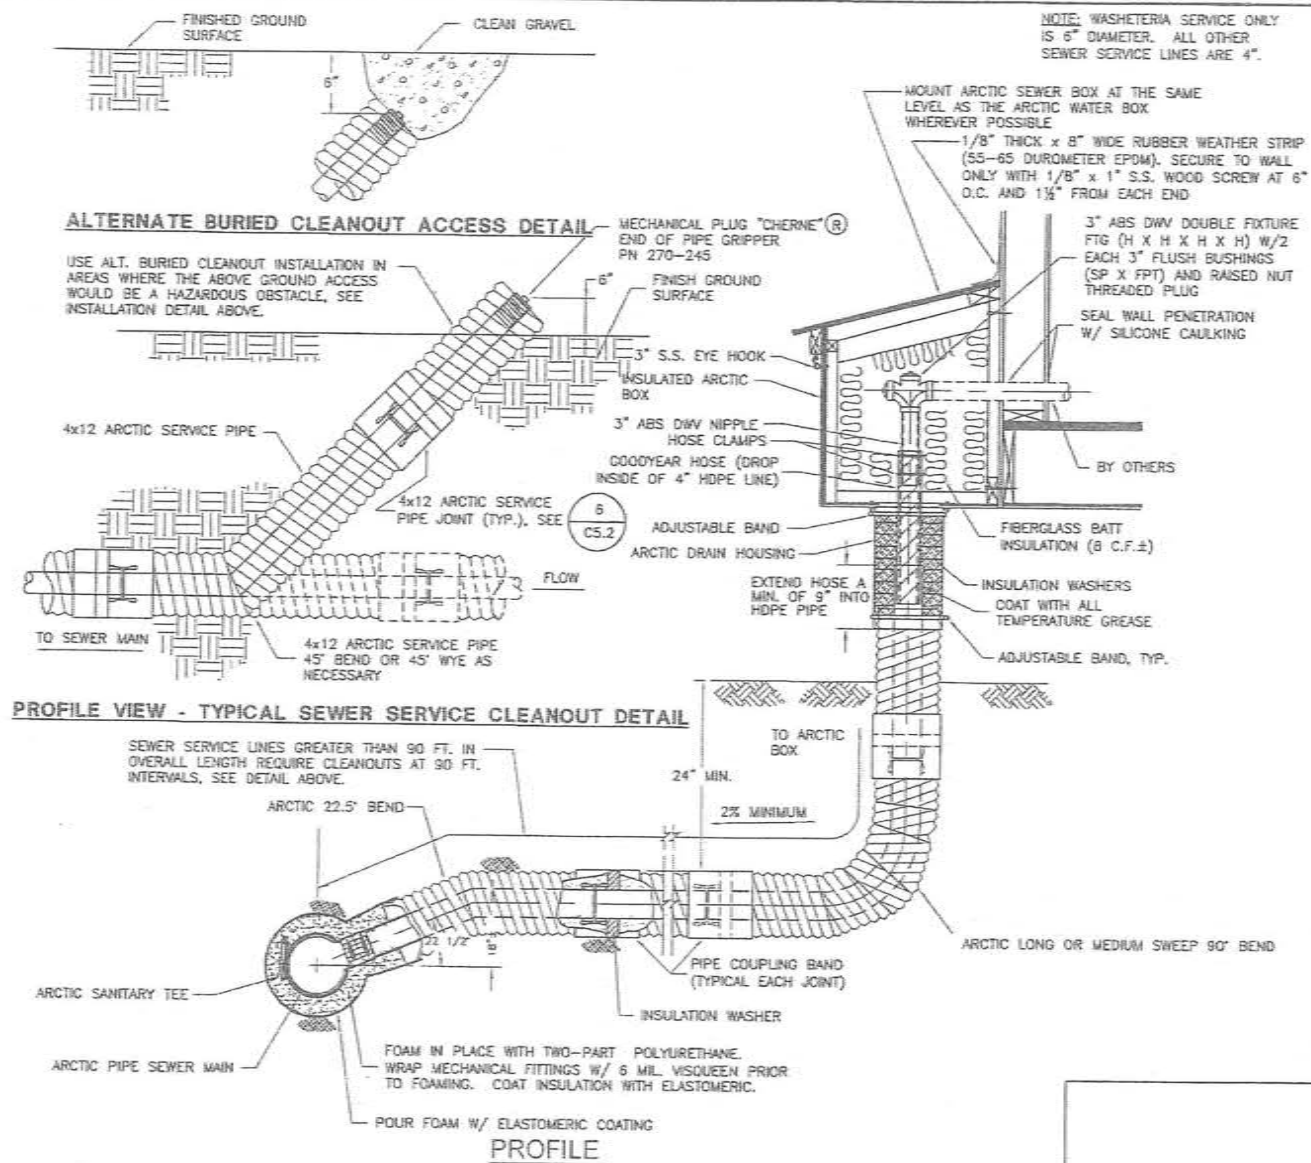

ARCTIC 11 1/4" OR ARCTIC 22 1/2" BEND	NOMINAL 4 X 12 OR 6 X 12 PRE-INSULATED HDPE 22 1/2" OR 11 1/4" BEND, IPS, SDR 17, 16 GA. CORRUGATED ALUMINUM JACKET, PUSH ON COUPLING X BEVELED END.
ARCTIC SERVICE LINE	NOMINAL 4 X 12 OR 6 X 12 PRE-INSULATED HDPE, IPS, SDR 17, 16 GA. CORRUGATED ALUMINUM JACKET, 20 FT. LENGTHS, PUSH ON COUPLING X BEVELED END.
INSULATION WASHER	NOMINAL 4 X 12 OR 6 X 12 RUBBER WASHER, 4.75" I.D. X 12" O.D. X 2" THICK (SPEC. ASTM-D-1056-85 GRADE 2A1 BLACK EPT/PE/BUTYL BLEND).
PIPE COUPLING BAND	NOMINAL 12", 16 GA. ALUMINUM, SINGLE PIECE, 3 BOLT BAND X 12" LONG.
ARCTIC LONG SWEEP 90° BEND	NOMINAL 4 X 12 OR 6 X 12 PRE-INSULATED HDPE, SDR 17, 90° LONG SWEEP (30" BEND RADIUS), 16 GA. CORRUGATED ALUMINUM JACKET, PUSH ON COUPLING X BEVELED END.
ARCTIC DRAIN HOUSING	FERNCO ADH-13, 13" DIAMETER X 29" LONG ARCTIC DRAIN HOUSING WITH 8 BOLT UPPER RING 7/16" HOLES; FERNCO INC., DAVISON, MI (800-521-1283).
GOODYEAR HOSE	GOODYEAR "HI-MILER" STR RADIATOR HOSE, P/N 57256, FLEXTEEN SAE 20 RI DI, 3.50" I.D.; 3.90" O.D. FITS INSIDE 4" HDPE, SDR 17. FOR 6" SERVICE TO THE WATER TREATMENT PLANT/WASHETERIA USE A STRAIGHT MISSION PN MR56 66 ARC REINFORCED COUPLING.
INSULATED ARCTIC BOX	INSULATED PLYWOOD ARCTIC BOX WITH HINGED LID AND REMOVABLE FRONT PANEL, FABRICATE TO CE2 ENGINEERS STANDARD DETAIL APPROXIMATE SIZE = 8 C.F.
PLUMBING	3" OR 6" ABS - DWV PIPE ASTM D1788 & D2661.
HOSE CLAMPS AND ADJUSTABLE BAND	STAINLESS STEEL, 1/2" WIDE, ADJUSTABLE.
POUR FOAM	2 COMPONENT URETHANE FOAM, 2.5 LB./C.F. DENSITY.
ELASTOMERIC COATING	APPLY 50 MILS. DURATHANE ELASTOMERIC RESIN COATING AS FURNISHED BY URETHANE CONTRACTORS SUPPLY CORP., ANCHORAGE.

1
C5.4 NTS

TYPICAL SEWER SERVICE CONNECTION TO MAIN

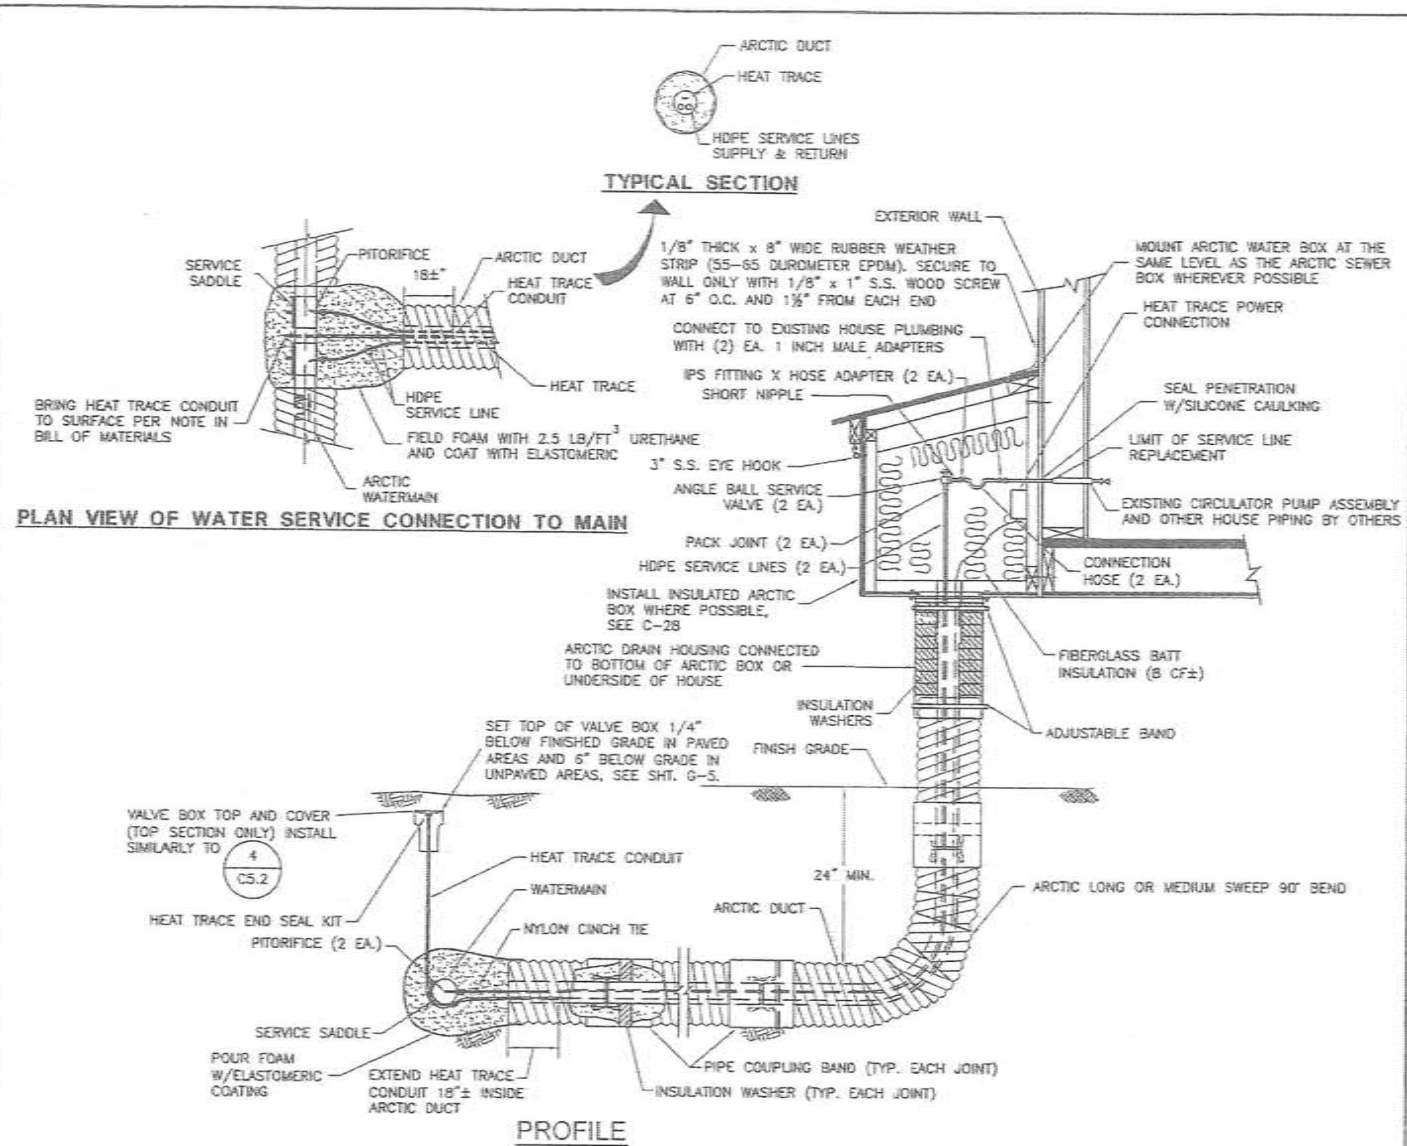

SERVICE SADDLE	ROMAC SS1-H (ACTUAL WATER MAIN ODO X LENGTH X TAP SIZE (NORMALLY 1" IP), STAINLESS STEEL, 2 BOLT (MIN.) SERVICE SADDLE. PROVIDE 4 EA. SS SPRING WASHERS PER BOLT.	ADJUSTABLE BANDS	STAINLESS STEEL, 1/2" WIDE, ADJUSTABLE.
PITOTIFICE	1" FORD PITOTIFICE CORPORATION STOP F1102-4-P WITH 1" IP THREAD X 1" PACK JOINT FOR PVC SIZE HDPE (1" SDR 11 MEETING ASTM D-3035). PROVIDE SS INSERT STIFFENER (FORD INSERT NO. 53-72 OR MUELLER NO. 504-385) AND PITOTIFICE STINGER FOR INSERTION IN 8" MAINLINE.	POUR FOAM	2 COMPONENT, 2.5 LBS/FT POLYURETHANE FOAM.
HDPE SERVICE LINE	1" HDPE (PE 3408), SDR 11, 160 PSI MIN., NSF 61 APPROVED, MEETING ID ASTM D-3035	ELASTOMERIC COATING	APPLY 50 MILS DURATHANE ELASTOMERIC RESIN COATING AS FURNISHED BY URETHANE CONTRACTORS SUPPLY CORP., ANCHORAGE (907-276-7932).
ARCTIC DUCT	NOMINAL 4" X 12" PRE-INSULATED HDPE, IPS, SDR 17, 16 GA. CORRUGATED ALUMINUM JACKET, PUSH ON COUPLING X BEVELED END.	HEAT TRACE	5 W/FT, SELF LIMITING HEAT TRACE.
INSULATION WASHER	NOMINAL 4 X 12 RUBBER WASHER, 4.75" I.D. X 12" O.D. X 2" THICK (SPEC. ASTM-D-1056-85 GRADE 2A1 BLACK EPT/PE/BUTYL BLEND).	HEAT TRACE CONNECTION KIT AND END SEAL KIT	USE MANUFACTURER'S RECOMMENDED HEAT TRACE END SEAL FOR BELOW GROUND CONDITIONS.
PIPE COUPLING BAND	NOMINAL 12", 16 GA. ALUMINUM, SINGLE PIECE, 3 BOLT BAND	HEAT TRACE CONDUIT AND TERMINATION ENCLOSURE	1" HDPE, SDR 11 CONDUIT, ROUTE FROM 18" INSIDE OF SERVICE LINE DUCT, BENEATH SERVICE SADDLE TO BOTTOM OF VALVE BOX COVER. USE 1" GALVANIZED "KING NIPPLE" W/ PIPE CAP & 1" SS HOSE CLAMP.
ARCTIC LONG SWEEP 90° BEND	NOMINAL 4" X 12" PRE-INSULATED HDPE, SDR 17, 90° LONG SWEEP (30" BEND RADIUS), 16 GA. CORRUGATED ALUMINUM JACKET, PUSH ON COUPLING X BEVELED END.	VALVE BOX AND COVER	5" I.D. X 9" LONG VALVE BOX, ADJUSTING SLEEVE AND COVER MARKED "H.T.", IFCO PN 2051 OR EQUAL.
ARCTIC DRAIN HOUSING	FERNCO ADH-13, 13" DIAMETER X 29" LONG ARCTIC DRAIN HOUSING WITH 8 BOLT UPPER RING 7/16" HOLES; FERNCO INC., DAVISON, MI (800-521-1283).	INSULATED ARCTIC BOX	INSULATED PLYWOOD ARCTIC BOX WITH HINGED LID AND REMOVABLE FRONT PANEL, FABRICATE TO CE2 STANDARD DETAIL, APPROXIMATE SIZE = 8 C.F.
PACK JOINT COMPRESSION CONNECTOR	1" PVC PACK JOINT X 1" MIP (FORD C87-44) WITH INSERT STIFFENER (FORD NO. 53-72).	RUBBER WEATHER STRIP	1/8" THICK X 8" WIDE RUBBER WEATHER STRIP (55-65 DUROMETER EPDM). SECURE TO WALL ONLY WITH 1/8" X 1" S.S. WOOD SCREW AT 6" O.C. AND 1 1/2" FROM EACH END.
ANGLE BALL SERVICE VALVE	1" FORD ANGLE BALL VALVE. BA11-344W, W/PADLOCK WINGS, 1" FIPT X FIPT.		
SHORT NIPPLE	1" DIAMETER CLOSE BRASS NIPPLE		
CONNECTION HOSE	1" I.D. NSF APPROVED POTABLE WATER HOSE X 12"± LONG (FIELD CUT TO FIT) BOTH ENDS SHALL BE FITTED W/ BRASS LONG SHANK RIBBED INSERT (DIXON BLS 848 OR EQUAL) X 1" FIPT SWIVEL FITTINGS W/ GASKETS. INSERT FITTINGS SHALL BE SECURED W/ 2 EA. STAINLESS STEEL ADJUSTABLE CLAMPS PER FITTING. ASSEMBLY SHALL BE RATED AT 150 PSI MINIMUM.		

2
C5.4 NTS

TYPICAL WATER SERVICE CONNECTION TO MAIN

RECORD DRAWING CERTIFICATE

THESE DRAWINGS REFLECT RECORDED INFORMATION OBTAINED DURING CONSTRUCTION. INFORMATION PROVIDED HEREIN IS ACCURATE TO THE BEST OF MY KNOWLEDGE.

SCALE: AS SHOWN

DATE: _____



2010-11 WASTEWATER SYSTEM IMPROVEMENTS

SEWER SERVICE LINE DETAILS

TULUKSAK, ALASKA

CE2 ENGINEERS, INC.

PO BOX 2254 ANCHORAGE, AK 99501 PH 907-345-1000 FAX 907-345-1005

REVISION	BY	DATE
1	DATE	DATE
2	DATE	DATE
3	DATE	DATE
4	DATE	DATE
5	DATE	DATE
6	DATE	DATE
7	DATE	DATE
8	DATE	DATE
9	DATE	DATE
10	DATE	DATE

Project No. _____


Date: JUNE 2009

Design: LAP

Draw: JDL




Approved: LAP

Sheet No. C5.4

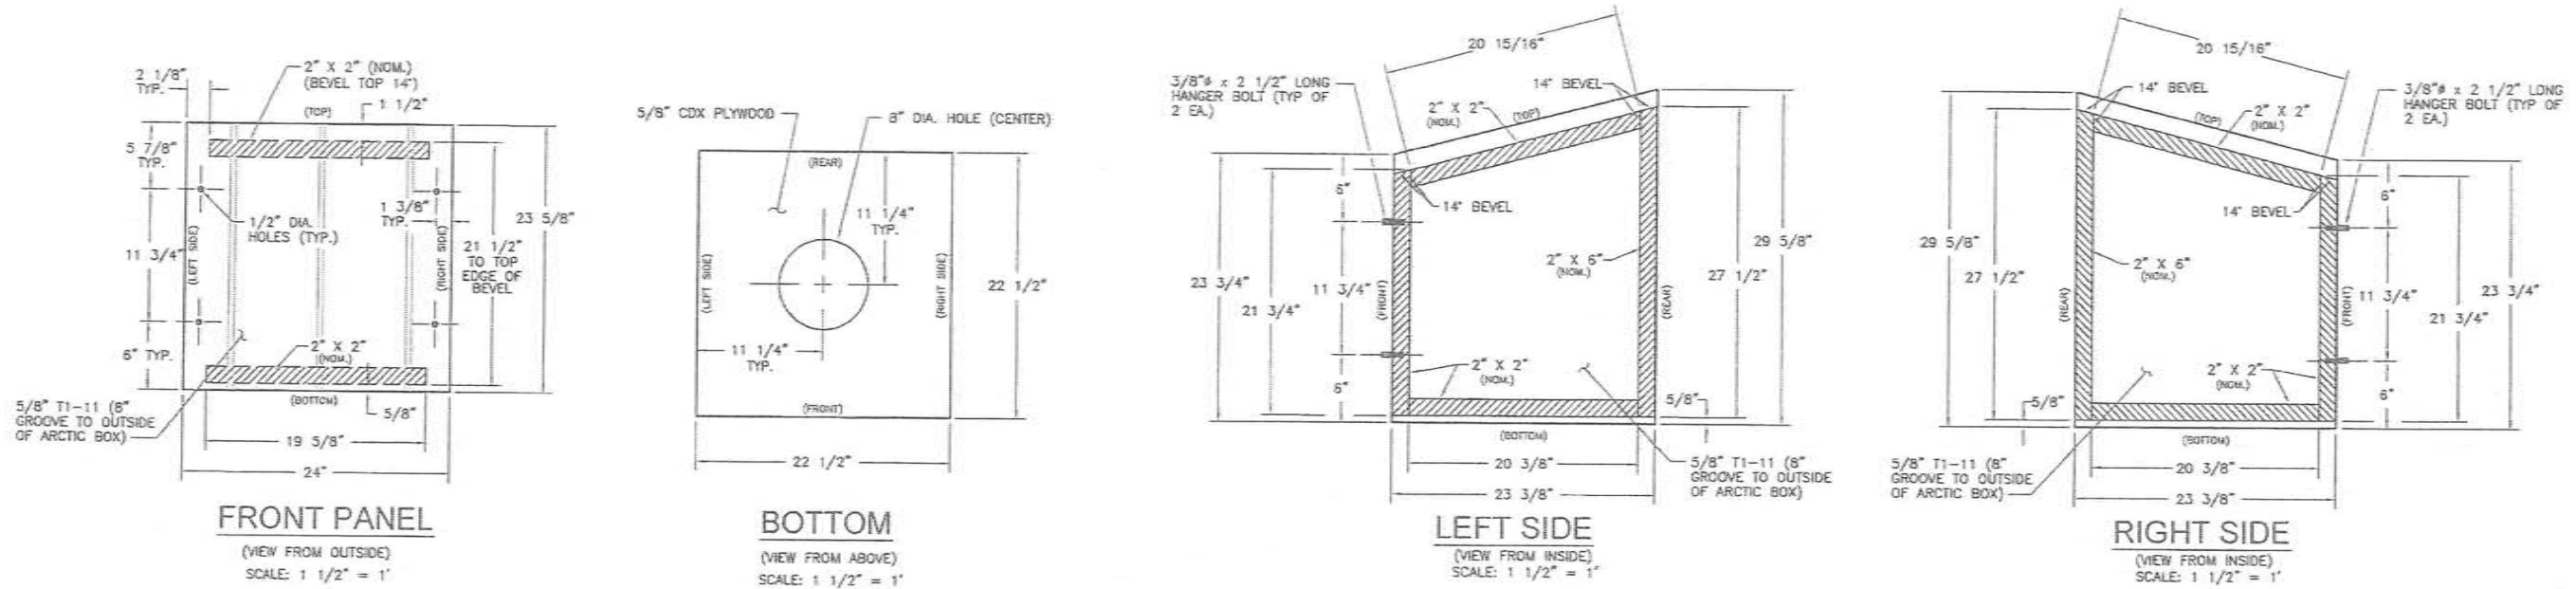

GENERAL NOTES:

1. ALL "2x" MATERIAL SHALL BE GRADE #2 OR BETTER.
2. FLAWED CONSTRUCTION MATERIAL SHALL NOT BE USED IN ARCTIC BOX CONSTRUCTION. FLAWED MATERIAL INCLUDES LARGE KNOTS, CRACKS, CHECKS, DELAMINATIONS, AND SPLITS CAUSED DURING ASSEMBLY.
3. ALL "2x" MATERIAL SHALL BE FASTENED TO PLYWOOD AND T1-11 WITH #6 X 1 5/8" DECK SCREWS OR 1 1/2" LONG 16 GA. STAPLES AT 4" O.C.

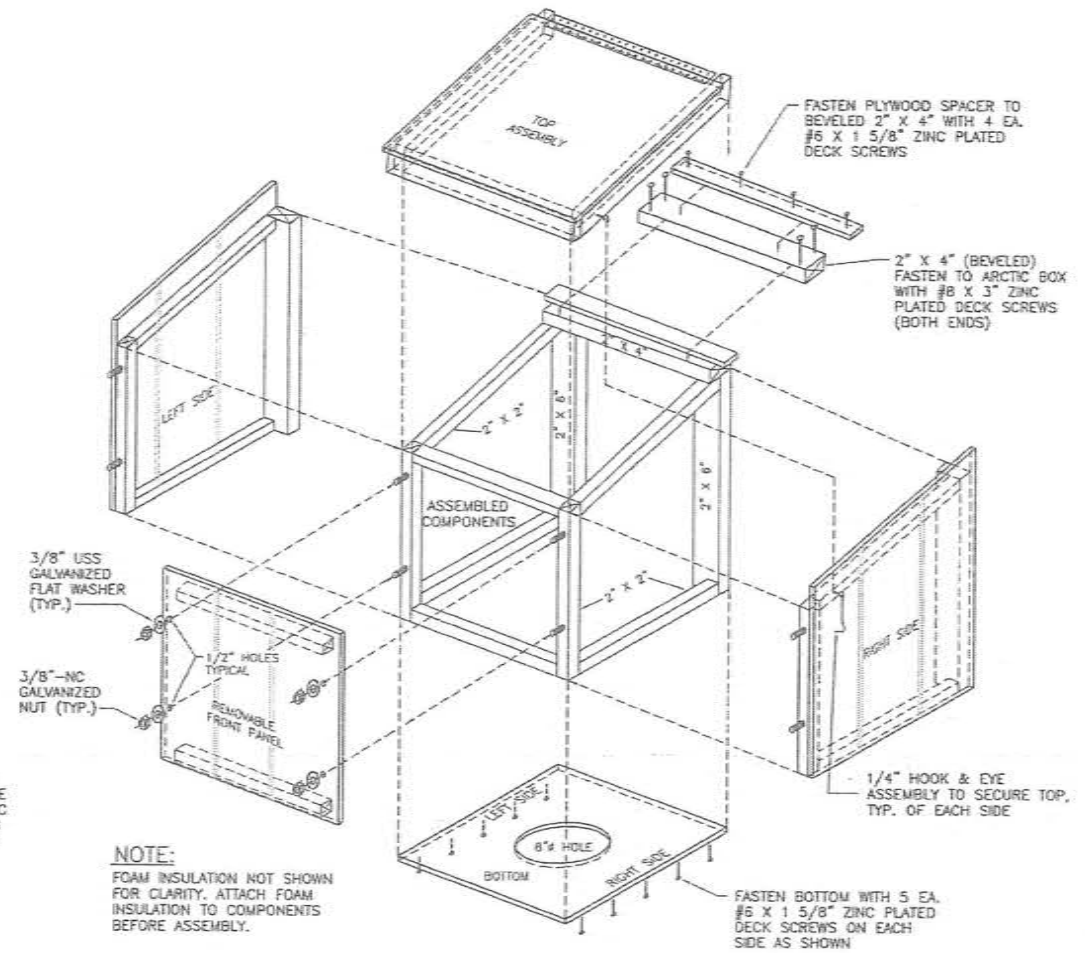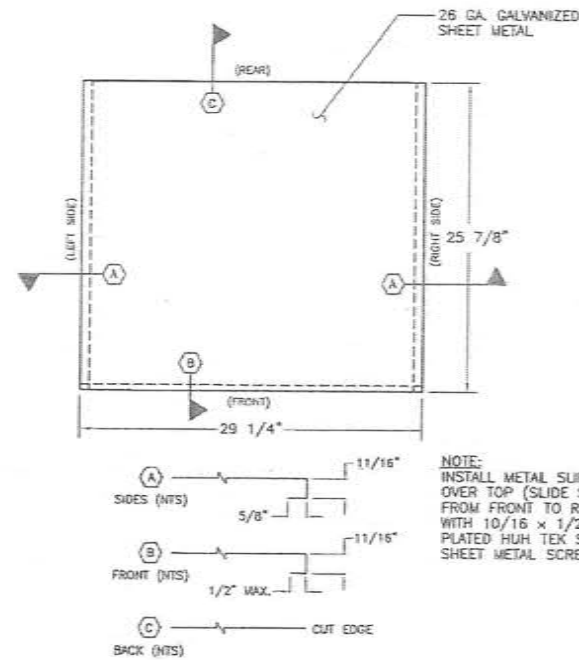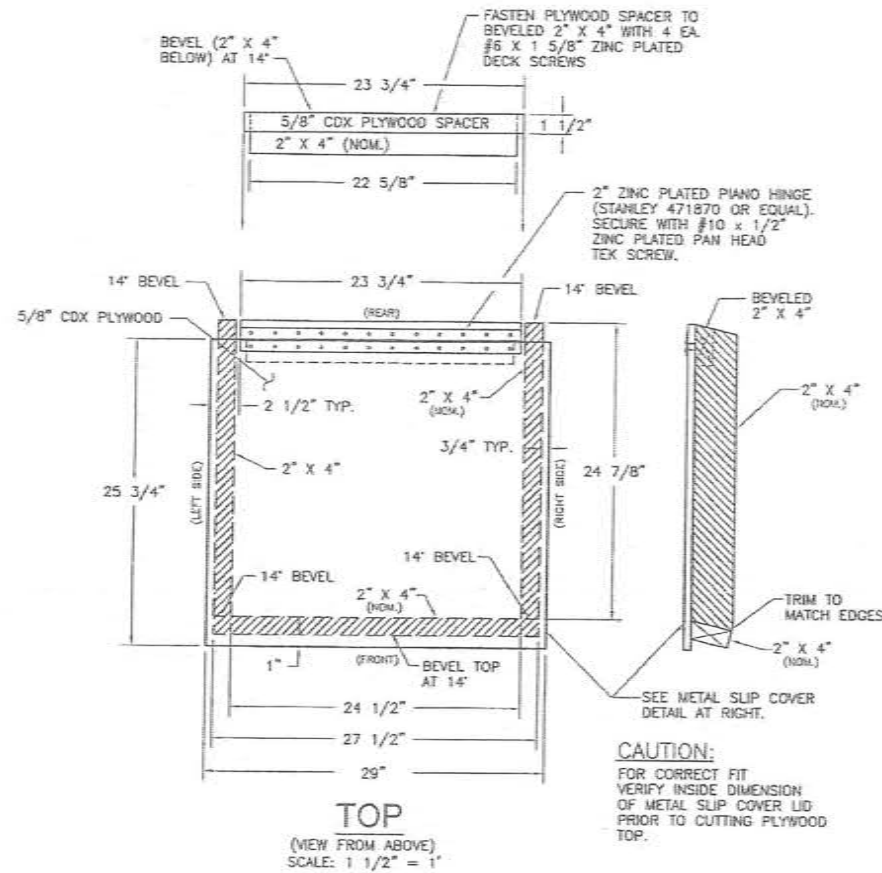

RECORD DRAWING CERTIFICATE
THESE DRAWINGS REFLECT RECORDED
INFORMATION OBTAINED DURING
CONSTRUCTION. INFORMATION PROVIDED
HEREIN IS ACCURATE TO THE BEST OF MY
KNOWLEDGE.

SCALE:
AS SHOWN



2010-11 WASTEWATER
SYSTEM IMPROVEMENTS
ARCTIC BOX DETAILS
TULUKSAK, ALASKA

CEE
ENGINEERS, INC.
PO BOX 22916 ANCHORAGE, AK 99503 TEL: 907-349-1010 FAX: 907-349-1015


REVISION	DATE	BY	DATE
LAGOON RELOCATION	LP	8/10	

Project No.	Date	Designed	Drawn	Approved
	JUNE 2009	JDL	JDL	LAP


Sheet No.
C5.5

G:\ACAD\TULUKSAK\T10901 2008 Waste water disposal area\CS.6 ARCTIC BOX DETAILS.dwg, 1/11/2011 1:31:41 PM, cmer2, LANIER MP C2050_LDS20C PCL 6.pcl


NOTE:
ALL FOAM INSULATION SHALL BE SECURELY GLUED TO THE INSIDE FACE OF THE T1-11 ARCTIC BOX WITH FOAM-PLYWOOD ADHESIVE (LIQUID NAILS LN 603) TYPICAL.

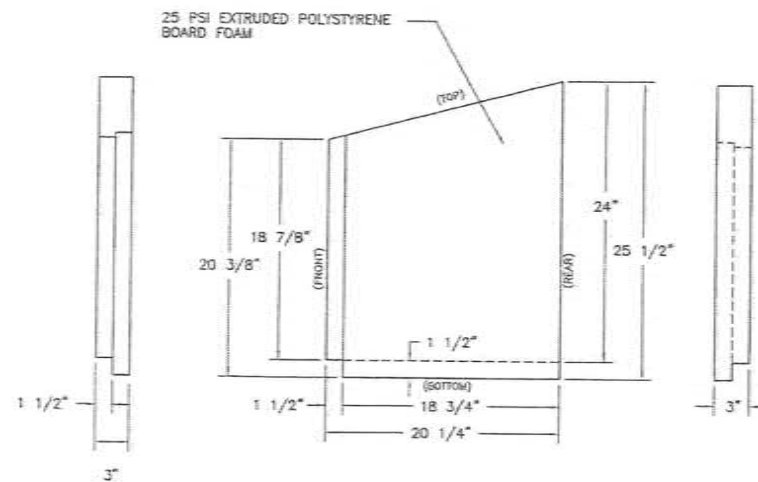


LEFT SIDE FOAM
(VIEW FROM INSIDE ARCTIC BOX)
SCALE: 1 1/2" = 1'

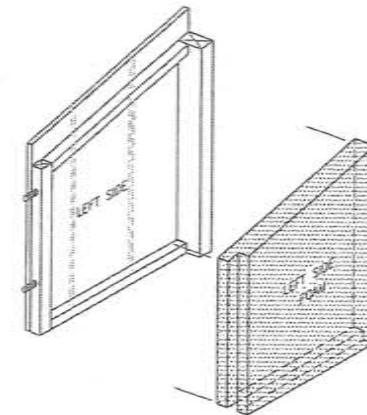


LEFT SIDE ASSEMBLY
NOT TO SCALE

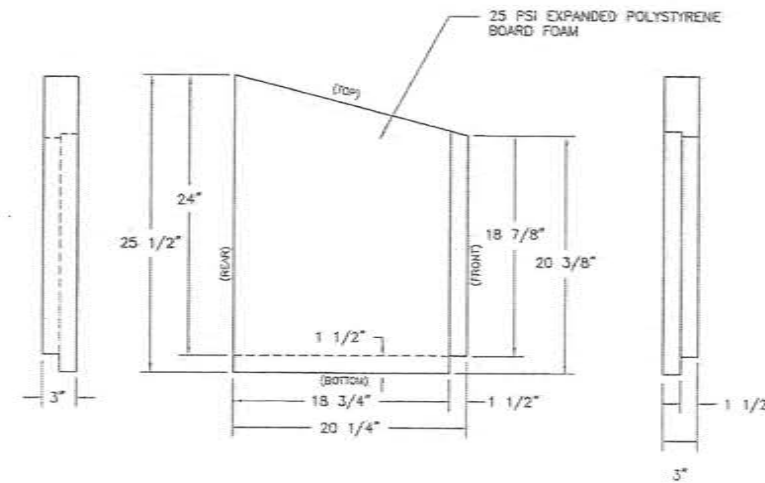


RIGHT SIDE FOAM
(VIEW FROM INSIDE ARCTIC BOX)
SCALE: 1 1/2" = 1'

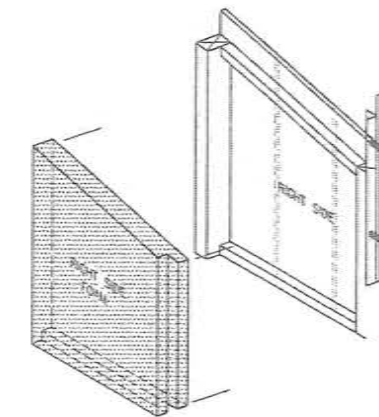


RIGHT SIDE ASSEMBLY
NOT TO SCALE

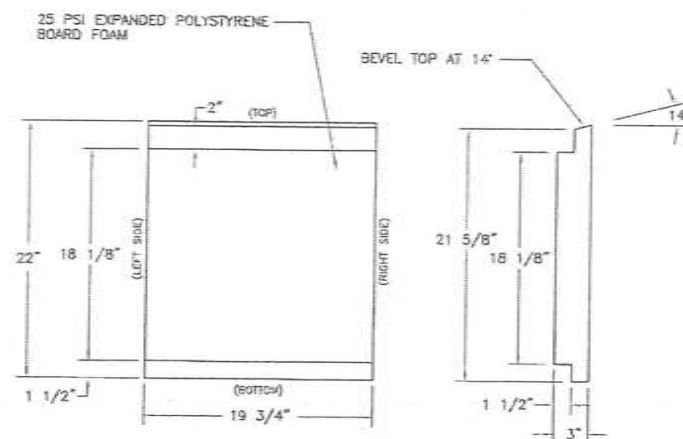


FRONT PANEL FOAM
SCALE: 1 1/2" = 1'

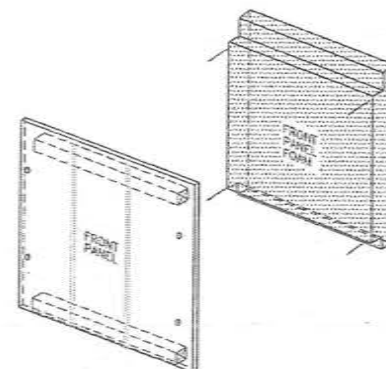

FRONT PANEL ASSEMBLY
NOT TO SCALE

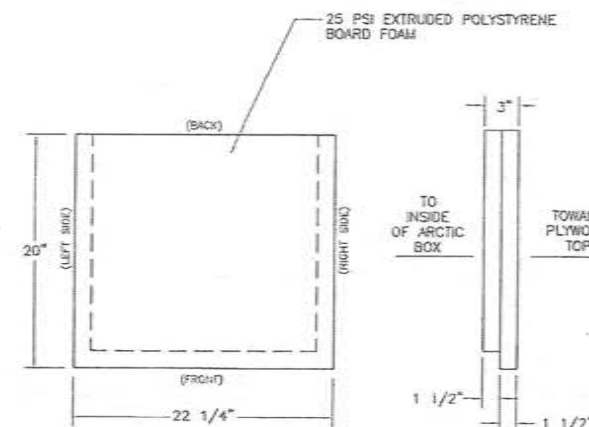

TOP FOAM
(VIEW FROM ABOVE)
SCALE: 1 1/2" = 1'

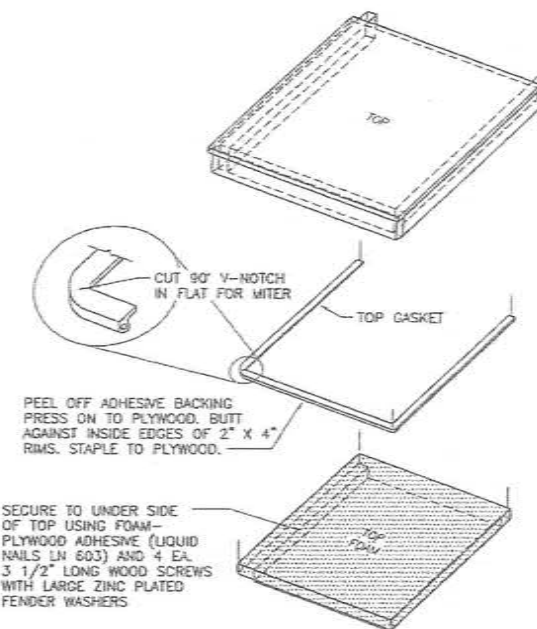

TOP ASSEMBLY
NOT TO SCALE

RECORD DRAWING CERTIFICATE
THESE DRAWINGS REFLECT RECORDED INFORMATION OBTAINED DURING CONSTRUCTION. INFORMATION PROVIDED HEREIN IS ACCURATE TO THE BEST OF MY KNOWLEDGE.
NAME _____ DATE _____

SCALE: AS SHOWN
DATE OF RECORD: 1/11/2011
SCALE: 1/2" = 1'





2010-11 WASTEWATER SYSTEM IMPROVEMENTS
ARCTIC BOX DETAILS
TULUKSAK, ALASKA

CE2
ENGINEERS, INC.
PO BOX 22046 ANCHORAGE, AK 99523 TEL 907-548-0100 FAX 907-548-1015

REVISION	DATE	BY
LAGOON RELOCATION	LP	8/10

Project No.	Date	Designed	Drawn	Approved
	JUNE 2009	JDI	JDI	Lap

Sheet No. C5.6

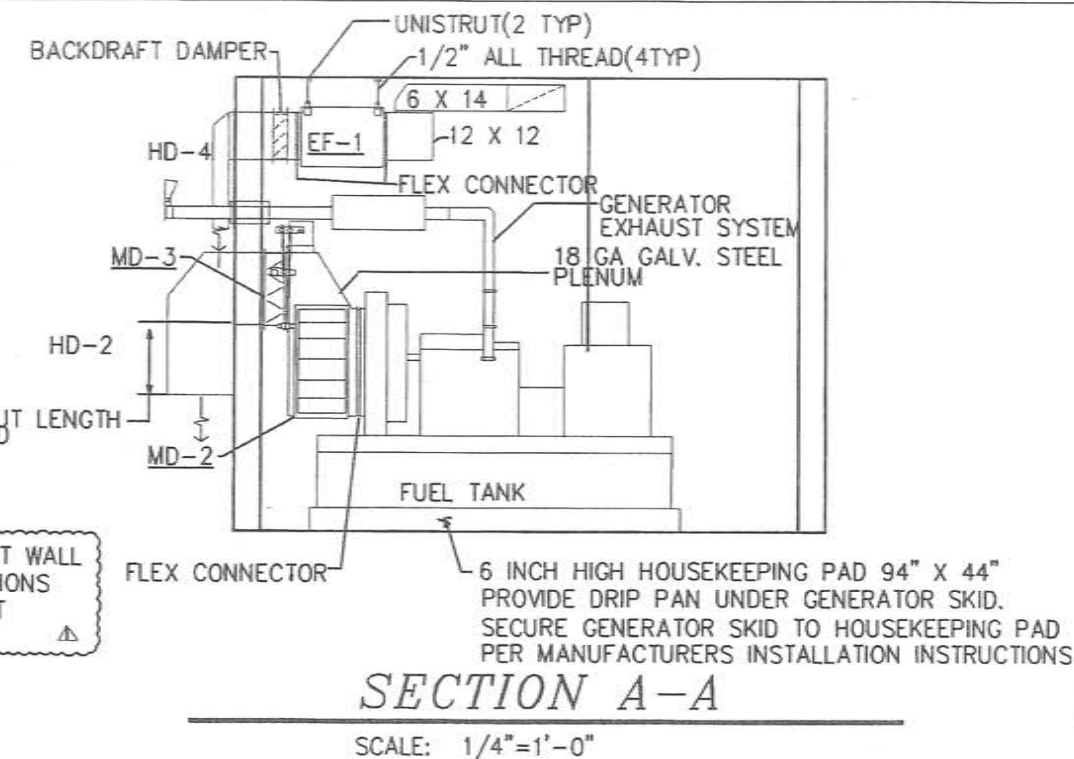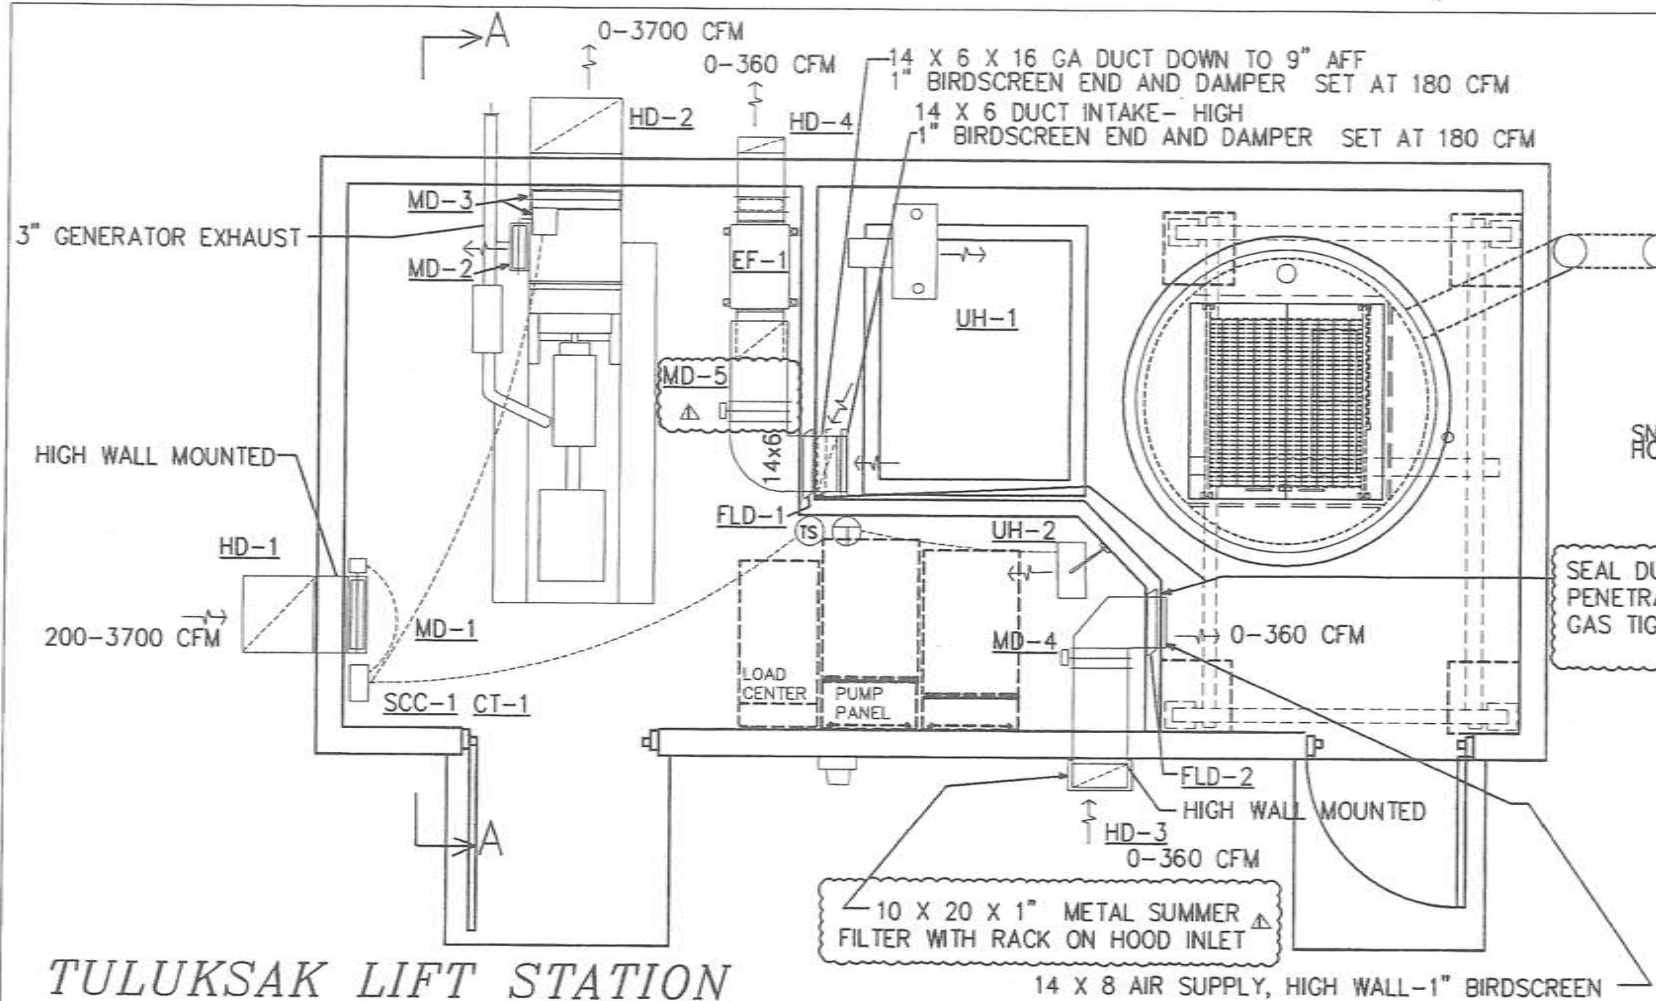

SCC-1 CONTROLLER FOR MD-1 DAMPER MOTOR, MD-2, MD-3 DAMPER MOTOR:
 2 INPUTS: START-STOP CONTROL, ANALOG ROOM TEMPERATURE
 2 OUTPUTS: RELAY CONTROL OPEN CLOSE MD-1 MODULATE 4-20 MA MD-2,3
 DAMPER CONTROL SIGNAL
 MFG: HONEYWELL T775M2006 WITH C7130B1009 ROOM SENSOR

TULUKSAK LIFT STATION

MD-1 MOTORIZED DAMPER 24 WIDE X 16 HIGH. LOW LEAKAGE, 3 POSITION DAMPER SCALE: 1/4"=1'-0"
 MFG: RUSKIN CD-50 DAMPER WITH BELIMO AF24 W/ZDB-AF2 SPRING RETURN ACTUATOR 24 VAC 5 VA
 SUMMER FILTER: 16 X 25 X 1 AAF 316-001-600 OR EQUAL
 MD-2 MOTORIZED DAMPER 12" WIDE X 26" HIGH. LOW LEAKAGE, VARIABLE POSITION DAMPER
 MFG: DAMPER: RUSKIN CD-50 WITH COMMON OPERATOR WITH MD-3
 MD-3 MOTORIZED DAMPER 24" WIDE X 18" HIGH. LOW LEAKAGE, VARIABLE POSITION DAMPER
 MFG: RUSKIN CD-50 DAMPER WITH HONEYWELL M9185E MOTOR W/4074 EDC MODULE 24 VAC 24 VA
 PROVIDE CRANK ARMS, RODS, AND FITTINGS TO EFFECT 2 DAMPER CONTROL
 MD-4 MOTORIZED DAMPER 14" WIDE X 8" HIGH. LOW LEAKAGE, TWO POSITION DAMPER
 MFG: RUSKIN CD-50 DAMPER WITH BELIMO AF24 W/ZDB-AF2 SPRING RETURN ACTUATOR 24 VAC 5 VA
 MD-5 MOTORIZED DAMPER 14" WIDE X 6" HIGH. LOW LEAKAGE, TWO POSITION DAMPER
 MFG: RUSKIN CD-50 DAMPER WITH BELIMO AF24 W/ZDB-AF2 SPRING RETURN ACTUATOR 24 VAC 5 VA
 SUMMER FILTER: 10 X 20 X 1 AAF 316-001-200 OR EQUAL

HD-1 INTAKE HOOD: 24" WIDE X 18" DEEP WITH 36 INCH SNOUT. 16 GA. GALVANIZED STEEL, 1" BIRDSCREEN, SEE DETAIL SHEET M1-2
 HD-2 EXHAUST HOOD: 24" WIDE X 16" DEEP WITH 9 INCH SNOUT. 16 GA. GALVANIZED STEEL, 1" BIRDSCREEN, SEE DETAIL SHEET M1-2
 HD-3 INTAKE HOOD: 14" WIDE X 8" DEEP WITH 18 INCH SNOUT. 16 GA. GALVANIZED STEEL, 1" BIRDSCREEN, SEE DETAIL SHEET M1-2
 FLARE INTAKE OF HD-3 FOR 10x20 METAL FILTER w/ RACK FOR SUMMER FILTER
 HD-4 EXHAUST HOOD: 12" WIDE X 5" DEEP WITH 16 INCH SNOUT. 16 GA. GALVANIZED STEEL, 1" BIRDSCREEN, SEE DETAIL SHEET M1-2
 FLD-1 DYNAMIC FIRE DAMPER 14 X 6 MFG: RUSKIN DIBD2 OR EQUAL
 FLD-2 DYNAMIC FIRE DAMPER 14 X 8 MFG: RUSKIN DIBD2 OR EQUAL

SEQUENCE OF OPERATION: LIFT STATION AREA

EF-1, MD-4, MD-5 OPERATION: EF-1, MD-4, MD-5 ARE INTERLOCKED. WHEN WALL SWITCH OUTSIDE LIFT STATION DOOR IS SET TO "ON" EF-1 STARTS, MD-4 OPENS, MD-5 OPENS TO FULL OPEN. SWITCH ACTIVATES FLASHING RED LIGHT (LABELED "UNSAFE TO ENTER"). LIGHT IS ON FOR 5 MINUTES TO PURGE AREA AND AT THE END OF THE 5 MINUTE TIME A GREEN LIGHT (LABELED "MONITOR WET WELL ROOM WITH COMBUSTIBLE GAS DETECTOR PRIOR TO ENTRY"). WHEN OPERATOR LEAVES WORK AREA THE SWITCH IS SET TO "OFF" AND EF-1 STOPS & MD-5, MD-5 DAMPERS CLOSE.

CT-1 CONTROL TRANSFORMER: 120 V PRIMARY/ 24 VAC SECONDARY 60 VA MFG: HONEYWELL OR EQUAL
 EF-1 EXHAUST FAN: INLINE TYPE, BELT DRIVE. 360 CFM@ 0.4 INCHES W.C., ALUMINUM HOUSING AND WHEEL STAINLESS STEEL FASTENERS, PERMATECTOR COATING, TOGGLE SWITCH, DUAL DRIVES, GRIP NOTCH BELTS SPRING HANGER ISOLATORS, GREASABLE BEARINGS WITH EXTENDED LUBE LINES, TEFC MOTOR, BACKDRAFT DAMPER, MOTOR COVER. MFG: GREENHECK BSQ 90-4 1/4 HP/115V/1 PH OR APPROVED EQUAL

GENERATOR: NOMINAL 40 KW 208/3 PH/60 HZ SEE ELECTRICAL FOR CONFIG: MFG: KOHLER 40RE0ZJC (VERIFY) WIDE SKID CONFIG, DIESEL ENGINE, 1530 LB, 113 GALLON INTEGRAL SKID FUEL TANK (14 HIGH X 90.5 L X 41 WIDE, GENERATOR EXHAUST: 355 CFM, GENERATOR RADIATOR AIR 3400 CFM, COMBUSTION AIR-130 CFM

GENERATOR EXHAUST SYSTEM:

PROVIDE 3 INCH STAINLESS STEEL EXHAUST SYSTEM WITH PIPE, FLEX CONNECTOR, WALL THIMBLE FOR WOOD FRAME WALL, CLAMPS, FITTINGS, FASTENERS, HANGERS, RESIDENTIAL MUFFLER, FLAPPER, WRAP EXHAUST WITH APPROVED BLANKET INSULATION. 3M 615-(1 WRAP) OR EQUAL

HOUSEKEEPING PAD: PROVIDE CONCRETE PAD AND DRIP PAN UNDER SKID.

UH-1: UNIT HEATER. 10 KW, 208 V, 3 PH. HANGING UNIT HEATER WITH PROPELLOR FAN EXPLOSION PROOF UNIT WITH BUILT IN SPACE THERMOSTAT. PROVIDE CEILING MOUNTING KIT MFG: Q MARK GUX1000832 WITH SPACE T STAT. 29.2 AMPS, 840 CFM

UH-2: UNIT HEATER. 3 KW, 208/240 V, 1 PH. HANGING UNIT HEATER WITH PROPELLOR FAN PROVIDE WALL MOUNTING KIT, AND LOW VOLTAGE WALL THERMOSTAT. MFG: Q MARK MUH 0321 11/12.5 AMPS, 350 CFM

SEQUENCE OF OPERATION: GENERATOR OPERATION

MD-1, MD-2, MD-3 OPERATION: OFF POSITION: MD-1 IS CLOSED, MD-2 IS FULL OPEN, MD-3 IS FULL CLOSED. GENERATOR IS STARTED: MD-1 OPENS, MD-2 BYPASSES AIR TO ROOM AND BEGINS TO MODULATE CLOSED WHILE MD-3 BEGINS TO OPEN. DAMPER MOTOR MODULATES TO ALLOW GENERATOR RADIATOR AIR TO HEAT ROOM ROOM SET POINT: 75 F. ON GENERATOR SHUT DOWN SYSTEM RETURNS TO OFF POSITION


SEQUENCE OF OPERATION: UNIT HEATERS UH-1, UH-2

UH-1 CYCLES ON BUILT IN THERMOSTAT: SET 50 F
 UH-2 CYCLES ON ROOM THERMOSTAT: SET 55 F

03-23-2011 REVISE DUCT WORK, MD-4, SEQUENCE OF OPERATION

CAPSTONE ENGINEERING LLC
MECHANICAL ENGINEERS

12110 BUSINESS BLVD. STE. 600
EAGLE RIVER, ALASKA 99577
TELEPHONE & FAX 907-884-8063

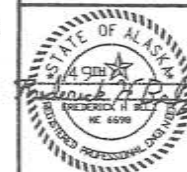

JAN 10, 2011


MECHANICAL DETAILS AND INSERTS
TULUKSAK LIFT STATION
TULAKSAK, ALASKA

DATE: JAN 10, 2011
 DRAWN: F.H. BELTZ
 CHECKED: AS NOTED
 SCALE: AS NOTED
 REVISED: MARCH 23, 2011
 JOB NO.: C378

SHEET NO. 1 OF 3
 M1-1

G:\CAD\TULUKSAK\T0901 2008 Waste water disposal area\PC Rev Jan 2011\T1-2 Mechanical Fred Beltz.dwg, 10/14/2011 4:37:10 PM, cmerz, \\C02mail\LANIER HP C2050\LD520C PCL 6


EQUIPMENT LIST HYDRONIC HEAT TRACE PIPING FOR SEWAGE FORCE MAIN	
AAV	AUTOMATIC AIR VENT, 2" FIPT CONNECTIONS, SPIROVENT JUNIOR MODEL 200TM
CP-1A, CP-1B	2-STAGE CENTRIFUGAL CIRCULATING PUMP, TYPE 304 STAINLESS STEEL CONSTRUCTION, 0.5 HP TEFC 3450 RPM MOTOR, 208-230/460 VOLT 3-PHASE, GRUNDFOS 1SVB1C9B0
CV-1	THREE WAY CONTROL VALVE, 1-1/4" FIPT, CV 18.7, B TO AB PORT OPEN ON STEM RISE. HONEYWELL V5013N1071 WITH ML7424B3012 SPRING DIRECT COUPLED GLOBE VALVE ACTUATOR (PULLS STEM UP TO FULL BYPASS ON POWER FAILURE.
ET-1A, ET-1B	THERMAL EXPANSION TANKS, VERTICAL WITH STAND, BLADDER TYPE, ASME SECTION VIII, DIV 1 CONSTRUCTION, MAX ACCEPTANCE VOLUME 34.0 GALLONS, 1" FIPT BOTTOM CONNECTION, AMTROL AX-200(V).
GT-1	GLYCOL SOLUTION MIXING TANK, 100 GAL CAPACITY, WITH INTEGRAL PUMP AND PRESSURE REGULATOR, AXIOM SF100-L
PG-1	PROCESS PRESSURE GAUGE, SILICONE FILLED CASE, POCAN CASE, 1/2" MIPT BOTTOM PORT, 0-60 PSIG, WIKA TYPE 213.34, PART # 9834354
RV-1	PRESSURE RELIEF VALVE, 3/4" x 3/4" FIPT, SET 30 PSIG, RATED 650,000 BTU/HR RELIEF, BRONZE BODY CONSTRUCTION, NONMETALLIC DISC TO METAL SEATING.
ST-1	WYE-TYPE STRAINER, 2" BRONZE SWEAT TYPE, 20 MESH SS SCREEN, METRAFLEX STYLE BSJC 2" OR EQUAL
TC-1	ELECTRONIC STAND-ALONE TEMPERATURE CONTROLLER, WITH REMOTE RESISTANCE SENSOR, NEMA 4X ENCLOSURE, 120 VAC OR 24 VAC POWER INPUT, 2-10 VDC, 0-10 VDC, 4-20 MA DC OUTPUT, HONEYWELL T775M2022 WITH INCLUDED SENSOR, C7031D2003 5 IN IMMERSION SENSOR WITH WELL.
TE-1	PART OF TC-1 ASSEMBLY (C7031D2003 5 IN IMMERSION SENSOR WITH WELL).

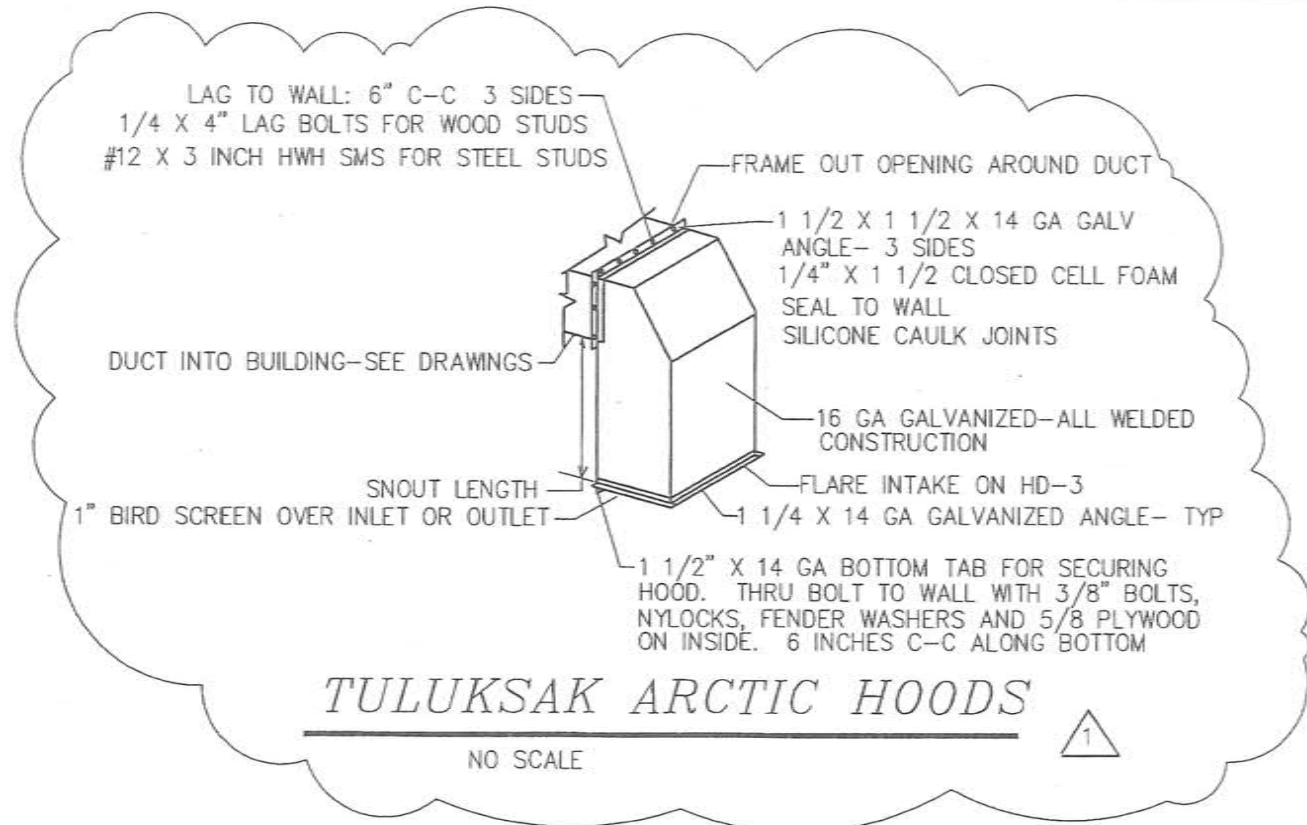

CAPSTONE ENGINEERING LLC
MECHANICAL ENGINEERS
1210 BUSINESS BLVD STE 6 PMB 169
EAGLE RIVER, ALASKA 99577
TELEPHONE & FAX 541-884-8065



MECHANICAL DETAILS AND INSERTS
TULUKSAK LIFT STATION
TULAKSAK, ALASKA

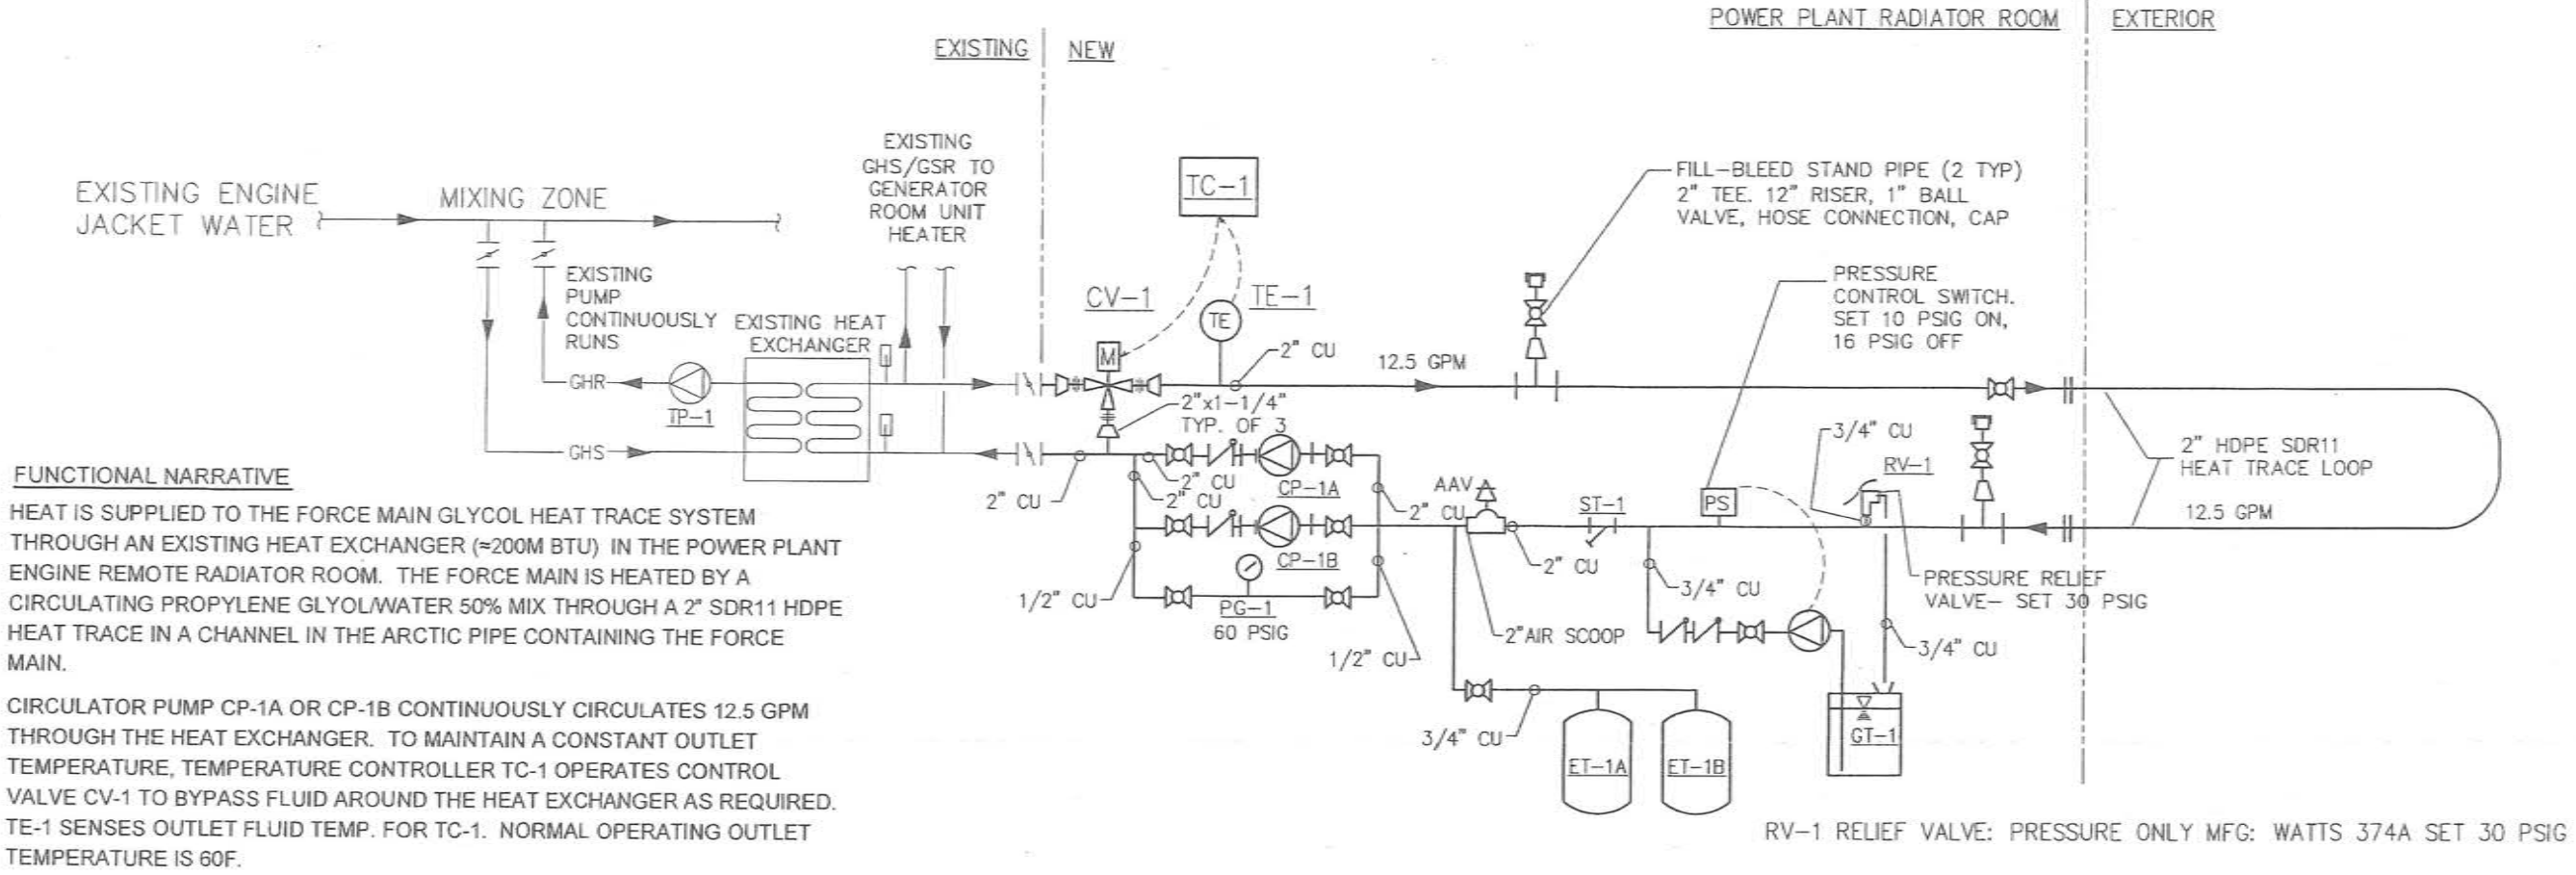

FUNCTIONAL NARRATIVE

HEAT IS SUPPLIED TO THE FORCE MAIN GLYCOL HEAT TRACE SYSTEM THROUGH AN EXISTING HEAT EXCHANGER (≈200M BTU) IN THE POWER PLANT ENGINE REMOTE RADIATOR ROOM. THE FORCE MAIN IS HEATED BY A CIRCULATING PROPYLENE GLYCOL/WATER 50% MIX THROUGH A 2" SDR11 HDPE HEAT TRACE IN A CHANNEL IN THE ARCTIC PIPE CONTAINING THE FORCE MAIN.

CIRCULATOR PUMP CP-1A OR CP-1B CONTINUOUSLY CIRCULATES 12.5 GPM THROUGH THE HEAT EXCHANGER. TO MAINTAIN A CONSTANT OUTLET TEMPERATURE, TEMPERATURE CONTROLLER TC-1 OPERATES CONTROL VALVE CV-1 TO BYPASS FLUID AROUND THE HEAT EXCHANGER AS REQUIRED. TE-1 SENSES OUTLET FLUID TEMP. FOR TC-1. NORMAL OPERATING OUTLET TEMPERATURE IS 60F.

PRESSURE RELIEF VALVE RV-1 PROTECTS THE SYSTEM FROM OVER PRESSURE, AND IS SET AT 30 PSIG. GLYCOL TANK GT-1 SERVES AS A MAKE-UP UNIT FOR GLYCOL MIX REPLACEMENT IN THE HEAT TRACE LOOP. EXPANSION TANKS ET-1A AND ET-1B SERVE TO ALLOW ROOM FOR EXPANSION OF HEAT TRANSFER FLUID OVER THE EXPECTED RANGE OF TEMPERATURE OF THE SYSTEM.

TULUKSAK HYDRONIC PIPING HEAT TRACE PIPING SCHEMATIC


NO SCALE

03-23-2011 REVISE HOOD DETAIL

DATE:	JAN 10, 2011
DRAWN:	FM BELZ
CHECK:	AS NOTED
SCALE:	AS NOTED
REVISED:	
JOB NO.	C378
SHEET NO.	2 OF 3
M1-2	

BACK-UP GLYCOL HEAT TRACE NOTES:

1. THE BACK-UP HEAT TRACE SYSTEM IS DESIGNED TO MAINTAIN FORCEMAIN TEMPERATURE IN THE EVENT THAT THE TEMPERATURE OF THE WASTEWATER IS INADEQUATE TO PREVENT FREEZING
2. HEAT TRANSFER FLUID WILL BE A 50/50 INHIBITED PROPYLENE GLYCOL / WATER MIX, WHICH WILL ALLOW FLUID FLOW TO -30°F AND FREEZE PROTECTION OF THE GLYCOL TO -60°F.

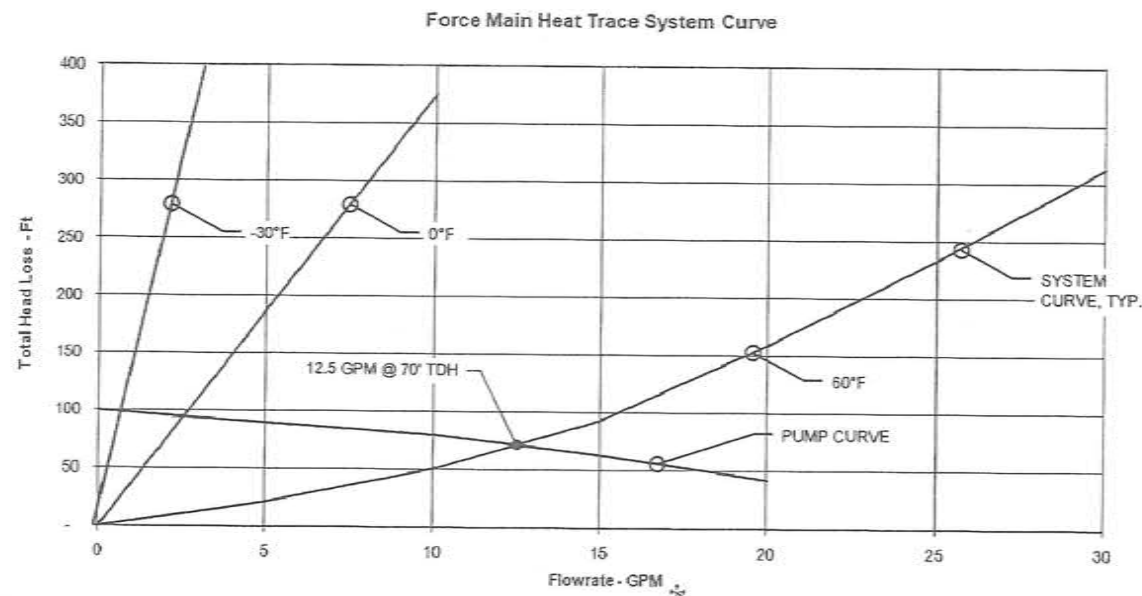


FORCEMAIN BACKUP HEAT TRACE SYSTEM CURVE

BACKUP GLYCOL HEAT TRACE FOR FORCEMAIN SYSTEM
EQUIVALENT LOOP LENGTH WITH FITTINGS: 7,600 LF
PIPE: 2" SDR 11 HDPE
PUMP: G&L #1SVC-2 STAGE VERTICAL SS CENTRIFUGAL
MODEL# 1SVB1C9B0
TAG# CP-1A AND 1B


TOTAL FORCEMAIN HEAT DEMAND = 21,600 Btu/Hr

1 GLYCOL CIRC. PUMP CURVE
M1-3 NTS

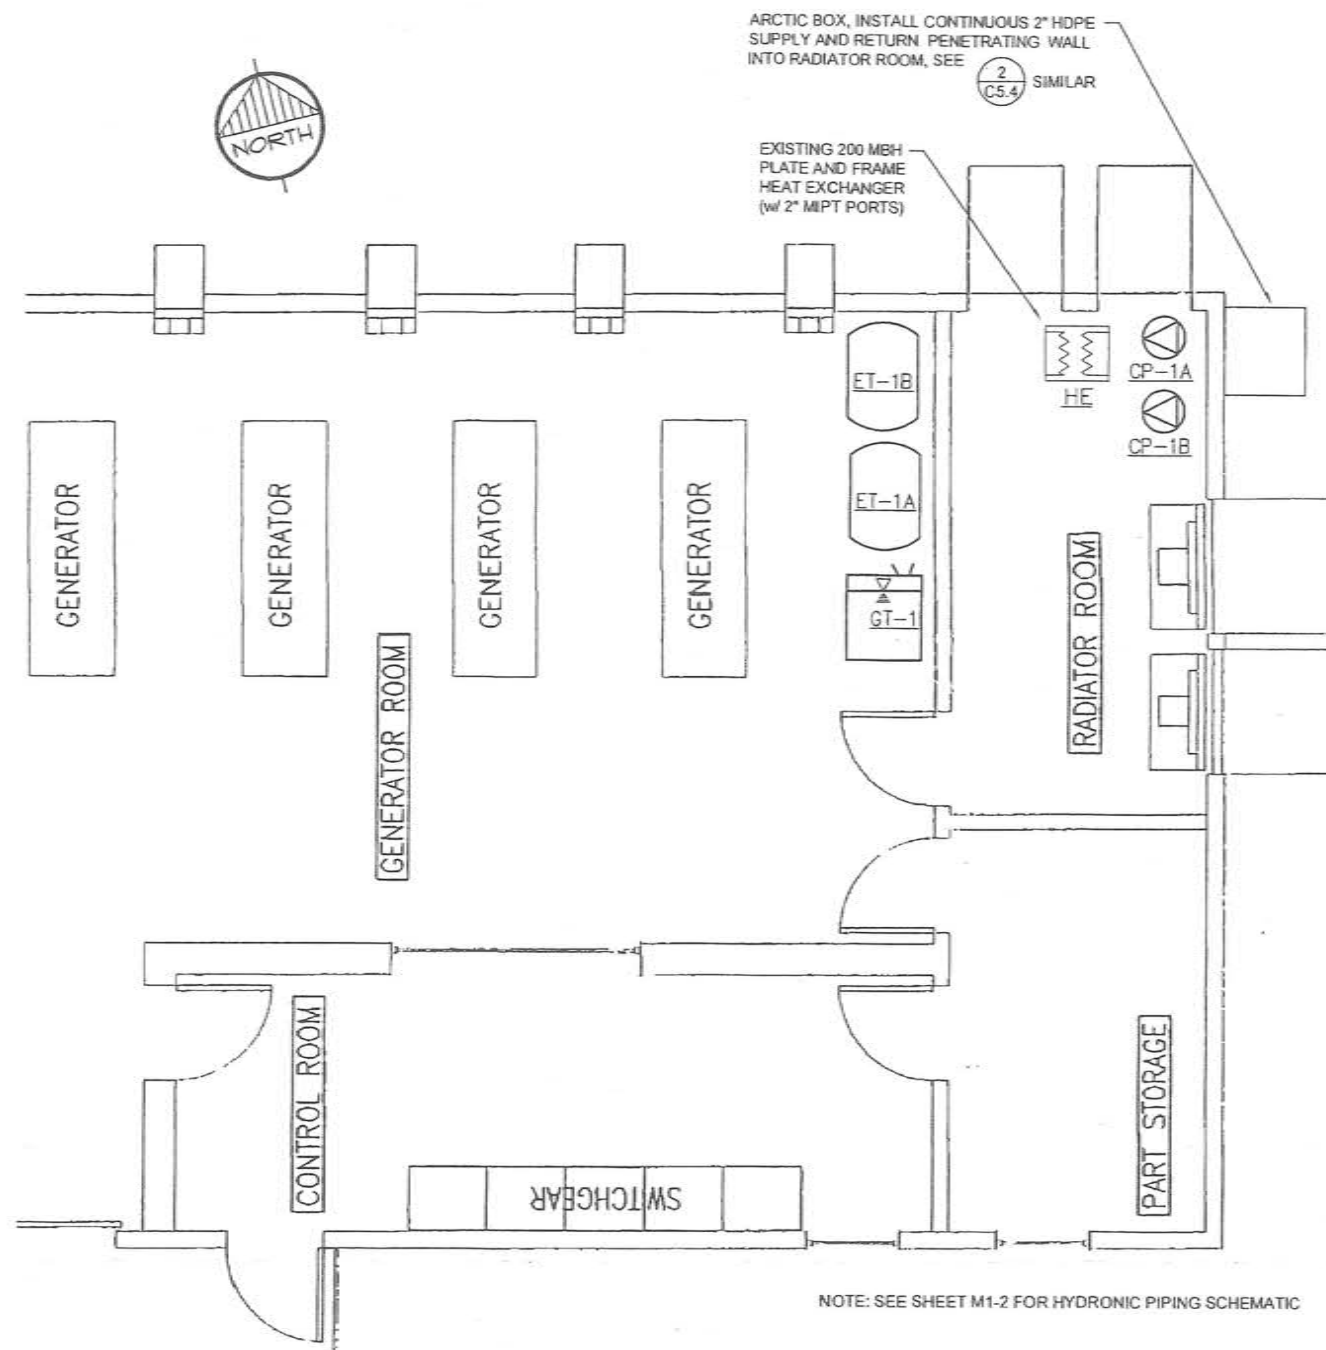

2 POWER PLANT MECH. PLAN
M1-3 NTS

CAPSTONE ENGINEERING LLC
MECHANICAL ENGINEERS
12110 BUSINESS BLVD. STE 6, PHB 169
EAGLE RIVER, ALASKA 99577
TELEPHONE & FAX 941-884-8065

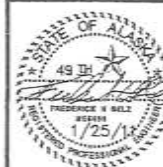

MECHANICAL DETAILS AND INSERTS
TULAKSAK LIFT STATION
TULAKSAK, ALASKA

DATE: JAN 10, 2011
DRAWN: F.M. BELZ
CHKD: AS NOTED
SCALE: AS NOTED
REVISED:
JOB NO. C378
SHEET NO. 3 OF 3
M1-3

ELECTRICAL LEGEND

(NOTE: THIS IS A STANDARD LEGEND AND NOT ALL SYMBOLS ARE NECESSARILY USED.)

	EXTERIOR LIGHT FIXTURE, POLE MOUNTED, HEADS AS SHOWN
	HAND HOLE
	ELECTRIC VAULT
	PHOTOCELL CONTROL
	LUMINAIRE - TYPE AS NOTED ON PLAN
	LUMINAIRE - WALL MOUNTED, TYPE AS NOTED ON PLAN
	LUMINAIRE - EMERGENCY LIGHT
	TRACK LIGHTING - TRACK LENGTH AS SCALED, TYPE AS NOTED ON PLAN
	EMERGENCY LIGHTING UNIT (WALL, CEILING, REMOTE HEAD), TYPE "E", UON
	EMERGENCY BATTERY TO POWER REMOTE HEAD(S), TYPE "EBS", UON
	EXIT SIGN (CEILING, WALL), SHADE DENOTES FACE, ARROWS AS INDICATED, TYPE "X", UON
	SWITCH - SINGLE POLE, SINGLE THROW, UON
	SWITCH - THREE WAY
	SWITCH - FOUR WAY
	SWITCH CONTROL FOR FIXTURES DENOTED WITH "S" APPENDED TO CIRCUIT NUMBER
	SWITCH - LOW VOLTAGE
	SWITCH - ELECTRONIC DIMMER SWITCH COMPATIBLE WITH LIGHT FIXTURE
	SWITCH - KEYED
	SWITCH - PILOT LIGHT
	SWITCH - INTEGRAL MOTOR OVERLOAD
	SWITCH - VARIABLE SPEED CONTROL
	LIGHT CONTROL OCCUPANCY SENSOR - WALL SWITCH BOX MOUNTED
	LIGHT CONTROL OCCUPANCY SENSOR - CEILING MOUNTED
	POWER DISTRIBUTION PANELBOARD
	METERING DEVICE
	CURRENT TRANSFORMER ENCLOSURE
	POWER PANELBOARD (NEW - SURFACE, RECESSED), (EXISTING - SURFACE, RECESSED)
	TRANSFORMER, APPROX. PHYSICAL SIZE AS SCALED, ACTUAL RATING AS NOTED ON ONE-LINE DIAGRAMS
	MOTOR CONNECTION
	COMBINATION BATHROOM FAN/LIGHT, TYPE AS NOTED ON PLAN
	NON-FUSED SAFETY SWITCH
	FUSED SAFETY SWITCH
	ENCLOSED CIRCUIT BREAKER SWITCH
	MOTOR STARTER
	COMBINATION MOTOR STARTER SAFETY SWITCH
	PUSH BUTTON CONTROL STATION
	JUNCTION BOX OR EQUIPMENT CONNECTION - FLEX OR RECEPTACLE AS REQUIRED (CEILING, WALL, FLOOR)
	POWER CONNECTION TO FSD CONTROLLED BY FIRE ALARM SYSTEM
	SIMPLEX RECEPTACLE
	DUPLEX RECEPTACLE
	DOUBLE DUPLEX RECEPTACLE
	DUPLEX RECEPTACLE - SPLIT WIRED FOR SWITCH CONTROL OF LOWER OUTLET
	DUPLEX RECEPTACLE - GFCI PROTECTED
	DUPLEX RECEPTACLE - GFCI PROTECTED MOUNTED +48" AFF
	DUPLEX RECEPTACLE - GFCI PROTECTED MOUNTED ABOVE COUNTERTOP
	DUPLEX RECEPTACLE - MOUNTED ABOVE COUNTERTOP
	DUPLEX RECEPTACLE - FLOOR MOUNTED FIRE RATED POKE THROUGH, UON
	DOUBLE DUPLEX RECEPTACLE - FLOOR MOUNTED FIRE RATED POKE THROUGH, UON
	RECEPTACLE - PENDANT MOUNTED FROM CEILING
	RECEPTACLE - FLUSH MOUNTED IN CEILING
	DRYER RECEPTACLE - 30A, 3 POLE, 4 WIRE, NEMA 14-30R
	ELECTRIC RANGE RECEPTACLE - 50A, 3 POLE, 4 WIRE, NEMA 14-50R
	SPECIAL PURPOSE RECEPTACLE - NEMA CONFIGURATION AS NOTED (SURFACE, WALL)
	GROUND CONNECTION POINT
	DUAL CHANNEL SURFACE MOUNTED RACEWAY - LENGTH AS SCALED
	SINGLE CHANNEL SURFACE MOUNTED RACEWAY - LENGTH AS SCALED
	TELECOMMUNICATION OUTLET (WALL, FLOOR)
	TELEPHONE OUTLET
	TELEVISION OUTLET (WALL, CEILING)
	DUAL CHANNEL SERVICE POLE
	TELECOMMUNICATION FLOOR STANDING RACK
	TELECOMMUNICATION WALL MOUNTED RACK
	TELECOMMUNICATION MAIN GROUNDING BUS
	TELECOMMUNICATION GROUNDING BUS
	CONTROL PANEL - TYPE AS NOTED (SURFACE, RECESSED)

	FIRE ALARM CONTROLLED MAGNETIC DOOR HOLDER / RELEASE
	ABORT STATION
	CARBON MONOXIDE DETECTOR
	HEAT DETECTOR - RATE OF RISE
	HEAT DETECTOR - FIXED TEMPERATURE AS NOTED
	SMOKE DETECTOR - PHOTOELECTRIC TYPE
	SMOKE DETECTOR - MULTI-SENSOR TECHNOLOGY TYPE
	SMOKE DETECTOR - DUCT MOUNTED
	SMOKE DETECTOR - BEAM RECEIVER
	SMOKE DETECTOR - BEAM TRANSMITTER
	FLAME DETECTOR
	LINE TYPE HEAT SENSITIVE CABLE DETECTOR
	FIRE ALARM HORN
	FIRE ALARM STROBE
	FIRE ALARM COMBINATION HORN/STROBE
	FIRE ALARM PULL STATION
	FIRE ALARM CONTROL PANEL
	FIRE SYSTEM ANNUNCIATOR PANEL
	HALON CONTROL PANEL
	FIRE ALARM SPEAKER STROBE
	WATER FLOW BELL - 120V CONTROLLED BY FLOW SWITCH
	FIRE ALARM FLOW SWITCH
	FIRE ALARM TAMPER SWITCH
	MICROPHONE INPUT JACK
	MICROPHONE INPUT JACK - FLOOR MOUNTED
	INTERCOM CALL BUTTON
	INTERCOM ADMINISTRATION PHONE
	SPEAKER (WALL, CEILING)
	CLOCK SPEAKER COMBINATION WALL MOUNT UNIT
	CLOCK - WALL MOUNTED
	SECURITY ACCESS CARD READER
	DOOR CONTROL SOLENOID
	DOOR MAGNETIC CONTACT
	SECURITY SYSTEM - GLASS BREAK SENSOR
	SECURITY SYSTEM - MOTION SENSOR
	SECURITY SYSTEM - DOOR POSITION SENSOR
	SECURITY SYSTEM - REQUEST TO EXIT MOTION DETECTOR
	SECURITY SYSTEM - ACCESS KEY PAD
	SECURITY SYSTEM - MOTION SENSOR - NARROW PATTERN
	SECURITY SYSTEM - CAMERA
	ACCESS PANEL
	LINE TYPE DENOTING CABLE TRAY
	LINE TYPE/LINE WEIGHT DENOTING FUTURE WORK
	LINE TYPE/LINE WEIGHT DENOTING EXISTING WORK TO REMAIN
	LINE TYPE/LINE WEIGHT DENOTING NEW WORK
	LINE TYPE/LINE WEIGHT DENOTING DEMO WORK
	DENOTES AVAILABLE FAULT CURRENT

EQUIPMENT TAG LEGEND

LUMINAIRES	LUMINAIRE TYPE (UNDERLINED) THE NUMBER IN BRACKETS INDICATES HOW MANY TYPICAL LUMINAIRES OF THIS TYPE ARE IN THIS AREA PANEL TYPICAL LUMINAIRE
CONTROL SWITCHES	LOWER CASE LETTER DENOTES SWITCH LEG FOR CORRESPONDING LUMINAIRE CONTROL UPPERCASE LETTER OR NUMBER DENOTES SWITCH CONFIGURATION
EQUIPMENT CONNECTIONS	EQUIPMENT ID (UNDERLINED) REFER TO EQUIPMENT CONNECTION SCHEDULE FOR REQUIREMENTS TYPICAL EQUIPMENT (MOTOR STARTER SHOWN) CIRCUIT NUMBER(S) PANEL
RECEPTACLES	MOUNTING HEIGHT AFF PANEL CIRCUIT NUMBER(S) NEMA CONFIGURATION FOR SPECIAL RECEPTACLES (UNDERLINED)

ABBREVIATIONS

(E)	EXISTING
A	AMPERES
AC	ACROSS COUNTER
AFT	ABOVE FINISHED FLOOR
AFCI	ARC FAULT CIRCUIT INTERRUPTER
AFG	ABOVE FINISHED GRADE
AHJ	AUTHORITY HAVING JURISDICTION
ANC	AMPS INTERRUPTING CAPACITY
C	CONDUIT OR CABLE
CM	CATEGORY
CB	CIRCUIT BREAKER
CO	CONDUIT ONLY
CT	CURRENT TRANSFORMER
(D)	DEMOLISH
DISC	DISCONNECT
EGC	EQUIPMENT GROUNDING CONDUCTOR
F	FAN/EXHAUST
FAA	FIRE ALARM ANNUNCIATOR
FACP	FIRE ALARM CONTROL PANEL
FHP	FRACTIONAL HORSEPOWER
FLA	FULL LOAD AMPS
FSD	FIRE SMOKE DAMPER
FT	FEET
FU	FUSE
G	GROUND FAULT CIRCUIT INTERRUPTER
GEC	GROUNDING ELECTRODE CONDUCTOR
HP	HORSEPOWER
ID	IDENTIFICATION
IN	INCHES
KVA	KILOVOLT-AMPERE
KW	KILOWATT
LRA	LOCKED ROTOR AMPS
LTD	LIGHTING
MCA	MINIMUM CIRCUIT AMPACITY
MCP	MAIN DISTRIBUTION PANEL
MDS	MAIN DISTRIBUTION SWITCHBOARD
MFS	MAXIMUM FUSE SIZE
(N)	NEW
NC	NORMALLY CLOSED
NO	NORMALLY OPEN
P	POLES
PC	PHOTO CELL
PH #	PHASE
PAL	PANEL
PRI	PRIMARY
REC	RECEPTACLE
(R)	RELOCATED
RB	RELAY IN A BOX (MOTOR RATED)
SCCR	SHORT CIRCUIT CURRENT RATING
SE	SERVICE ENTRANCE RATED
SEC	SECONDARY
SSEBU	SUPPLY SIDE EQUIPMENT BONDING JUMPER
SVC	SERVICE
TELECOM	TELECOMMUNICATION
TGB	TELECOMMUNICATION GROUNDING BUSBAR
TWGB	TELECOMMUNICATION MAIN GROUNDING BUSBAR
TYP	TYPICAL
UON	UNLESS OTHERWISE NOTED
V	VOLTS
VA	VOLT-AMPERES
VFD	VARIABLE FREQUENCY DRIVE
W	WATTS OR WIRE
WG	WIRE GUARD
WP	WEATHERPROOF (NEMA 4 RATED)
XTMR	TRANSFORMER

MOUNTING HEIGHT SCHEDULE

PANELBOARDS (TOP)	+70"
SPECIAL SYSTEM PANELS (TOP)	+68"
POWER METER BASE (CENTER LINE OF SOCKET)	+66"
CONTACTORS, MOTOR STARTERS, DISCONNECT SWITCHES (TOP)	+66"
RECEPTACLES IN OFFICE AREAS	+18"
RECEPTACLES IN NON-FINISHED AND MECHANICAL SPACES	+48"
ABOVE COUNTER DEVICES (DENOTED "AC" OR BY SYMBOL)	SEE NOTES
WALL MOUNTED SWITCHES	+48"
TELECOMMUNICATION OUTLETS	+18"
WALL MOUNTED TELEPHONE OUTLET (DENOTED "W")	+18"
CLOCK OUTLETS	+80" TO BOTTOM
HORN/STROBES/HORN STROBES/DOORBELL RINGER	+80" TO BOTTOM
PULL STATIONS, PUSH BUTTONS, DOORBELL PUSHBUTTON	+48"

- NOTES:
- COORDINATE AND INSTALL ALL EQUIPMENT AND DEVICES WITH THE ARCHITECTURAL PLANS AND ANY SPECIFICALLY DENOTED REQUIREMENTS.
 - MOUNTING HEIGHTS SHALL PREVAIL UNLESS OTHERWISE NOTED OR FIELD CONDITIONS REQUIRE OTHERWISE.
 - MOUNTING HEIGHTS ARE FROM FINISHED FLOOR TO THE CENTERLINE OF THE DEVICE UNLESS OTHERWISE NOTED.
 - COORDINATE MOUNTING HEIGHTS AND LOCATIONS OF OUTLETS DENOTED AS ABOVE COUNTER TO BE INSTALLED 6" ABOVE COUNTERS OR BACKSPASHES, WHICHEVER IS HIGHER.

GENERAL REQUIREMENTS

- ALL ELECTRICAL WORK SHALL BE INSTALLED IN ACCORDANCE WITH ALL REQUIREMENTS OF THE LATEST EDITION OF THE NATIONAL ELECTRIC CODE, STATE, MUNICIPAL, AND FEDERAL LAWS, AMENDMENTS AND/OR ORDINANCES GOVERNING THE PROJECT. IF IN ANY INSTANCE THE PLANS AND SPECIFICATIONS ARE IN DIRECT CONFLICT WITH SUCH CODES, LAWS, AND/OR ORDINANCES, THE CODE, LAWS, AND/OR ORDINANCES SHALL HAVE JURISDICTION AND THE WORK IN QUESTION SHALL BE INSTALLED ACCORDING TO THE CODES, LAWS, AND/OR ORDINANCES. ALL WORK SHALL BE PERFORMED UNDER THE SUPERVISION OF A CERTIFIED ELECTRICAL.
- THE CONTRACTOR SHALL OBTAIN ALL REQUIRED CONSTRUCTION PERMITS AND PAY ALL ASSOCIATED FEES.
- MATERIALS AND EQUIPMENT SHALL BE COMMERCIAL GRADE AND ACCEPTABLE TO THE AUTHORITY HAVING JURISDICTION AS SUITABLE FOR THE USE INTENDED. ALL ELECTRICAL EQUIPMENT SHALL INCLUDE THE SEAL OF A NATIONALLY RECOGNIZED TESTING LABORATORY FOR THE PURPOSE FOR WHICH IT IS INSTALLED. WHENEVER POSSIBLE, SIMILAR ITEMS SHALL BE SUPPLIED BY THE SAME MANUFACTURER THROUGHOUT THE PROJECT.
- COORDINATE AND PROVIDE THE EQUIPMENT WITH THE SHORT CIRCUIT CURRENT RATING (SCCR) FOR THE AVAILABLE FAULT CURRENT AT THE POINT OF THE SYSTEM WHERE INSTALLED. SERIES RATING OF EQUIPMENT IS ACCEPTABLE. PROVIDE ARC FAULT WARNING LABELS ON ALL PANELBOARDS, MCC UNITS AND SIMILAR EQUIPMENT PER NEC REQUIREMENTS.
- THE FOLLOWING WIRING METHODS SHALL BE ACCEPTABLE FOR INSTALLATION OF ELECTRICAL CIRCUITS: TYPE MC CABLE, INTERMEDIATE METAL CONDUIT, RIGID METAL CONDUIT, RIGID NONMETALLIC CONDUIT (FOR UNDERGROUND USE ONLY), ELECTRICAL METALLIC TUBING, FLEXIBLE METALLIC TUBING, FLEXIBLE METAL CONDUIT, AND LIQUID TIGHT FLEXIBLE CONDUIT. ALL WIRING METHODS SHALL INCLUDE AN EQUIPMENT GROUNDING CONDUCTOR TO BE INSTALLED THEREIN AND SIZED FOR THE CIRCUITS SERVED.
- ALL CONDUCTORS SHALL BE COPPER. ALL CONDUCTORS IN UNHEATED SPACES OF THE BUILDING OR LOCATED OUTSIDE OF THE BUILDING ARE REQUIRED TO HAVE TYPE 90 DEGREE C INSULATION. ALL CONDUCTORS LOCATED IN HEATED SPACES CAN BE 90 DEGREE C OR 75 DEGREE C INSULATION UNLESS NOTED OTHERWISE. CONDUCTOR AMPACITY SHALL BE BASED ON TABLE 310-16 OF THE NEC. USE 60-DEGREE C RATING FOR CIRCUITS TERMINATING ON DEVICES RATED BELOW 100A. USE 75-DEGREE C RATING FOR CIRCUITS TERMINATING ON DEVICES AND IN ENCLOSURES RATED 100A AND OVER. DERATE CONDUCTORS PER NEC REQUIREMENTS.
- CONCEAL ALL ELECTRICAL RACEWAYS, BOXES, CABLES, CONDUCTORS AND THE LIKE IN WALLS, BELOW FLOORS, SLABS OR ABOVE FINISHED CEILING SPACES. ELECTRICAL EQUIPMENT AND WIRING CAN BE EXPOSED IN MECHANICAL ROOMS, TELECOMMUNICATION ROOMS OR WHERE SPECIFICALLY NOTED.
- DO NOT ROUTE RACEWAYS ON THE EXTERIOR SURFACE OF THE BUILDING OR THE ROOF UNLESS SPECIFICALLY NOTED OTHERWISE.
- PROVIDE ALL WIRING AND EQUIPMENT IN WET AND EXTERIOR LOCATIONS USING EQUIPMENT AND WIRING METHODS RATED FOR WET ENVIRONMENTS.
- ALL CABLES LOCATED IN CEILING SPACES THAT ARE PLENUMS SHALL BE PLENUM RATED.
- PROVIDE ACCESS PANELS FOR ALL LOCATION NECESSARY TO ACCESS ELECTRICAL EQUIPMENT AND JUNCTION BOXES. ACCESS PANELS SHALL BE FIRE RATED EQUAL TO OR EXCEEDING THE ADJACENT WALL OR CEILING CONSTRUCTION AND PAINTED TO MATCH.
- CONNECT ALL EMERGENCY LIGHTING UNITS AND MODULES TO THE LOCAL AREA LIGHTING CIRCUITS AHEAD OF ANY SWITCHES OR RELAYS. LOCATE REMOTE TEST SWITCHES AND INDICATOR LIGHTS AS NECESSARY FOR TEST SWITCHES ON EMERGENCY MODULES.
- SEAL ALL PENETRATIONS. SEAL PENETRATIONS AT ALL FIRE WALLS WITH APPROVED FIRE STOPPING COMPOUND.
- OUTLET BOXES LOCATED BACK TO BACK IN FIRE RATED WALLS SHALL BE SPACED A MINIMUM OF 2 FEET HORIZONTALLY OR PROVIDE AN APPROVED FIRE PROTECTIVE MATERIAL PLACED ON OR AROUND THEM LISTED FOR THE FIRE RATING OF THE WALL.
- CONTRACTOR SHALL SUBMIT REQUEST FOR SUBSTITUTION IN WRITING TO THE ENGINEER.
- PROVIDE SEISMIC SUPPORT AND DESIGN PER IBC REQUIREMENTS.
- THE ELECTRICAL CONTRACTOR SHALL CONTACT EACH SERVING UTILITY CO. AND VERIFY EXIST SERVICE REQUIREMENTS FOR POWER AND TELEPHONE. THE CONTRACTOR SHALL COORDINATE AND PROVIDE ALL REQUIREMENTS OF EACH SERVING UTILITY AND ALL EQUIPMENT SHALL CONFORM TO THE SERVING UTILITY STANDARDS AND REQUIREMENTS.

ELECTRICAL SHEET LIST

E1.1	ELECTRICAL LEGEND & SCHEDULES
E2.1	ELECTRICAL SITE PLAN
E3.1	ELECTRICAL NEC CLASSIFIED BOUNDARY DETAILS
E4.1	ELECTRICAL CELL TRANSFER MANHOLE PLANS
E4.2	ELECTRICAL POWER PLANT PLANS
E5.1	ELECTRICAL LIFT STATION PLANS
E5.2	ELECTRICAL LIFT STATION PLANS
E6.1	ELECTRICAL LIFT STATION DIAGRAMS & PANEL SCHEDULES
E6.2	ELECTRICAL LIFT STATION CONTROLS
E6.3	ELECTRICAL POWER PLANT CONTROLS & DIAGRAMS

EIC ENGINEERS, INC.

ELECTRICAL ENGINEERS

6957 OLD SEWARD HWY, SUITE 200
ANCHORAGE, AK 99518
T 907.347-9712
F 907.347-9713
www.eiceng.com

SC JOB #E10-1223

RECORD DRAWING CERTIFICATE

THESE DRAWINGS REFLECT RECORDED INFORMATION OBTAINED DURING CONSTRUCTION. INFORMATION PROVIDED HEREIN IS ACCURATE TO THE BEST OF MY KNOWLEDGE.

DATE

SCALE:

1" = 10' (SEE PLAN FOR DIMENSIONS)



2009 WASTEWATER SYSTEM IMPROVEMENTS

ELECTRICAL LEGEND & SCHEDULES

TULUAK, ALASKA

EIC ENGINEERS, INC.

PO BOX 3224 ANCHORAGE, AK 99511 TEL: 907-347-9712 FAX: 907-347-9713

BY DATE

REVISION

Project No.


Date

Drawn

Approved

Sheet No.

E1.1

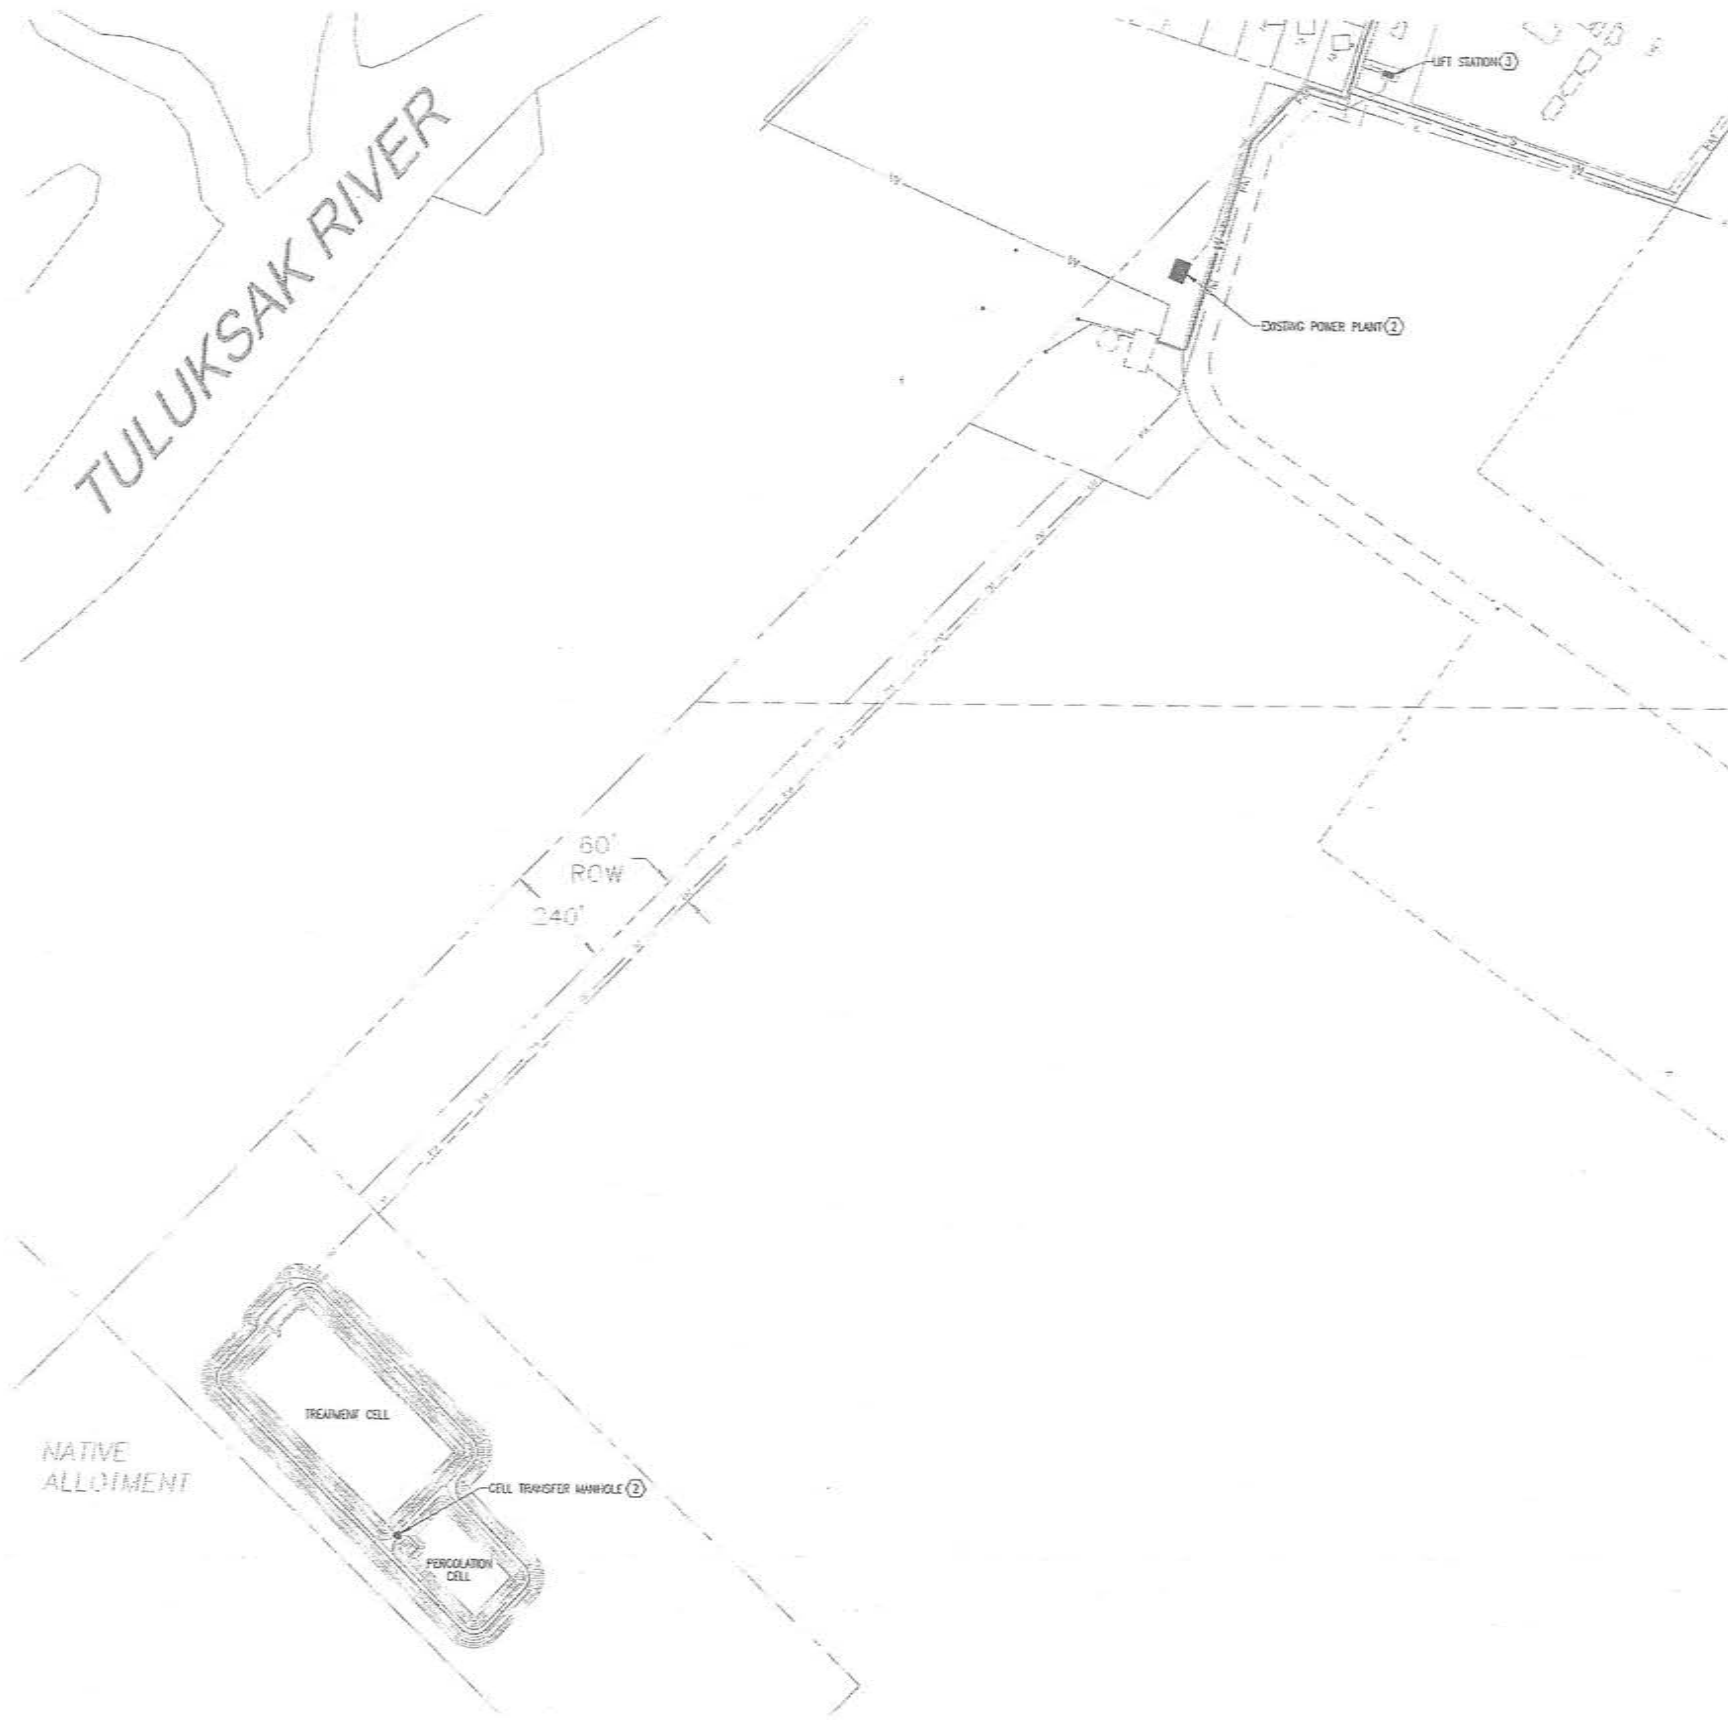

1 ELECTRICAL SITE PLAN
E2.1 SCALE: 1" = 200'-0"



SHEET NOTES

- CONTRACTOR TO PROVIDE PORTABLE GENERATOR POWER CONNECTION AND SEWER PIPE HEAT TRACE AT NEW CELL TRANSFER MANHOLE LOCATION. SEE E4.1 FOR DETAIL.
- CONTRACTOR TO PROVIDE NEW BRANCH CIRCUITS IN EXISTING POWER PLANT FOR HEAT LOOP PUMP CONTROL PANEL AND CIRCULATION PUMPS. SEE 1/E4.2 FOR DETAIL.
- CONTRACTOR TO PROVIDE ELECTRICAL INSTALLATIONS IN NEW LIFT STATION. SEE E5.1, E5.2, AND E5.1 FOR DETAIL.

EIC ENGINEERS, INC.
ELECTRICAL ENGINEERS

6927 OLD SEWAPD HWY, SUITE 200
ANCHORAGE, AK 99518
T 907.349.9712
F 907.349.9713
www.eiceng.com

RECORD DRAWING CERTIFICATE
THESE DRAWINGS REFLECT RECORD INFORMATION OBTAINED DURING CONSTRUCTION. INFORMATION PROVIDED HEREIN IS ACCURATE TO THE BEST OF MY KNOWLEDGE.

NAME _____ DATE _____

SCALE: 1" = 200'-0"

STATE OF ALASKA
1924
ENGINEER
ENC. D. CORREDO
REG. EE-5712
SUTHERLAND


2008 WASTEWATER
SYSTEM IMPROVEMENTS
ELECTRICAL
SITE PLAN
TULUKSAK, ALASKA

CER ENGINEERS, INC.
PO BOX 13394 ANCHORAGE AK 99512 PH: 907-260-1981 FAX: 907-508-9103


REVISION	BY	DATE

Project No.	Date	Designed	Drawn	Approved
	JAN 2011	BLS	BLS	ECC

Sheet No. **E2.1**

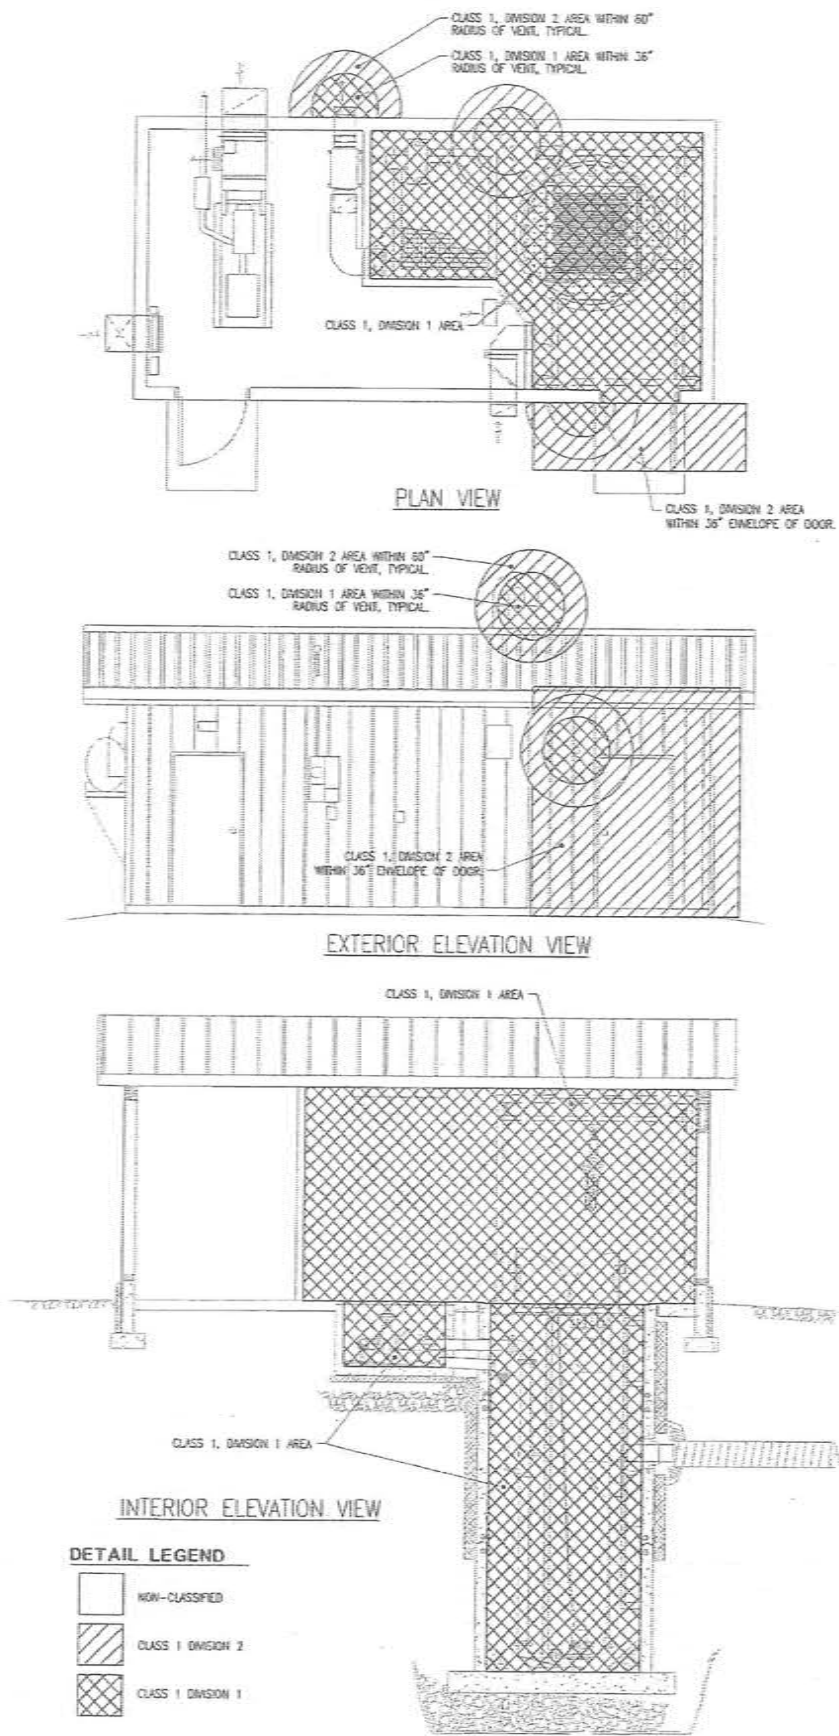

1
E3.1
LIFT STATION
NEC CLASSIFIED BOUNDARY DETAIL
SCALE: 1/4" = 1'-0"

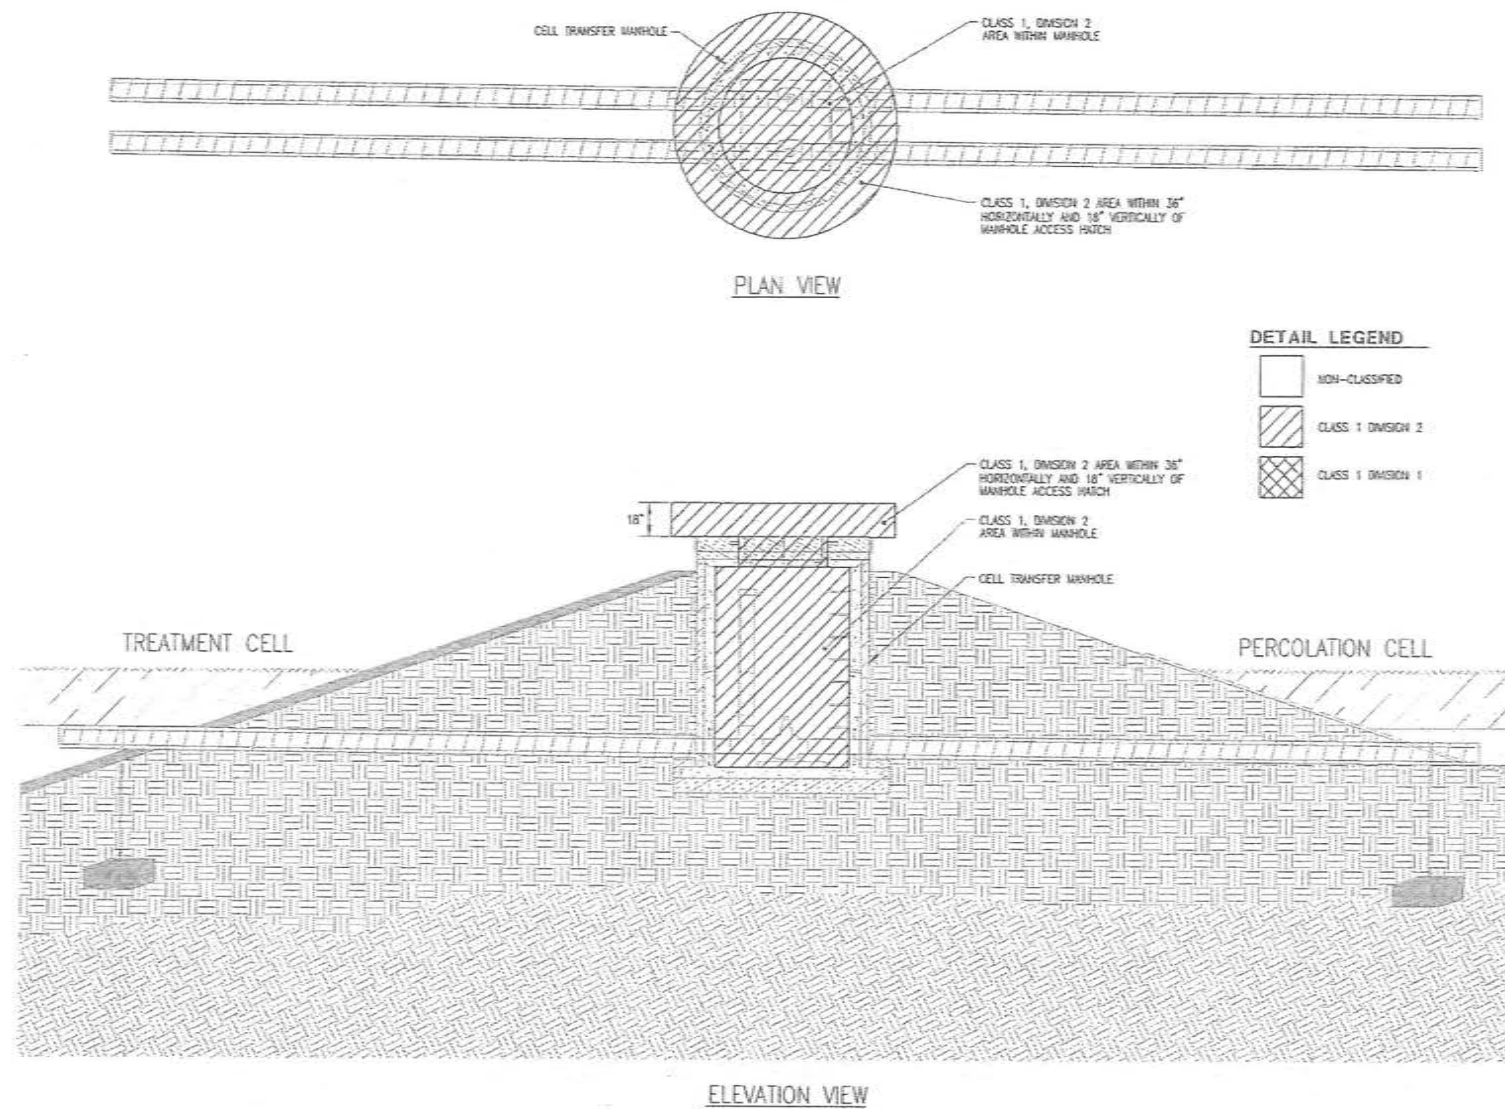

2
E3.1
CELL TRANSFER MANHOLE
NEC CLASSIFIED BOUNDARY DETAIL
SCALE: 1/4" = 1'-0"



EIC ENGINEERS, INC.
ELECTRICAL ENGINEERS

6927 OLD SEWARD HWY., SUITE 200
ANCHORAGE, AK 99518
T 907.348.9712
F 907.348.9713
www.eiceng.com

RECORD DRAWING CERTIFICATE
THESE DRAWINGS REFLECT RECORDED INFORMATION OBTAINED DURING CONSTRUCTION. INFORMATION PROVIDED HEREIN IS ACCURATE TO THE BEST OF MY KNOWLEDGE.

SCALE: 1/4" = 1'-0"

STATE OF ALASKA
REGISTERED PROFESSIONAL ENGINEER
ELECTRICAL ENGINEERING
EPC 0.00000
AL. E.E.-7773
06/01/11


2009 WASTEWATER SYSTEM IMPROVEMENTS
ELECTRICAL
NEC CLASSIFIED
BOUNDARY PLANS
TULUKSAK, ALASKA

CEI ENGINEERS, INC.
PO BOX 12266 ANCHORAGE AK 99512 PH 907.348.9712 FAX 907.348.9713


REVISION	BY	DATE

Project No.	Date	Designed	Drawn	Approved
	JAN 2011	ELS	ELS	EDC

Sheet No. **E3.1**

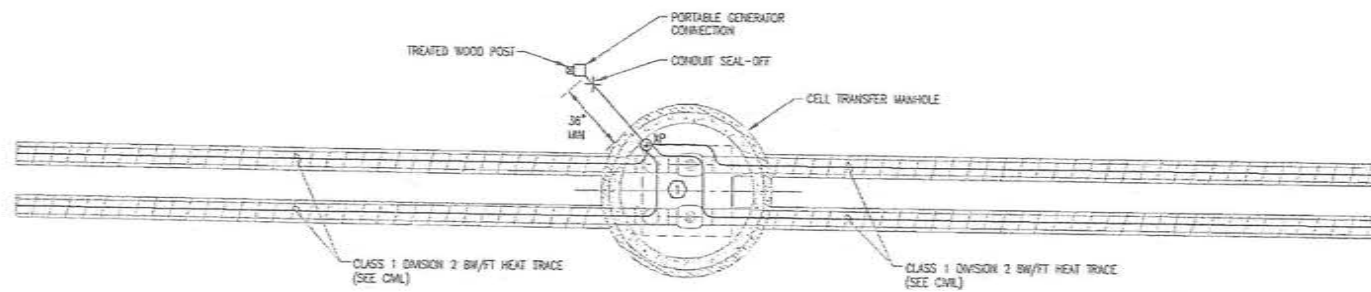


1 CELL TRANSFER MANHOLE ELECTRICAL PLAN
E4.1 SCALE: 1/4" = 1'-0"

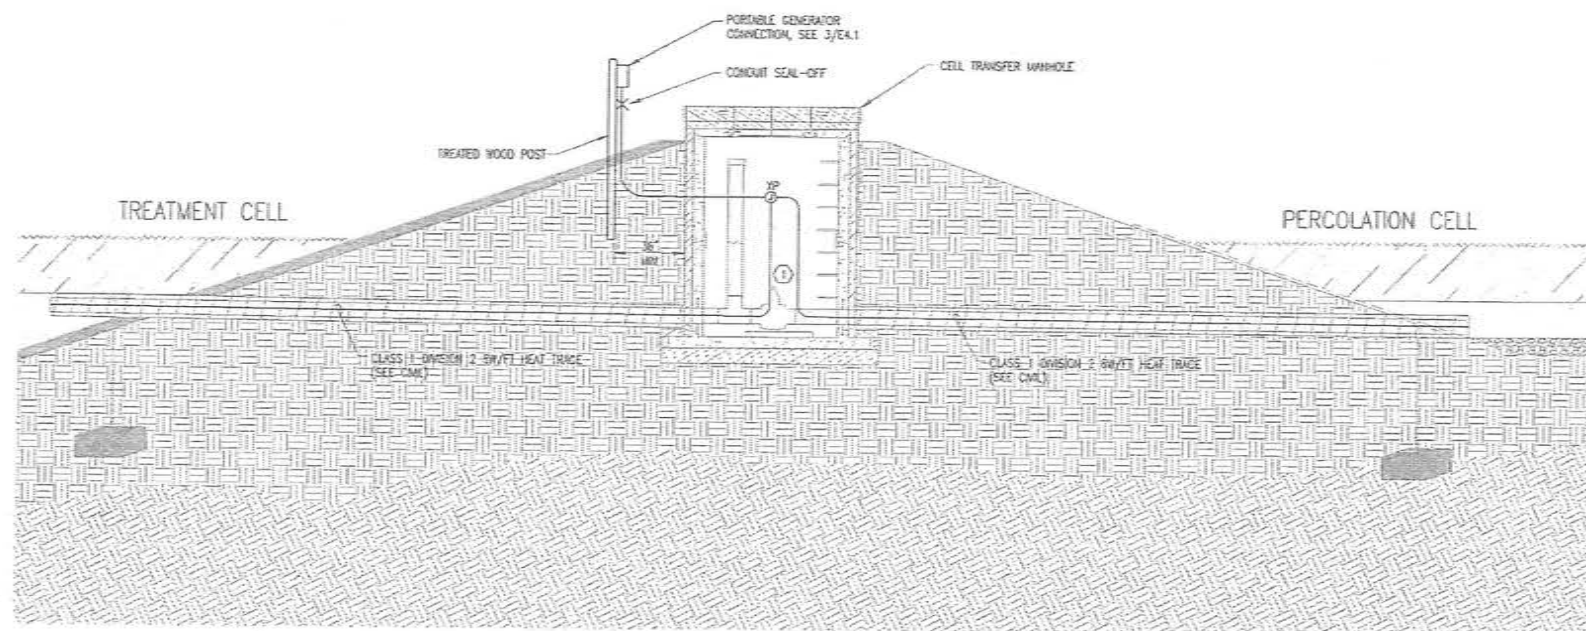

2 CELL TRANSFER MANHOLE ELEVATION
E4.1 SCALE: 1/4" = 1'-0"

SHEET NOTES

- 1 WRAP EXPOSED PIPING AND VALVES IN MANHOLE WITH HEAT TRACE FOR FREEZE PROTECTION. PROVIDE AT LEAST 1 REVOLUTION PER FOOT ON EACH OF THE PIPES.

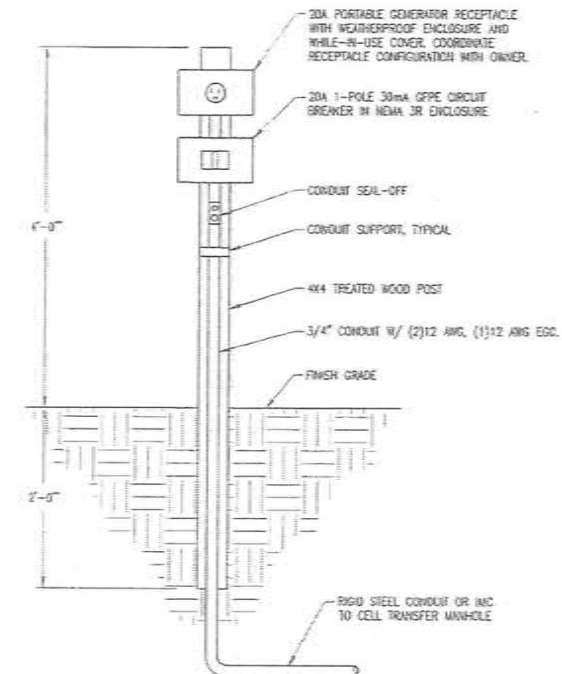

3 PORTABLE GENERATOR CONNECTION DETAIL
E4.1 SCALE: NONE

EIC ENGINEERS, INC.
ELECTRICAL ENGINEERS

6927 OLD SEWARD HWY., SUITE 200
ANCHORAGE, AK 99516
T 907.348.9712
F 907.348.9712
www.eiceng.com

RECORD DRAWING CERTIFICATE
THESE DRAWINGS REFLECT RECORDED
INFORMATION OBTAINED DURING
CONSTRUCTION. INFORMATION PROVIDED
HEREIN IS ACCURATE TO THE BEST OF MY
KNOWLEDGE.

NAME _____ DATE _____

SCALE:
1" = 1'-0"




2009 WASTEWATER
SYSTEM IMPROVEMENTS
ELECTRICAL
CELL TRANSFER
MANHOLE PLANS
TULUKSAK, ALASKA

CE2
ENGINEERS, INC.
PO BOX 33266 ANCHORAGE AK 99503 PH: 907.348.9712 FAX: 907.348.9713

REVISION	BY	DATE

Project No.	Date	Designed	Drawn	Approved
	JAN 2011	BLS	BLS	EDC

Sheet No. **E4.1**

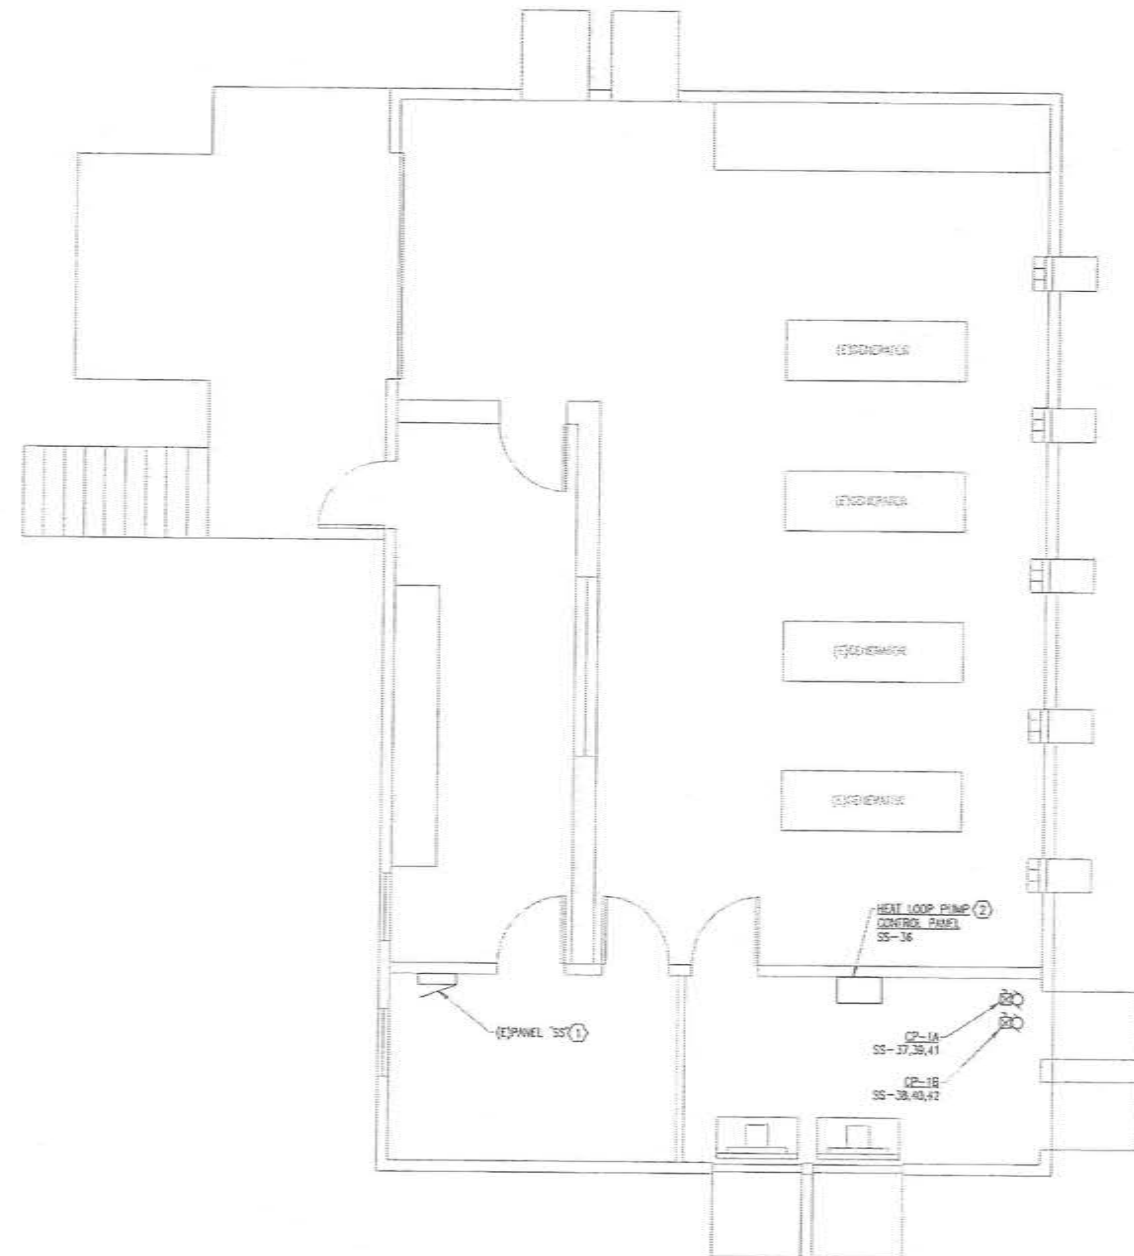

1 EXISTING POWER PLANT PLAN
E4.2 SCALE: 1/4" = 1'-0"

SHEET NOTES

1. PROVIDE BRANCH CIRCUITS IN EXISTING PANEL 'SS' (208Y/120V, 150A, 3Ø, 4W) FOR FEED TO NEW HEAT LOOP CONTROL PANEL AND CIRCULATION PUMPS. SEE 3/E6.3 FOR DETAIL.
2. PROVIDE HEAT LOOP PUMP CONTROL PANEL. SEE 1/E6.3 AND 2/E6.3 FOR DETAIL.

EIC ENGINEERS, INC.
ELECTRICAL ENGINEERS

6927 OLD SEWARD HWY, SUITE 200
ANCHORAGE, AK 99518
T 907.249.9712
F 907.249.9713
www.eiceng.com

RECORD DRAWING CERTIFICATE
THESE DRAWINGS REFLECT RECORDED
INFORMATION OBTAINED DURING
CONSTRUCTION. INFORMATION PROVIDED
HEREIN IS ACCURATE TO THE BEST OF MY
KNOWLEDGE.
NAME _____ DATE _____

SCALE:
1" = 10'-0"
1" = 20'-0"
1" = 30'-0"
1" = 40'-0"
1" = 50'-0"
1" = 60'-0"
1" = 70'-0"
1" = 80'-0"
1" = 90'-0"
1" = 100'-0"



2009 WASTEWATER
SYSTEM IMPROVEMENTS
ELECTRICAL
POWER PLANT PLANS
TULUKSAK, ALASKA

EIC
ENGINEERS, INC.
PO BOX 3324 ANCHORAGE AK 99513 PH: 907-348-1000 FAX: 907-348-1010

REVISION	BY	DATE

Project No.	0100	Design	BLS	Drawn	BLS	Approved	EOC
Date	JAN 2011						


Sheet No. **E4.2**

LUMINAIRE SCHEDULE				
TYPE	DESCRIPTION	LAMPS	MOUNTING	MANUFACTURER/MODEL
LB2	LOW PROFILE ARCHITECTURAL WRAP W/ PRISMATIC LENS	(2) 32W T8	CEILING SURFACE	LITHONIA #LB-2-32-INVOLT-GB10S
LB2E	IDENTICAL TO TYPE "LB2" EXCEPT W/ 1400 LUMEN BATTERY UNIT	(2) 32W T8	CEILING SURFACE	LITHONIA #LB-2-32-INVOLT-GB10S-EL14
XP1	CLASS 1 DIVISION 1 INCANDESCENT GLOBE & GUARD	(1) 150W INCAN	CEILING SURFACE	HUBBELL #HLE-W-1-15-120-X2-C-HLEMG1
ZW1	WALL MOUNTED AREA LIGHT W/ CUTOFF OPTICS & INTEGRAL PHOTOCELL	(1) 35W HPS	EXTERIOR WALL	LITHONIA #TWAC-35S-120-PE

A) CATALOG NUMBERS ARE FOR GENERAL REFERENCE AND ARE NOT INCLUSIVE OF ALL OPTIONS OR REQUIREMENTS DENOTED ON PLANS AND SPECIFICATIONS.
 B) REFER TO ARCHITECTURAL DRAWINGS FOR EXACT LOCATION AND PROVIDE MOUNTING HARDWARE/FLANGES ETC FOR ALL LUMINAIRES FOR CEILING TYPES SHOWN.
 C) LUMINAIRES NOTED ON THE FLOOR PLANS AS "NL" (NIGHTLIGHT) SHALL BE CONNECTED TO UNSWITCHED POWER CIRCUIT NOTED ON DRAWINGS.
 D) ALL FLUORESCENT BALLASTS TO BE ELECTRONIC WITH LESS THAN OR EQUAL 10% TOTAL HARMONIC DISTORTION.
 E) ALL FLUORESCENT LAMPS TO BE 3500K.
 F) PROVIDE ROUGH SERVICE LAMPS FOR ALL INCANDESCENT LUMINAIRES.

REFERENCED NOTES

1) NONE.

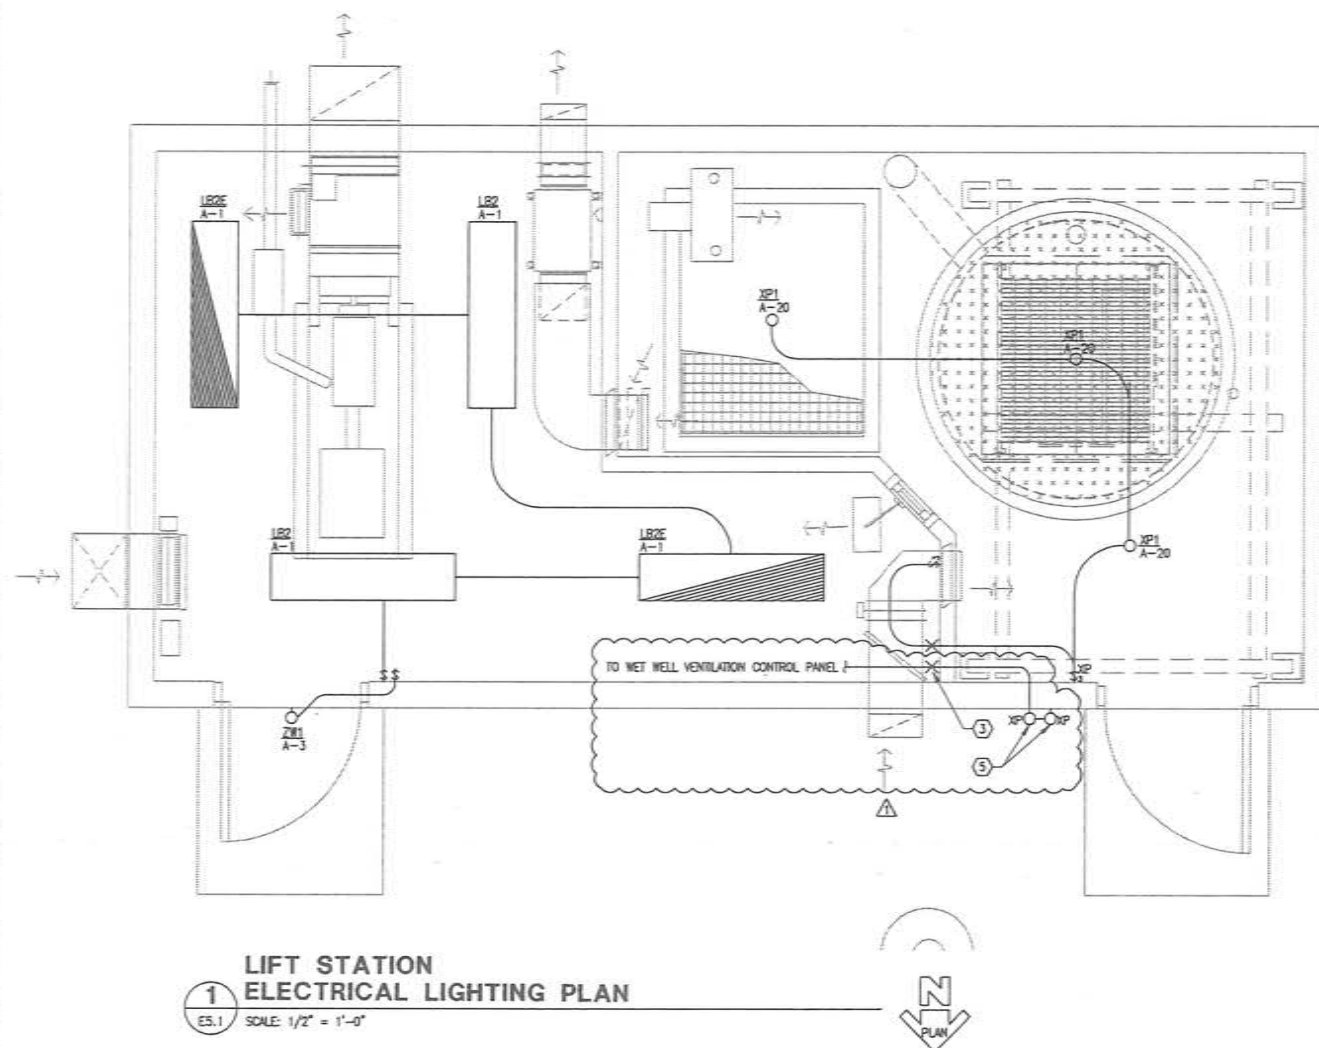

1
LIFT STATION
ELECTRICAL LIGHTING PLAN
ES.1 SCALE: 1/2" = 1'-0"


MECHANICAL EQUIPMENT CONNECTION SCHEDULE									
UNIT ID	LOCATION OR FUNCTION	LOAD RATINGS						CONDUCTORS & CONDUIT	NOTES
		KVA	HP	FLA	MCA	MPS	V		
EF-1	CLASS 1 DIVISION 1 EXHAUST FAN		1/4				120	1 (2)12 AWG, (1)12 AWG EGC, 1/2" C.	2
SP-1	SEWAGE PUMP		10				208	3 SEE ONE-LINE DIAGRAM	1
SP-2	SEWAGE PUMP		10				208	3 SEE ONE-LINE DIAGRAM	1
UH-1	CLASS 1 DIVISION 1 ELECTRIC UNIT HEATER	10					208	3 (3)8 AWG, (1)10 AWG EGC, 3/4" C.	
UH-2	ELECTRIC UNIT HEATER	3					208	1 (2)12 AWG, (1)12 AWG EGC, 1/2" C.	

STANDARD NOTES

A) REFER TO FLOOR PLAN DRAWINGS FOR EQUIPMENT TYPE REQUIREMENTS, LOCATIONS AND QUANTITIES.
 B) COORDINATE ALL CONNECTION REQUIREMENTS WITH MECHANICAL AND ACTUAL EQUIPMENT SUPPLIED PRIOR TO ROUGH-IN.

REFERENCED NOTES

1) PUMP PROVIDED WITH SOFT START. COORDINATE WITH MECHANICAL.
 2) EF-1 CONTROLLED THRU WET WELL VENTILATION CONTROL PANEL.

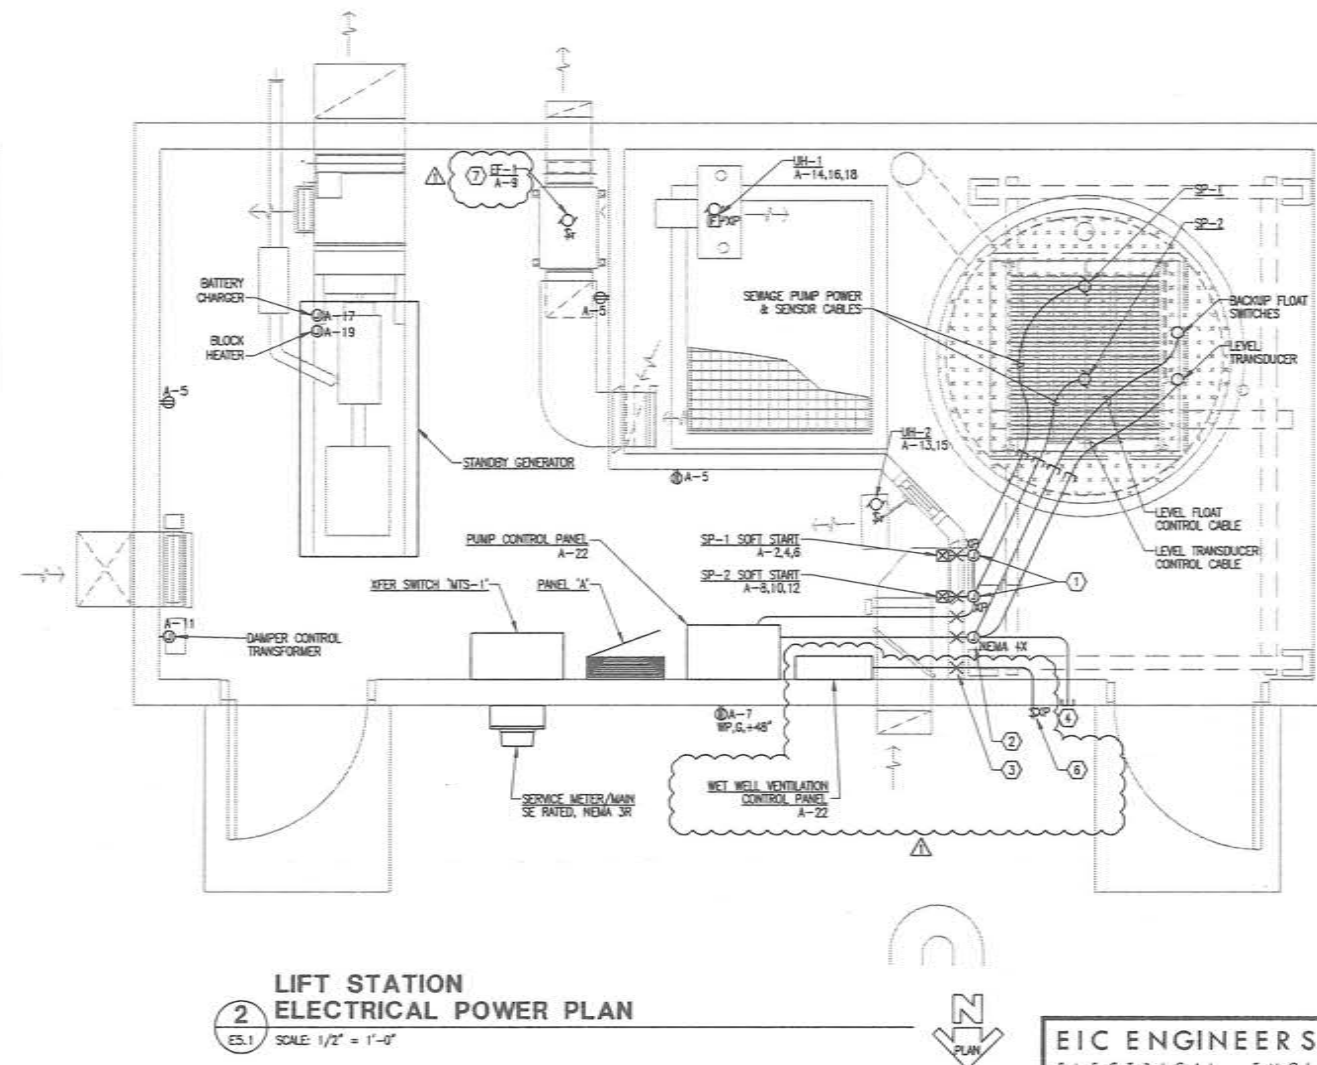

2
LIFT STATION
ELECTRICAL POWER PLAN
ES.1 SCALE: 1/2" = 1'-0"

SHEET NOTES

- PROVIDE EXPLOSION PROOF JUNCTION BOXES FOR WET WELL PUMP CABLE TERMINATIONS. SEE 2/ES.2 FOR DETAIL.
- PROVIDE NEMA 4X JUNCTION FOR FLOAT SWITCH, AND LEVEL TRANSDUCER CABLE TERMINATIONS. SEE 2/ES.2 FOR DETAIL.
- PROVIDE CONDUIT SEAL-OFF AT HAZARDOUS BOUNDARY, TYPICAL.
- PROVIDE CONDUIT FROM CONTROL J-BOX TO BUILDING EXTERIOR FOR LEVEL TRANSDUCER BELLWIS VENTILATION.
- PROVIDE EXPLOSION PROOF STATUS LIGHTS TO BUILDING EXTERIOR, CONTROL FROM WET WELL VENTILATION CONTROL PANEL. SEE MECHANICAL AND 1/ES.4 FOR DETAIL.
- PROVIDE EXPLOSION PROOF SELECTOR SWITCH TO BUILDING EXTERIOR, CONTROL FROM WET WELL VENTILATION CONTROL PANEL. SEE MECHANICAL AND 1/ES.4 FOR DETAIL.
- EF-1 CONTROLLED THRU WET WELL VENTILATION CONTROL PANEL. SEE MECHANICAL AND 1/ES.4 FOR DETAIL.

RECORD DRAWING CERTIFICATE



THESE DRAWINGS REFLECT RECORDED INFORMATION OBTAINED DURING CONSTRUCTION. INFORMATION PROVIDED HEREIN IS ACCURATE TO THE BEST OF MY KNOWLEDGE.

NAME _____ DATE _____

SCALE: AS SHOWN

BASED ON ORIGINAL DRAWING

IF ANY DISCREPANCY BETWEEN THIS SHEET AND THE ORIGINAL DRAWING, THE ORIGINAL DRAWING SHALL BE ACCURATE.

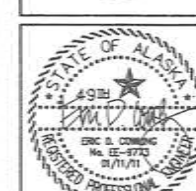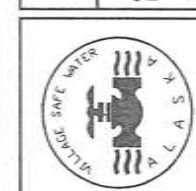

2009 WASTEWATER SYSTEM IMPROVEMENTS

ELECTRICAL LIFT STATION PLANS

TULUKSAK, ALASKA

CEI ENGINEERS, INC.

PO BOX 22546 ANCHORAGE, AK 99523 PH 907.349.1010 FAX 907.349.1015

REVISION	DATE	BY
1	1/19/11	BL

Project No. _____

Date: JAN 2011

Designed: BLS


Drawn: BLS

Approved: EDC


Sheet No. E5.1

EIC ENGINEERS, INC
ELECTRICAL ENGINEERS

4927 OLD SEWARD HWY, SUITE 200
ANCHORAGE, AK 99518
T 907.349.9712
F 907.349.9713
www.eiceng.com

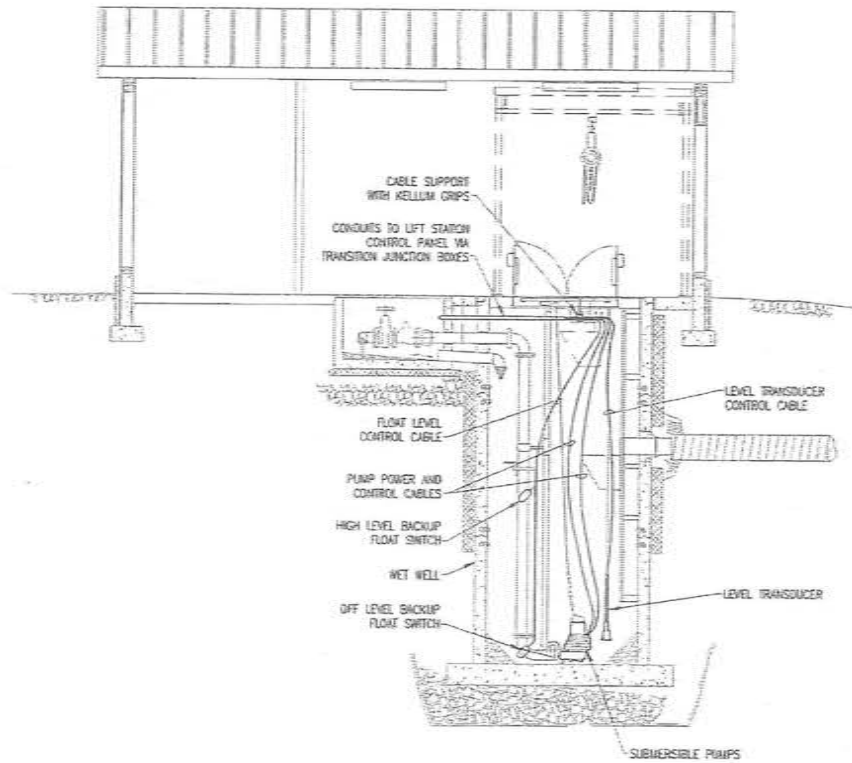

1 LIFT STATION
WET WELL ELEVATION
ES.2 SCALE: 1/4" = 1'-0"

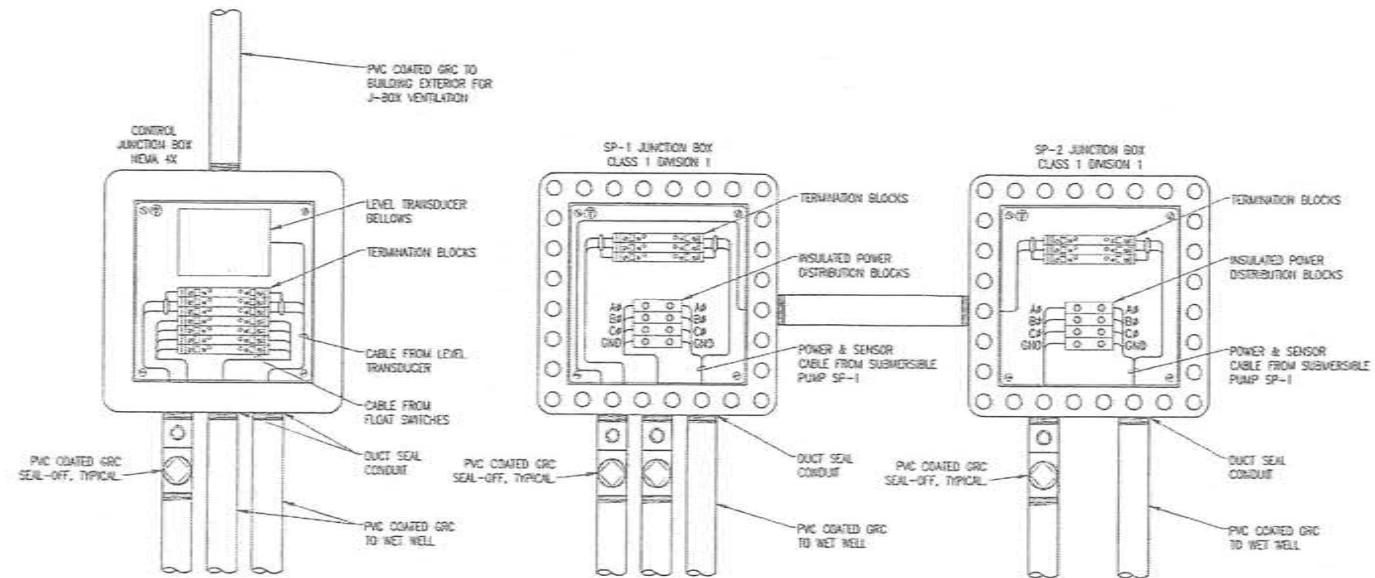

DETAIL NOTES


1. JUNCTION BOXES SHALL BE SIZED AS REQUIRED TO HOUSE TERMINATION COMPONENTS AND WIRING PER IEC.
2. ALL WIRING ROUTED THROUGH THE NEVA 4X CONTROL JUNCTION BOX SHALL BE INTRINSICALLY SAFE.

2 LIFT STATION TRANSITION JUNCTION BOX DETAIL
ES.2 SCALE: NONE




- ① SERVICE WATER MAIN-
32 RATED, NEMA 3B, 200A MAIN CB, 200Y/120V, 3 ϕ , 4W.
SQUARE D OR EQUIVALENT.
- ② MAINLINE TRANSFER SWITCH "1"-
NEMA 1, 3-POLE, 200A, 200Y/120V, 3 ϕ , 4W. ASCO OR
EQUIVALENT.
- ③ PANEL "1"-
NEMA 1, 225A, 200Y/120V, 3 ϕ , 4W, 42 SPACE SQUARE D
TYPE WOOD OR EQUIVALENT. PROVIDE WITH TRANSIENT
VOLTAGE SURGE SUPPRESSION (TVSS).
- ④ PUMP CONTROL PANEL-
DUPLEX PUMP CONTROL PANEL
(SEE SHEET EA.2)
- ⑤ SERVICE PUMP START/STOP MOTOR STARTER-
1/2HP, 200V 3 ϕ , FPO ENCLOSURE
PROGRAMMABLE PUMP CURVES
DAFFORS OR EQUIVALENT
(SEE SHEET EA.2)
- ⑥ STANDBY GENERATOR-
45KW/500VA, 200Y/120V, 3 ϕ , 4 WIRE
DIESEL, WITH BASE TANK
KOHLER OR EQUIVALENT

FEEDER SCHEDULE				
FEEDER ID	RACEWAY QTY	SIZE	CONDUCTORS	NOTES
SD	1	1"	(3)6 AWG, (1)10 AWG EGC	
100N	1	1-1/4"	(4)2 AWG, (1)8 AWG EGC	
150N	1	2"	(4)1/0 AWG, (1)6 AWG EGC	
200N	1	2"	(4)3/0 AWG, (1)6 AWG EGC	
PC1	1	1-1/2"	PUMP POWER & SENSOR CABLE	
TC1	1	3/4"	(1)16/2 THWD, (4)12 AWG (FLOAT & LEVEL TRANSDUCER CONTROL WIRING)	2
TC2	1	1-1/2"	LEVEL TRANSDUCER CABLE	
TC3	1	1-1/2"	FLOAT SWITCH CABLE	
TC4	1	3/4"	(4)12 AWG (PUMP START/STOP & PHASE FAIL CONTROL WIRING)	2
TC5	1	1/2"	(2)16/2 THWD (PUMP SENSOR CONTROL WIRING)	2
TC6	1	1/2"	(1)16/2 THWD (PUMP SENSOR CONTROL WIRING)	2
SE	1	2"	CONDUIT ONLY	1
STANDARD NOTES				
A) ALL CONDUCTOR SIZES SHOWN ARE COPPER.				
REFERENCED NOTES				
1) CONDUIT SUB WITH WEATHER HEAD FOR OVERHEAD UTILITY CONNECTION.				
2) CONTRACTOR TO VERIFY CONDUIT WIRING WITH ACTUAL EQUIPMENT SUPPLIED.				

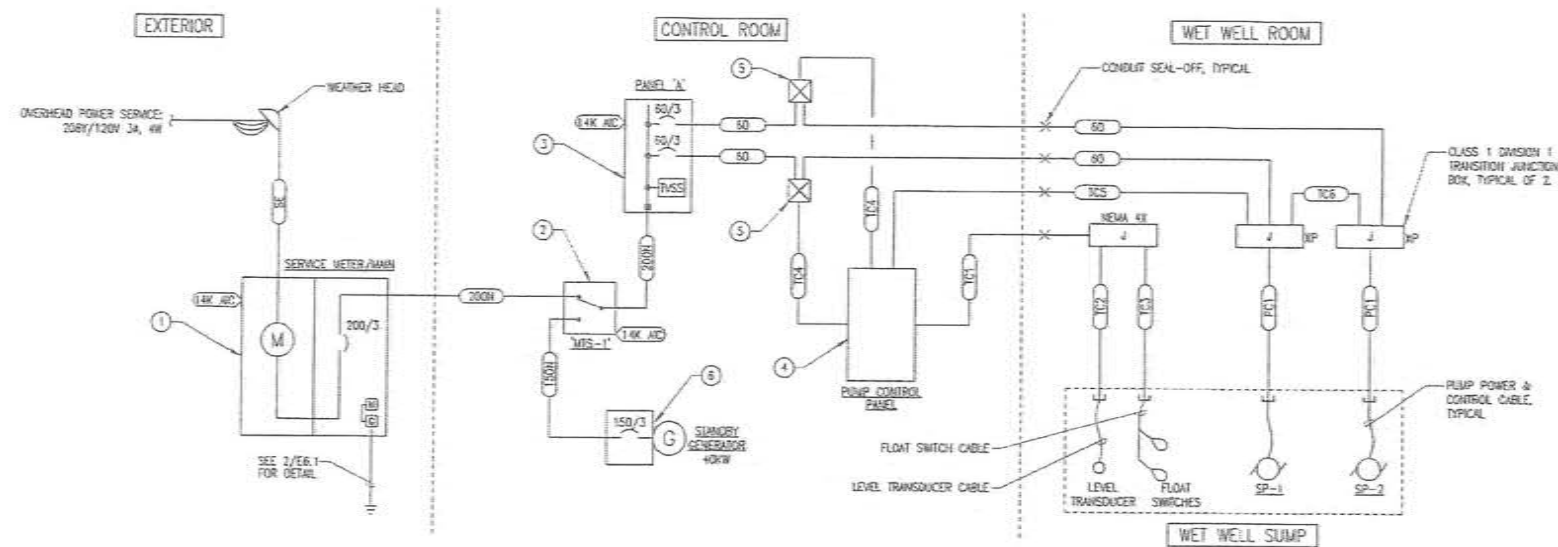

1 LIFT STATION POWER ONE-LINE DIAGRAM
ES.1 SCALE: NONE

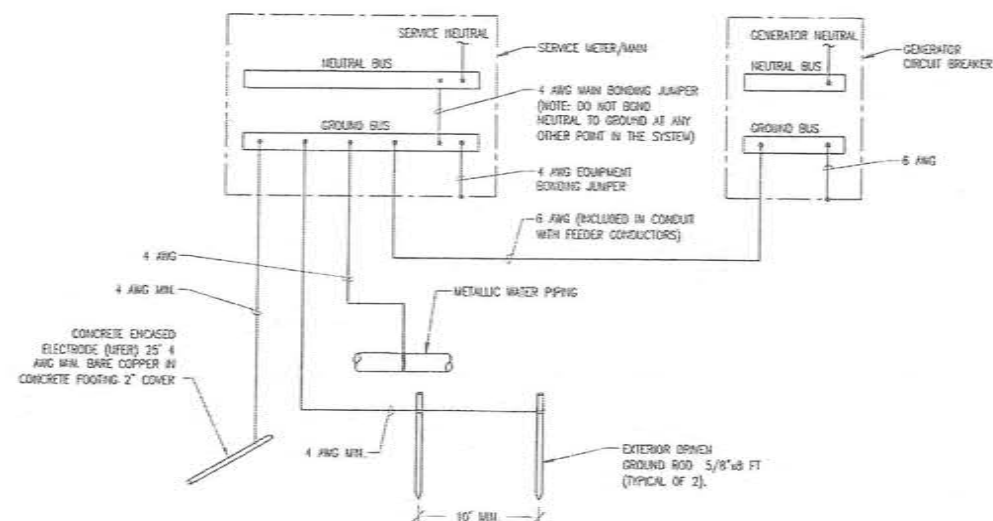

2 LIFT STATION GROUNDING DIAGRAM
E6.1 SCALE: NONE

[illegible]

EIC ENGINEERS, INC
ELECTRICAL ENGINEERS



6927 OLD SEWARD HWY, SUITE 205
ANCHORAGE, AK 99518
T 907.349.9712
F 907.349.9713
www.ellco.com

BC JCA #E10-1120

RECORD DRAWING CERTIFICATE

THESE DRAWINGS REFLECT RECORDED
INFORMATION OBTAINED DURING
CONSTRUCTION. INFORMATION PROVIDED
HEREIN IS ACCURATE TO THE BEST OF MY
KNOWLEDGE.

NAME _____ DATE _____

SCALE:

DATE OF MEASUREMENT

ORIGINAL DRAWING

1"

0

IF NOT ONE EACH ON
THIS SHEET, ADJUST
SCALE AS NECESSARY




2009 WASTEWATER
SYSTEM IMPROVEMENTS
ELECTRICAL
LIFT STATION
DIAGRAMS &
PANEL SCHEDULE
TULUKSAK, ALASKA

CE2
ENGINEERS, INC.
PO BOX 22504 ANCHORAGE, AK 99521 PH: 907-249-1910 FAX: 907-249-1015

[illegible]

Project _____
No. _____
Date JAN 2011
Designed BLS
Drawn BLS
Approved EDC


Sheet No. E6.1

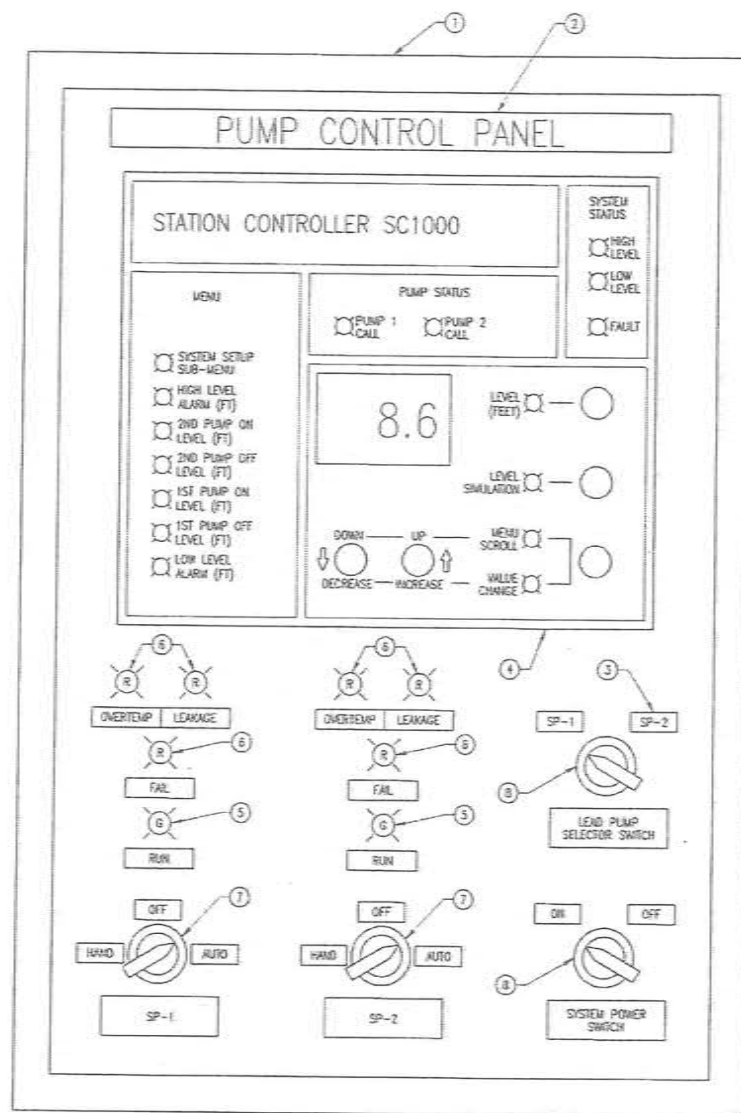

CONTROL PANEL COMPONENT SCHEDULE		
ITEM	DESCRIPTION	NOTES
1	CONTROL PANEL ENCLOSURE- NEMA 4, SIZED ADEQUATE TO HOUSE COMPONENTS.	
2	NAME TAG- BLACK LAMINATED PLASTIC W/ WHITE CORE, SCREW MOUNTED, 1/2" ENGRAVED LETTERS	
3	NAME TAG- BLACK LAMINATED PLASTIC W/ WHITE CORE, SCREW MOUNTED, 1/4" ENGRAVED LETTERS	
4	DUPLEX PUMP CONTROLLER- MPE, INC STATION CONTROLLER SC1000	
5	Pilot Light- 30mm, GREEN, LED, 120VAC, PUSH TO TEST TYPE, ALLEN BRADLEY 800-PH18G	
6	Pilot Light- 30mm, RED, LED, 120VAC, PUSH TO TEST TYPE, ALLEN BRADLEY 800-PH18R	
7	SELECTOR SWITCH- 30mm, 3-POSITION MAINTAINED W/ TERMINAL BLOCKS & CAP SHOWN, ALLEN BRADLEY 800 SERIES	
8	SELECTOR SWITCH- 30mm, 2-POSITION MAINTAINED W/ TERMINAL BLOCKS & CAP SHOWN, ALLEN BRADLEY 800 SERIES	
STANDARD NOTES		
A) CONTRACTOR TO PROVIDE PART NUMBERS SHOWN OR EQUIVALENT.		
REFERENCED NOTES		
1) NONE.		

1 PUMP CONTROL PANEL LAYOUT & CONTROL DIAGRAM

E6.2 SCALE: NONE

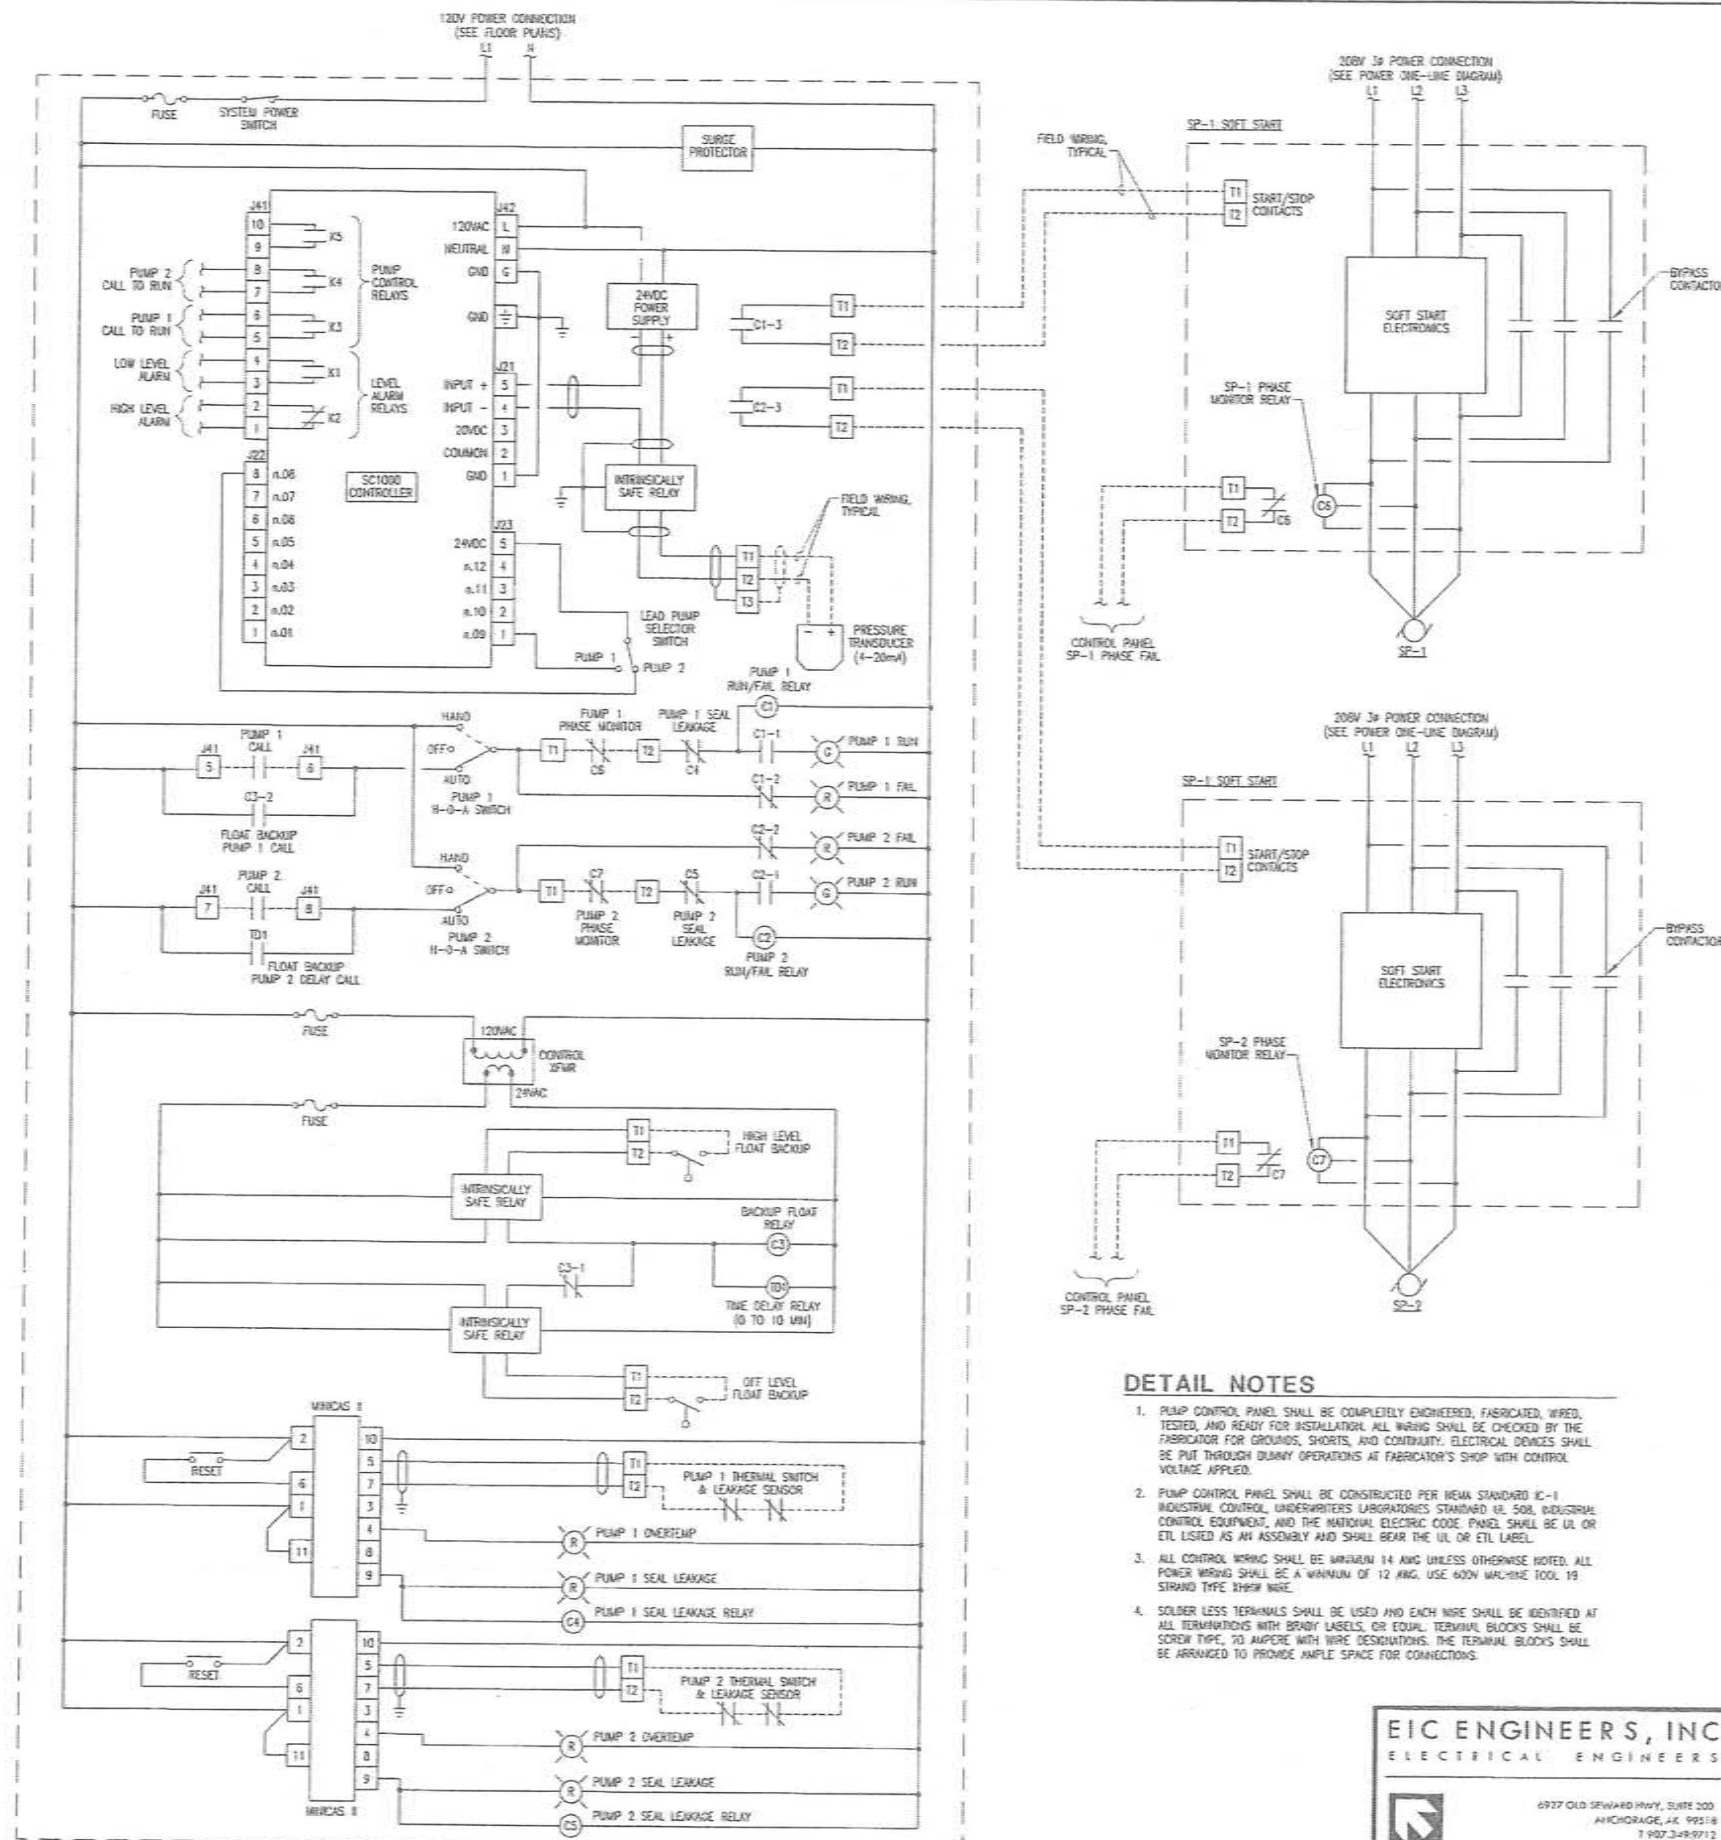

EIC ENGINEERS, INC.
ELECTRICAL ENGINEERS

6977 OLD SEWARD HWY, SUITE 200
ANCHORAGE, AK 99518
T 907.349.9712
F 907.349.9713
www.eiceng.com

9C ICE #10-1223

RECORD DRAWING CERTIFICATE

THESE DRAWINGS REFLECT RECORDED INFORMATION OBTAINED DURING CONSTRUCTION. INFORMATION PROVIDED HEREIN IS ACCURATE TO THE BEST OF MY KNOWLEDGE.

SCALE: 1" = 1'-0"

DATE: _____

NAME: _____

STATE OF ALASKA

19th

REGISTERED PROFESSIONAL

2009 WASTEWATER SYSTEM IMPROVEMENTS

ELECTRICAL LIFT STATION CONTROLS

TULUKSAK, ALASKA

EIC ENGINEERS, INC.

PO BOX 1234 ANCHORAGE AK 99513 PH: 907.349.9712 FAX: 907.349.9713

REVISION	DATE	BY	DATE

Project No. _____

Date: JAN 2011


Designed: BLS

Drawn: BLS



Approved: EDC

Sheet No. _____

E6.2

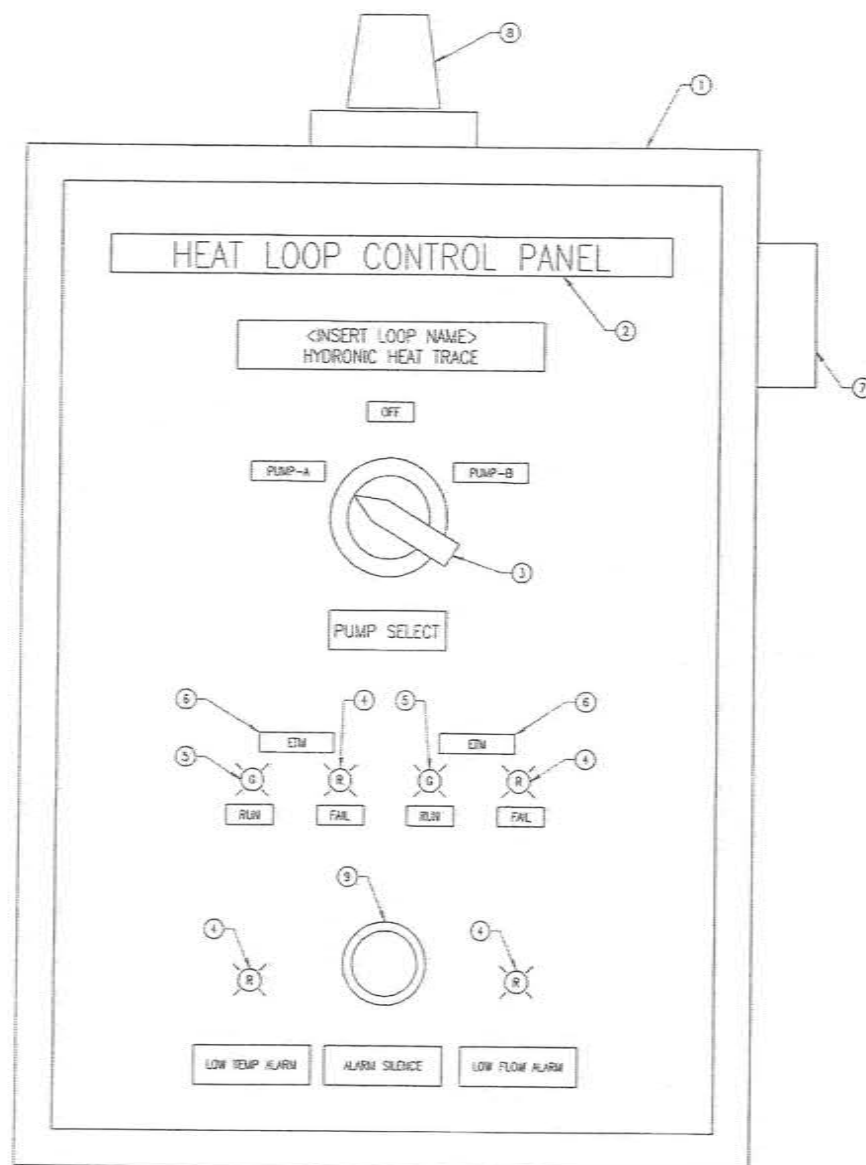

HEAT LOOP CONTROL PANEL COMPONENT SCHEDULE		
ITEM	DESCRIPTION	NOTE
1	CONTROL PANEL ENCLOSURE- NEUA JR. SIZED AS ADEQUATE TO HOUSE COMPONENTS	
2	NAME TAG- BLACK LAMINATED PLASTIC W/ WHITE CORE, SCREW MOUNTED, 1/4" (1/2" FOR FRONT DOOR ONLY) ENGRAVED LETTERS	
3	SELECTOR SWITCH- 30mm, 3-POSITION MAINTAINED W/ TERMINAL BLOCKS & CAM SHOWN	
4	PILOT LIGHT- 18mm, RED, LED, 120VAC, PUSH TO TEST TYPE, ALLEN BRADLEY 800T-PSH16R	
5	PILOT LIGHT- 18mm, GREEN, LED, 120VAC, PUSH TO TEST TYPE, ALLEN BRADLEY 800T-PSH16G	
6	ELAPSE TIME METER- HOUR METER, NON-RESETTABLE, 99999.9 HOUR REGISTER, HOBBS #20017	
7	ALARM HORN- 120VAC, WEATHERPROOF, CAST BACK BOX	
8	ALARM STROBE- 120VAC, WEATHERPROOF, CASE BACK BOX, AMBER LENS	
9	ALARM SILENCE PUSHBUTTON- MOMENTARY SWITCH, 120VAC, RED	
STANDARD NOTES		
A) CONTRACTOR TO PROVIDE PART NUMBERS SHOWN OR EQUIVALENT.		
REFERENCED NOTES		
1) NONE		

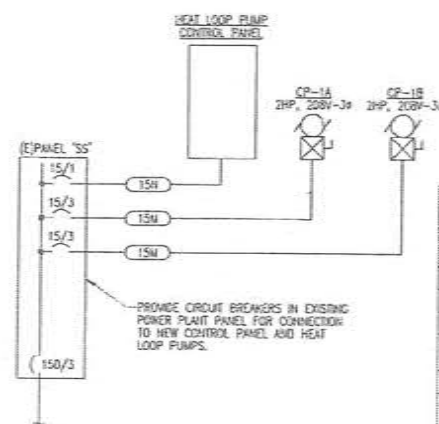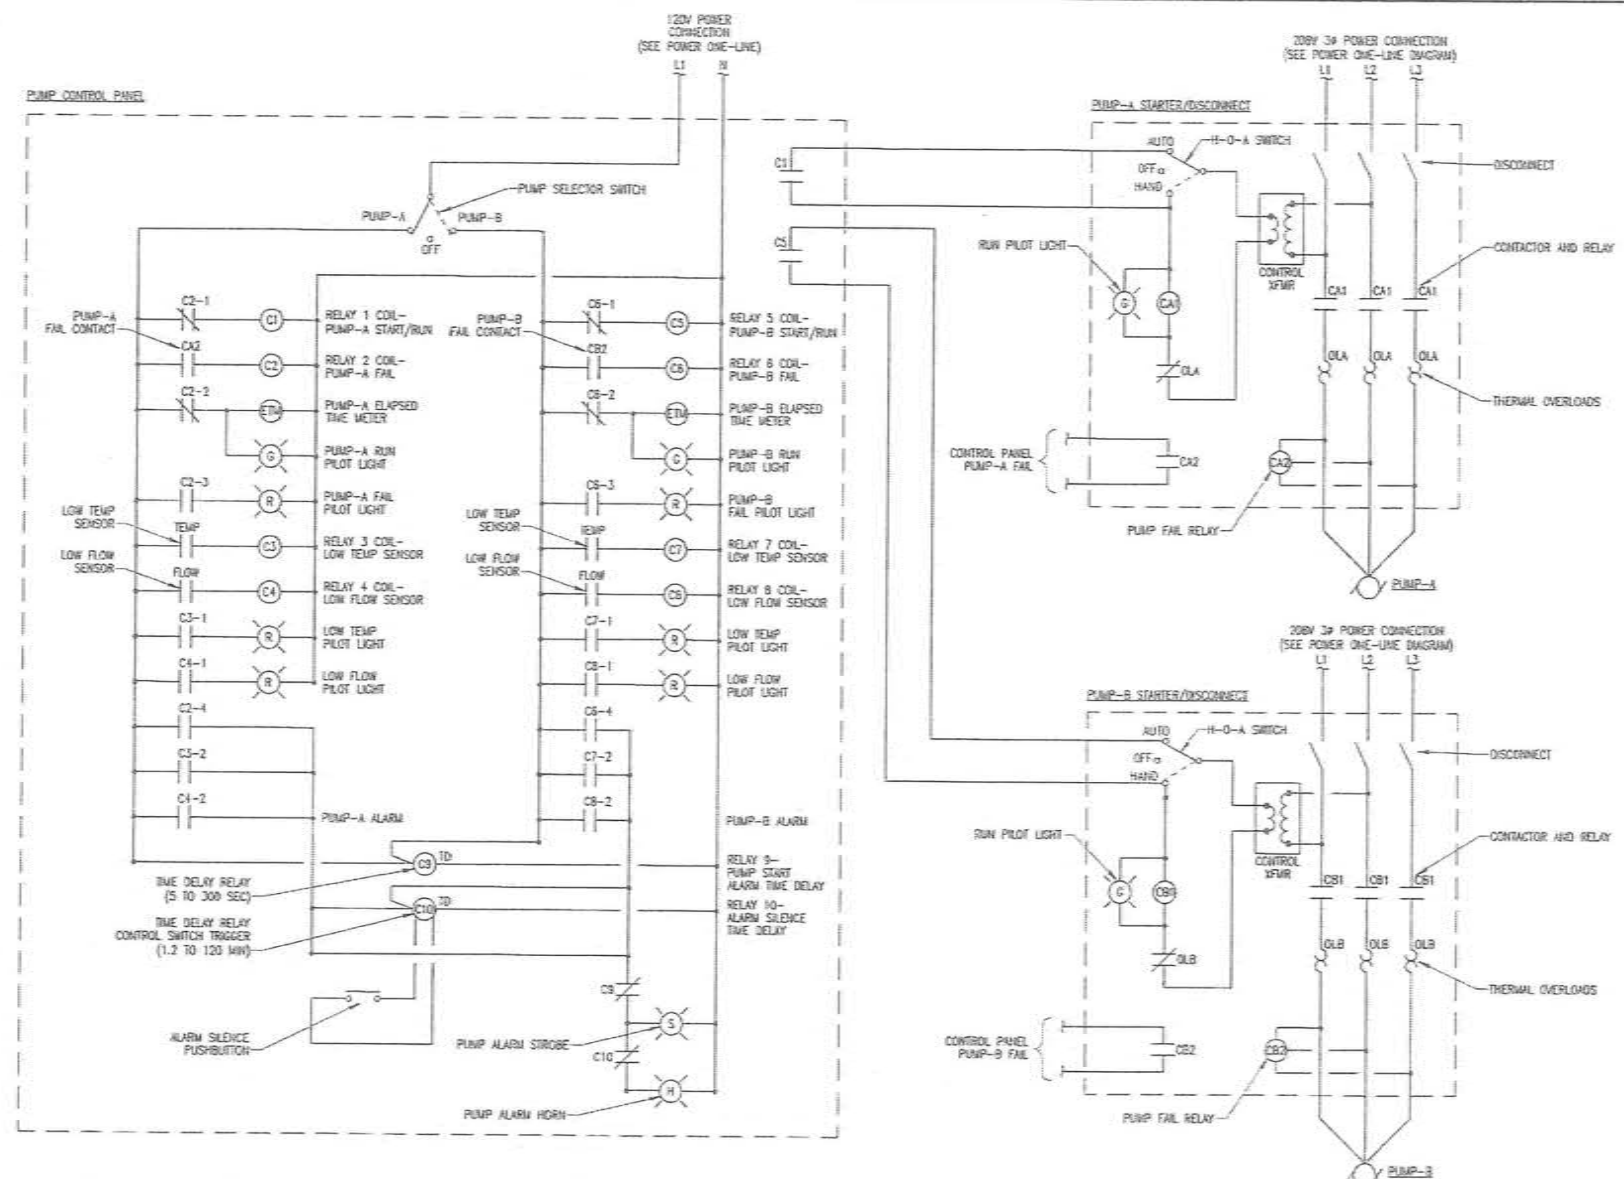

FEEDER SCHEDULE					
FEEDER		RACEWAY		CONDUCTORS	NOTES
ID	QTY	SIZE			
15M	1	1/2"		(2)12 AWG, (1)12 AWG EGC	
15M	1	1/2"		(2)12 AWG, (1)12 AWG EGC	

STANDARD NOTES

A) ALL CONDUCTOR SIZES SHOWN ARE COPPER.

REFERENCED NOTES


1) NONE

PANEL 'SS' LOAD SUMMARY	
<u>EXISTING LOAD</u>	
PANEL 'SS' LOAD (FROM RESULTS) =	37.0 KVA
<u>NEW LOAD</u>	
CP-1A/B =	2.70 KVA
HEAT LOOP PUMP CONTROL PANEL =	0.75 KVA
25% LARGEST MOTOR =	0.88 KVA
	<u>41.1 TOTAL KVA</u>
CALCULATED CURRENT = 114.2 AMPS @	
208 V., 3 PHASE	
EXISTING 150 A, 208 V., 3 PHASE, 4 WIRE	
PANEL IS ADEQUATE	

EIC ENGINEERS, INC.
ELECTRICAL ENGINEERS

 6927 OLD SEWARD HWY., SUITE 200
ANCHORAGE, AK 99516
T 907.349.9712
F 907.349.9713
www.eiceng.com

EIC #02 #E10-1223

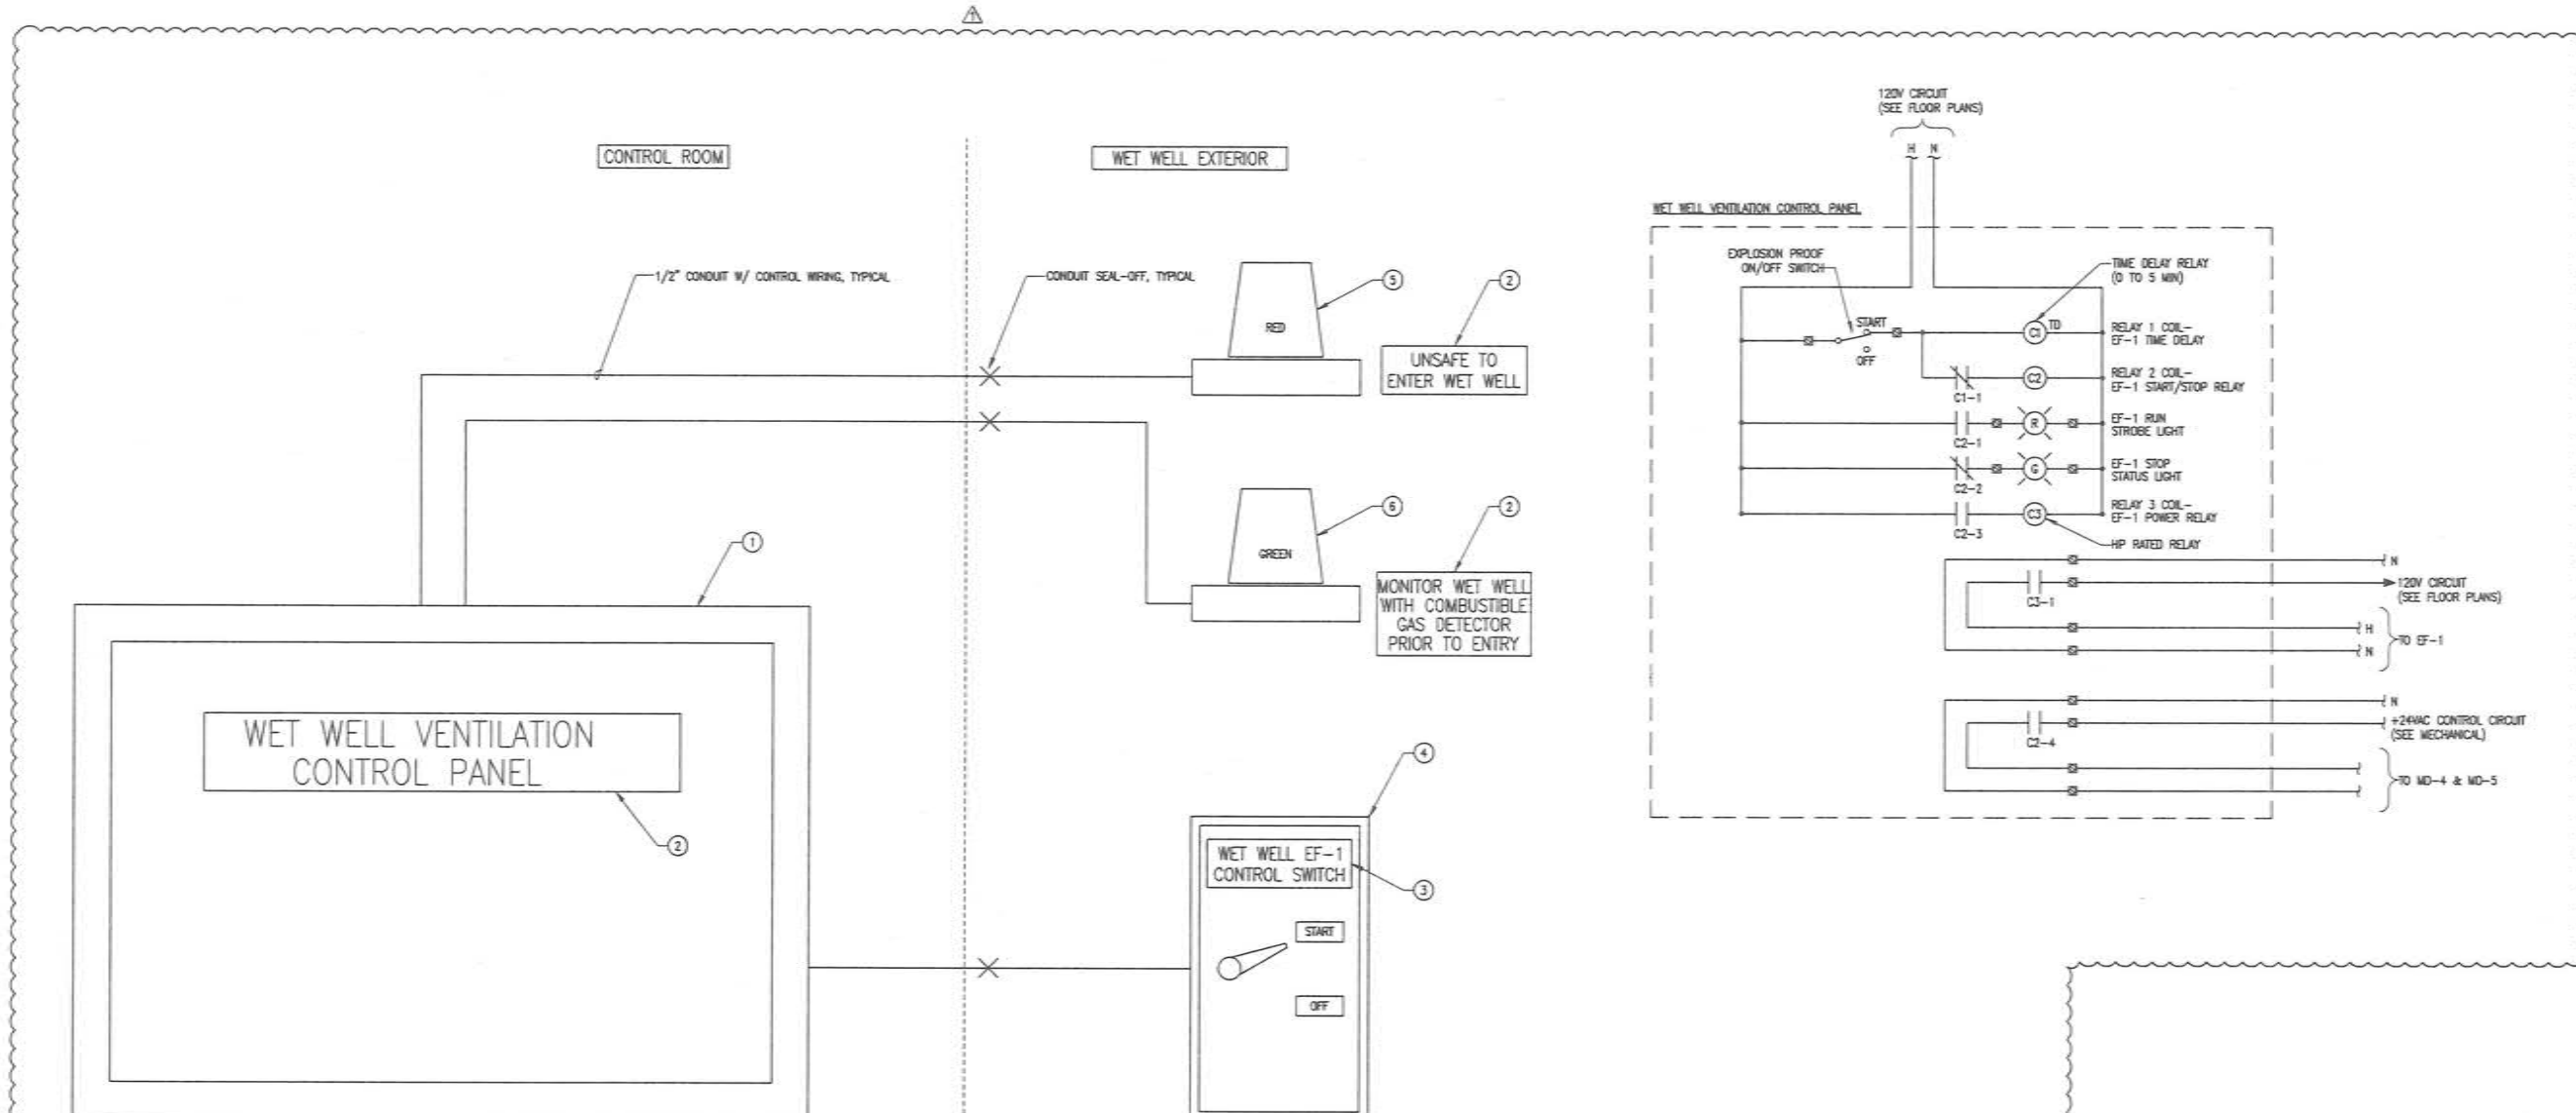

CONTROL PANEL COMPONENT SCHEDULE		
ITEM	DESCRIPTION	NOTES
1	CONTROL PANEL ENCLOSURE- NEMA 4, SIZED ADEQUATE TO HOUSE COMPONENTS.	
2	NAME TAG- BLACK LAMINATED PLASTIC W/ WHITE CORE, SCREW MOUNTED, 1/2" ENGRAVED LETTERS	
3	NAME TAG- BLACK LAMINATED PLASTIC W/ WHITE CORE, SCREW MOUNTED, 1/4" ENGRAVED LETTERS	
4	2-POSITION CLASS 1 DIVISION 2 EXPLOSION PROOF SELECTOR SWITCH	
5	RED CLASS 1 DIVISION 2 EXPLOSION PROOF STROBE LIGHT, RATED -40° F	
6	GREEN CLASS 1 DIVISION 2 EXPLOSION PROOF STATUS LIGHT, RATED -40° F	
STANDARD NOTES		
A) CONTRACTOR TO SELECT EXACT EQUIPMENT UTILIZED.		
REFERENCED NOTES		
1) NONE.		

- DETAIL NOTES**
- CONTROL PANEL SHALL BE COMPLETELY ENGINEERED, FABRICATED, WIRED, TESTED, AND READY FOR INSTALLATION. ALL WIRING SHALL BE CHECKED BY THE FABRICATOR FOR GROUNDING, SHORTS, AND CONTINUITY. ELECTRICAL DEVICES SHALL BE PUT THROUGH DUMMY OPERATIONS AT FABRICATOR'S SHOP WITH CONTROL VOLTAGE APPLIED.
 - PUMP CONTROL PANEL SHALL BE CONSTRUCTED PER NEMA STANDARD IC-1 INDUSTRIAL CONTROL, UNDERWRITERS LABORATORIES STANDARD UL 508, INDUSTRIAL CONTROL EQUIPMENT, AND THE NATIONAL ELECTRIC CODE. PANEL SHALL BE UL OR ETL LISTED AS AN ASSEMBLY AND SHALL BEAR THE UL OR ETL LABEL.
 - ALL CONTROL WIRING SHALL BE MINIMUM 14 AWG UNLESS OTHERWISE NOTED. ALL POWER WIRING SHALL BE A MINIMUM OF 12 AWG. USE 600V MACHINE TOOL 19 STRAND TYPE XHHW WIRE.
 - SOLDER LESS TERMINALS SHALL BE USED AND EACH WIRE SHALL BE IDENTIFIED AT ALL TERMINATIONS WITH BRADY LABELS, OR EQUAL TERMINAL BLOCKS SHALL BE SCREW TYPE, 20 AMPERE WITH WIRE DESIGNATIONS. THE TERMINAL BLOCKS SHALL BE ARRANGED TO PROVIDE AMPLE SPACE FOR CONNECTIONS.

1 WET WELL VENTILATION CONTROL PANEL LAYOUT & CONTROL DIAGRAM
E6.4 SCALE: NONE

EIC ENGINEERS, INC
ELECTRICAL ENGINEERS



6927 OLD SEWARD HWY., SUITE 200
ANCHORAGE, AK 99518
T 907.349.9712
F 907.349.9713
www.eiceng.com

RECORD DRAWING CERTIFICATE
THESE DRAWINGS REFLECT RECORDED
INFORMATION OBTAINED DURING
CONSTRUCTION. INFORMATION PROVIDED
HEREIN IS ACCURATE TO THE BEST OF MY
KNOWLEDGE.

SCALE:
AS SHOWN
DATE: 01/11/11
SCALE: 1" = 1'-0"





2009 WASTEWATER SYSTEM
IMPROVEMENTS
ELECTRICAL
POWER PLANT
CONTROLS & DIAGRAMS
TULUKSAK, ALASKA



ENGINEERS, INC.
PO BOX 232949 ANCHORAGE AK 99523 PH 907-545-1019 FAX 907-545-1015

REVISION	BY	DATE
1	BLS	1/10/11
2	BLS	
3	BLS	
4	EDC	

Project No.	Date	Designed	Drawn	Approved
	JAN 2011	BLS	BLS	EDC

Sheet No. **E6.4**